


1 2 3 4 5 6 7

A B C D E

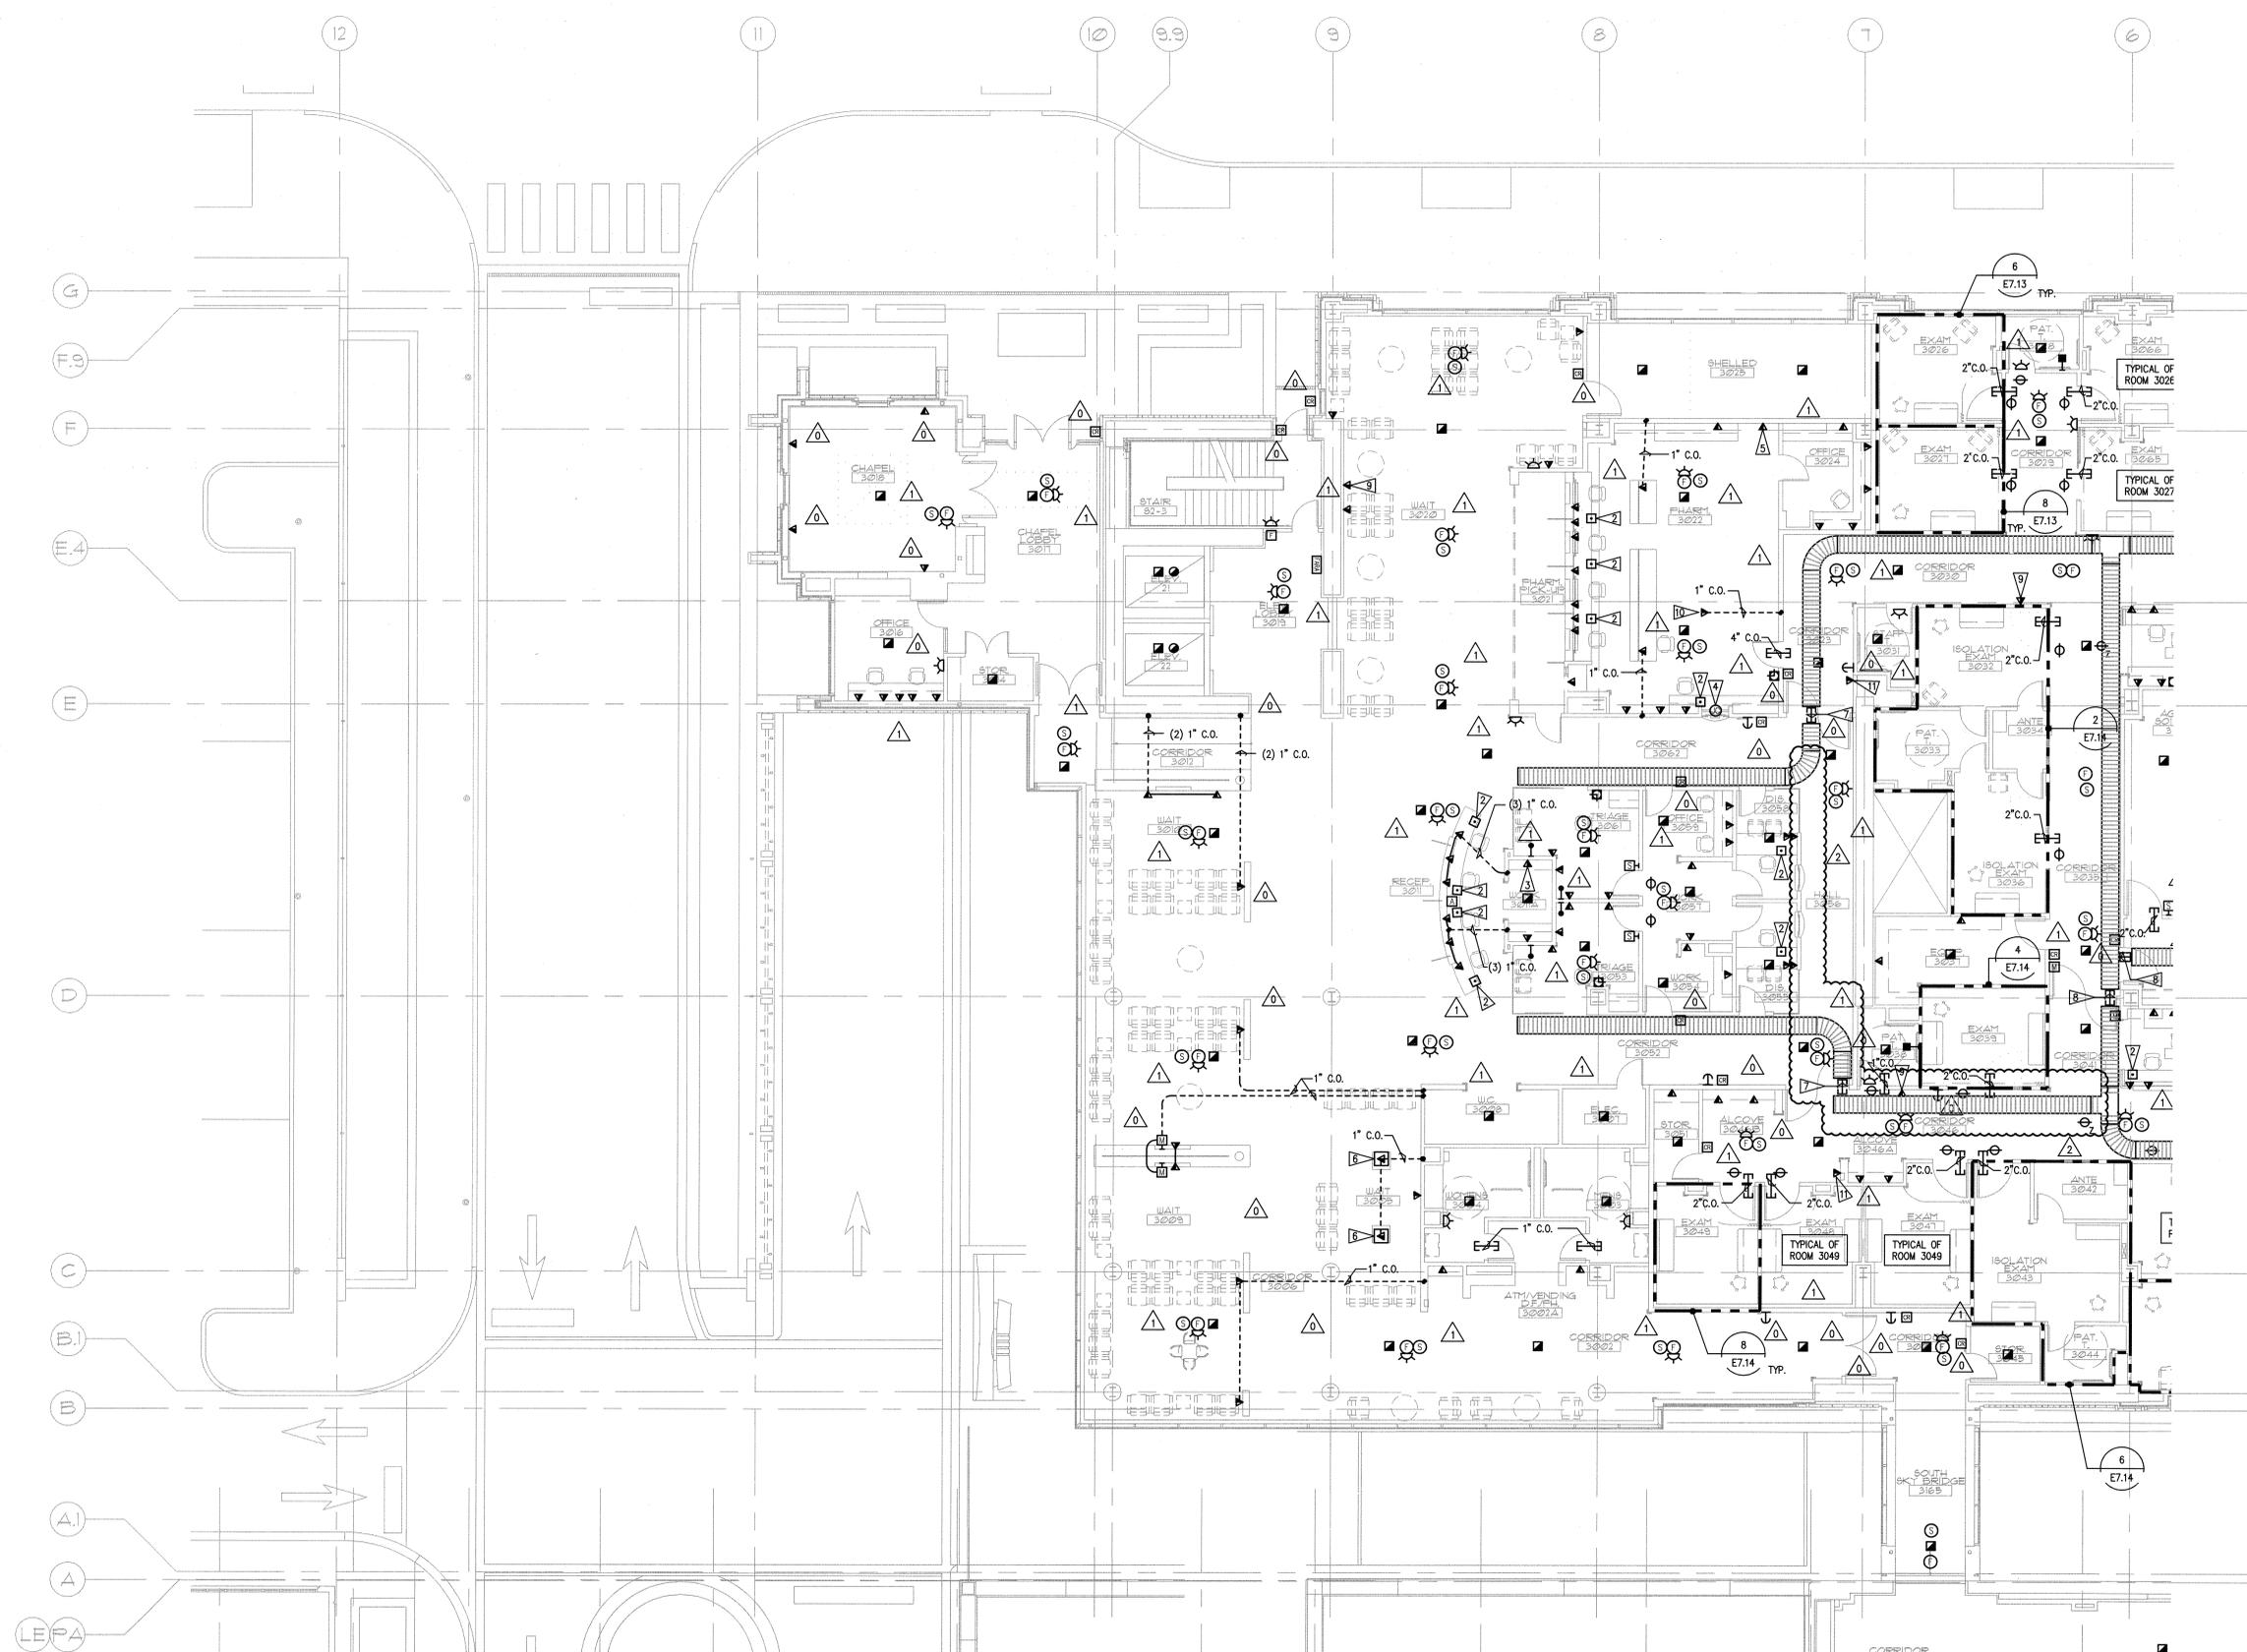

- GENERAL NOTES**
- SEE ARCHITECTURAL PLANS, SECTIONS AND ELEVATIONS FOR EXACT EQUIPMENT AND DEVICE LOCATIONS.
 - SEE ARCHITECTURAL PLANS FOR LOCATIONS OF SOUND, SMOKE AND FIRE RATED WALLS.
 - REFER TO MECHANICAL DRAWINGS FOR FIRE/SMOKE DAMPER LOCATIONS. PROVIDE FIRE ALARM MONITORING POINT FOR EACH FIRE/SMOKE DAMPER.
 - CONTRACTOR SHALL OBTAIN THE FINAL OWNER APPROVED HILLROM NURSE CALL SHOP DRAWINGS PRIOR TO ROUGH-IN.

- FLAG NOTES**
- △ NOT USED.
 - ▽ PANIC BUTTON CONNECTION.
 - ▽ COPIER CONNECTION.
 - ▽ CONNECT ROLL DOWN FIRE DOOR TO FIRE ALARM SYSTEM PER MANUFACTURER'S INSTRUCTIONS.
 - ▽ PYXIS CONNECTION.
 - ▽ RECESSED FLOOR BOX. UTILIZE BOX FOR BOTH POWER AND TELE/DATA. SEE DRAWING E3.03. COORDINATE EXACT LOCATION WITH ARCHITECT PRIOR TO ROUGH-IN.
 - ▽ PROVIDE (1) 3.5"x3.5" SQUARE EZ PATH DEVICES OR APPROVED.
 - ▽ PROVIDE (2) 3.5"x3.5" SQUARE EZ PATH DEVICES OR APPROVED.
 - ▽ CENSES BOARD CONNECTION. VERIFY EXACT LOCATION WITH ARCHITECT PRIOR TO ROUGH-IN.
 - ▽ COMBINATION FLOOR BOX WITH POWER.
 - ▽ TIME CLOCK CONNECTION VERIFY WITH ARCHITECT PRIOR TO ROUGH-IN.

1 THIRD FLOOR PLAN - SOUTH - SYSTEMS
 E4.03 SCALE: AS INDICATED
 0 4 8 16 24 feet

N:\13608\CAD-05\406_E4-03.DWG JAN 21, 2009 - 10:33:19 AM BY: JLUO

GIFFIN • BOLTE • JURGENS
 ARCHITECTS P.C.
 815 S.W. SECOND AVENUE - PORTLAND, OREGON 97204
 (503) 223-0992 www.gbjarch.com FAX (503) 294-3961



MultiCare
EMERGENCY DEPARTMENT & CANCER CENTER EXPANSION
 TACOMA, WASHINGTON

- △ 100% CD SET 9/26/08
- △ 1 CCD #4 12/17/08
- △ 2 CCD #5 1/21/09

Date 09-26-2008
 Scale AS INDICATED
 Drawn By JL
 Job No. 4034

**THIRD FLOOR
 PLAN - SOUTH
 SYSTEMS**

**E4
 03**