



DRAWING NUMBER

1/4"=1'- 0" DRAWING TITLE LOWER LEVEL POWER PLAN AREA - A

ISSUE OSHPD PERMIT DATE 01/27/2010 SCALE

12011.00 Increment #7 OSHPD - PROJECT NUMBER IL 072072-30

PROJECT NUMBER

SHOCSM HOSPITAL

TOWER II

PROJECT NAME CHILDREN'S HOSPITAL OF ORANGE COUNTY 455 S. Main St. Orange, CA 92868-3874

APPROVAL

REVISIONS

12/19/11 CHANGE ORDER #294 <u>798</u>

100 South Anaheim Boulevard, Suite 150 Anaheim, California 92805 Phone: 714.490.5555 Fax: 714.490.5560 Project No. 2305-163-07

TMAD

STRUCTURAL

MECHANICAL

ELECTRICAL

CIVIL




CONSULTANT

TAYLO R

&G AINES

ARCHITECT OF RECORD

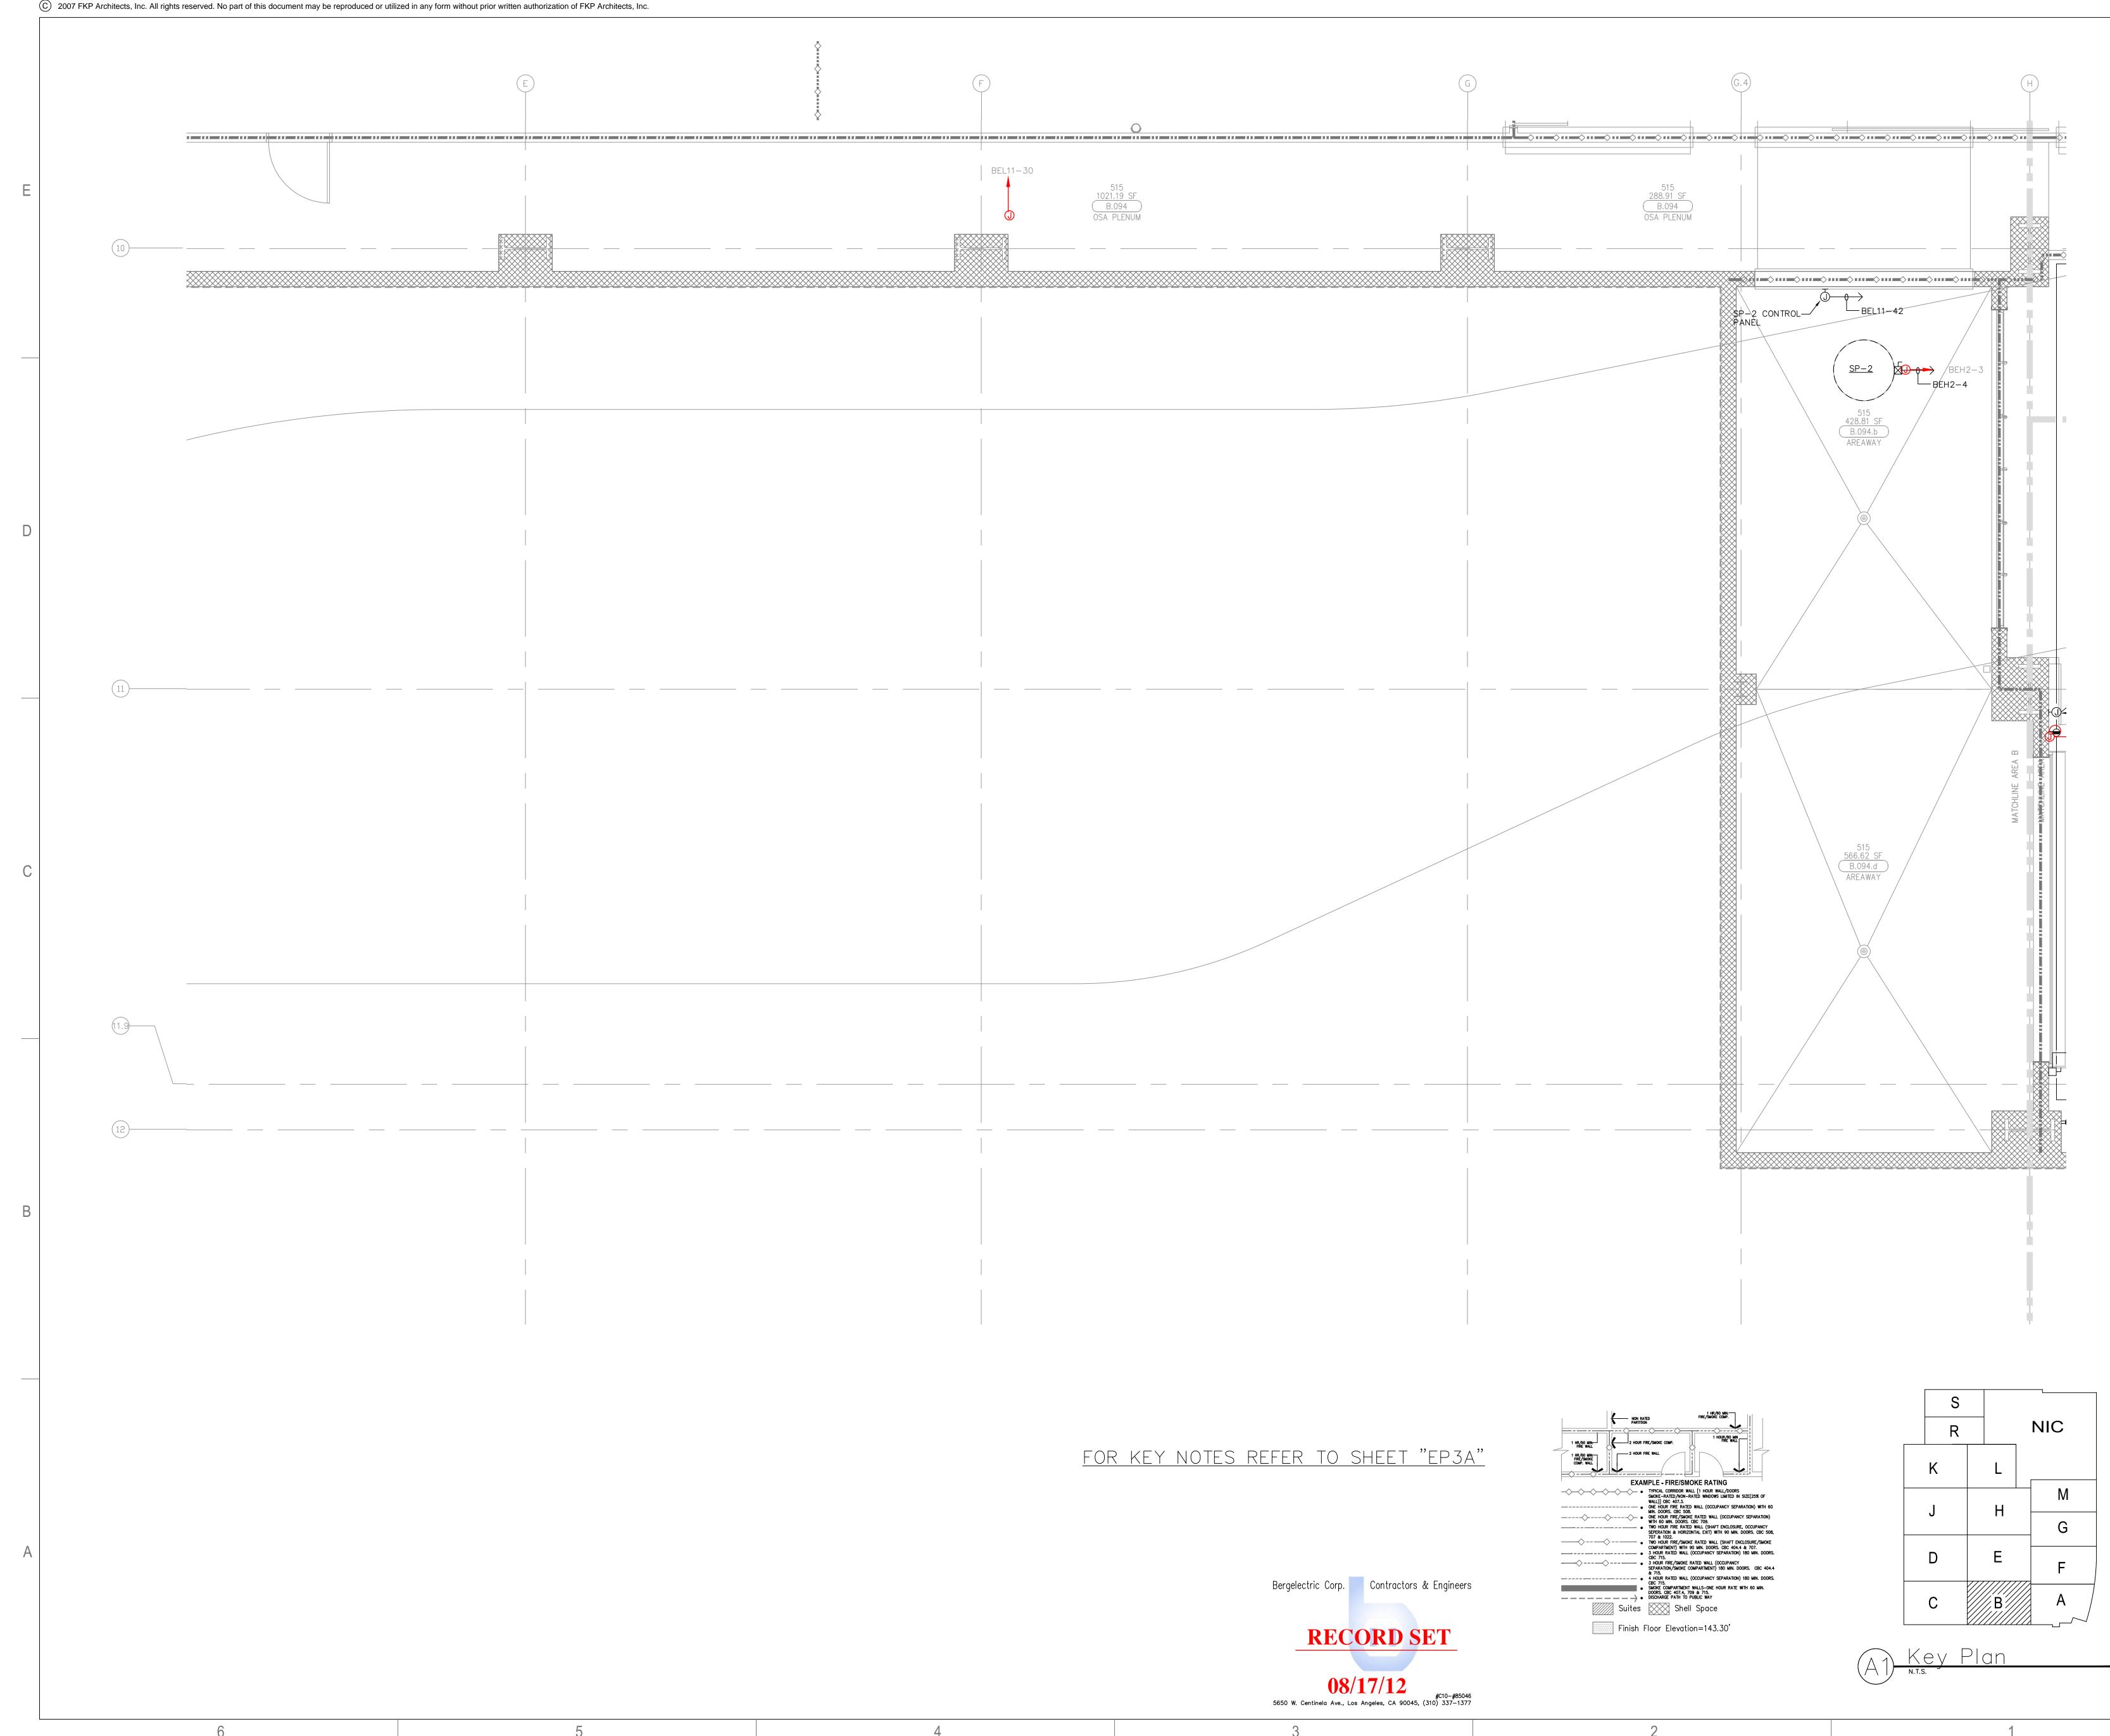

г. үгличент 5/17/2012 SSOGHOMON



DRAWING NUMBER

SCALE 1/4"=1'- 0" DRAWING TITLE LOWER LEVEL POWER PLAN AREA - B

IL 072072-30 ISSUE OSHPD PERMIT DATE 01/27/2010

PROJECT NUMBER 12011.00 Increment #7 OSHPD - PROJECT NUMBER



TOWER II

PROJECT NAME CHILDREN'S HOSPITAL OF ORANGE COUNTY 455 S. Main St. Orange, CA 92868-3874

APPROVAL

REVISIONS

<u>\$97</u> 12/19/11 CHANGE ORDER #294

100 South Anaheim Boulevard, Suite 150 Anaheim, California 92805 Phone: 714.490.5555 Fax: 714.490.5560 Project No. 2305-163-07

TMAD

STRUCTURAL

MECHANICAL

ELECTRICAL


CIVIL

ARCHITECT OF RECORD

CONSULTANT

TAYLO R

&G AINES

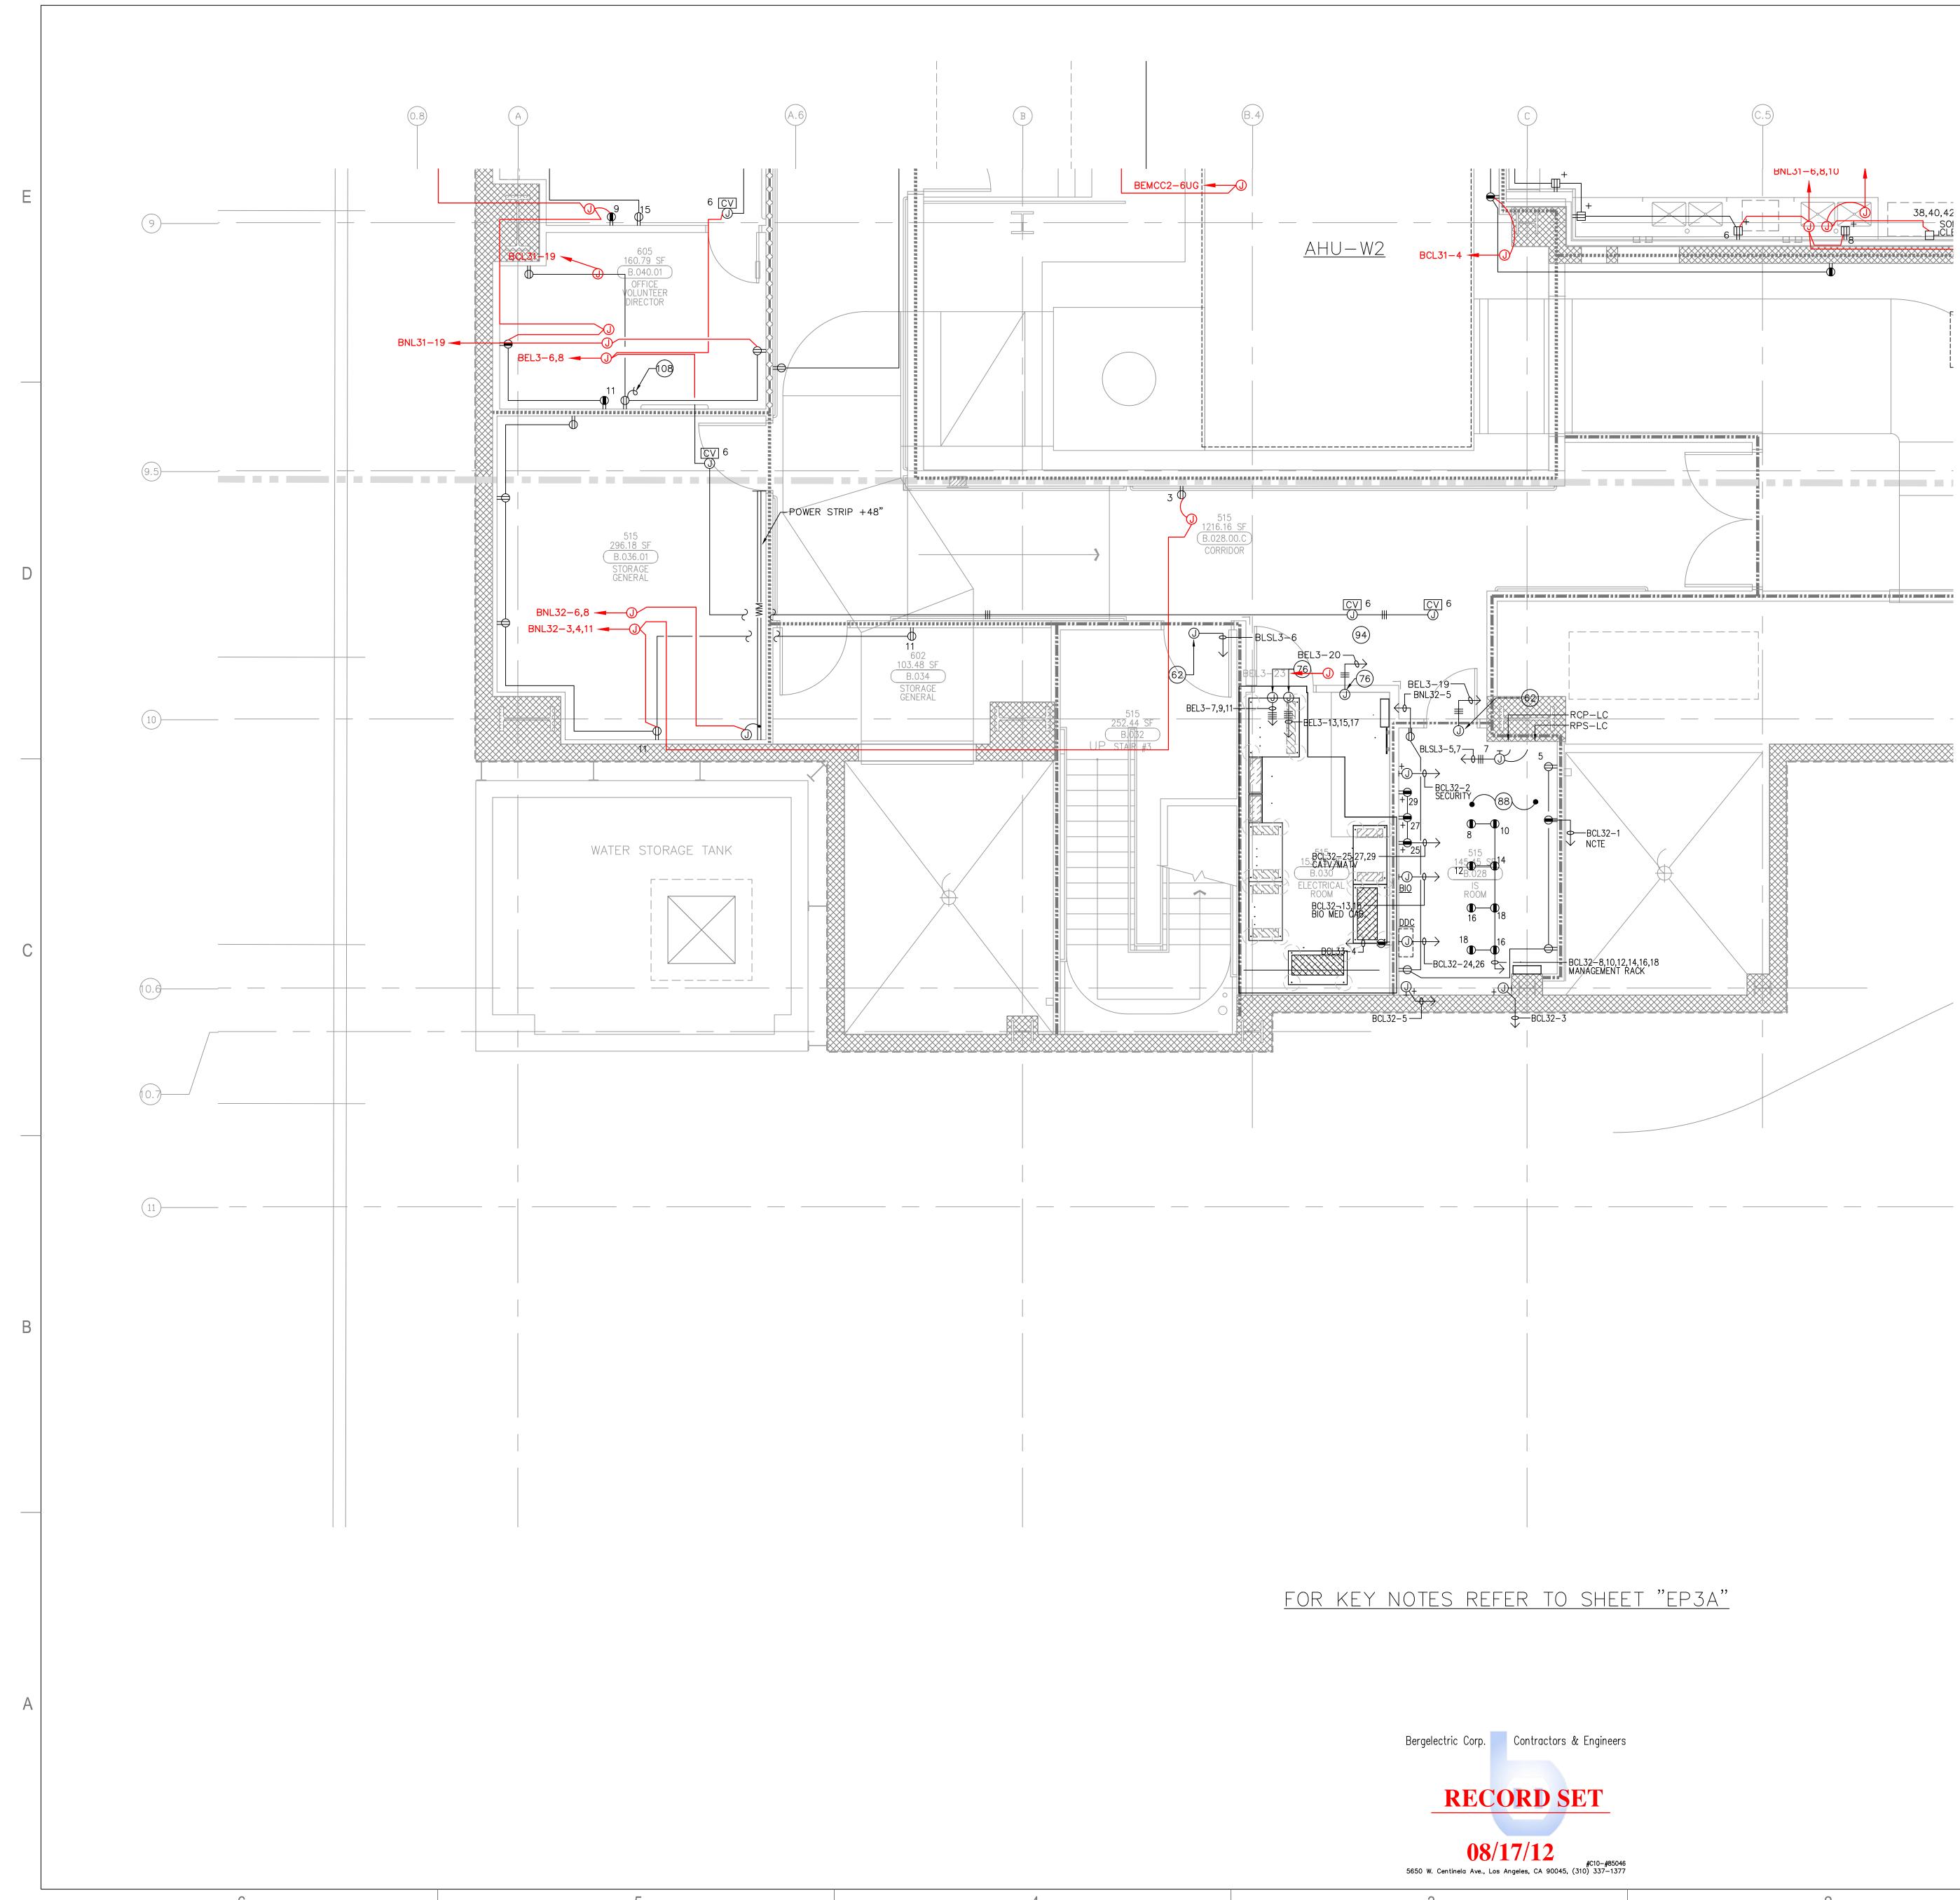

C 2007 FKP Architects, Inc. All rights reserved. No part of this document may be reproduced or utilized in any form without prior written authorization of FKP Architects, Inc.

1 HR/60 MIN. 2 HOUR FIRE/SMOKE COMP. 2 HOUR FIRE WALL " 1 HR/60 MIN. FIRE/SMOKE COMP. WALL EXAMPLE - FIRE/SMOKE RATING • TYPICAL CORRIDOR WALL [1 HOUR WALL/DOORS SMOKE - RATED /NOM-RATED WINDOWS LIMITED IN SIZE(25% OF WALL)] GC 407.3. • ONE HOUR FIRE RATED WALL (OCCUPANCY SEPARATION) WITH 60 MIN. DOORS. CBC 508. • ONE HOUR FIRE RATED WALL (OCCUPANCY SEPARATION) WITH 60 MIN. DOORS. CBC 709. • ONE HOUR FIRE/SMOKE RATED WALL (OCCUPANCY SEPARATION) WITH 60 MIN. DOORS. CBC 709. • ONE HOUR FIRE/SMOKE RATED WALL (SHAFT ENCLOSURE, OCCUPANCY SEPERATION & HORIZONTAL EXIT) WITH 90 MIN. DOORS. CBC 508, 707 & 1022. • TWO HOUR FIRE/SMOKE RATED WALL (SHAFT ENCLOSURE/SMOKE COMPARTMENT) WITH 90 MIN. DOORS. CBC 404.4 & 707. • JOUR FIRE/SMOKE RATED WALL (OCCUPANCY SEPARATION) 180 MIN. DOORS. CBC 715. • ON HOUR FIRE/SMOKE RATED WALL (OCCUPANCY SEPARATION/SMOKE COMPARTMENT) 180 MIN. DOORS. CBC 404.4 & 715. • ON HOUR RATED WALL (OCCUPANCY SEPARATION) 180 MIN. DOORS. CBC 715. • ONCE COMPARTMENT WALLS-ONE HOUR RATE WITH 60 MIN. DOORS. CBC 407.4, 709 & 715. • DISCHARGE PATH TO PUBLIC WAY © Suites © Shell Space EXAMPLE - FIRE/SMOKE RATING Finish Floor Elevation=143.30'

NON RATED

S		
R		NIC
K	L	
J		М
J	Η	G
D	Е	F
C	В	A

(A1) Key Plan



1/4"=1'- 0" DRAWING TITLE LOWER LEVEL POWER PLAN AREA - C

Increment #7 OSHPD - PROJECT NUMBER IL 072072-30 ISSUE OSHPD PERMIT DATE 01/27/2010 SCALE

HOSPITAL

TOWER II

PROJECT NUMBER

12011.00

PROJECT NAME CHILDREN'S HOSPITAL OF ORANGE COUNTY 455 S. Main St. Orange, CA 92868-3874

APPROVAL

REVISIONS

多入 12/19/11 CHANGE ORDER #294

100 South Anaheim Boulevard, Suite 150 Anaheim, California 92805 Phone: 714.490.5555 Fax: 714.490.5560 Project No. 2305-163-07

TMAD

TAYLO R

&G AINES

STRUCTURAL


MECHANICAL

ELECTRICAL

CIVIL

ARCHITECT OF RECORD

CONSULTANT

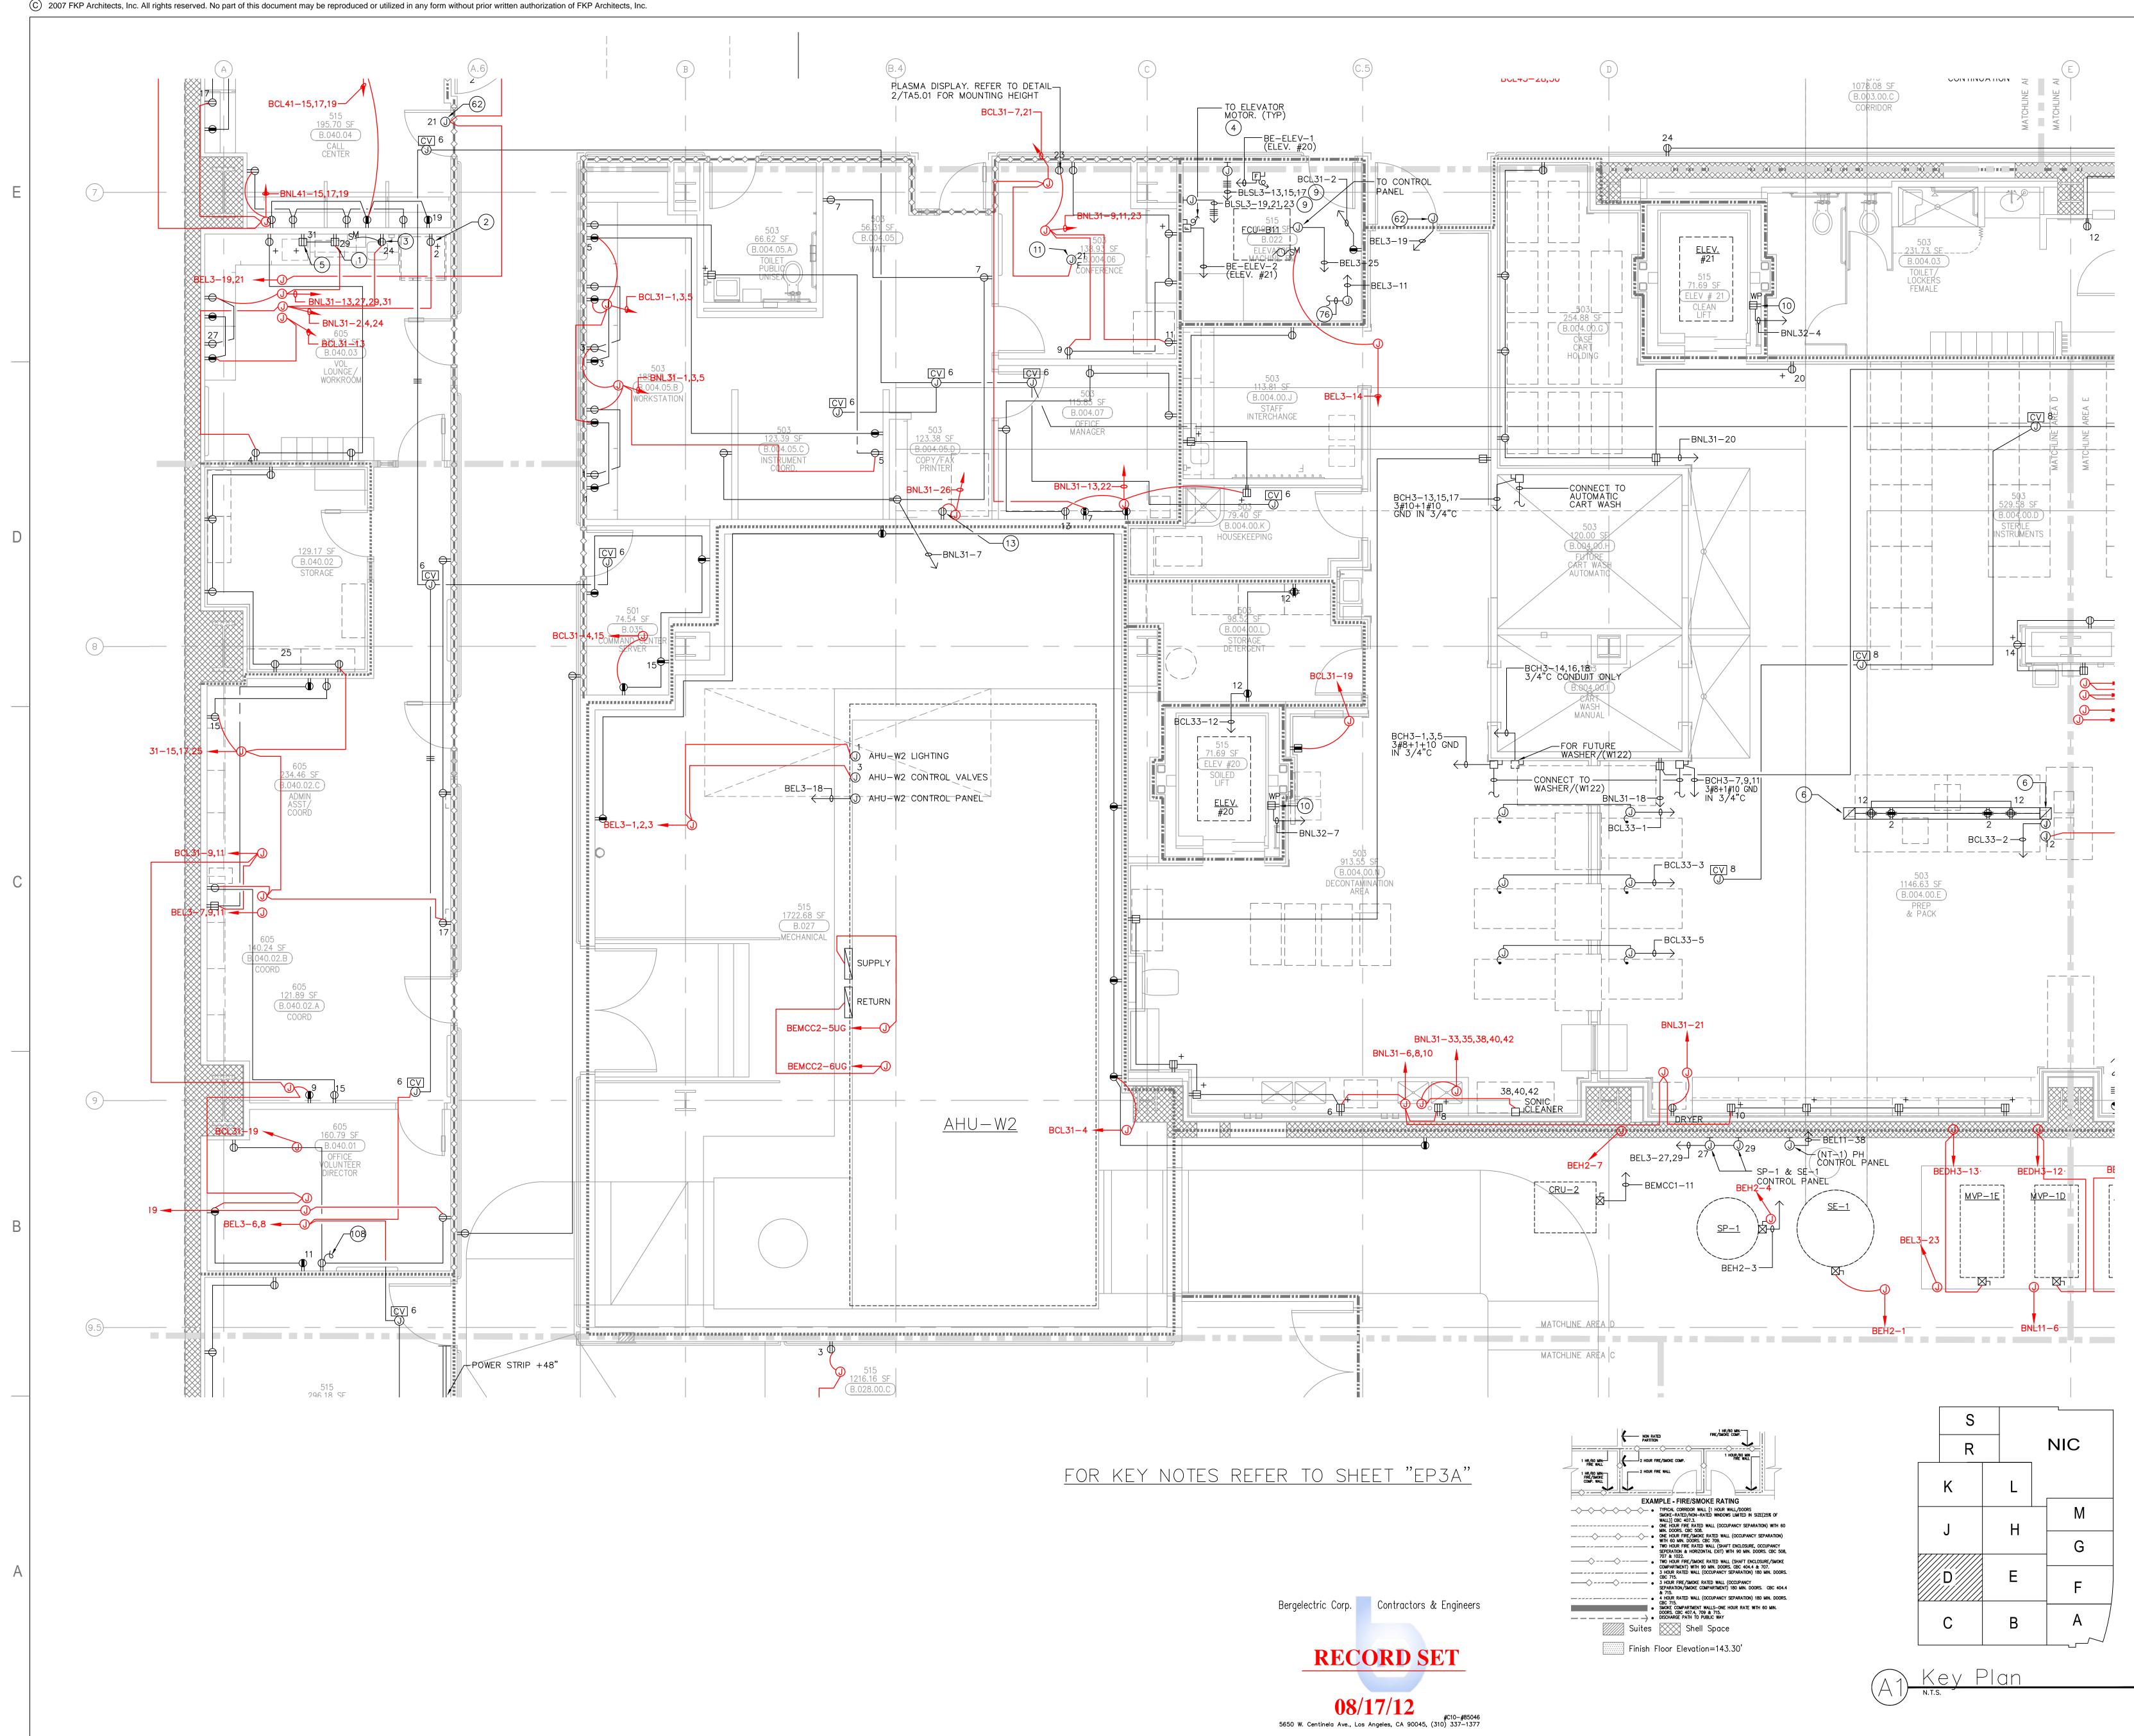



DATE 01/27/2010 SCALE 1/4"=1'-0" DRAWING TITLE LOWER LEVEL POWER PLAN AREA - D

HOSPITAL PROJECT NUMBER 12011.00 Increment #7 OSHPD - PROJECT NUMBER IL 072072-30 ISSUE OSHPD PERMIT

TOWER II

OF ORANGE COUNTY 455 S. Main St. Orange, CA 92868-3874

CHILDREN'S HOSPITAL

PROJECT NAME

APPROVAL

	02/05/10	INFORMATION BULLETIN #5
73	07/12/10	CHANGE ORDER #64
157	03/08/11	CHANGE ORDER #130
<u>rer</u>	03/28/11	CHANGE ORDER #156
299	08/22/11	CHANGE ORDER #234
297	12/19/11	CHANGE ORDER #294
883	12/22/11	CHANGE ORDER #295

REVISIONS

100 South Anaheim Boulevard, Suite 150 Anaheim, California 92805 Phone: 714.490.5555 Fax: 714.490.5560 Project No. 2305-163-07

TMAD

TAYLO R

&G AINES

STRUCTURAL

MECHANICAL


ELECTRICAL

CIVIL

ARCHITECT OF RECORD

CONSULTANT



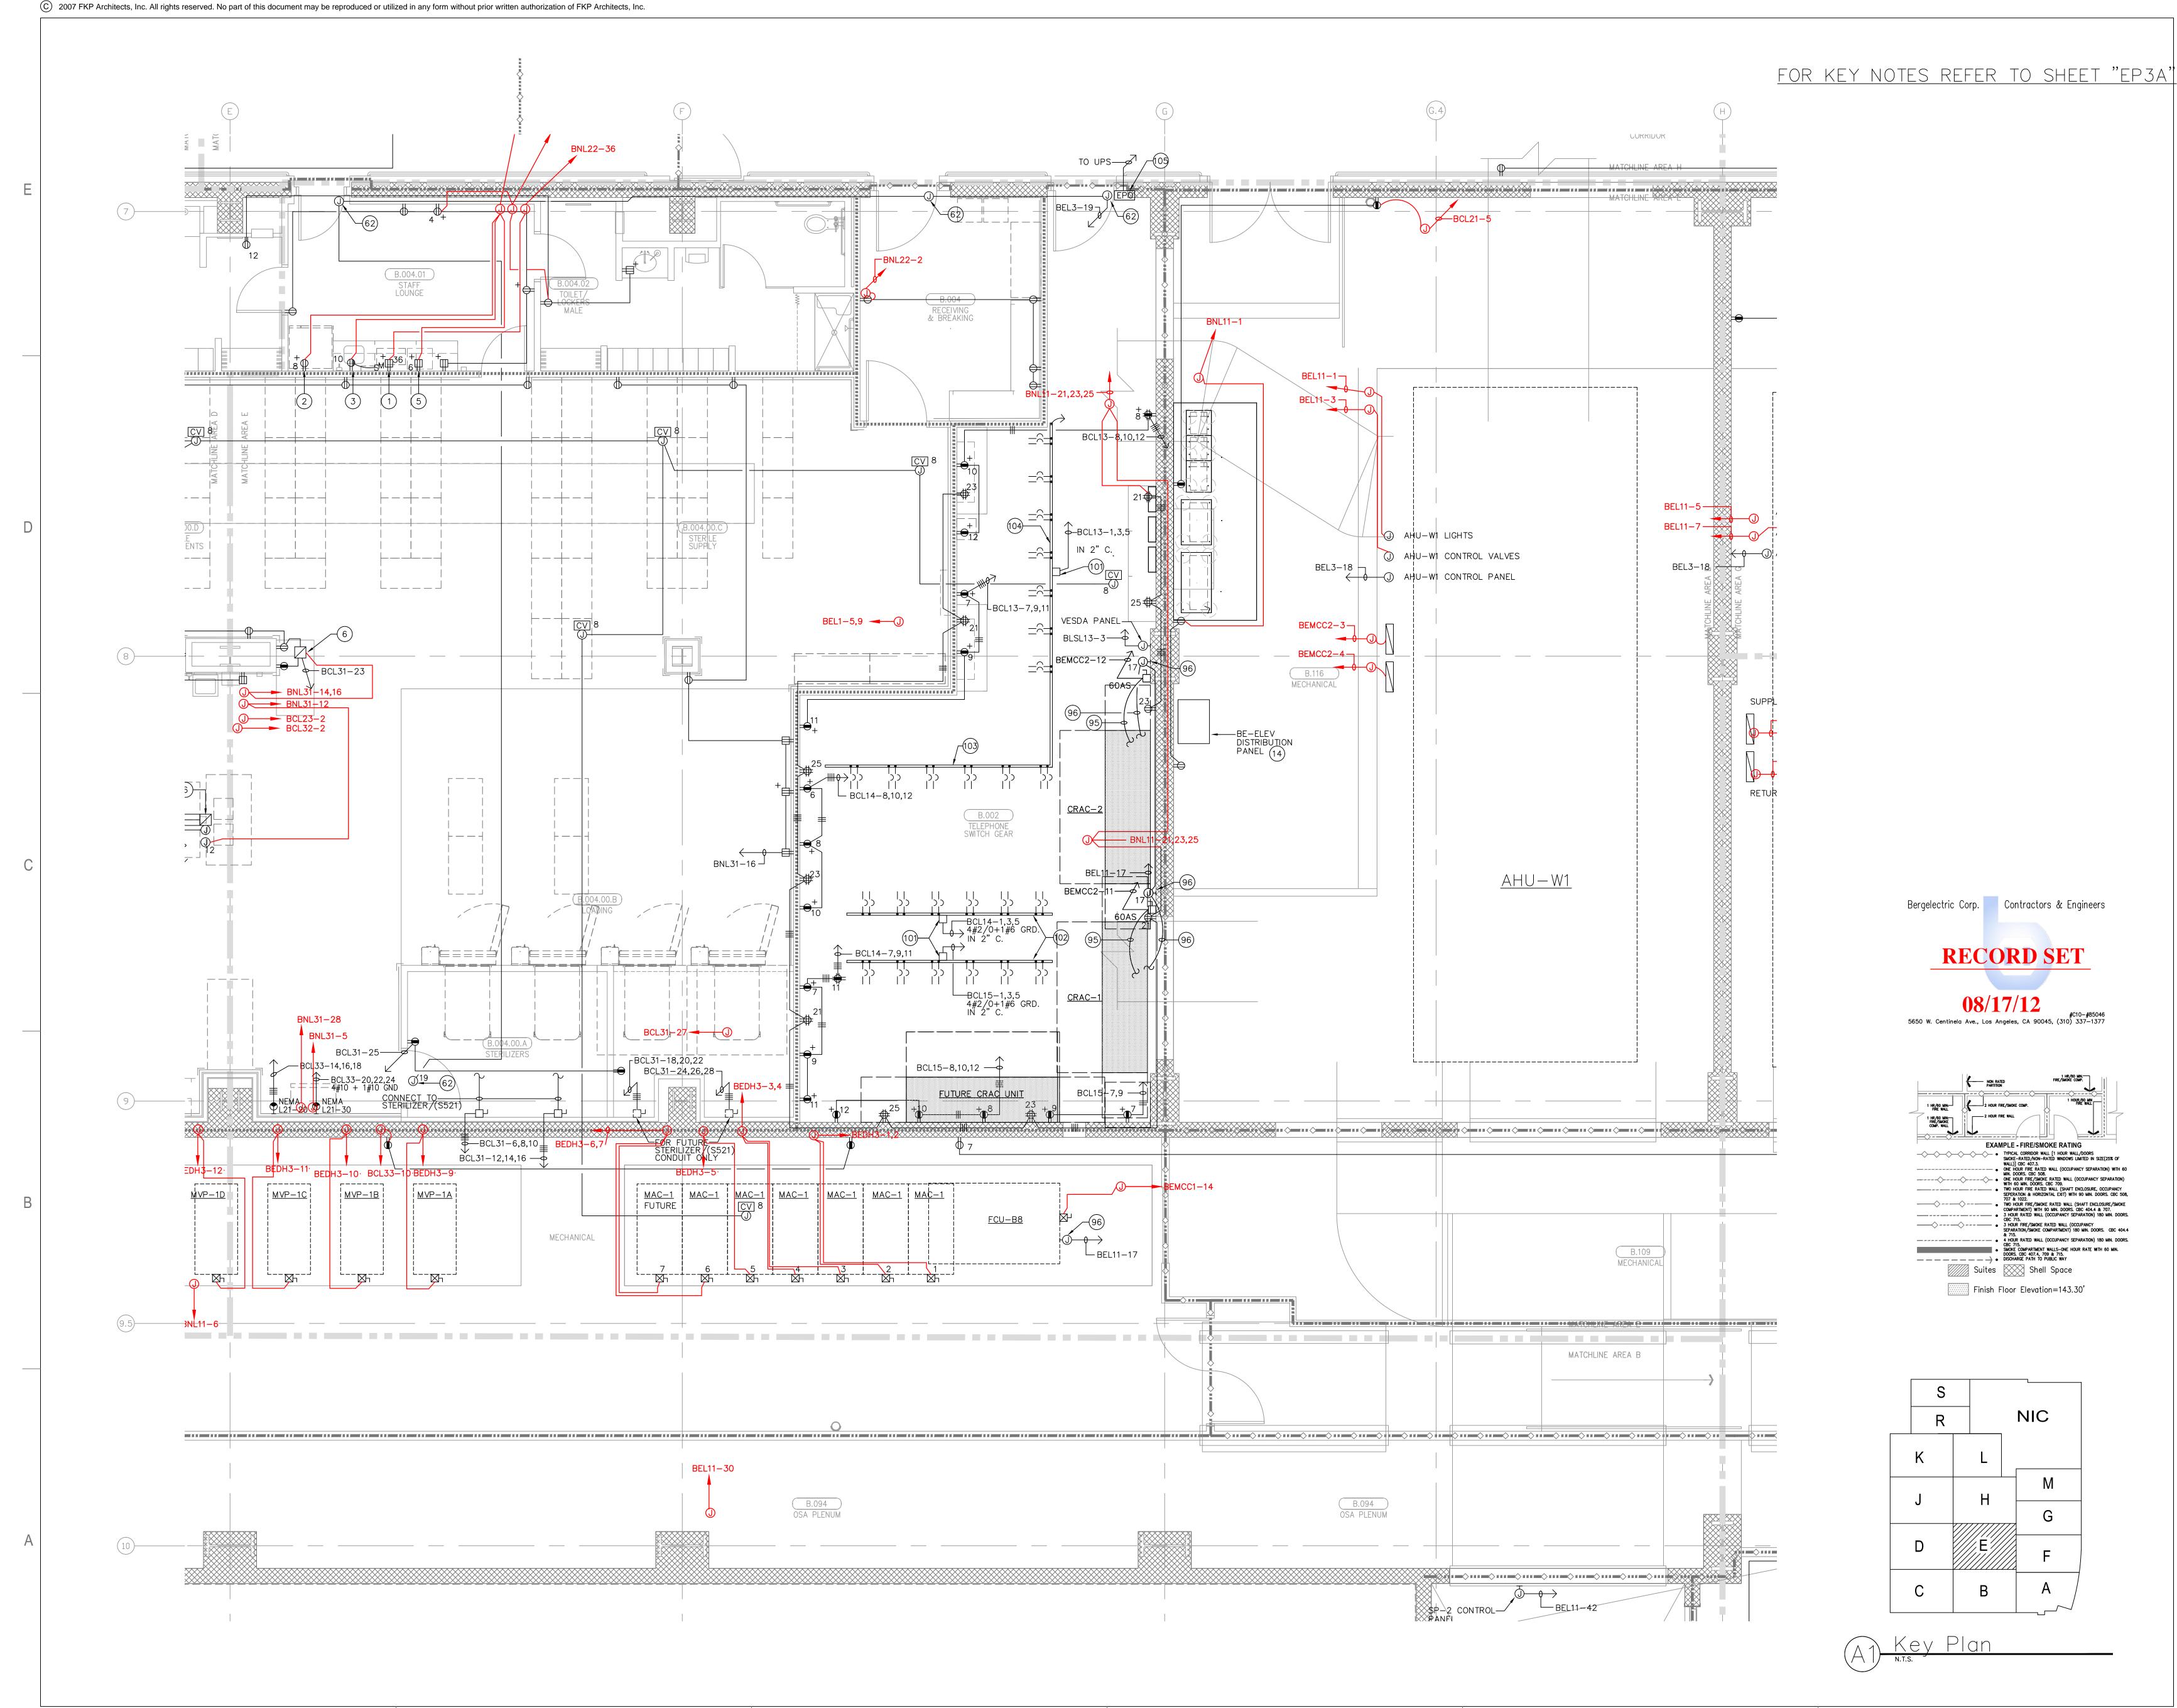

r. үглоиесто үспос ттвих үлесолио үгомел үеги_од. 5/17/2012

5



DRAWING NUMBER

H O S P I T A L
PROJECT NUMBER
12011.00 Increment #7
OSHPD - PROJECT NUMBER
OSHPD PERMIT
01/27/2010
SCALE
1/4"=1'- 0" DRAWING TITLE
LOWER LEVEL POWER PLAN AREA - E

CHOCSM



APPROVAL

PROJECT NAME

•	02/05/10	INFORMATION BULLETIN #5
14	03/31/10	CHANGE ORDER #14
28	06/14/10	CHANGE ORDER #11
73	07/12/10	CHANGE ORDER #64
46	02/14/11	CHANGE ORDER #107
291	07/06/11	CHANGE ORDER #226
<u>768</u>	12/19/11	CHANGE ORDER #294
883	12/22/11	CHANGE ORDER #295

REVISIONS


CONSULTANT T M A D T A Y LO R & C AINES

ARCHITECT OF RECORD

STRUCTURAL
MECHANICAL
ELECTRICAL
CIVIL

KP Archited



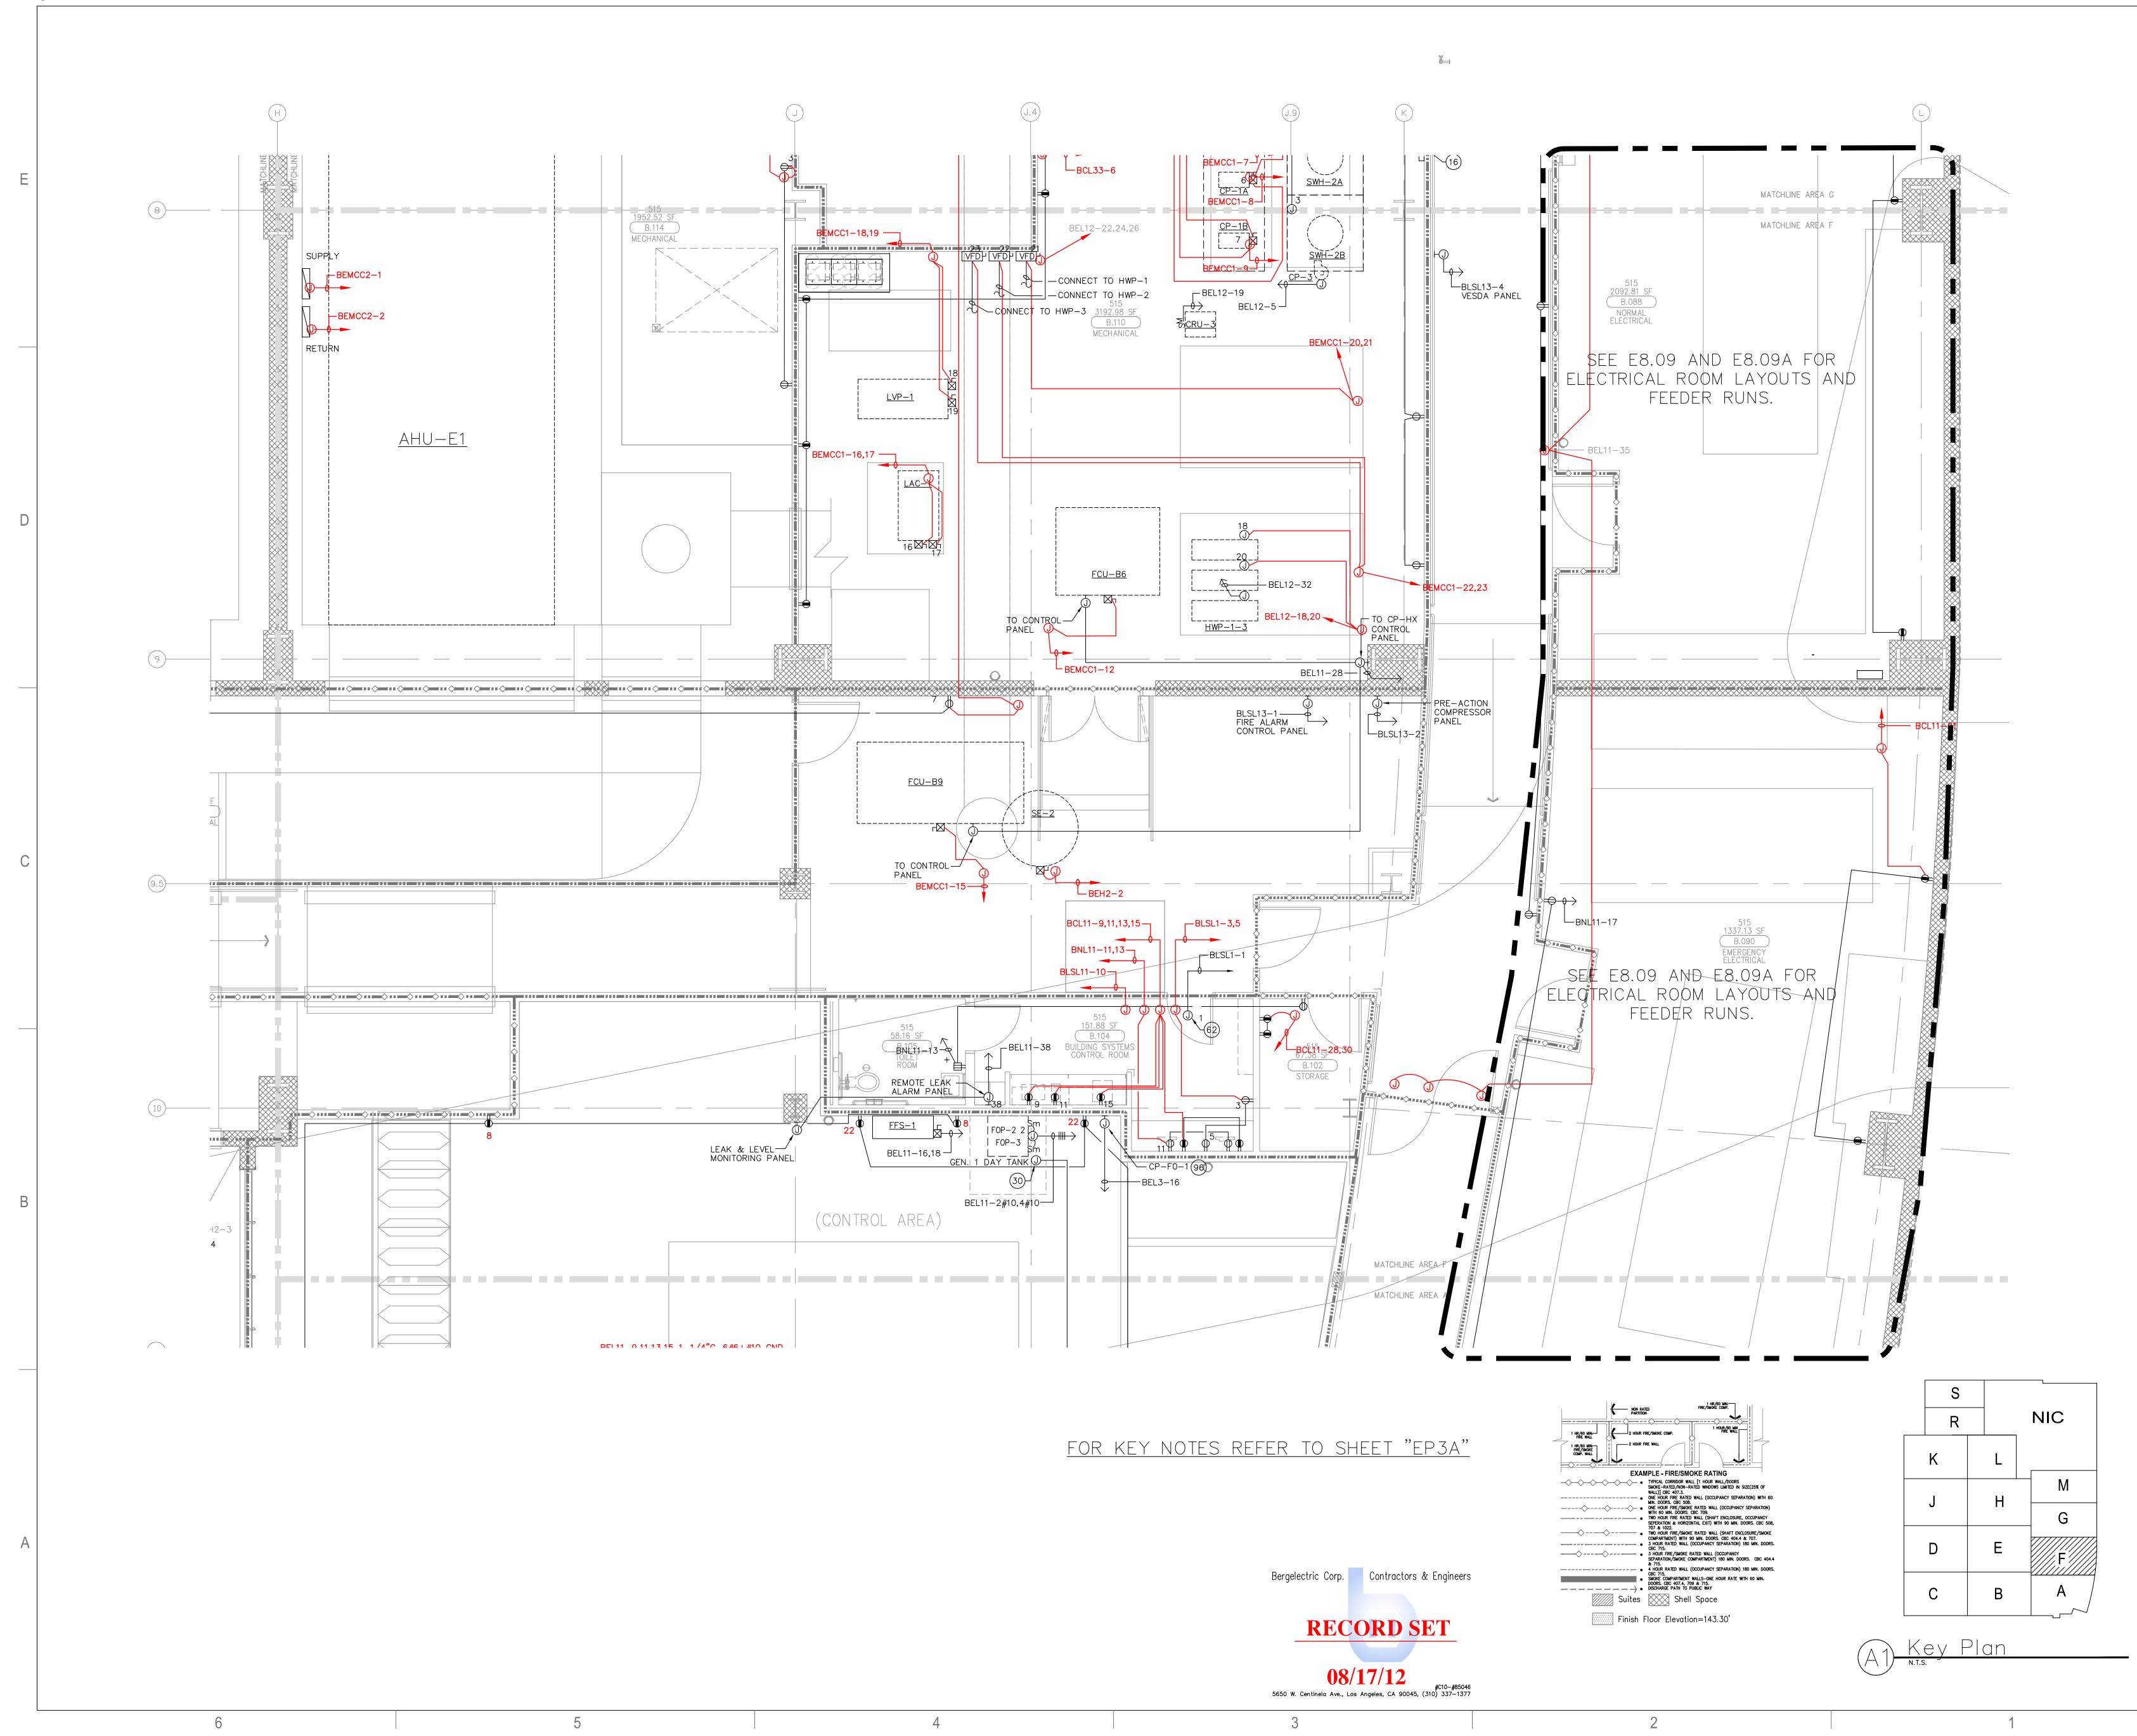

(C) 2007 FKP Architects, Inc. All rights reserved. No part of this document may be reproduced or utilized in any form without prior written authorization of FKP Architects, Inc.



LOWER LEVEL POWER PLAN AREA - F

Increment #7 OSHPD - PROJECT NUMBER IL 072072-30 ISSUE OSHPD PERMIT DATE 01/27/2010 SCALE 1/4"=1'-0"

ΗΟΣΡΙΤΑΙ

TOWER II

PROJECT NUMBER

DRAWING TITLE

12011.00

PROJECT NAME CHILDREN'S HOSPITAL OF ORANGE COUNTY 455 S. Main St. Orange, CA 92868-3874

APPROVAL

REVISIONS

CHANGE ORDER #104 /128 06/07/11 <u>⁄897</u> 12/19/11 CHANGE ORDER #294

100 South Anaheim Boulevard, Suite 150 Anaheim, California 92805 Phone: 714.490.5555 Fax: 714.490.5560 Project No. 2305-163-07

M A D

STRUCTURAL

MECHANICAL

ELECTRICAL

CIVIL




ARCHITECT OF RECORD

CONSULTANT

TAYLO R

&G AINES

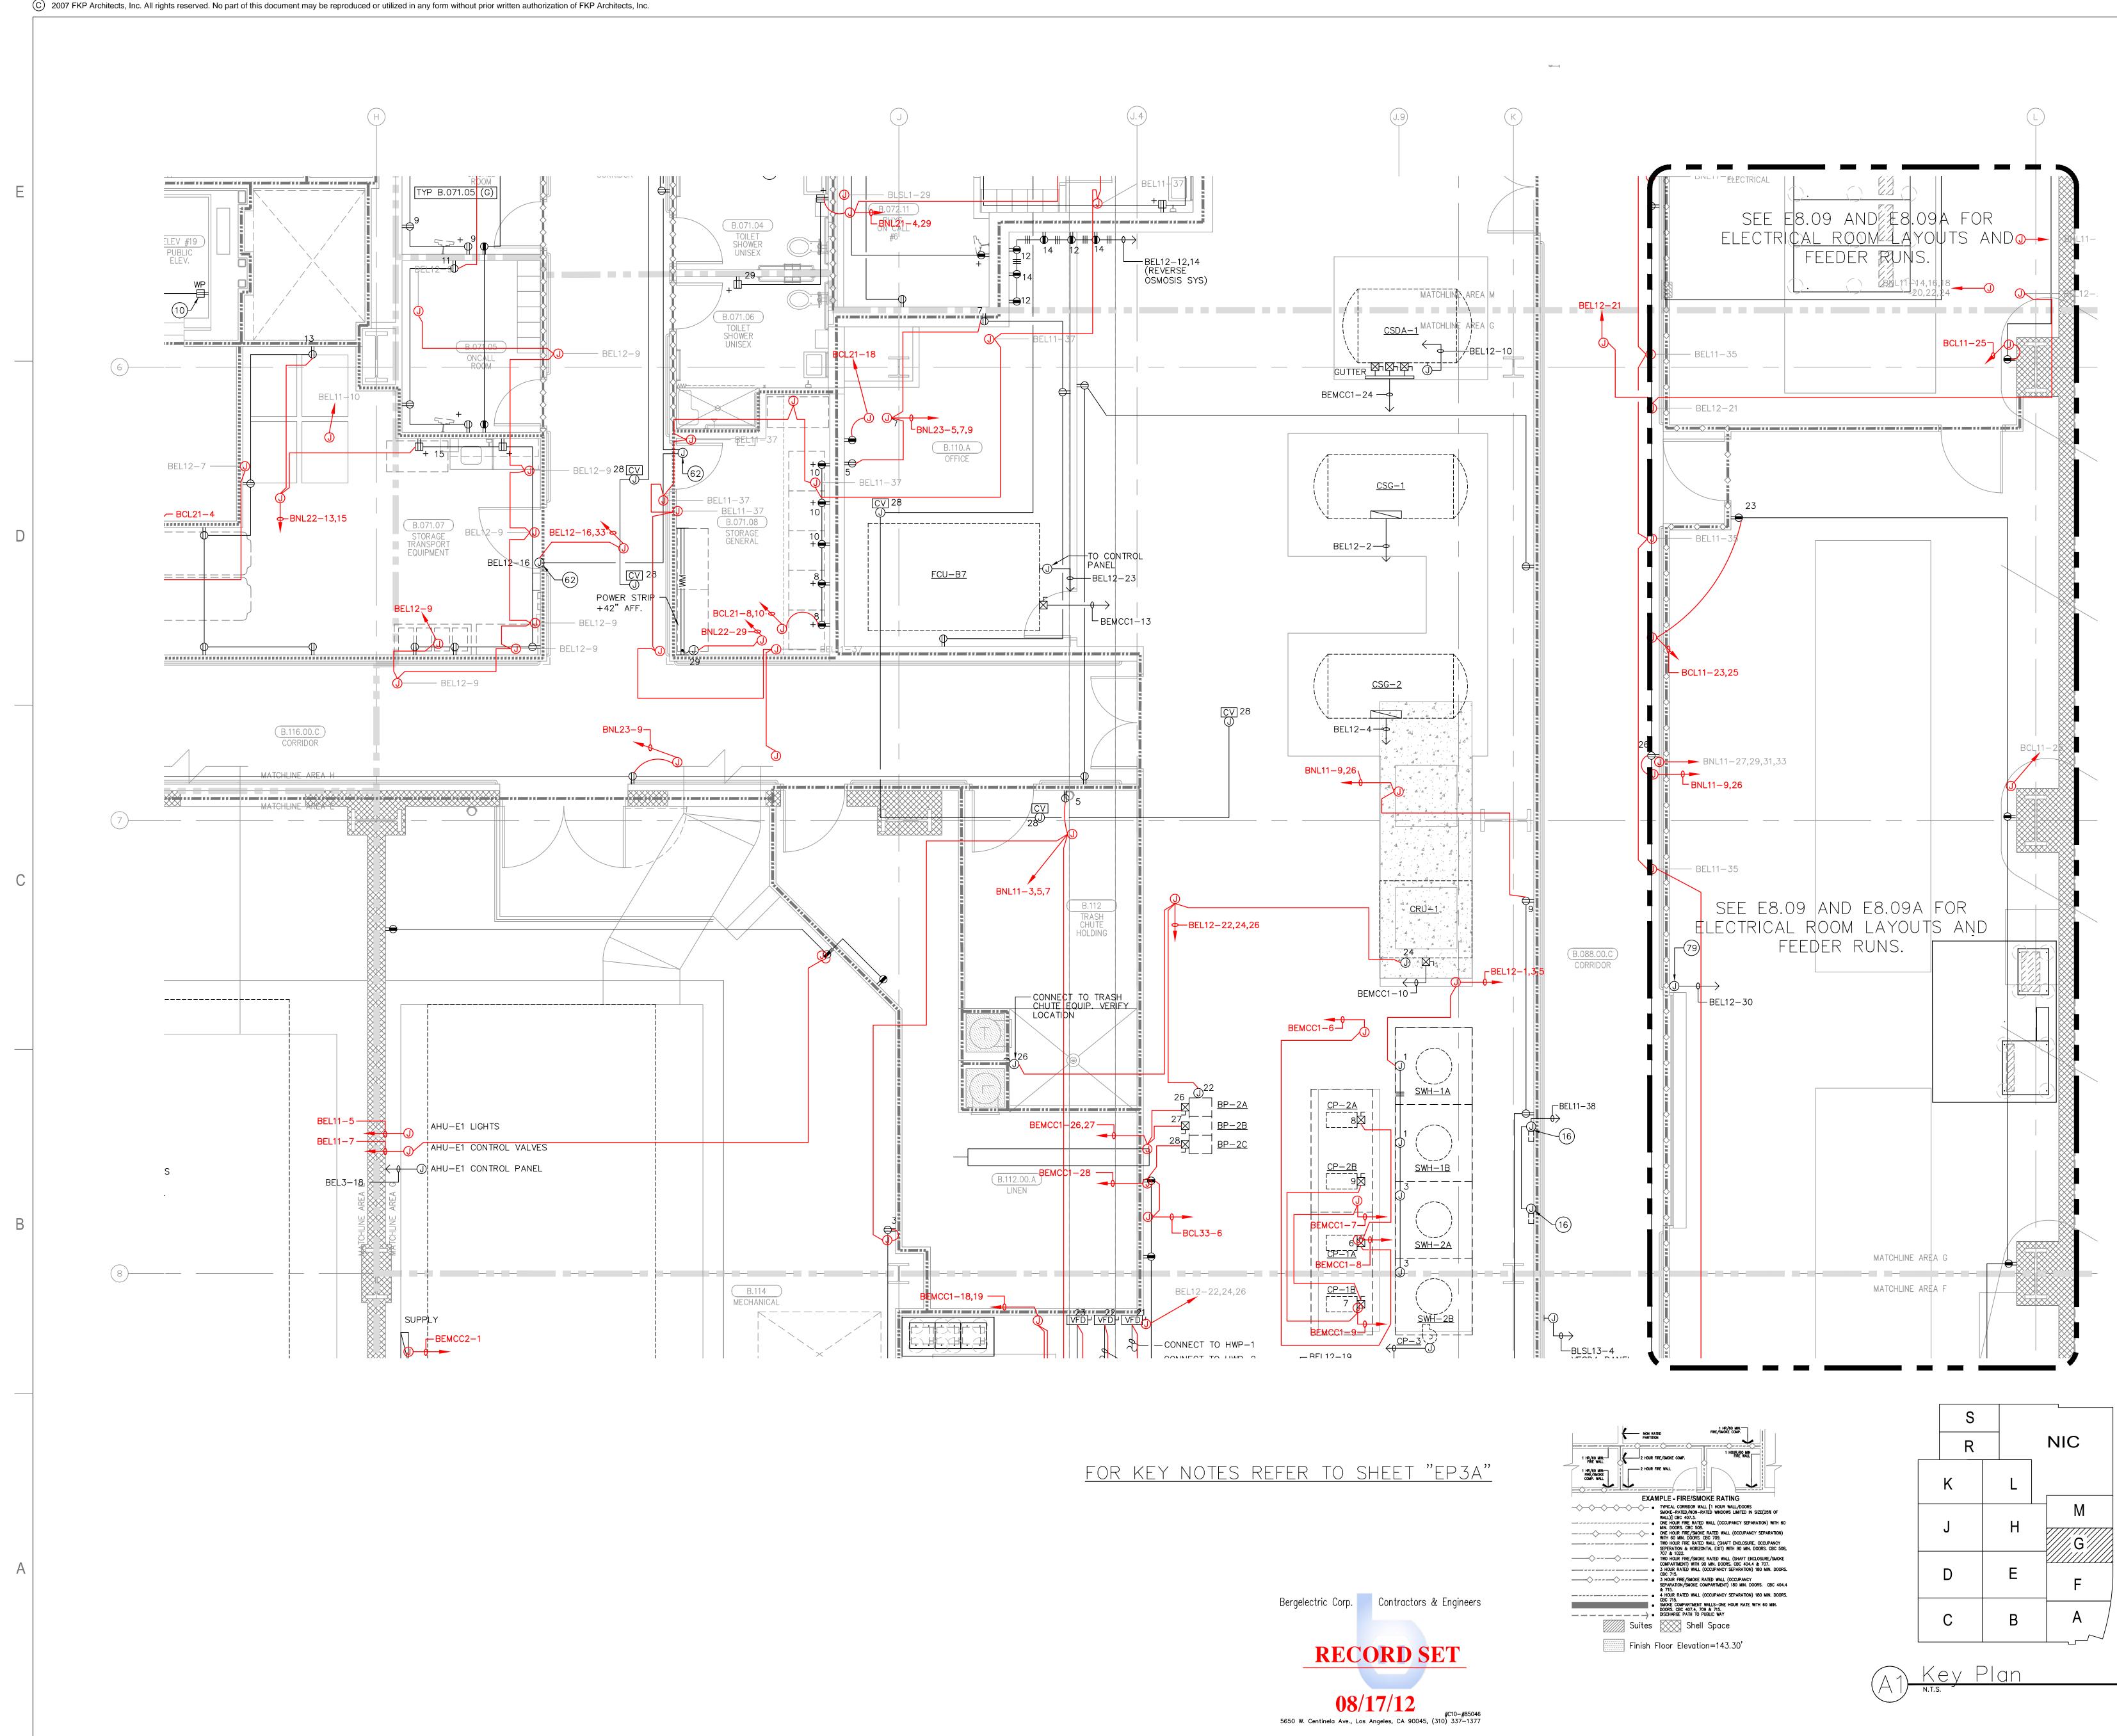

г. үгличецт 5/17/2012 SSOGHOMON



DRAWING NUMBER

1/4"=1'- 0" DRAWING TITLE LOWER LEVEL POWER PLAN AREA - G

OSHPD - PROJECT NUMBER IL 072072-30 ISSUE OSHPD PERMIT DATE 01/27/2010 SCALE

HOSPITAL

TOWER II

PROJECT NUMBER

12011.00

Increment #7

PROJECT NAME CHILDREN'S HOSPITAL OF ORANGE COUNTY 455 S. Main St. Orange, CA 92868-3874

APPROVAL

REVISIONS

12/19/11 CHANGE ORDER #294 <u>\$97</u>

100 South Anaheim Boulevard, Suite 150 Anaheim, California 92805 Phone: 714.490.5555 Fax: 714.490.5560 Project No. 2305-163-07

M A D

TAYLO R

&G AINES

STRUCTURAL


MECHANICAL

ELECTRICAL

CIVIL

ARCHITECT OF RECORD

CONSULTANT

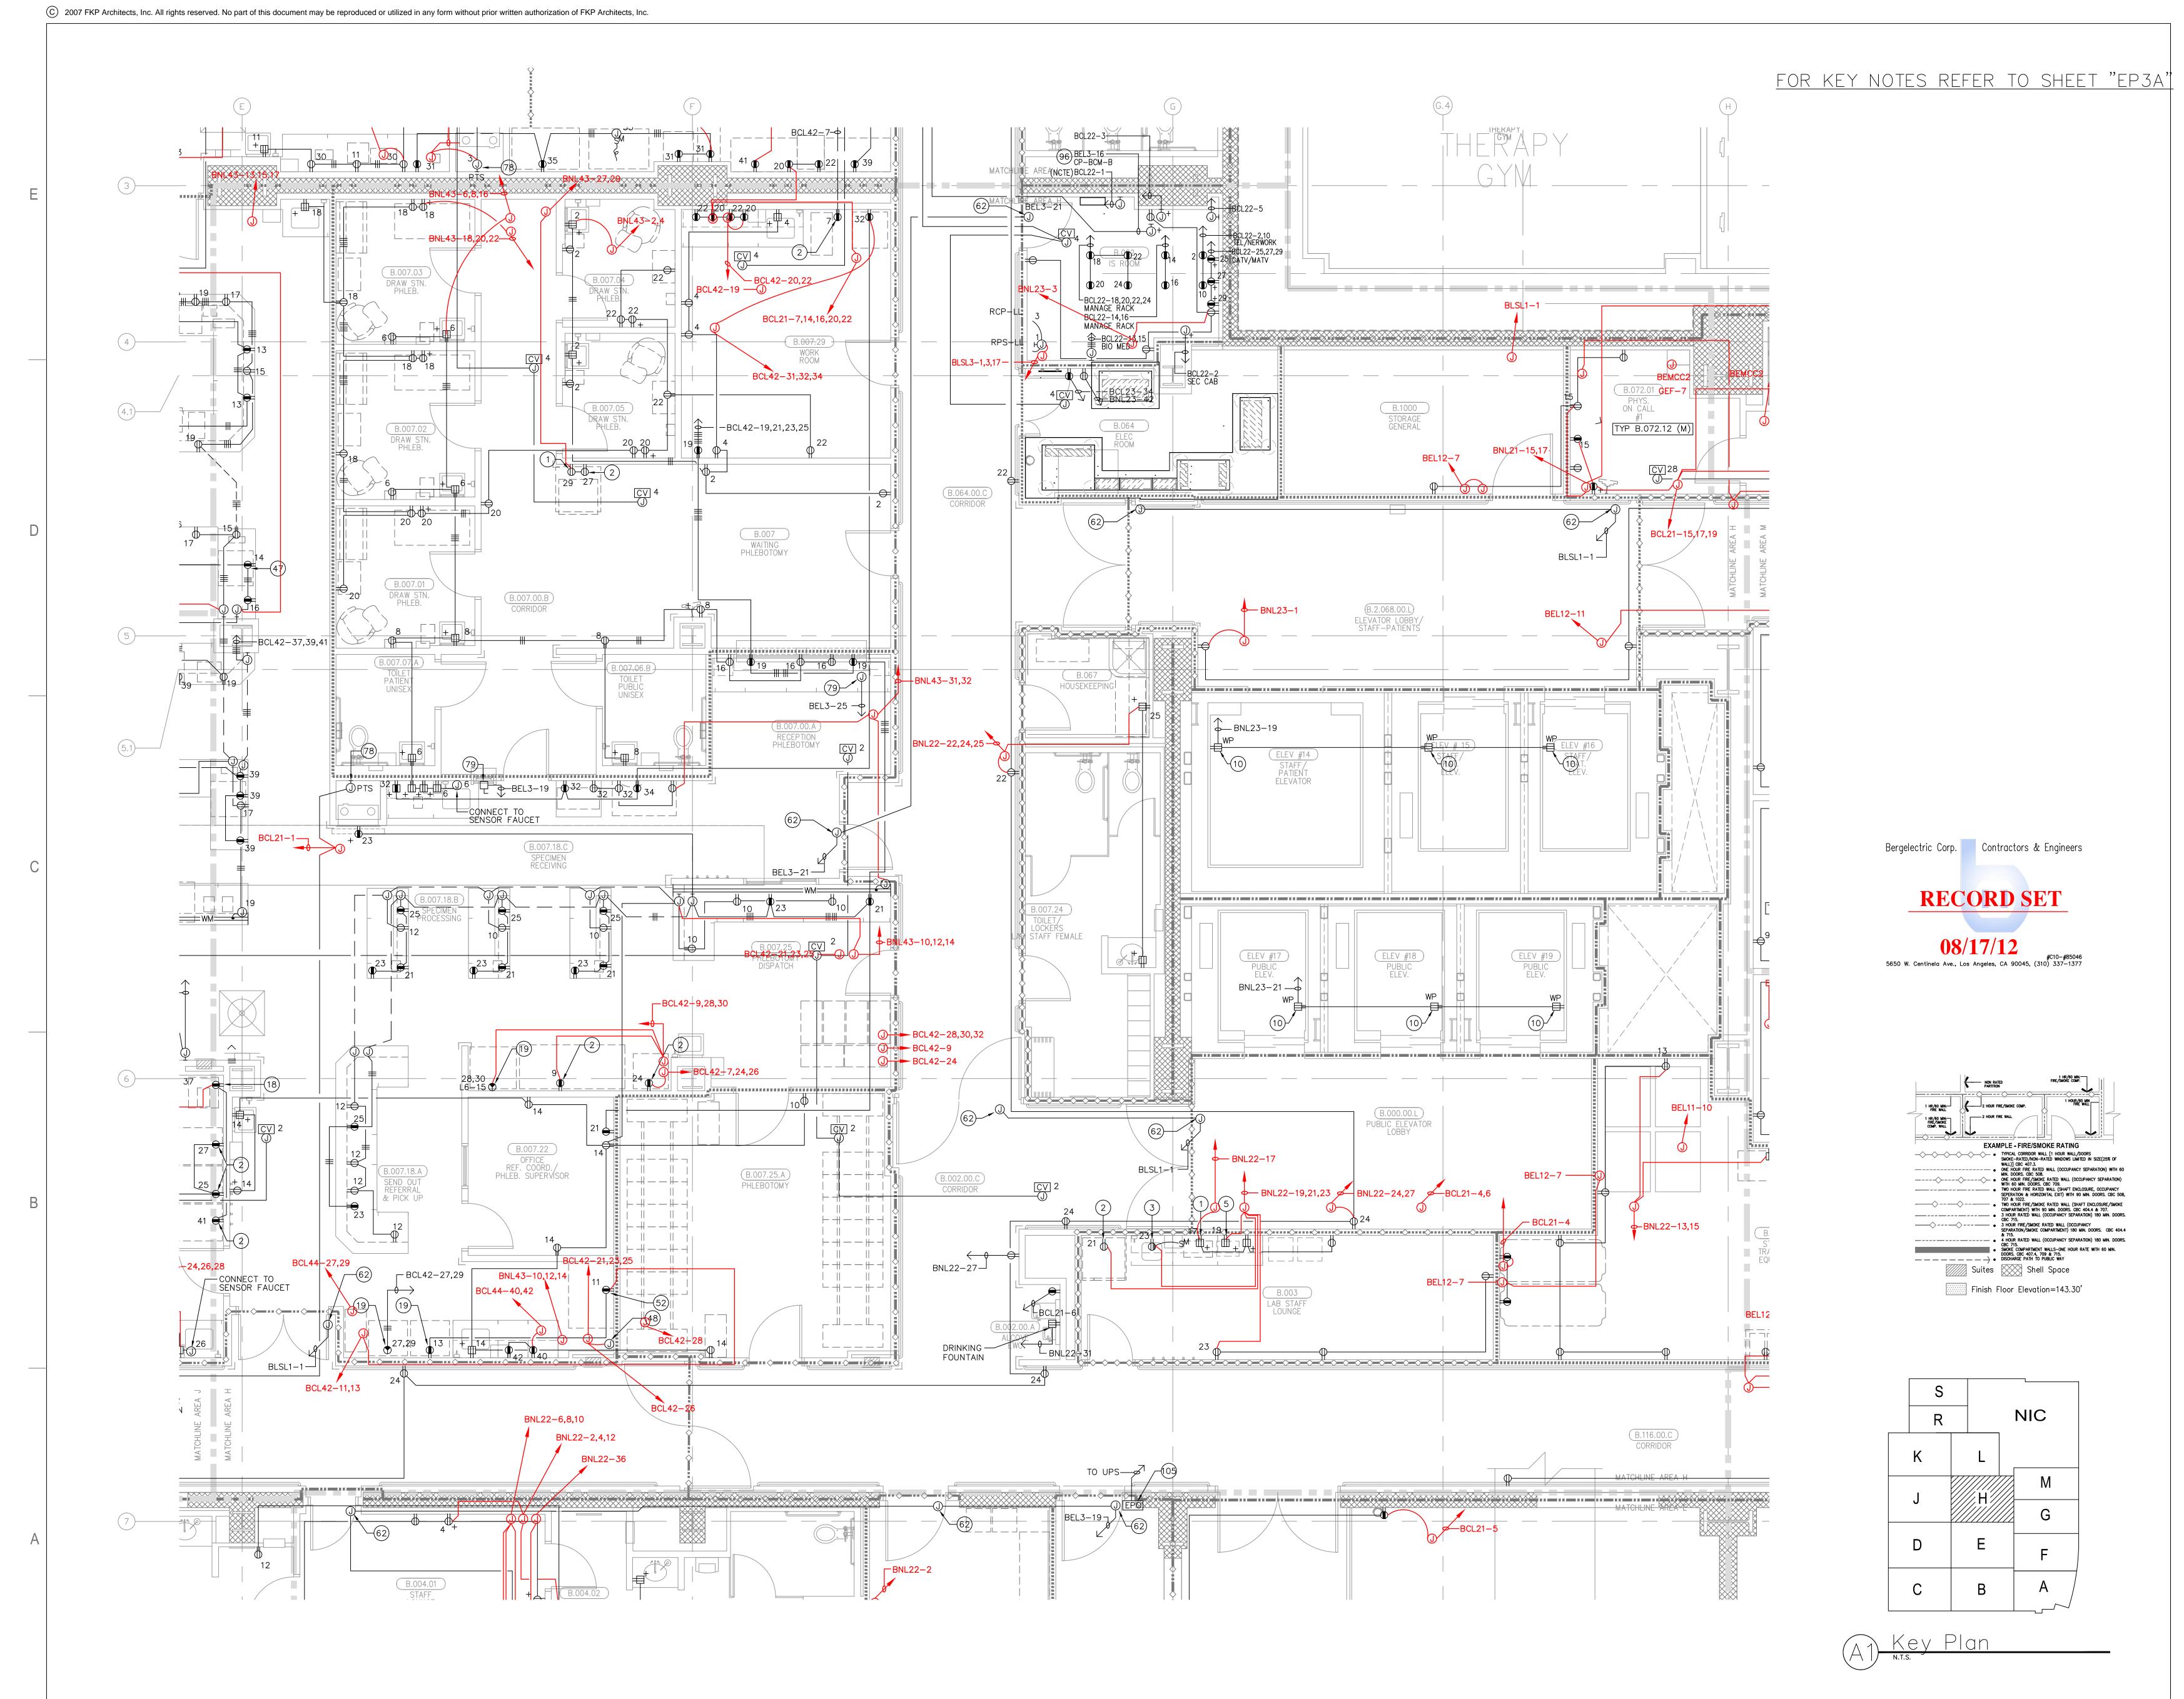

г. үгличец 5/18/2012 SSOGHOMON



DRAWING NUMBER

PROJECT NUMBER	
12011.00 Increment #7	
OSHPD - PROJECT NUMBER IL 072072-30	
ISSUE	
OSHPD PERMIT	
DATE	
01/27/2010	
SCALE	
1/4"=1'- 0" DRAWING TITLE	
LOWER LEVEL POWER PLAN AREA - H	

HOSPITAL

OF ORANGE COUNTY 455 S. Main St. Orange, CA 92868-3874 TOWER II

CHILDREN'S HOSPITAL

PROJECT NAME

APPROVAL

REVISIONS

07/12/10 09/26/11

02/05/10 INFORMATION BULLETIN #5 CHANGE ORDER #40 CHANGE ORDER #262

STRUCTURAL

MECHANICAL

ELECTRICAL

CIVIL

Phone: 714.490.5555 Fax: 714.490.5560 Project No. 2305-163-07

MAD

100 South Anaheim Boulevard, Suite 150


CONSULTANT	

TAYLO R

&G AINES

Anaheim, California 92805

ARCHITECT OF RECORD

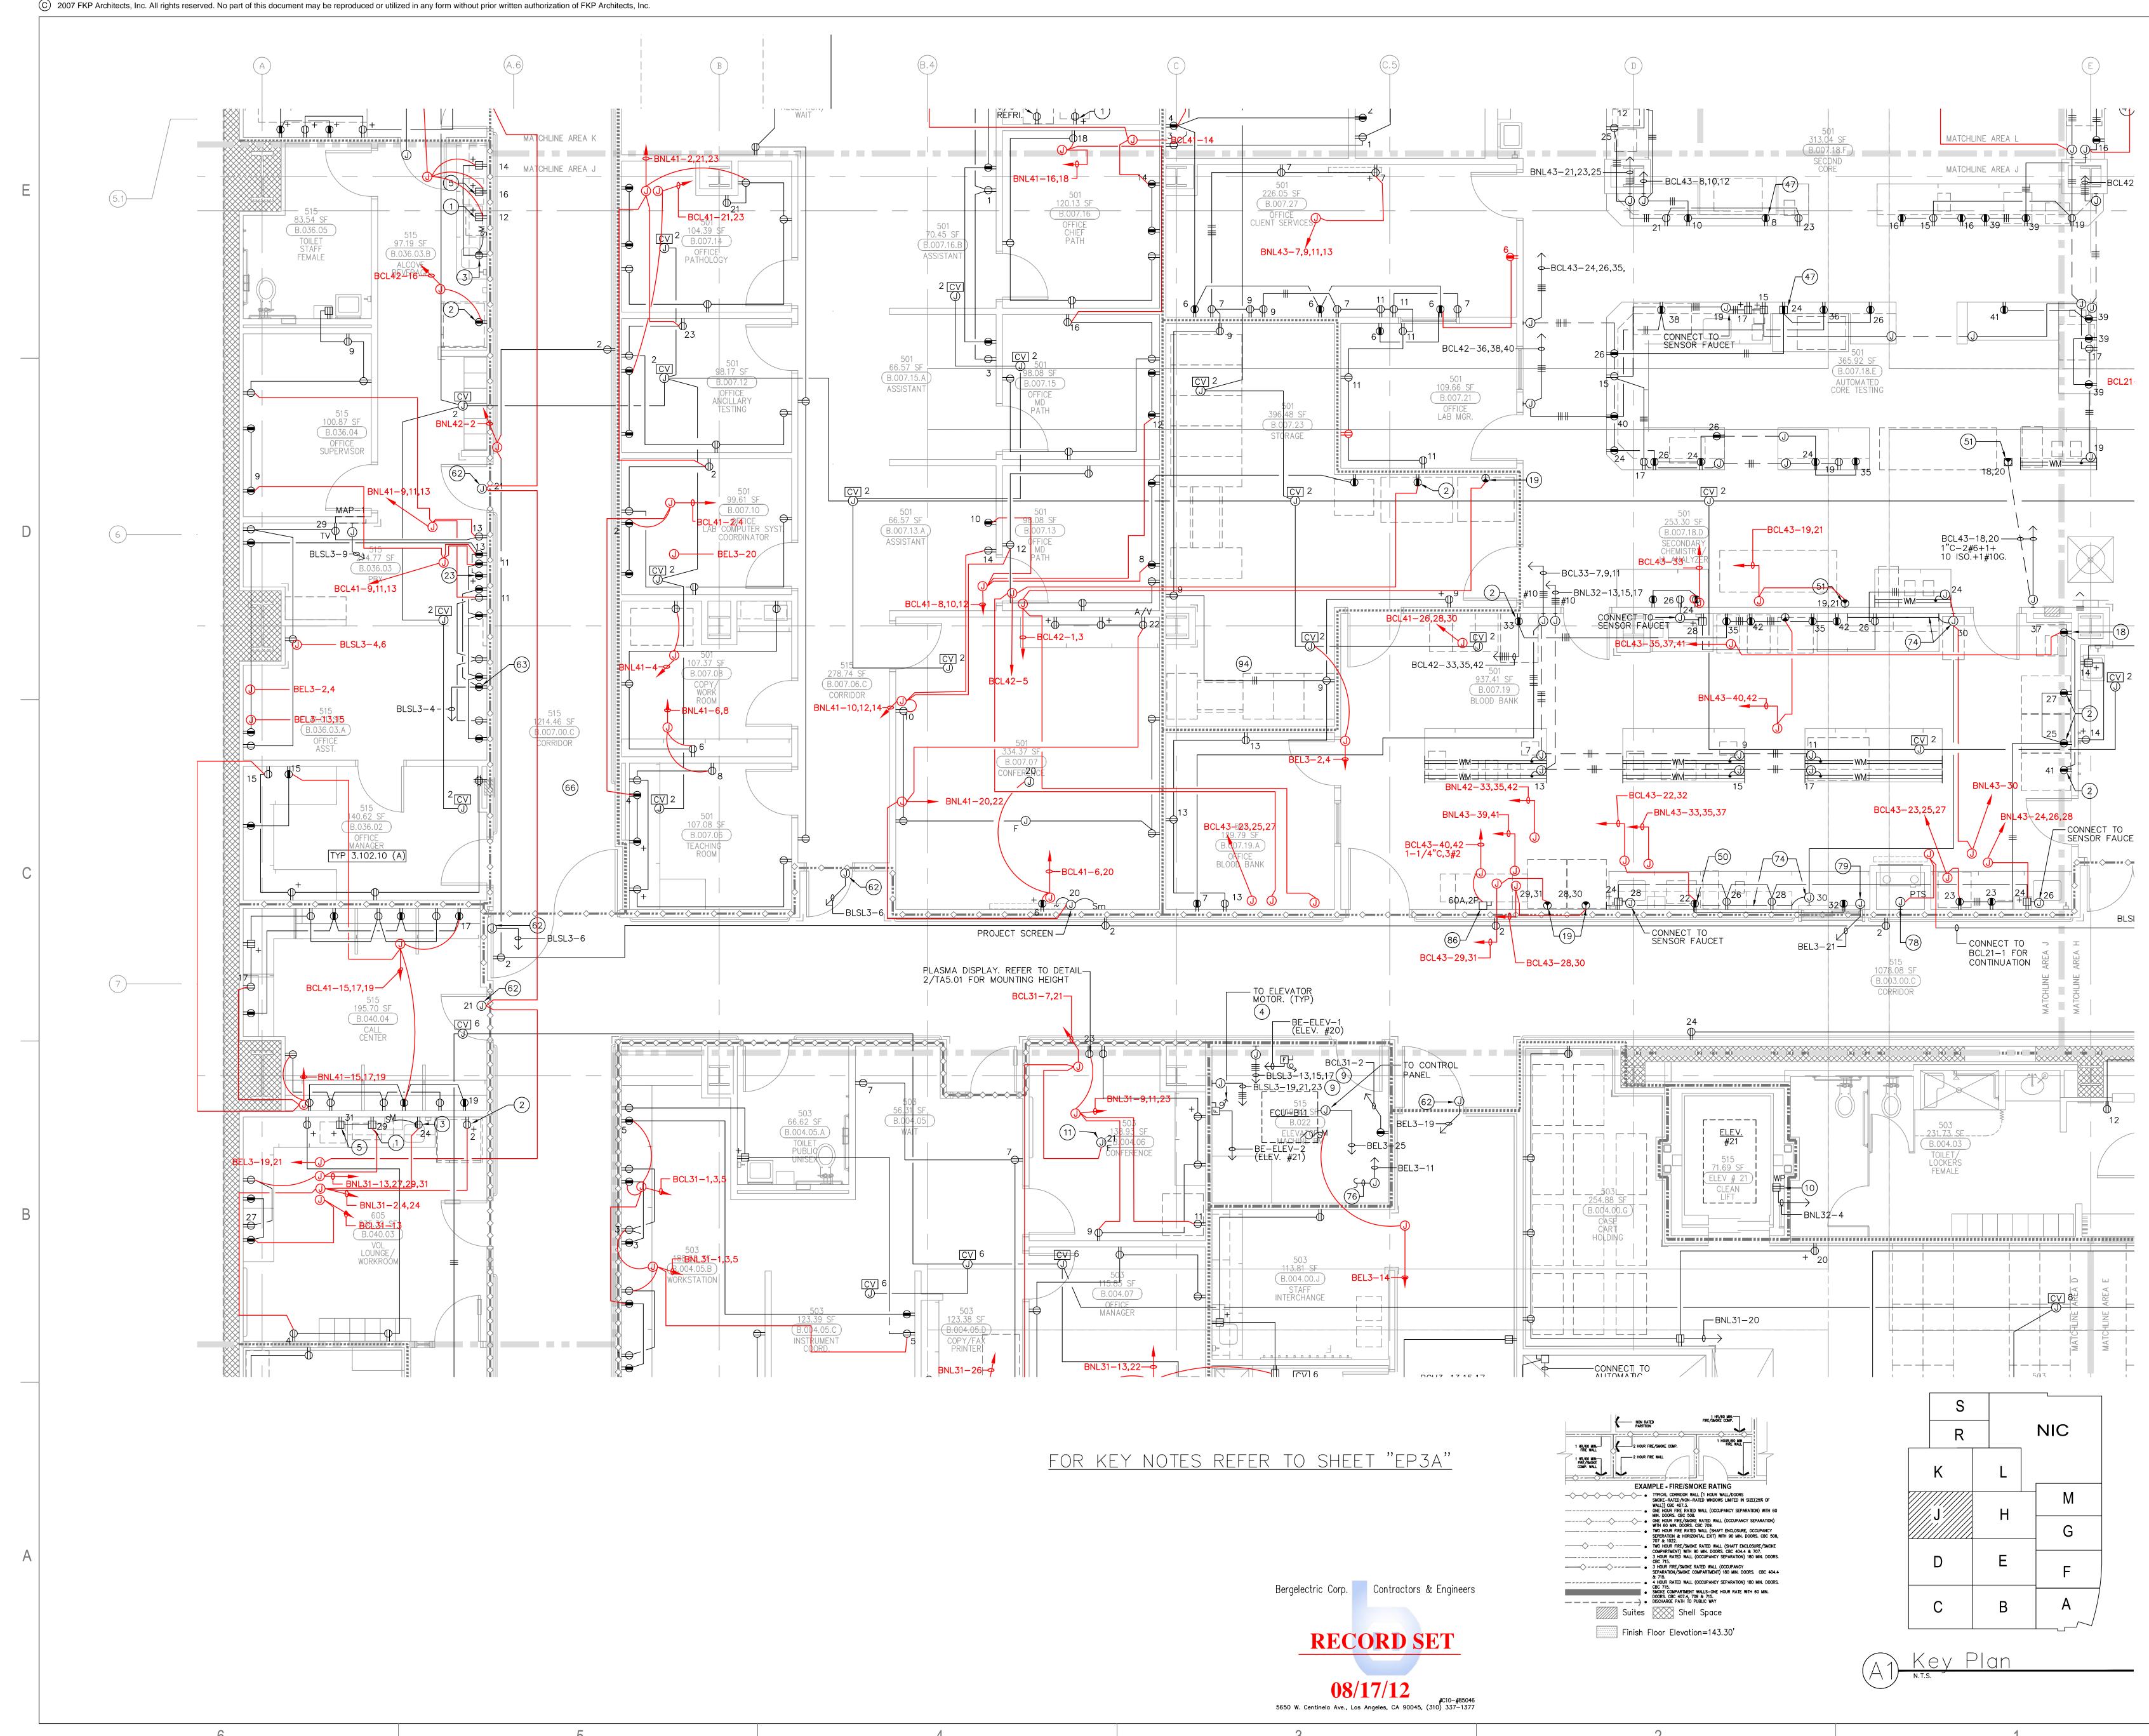

г. үглчиеч и 5/21/2012 SSOGHOMON



ARCHITECT OF RECORD

CONSULTANT

T M A D TAYLOR GAINES			
100 South Anaheim Boulevard			
Analysian California 00005			

Suite 150 Anaheim, California 92805 Phone: 714.490.5555 Fax: 714.490.5560 Project No. 2305-163-07

STRUCTURAL

MECHANICAL

ELECTRICAL

CIVIL

REVISIONS

	02/05/10	INFORMATION BULLETIN #5
41	07/12/10	CHANGE ORDER #40
157	03/08/11	CHANGE ORDER #130
835	09/26/11	CHANGE ORDER #262
370	12/05/11	CHANGE ORDER #288

APPROVAL




TOWER II



PROJECT NUMBER 12011.00 Increment #7 OSHPD - PROJECT NUMBER IL 072072-30 ISSUE **OSHPD PERMIT** DATE

01/27/2010 SCALE 1/4"=1'- 0" DRAWING TITLE

EP3.0J

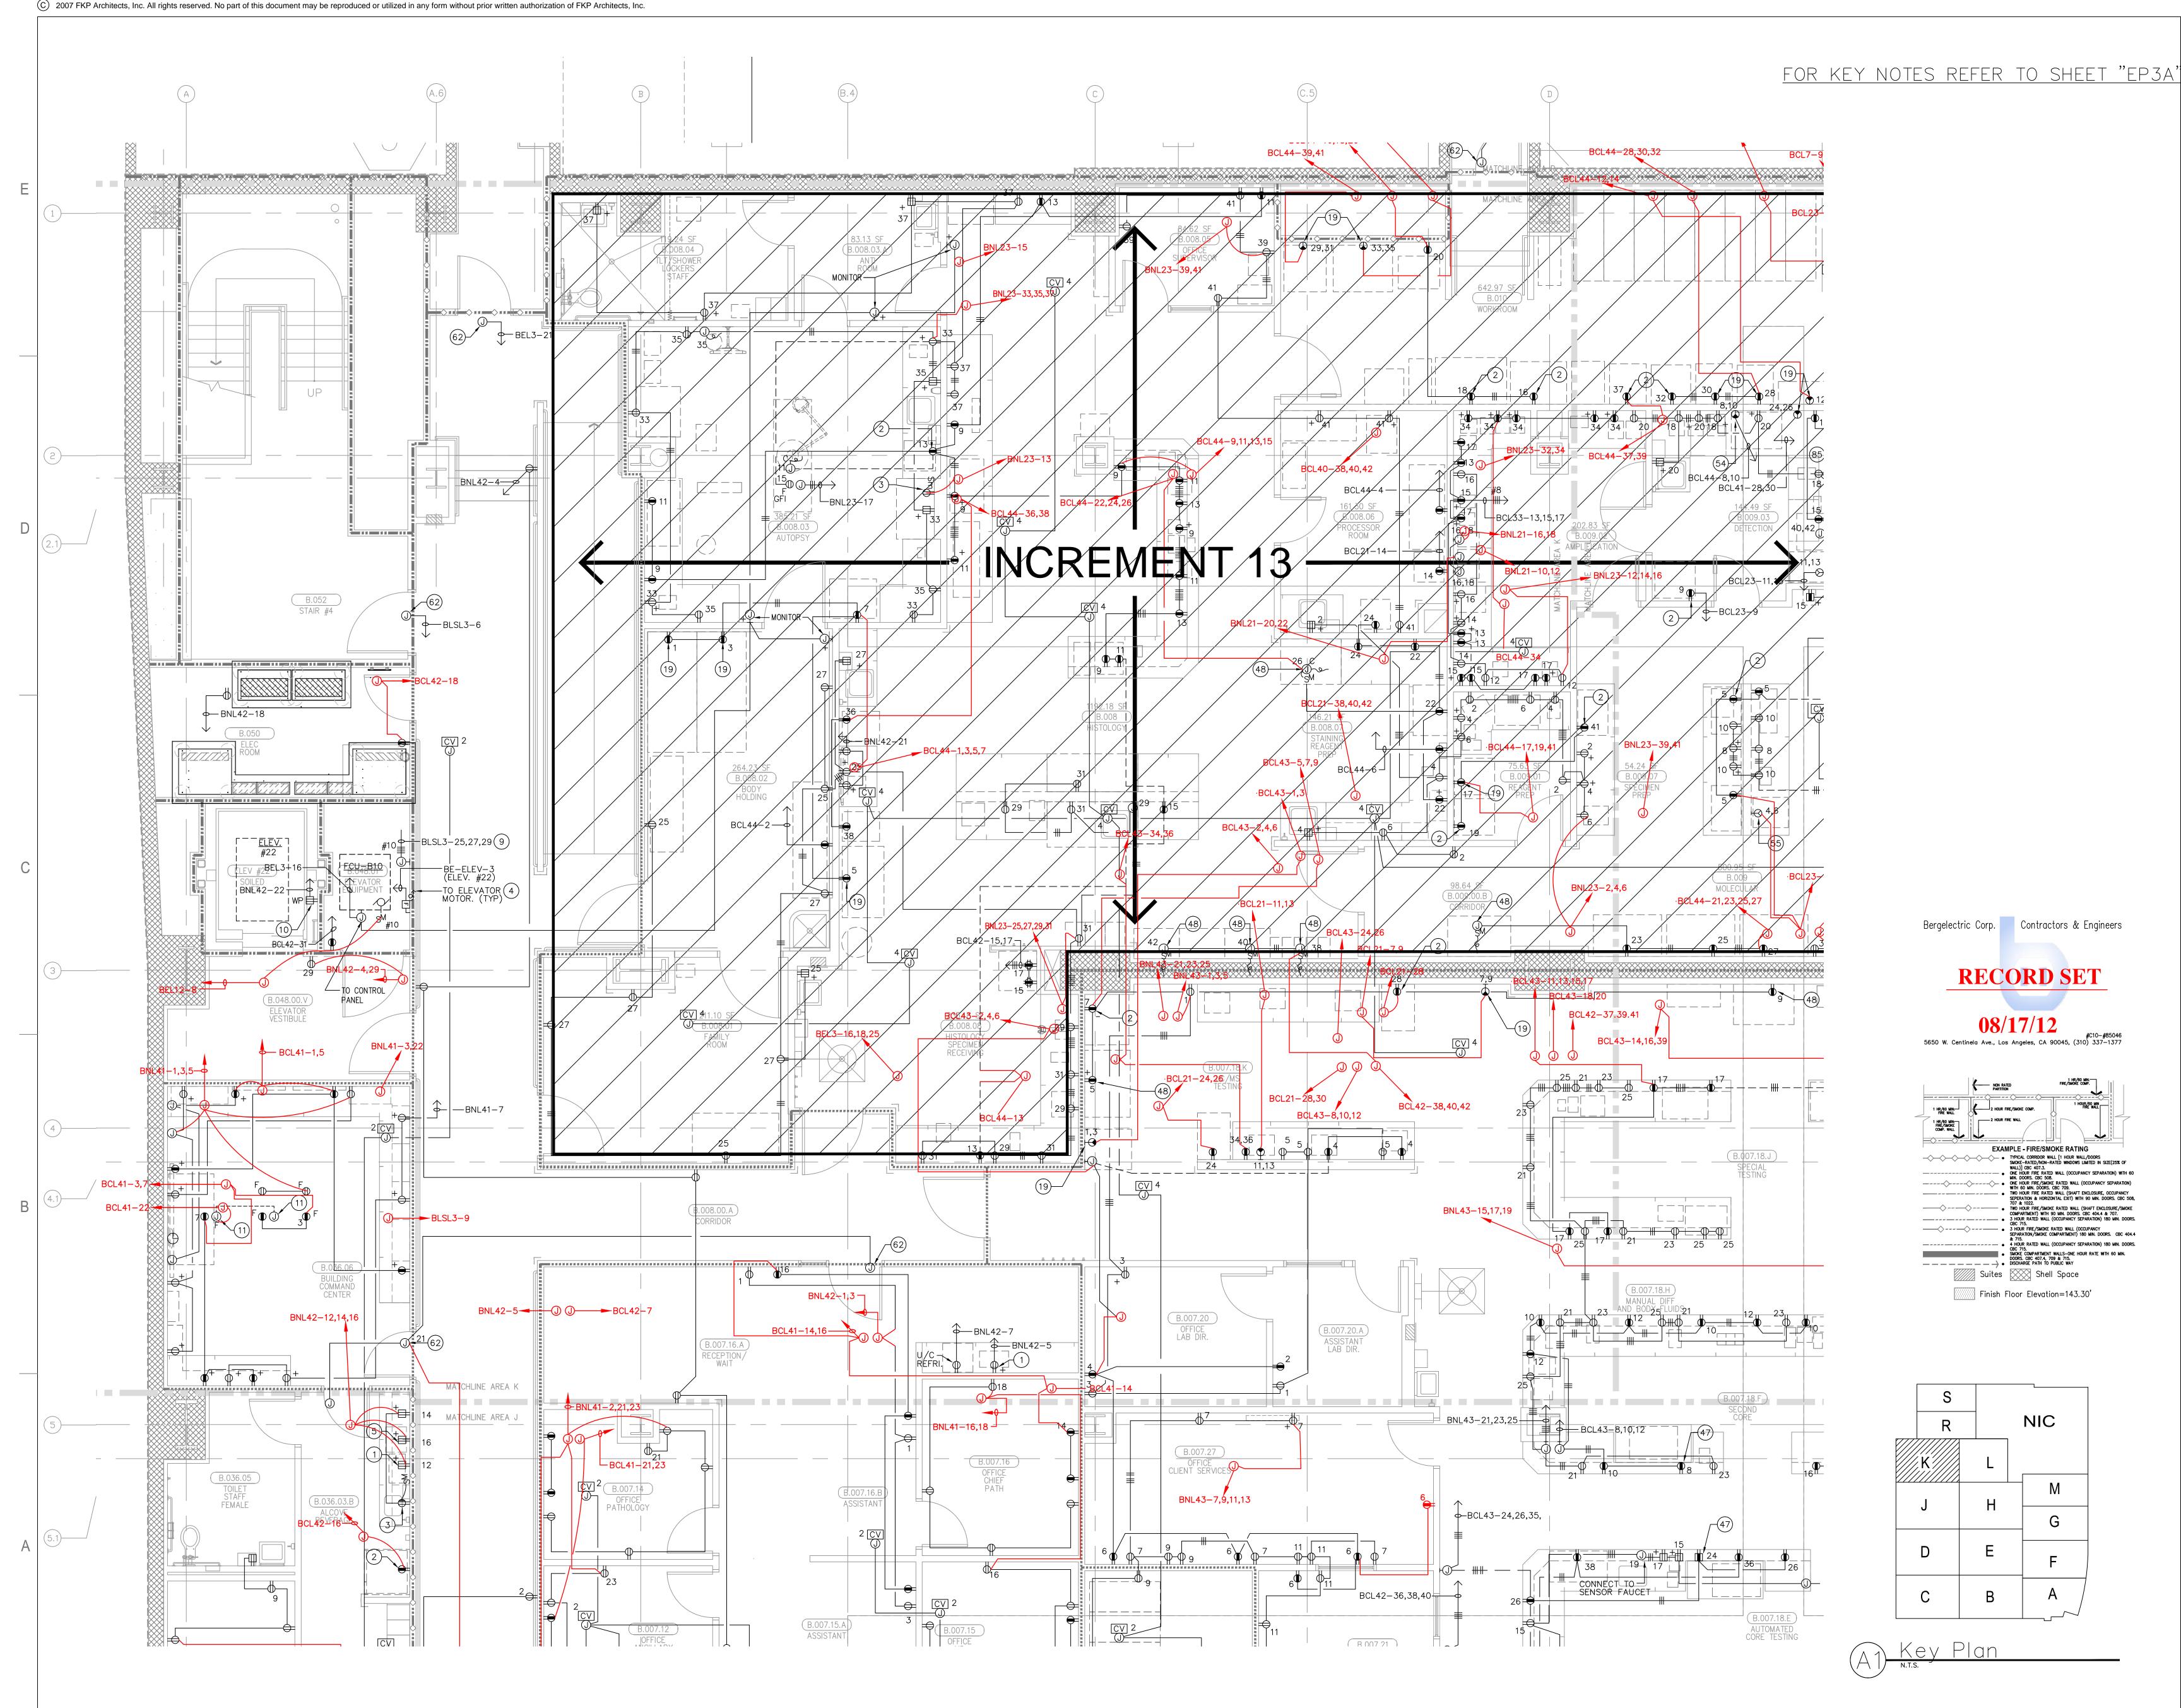

г. үгичечт 5/18/2012 SSOGHOMON



DRAWING NUMBER

ISSUE OSHPD PERMIT DATE 01/27/2010 SCALE 1/4"=1'-0" DRAWING TITLE LOWER LEVEL POWER PLAN AREA - K

3 HOSPITAL PROJECT NUMBER

CHILDREN'S HOSPITAL OF ORANGE COUNTY 455 S. Main St. Orange, CA 92868-3874 TOWER II

APPROVAL

PROJECT NAME

12011.00

Increment #7

OSHPD - PROJECT NUMBER

IL 072072-30

REVISIONS

^		
44	05/28/10	A.S.I. #8
27	11/22/10	CHANGE ORDER #2
370	12/05/11	CHANGE ORDER #2
397	12/19/11	CHANGE ORDER #2


ELECTRICAL &G AINES CIVIL 100 South Anaheim Boulevard, Suite 150 Anaheim, California 92805 Phone: 714.490.5555 Fax: 714.490.5560 Project No. 2305-163-07

STRUCTURAL

MECHANICAL

CONSULTANT MAD TAYLO R

ARCHITECT OF RECORD

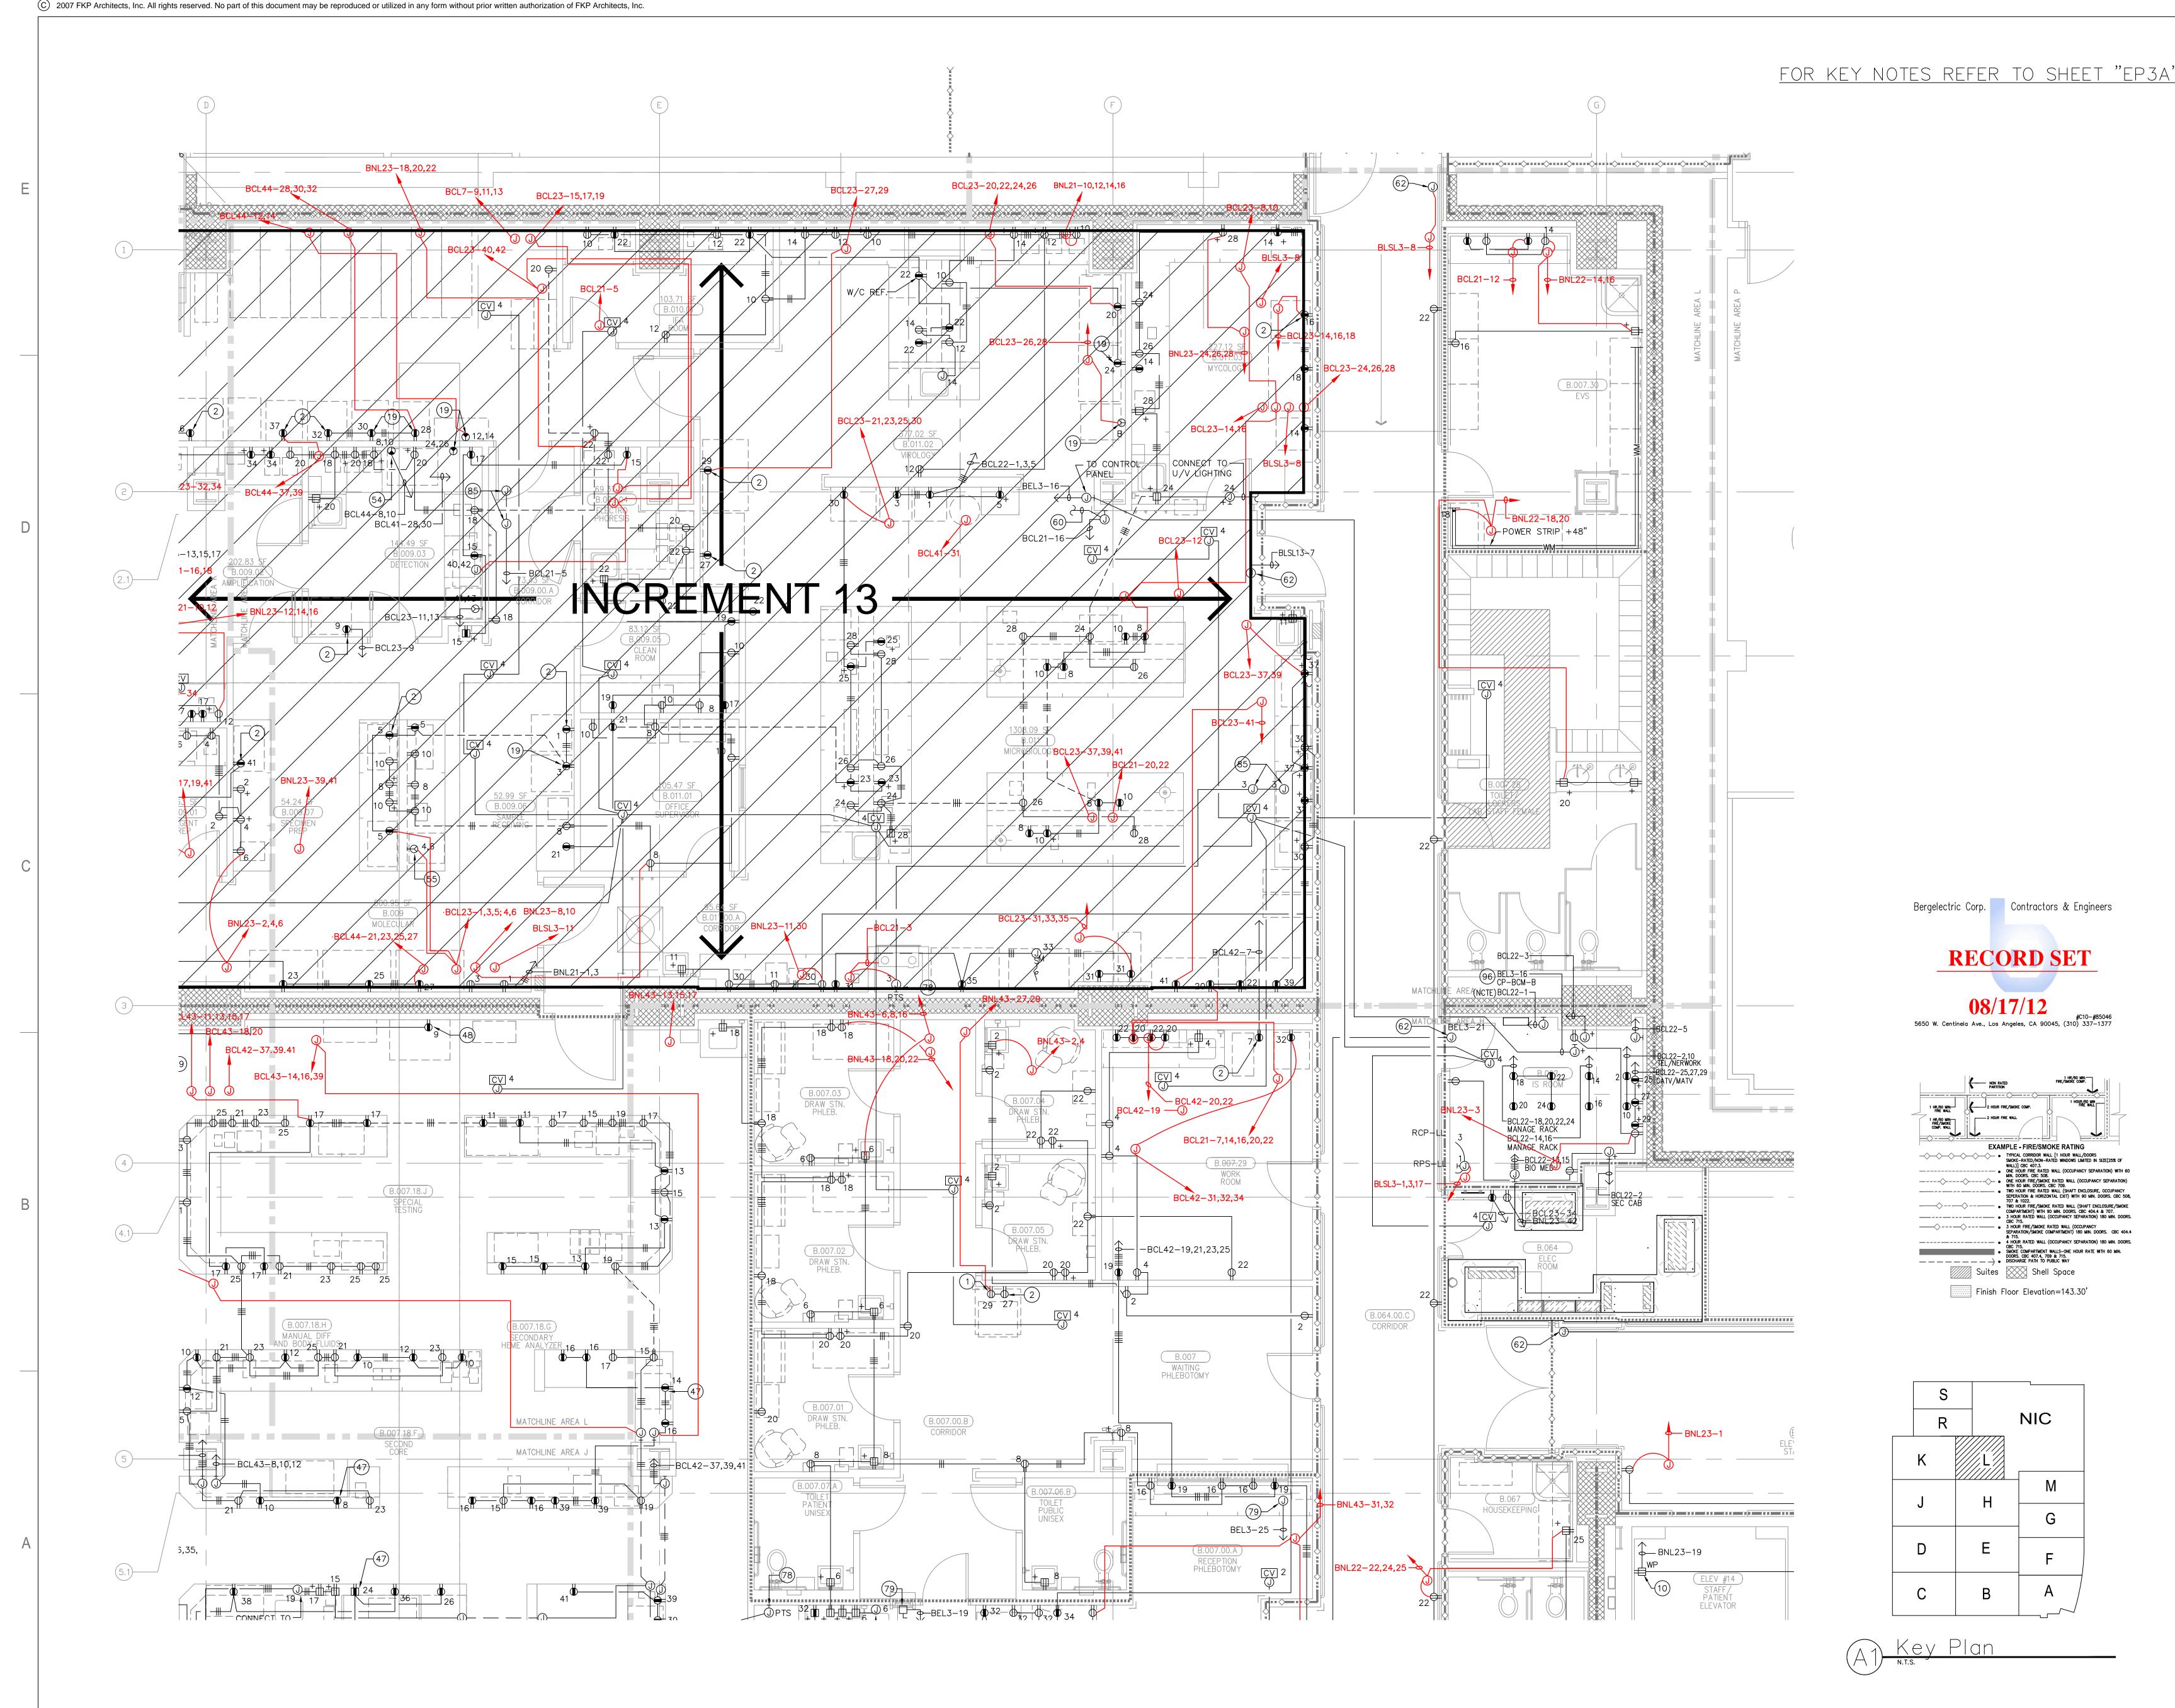

r. Vrnujelij vunul IIB/2 (nelunuj vrumen (erul 5/18/2012 SSOGHOMONYAN

5

4



DRAWING NUMBER

PROJECT NUMBER 12011.00 Increment #7 OSHPD - PROJECT NUMBER IL 072072-30 ISSUE OSHPD PERMIT DATE 01/27/2010 SCALE 1/4"=1'-0" DRAWING TITLE LOWER LEVEL POWER PLAN AREA - L

HOSPITAL

455 S. Main St. Orange, CA 92868-3874 TOWER II

PROJECT NAME CHILDREN'S HOSPITAL OF ORANGE COUNTY

APPROVAL

REVISIONS

 02/05/10
 INFORMATION BULLETIN #5

 07/12/10
 CHANGE ORDER #40

 12/19/11
 CHANGE ORDER #294

Anaheim, California 92805 Phone: 714.490.5555 Fax: 714.490.5560 Project No. 2305-163-07

100 South Anaheim Boulevard, Suite 150

MAD

TAYLO R

&G AINES

STRUCTURAL

MECHANICAL


ELECTRICAL

CIVIL

ARCHITECT OF RECORD

CONSULTANT



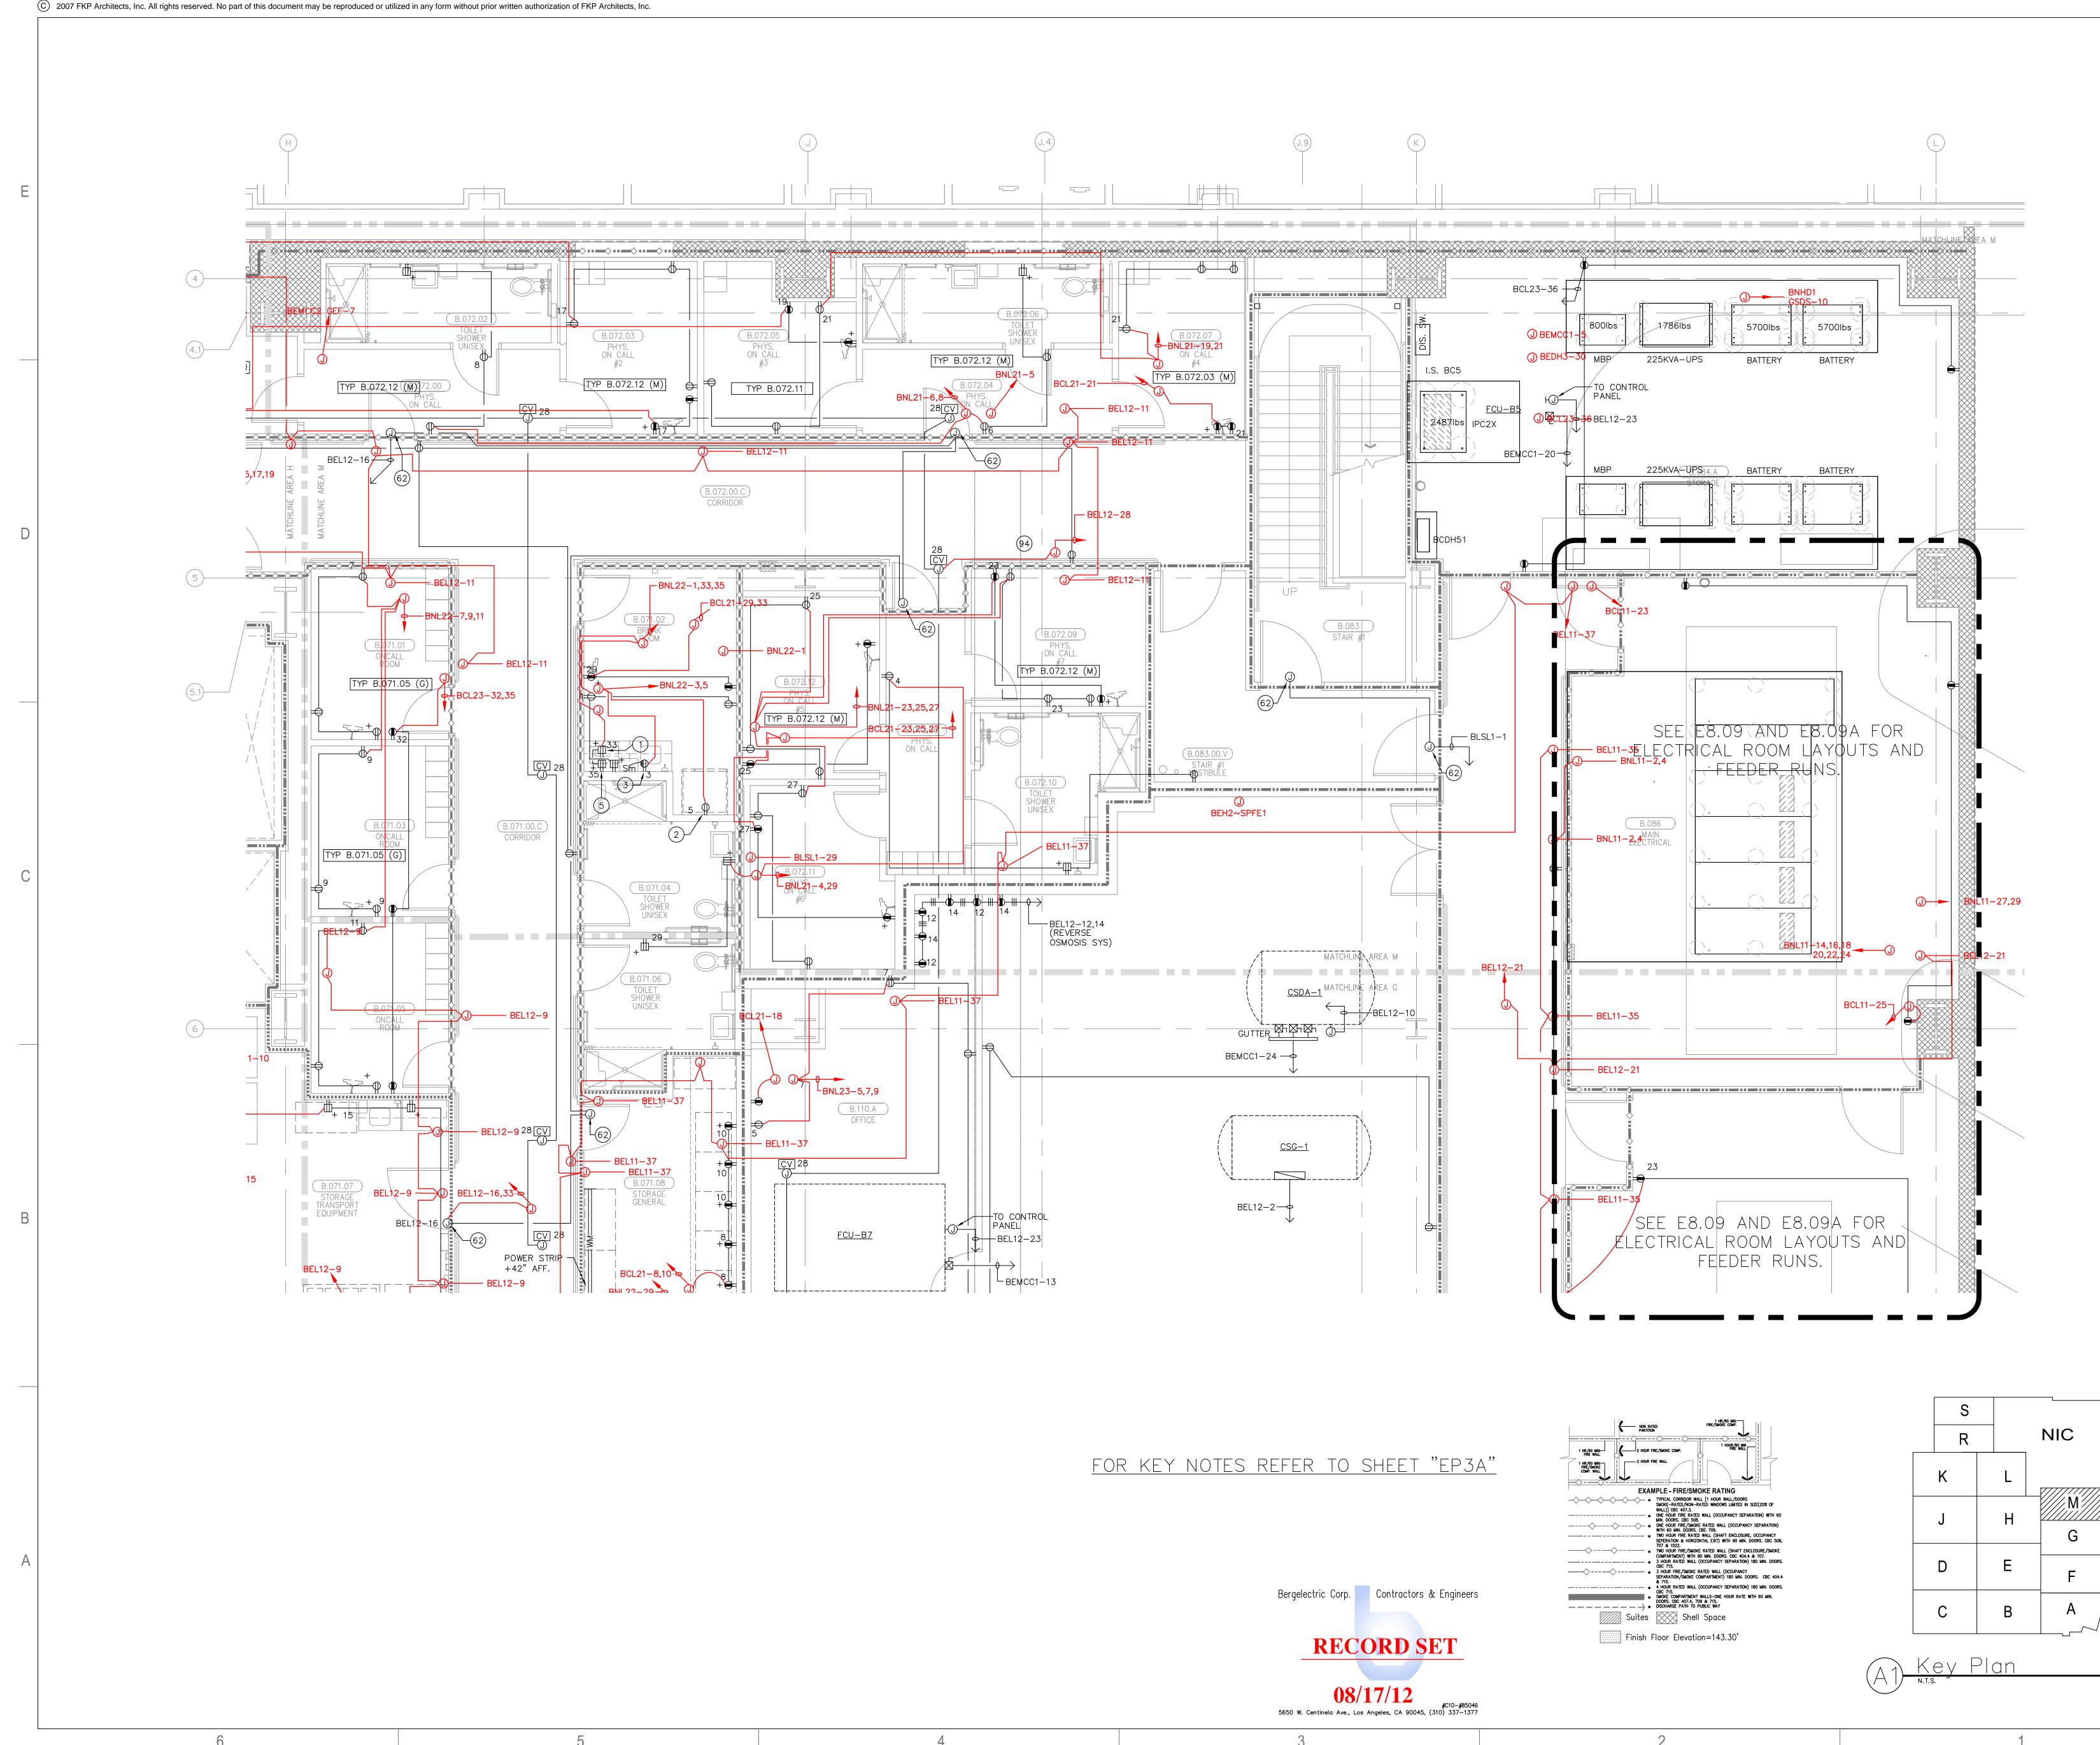

г. \гичечи 5/21/2012 SSOGHOMON



DRAWING NUMBER

UHUU
ΗΟΣΡΙΤΑΙ
PROJECT NUMBER
12011.00 Increment #7
<u>OSHPD - PROJECT NUMBER</u> IL 072072-30
ISSUE
OSHPD PERMIT
01/27/2010 SCALE
1/4"=1'-0" DRAWING TITLE
LOWER LEVEL POWER PLAN AREA - M

TOWER II



APPROVAL

PROJECT NAME

REVISIONS

$\overline{1}$	02/02/10	OSHPD CHANGE ORDER #9
14	03/31/10	CHANGE ORDER #14
28	06/14/10	CHANGE ORDER #11
27	11/22/10	CHANGE ORDER #29
182	02/14/11	CHANGE ORDER #122
297	12/19/11	CHANGE ORDER #294

100 South Anaheim Boulevard, Suite 150 Anaheim, California 92805 Phone: 714.490.5555 Fax: 714.490.5560 Project No. 2305-163-07

TMAD

TAYLO R

&G AINES

STRUCTURAL

MECHANICAL


ELECTRICAL

CIVIL

ARCHITECT OF RECORD

CONSULTANT



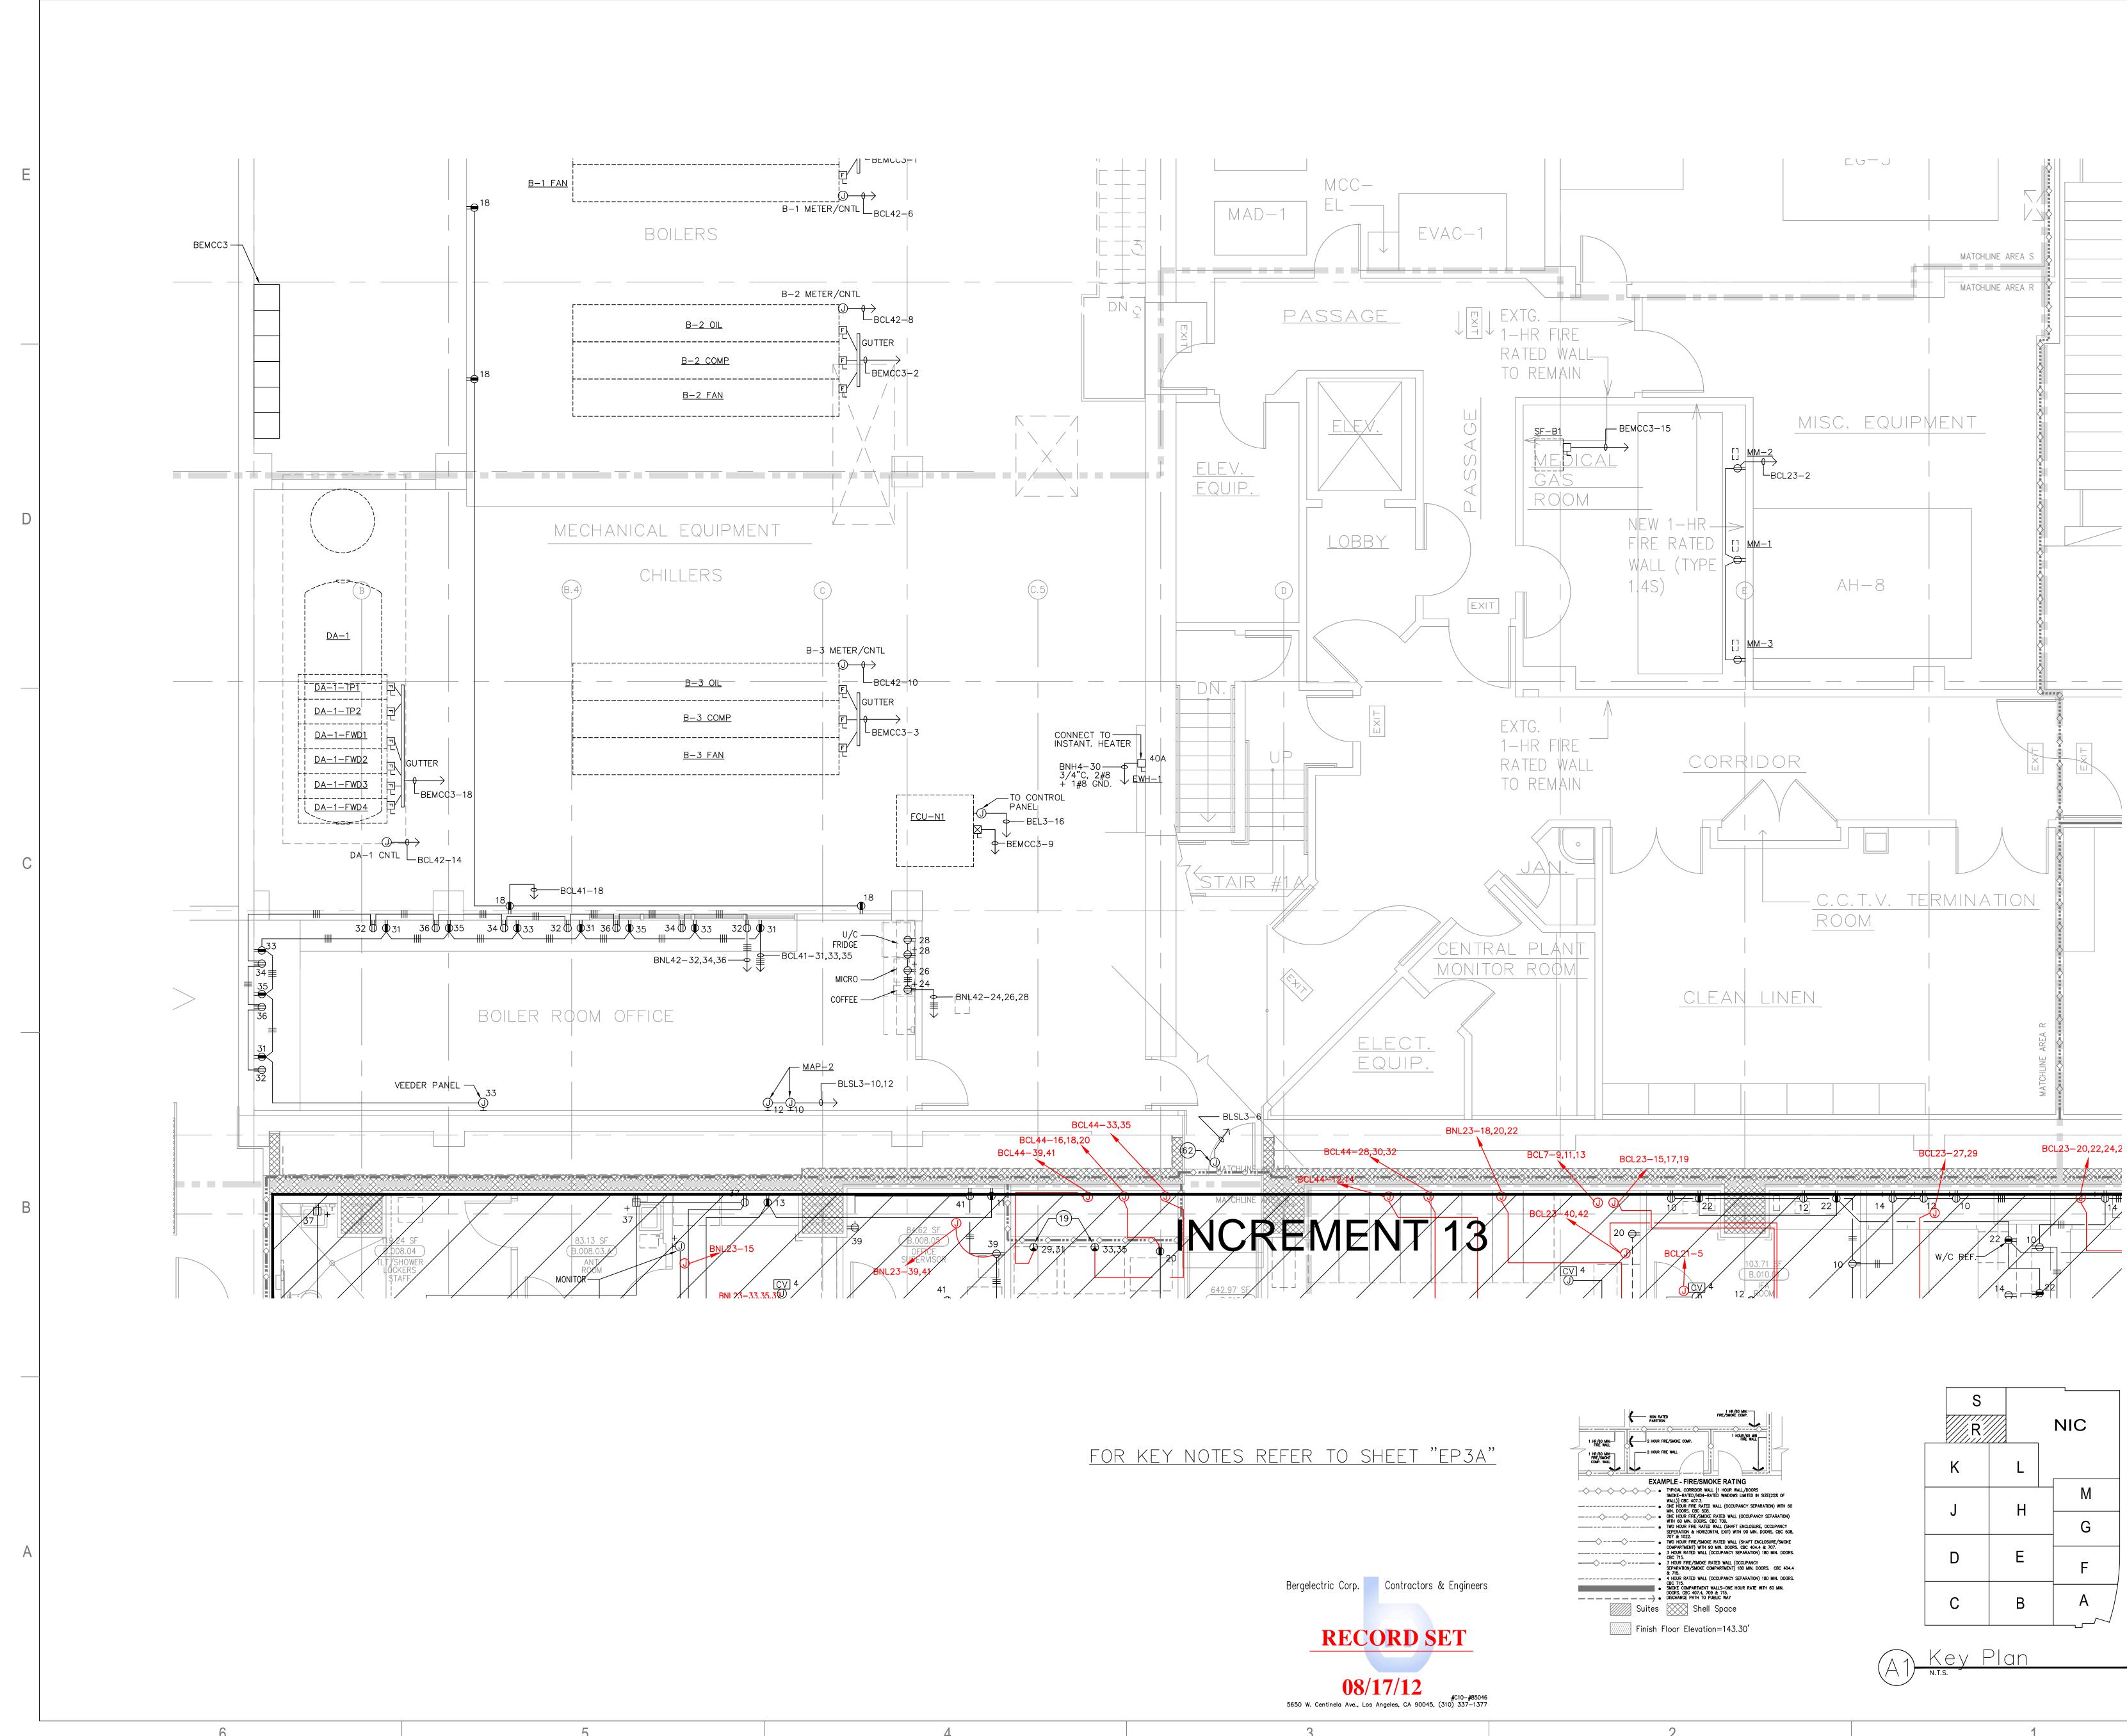

г. үгличец 1 5/18/2012 SSOGHOMON

(C) 2007 FKP Architects, Inc. All rights reserved. No part of this document may be reproduced or utilized in any form without prior written authorization of FKP Architects, Inc.

	S			NIC
	K		L	
	J	ŀ	Ц	 М
			11	G
	D		Е	F
	С		В	A



DRAWING NUMBER

LOWER LEVEL POWER PLAN AREA - R

IL 072072-30 ISSUE OSHPD PERMIT DATE 01/27/2010 SCALE

1/4"=1'-0"

DRAWING TITLE

PROJECT NUMBER 12011.00 Increment #7 OSHPD - PROJECT NUMBER

HOSPITAL

TOWER II

PROJECT NAME CHILDREN'S HOSPITAL OF ORANGE COUNTY 455 S. Main St. Orange, CA 92868-3874

APPROVAL

294 <u>\$70</u>

REVISIONS

07/14/11

CHANGE ORDER #230 12/05/11 CHANGE ORDER #288

STRUCTURAL


MECHANICAL

ELECTRICAL &G AINES CIVIL 100 South Anaheim Boulevard, Suite 150 Anaheim, California 92805 Phone: 714.490.5555 Fax: 714.490.5560 Project No. 2305-163-07

CONSULTANT TMAD TAYLO R

ARCHITECT OF RECORD



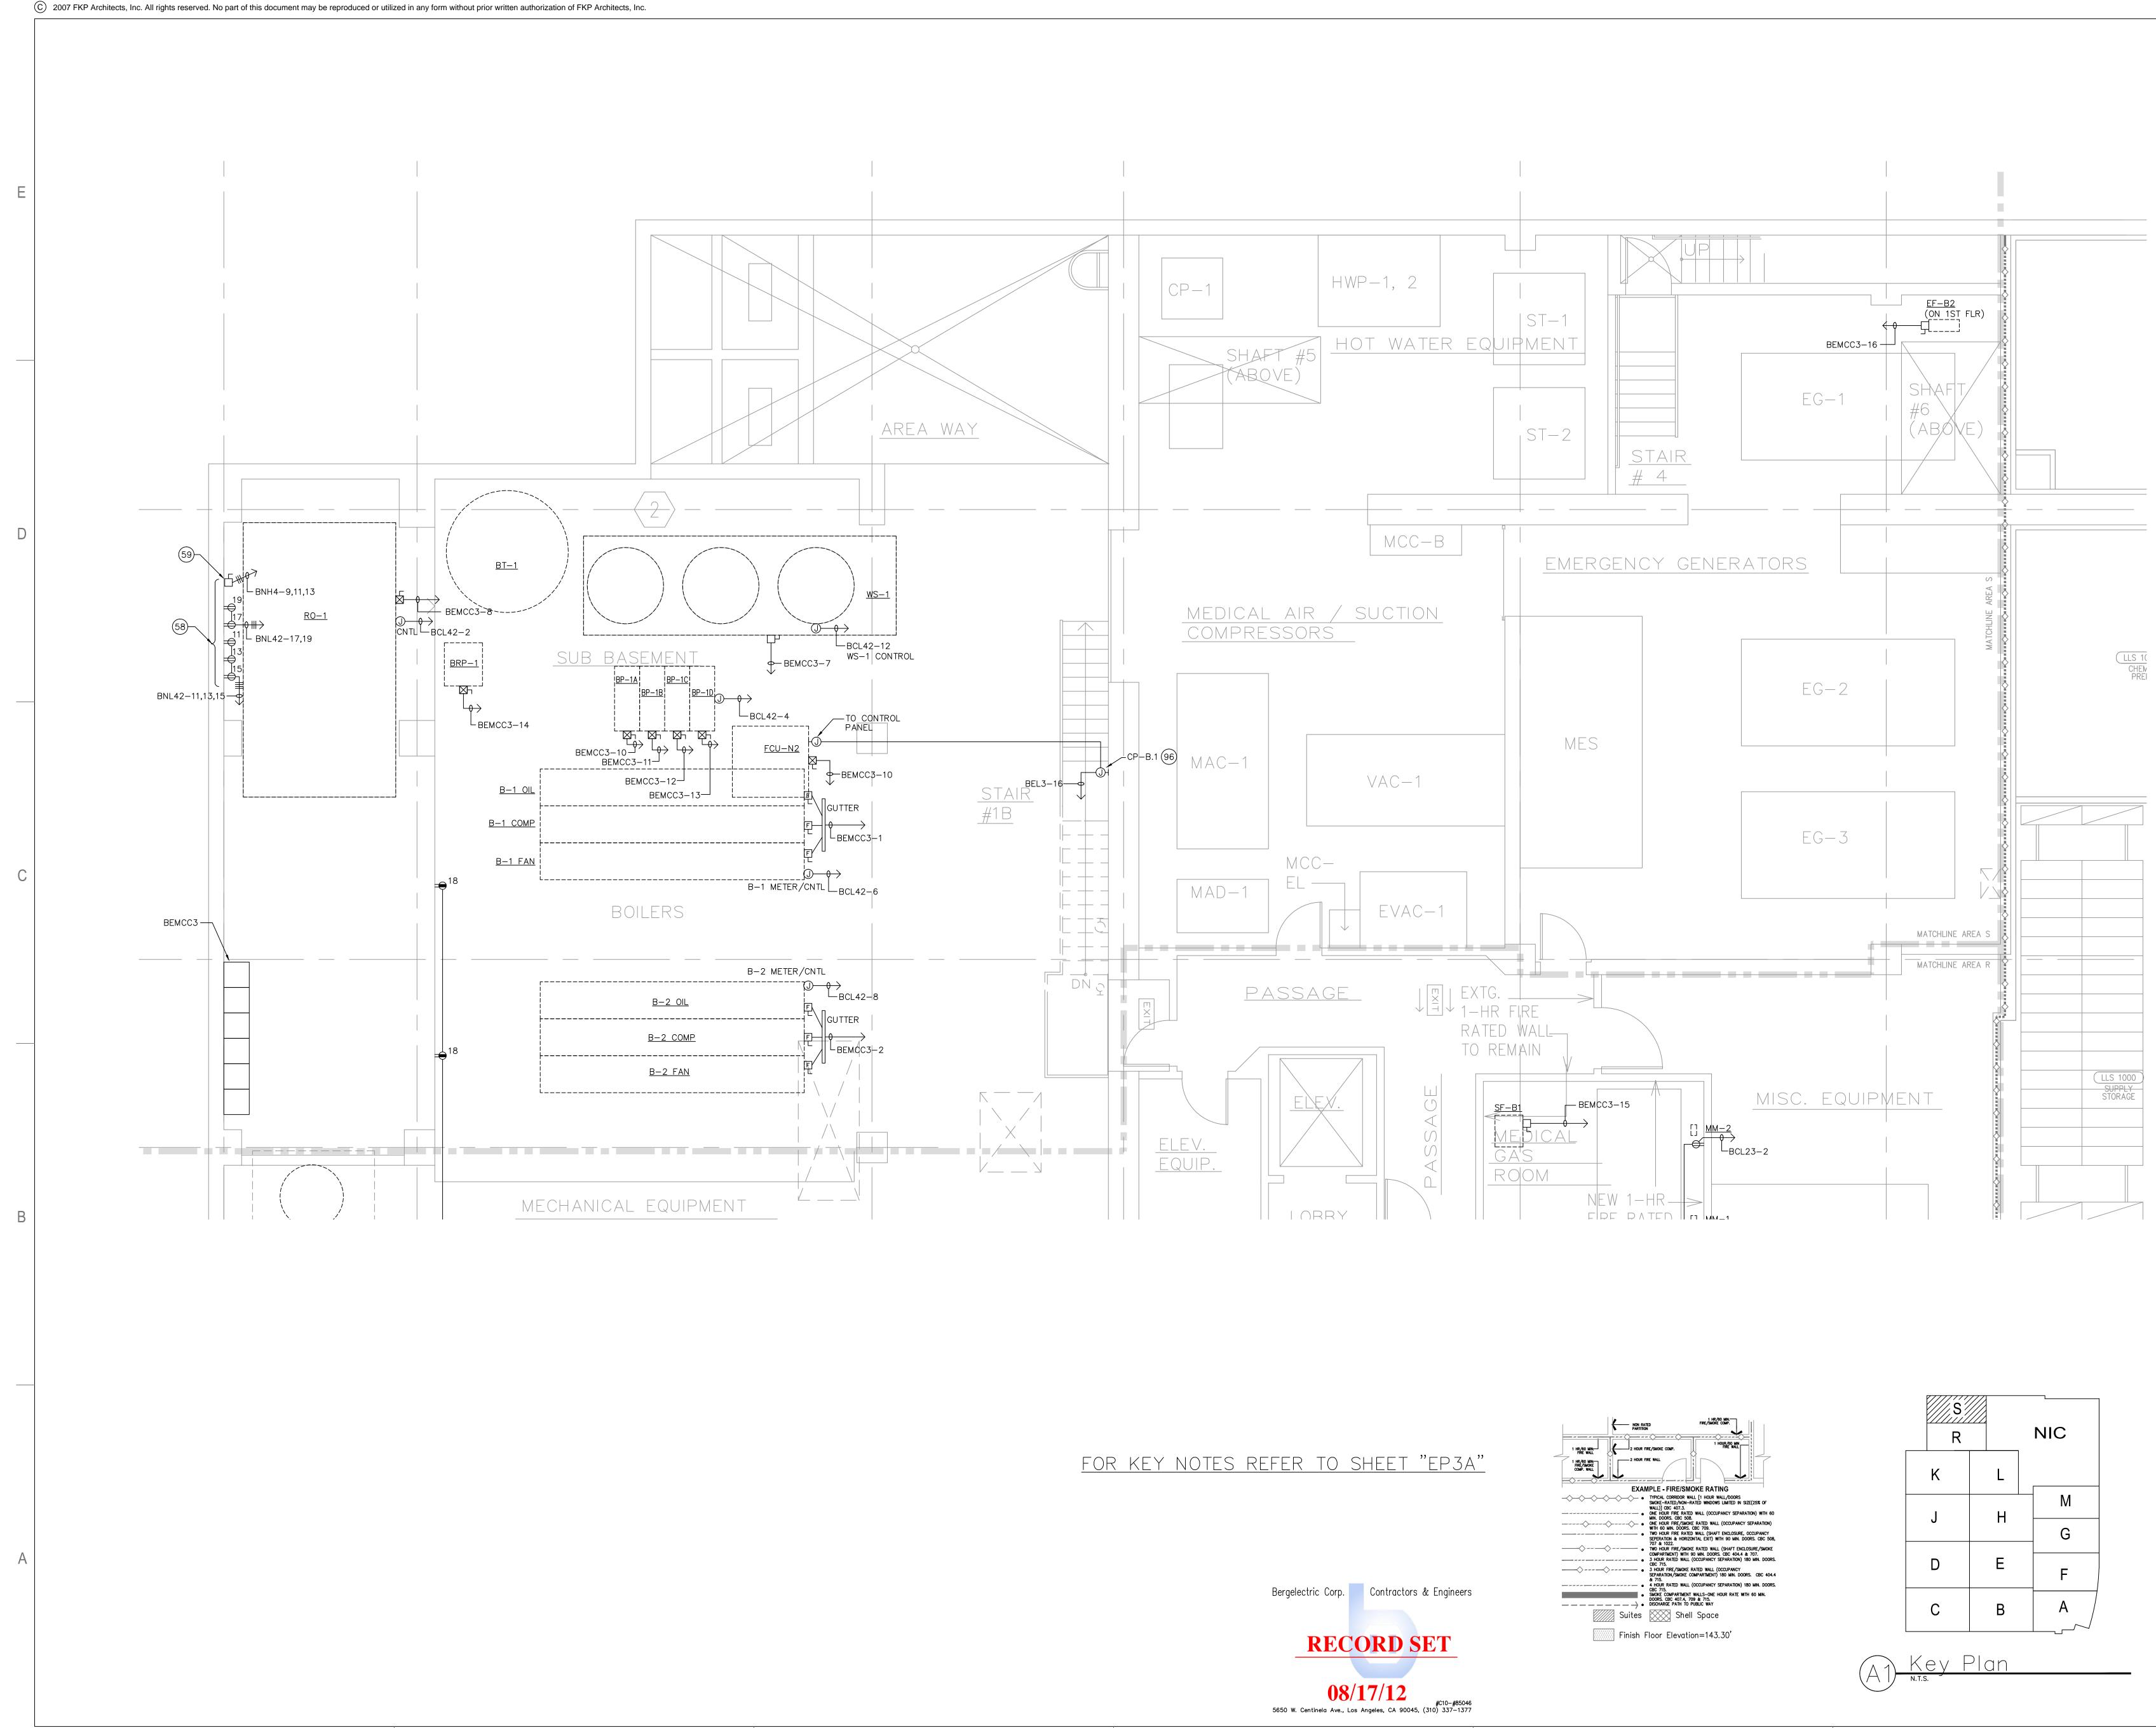

г. үгилици 1 5/17/2012 SSOGHOMON

R		NIC	
K	L		
J	H	M	
		G	
D	E	F	
С	В	A	



DRAWING NUMBER

LOWER LEVEL POWER PLAN AREA - S

IL 072072-30 ISSUE OSHPD PERMIT DATE 01/27/2010 SCALE

1/4"=1'-0"

DRAWING TITLE

PROJECT NUMBER 12011.00 Increment #7 OSHPD - PROJECT NUMBER

ΗΟΣΡΙΤΑΙ

TOWER II

PROJECT NAME CHILDREN'S HOSPITAL OF ORANGE COUNTY 455 S. Main St. Orange, CA 92868-3874

APPROVAL

REVISIONS

*≴*97∖ 12/19/11 CHANGE ORDER #294

ELECTRICALCIVIL 100 South Anaheim Boulevard, Suite 150 Anaheim, California 92805 Phone: 714.490.5555 Fax: 714.490.5560 Project No. 2305-163-07

ГМ А D

TAYLOR

&G AINES

STRUCTURAL

MECHANICAL

ARCHITECT OF RECORD

CONSULTANT