

DEVICE LEGEND

DEVICE	DESCRIPTION	QTY.
CR	CARD READER	3
DC	DOOR CONTACT	4
REX	REQUEST TO EXIT DEVICE W/ DOOR LOCKS	3
EL	ELECTRIFIED LOCK	3
П _р	PANIC BUTTON	0
lacksquare	INTERCOMS	0
	FIXED IP DOME COLOR CAMERA	3
	PTZ IP DOME COLOR CAMERA	0
	ACCESS CONTROL PANEL	0
	CCTV HEAD END LOCATIONS	0
	PENETRATION SLEEVES	0

DRAWING PREPARED BY:

FULLERTON, CALIFORNIA 92831 714-525-4350 - o; 714-525-4386 - f (c) Copyright 2012 KRATOS | HBE All Rights Reserved.


1511 E. ORANGETHORPE BLVD.

MUST BE SIGNED BY HBE TO AUTHENTICATE CONTENT(S). ALL DETAILS CHECKED FOR ACCURACY.

SIGNATURE DATE HBE JOB#

CONFIDENTIAL

THE INFORMATION CONTAINED HERIN MAY NOT BE USED OR REPRODUCED IN ANY MANNER WITHOUT WRITTEN PERMISSION OF KRATOS | HBE.

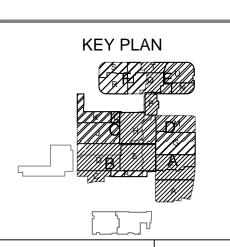

REV DESCRIPTION REV DATE APPROVED BY AS BUILTS 08/15/2012 JOHN J. CHRISTIE

REV. DESCRIPTION APPROVED BY

CHOC CHILDREN'S HOSPITAL 455 SOUTH MAIN ST. ORANGE, CA 92668

DRAWING TITLE:


LEVEL P1 SECURITY PLAN

DRN BY DATE DRN CHK BY DATE CHK

JOSH G. 08/08/2012 JJC

SCALE: NTS

DWG NO. SE3.P1

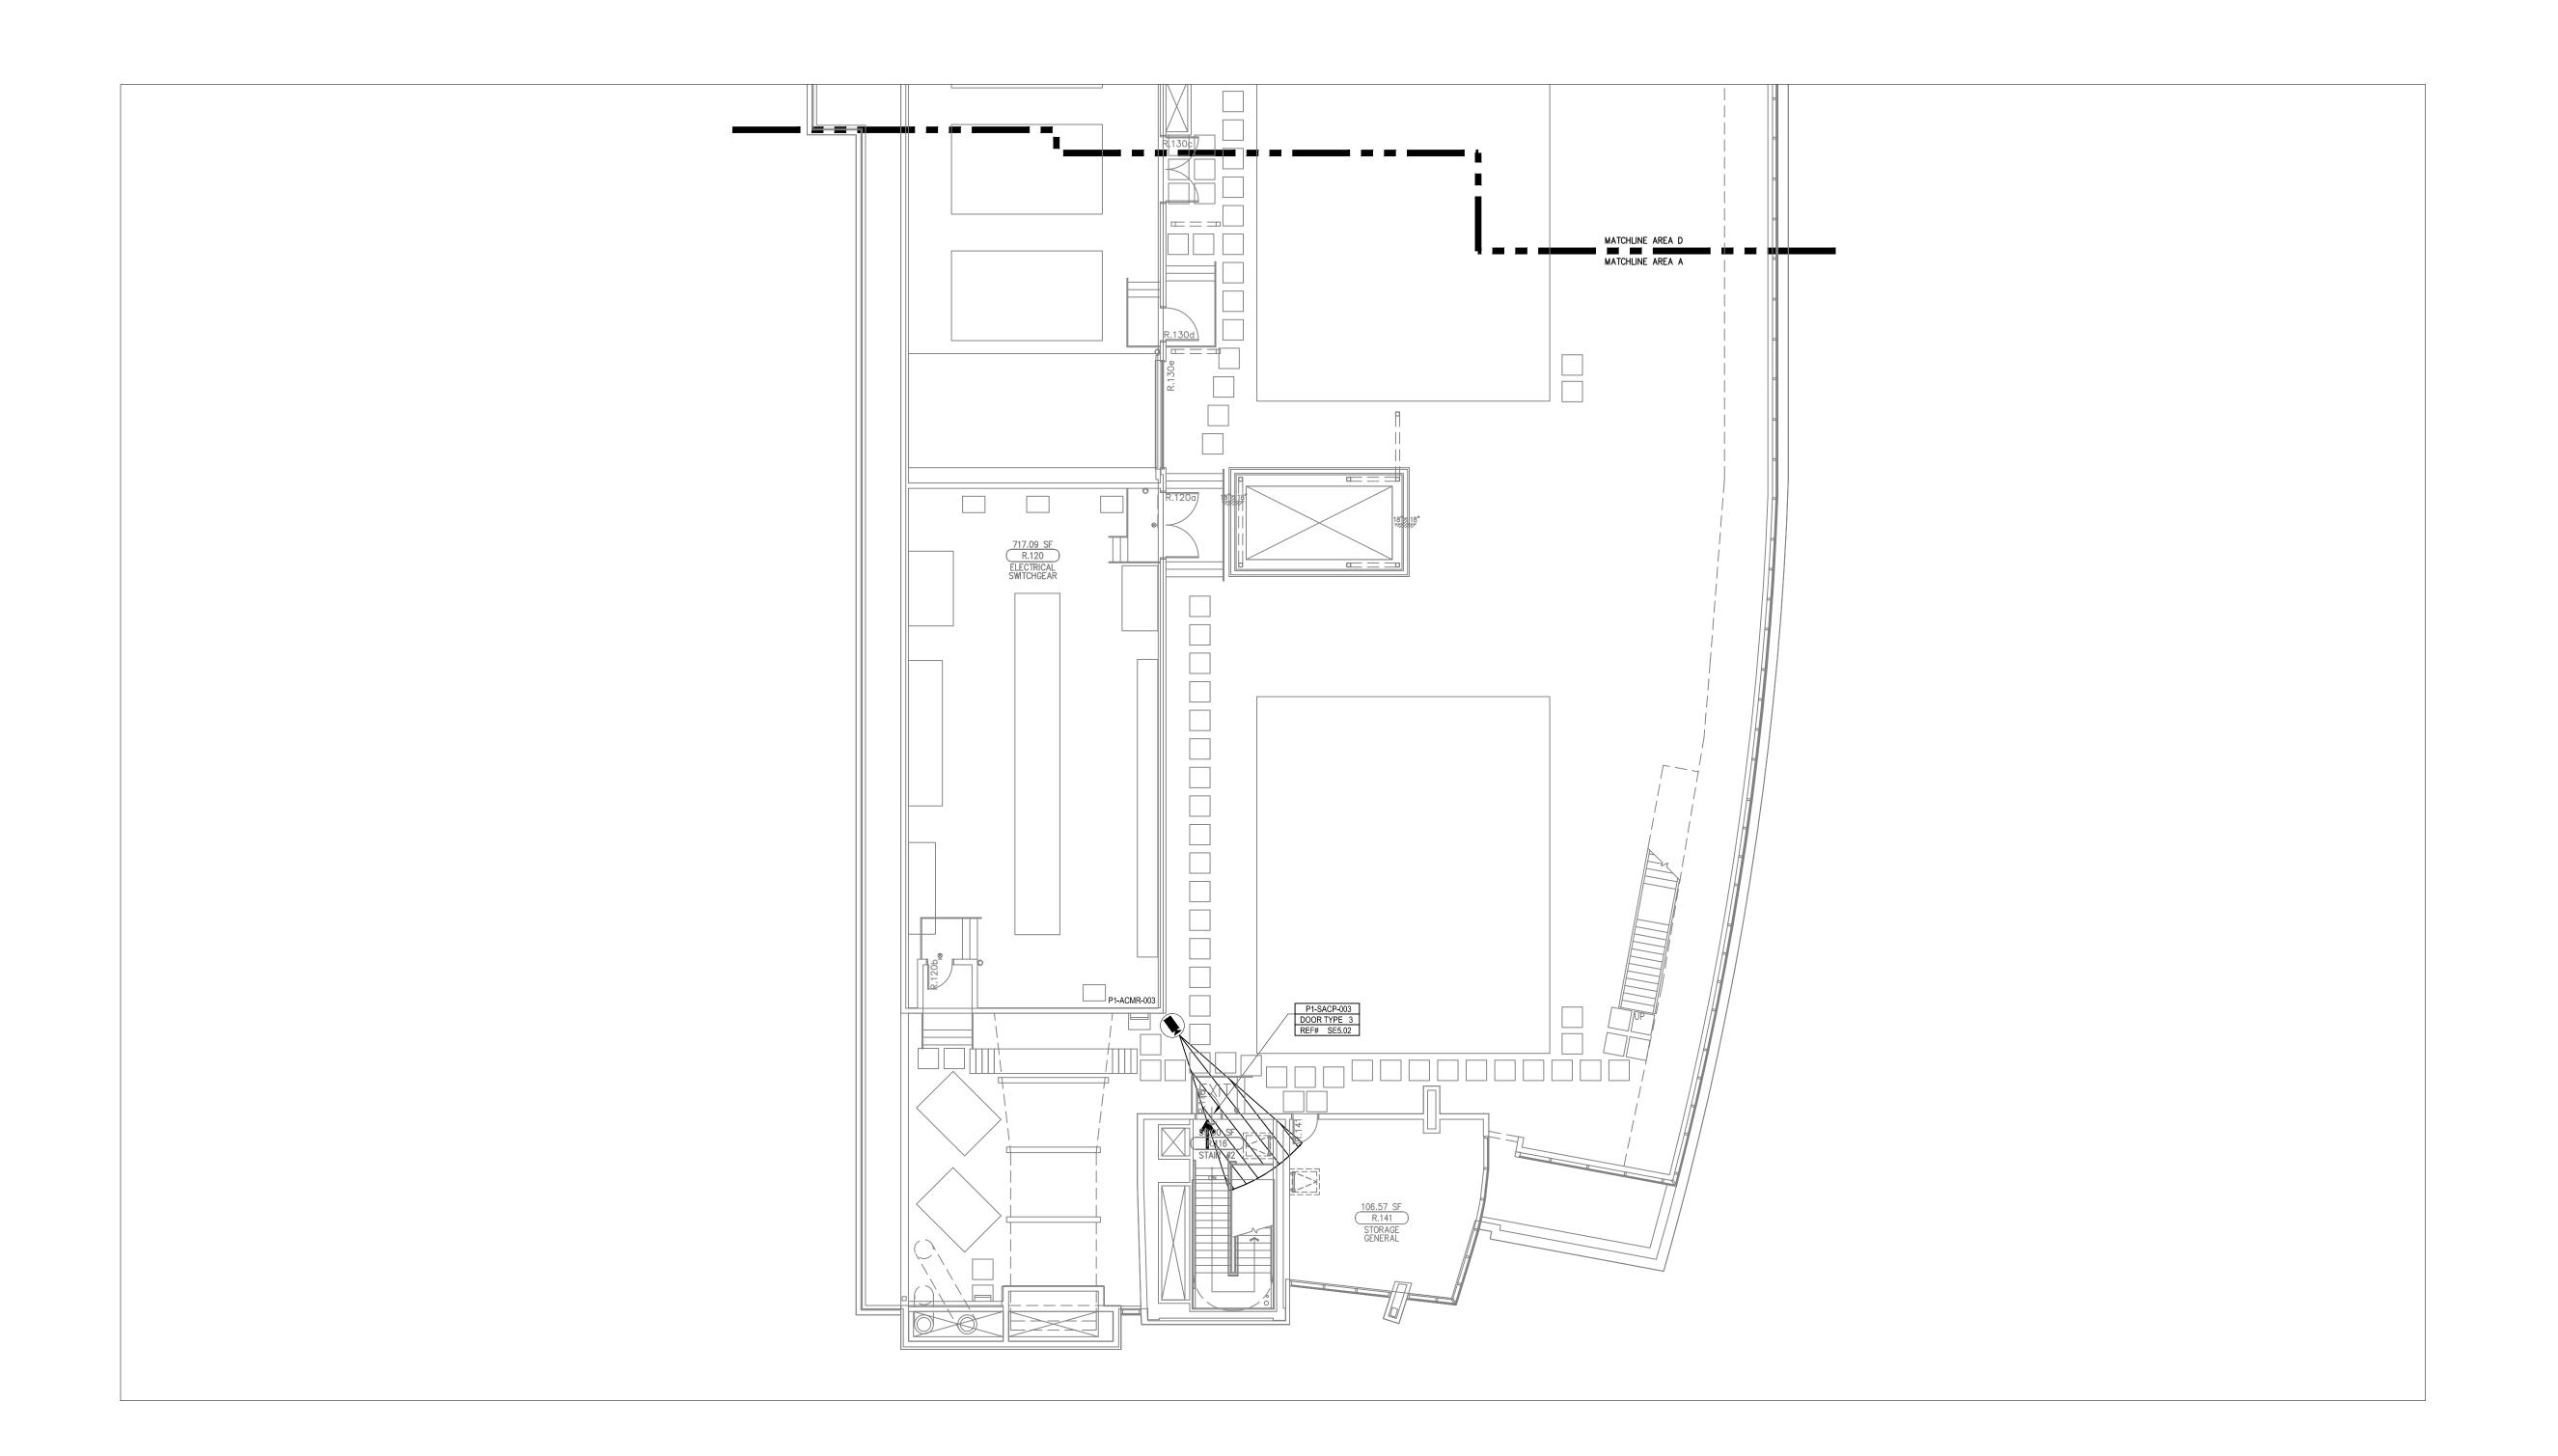

		I
DEVICE	DESCRIPTION	QTY.
CR	CARD READER	1
DC	DOOR CONTACT	1
REX	REQUEST TO EXIT DEVICE W/ DOOR LOCKS	1
EL	ELECTRIFIED LOCK	1
Пp	PANIC BUTTON	0
$\bigoplus_{\mathbb{S}}^{\mathbb{D}}$	INTERCOMS	0
	FIXED IP DOME COLOR CAMERA	1
	PTZ IP DOME COLOR CAMERA	0
	ACCESS CONTROL PANEL	0
	CCTV HEAD END LOCATIONS	0
χ	PENETRATION SLEEVES	0

DEVICE LEGEND

DRAWING PREPARED BY:	
KR TO	
HBE	


1511 E. ORANGETHORPE BLVD. FULLERTON, CALIFORNIA 92831 714-525-4350 - o; 714-525-4386 - f (c) Copyright 2012 KRATOS | HBE All Rights Reserved.

MUST BE SIGNED BY HBE TO AUTHENTICATE CONTENT(S). ALL DETAILS CHECKED FOR ACCURACY.

SIGNATURE DATE HBE JOB#

CONFIDENTIAL

THE INFORMATION CONTAINED HERIN MAY NOT BE USED OR REPRODUCED IN ANY MANNER WITHOUT WRITTEN PERMISSION OF KRATOS | HBE.

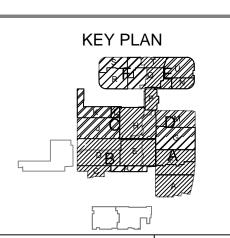

REV DESCRIPTION REV DATE APPROVED BY AS BUILTS 08/15/2012 JOHN J. CHRISTIE

REV. DESCRIPTION APPROVED BY



CHOC CHILDREN'S HOSPITAL 455 SOUTH MAIN ST. ORANGE, CA 92668

DRAWING TITLE:


LEVEL P1 SECURITY PLAN AREA A

DRN BY DATE DRN CHK BY DATE CHK

JOSH G. 08/08/2012 JJC

SCALE: NTS

DWG NO. SE3.P1A

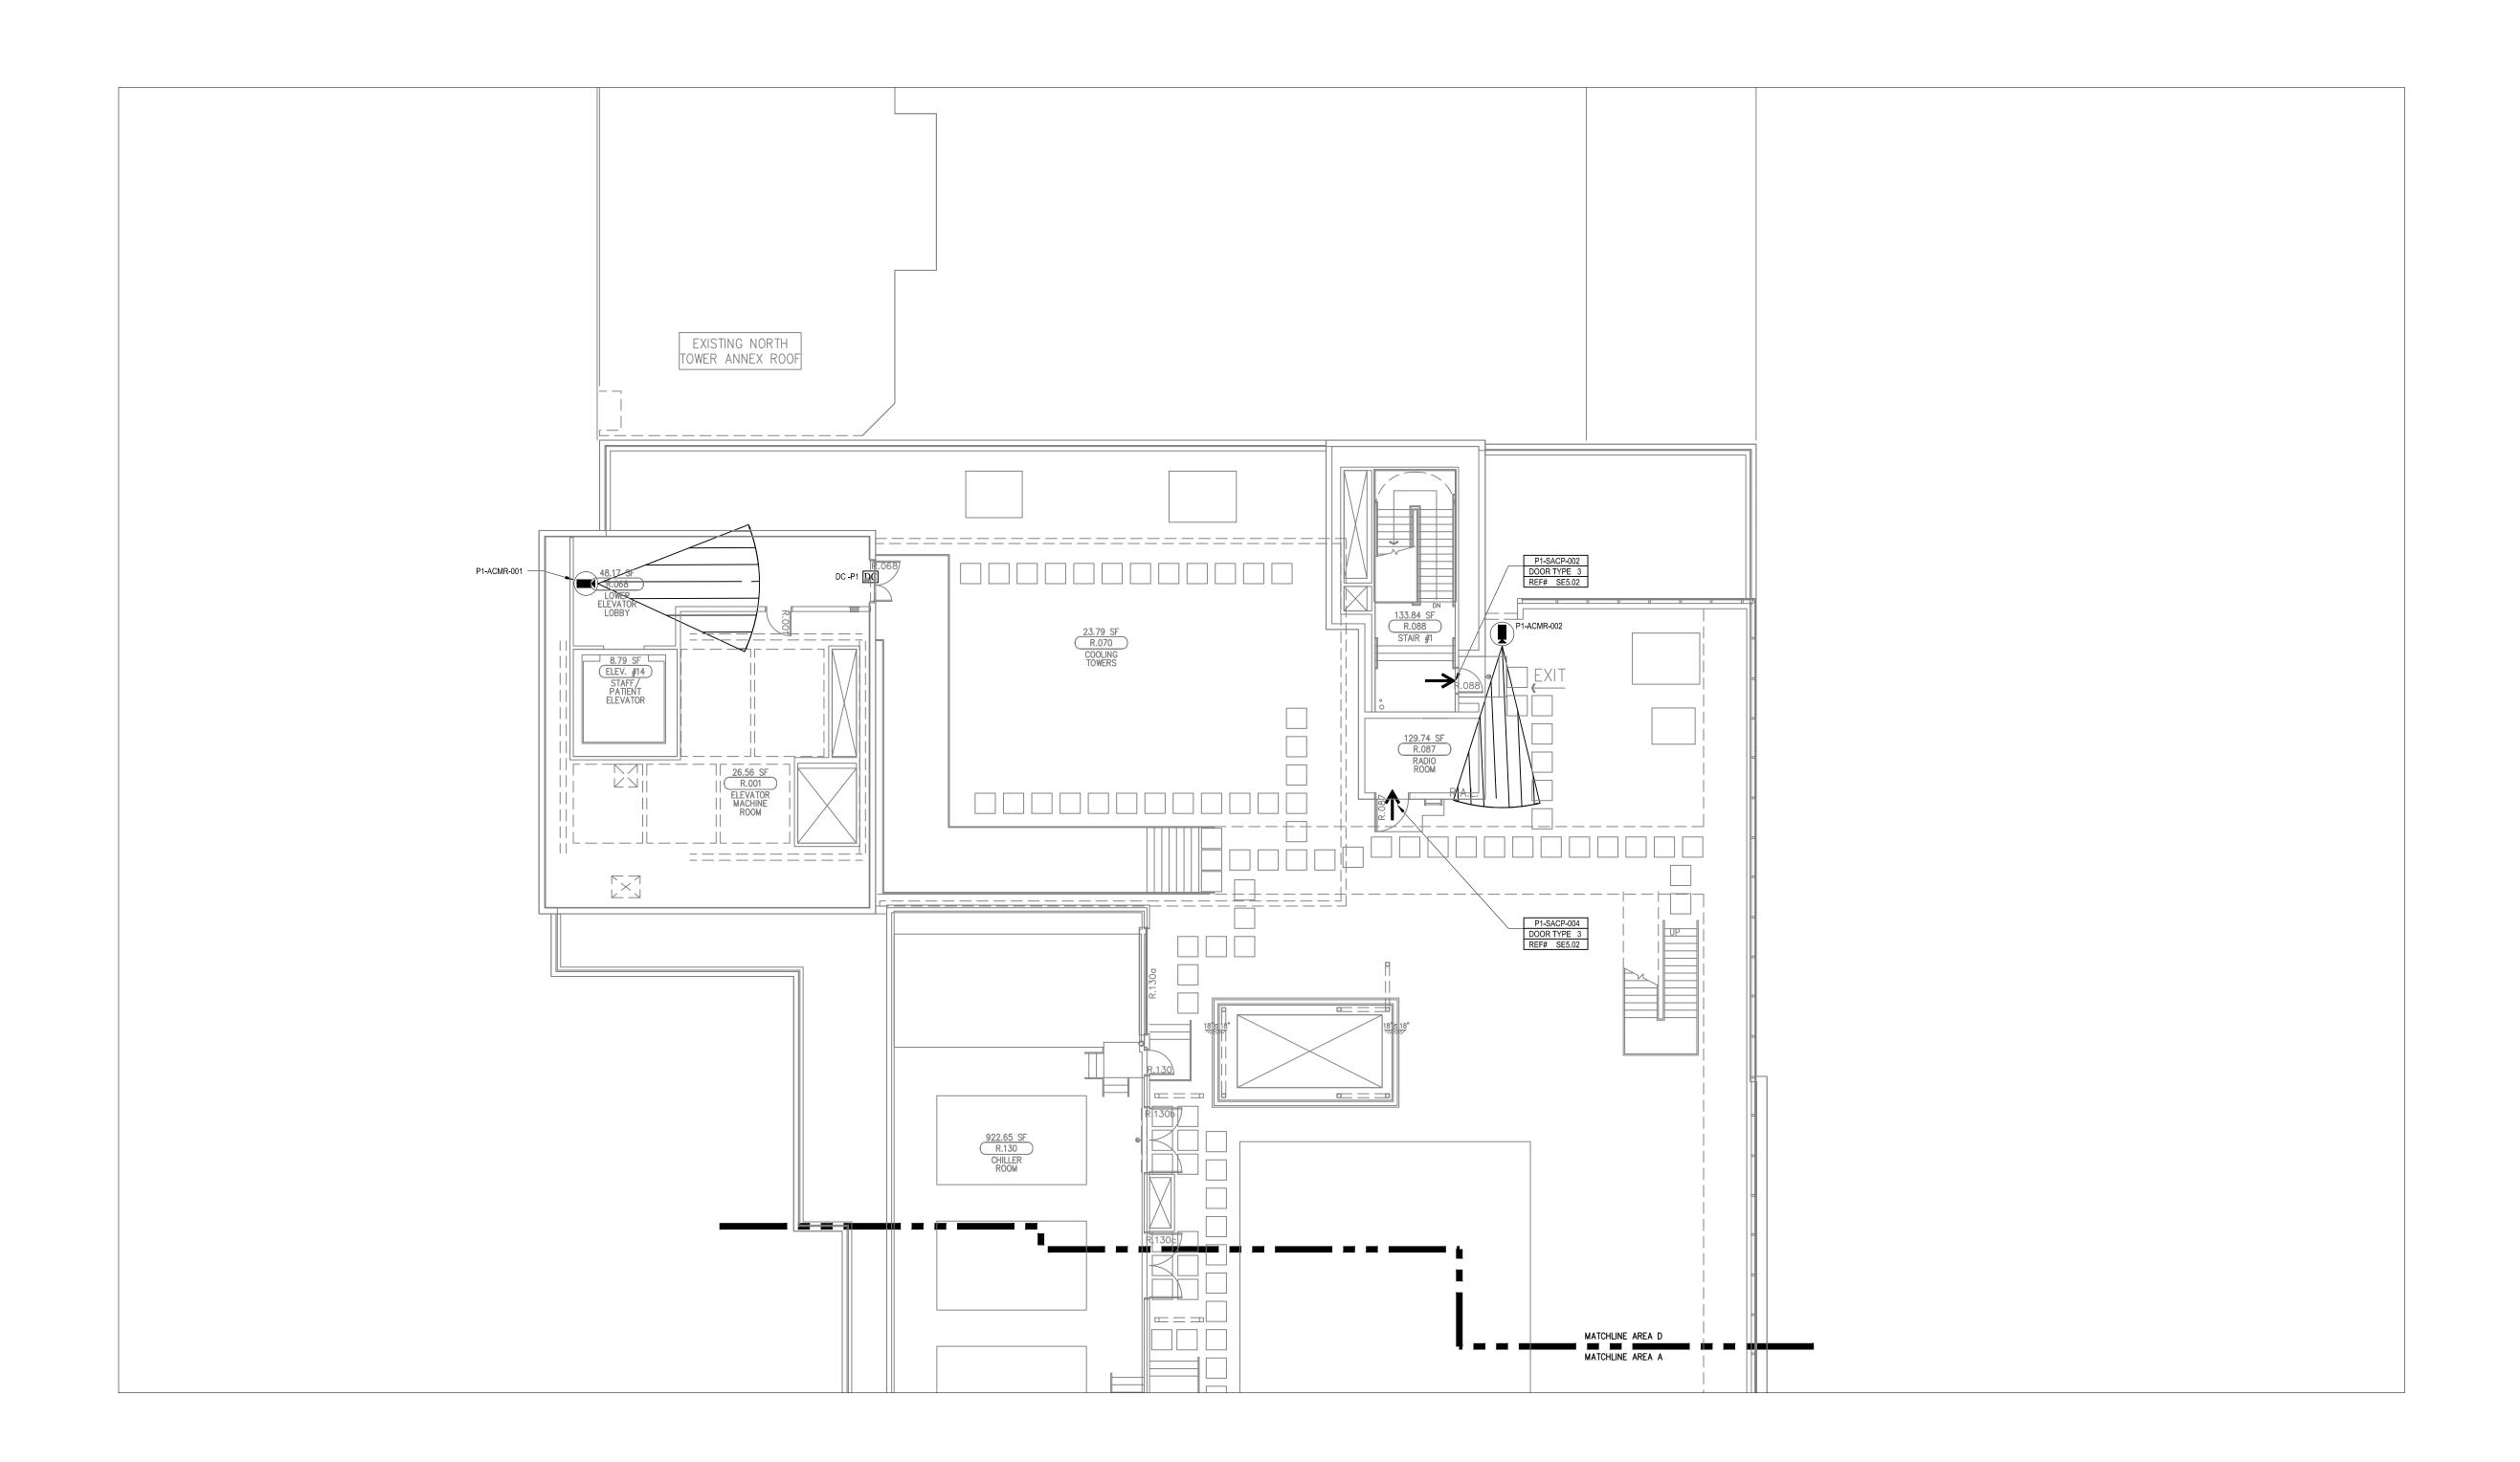

DEVICE	DESCRIPTION	QTY.
CR	CARD READER	2
DC	DOOR CONTACT	4
REX	REQUEST TO EXIT DEVICE W/ DOOR LOCKS	2
EL	ELECTRIFIED LOCK	2
П _Р	PANIC BUTTON	0
\bigoplus_{s}^{D}	INTERCOMS	0
	FIXED IP DOME COLOR CAMERA	2
	PTZ IP DOME COLOR CAMERA	0
	ACCESS CONTROL PANEL	0
	CCTV HEAD END LOCATIONS	0
\asymp	PENETRATION SLEEVES	0

DEVICE LEGEND

DRAWING PREPARED BY:
KRATAS
KUNKIOS
HRE


1511 E. ORANGETHORPE BLVD. FULLERTON, CALIFORNIA 92831 714-525-4350 - o; 714-525-4386 - f (c) Copyright 2012 KRATOS | HBE All Rights Reserved.

MUST BE SIGNED BY HBE TO AUTHENTICATE CONTENT(S). ALL DETAILS CHECKED FOR ACCURACY.

SIGNATURE DATE HBE JOB#

CONFIDENTIAL

THE INFORMATION CONTAINED HERIN MAY NOT BE USED OR REPRODUCED IN ANY MANNER WITHOUT WRITTEN PERMISSION OF KRATOS | HBE.

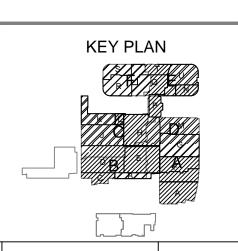

REV DESCRIPTION REV DATE APPROVED BY AS BUILTS 08/15/2012 JOHN J. CHRISTIE

REV. DESCRIPTION APPROVED BY

CHOC CHILDREN'S HOSPITAL 455 SOUTH MAIN ST. ORANGE, CA 92668

DRAWING TITLE:

LEVEL P1 SECURITY PLAN AREA D

DRN BY DATE DRN CHK BY DATE CHK

JOSH G. 08/08/2012 JJC

SCALE: NTS

DWG NO. SE3.P1D