



DRAWING INDEX

SE 7.08	POINT TO POINT ROOM #3.106.13
SE 7.09	POINT TO POINT ROOM #3.064
SE 7.10	POINT TO POINT ROOM #5.123
SE 7.11	POINT TO POINT ROOM #5.101
SE 7.12	POINT TO POINT ROOM #6.121
SE 7.13	POINT TO POINT ROOM #7.103.02



SE 3.3	LEVEL 3 SECURITY PLAN
SE 3.3A	LEVEL 3 SECURITY PLAN AREA - A
SE 3.3B	LEVEL 3 SECURITY PLAN AREA - B
SE 3.3D	LEVEL 3 SECURITY PLAN AREA - D
SE 3.3E	LEVEL 3 SECURITY PLAN AREA - E
SE 3.3F	LEVEL 3 SECURITY PLAN AREA - F
SE 3.3G	LEVEL 3 SECURITY PLAN AREA - G
SE 3.3H	LEVEL 3 SECURITY PLAN AREA - H
SE 3.3J	LEVEL 3 SECURITY PLAN AREA - J
SE 3.3K	LEVEL 3 SECURITY PLAN AREA - K
SE 3.3L	LEVEL 3 SECURITY PLAN AREA - L
SE 3.3M	LEVEL 3 SECURITY PLAN AREA - M
SE 3.5	LEVEL 5 SECURITY PLAN
SE 3.5A	LEVEL 5 SECURITY PLAN AREA - A
SE 3.5D	LEVEL 5 SECURITY PLAN AREA - D
SE 3.5F	LEVEL 5 SECURITY PLAN AREA - F
SE 3.5G	LEVEL 5 SECURITY PLAN AREA - G
SE 3.5H	LEVEL 5 SECURITY PLAN AREA - H
SE 3.5M	LEVEL 5 SECURITY PLAN AREA - M
SE 3.5P	LEVEL 5 SECURITY PLAN AREA - P


SE 4.09	CCTV POINT TO POINT ROOM #3.064
SE 4.10	CCTV POINT TO POINT ROOM #5.123
SE 4.11	CCTV POINT TO POINT ROOM #5.101
SE 4.12	CCTV POINT TO POINT ROOM #6.121
SE 4.13	CCTV POINT TO POINT ROOM #6.103.02
SE 4.14	CCTV POINT TO POINT ROOM #7.121.01
SE 4.15	CCTV POINT TO POINT ROOM #7.103.02
SE 4.16	CCTV LOAD SCHEDULE
SE 5.01	SECURITY SYSTEM DOOR DETAILS
SE 5.02	SECURITY SYSTEM DOOR DETAILS
SE 5.03	SECURITY SYSTEM DOOR DETAILS
SE 5.04	SECURITY SYSTEM CAMERA DETAILS
SE 6.06	CCTV RISER DIAGRAM
SE 6.07	ACCESS RISER DIAGRAM
SE 7.00	POINT TO POINT ROOM #B62
SE 7.01	POINT TO POINT ROOM #B28
SE 7.02	POINT TO POINT ROOM #1.067
SE 7.03	POINT TO POINT ROOM #1.067
SE 7.04	POINT TO POINT ROOM #1.016
SE 7.05	POINT TO POINT ROOM #2.02
SE 7.06	POINT TO POINT ROOM #2.066
SE 7.07	POINT TO POINT ROOM #3.022

SECURITY DEVICE LEGEND		
DEVICE	DESCRIPTION	TOTAL QTY NEW
	CARD READER	199
	DOOR CONTACT	243
	REQUEST TO EXIT DEVICE W/ DOOR LOCKS	199
	ELECTRIFIED LOCK	BY OTHERS
	PANIC BUTTON	58
	FIXED DOME COLOR CAMERA	124
	PTZ DOME COLOR CAMERA	13
	ACCESS CONTROL PANEL	19
	HEADEND LOCATIONS CCTV PANEL LOCATIONS	3
	JUNCTION BOX	19

CABLE TYPE LEGEND (PLENUM)			
SYMBOL	CABLE USE DESCRIPTION	PART #	CABLE TYPE
A	CAMERA/ LOCK POWER	113003	2 Cond., 16 AWG
B	COMM / PTZ SIGNAL	110060	2 Pair, 24 AWG, Overall Sh.
C	NOT USED		
D	REX / DOOR CONTACT	110206	4 Cond., 22 AWG, Un-Sh.
E	NOT USED		
F	COAX FOR VIDEO	221106	RG59U
H	CARD READER	112150	6 Cond., 18 AWG. Overall Sh.

ASBUILTS
09/26/2012

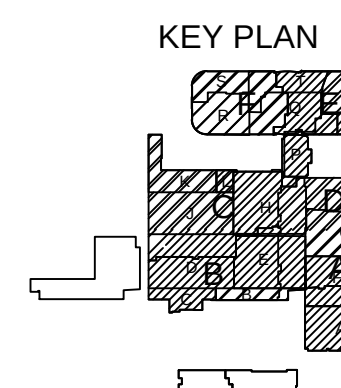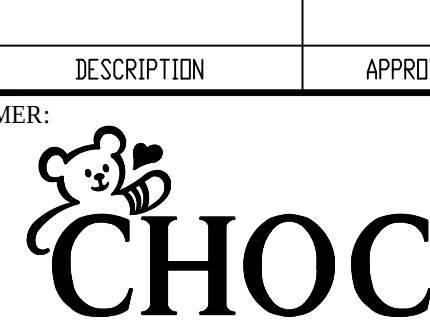DRAWING PREPARED BY:			
			
1511 E. ORANGETHORPE BLVD. FULLERTON, CALIFORNIA 92831 714-525-4350 - o; 714-525-4386 - f (c) Copyright 2012 KRATOS HBE All Rights Reserved.			
MUST BE SIGNED BY HBE TO AUTHENTICATE CONTENT(S). ALL DETAILS CHECKED FOR ACCURACY.			
SIGNATURE _____		DATE _____	
HBE JOB # _____			
CONFIDENTIAL THE INFORMATION CONTAINED HERIN MAY NOT BE USED OR REPRODUCED IN ANY MANNER WITHOUT WRITTEN PERMISSION OF KRATOS HBE.			
KEY PLAN 			
NO.	REV DESCRIPTION REV DATE	APPROVED BY	
1.	AS BUILTS 09/24/2012	JOHN J. CHRISTIE	
	CHANGE ORDER #376	JOHN J. CHRISTIE	
REV.	DESCRIPTION	APPROVED BY	
CUSTOMER:			
			
PROJECT:			
CHOC CHILDREN'S HOSPITAL 455 SOUTH MAIN ST. ORANGE, CA 92668			
DRAWING TITLE:			
SECURITY TITLE PAGE			
DRN BY	DATE DRN	CHK BY	DATE CHK
JOSH G.	08/08/2012	JJC	
SCALE:		NTS	
DWG NO.	SE0.00		

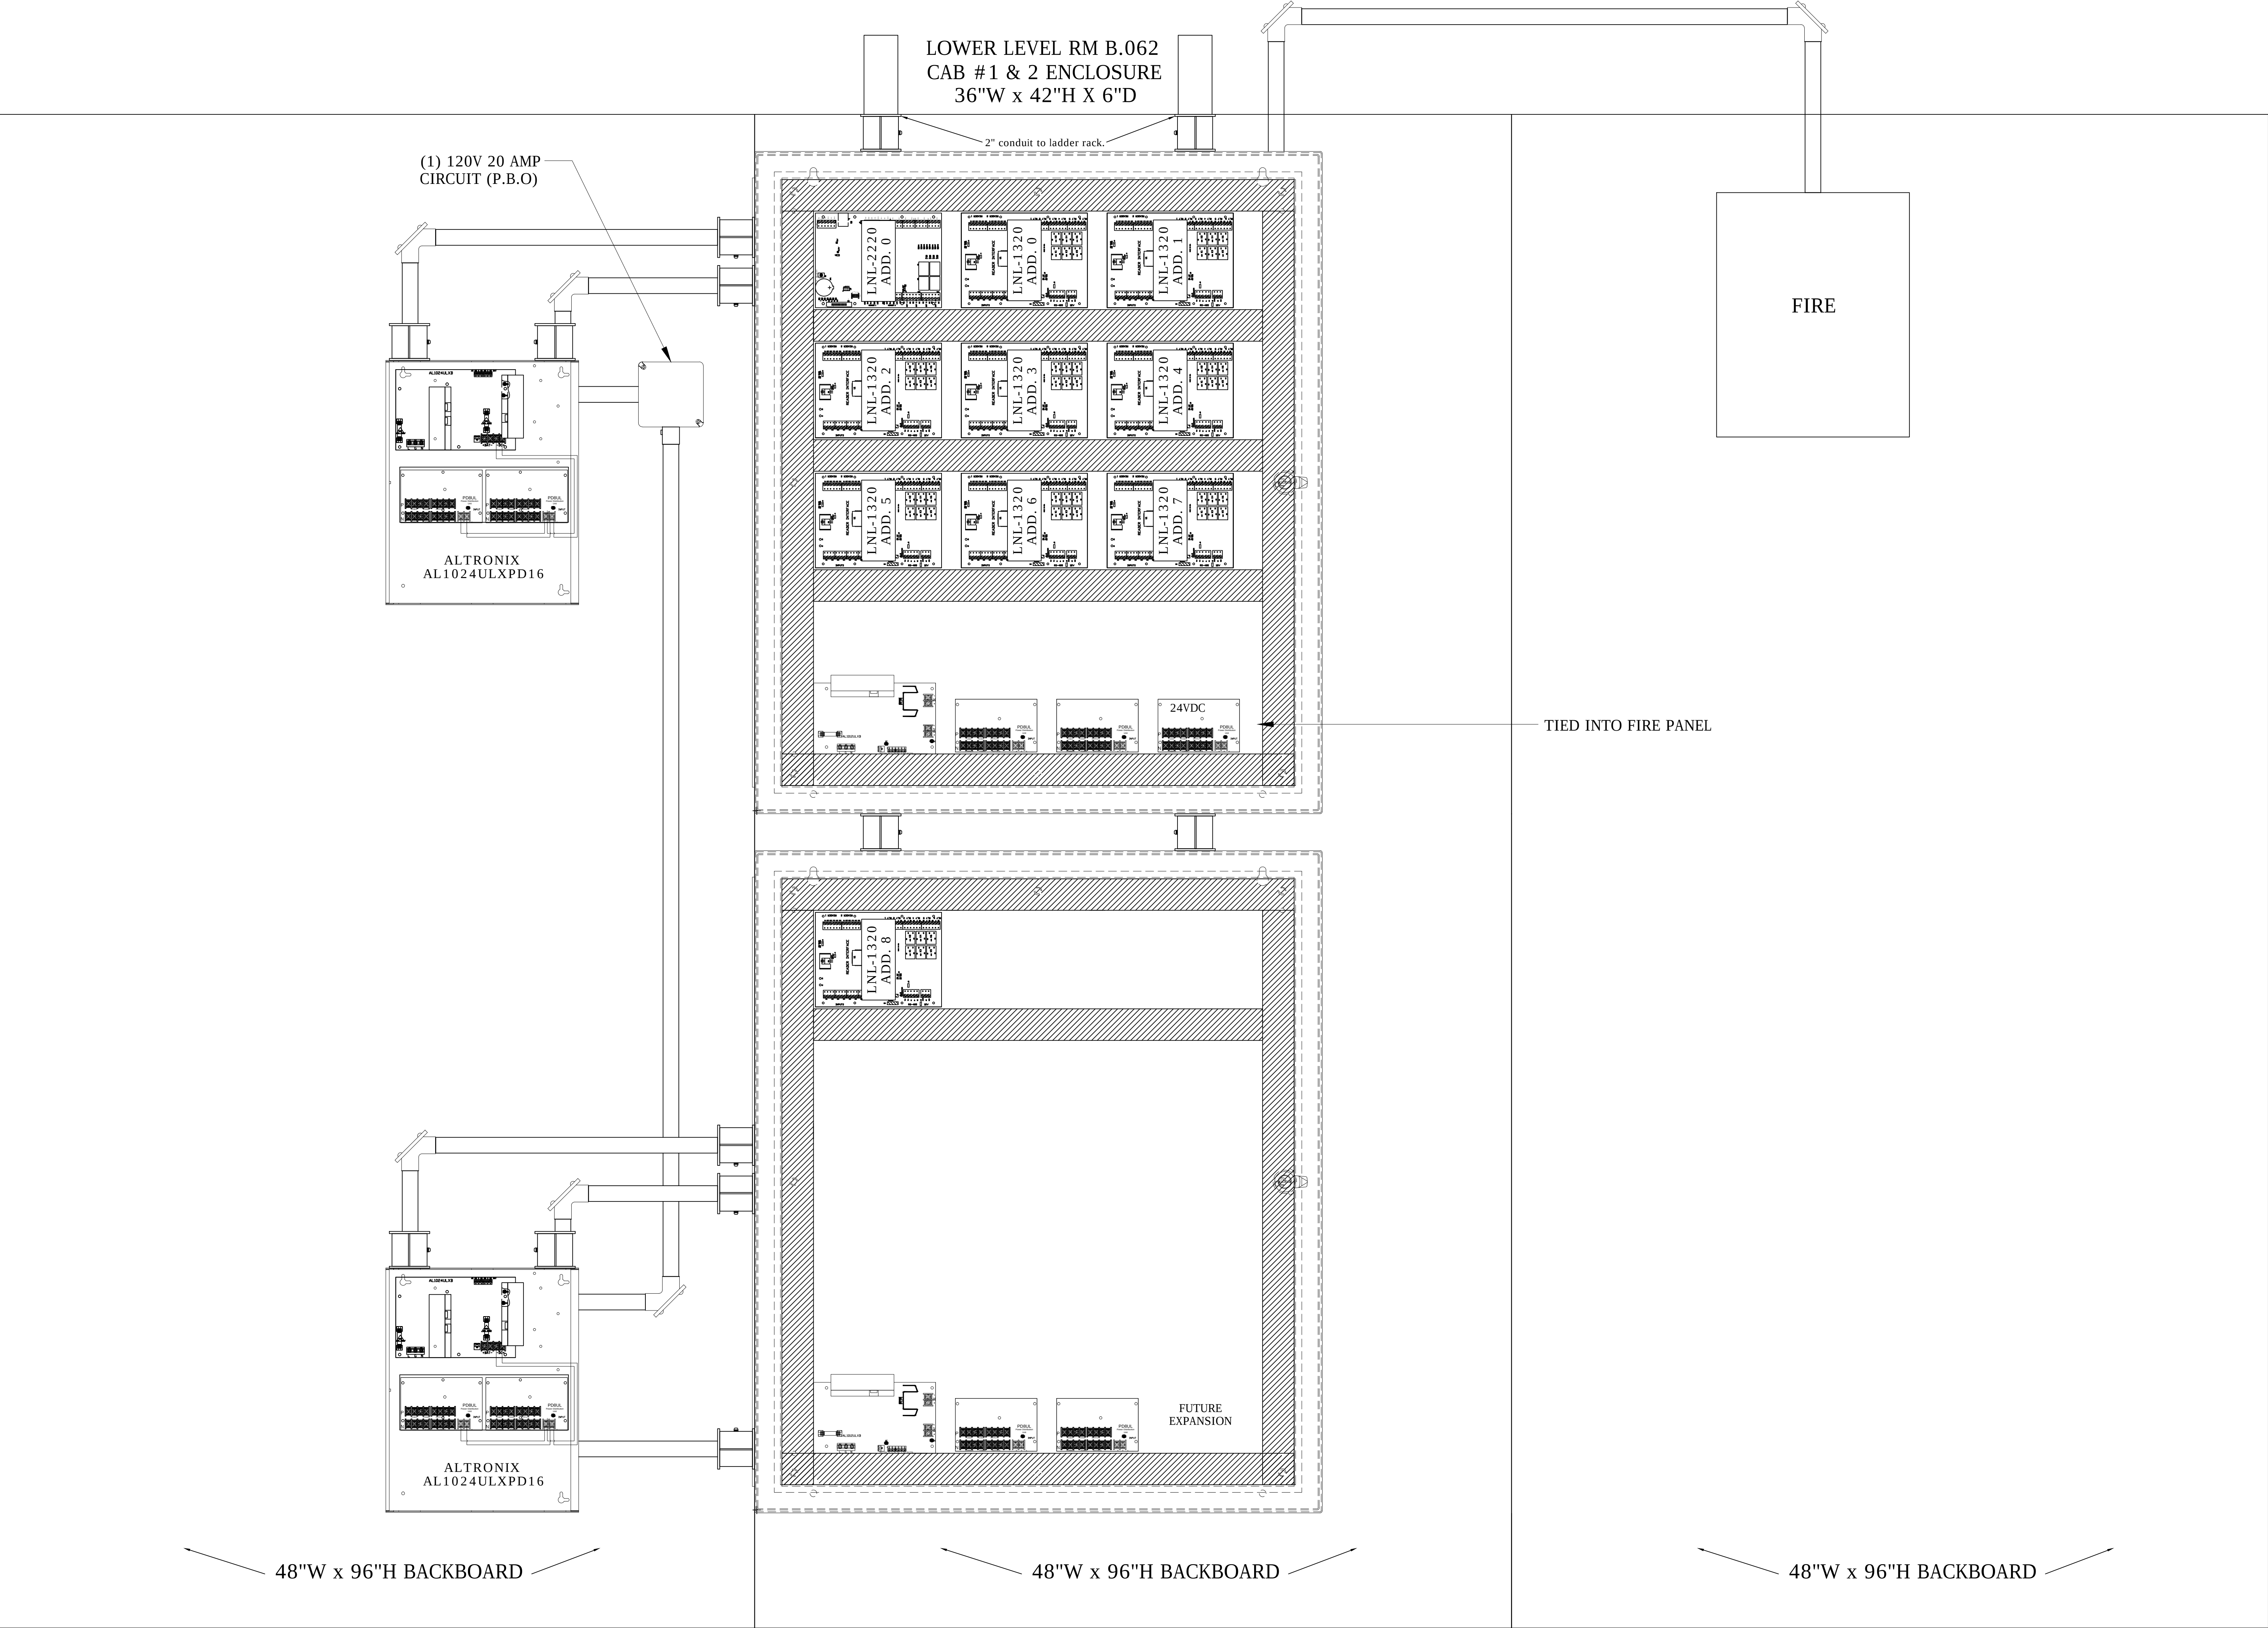

DRAWING PREPARED BY:



1511 E. ORANGETHORPE BLVD.
FULLERTON, CALIFORNIA 92831
714-525-4350 - o; 714-525-4386 - f
(c) Copyright 2012 KRATOS | HBE
All Rights Reserved.

MUST BE SIGNED BY HBE
TO AUTHENTICATE CONTENT(S).
ALL DETAILS CHECKED FOR ACCURACY.


SIGNATURE _____ DATE _____

HBE JOB #

CONFIDENTIAL

THE INFORMATION CONTAINED HEREIN MAY
NOT BE USED OR REPRODUCED IN ANY
MANNER WITHOUT WRITTEN PERMISSION OF
KRATOS | HBE.

KEY PLAN

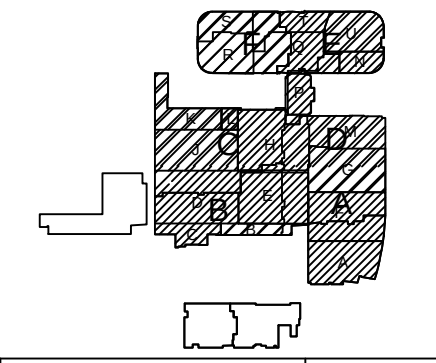

NO.	REV DESCRIPTION REV DATE	APPROVED BY
1.	AS BUILTS 08/15/2012	JOHN J. CHRISTIE

REV. DESCRIPTION APPROVED BY

CUSTOMER:



PROJECT:
CHOC CHILDREN'S
HOSPITAL
455 SOUTH MAIN ST.
ORANGE, CA 92668

DRAWING TITLE:
LOWER LEVEL ACCESS
CONTROL PANEL
LAYOUT RM B.062

DRN BY	DATE DRN	CHK BY	DATE CHK
JOSH G.	08/08/2012	JJC	
SCALE:	NTS		
DWG NO.	SE2.00		

ASBUILTS
08/15/2012

DRAWING PREPARED BY:



1511 E. ORANGETHORPE BLVD.
FULLERTON, CALIFORNIA 92831
714-525-4350 - o; 714-525-4386 - f
(c) Copyright 2012 KRATOS | HBE
All Rights Reserved.

MUST BE SIGNED BY HBE
TO AUTHENTICATE CONTENT(S).
ALL DETAILS CHECKED FOR ACCURACY.


SIGNATURE _____ DATE _____

HBE JOB # _____

CONFIDENTIAL

THE INFORMATION CONTAINED HEREIN MAY
NOT BE USED OR REPRODUCED IN ANY
MANNER WITHOUT WRITTEN PERMISSION OF
KRATOS | HBE.

KEY PLAN

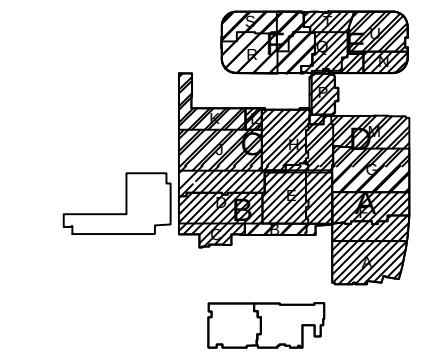

NO.	REV DESCRIPTION REV DATE	APPROVED BY
1.	AS BUILTS 08/15/2012	JOHN J. CHRISTIE

REV.	DESCRIPTION	APPROVED BY
------	-------------	-------------

CUSTOMER:




PROJECT:

CHOC CHILDREN'S
HOSPITAL
455 SOUTH MAIN ST.
ORANGE, CA 92668


DRAWING TITLE:

LOWER LEVEL ACCESS
CONTROL PANEL
LAYOUT RM B.028

DRN BY	DATE DRN	CHK BY	DATE CHK
JOSH G.	08/08/2012	JJC	
SCALE:	NTS		
DWG NO.	SE2.01		

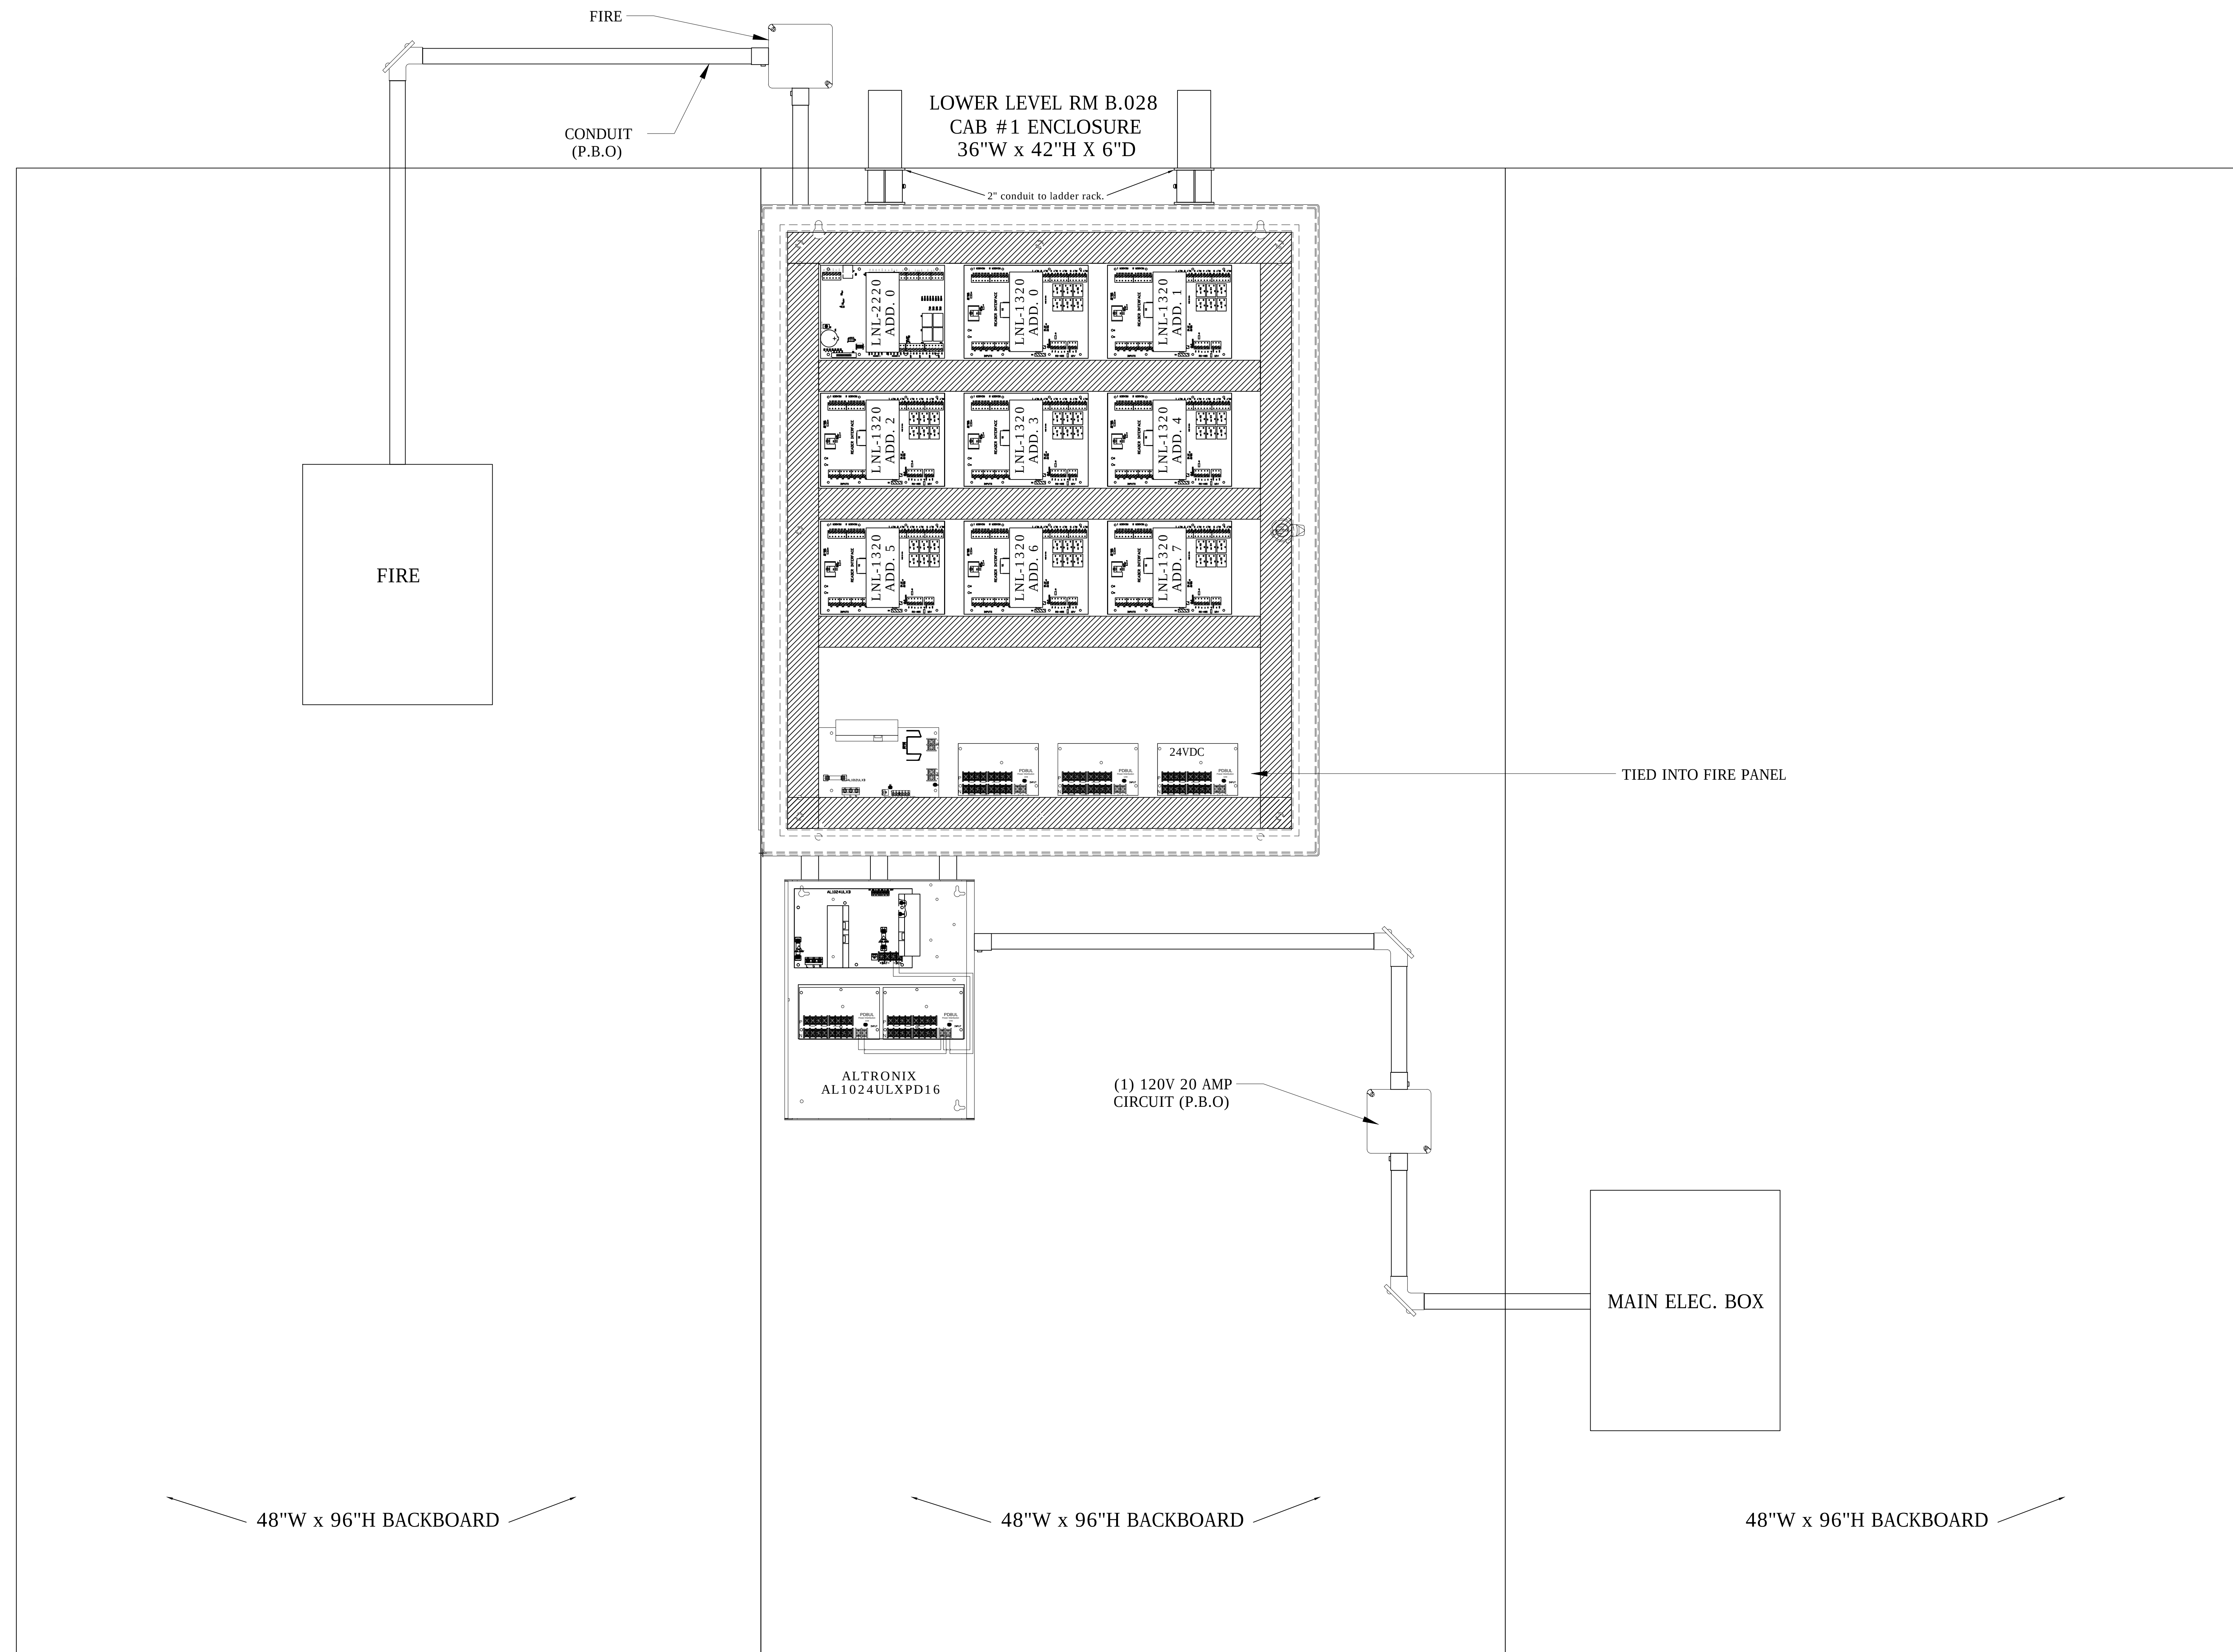

ASBUILTS
08/15/2012

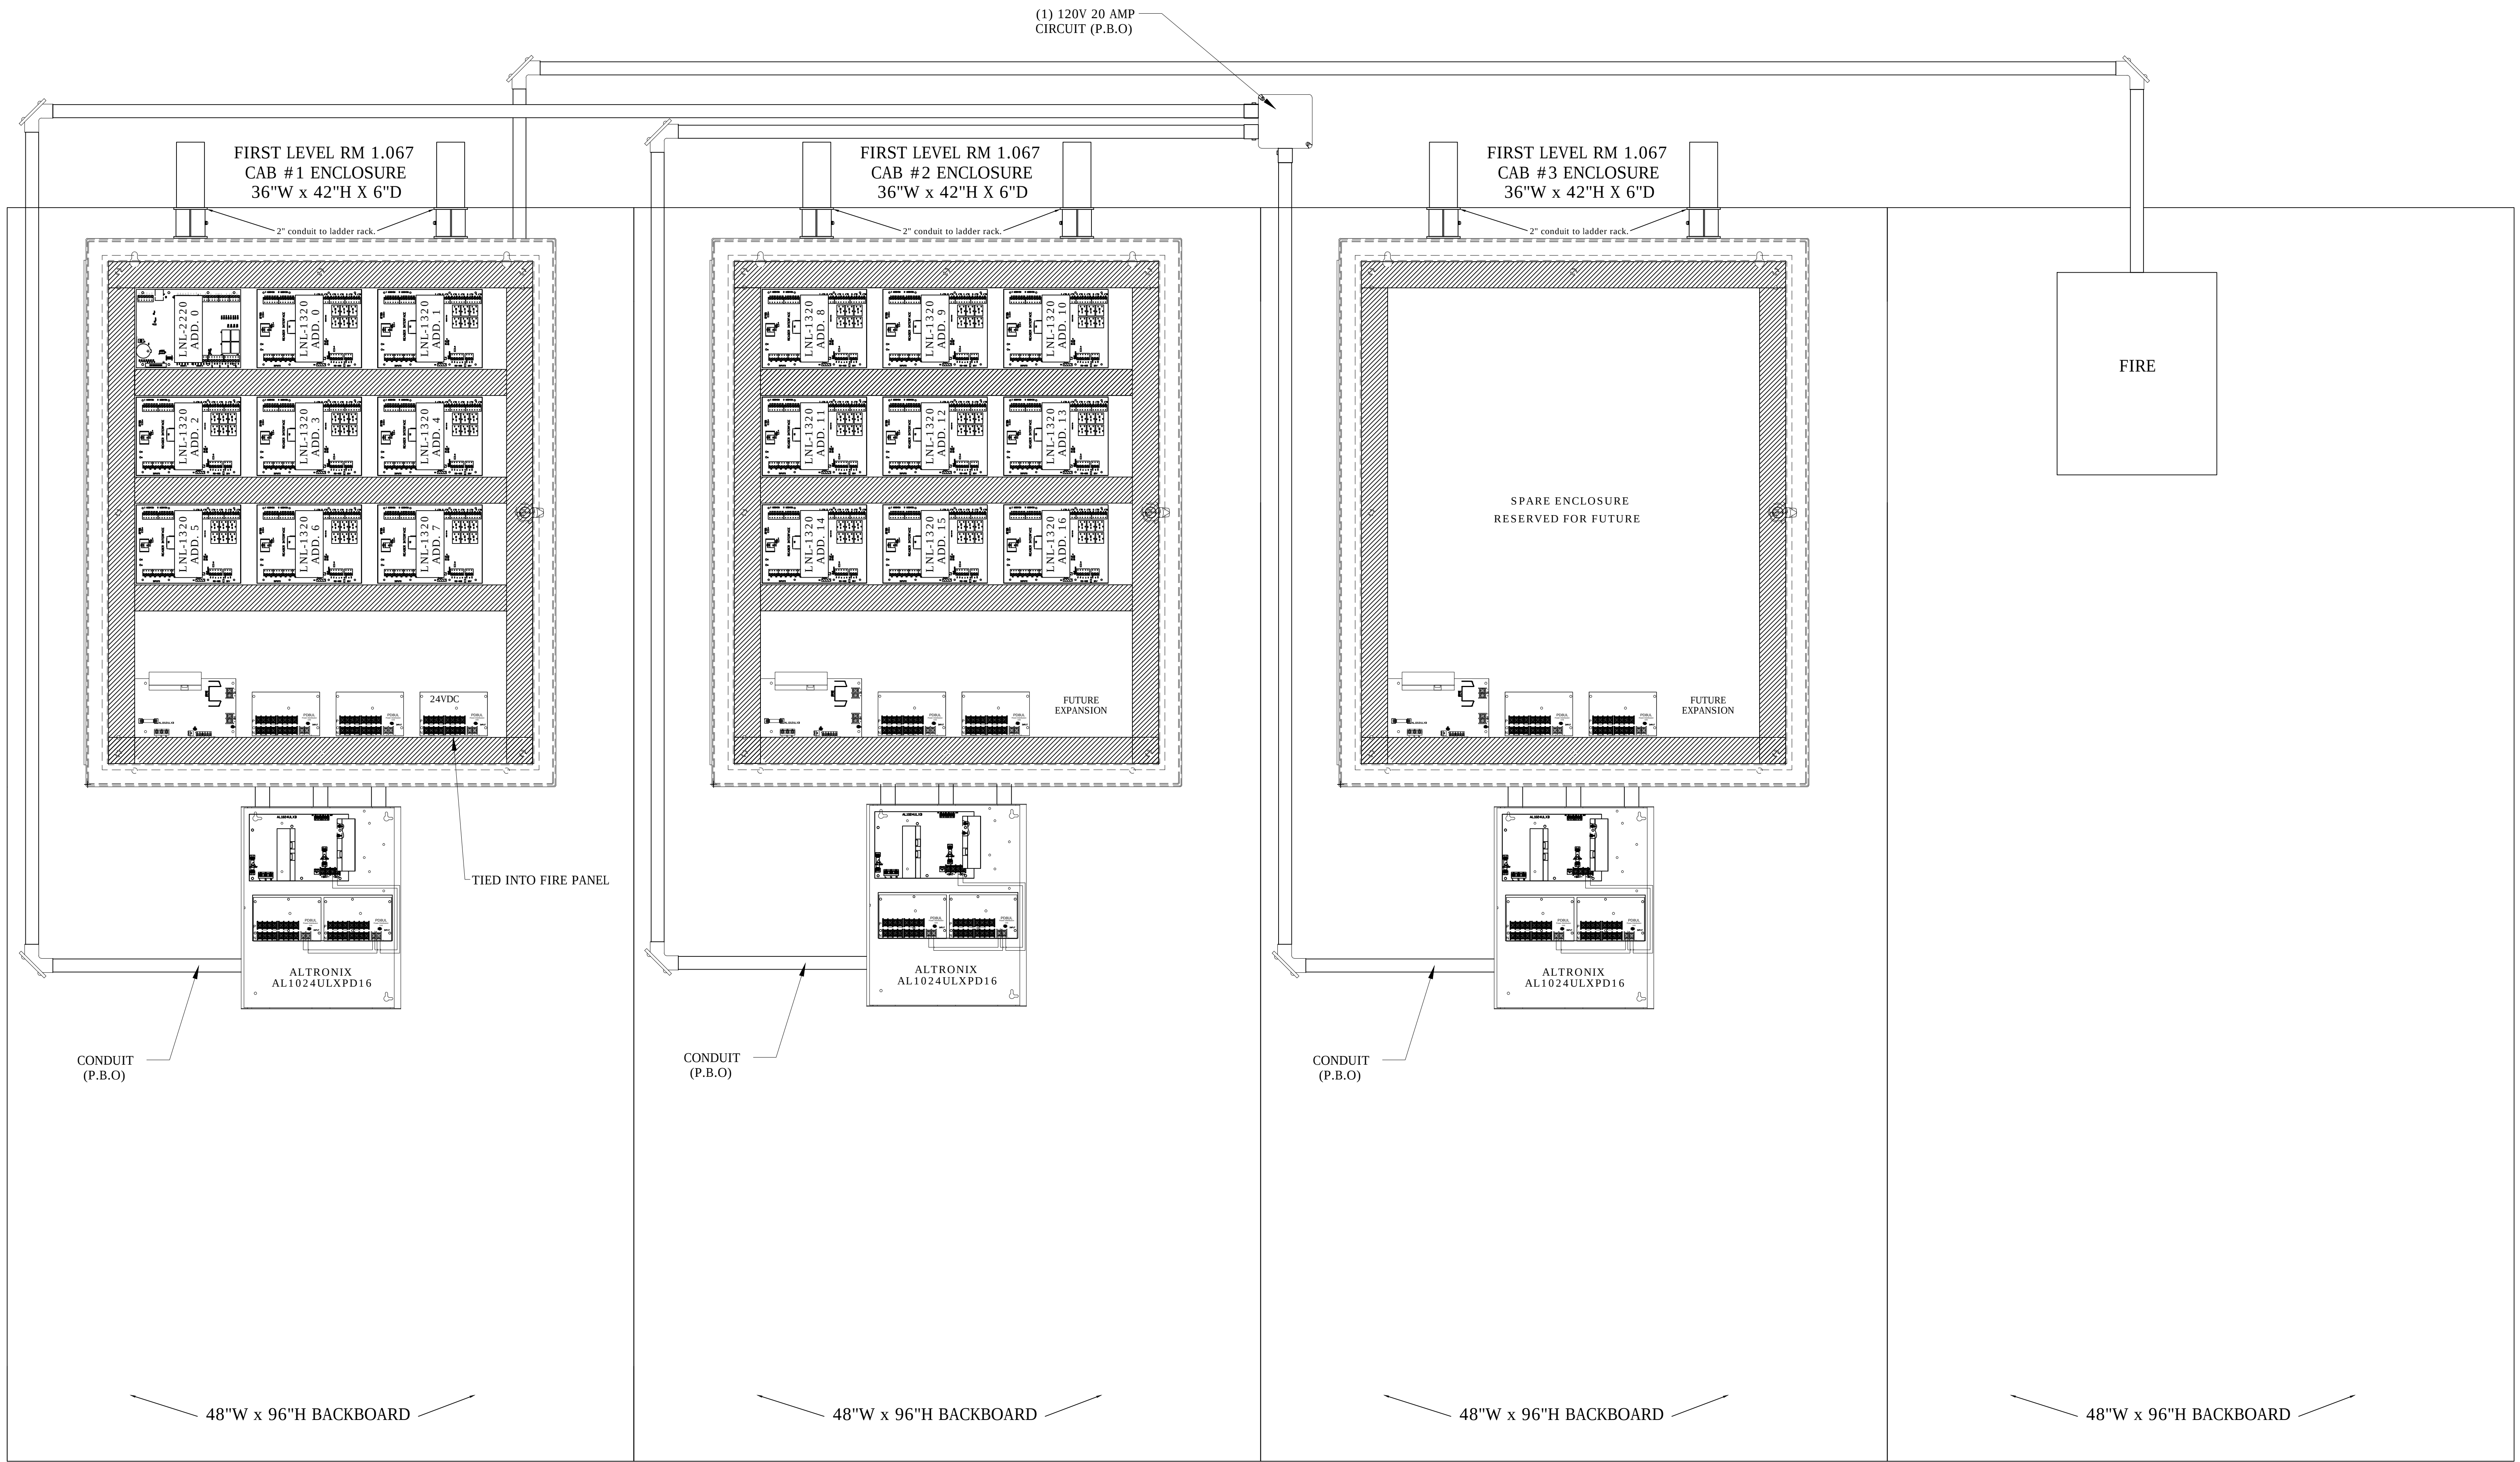

DRAWING PREPARED BY:

1511 E. ORANGETHORPE BLVD.
FULLERTON, CALIFORNIA 92831
714-525-4350 - o; 714-525-4386 - f
(c) Copyright 2012 KRATOS | HBE
All Rights Reserved.

MUST BE SIGNED BY HBE
TO AUTHENTICATE CONTENT(S).
ALL DETAILS CHECKED FOR ACCURACY.

SIGNATURE _____ DATE _____

HBE JOB # _____

CONFIDENTIAL

THE INFORMATION CONTAINED HEREIN MAY
NOT BE USED OR REPRODUCED IN ANY
MANNER WITHOUT WRITTEN PERMISSION OF
KRATOS | HBE.

KEY PLAN

NO.	REV DESCRIPTION REV DATE	APPROVED BY
1.	AS BUILT 08/15/2012	JOHN J. CHRISTIE

REV.	DESCRIPTION	APPROVED BY

CUSTOMER:

CHOC
Children's Hospital
of Orange County

PROJECT:

CHOC CHILDREN'S
HOSPITAL
455 SOUTH MAIN ST.
ORANGE, CA 92668


DRAWING TITLE:

FIRST LEVEL ACCESS
CONTROL PANEL
LAYOUT RM 1.067

DRN BY	DATE DRN	CHK BY	DATE CHK
JOSH G.	08/08/2012	JJC	

SCALE:	NTS
DWG NO.	SE2.02

ASBUILT
08/15/2012

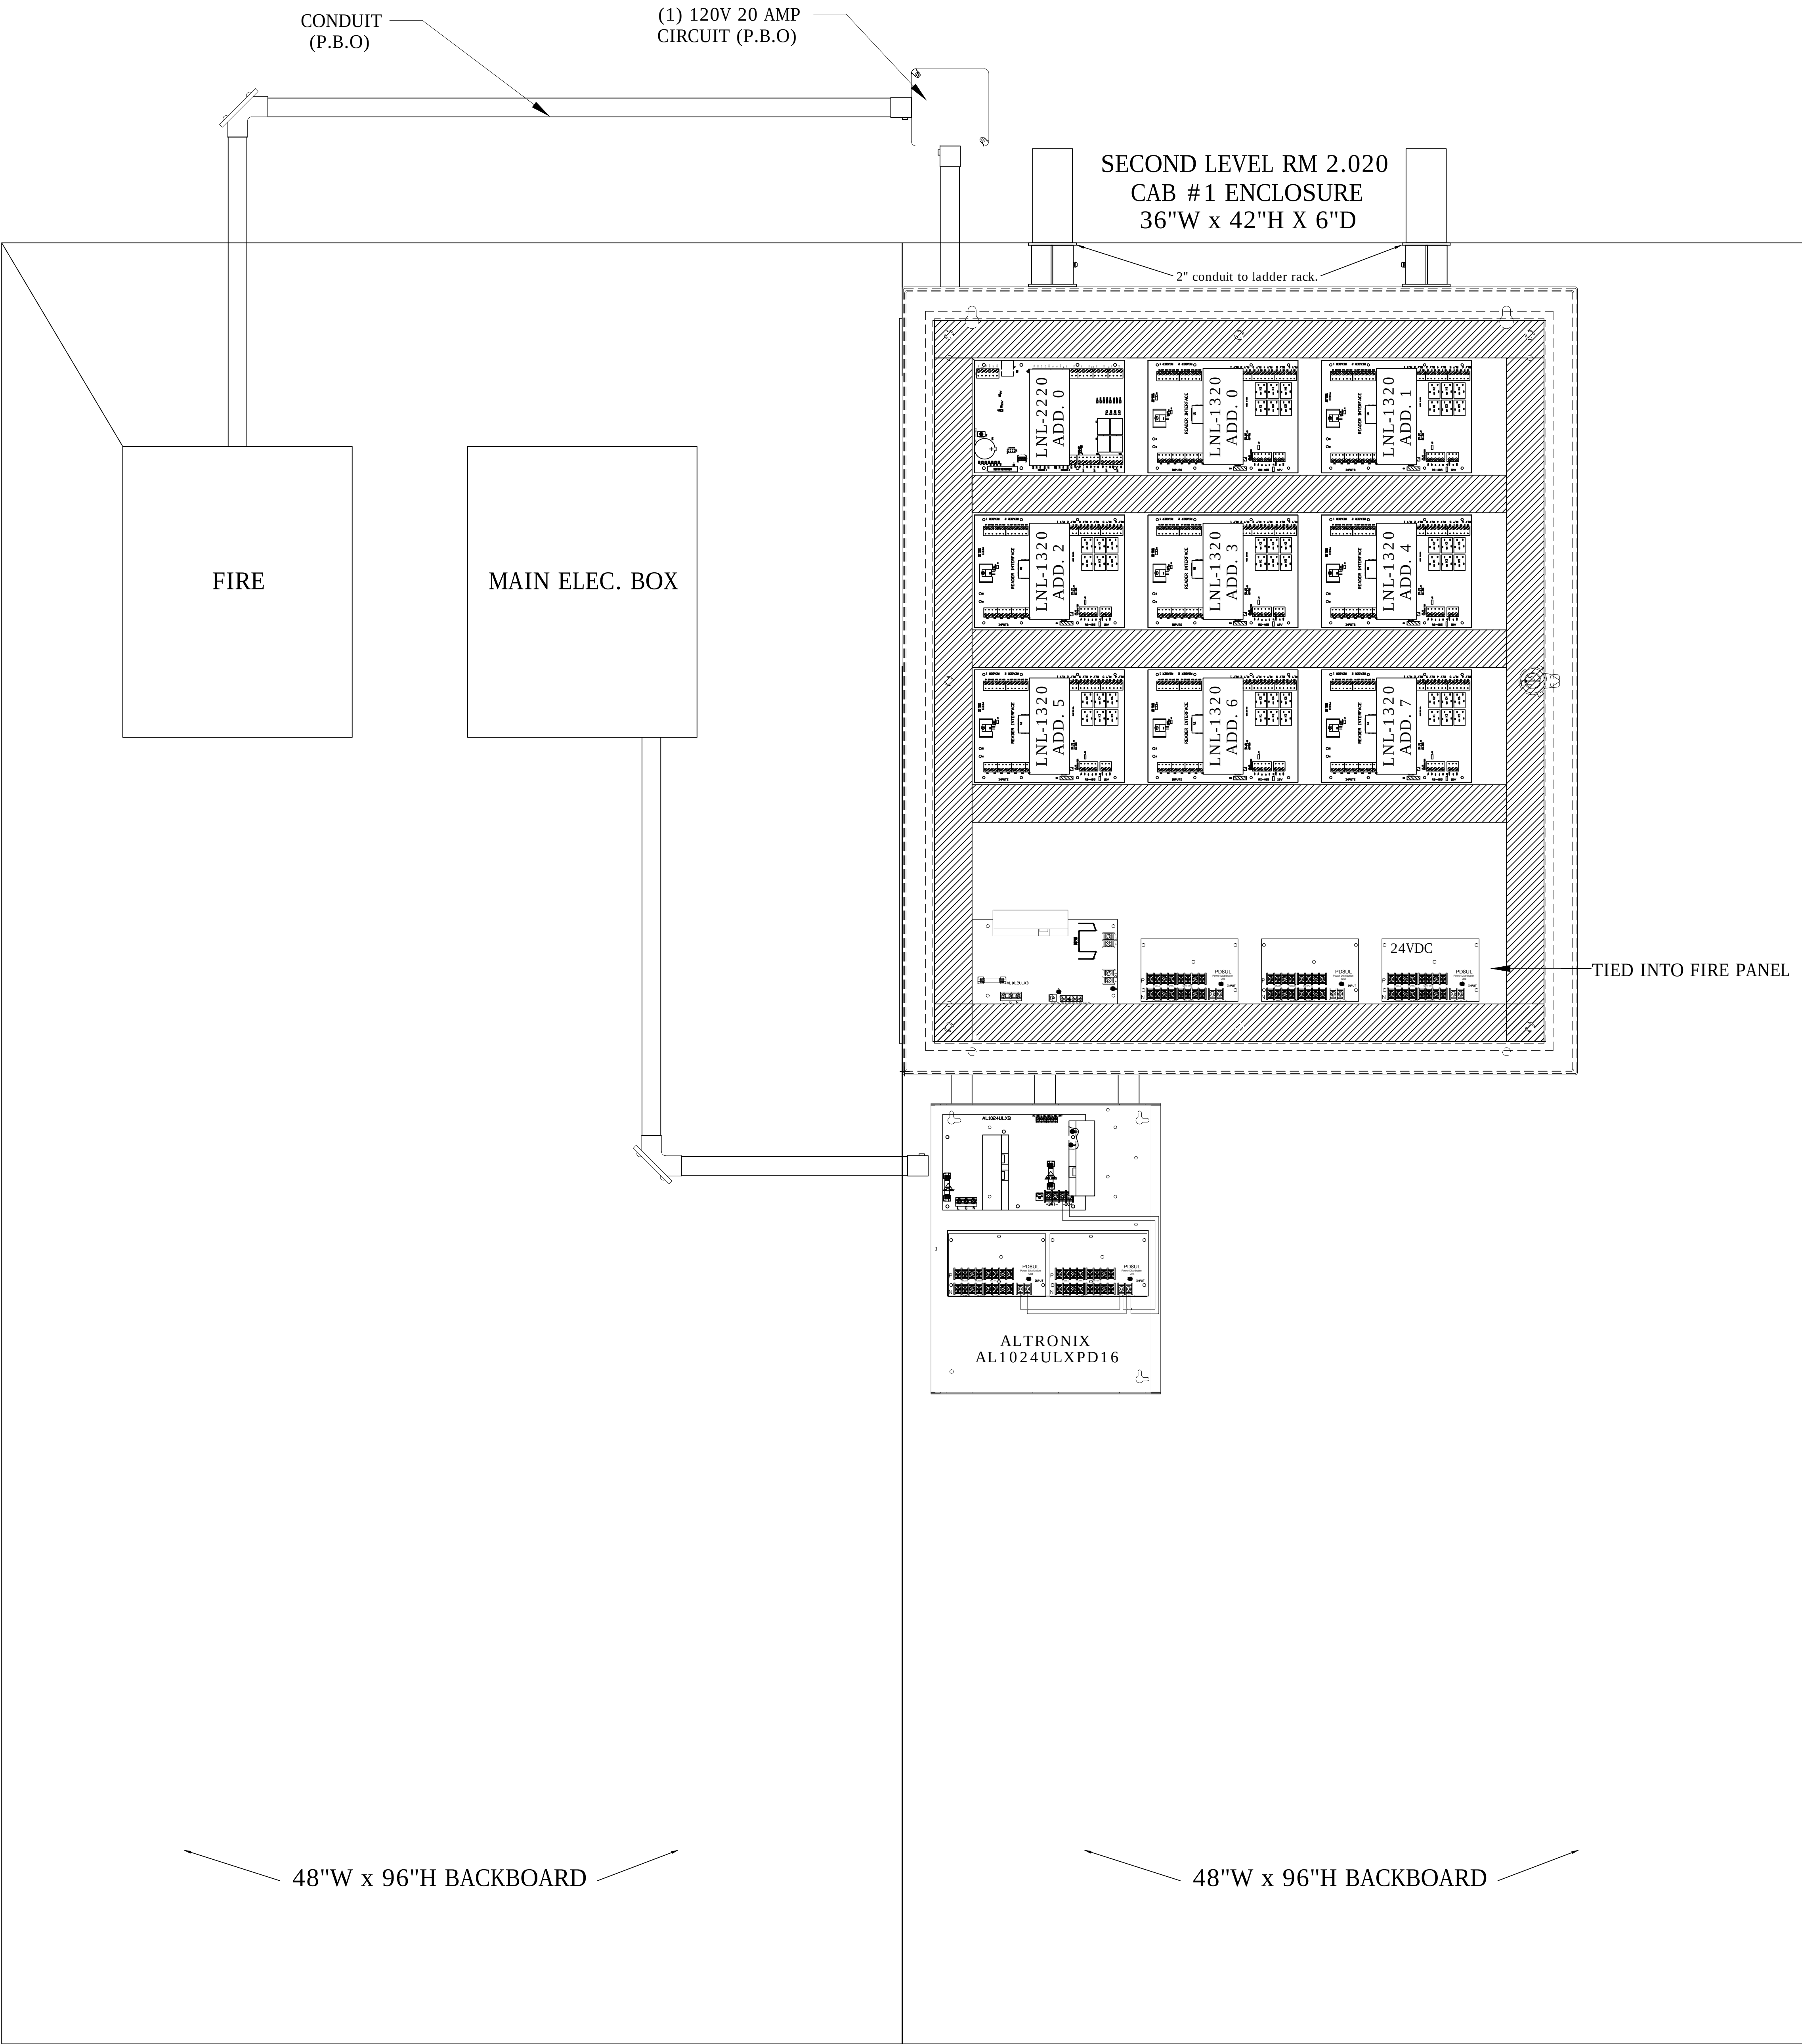

ASBUILTS
08/15/2012

DRAWING PREPARED BY:



1511 E. ORANGETHORPE BLVD.
FULLERTON, CALIFORNIA 92831
714-525-4350 - o; 714-525-4386 - f
(c) Copyright 2012 KRATOS | HBE
All Rights Reserved.

MUST BE SIGNED BY HBE
TO AUTHENTICATE CONTENT(S).
ALL DETAILS CHECKED FOR ACCURACY.


SIGNATURE _____ DATE _____

HBE JOB # _____

CONFIDENTIAL

THE INFORMATION CONTAINED HERIN MAY
NOT BE USED OR REPRODUCED IN ANY
MANNER WITHOUT WRITTEN PERMISSION OF
KRATOS | HBE.

KEY PLAN

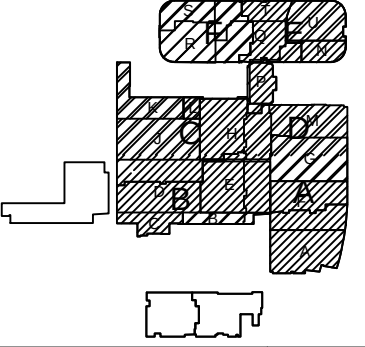

NO.	REV DESCRIPTION REV DATE	APPROVED BY
1.	AS BUILTS 08/15/2012	JOHN J. CHRISTIE

REV.	DESCRIPTION	APPROVED BY

CUSTOMER:




PROJECT:

CHOC CHILDREN'S
HOSPITAL
455 SOUTH MAIN ST.
ORANGE, CA 92668

DRAWING TITLE:

SECOND LEVEL ACCESS
CONTROL PANEL
LAYOUT RM 2.020

DRN BY	DATE DRN	CHK BY	DATE CHK
JOSH G.	08/08/2012	JJC	
SCALE:	NTS		
DWG NO.	SE2.04		

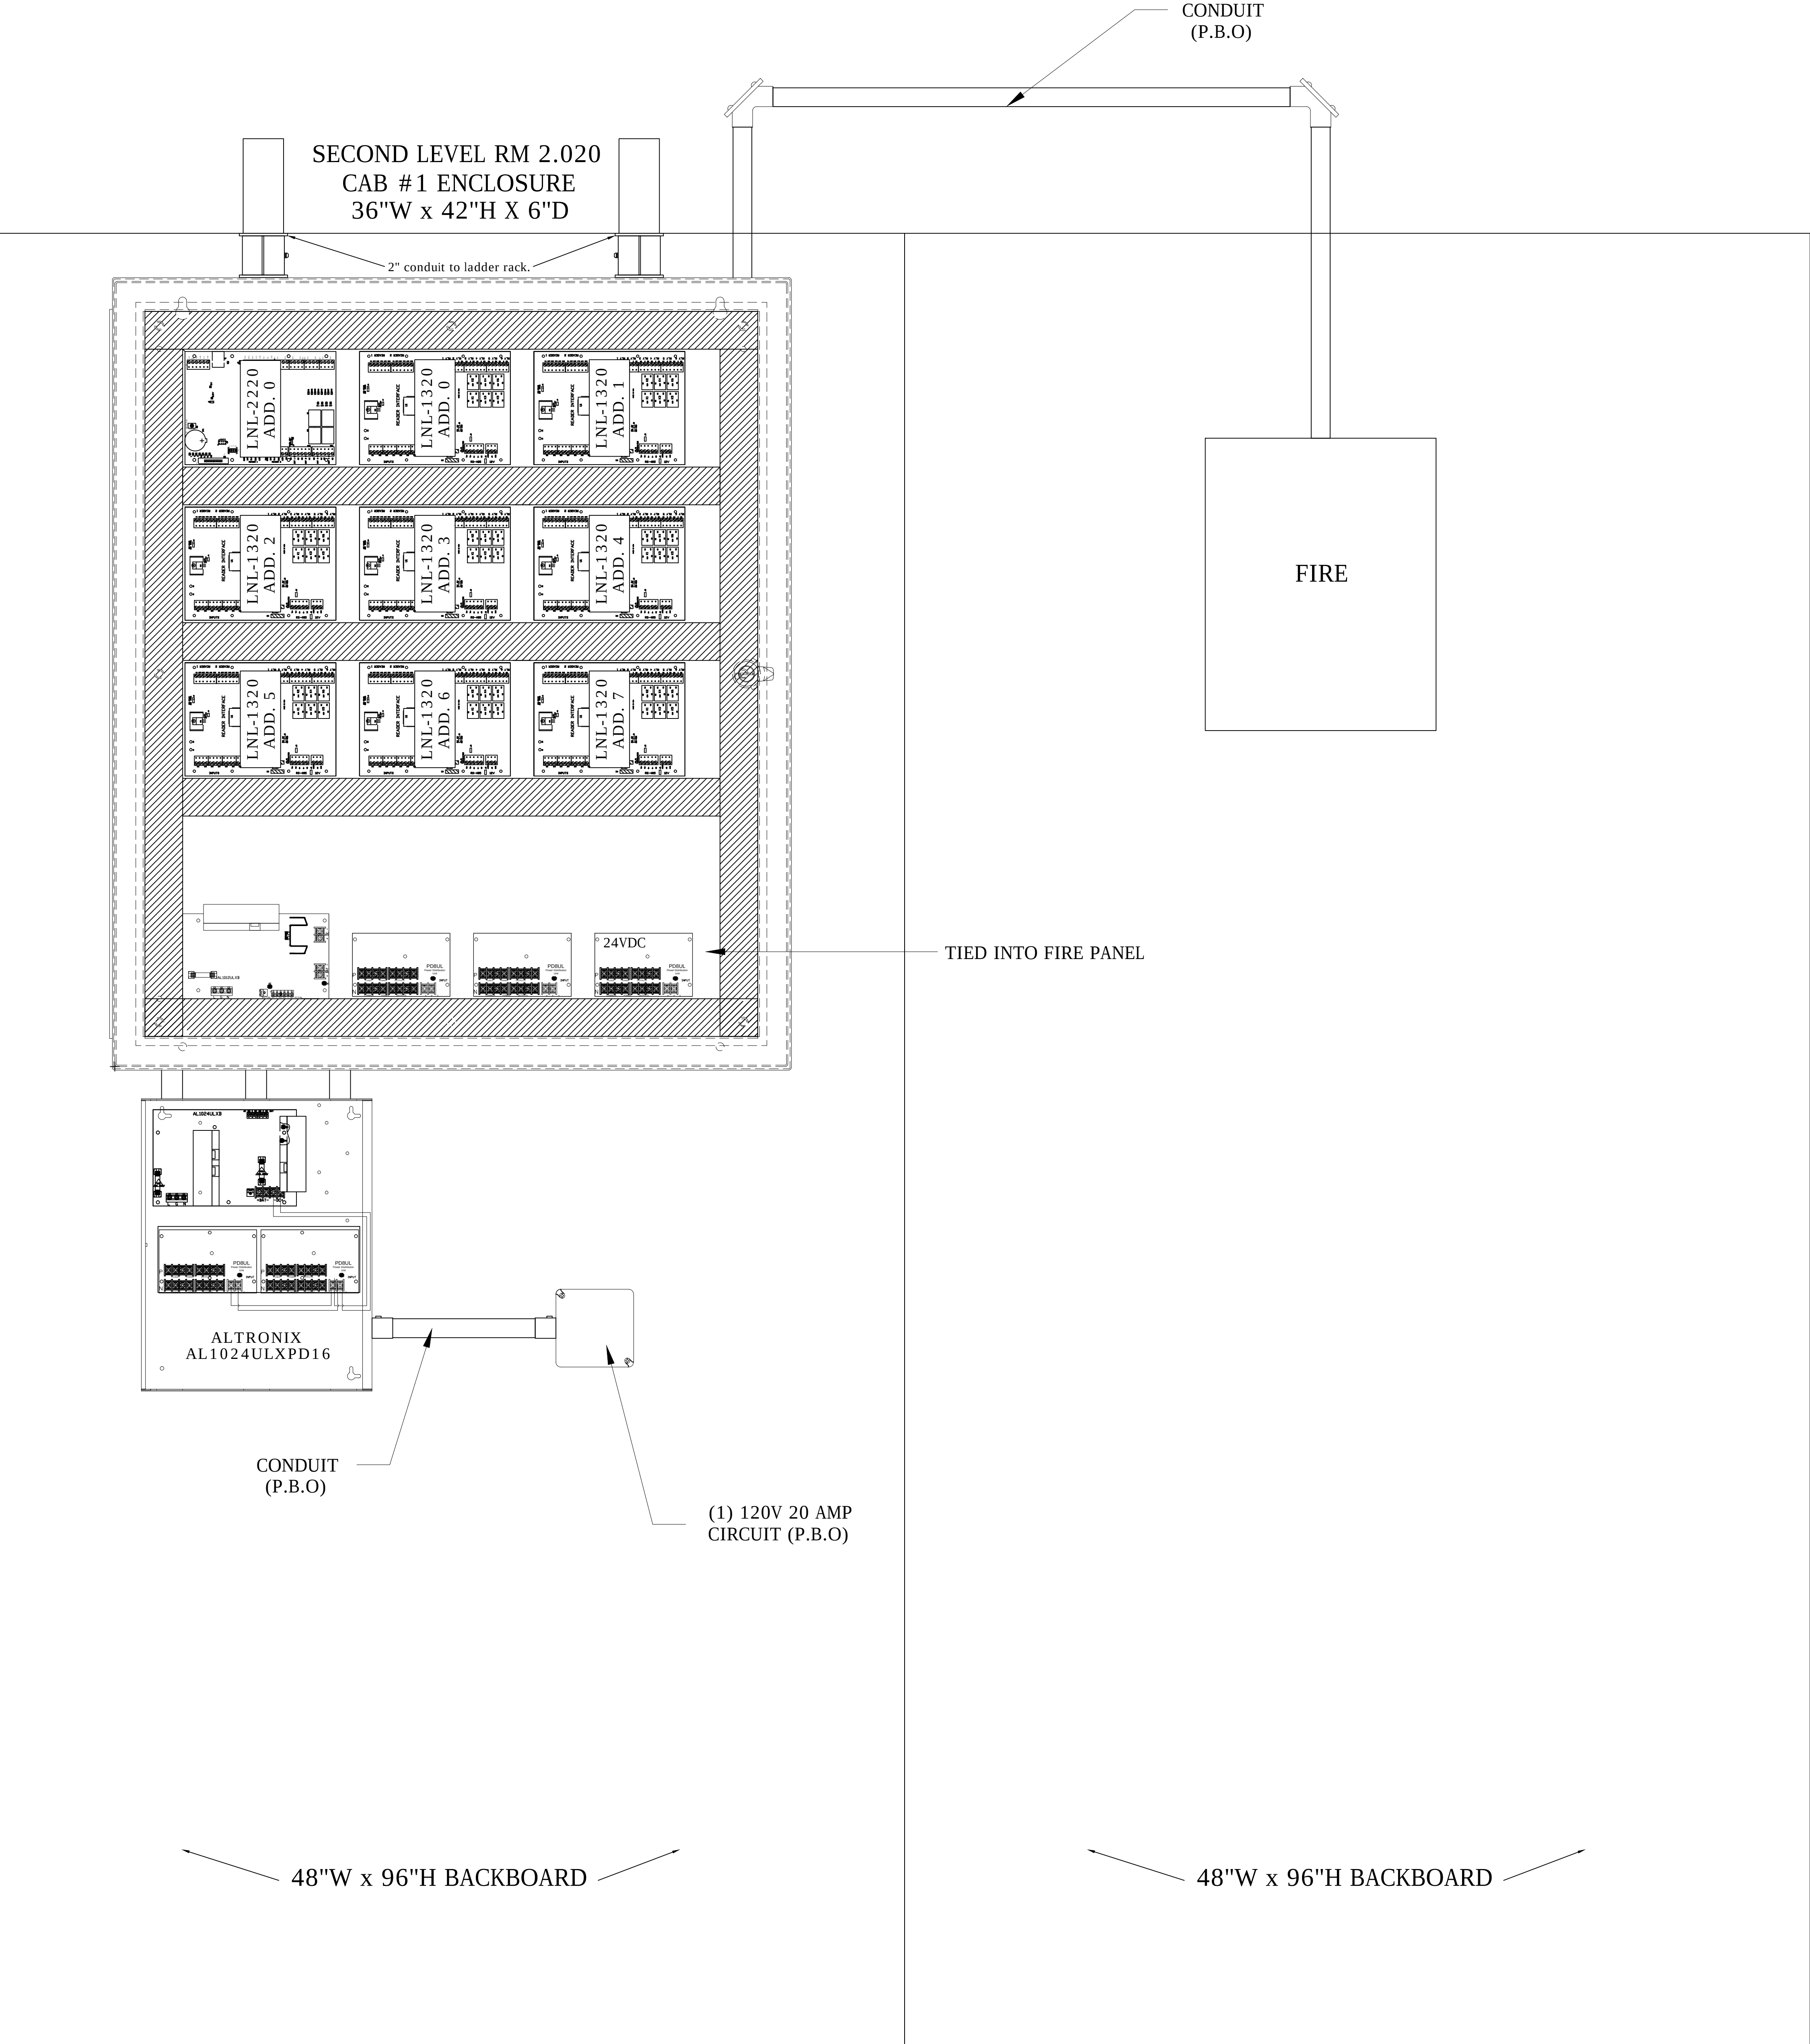

DRAWING PREPARED BY:



1511 E. ORANGETHORPE BLVD.
FULLERTON, CALIFORNIA 92831
714-525-4350 - o; 714-525-4386 - f
(c) Copyright 2012 KRATOS | HBE
All Rights Reserved.

MUST BE SIGNED BY HBE
TO AUTHENTICATE CONTENT(S).
ALL DETAILS CHECKED FOR ACCURACY.


SIGNATURE _____ DATE _____

HBE JOB #

CONFIDENTIAL

THE INFORMATION CONTAINED HEREIN MAY
NOT BE USED OR REPRODUCED IN ANY
MANNER WITHOUT WRITTEN PERMISSION OF
KRATOS | HBE.

KEY PLAN

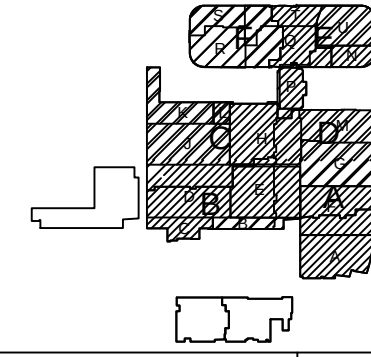

NO.	REV DESCRIPTION REV DATE	APPROVED BY
1.	AS BUILTS 08/15/2012	JOHN J. CHRISTIE

REV. DESCRIPTION APPROVED BY

CUSTOMER:



PROJECT:

CHOC CHILDREN'S
HOSPITAL
455 SOUTH MAIN ST.
ORANGE, CA 92668

DRAWING TITLE:

SECOND LEVEL ACCESS
CONTROL PANEL
LAYOUT RM 2.066

DRN BY	DATE DRN	CHK BY	DATE CHK
JOSH G.	08/08/2012	JJC	
SCALE:	NTS		
DWG NO.	SE2.05		


ASBUILTS
08/15/2012

FIRE/SMOKE

CONDUIT
(P.B.O)

THIRD LEVEL RM 3.022
CAB #1 ENCLOSURE
36"W x 42"H x 6"D

2" conduit to ladder rack

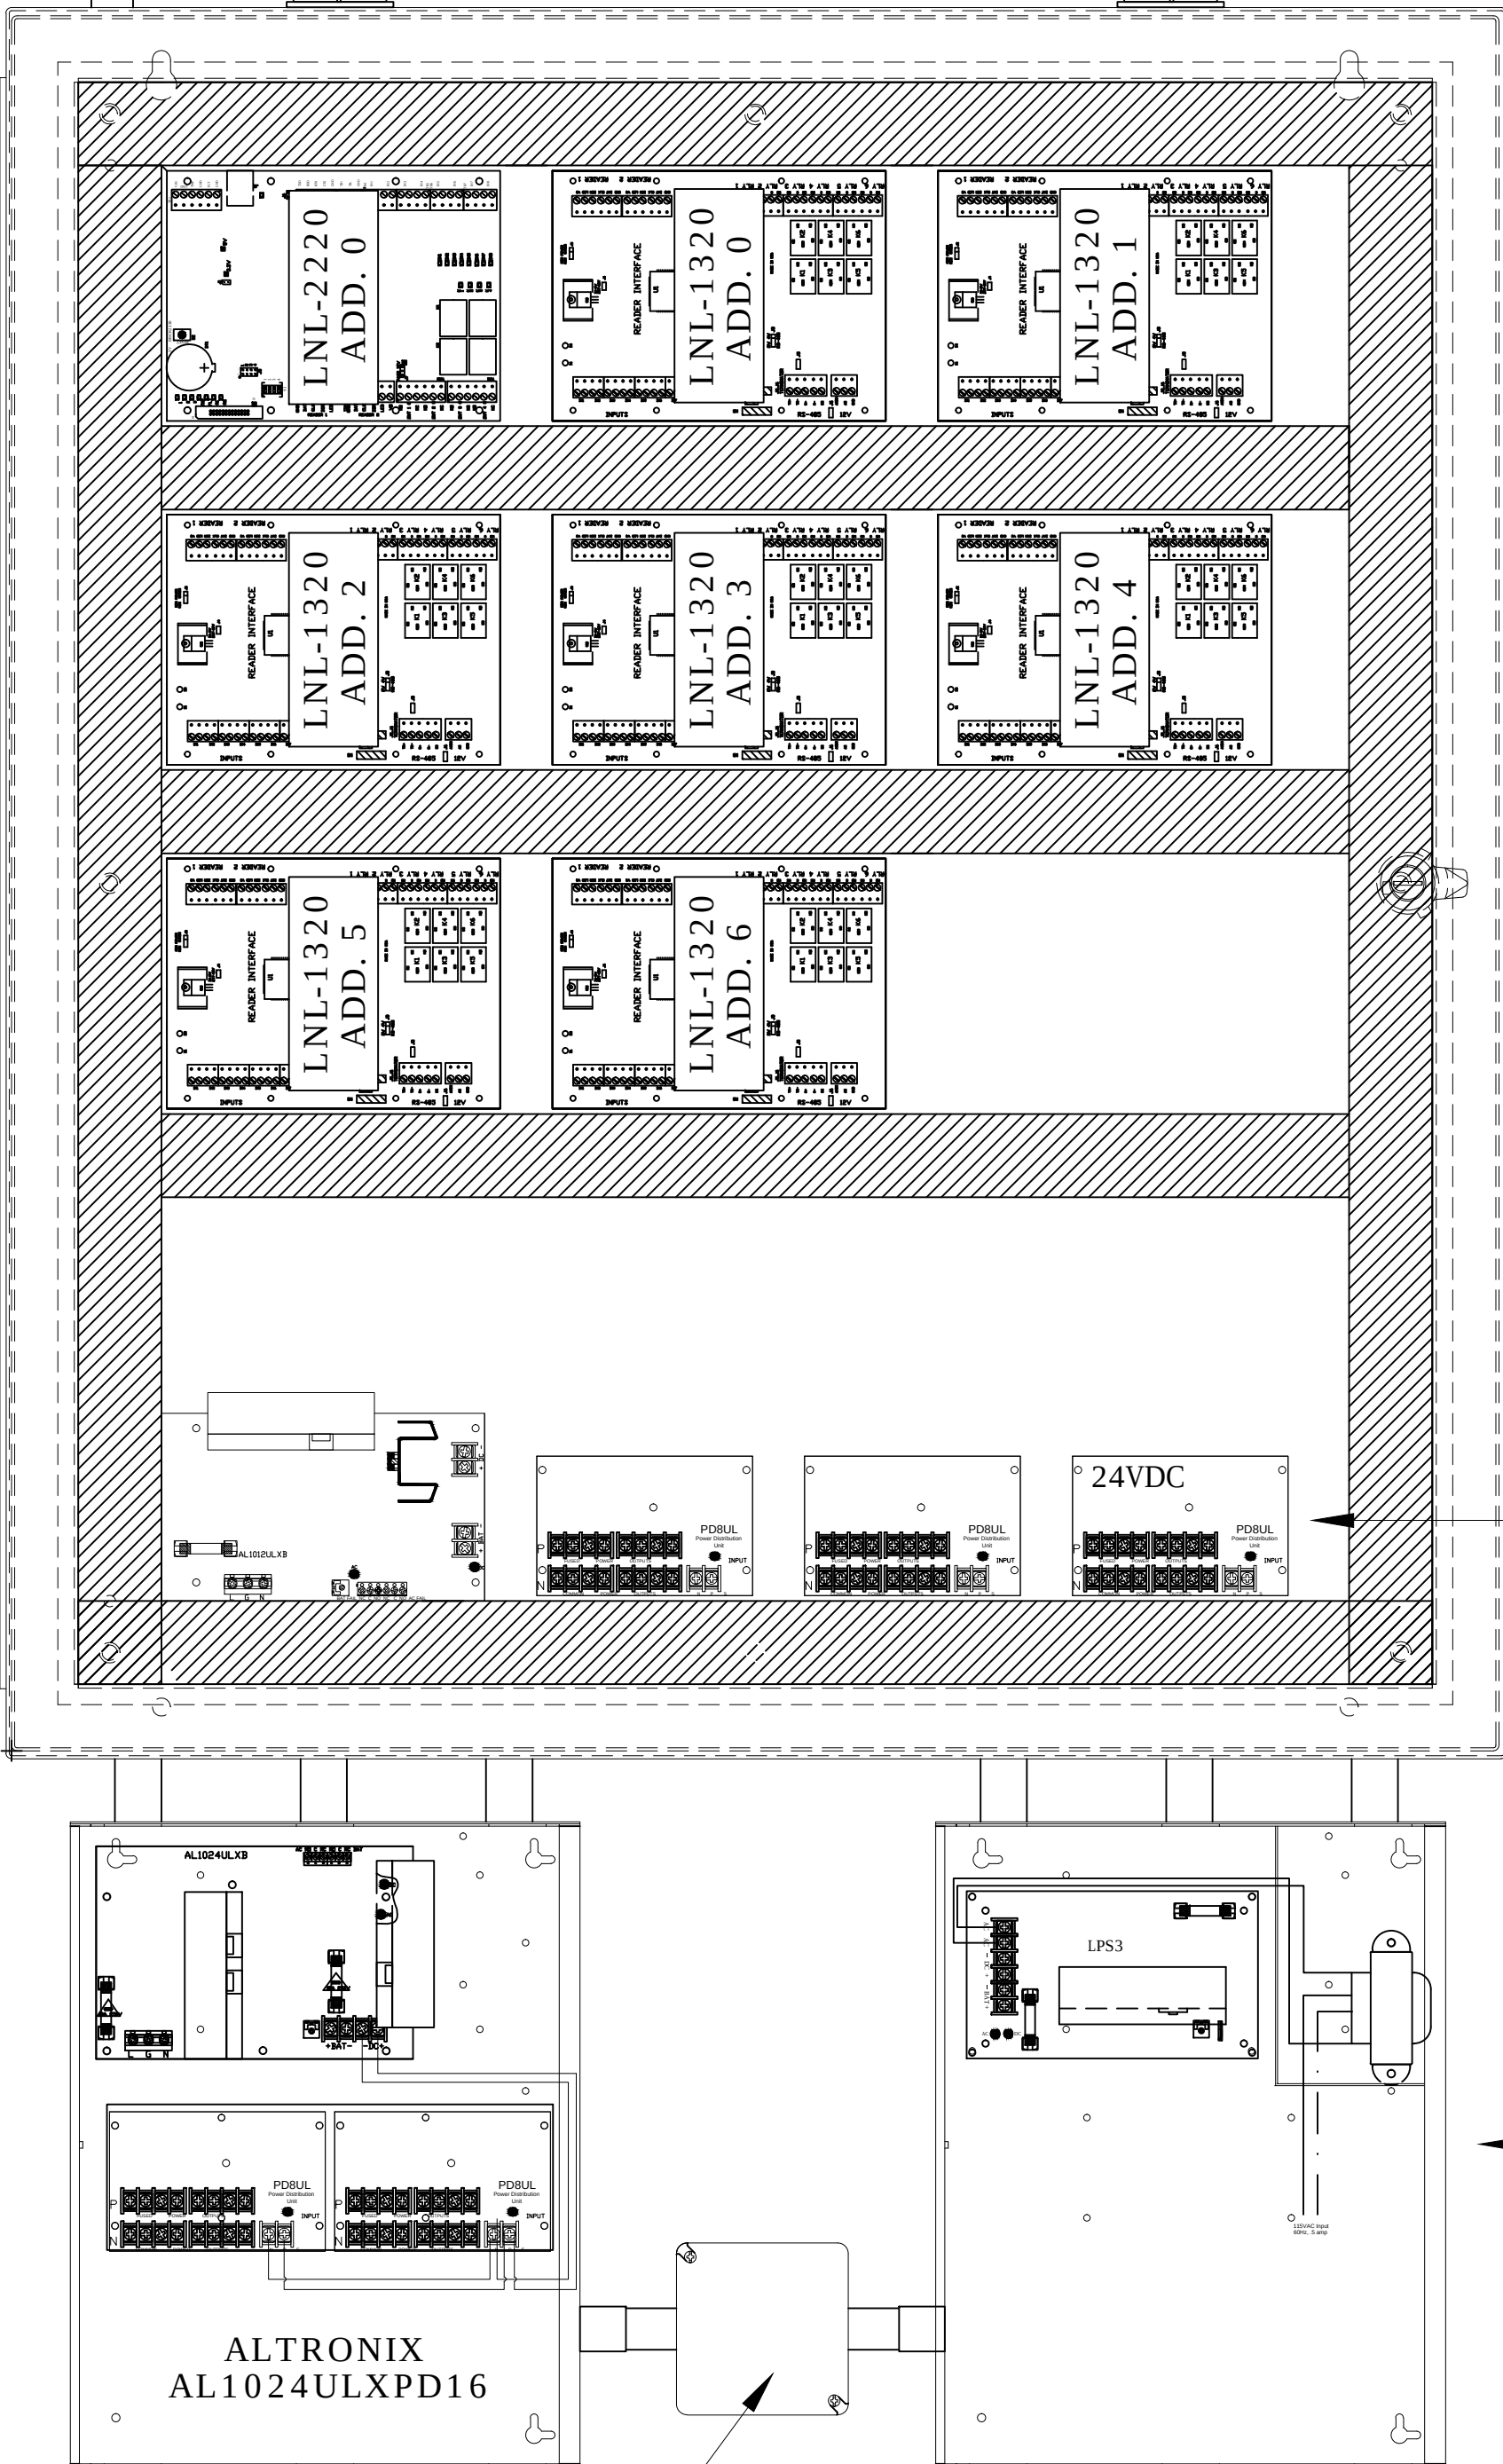

(1) 120V 20 AMP
CIRCUIT (P.B.O)

48"W x 96"H BACKBOARD

TIED INTO FIRE PANEL

12V LINEAR POWER SUPPLY

48"W x 96"H BACKBOARD

DRAWING PREPARED BY:

KRATOS
HBE

1511 E. ORANGETHORPE BLVD.
FULLERTON, CALIFORNIA 92831
714-525-4350 - o; 714-525-4386 - f
(c) Copyright 2012 KRATOS | HBE
All Rights Reserved.

MUST BE SIGNED BY HBE
TO AUTHENTICATE CONTENT(S).
ALL DETAILS CHECKED FOR ACCURACY.


SIGNATURE _____ DATE _____

HBE JOB #

CONFIDENTIAL

THE INFORMATION CONTAINED HEREIN MAY
NOT BE USED OR REPRODUCED IN ANY
MANNER WITHOUT WRITTEN PERMISSION OF
KRATOS | HBE.

KEY PLAN

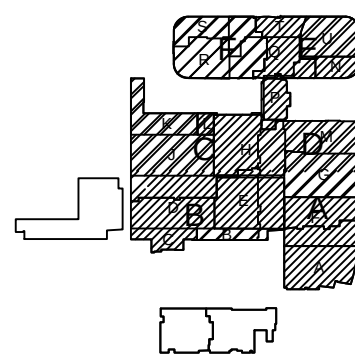

NO.	REV DESCRIPTION REV DATE	APPROVED BY
1.	AS BUILTS 08/15/2012	JOHN J. CHRISTIE

REV. DESCRIPTION APPROVED BY

CUSTOMER:


CHOC
Children's Hospital
of Orange County

PROJECT:
CHOC CHILDREN'S
HOSPITAL
455 SOUTH MAIN ST.
ORANGE, CA 92668

DRAWING TITLE:
THIRD LEVEL ACCESS
CONTROL PANEL
LAYOUT RM 3.022

DRN BY	DATE DRN	CHK BY	DATE CHK
JOSH G.	08/08/2012	JJC	
SCALE:	NTS		
DWG NO.	SE2.06		

ASBUILTS
08/15/2012

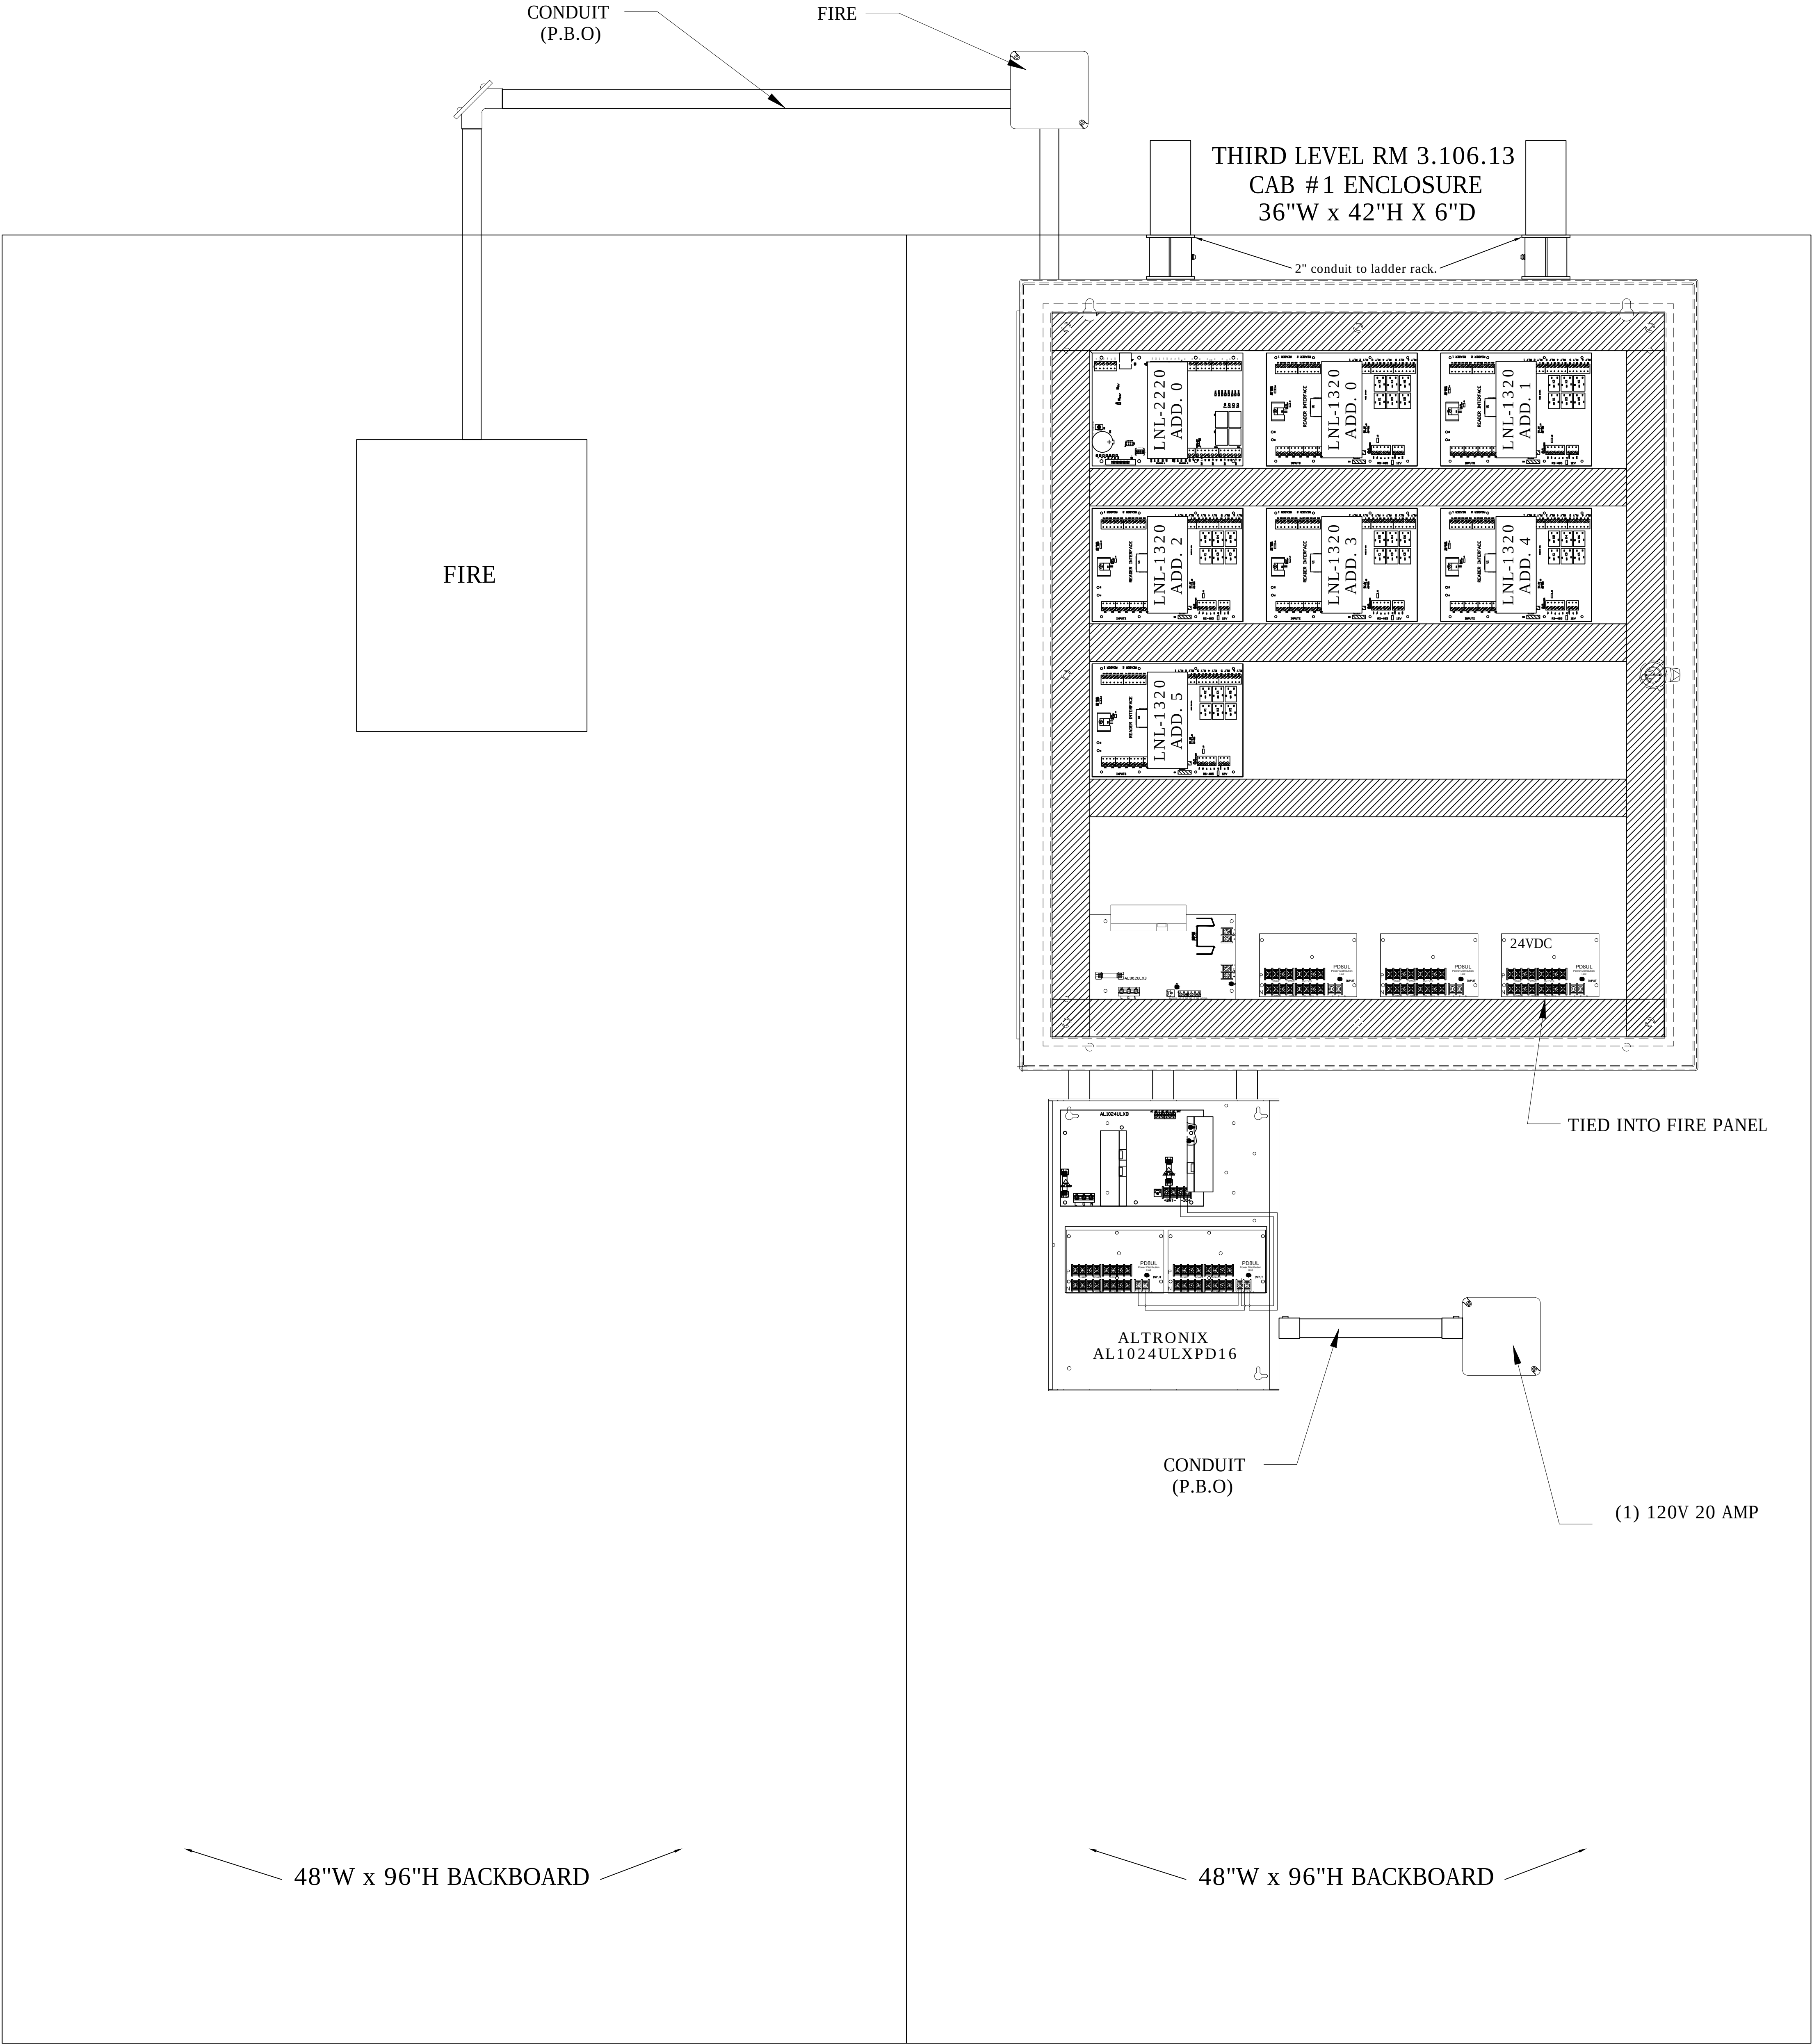

DRAWING PREPARED BY:



1511 E. ORANGETHORPE BLVD.
FULLERTON, CALIFORNIA 92831
714-525-4350 - o; 714-525-4386 - f
(c) Copyright 2012 KRATOS | HBE
All Rights Reserved.

MUST BE SIGNED BY HBE
TO AUTHENTICATE CONTENT(S).
ALL DETAILS CHECKED FOR ACCURACY.


SIGNATURE _____ DATE _____

HBE JOB # _____

CONFIDENTIAL

THE INFORMATION CONTAINED HERIN MAY
NOT BE USED OR REPRODUCED IN ANY
MANNER WITHOUT WRITTEN PERMISSION OF
KRATOS | HBE.

KEY PLAN

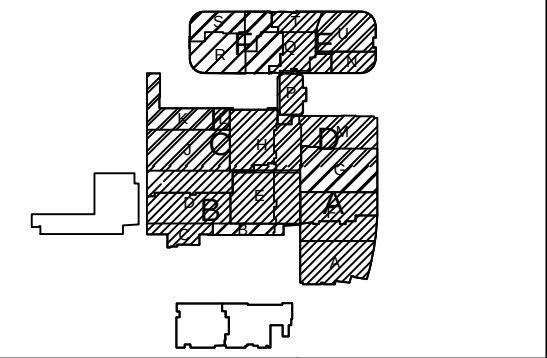

NO.	REV DESCRIPTION REV DATE	APPROVED BY
1.	AS BUILTS 08/15/2012	JOHN J. CHRISTIE

REV.	DESCRIPTION	APPROVED BY
------	-------------	-------------

CUSTOMER:




PROJECT:
CHOC CHILDREN'S
HOSPITAL
455 SOUTH MAIN ST.
ORANGE, CA 92668

DRAWING TITLE:
THIRD LEVEL ACCESS
CONTROL PANEL
LAYOUT RM 3.106.13

DRN BY	DATE DRN	CHK BY	DATE CHK
JOSH G.	08/08/2012	JJC	
SCALE:	NTS		
DWG NO.	SE2.07		

ASBUILTS
08/15/2012

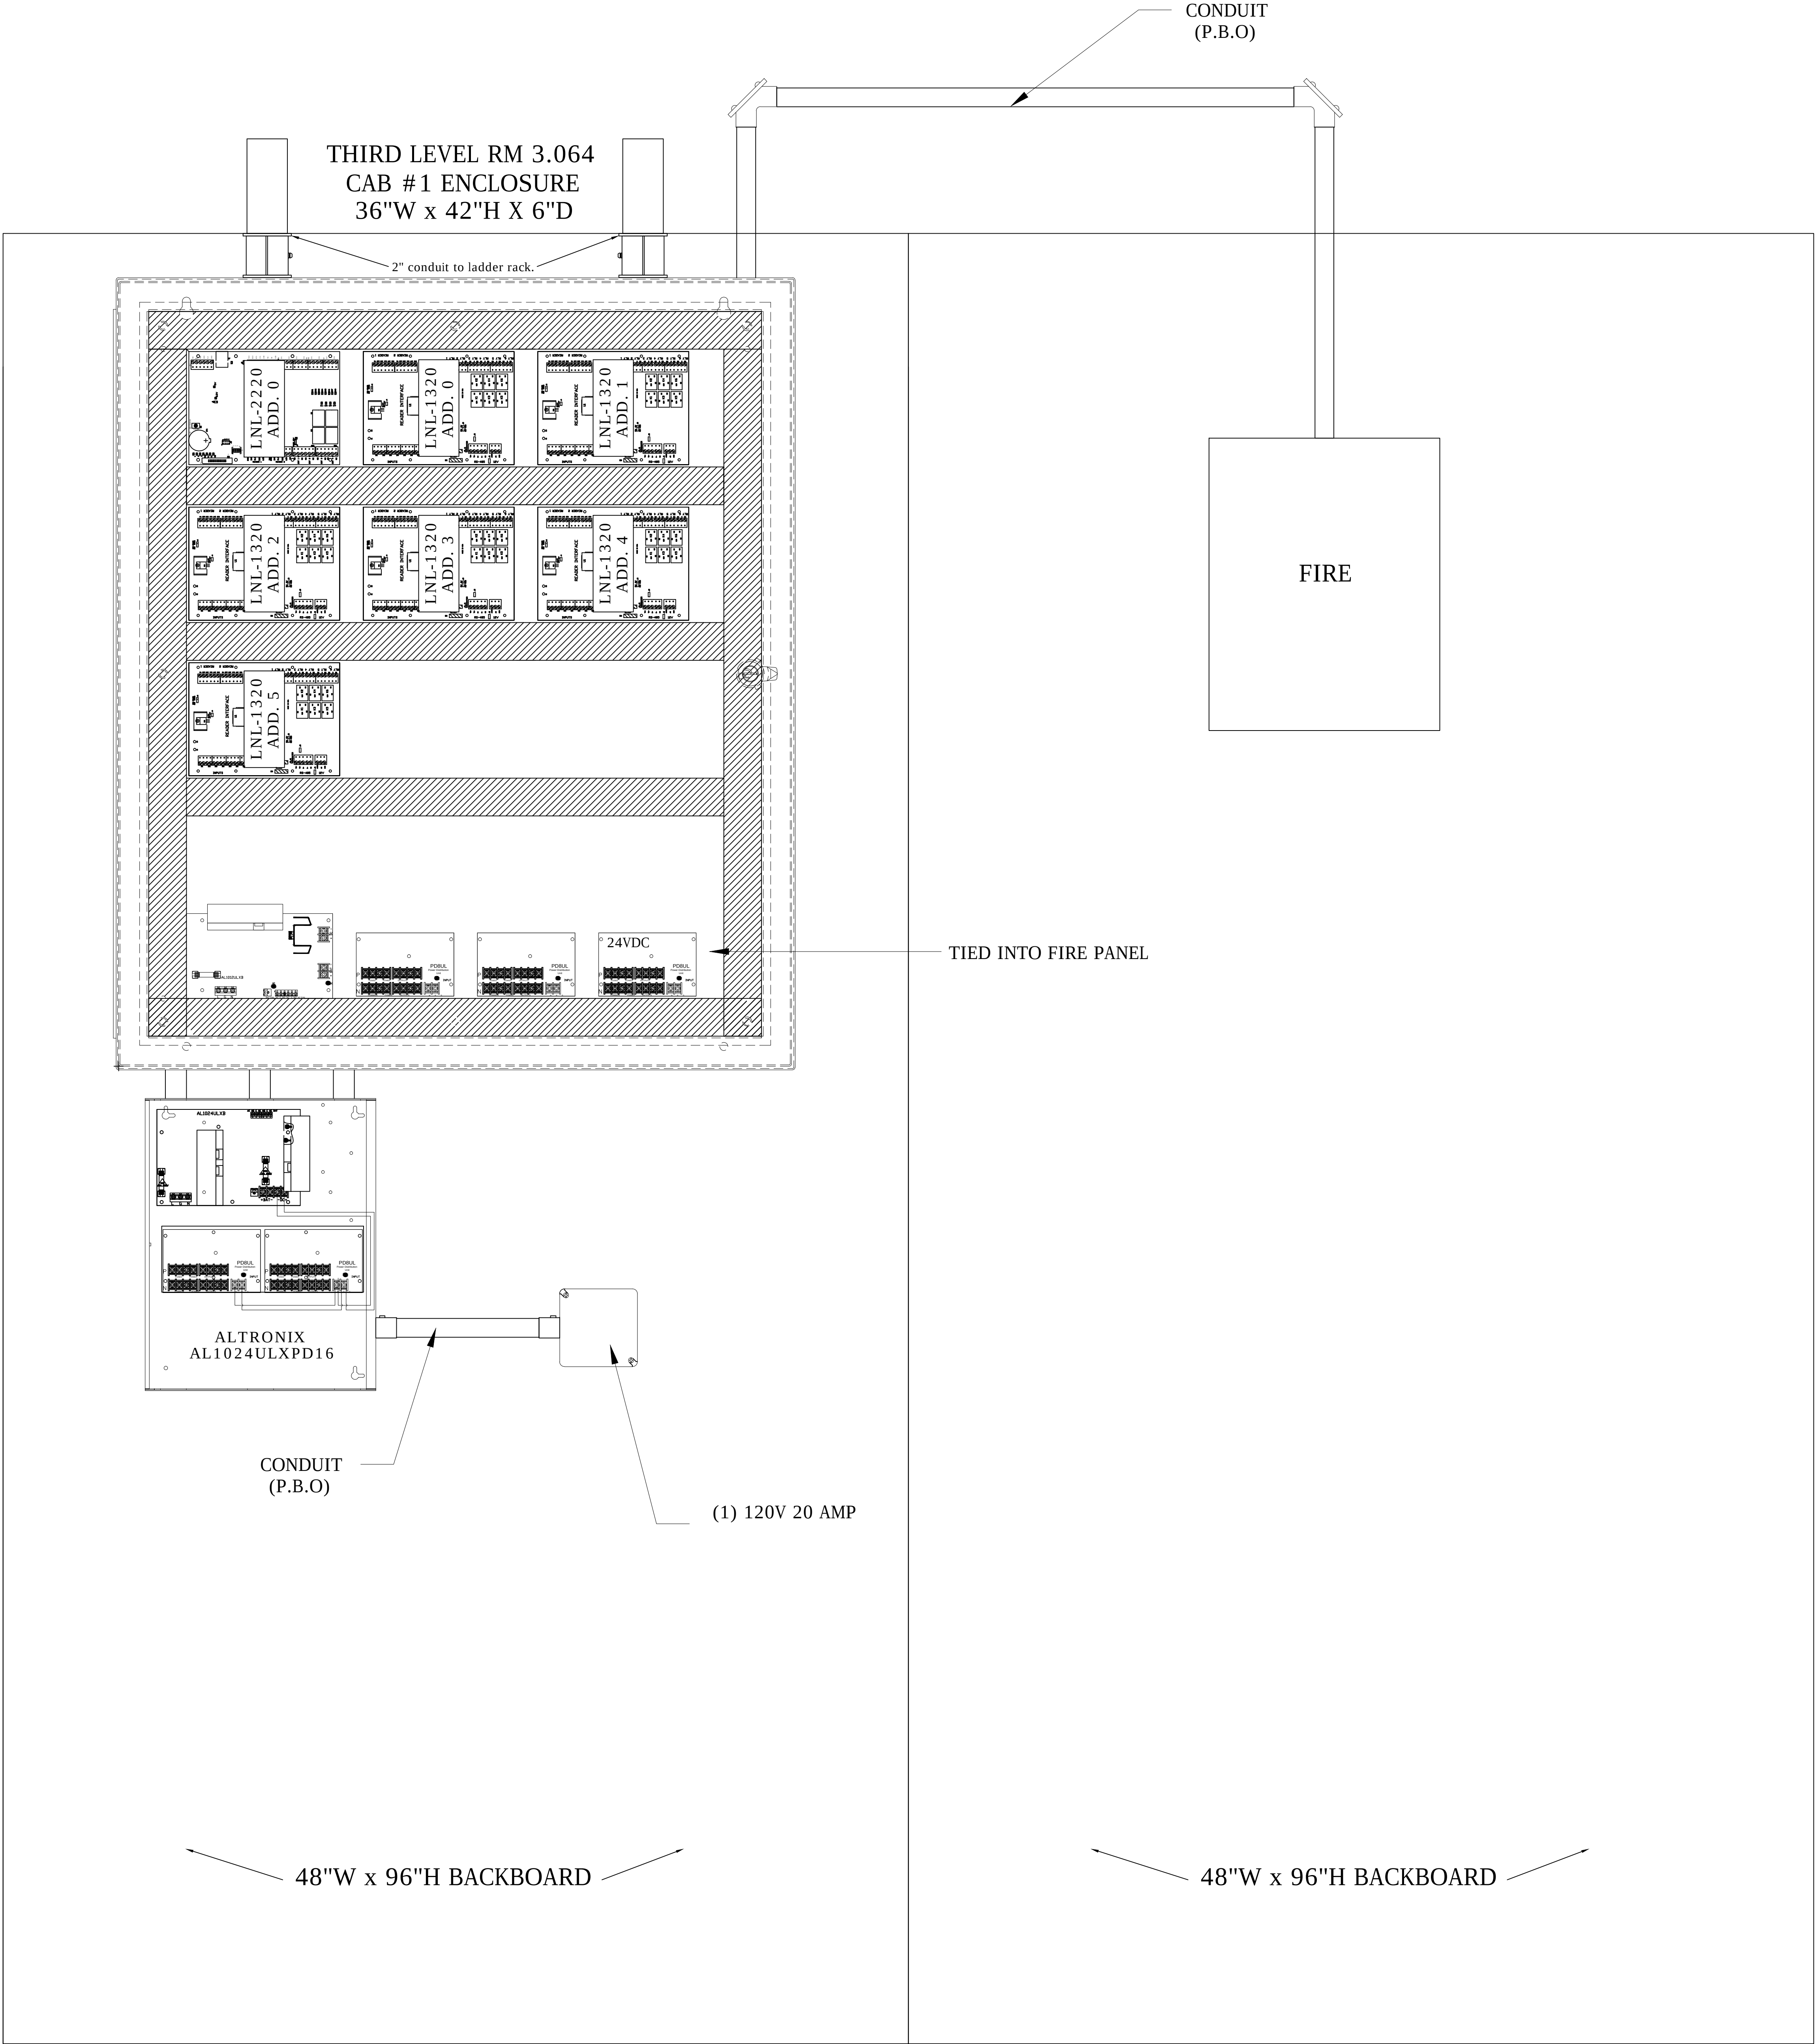

DRAWING PREPARED BY:



1511 E. ORANGETHORPE BLVD.
FULLERTON, CALIFORNIA 92831
714-525-4350 - o; 714-525-4386 - f
(c) Copyright 2012 KRATOS | HBE
All Rights Reserved.

MUST BE SIGNED BY HBE
TO AUTHENTICATE CONTENT(S).
ALL DETAILS CHECKED FOR ACCURACY.


SIGNATURE _____ DATE _____

HBE JOB #

CONFIDENTIAL

THE INFORMATION CONTAINED HEREIN MAY
NOT BE USED OR REPRODUCED IN ANY
MANNER WITHOUT WRITTEN PERMISSION OF
KRATOS | HBE.

KEY PLAN

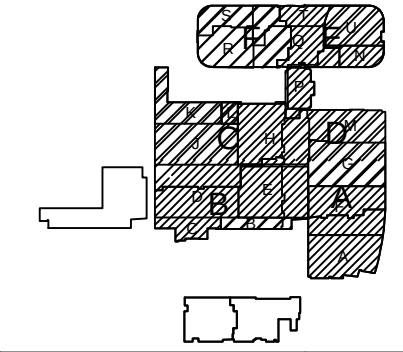

NO.	REV DESCRIPTION REV DATE	APPROVED BY
1.	AS BUILTS 08/15/2012	JOHN J. CHRISTIE

REV.	DESCRIPTION	APPROVED BY
------	-------------	-------------

CUSTOMER:




PROJECT:
CHOC CHILDREN'S
HOSPITAL
455 SOUTH MAIN ST.
ORANGE, CA 92668

DRAWING TITLE:
THIRD LEVEL ACCESS
CONTROL PANEL
LAYOUT RM 3.064

DRN BY	DATE DRN	CHK BY	DATE CHK
JOSH G.	08/08/2012	JJC	
SCALE:	NTS		
DWG NO.	SE2.08		

ASBUILTS
08/15/2012

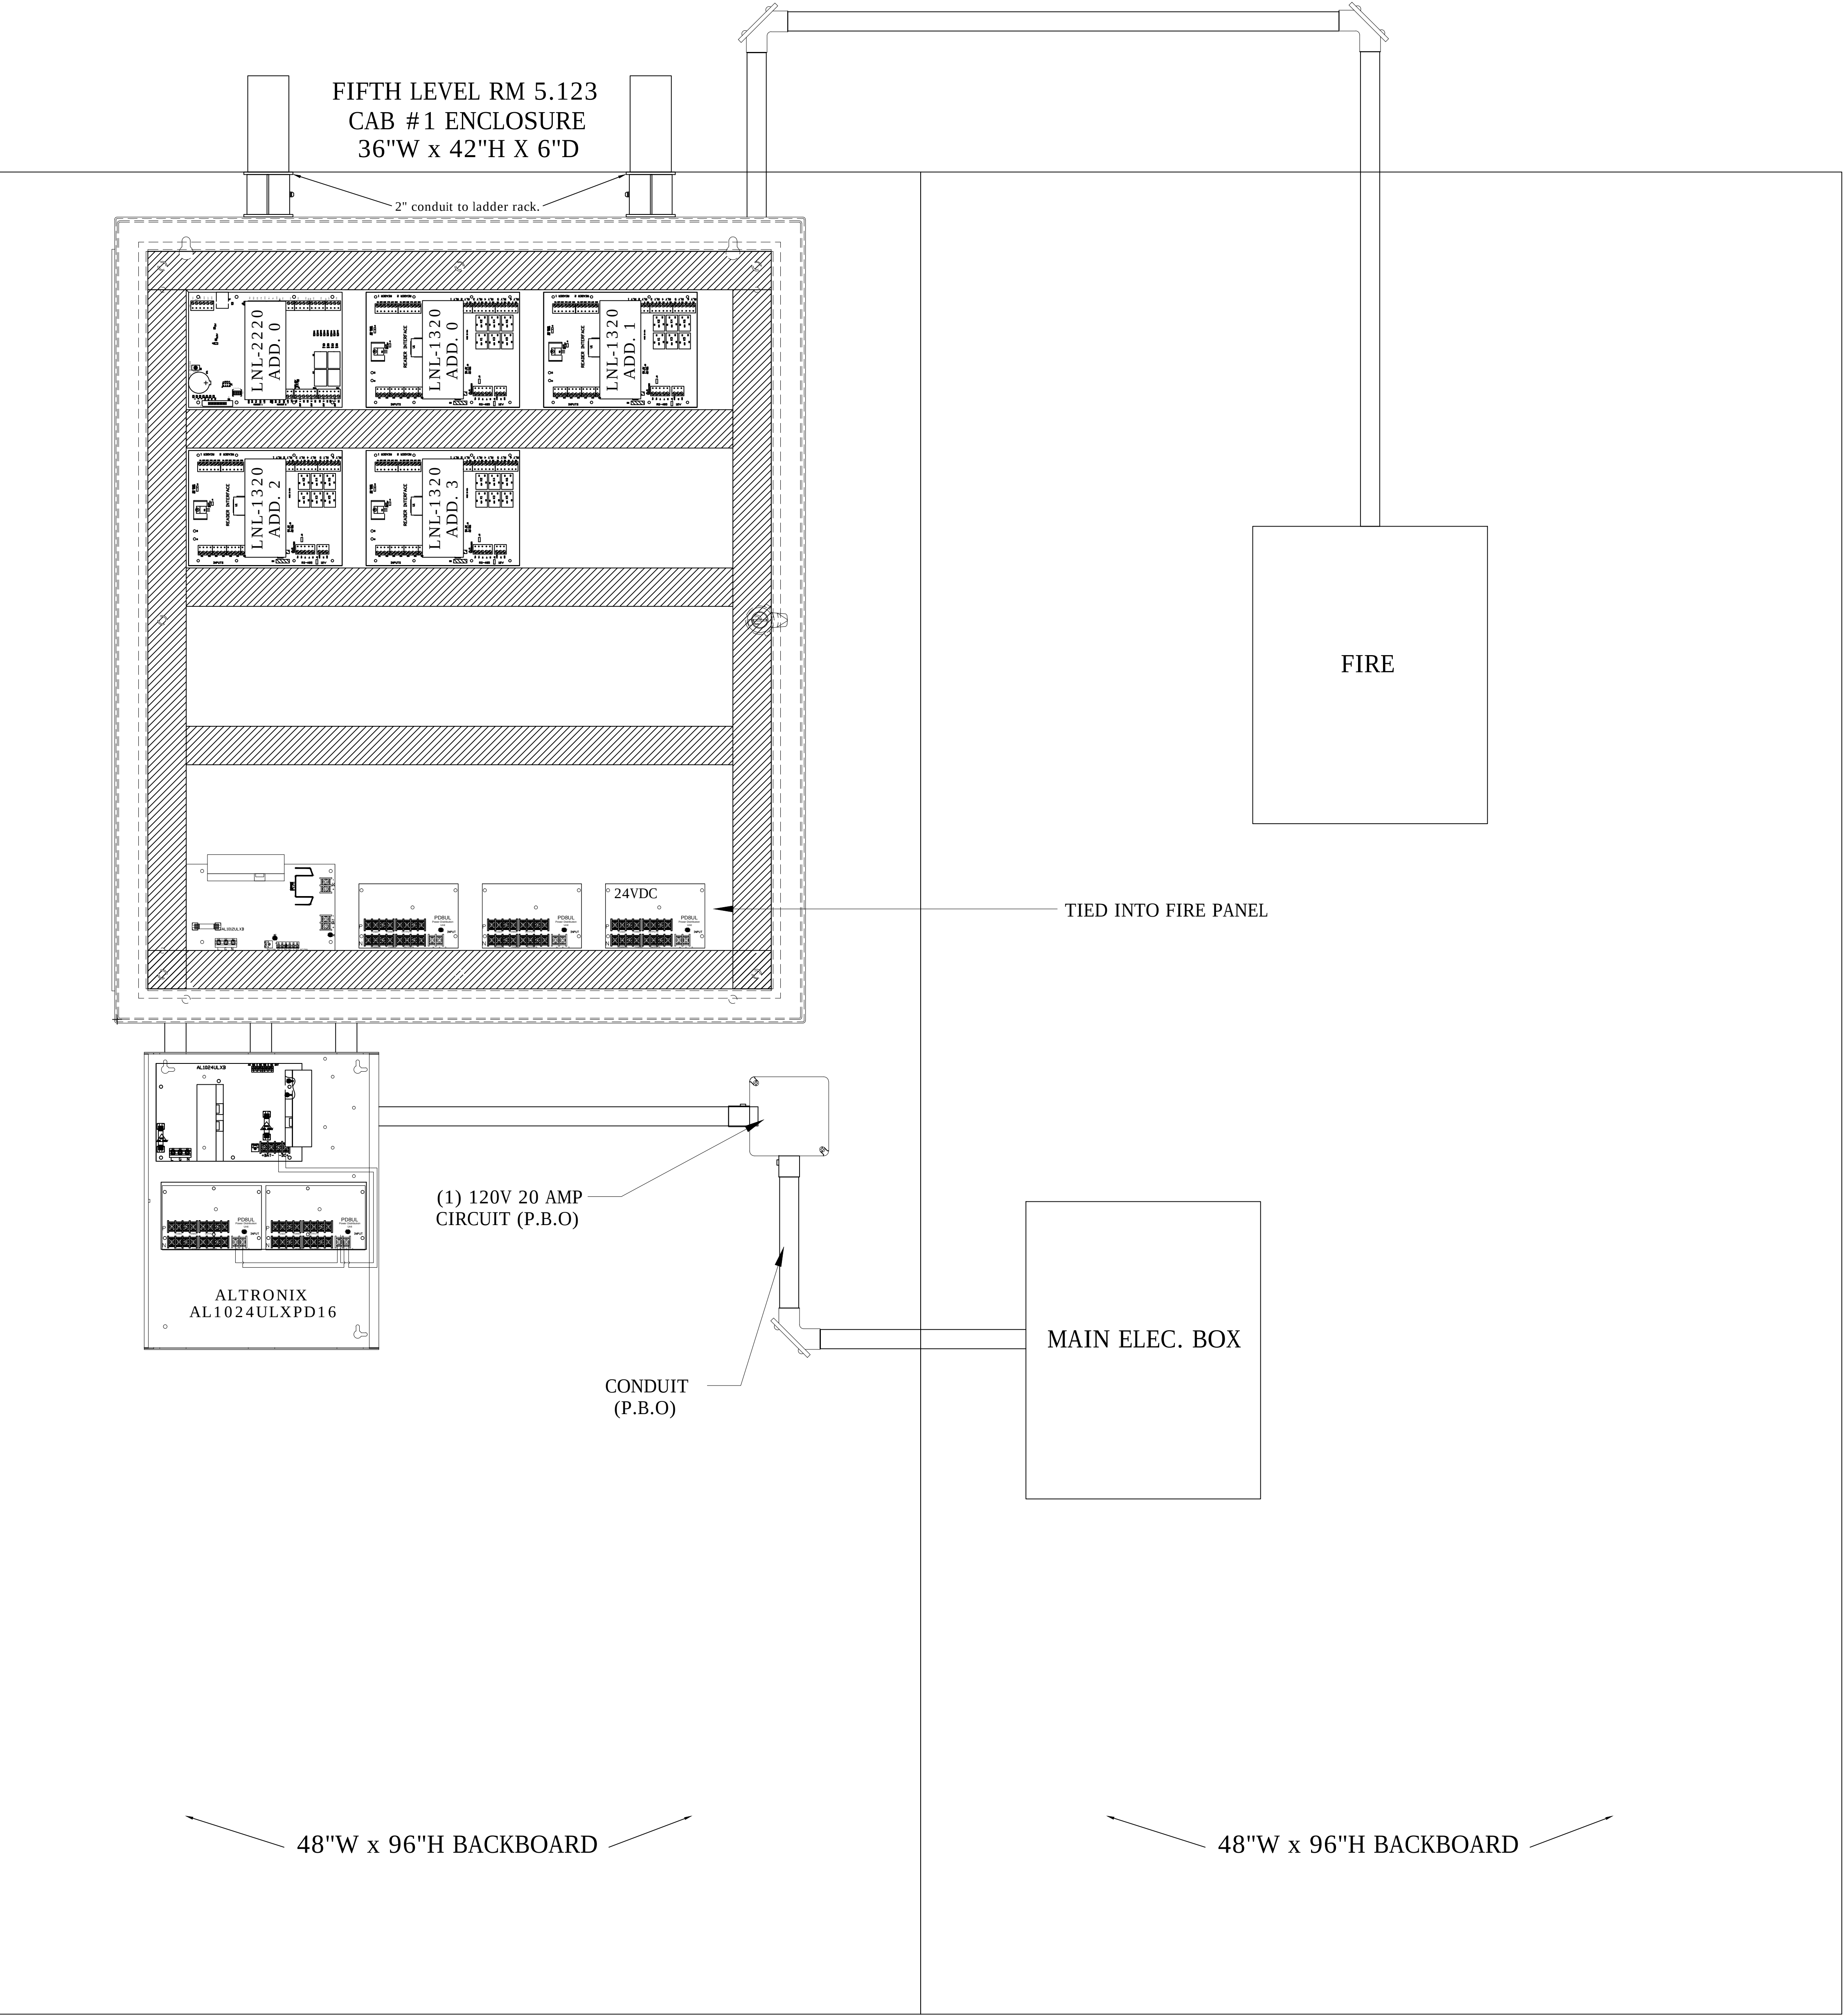

DRAWING PREPARED BY:



1511 E. ORANGETHORPE BLVD.
FULLERTON, CALIFORNIA 92831
714-525-4350 - o; 714-525-4386 - f
(c) Copyright 2012 KRATOS | HBE
All Rights Reserved.

MUST BE SIGNED BY HBE
TO AUTHENTICATE CONTENT(S).
ALL DETAILS CHECKED FOR ACCURACY.


SIGNATURE _____ DATE _____

HBE JOB #

CONFIDENTIAL

THE INFORMATION CONTAINED HERIN MAY
NOT BE USED OR REPRODUCED IN ANY
MANNER WITHOUT WRITTEN PERMISSION OF
KRATOS | HBE.

KEY PLAN

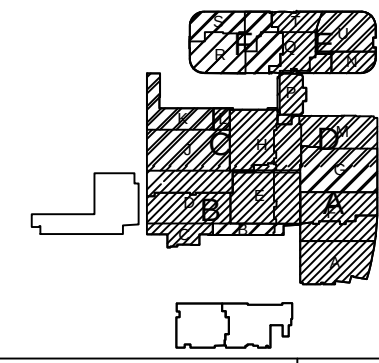

NO.	REV DESCRIPTION REV DATE	APPROVED BY
1.	AS BUILTS 08/15/2012	JOHN J. CHRISTIE

REV.	DESCRIPTION	APPROVED BY
------	-------------	-------------

CUSTOMER:




PROJECT:
CHOC CHILDREN'S
HOSPITAL
455 SOUTH MAIN ST.
ORANGE, CA 92668

DRAWING TITLE:
FIFTH LEVEL ACCESS
CONTROL PANEL
LAYOUT RM 5.123

DRN BY	DATE DRN	CHK BY	DATE CHK
JOSH G.	08/08/2012	JJC	
SCALE:	NTS		
DWG NO.	SE2.09		

ASBUILTS
08/15/2012

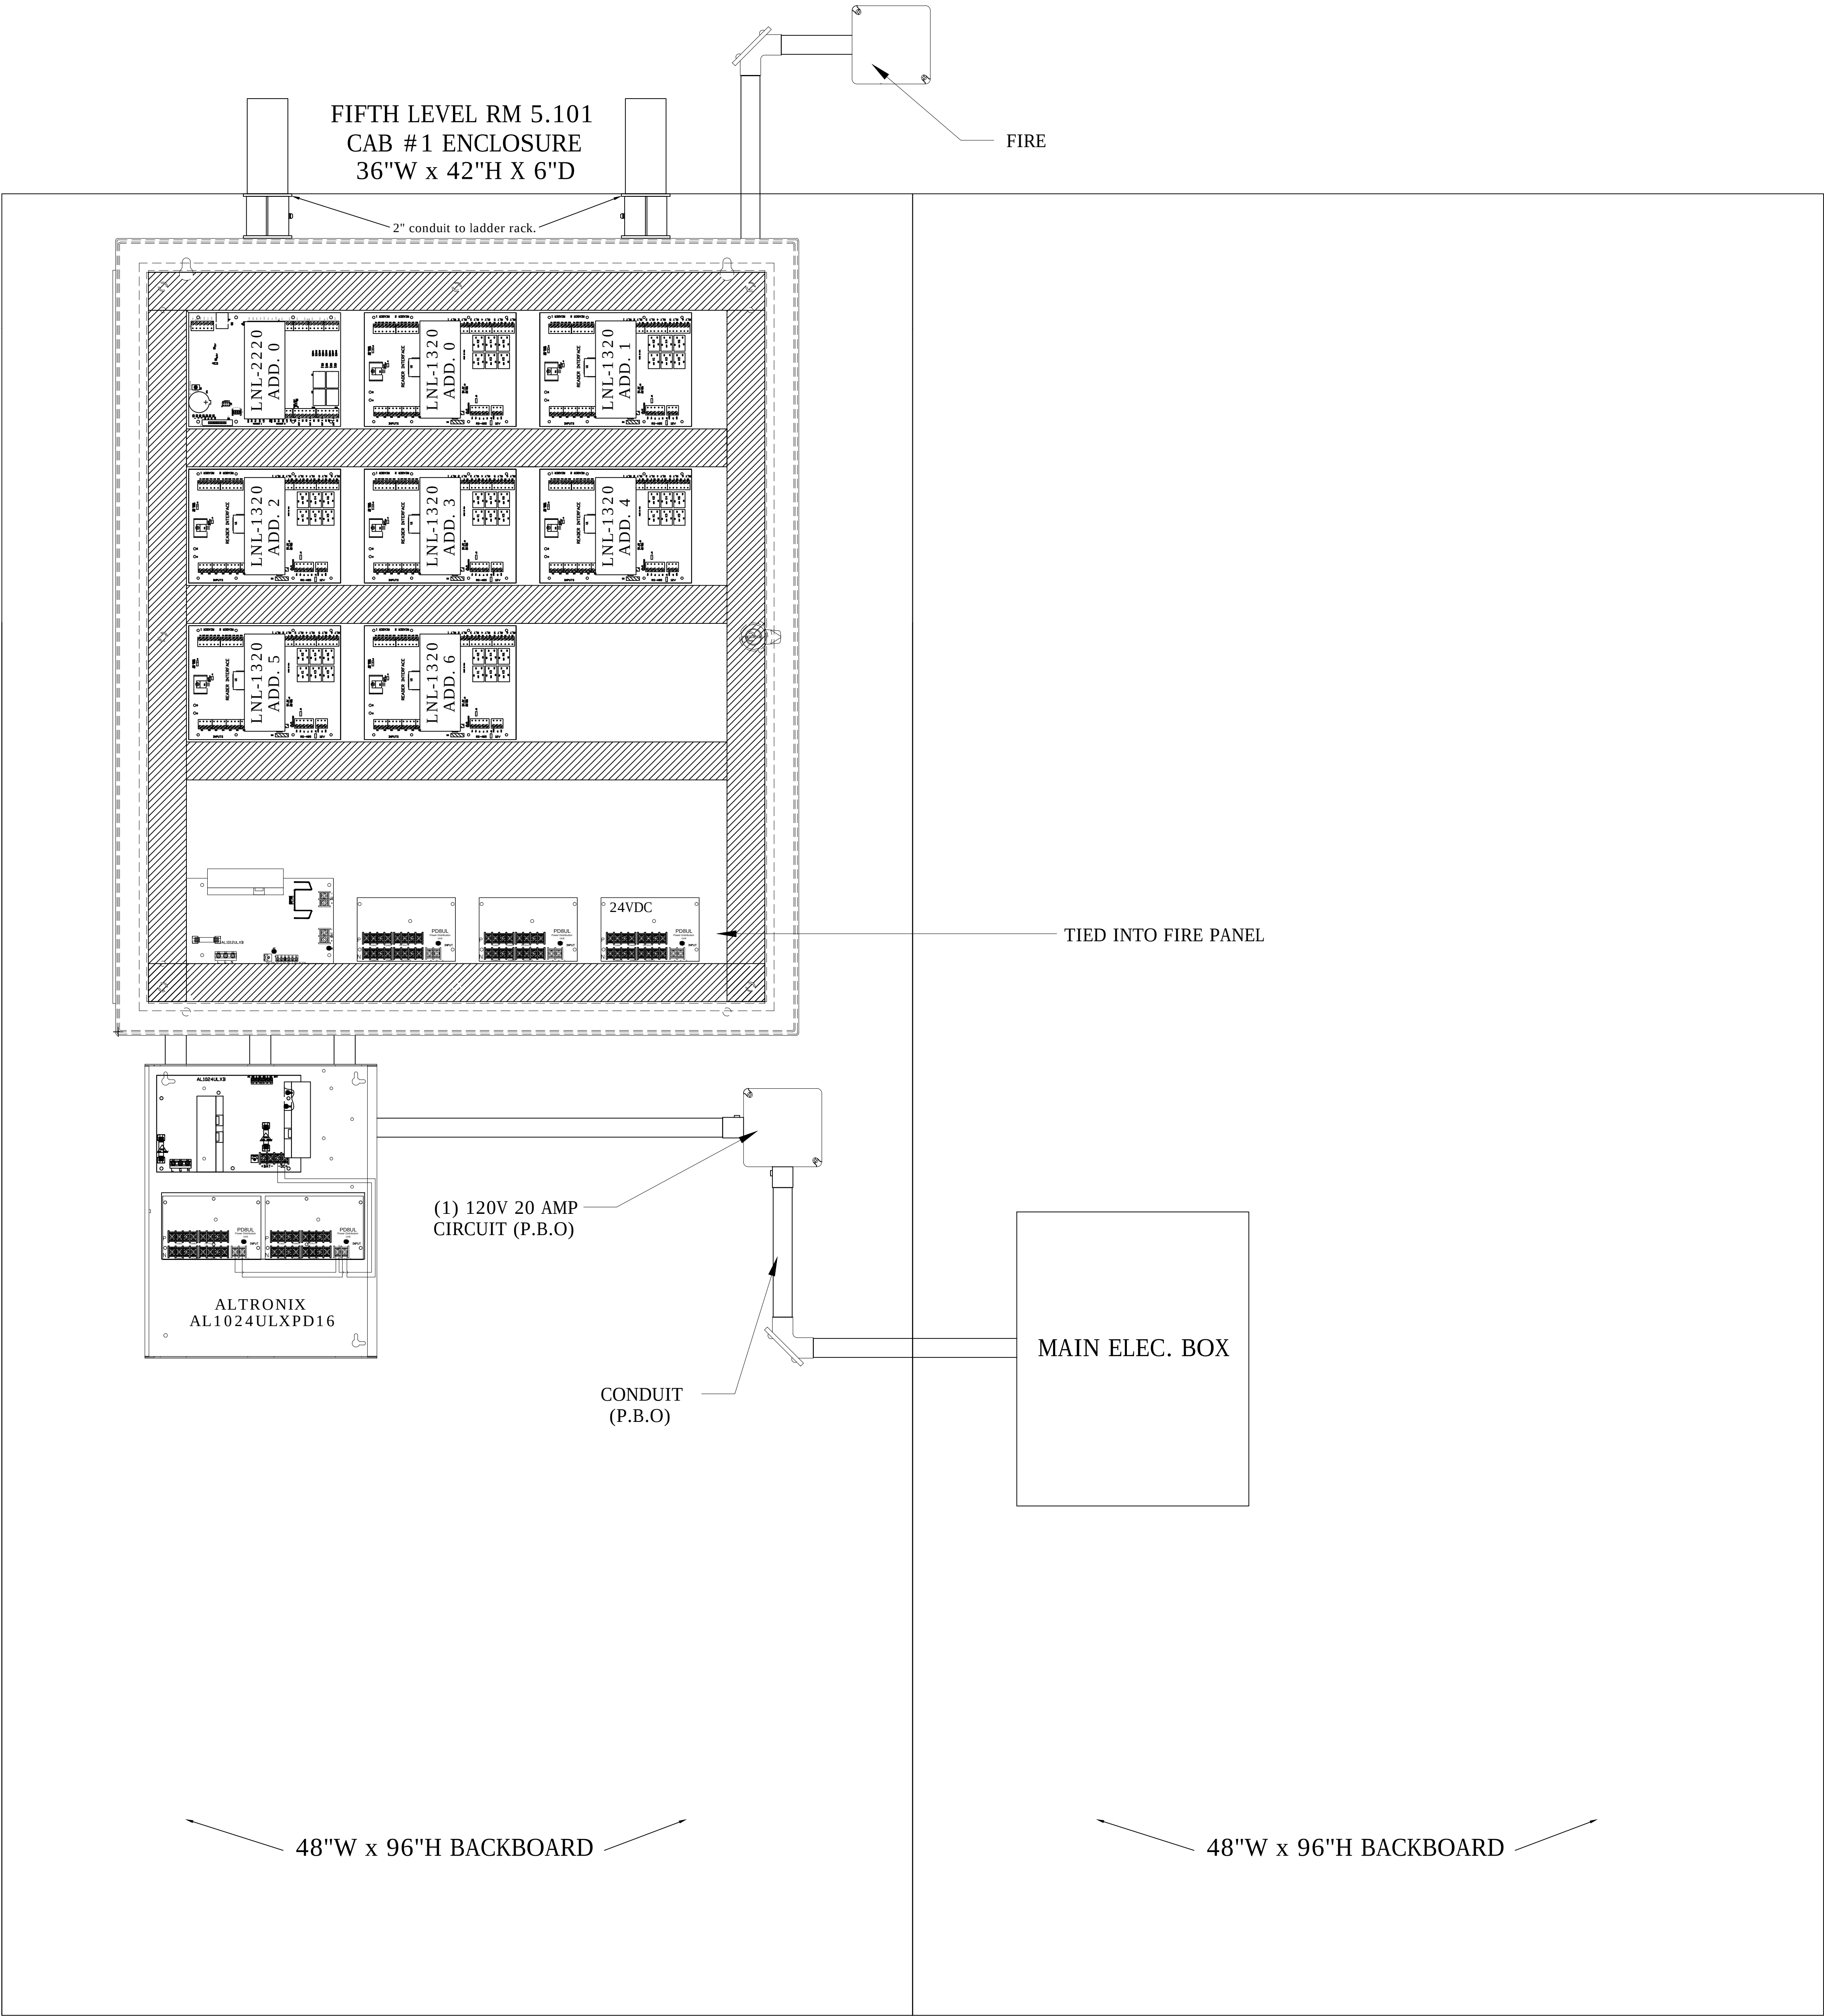

DRAWING PREPARED BY:



1511 E. ORANGETHORPE BLVD.
FULLERTON, CALIFORNIA 92831
714-525-4350 - o; 714-525-4386 - f
(c) Copyright 2012 KRATOS | HBE
All Rights Reserved.

MUST BE SIGNED BY HBE
TO AUTHENTICATE CONTENT(S).
ALL DETAILS CHECKED FOR ACCURACY.


SIGNATURE _____ DATE _____

HBE JOB #

CONFIDENTIAL

THE INFORMATION CONTAINED HEREIN MAY
NOT BE USED OR REPRODUCED IN ANY
MANNER WITHOUT WRITTEN PERMISSION OF
KRATOS | HBE.

KEY PLAN

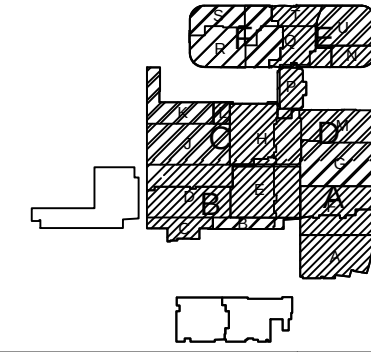

NO.	REV DESCRIPTION REV DATE	APPROVED BY
1.	AS BUILTS 08/15/2012	JOHN J. CHRISTIE

REV. DESCRIPTION APPROVED BY

CUSTOMER:



PROJECT:

CHOC CHILDREN'S
HOSPITAL
455 SOUTH MAIN ST.
ORANGE, CA 92668


DRAWING TITLE:

FIFTH LEVEL ACCESS
CONTROL PANEL
LAYOUT RM 5.101

DRN BY	DATE DRN	CHK BY	DATE CHK
JOSH G.	08/08/2012	JJC	
SCALE:	NTS		
DWG NO.	SE2.10		

ASBUILTS
08/15/2012

SIXTH LEVEL RM 6.121
CAB #1 ENCLOSURE
36"W x 42"H X 6"D

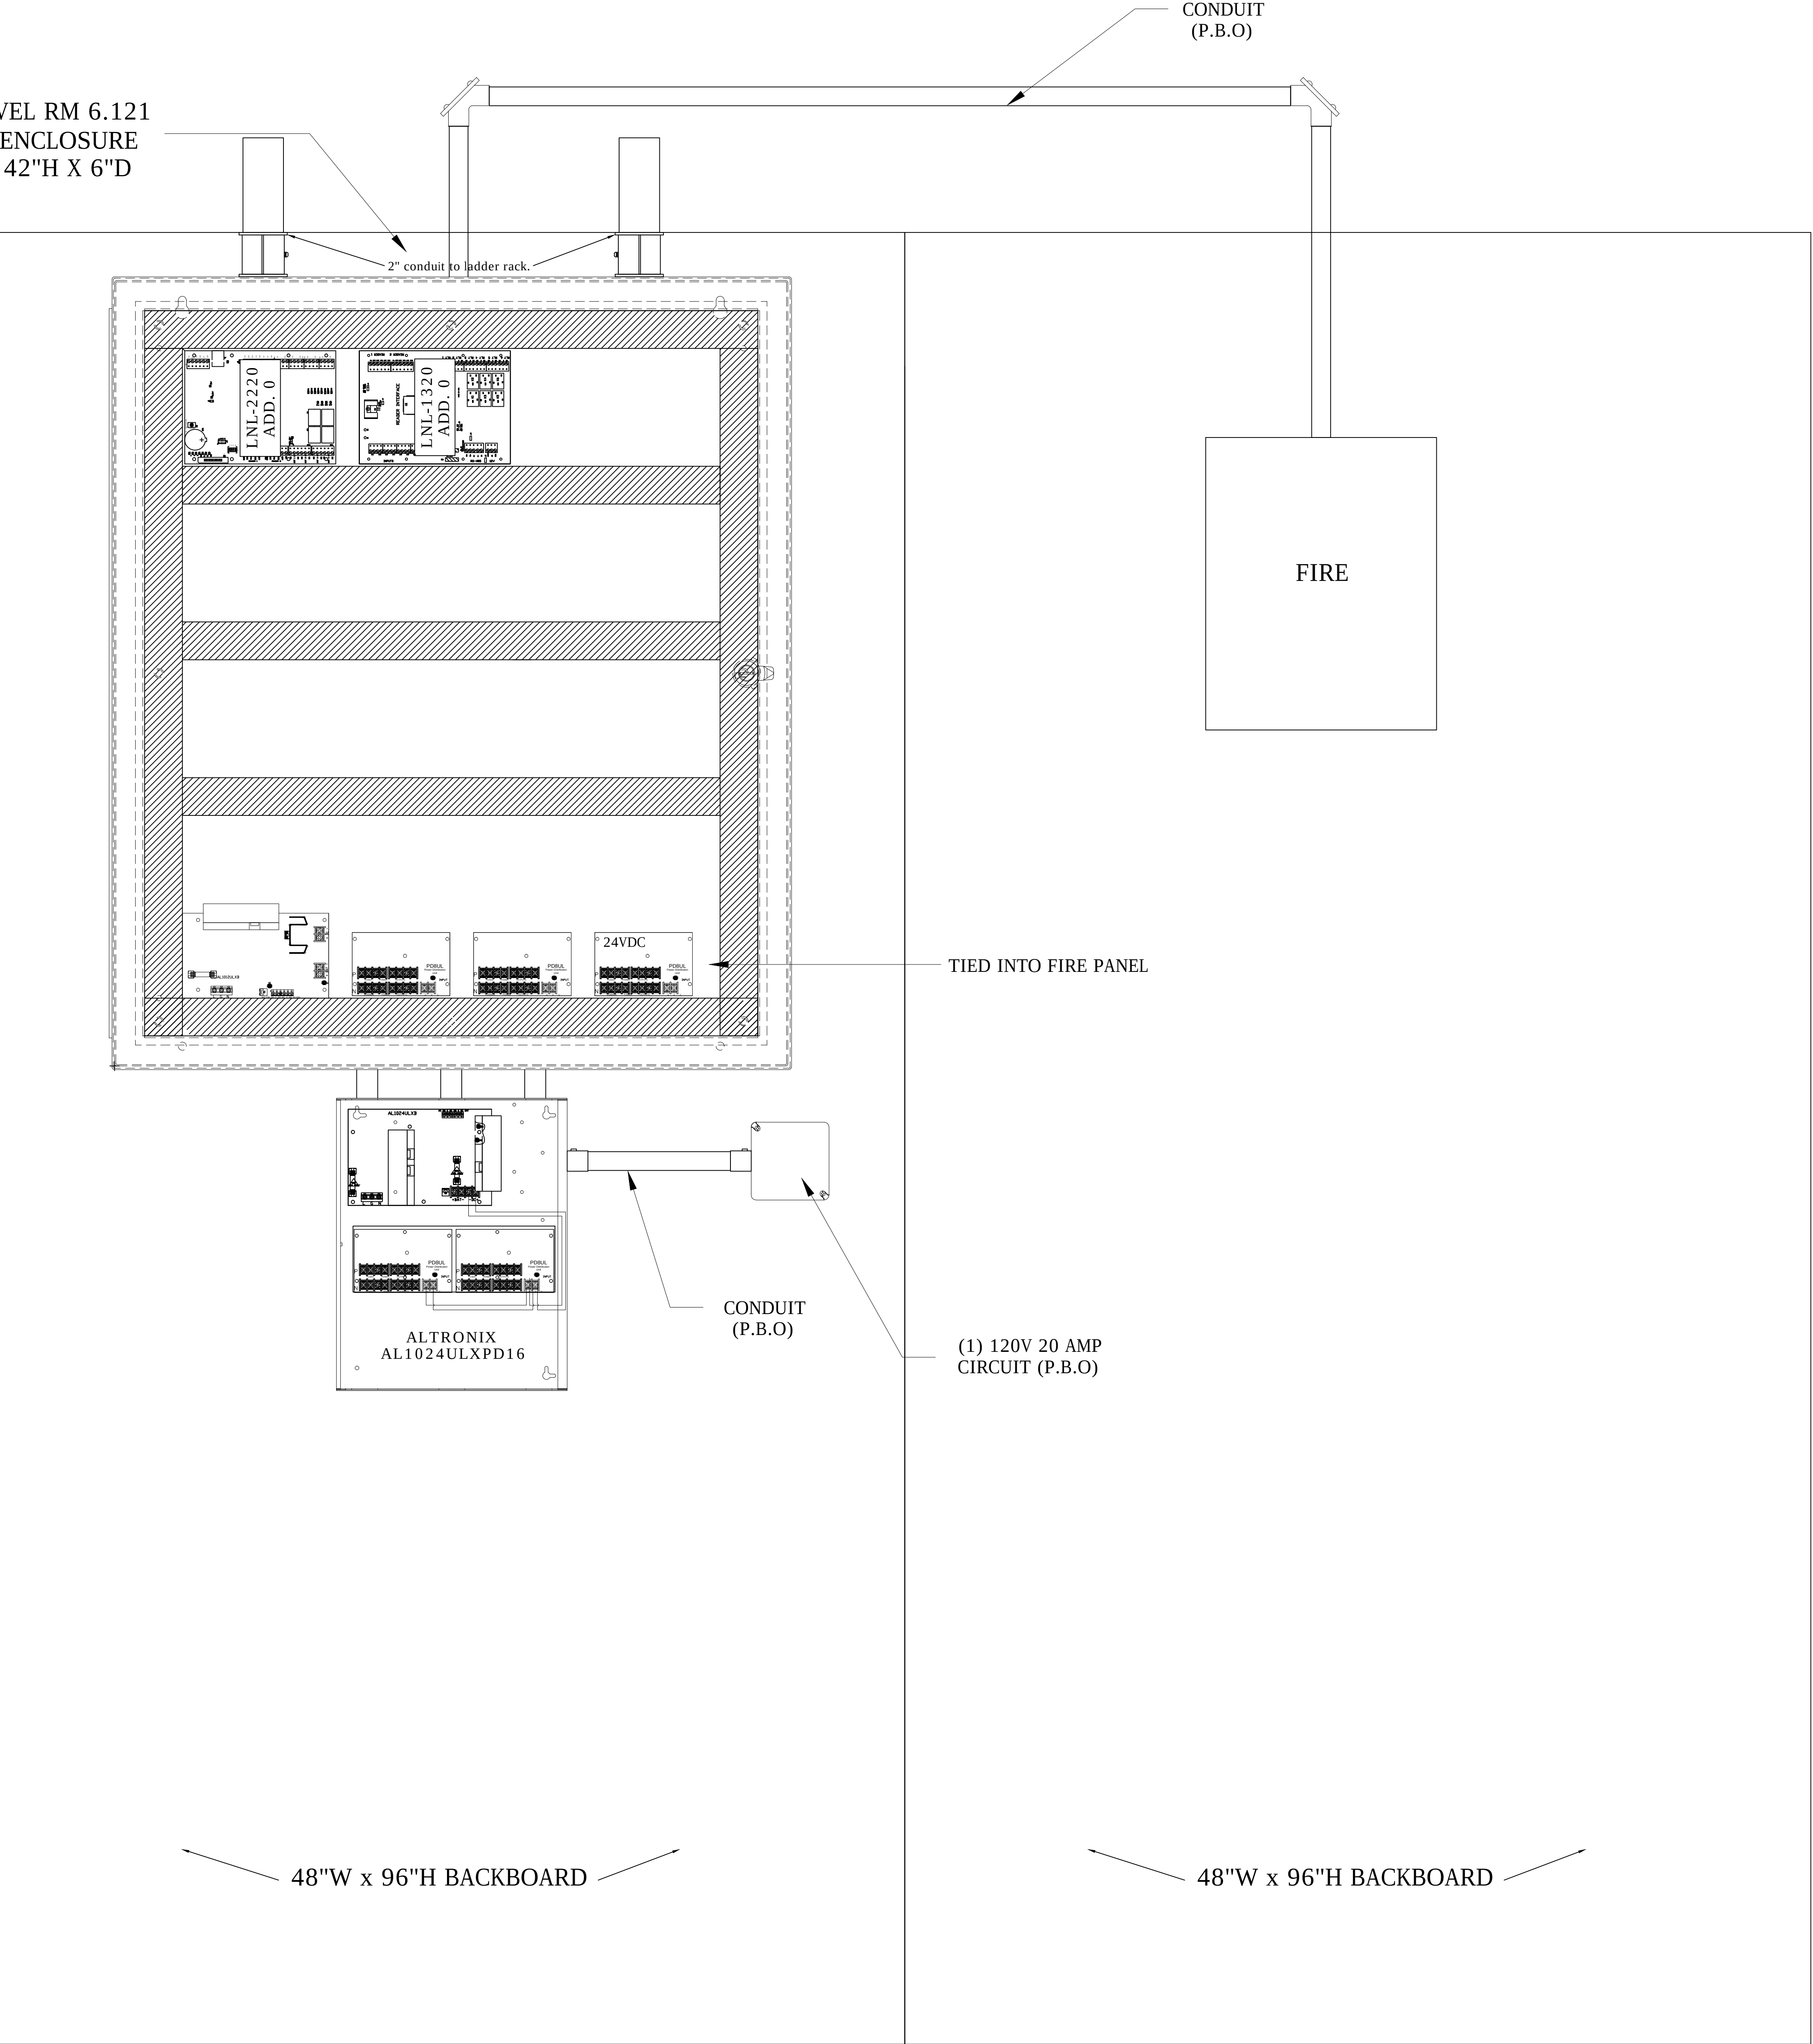

DRAWING PREPARED BY:



1511 E. ORANGETHORPE BLVD.
FULLERTON, CALIFORNIA 92831
714-525-4350 - o; 714-525-4386 - f
(c) Copyright 2012 KRATOS | HBE
All Rights Reserved.

MUST BE SIGNED BY HBE
TO AUTHENTICATE CONTENT(S).
ALL DETAILS CHECKED FOR ACCURACY.


SIGNATURE _____ DATE _____

HBE JOB #

CONFIDENTIAL

THE INFORMATION CONTAINED HEREIN MAY
NOT BE USED OR REPRODUCED IN ANY
MANNER WITHOUT WRITTEN PERMISSION OF
KRATOS | HBE.

KEY PLAN

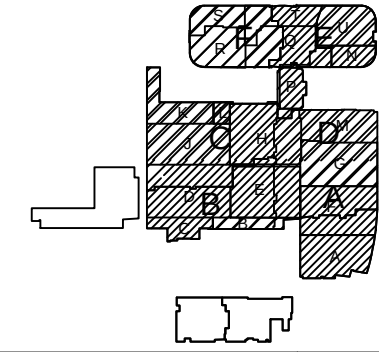

NO.	REV DESCRIPTION REV DATE	APPROVED BY
1.	AS BUILTS 08/15/2012	JOHN J. CHRISTIE

REV. DESCRIPTION APPROVED BY

CUSTOMER:




PROJECT:
CHOC CHILDREN'S
HOSPITAL
455 SOUTH MAIN ST.
ORANGE, CA 92668

DRAWING TITLE:
SIXTH LEVEL ACCESS
CONTROL PANEL
LAYOUT RM 6.121

DRN BY	DATE DRN	CHK BY	DATE CHK
JOSH G.	08/08/2012	JJC	
SCALE:	NTS		
DWG NO.	SE2.11		

ASBUILTS
08/15/2012

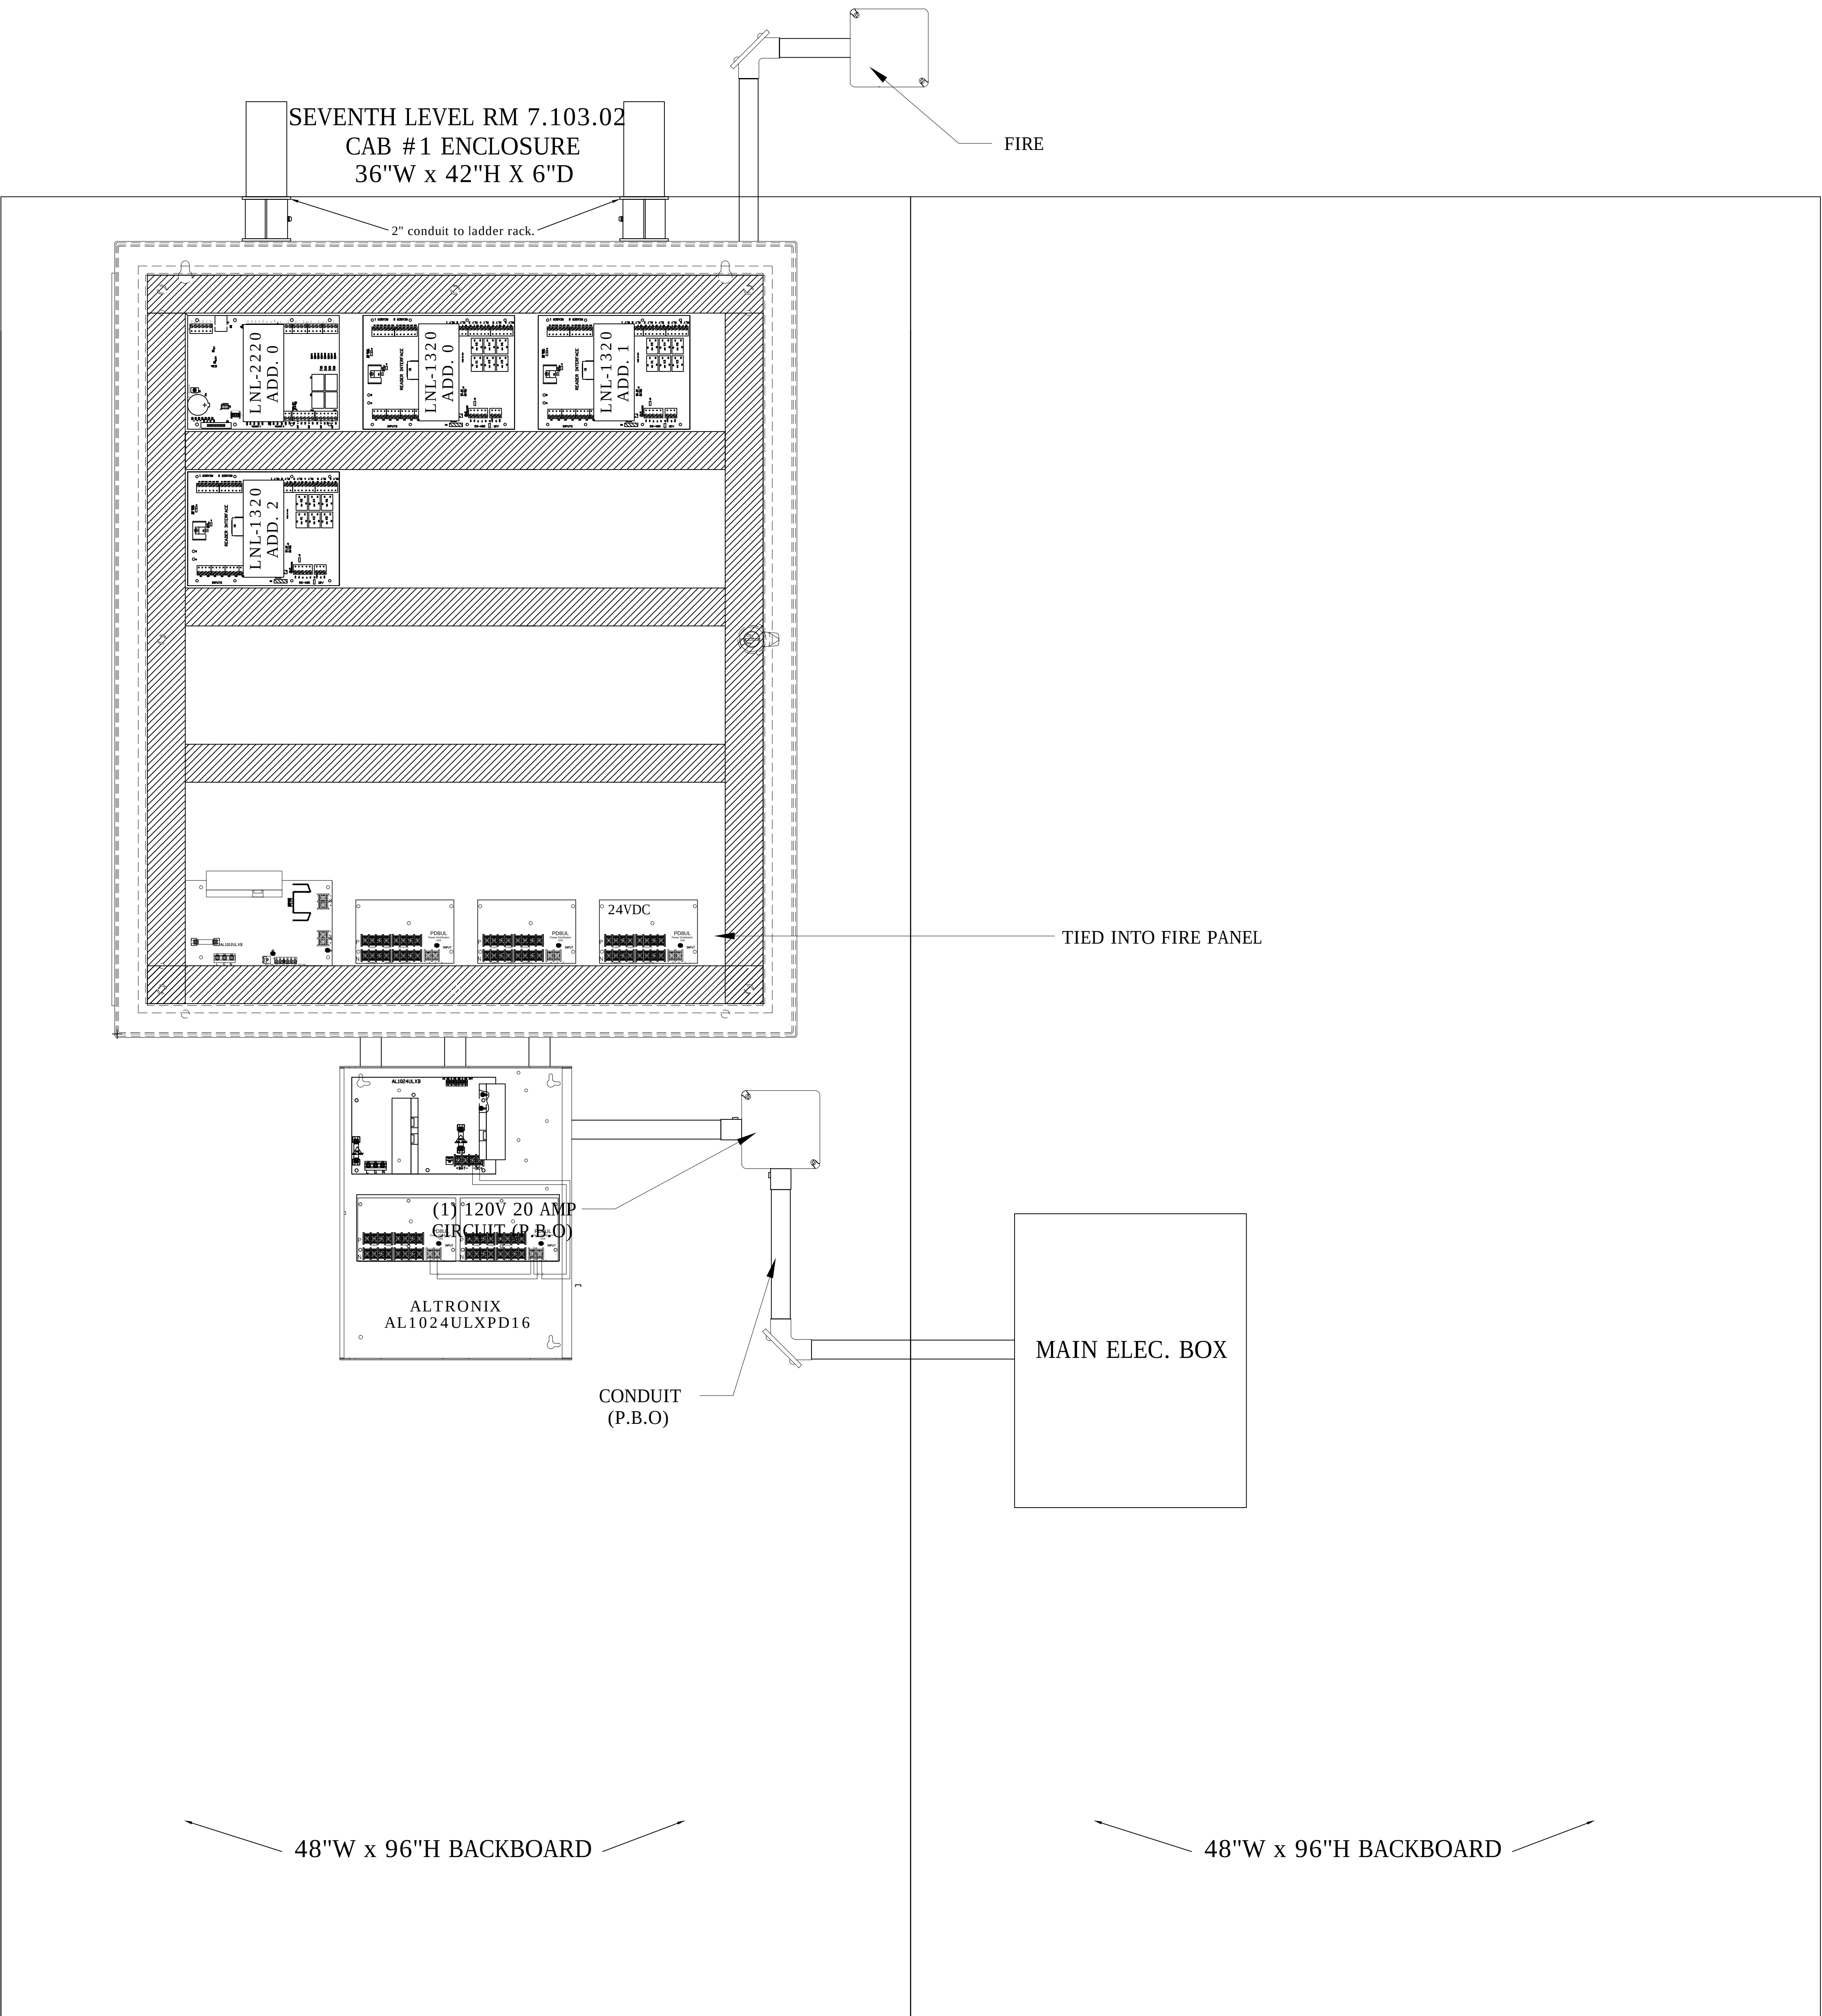

DRAWING PREPARED BY:



1511 E. ORANGETHORPE BLVD.
FULLERTON, CALIFORNIA 92831
714-525-4350 - o; 714-525-4386 - f
(c) Copyright 2012 KRATOS | HBE
All Rights Reserved.

MUST BE SIGNED BY HBE
TO AUTHENTICATE CONTENT(S).
ALL DETAILS CHECKED FOR ACCURACY.


SIGNATURE _____ DATE _____

HBE JOB #

CONFIDENTIAL

THE INFORMATION CONTAINED HERIN MAY
NOT BE USED OR REPRODUCED IN ANY
MANNER WITHOUT WRITTEN PERMISSION OF
KRATOS | HBE.

KEY PLAN

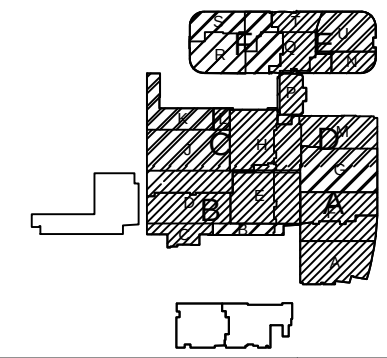

NO.	REV DESCRIPTION REV DATE	APPROVED BY
1.	AS BUILTS 08/15/2012	JOHN J. CHRISTIE

REV. DESCRIPTION APPROVED BY

CUSTOMER:




PROJECT:
CHOC CHILDREN'S
HOSPITAL
455 SOUTH MAIN ST.
ORANGE, CA 92668

DRAWING TITLE:
SEVENTH LEVEL ACCESS
CONTROL PANEL
LAYOUT RM 7.103.02


DRN BY	DATE DRN	CHK BY	DATE CHK
JOSH G.	08/08/2012	JJC	
SCALE:	NTS		
DWG NO.	SE2.12		

ASBUILTS
08/15/2012

1 CCTV POINT TO POINT ROOM B.062
NO SCALE

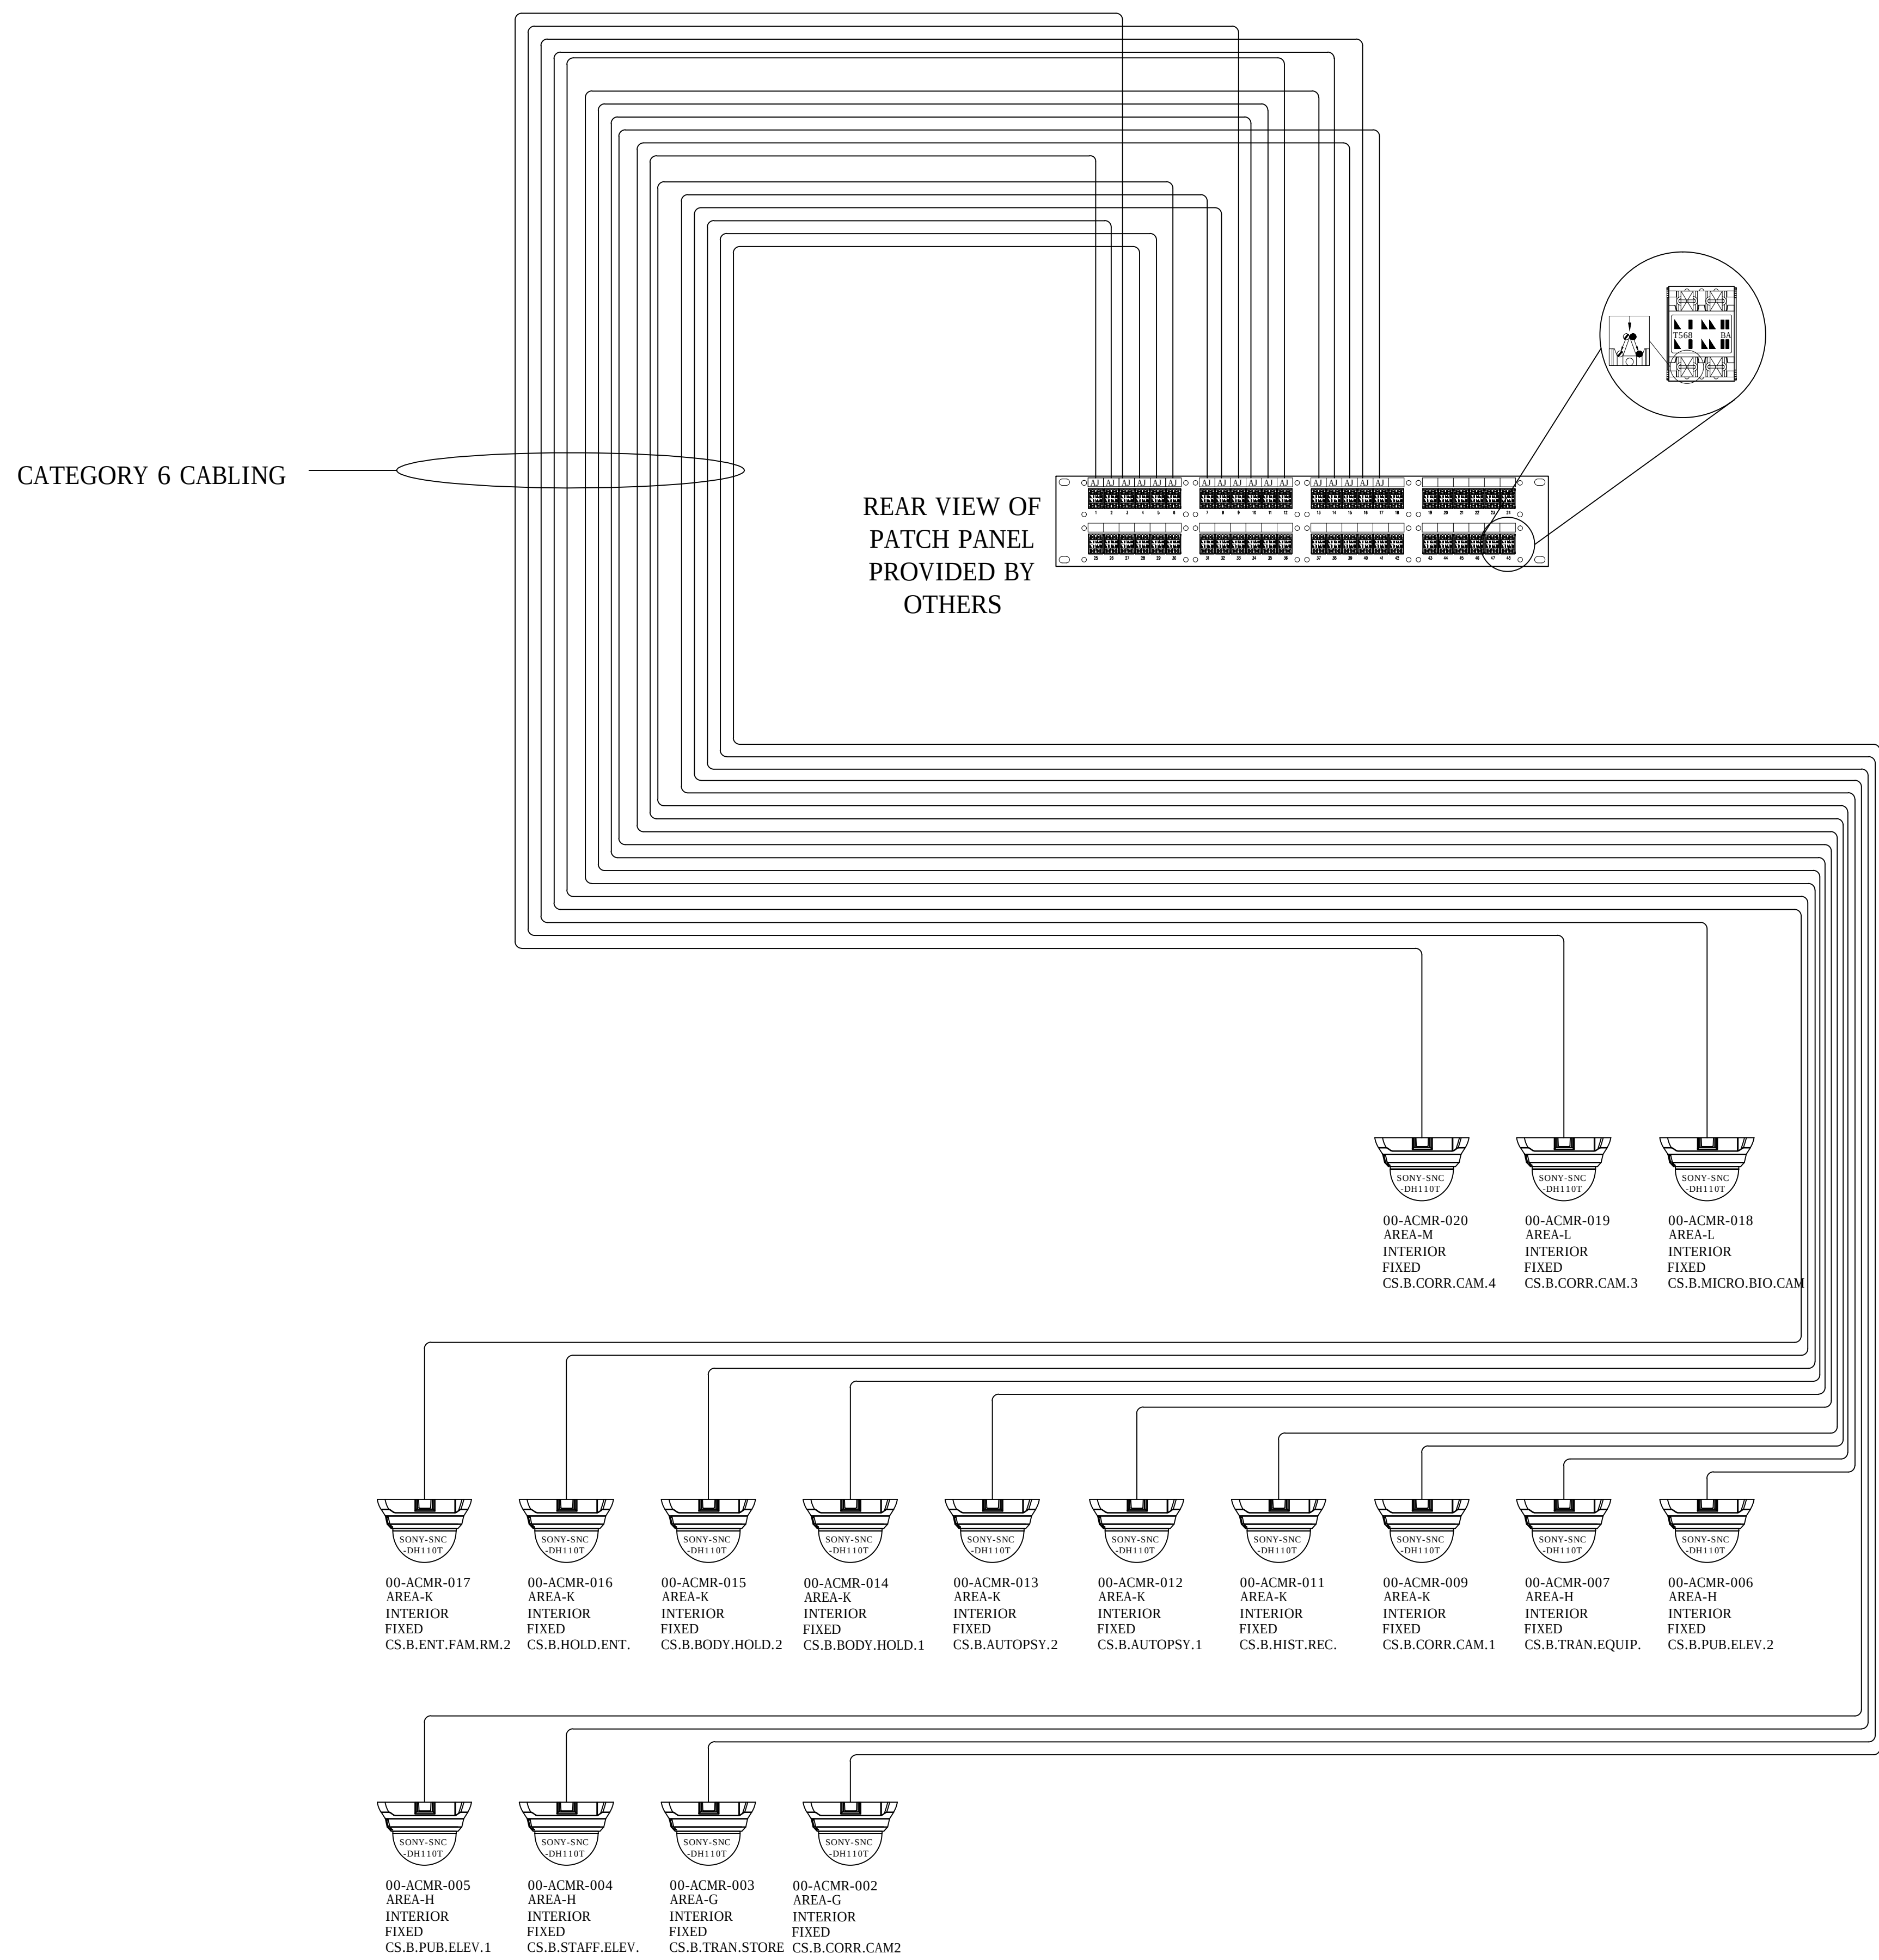

Pin outs	T568B	
5	WHITE/BLUE	T1
4	BLUE	R1
3	WHITE/GREEN	T3
6	GREEN	R3
1	WHITE/ORANGE	T2
2	ORANGE	R2
7	WHITE/BROWN	T4
8	BROWN	R4

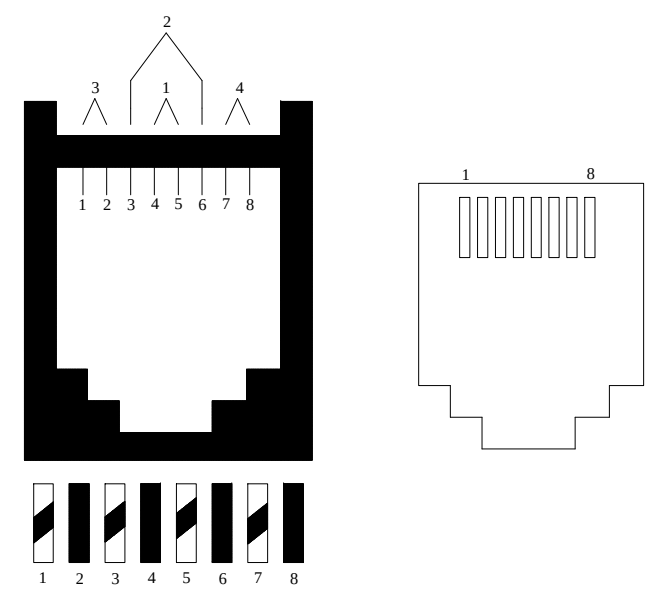

ASBUILTS
08/15/2012

DRAWING PREPARED BY:

KRATOS
HBE

1511 E. ORANGETHORPE BLVD.
FULLERTON, CALIFORNIA 92831
714-525-4350 - o; 714-525-4386 - f
(c) Copyright 2012 KRATOS | HBE
All Rights Reserved.

MUST BE SIGNED BY HBE
TO AUTHENTICATE CONTENT(S).
ALL DETAILS CHECKED FOR ACCURACY.


SIGNATURE _____ DATE _____

HBE JOB #

CONFIDENTIAL

THE INFORMATION CONTAINED HERIN MAY
NOT BE USED OR REPRODUCED IN ANY
MANNER WITHOUT WRITTEN PERMISSION OF
KRATOS | HBE.

KEY PLAN

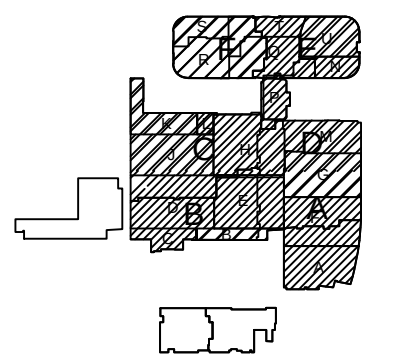

NO.	REV DESCRIPTION REV DATE	APPROVED BY
1.	AS BUILTS 08/15/2012	JOHN J. CHRISTIE

REV. DESCRIPTION APPROVED BY

CUSTOMER:

CHOC
Children's Hospital
of Orange County

PROJECT:

CHOC CHILDREN'S
HOSPITAL
455 SOUTH MAIN ST.
ORANGE, CA 92668

DRAWING TITLE:

LOWER LEVEL CCTV POINT
TO POINT DIAGRAM RM
B.062

DRN BY	DATE DRN	CHK BY	DATE CHK
JOSH G.	08/08/2012	JJC	
SCALE:	NTS		
DWG NO.	SE4.00		

2 CCTV POINT TO POINT ROOM B.028
NO SCALE

CATEGORY 6 CABLEING


REAR VIEW OF
PATCH PANEL
PROVIDED BY
OTHERS

00-ACMR-010
AREA-K
INTERIOR
FIXED
CS.B.ENT.FAM.RM.1

00-ACMR-008
AREA-J
INTERIOR
FIXED
CS.B.TEACH.ROOM

00-ACMR-001
AREA-C
INTERIOR
FIXED
CS.B.MECH.CAM.1

Pin outs	T568B	
5	WHITE/BLUE	T1
4	BLUE	R1
3	WHITE/GREEN	T3
6	GREEN	R3
1	WHITE/ORANGE	T2
2	ORANGE	R2
7	WHITE/BROWN	T4
8	BROWN	R4

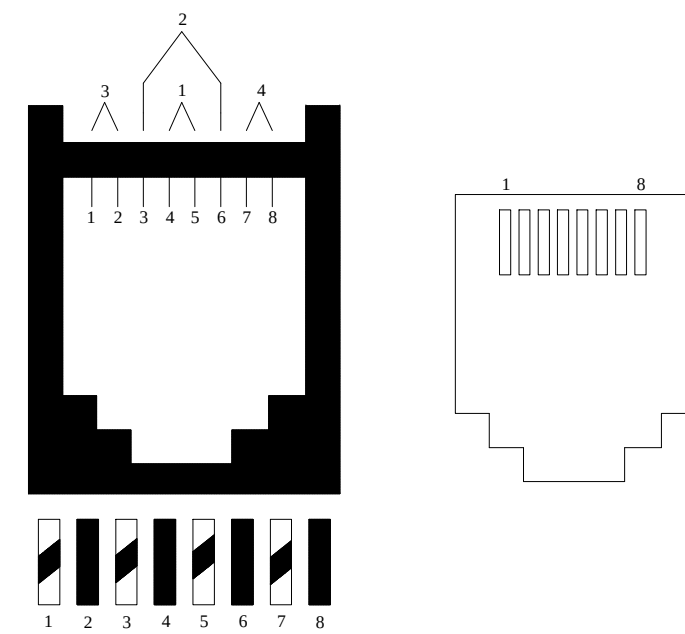

FRONT VIEW OF
PATCH PANEL
PROVIDED BY
OTHERS

24-PORT NETWORK
POE SWITCH
PROVIDED BY OTHERS

FACTORY MADE
PATCH CABLES

DRAWING PREPARED BY:

KRATOS
HBE

1511 E. ORANGETHORPE BLVD.
FULLERTON, CALIFORNIA 92831
714-525-4350 - o; 714-525-4386 - f
(c) Copyright 2012 KRATOS | HBE
All Rights Reserved.

MUST BE SIGNED BY HBE
TO AUTHENTICATE CONTENT(S).
ALL DETAILS CHECKED FOR ACCURACY.


SIGNATURE _____ DATE _____

HBE JOB #

CONFIDENTIAL

THE INFORMATION CONTAINED HERIN MAY
NOT BE USED OR REPRODUCED IN ANY
MANNER WITHOUT WRITTEN PERMISSION OF
KRATOS | HBE.

KEY PLAN

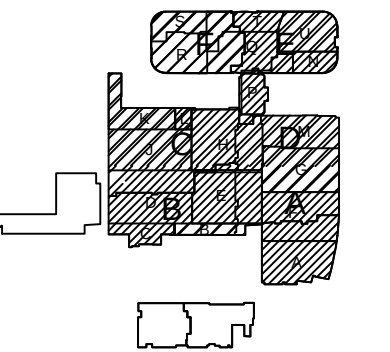

NO.	REV DESCRIPTION REV DATE	APPROVED BY
1.	AS BUILTS 08/15/2012	JOHN J. CHRISTIE

REV. DESCRIPTION APPROVED BY

CUSTOMER:

CHOC
Children's Hospital
of Orange County

PROJECT:


CHOC CHILDREN'S
HOSPITAL
455 SOUTH MAIN ST.
ORANGE, CA 92668

DRAWING TITLE:


LOWER LEVEL CCTV POINT
TO POINT DIAGRAM RM
B.028

DRN BY	DATE DRN	CHK BY	DATE CHK
JOSH G.	08/08/2012	JJC	
SCALE:	NTS		
DWG NO.	SE4.01		

ASBUILTS
08/15/2012

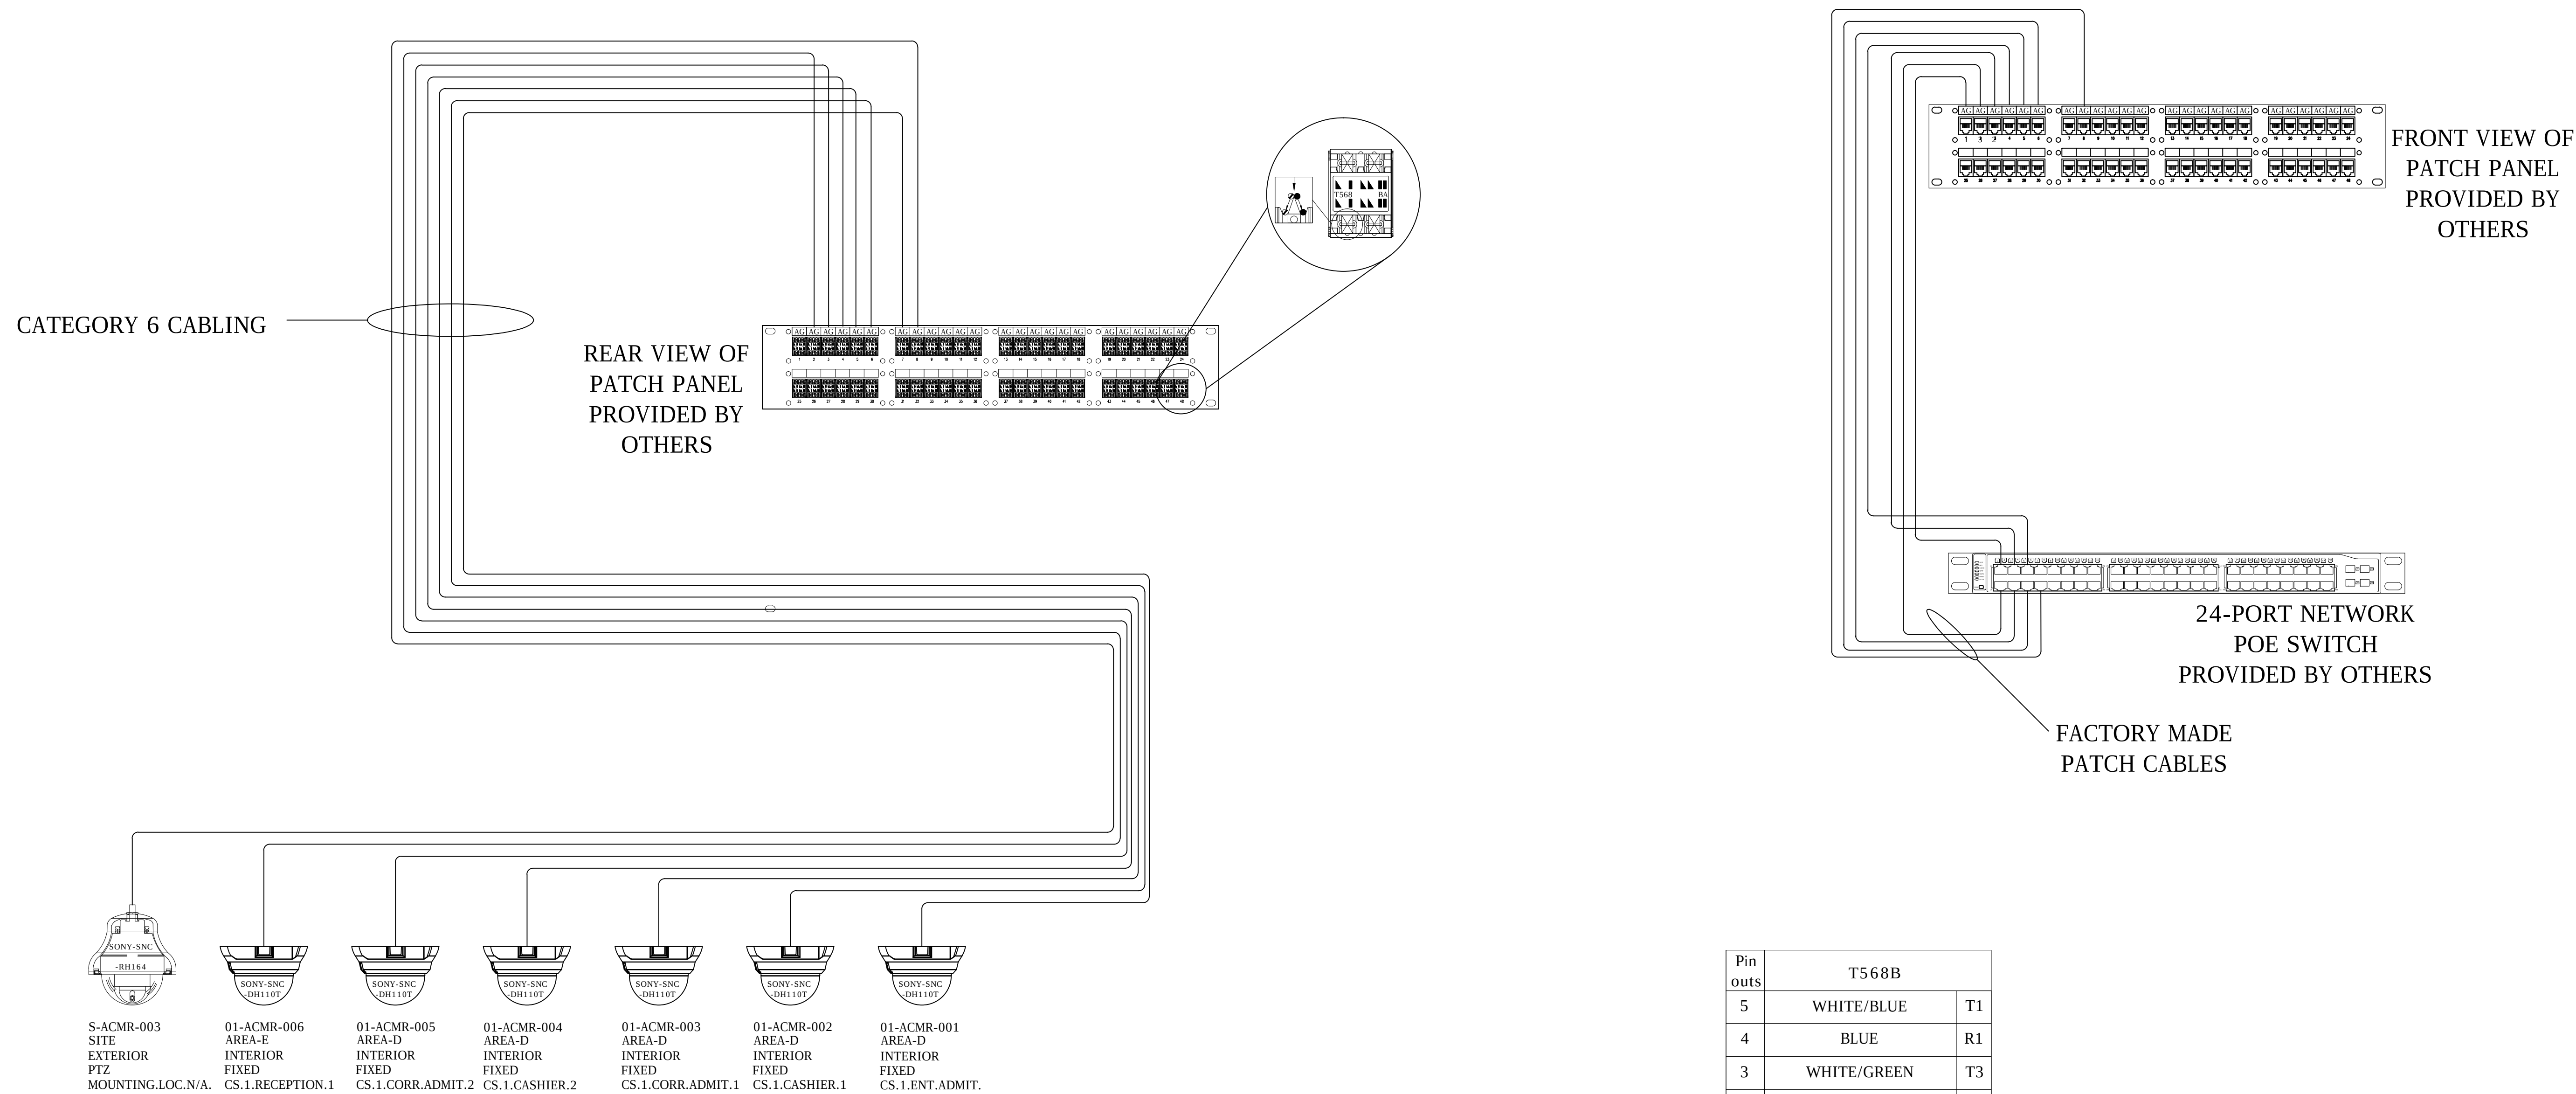

Pin outs	T568B	
5	WHITE/BLUE	T1
4	BLUE	R1
3	WHITE/GREEN	T3
6	GREEN	R3
1	WHITE/ORANGE	T2
2	ORANGE	R2
7	WHITE/BROWN	T4
8	BROWN	R4

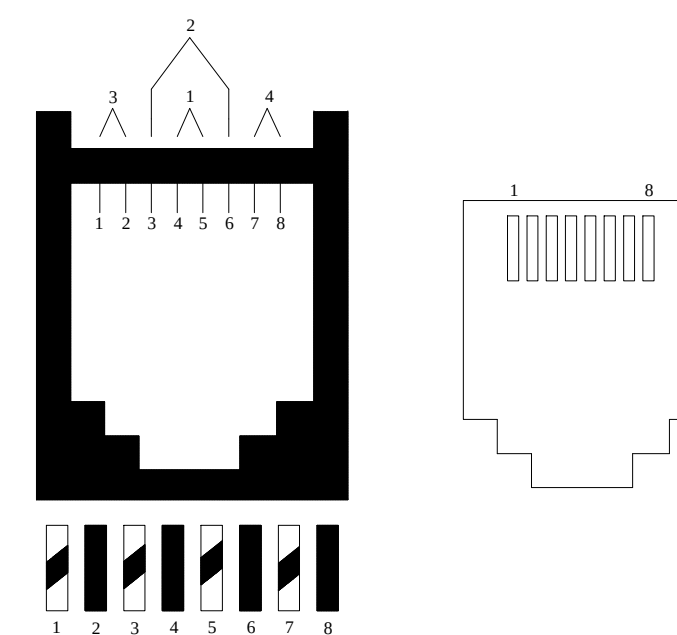

DRAWING PREPARED BY:

KRATOS
HBE

1511 E. ORANGETHORPE BLVD.
FULLERTON, CALIFORNIA 92831
714-525-4350 - o; 714-525-4386 - f
(c) Copyright 2012 KRATOS | HBE
All Rights Reserved.

MUST BE SIGNED BY HBE
TO AUTHENTICATE CONTENT(S).
ALL DETAILS CHECKED FOR ACCURACY.


SIGNATURE _____ DATE _____

HBE JOB #

CONFIDENTIAL

THE INFORMATION CONTAINED HERIN MAY
NOT BE USED OR REPRODUCED IN ANY
MANNER WITHOUT WRITTEN PERMISSION OF
KRATOS | HBE.

KEY PLAN

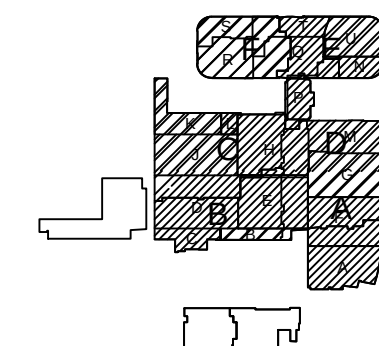

NO.	REV DESCRIPTION REV DATE	APPROVED BY
1.	AS BUILTS 08/15/2012	JOHN J. CHRISTIE

REV.	DESCRIPTION	APPROVED BY
------	-------------	-------------

CUSTOMER:



CHOC
Children's Hospital
of Orange County

PROJECT:
CHOC CHILDREN'S
HOSPITAL
455 SOUTH MAIN ST.
ORANGE, CA 92668


DRAWING TITLE:
FIRST LEVEL CCTV POINT
TO POINT DIAGRAM RM
1.016

DRN BY	DATE DRN	CHK BY	DATE CHK
JOSH G.	08/08/2012	JJC	
SCALE:	NTS		
DWG NO.	SF4.02		

ASBUILTS
08/15/2012

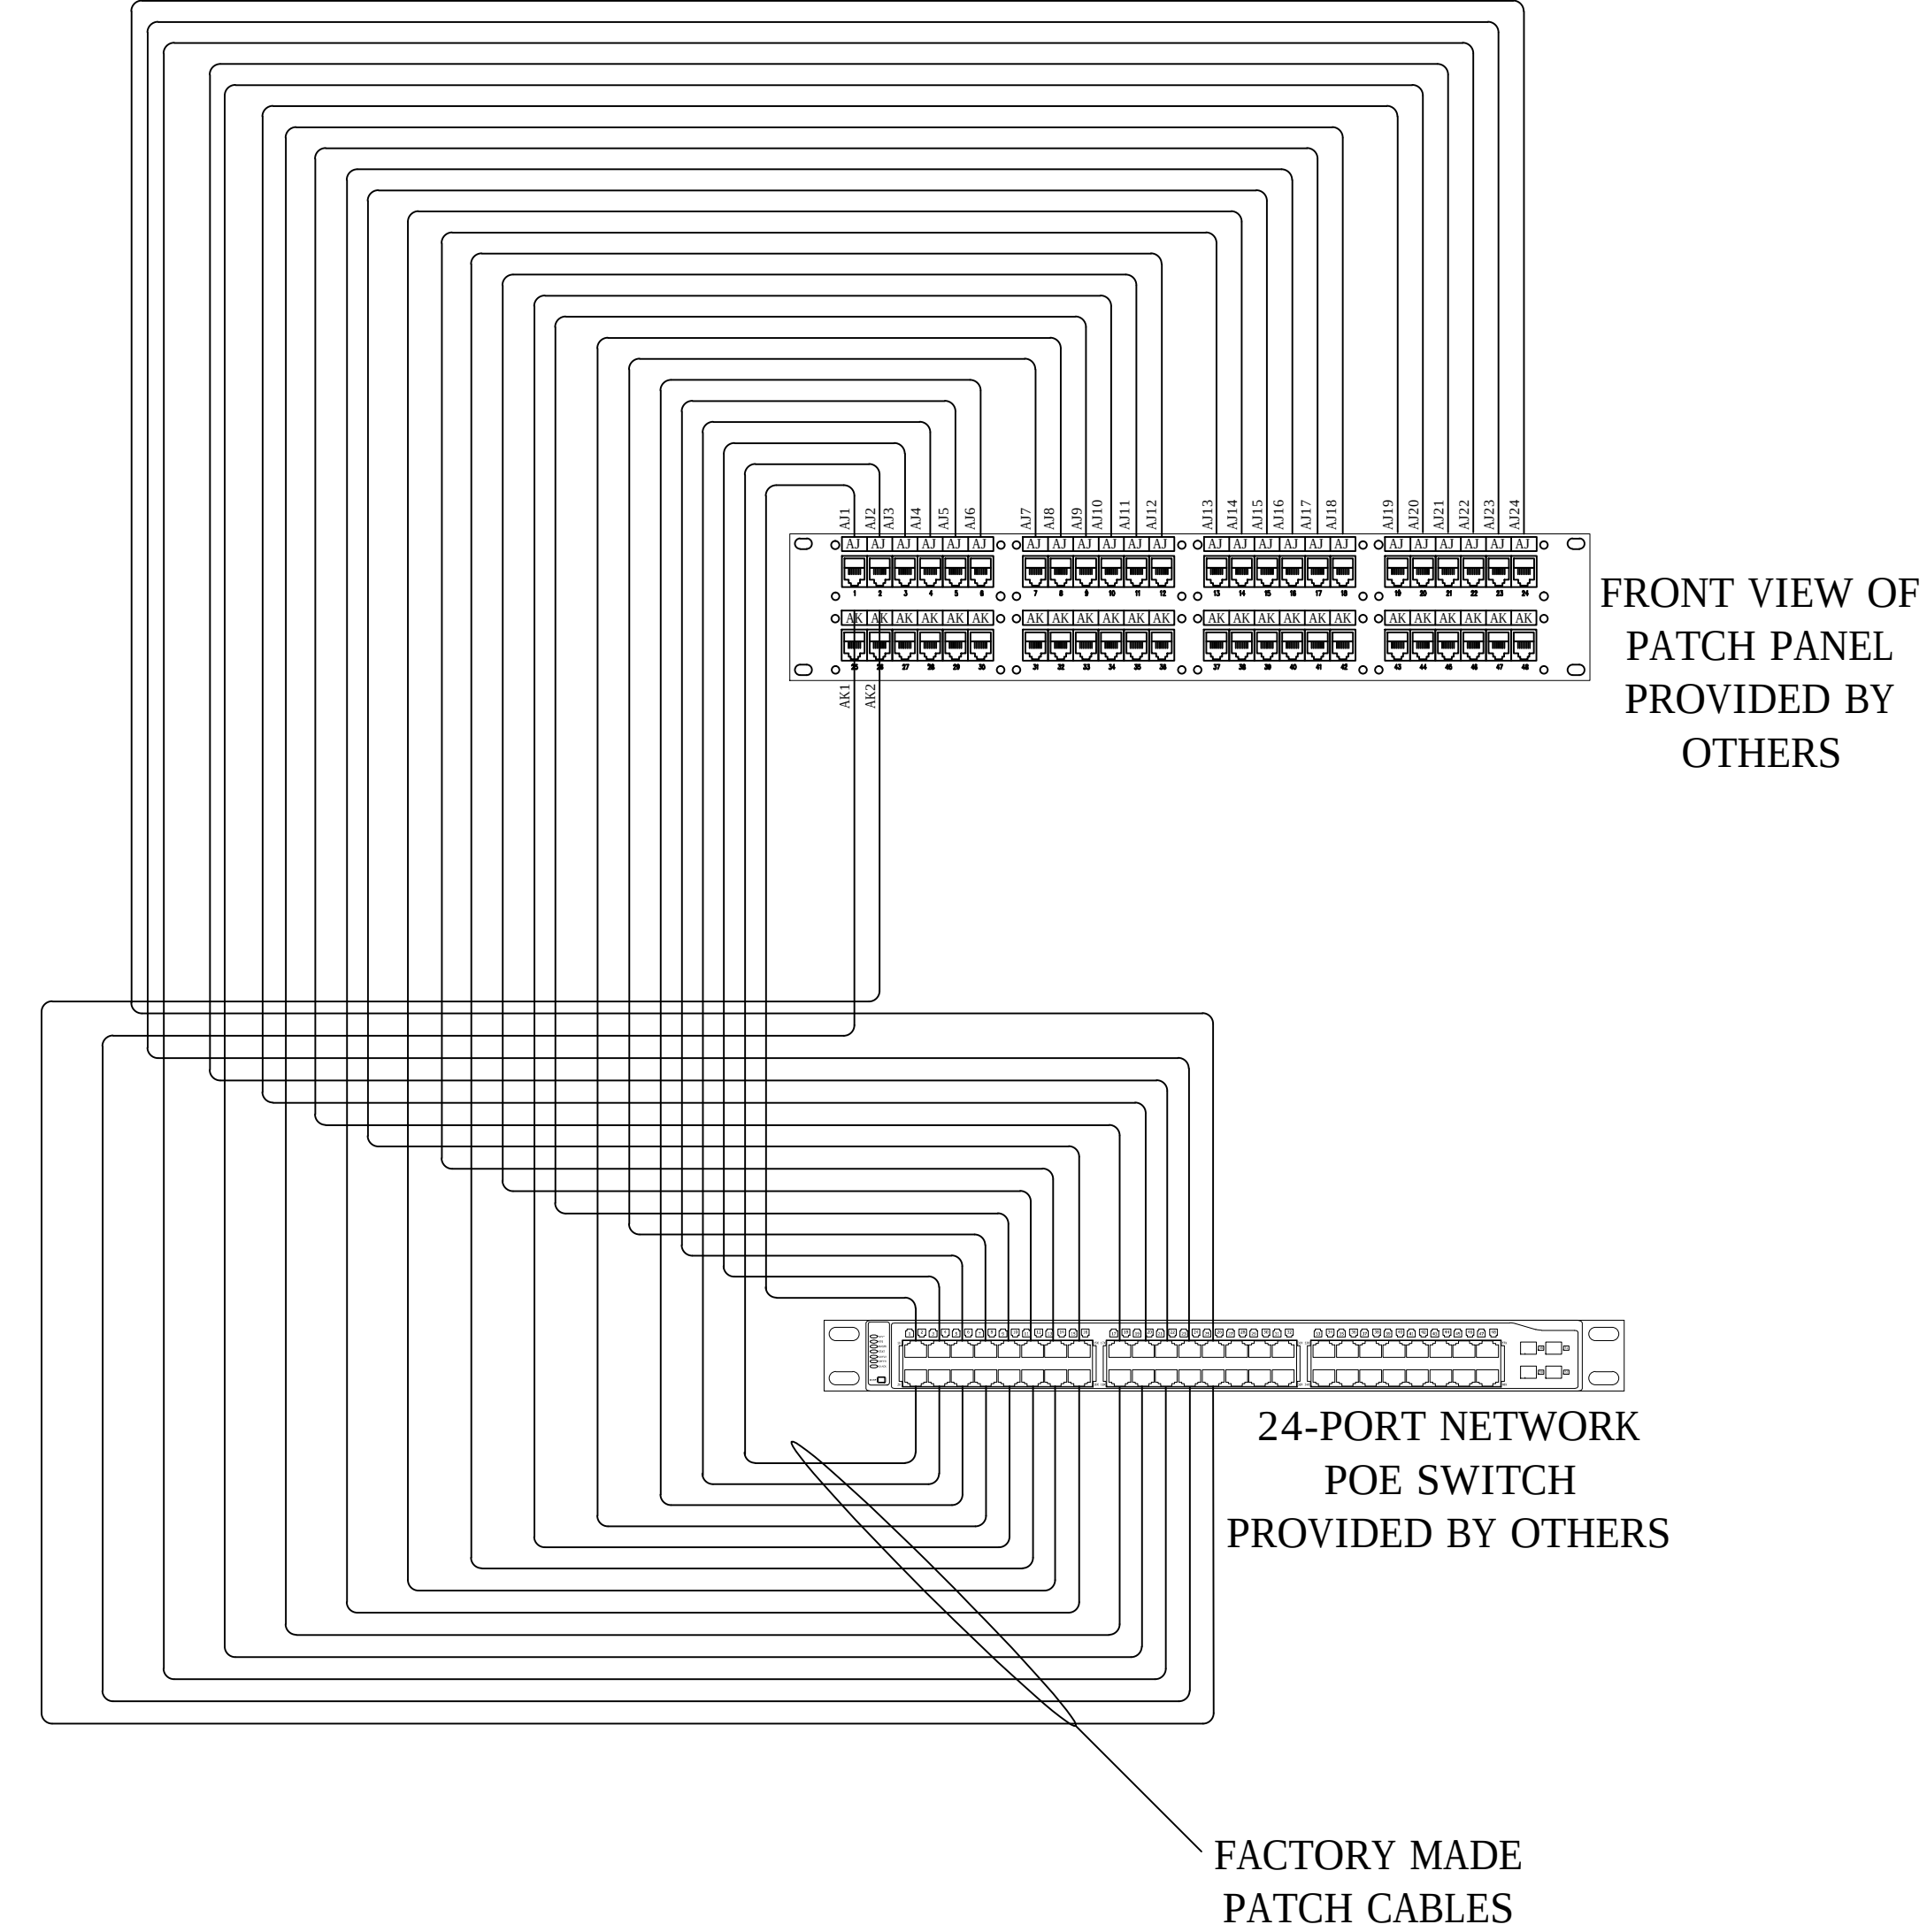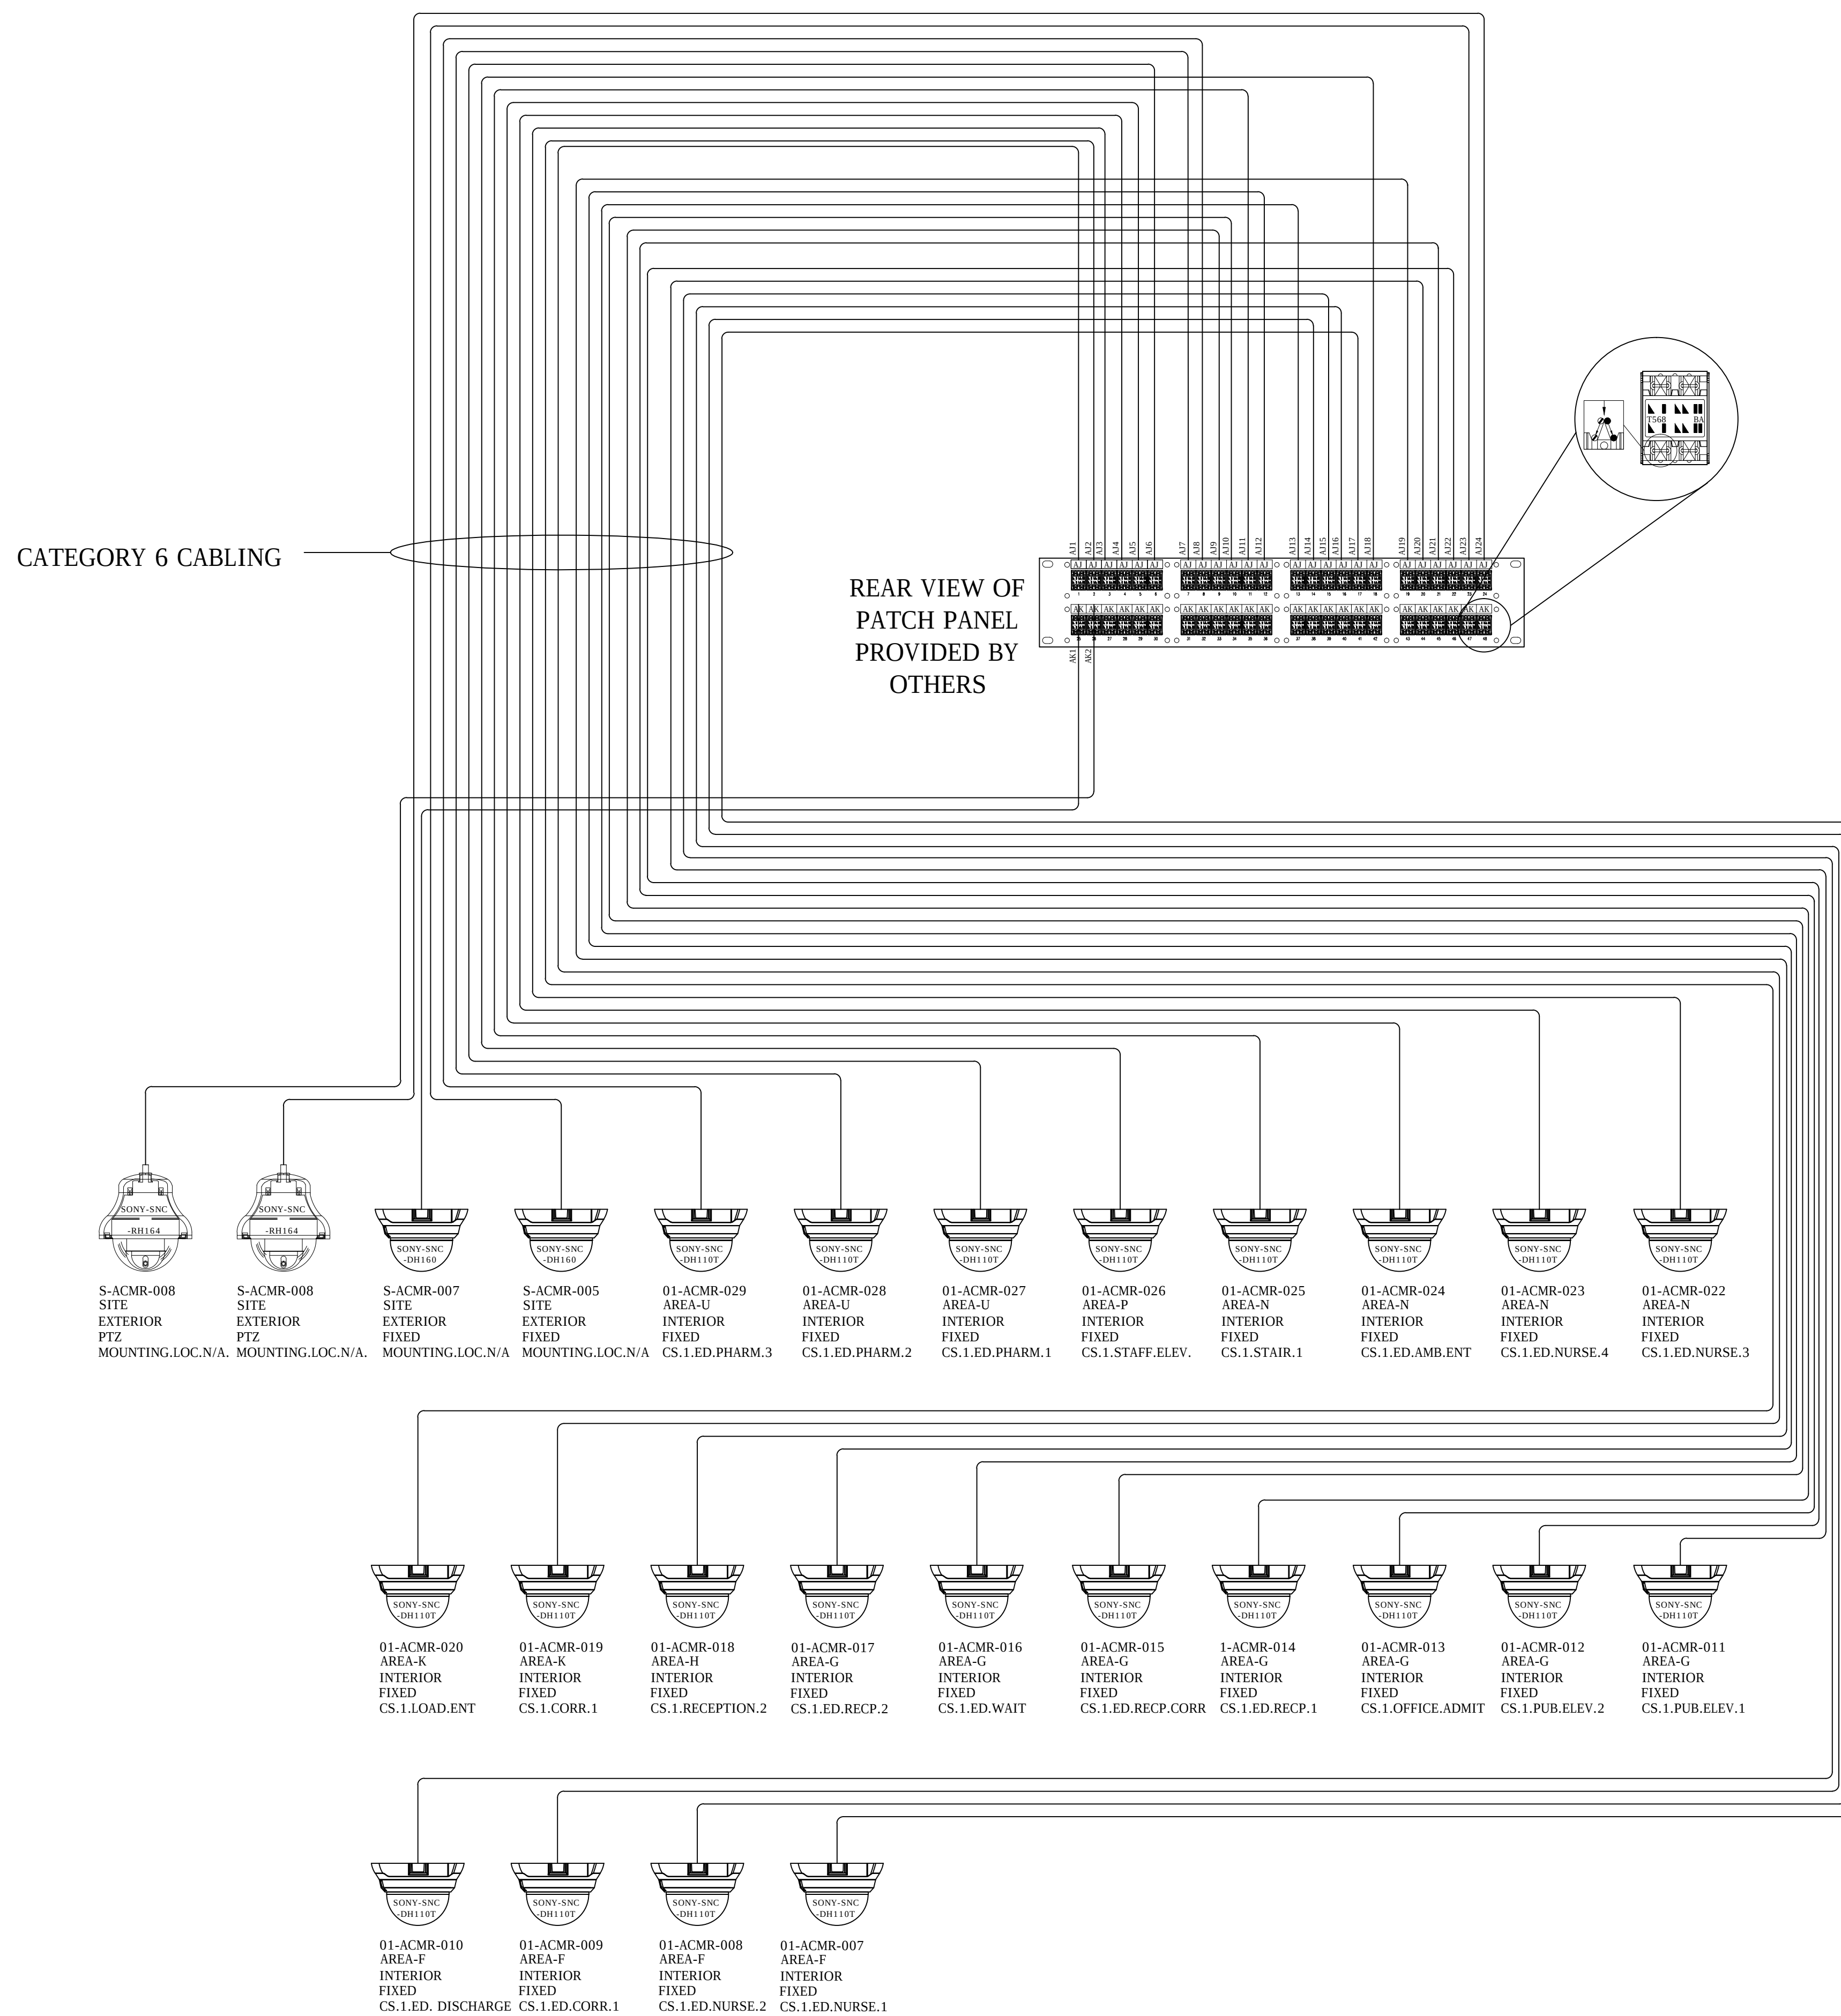

Pin outs	T568B	
5	WHITE/BLUE	T1
4	BLUE	R1
3	WHITE/GREEN	T3
6	GREEN	R3
1	WHITE/ORANGE	T2
2	ORANGE	R2
7	WHITE/BROWN	T4
8	BROWN	R4

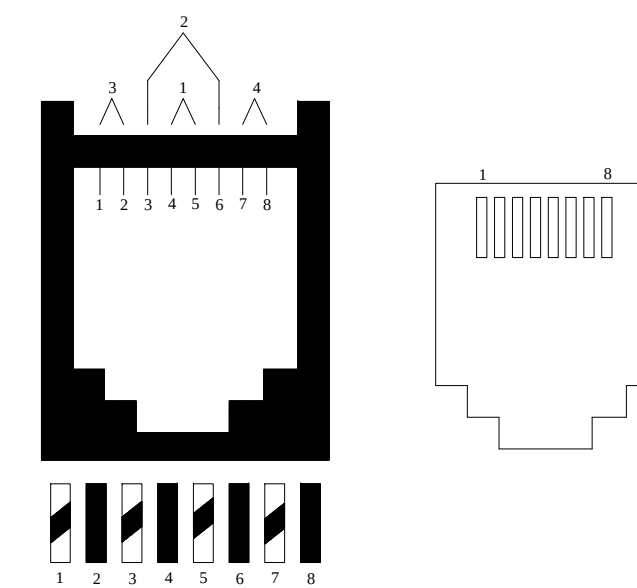

ASBUILTS
08/15/2012

DRAWING PREPARED BY:

KRATOS
HBE

1511 E. ORANGETHORPE BLVD.
FULLERTON, CALIFORNIA 92831
714-525-4350 - o; 714-525-4386 - f
(c) Copyright 2012 KRATOS | HBE
All Rights Reserved.


MUST BE SIGNED BY HBE
TO AUTHENTICATE CONTENT(S).
ALL DETAILS CHECKED FOR ACCURACY.

SIGNATURE _____ DATE _____

HBE JOB #

CONFIDENTIAL
THE INFORMATION CONTAINED HERIN MAY
NOT BE USED OR REPRODUCED IN ANY
MANNER WITHOUT WRITTEN PERMISSION OF
KRATOS | HBE.

KEY PLAN

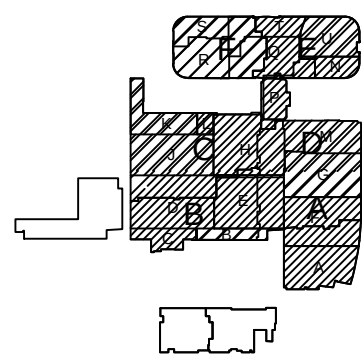

NO.	REV DESCRIPTION REV DATE	APPROVED BY
1.	AS BUILTS 08/15/2012	JOHN J. CHRISTIE

REV.	DESCRIPTION	APPROVED BY
------	-------------	-------------


CUSTOMER:

CHOC
Children's Hospital
of Orange County

PROJECT:
CHOC CHILDREN'S
HOSPITAL
455 SOUTH MAIN ST.
ORANGE, CA 92668

DRAWING TITLE:
FIRST LEVEL CCTV POINT
TO POINT DIAGRAM RM
1.067


DRN BY	DATE DRN	CHK BY	DATE CHK
JOSH G.	08/08/2012	JJC	
SCALE:	NTS		
DWG NO.	SE4.03		

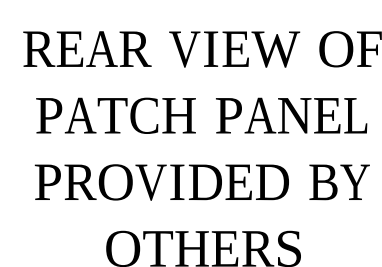

**MUST BE SIGNED BY HBE
TO AUTHENTICATE CONTENT(S).
ALL DETAILS CHECKED FOR ACCURACY**

HBE JOB #

THE INFORMATION CONTAINED HEREIN MAY NOT BE USED OR REPRODUCED IN ANY MANNER WITHOUT WRITTEN PERMISSION OF
KRATOS | HBE.

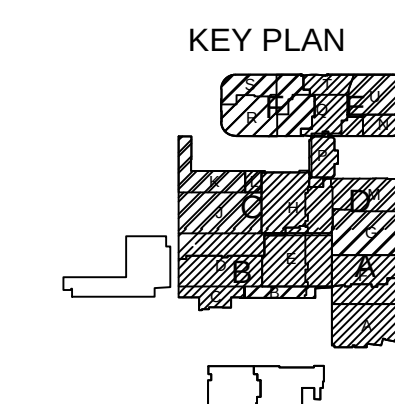[illegible]

CUSTOMER: **C**



DRAWING TITLE:
SECOND LEVEL CCTV POINT
TO POINT DIAGRAM RM
2.113.18A

DRN BY	DATE DRN	CHK BY	DATE CHK
JOSH G.	08/08/2012	JJC	
SCALE:	NTS		
DWG NO.	SF4.05		

ASBUILTS
08/15/2012

DRAWING PREPARED BY:



1511 E. ORANGETHORPE BLVD.
FULLERTON, CALIFORNIA 92831
714-525-4350 - o; 714-525-4386 - f
(c) Copyright 2012 KRATOS | HBE
All Rights Reserved.


**MUST BE SIGNED BY HBE
TO AUTHENTICATE CONTENT(S).
ALL DETAILS CHECKED FOR ACCURACY.**

SIGNATURE _____ DATE _____

HBE JOB #

CONFIDENTIAL

THE INFORMATION CONTAINED HERIN MAY NOT BE USED OR REPRODUCED IN ANY MANNER WITHOUT WRITTEN PERMISSION OF KRATOS | HBE.

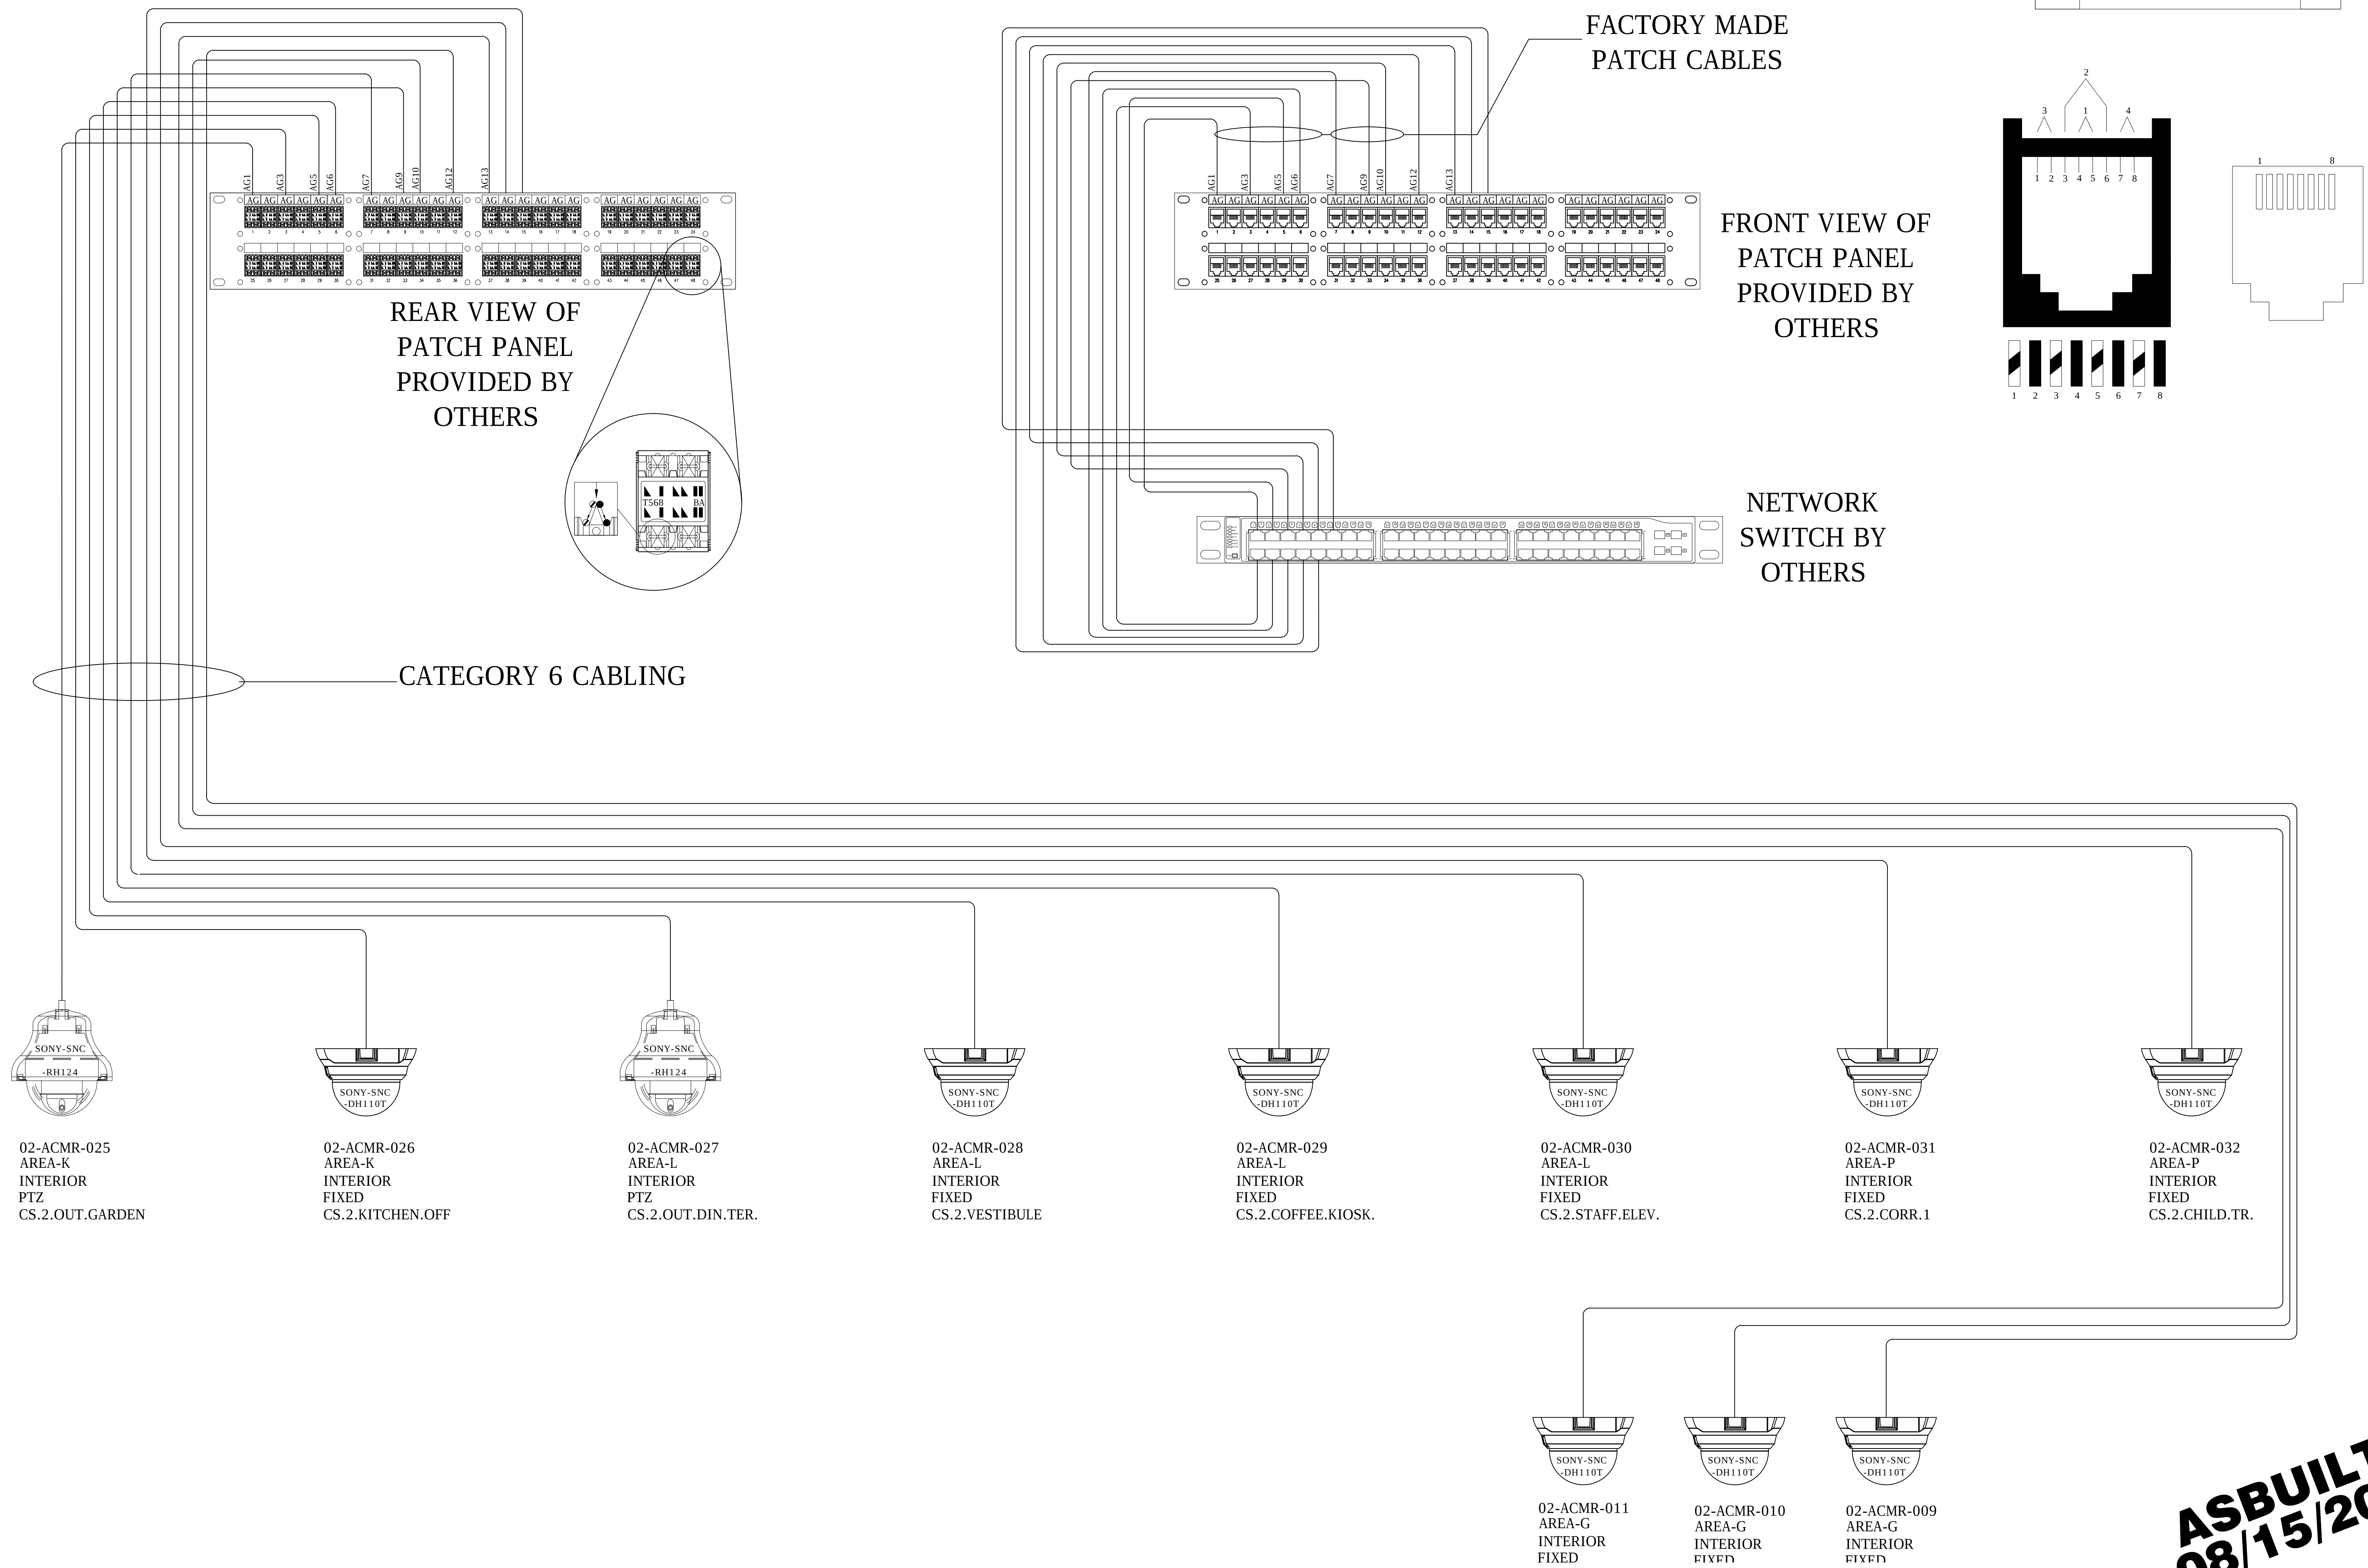

ASBUILTS
08/15/2012

REV.	DESCRIPTION	APPROVED BY
------	-------------	-------------



PROJECT: _____

CHOC CHILDREN'S
HOSPITAL
55 SOUTH MAIN ST.
ORANGE, CA 92668

DRAWING TITLE:
SECOND LEVEL OCTV/DOIN

SECOND LEVEL CCTV POINT
TO POINT DIAGRAM RM
2.066

DRN BY	DATE DRN	CHK BY	DATE CHK
--------	----------	--------	----------

JOSH G.	08/08/2012	JJC	
SCALE:	NTS		

DWG NO.	SF4 06
---------	--------

DRAWING PREPARED BY:



1511 E. ORANGETHORPE BLVD.
FULLERTON, CALIFORNIA 92831
714-525-4350 - o; 714-525-4386 - f
(c) Copyright 2012 KRATOS | HBE
All Rights Reserved.



**MUST BE SIGNED BY HBE
TO AUTHENTICATE CONTENT(S).
ALL DETAILS CHECKED FOR ACCURACY.**

SIGNATURE _____ DATE _____

HBE JOB #



CONFIDENTIAL

THE INFORMATION CONTAINED HEREIN MAY
NOT BE USED OR REPRODUCED IN ANY
MANNER WITHOUT WRITTEN PERMISSION OF
KRATOS | HBE.

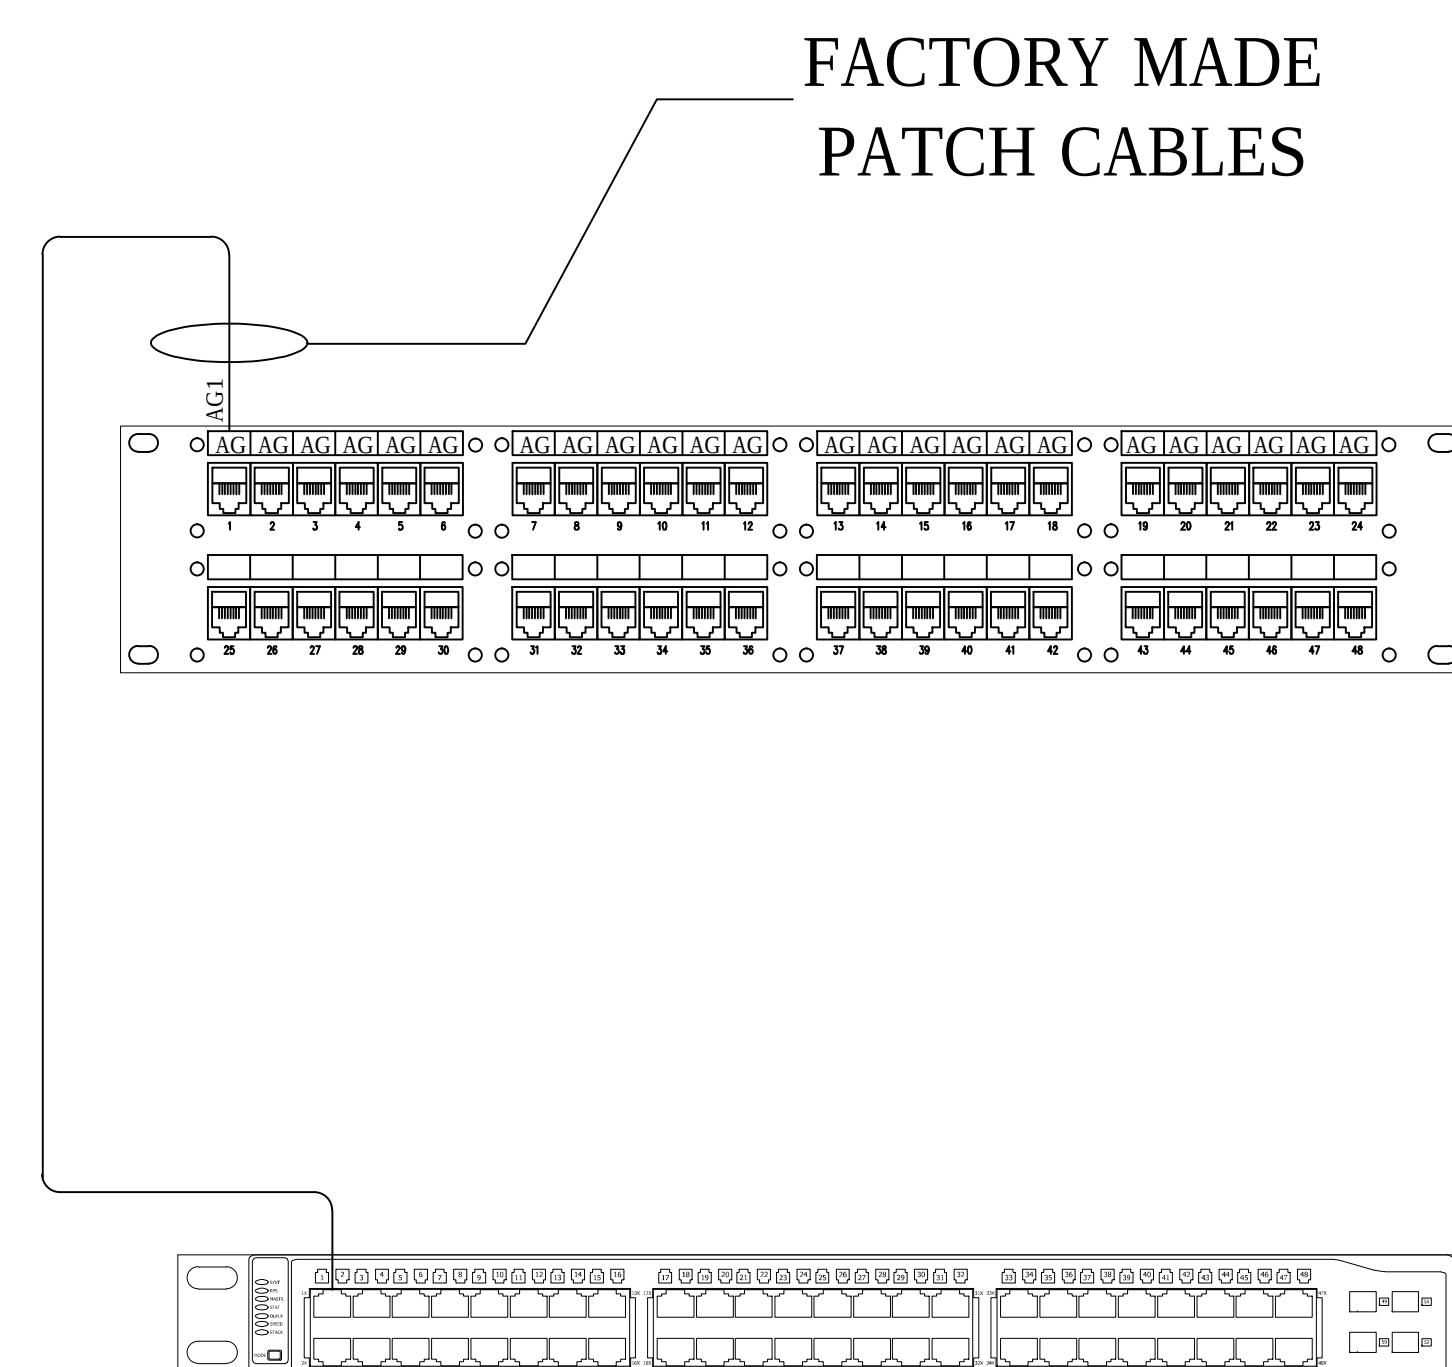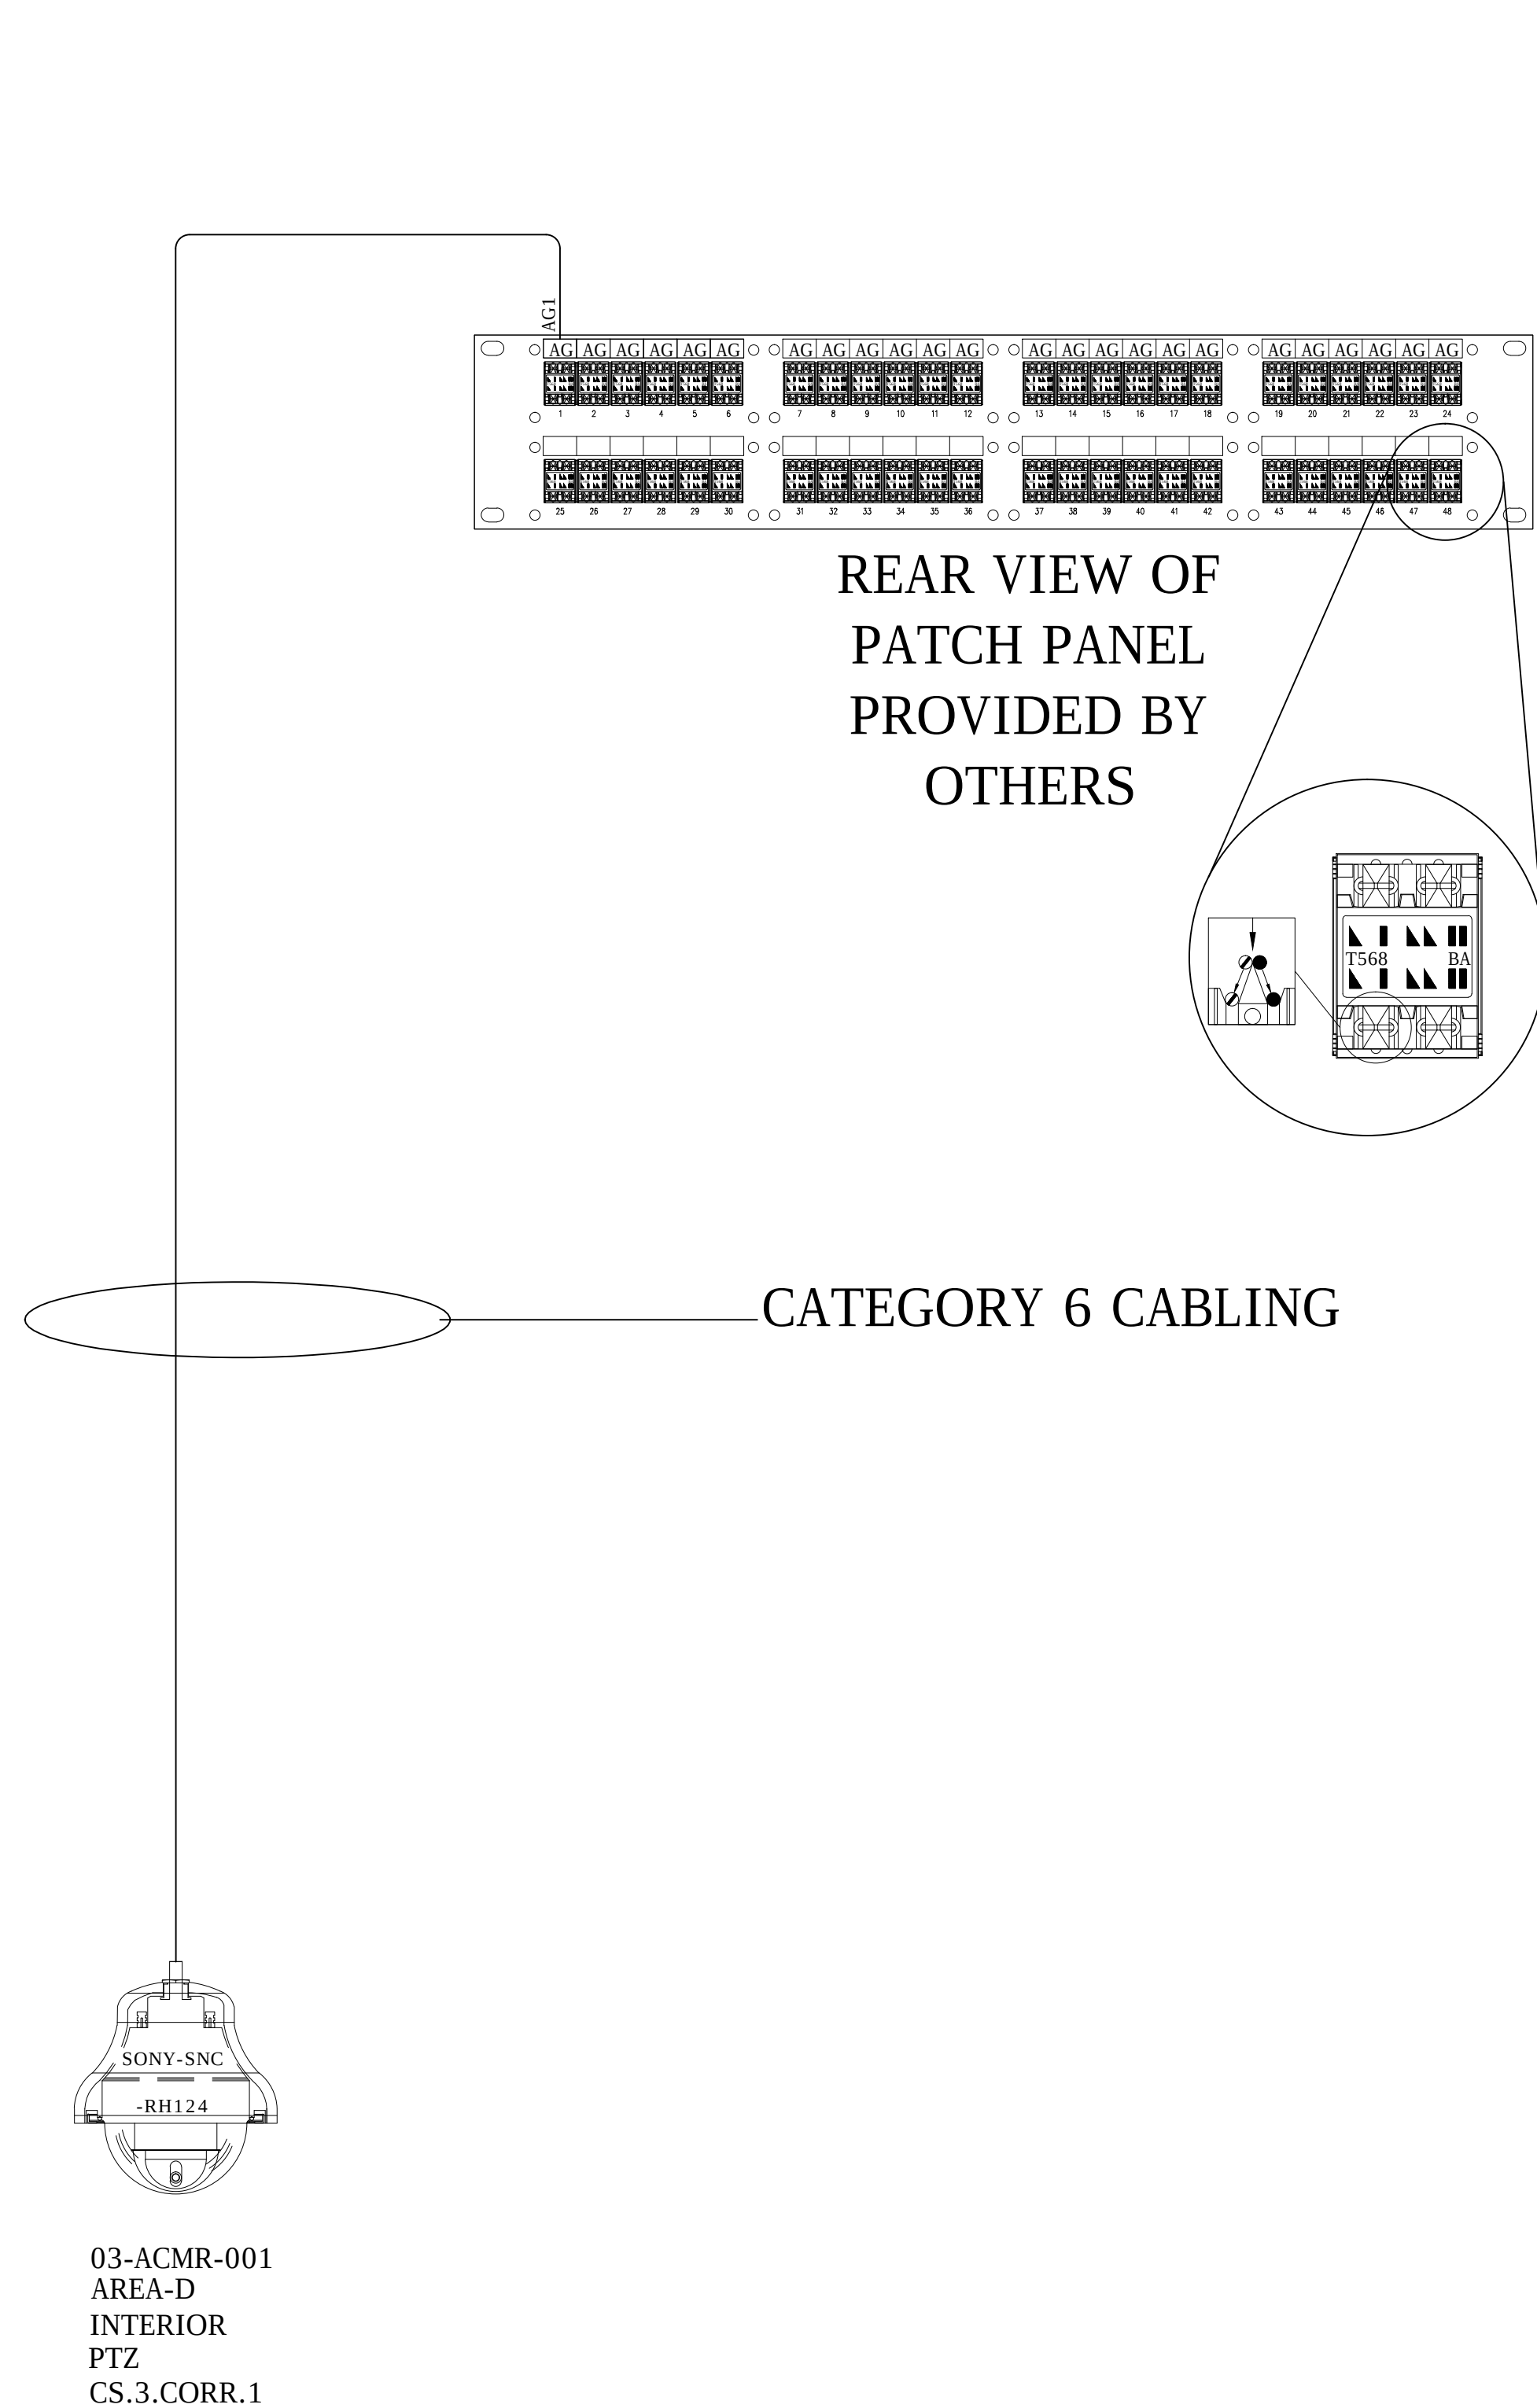

FRONT VIEW OF
PATCH PANEL
PROVIDED BY
OTHERS

NETWORK SWITCH BY OTHERS

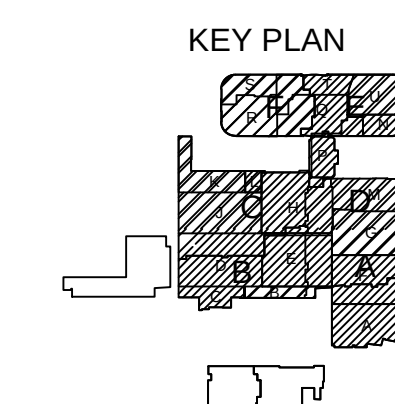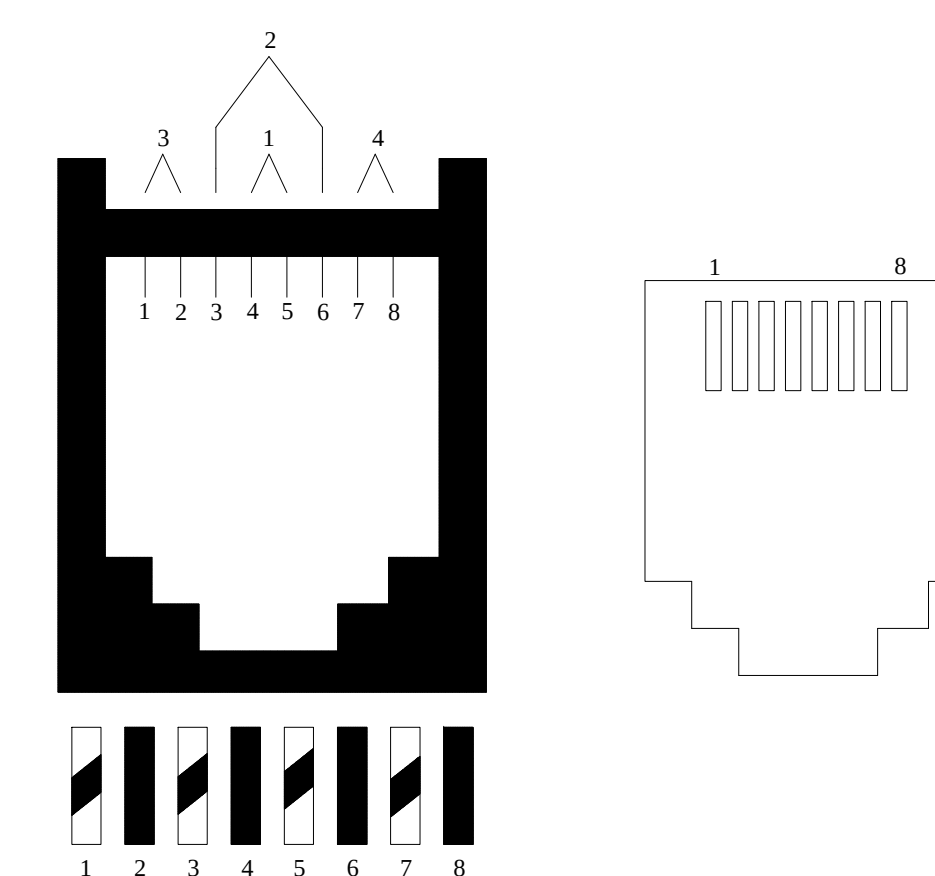

NO.	REV DESCRIPTION REV DATE	APPROVED BY
1.	AS BUILTS 08/15/2012	JOHN J. CHRISTI
REV.	DESCRIPTION	APPROVED BY

CUSTOMER:



PROJECT:

CHOC CHILDREN'S
HOSPITAL
455 SOUTH MAIN ST.
ORANGE, CA 92668

DRAWING TITLE:

DRAWING TITLE:
THIRD LEVEL CCTV POINT
TO POINT DIAGRAM RM
3.022

DRN BY	DATE DRN	CHK BY	DATE CH
JOSH G.	08/08/2012	JJC	
SCALE:	NTS		
DWG NO.	SE4.07		

ASBUILTS
08/15/2012



1511 E. ORANGETHORPE BLVD.
FULLERTON, CALIFORNIA 92831
714-525-4350 - o; 714-525-4386 - f
(c) Copyright 2012 KRATOS | HBE
All Rights Reserved.

MUST BE SIGNED BY HBE
TO AUTHENTICATE CONTENT(S).
ALL DETAILS CHECKED FOR ACCURACY.


SIGNATURE _____ DATE _____

HBE JOB #

CONFIDENTIAL

THE INFORMATION CONTAINED HERIN MAY
NOT BE USED OR REPRODUCED IN ANY
MANNER WITHOUT WRITTEN PERMISSION OF
KRATOS | HBE.

Pin outs	T568B	
5	WHITE/BLUE	T1
4	BLUE	R1
3	WHITE/GREEN	T3
6	GREEN	R3
1	WHITE/ORANGE	T2
2	ORANGE	R2
7	WHITE/BROWN	T4
8	BROWN	R4

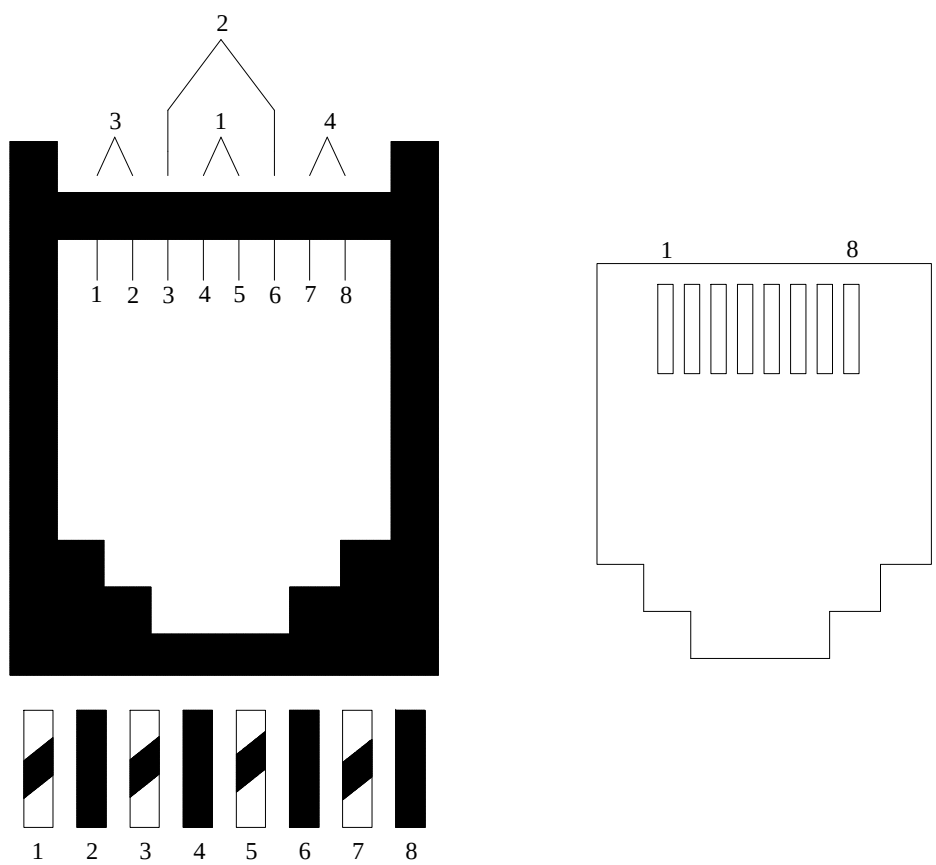


REAR VIEW OF
PATCH PANEL
PROVIDED BY
OTHERS

FRONT VIEW OF
PATCH PANEL
PROVIDED BY
OTHERS


FACTORY MADE
PATCH CABLES

NETWORK
SWITCH BY
OTHERS

CATEGORY 6 CABLING

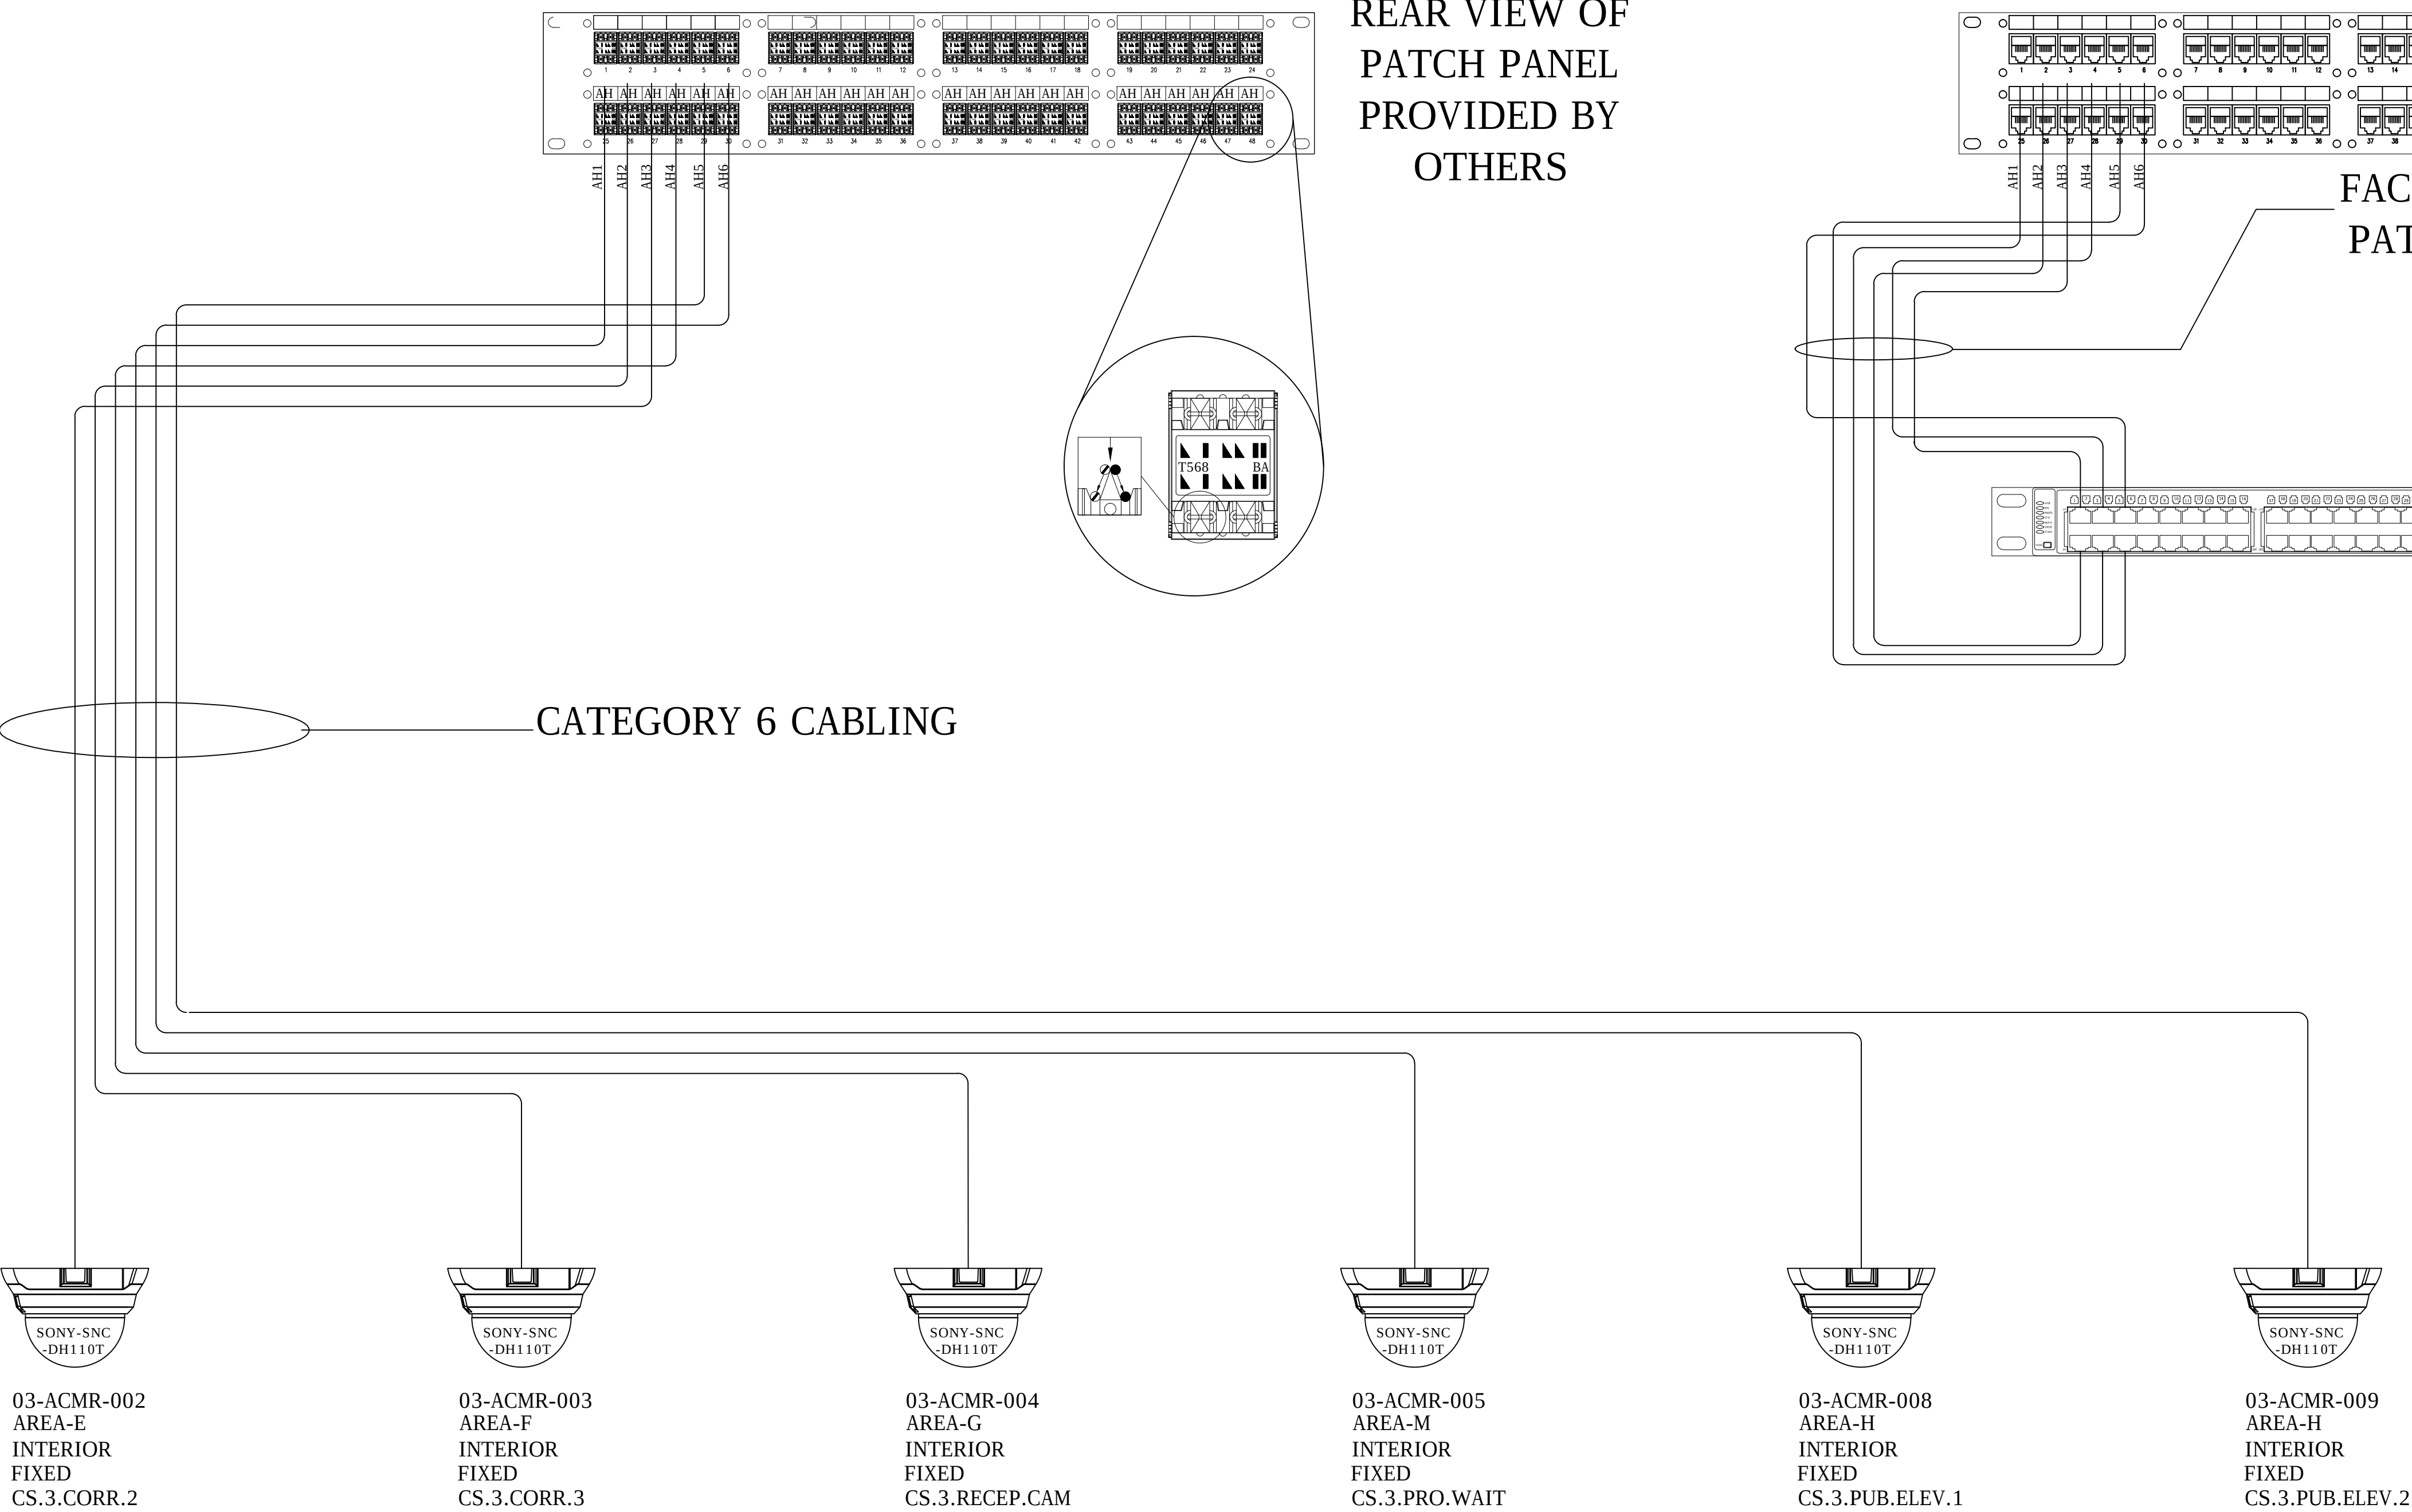

KEY PLAN

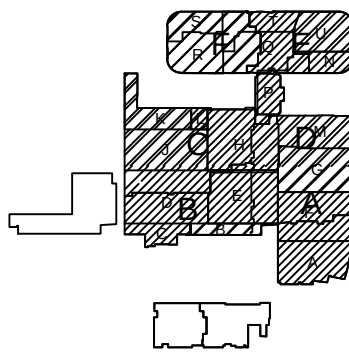

NO.	REV DESCRIPTION REV DATE	APPROVED BY
1.	AS BUILTS 08/15/2012	JOHN J. CHRISTIE

REV.	DESCRIPTION	APPROVED BY
------	-------------	-------------

CUSTOMER:



PROJECT:
CHOC CHILDREN'S
HOSPITAL
455 SOUTH MAIN ST.
ORANGE, CA 92668

DRAWING TITLE:
THIRD LEVEL CCTV POINT
TO POINT DIAGRAM RM
3.106.13

DRN BY	DATE DRN	CHK BY	DATE CHK
JOSH G.	08/08/2012	JJC	
SCALE:	NTS		
DWG NO.	SE4.08		

ASBUILTS
08/15/2012

DRAWING PREPARED BY:



1511 E. ORANGETHORPE BLVD.
FULLERTON, CALIFORNIA 92831
714-525-4350 - o; 714-525-4386 - f
(c) Copyright 2012 KRATOS | HBE
All Rights Reserved.


**MUST BE SIGNED BY HBE
TO AUTHENTICATE CONTENT(S).
ALL DETAILS CHECKED FOR ACCURACY.**

SIGNATURE _____ DATE _____


HBE JOB #

CONFIDENTIAL


THE INFORMATION CONTAINED HERIN MAY
NOT BE USED OR REPRODUCED IN ANY
MANNER WITHOUT WRITTEN PERMISSION OF
KRATOS | HBE.

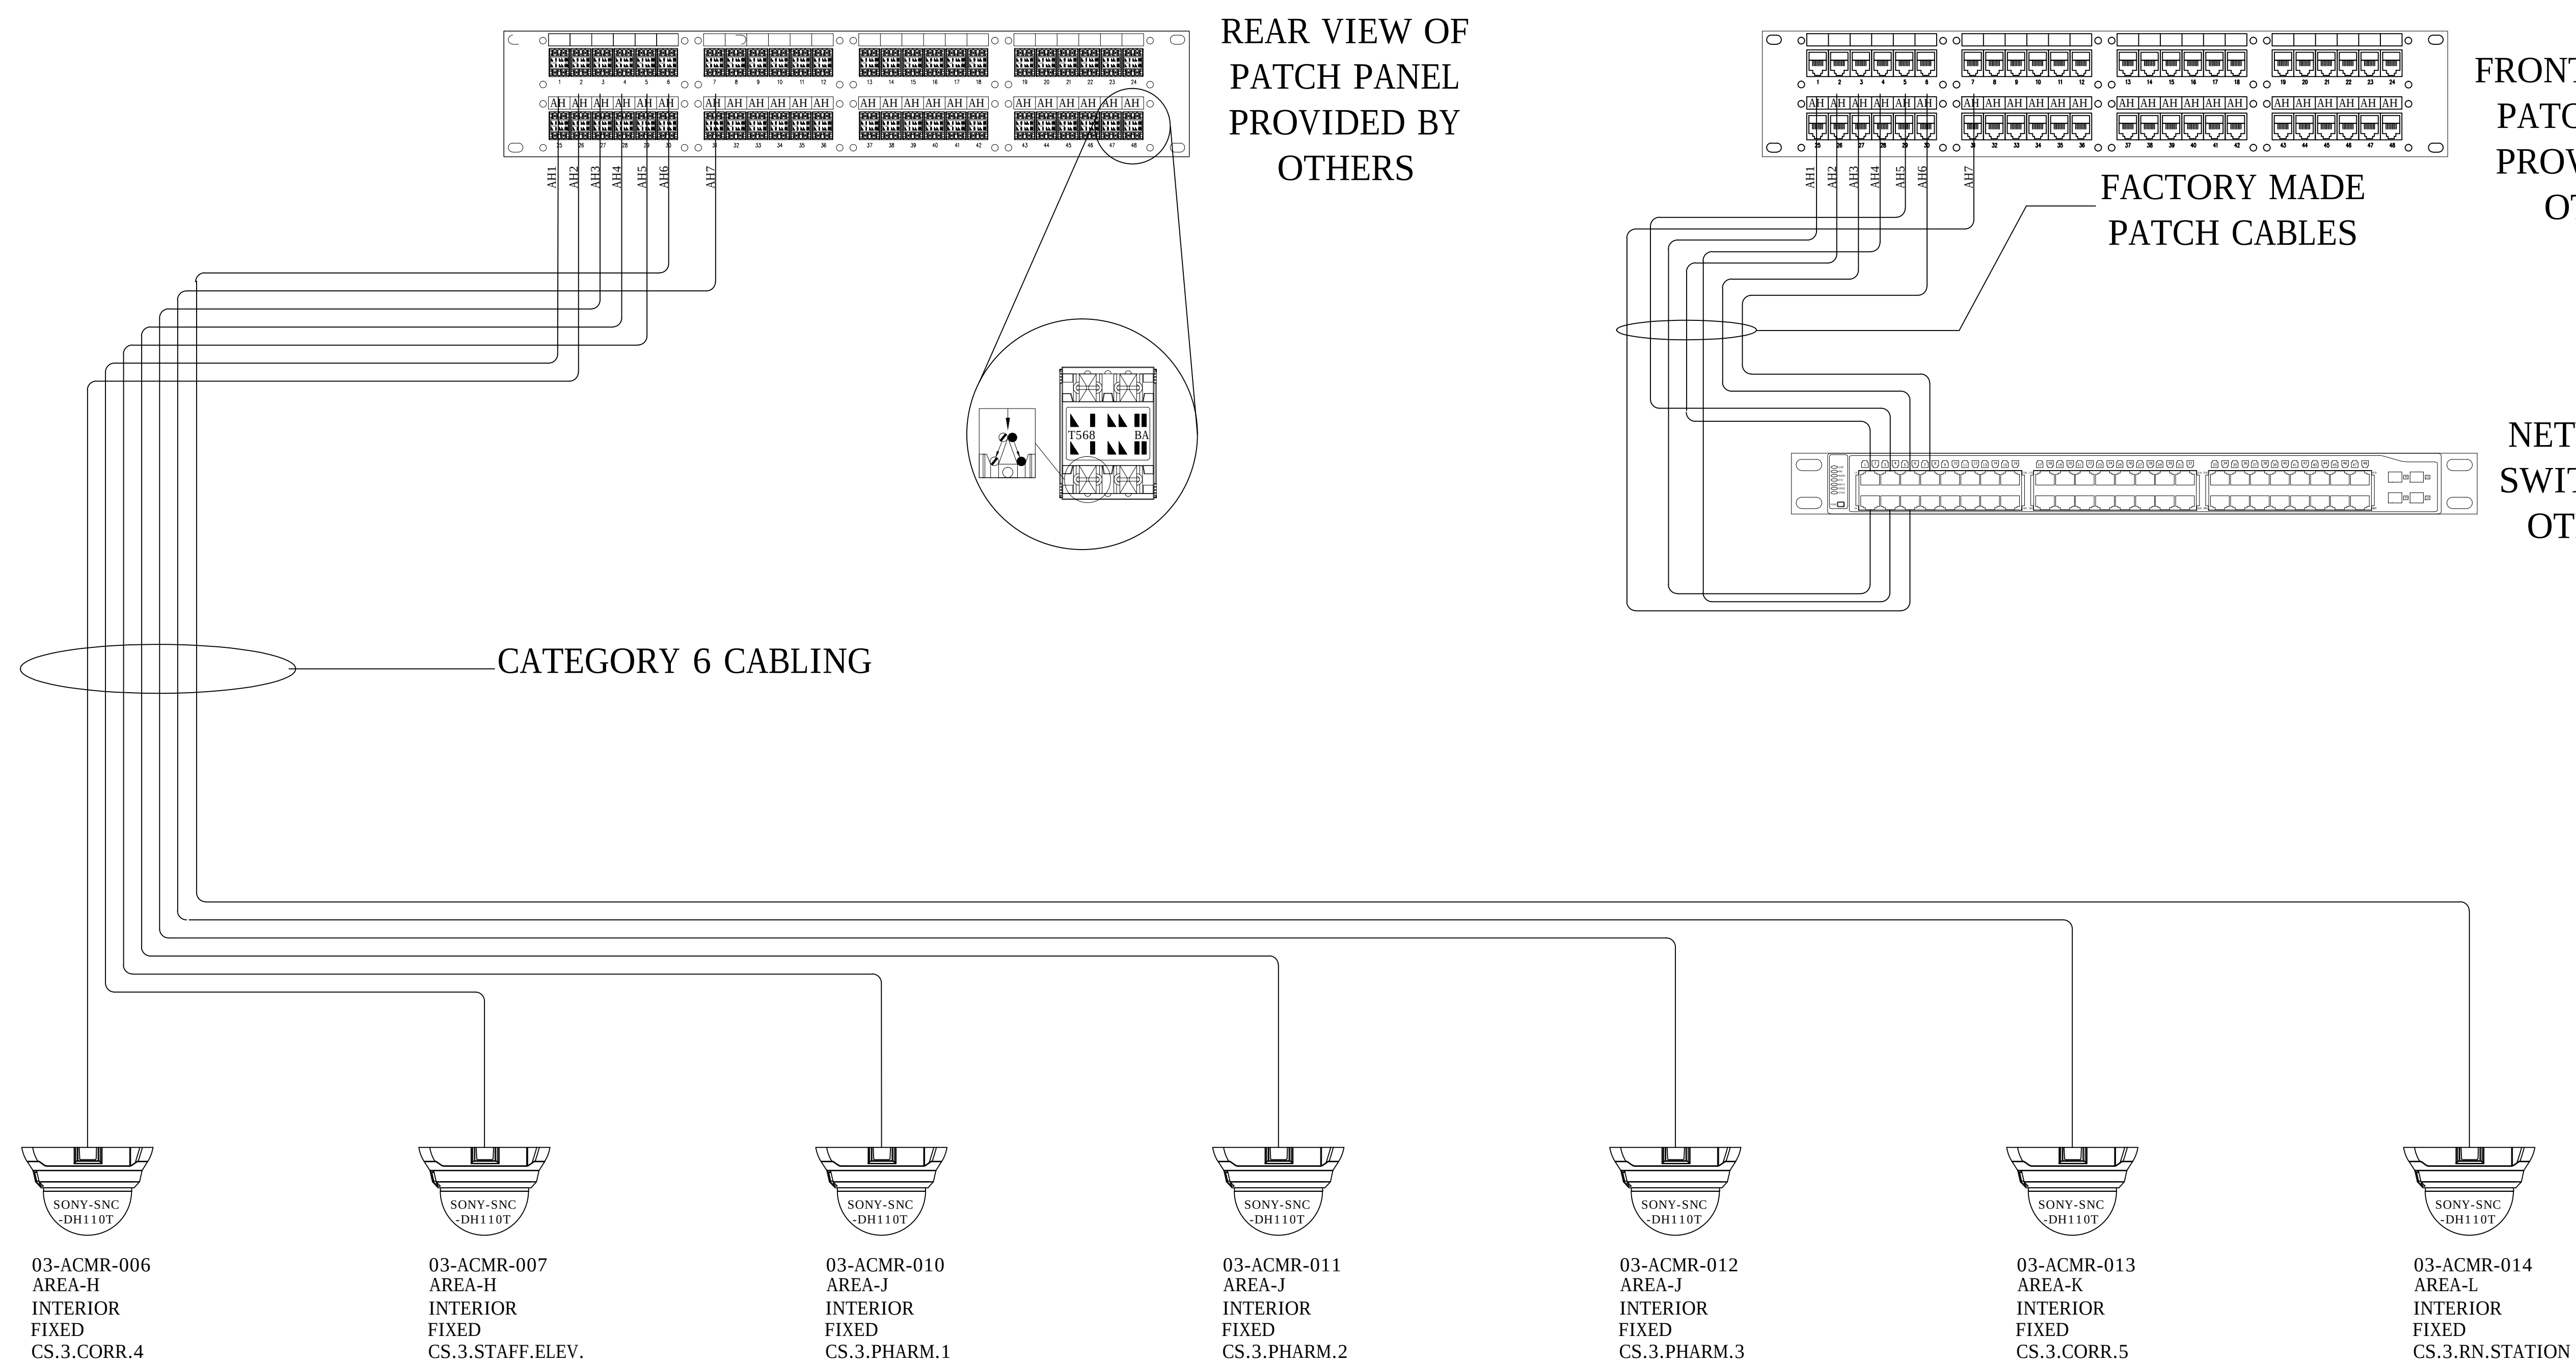

Pin outs	T568B	
5	WHITE/BLUE	T1
4	BLUE	R1
3	WHITE/GREEN	T3
6	GREEN	R3
1	WHITE/ORANGE	T2
2	ORANGE	R2
7	WHITE/BROWN	T4
8	BROWN	R4

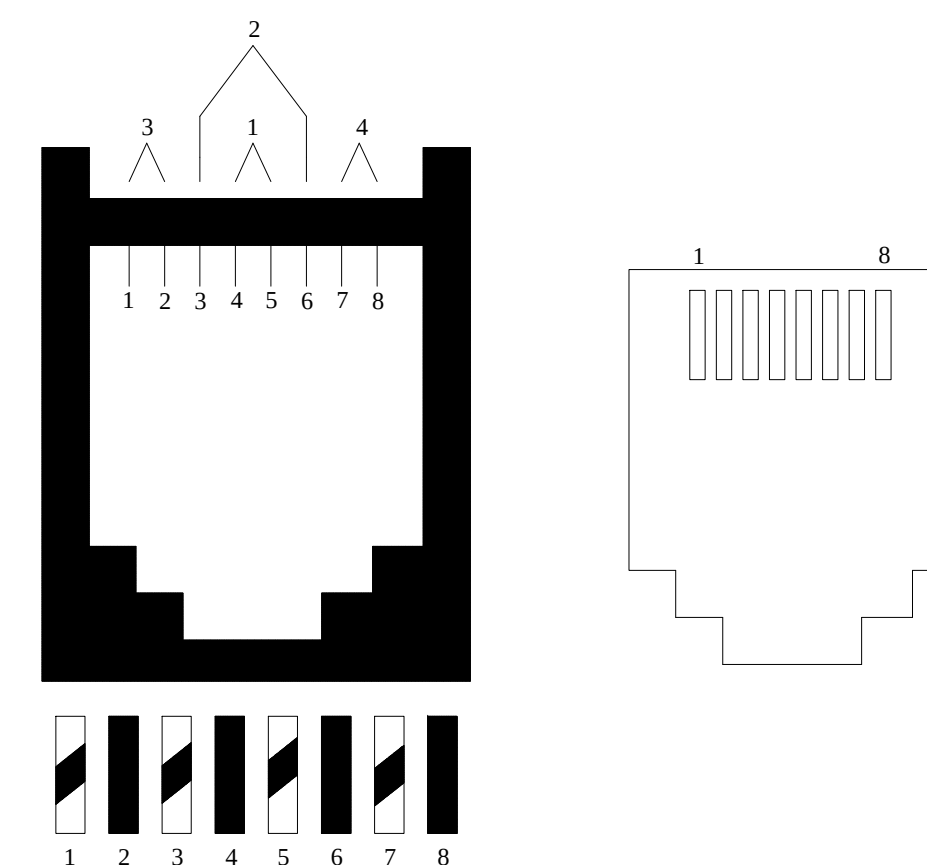

KEY PLAN

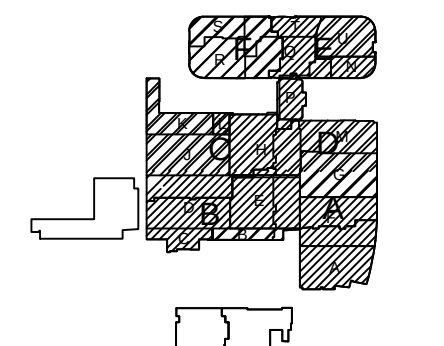

NO.	REV DESCRIPTION REV DATE	APPROVED BY
1.	AS BUILTS 08/15/2012	JOHN J. CHRISTIE
REV.	DESCRIPTION	APPROVED BY



PROJECT:

CHOC CHILDREN'S
HOSPITAL
455 SOUTH MAIN ST.
ORANGE, CA 92668

DRAWING TITLE:

DRAWING TITLE:
THIRD LEVEL CCTV POINT
TO POINT DIAGRAM RM
3.064

DRN BY	DATE DRN	CHK BY	DATE CHK
JOSH G.	08/08/2012	JJC	
SCALE:		NTS	
DWG NO.	SE4.09		


ASBUILTS
08/15/2012

1

NO SCALE



Y PLAN

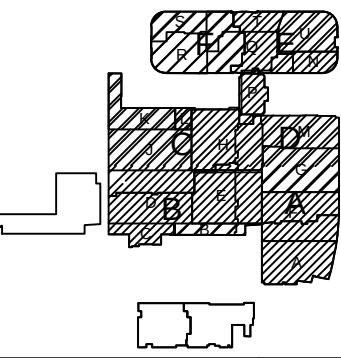

NO.	REV DESCRIPTION REV DATE	APPROVED BY
1.	AS BUILTS 09/24/2012	JOHN J. CHRISTIE
	CHANGE ORDER #376	JOHN J. CHRISTIE
REV.	DESCRIPTION	APPROVED BY



PROJECT:



CHOC CHILDREN'S
HOSPITAL
455 SOUTH MAIN ST.
ORANGE, CA 92668

DRAWING TITLE:


FOURTH LEVEL
CCTV POINT TO
POINT DIAGRAM

DEN BY	DAT DEN	CHK BY	DAT CHK
JOSH G.	08/08/2012	JJC	
SCALE:	NTS		
DWG NO.	SE4.00		

ASBUILTS
09/26/2012

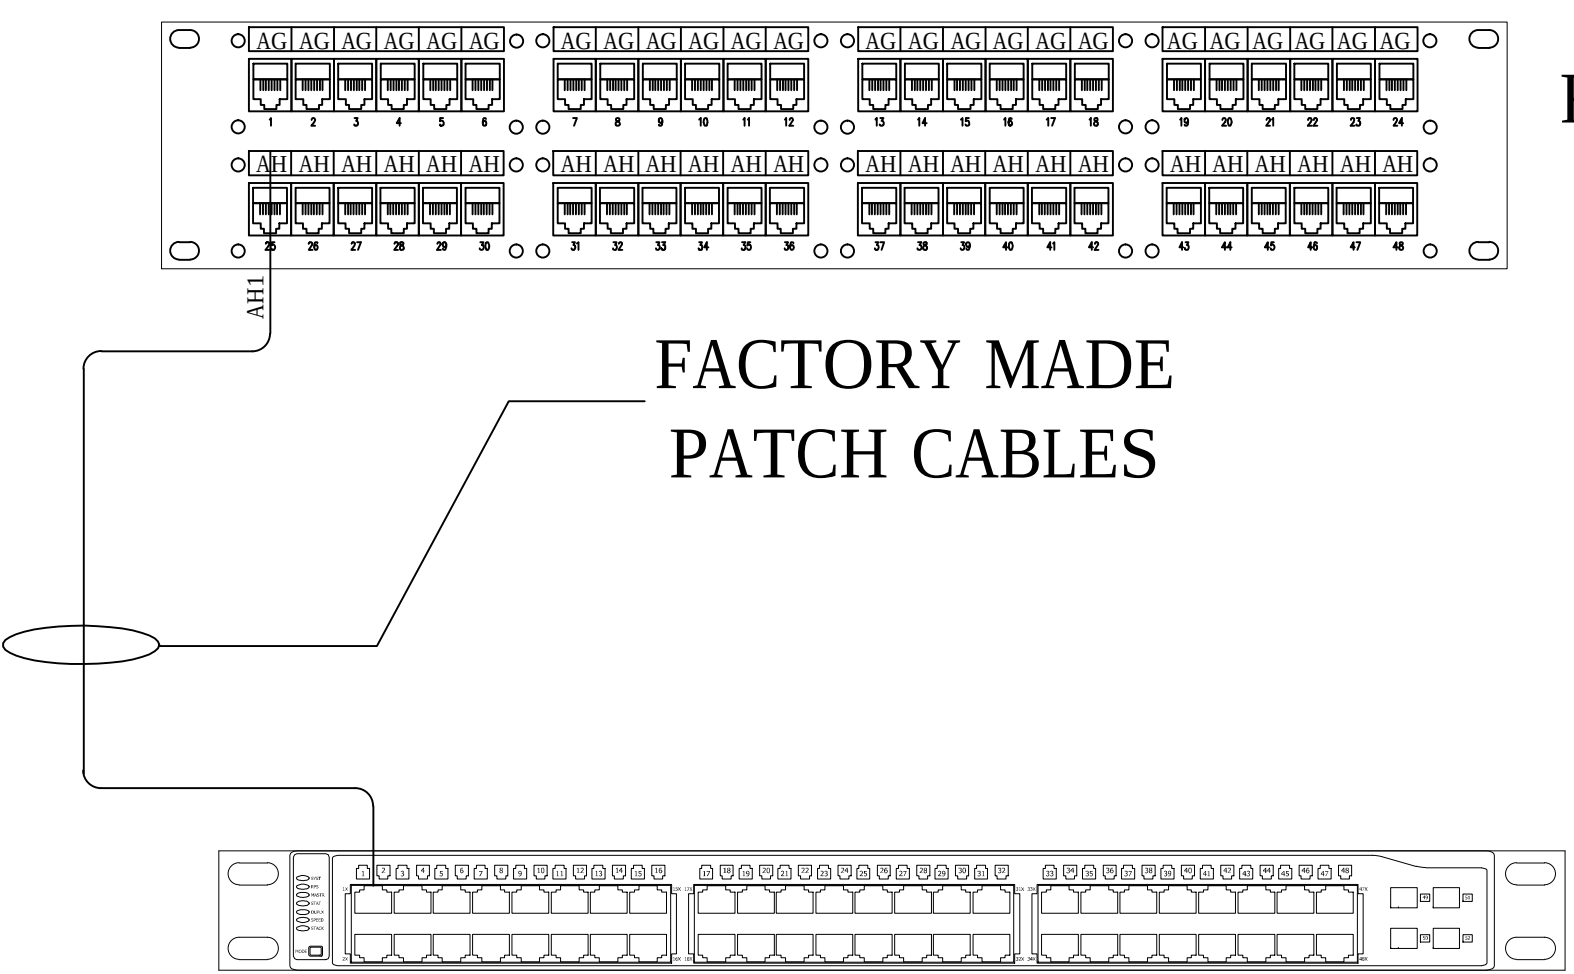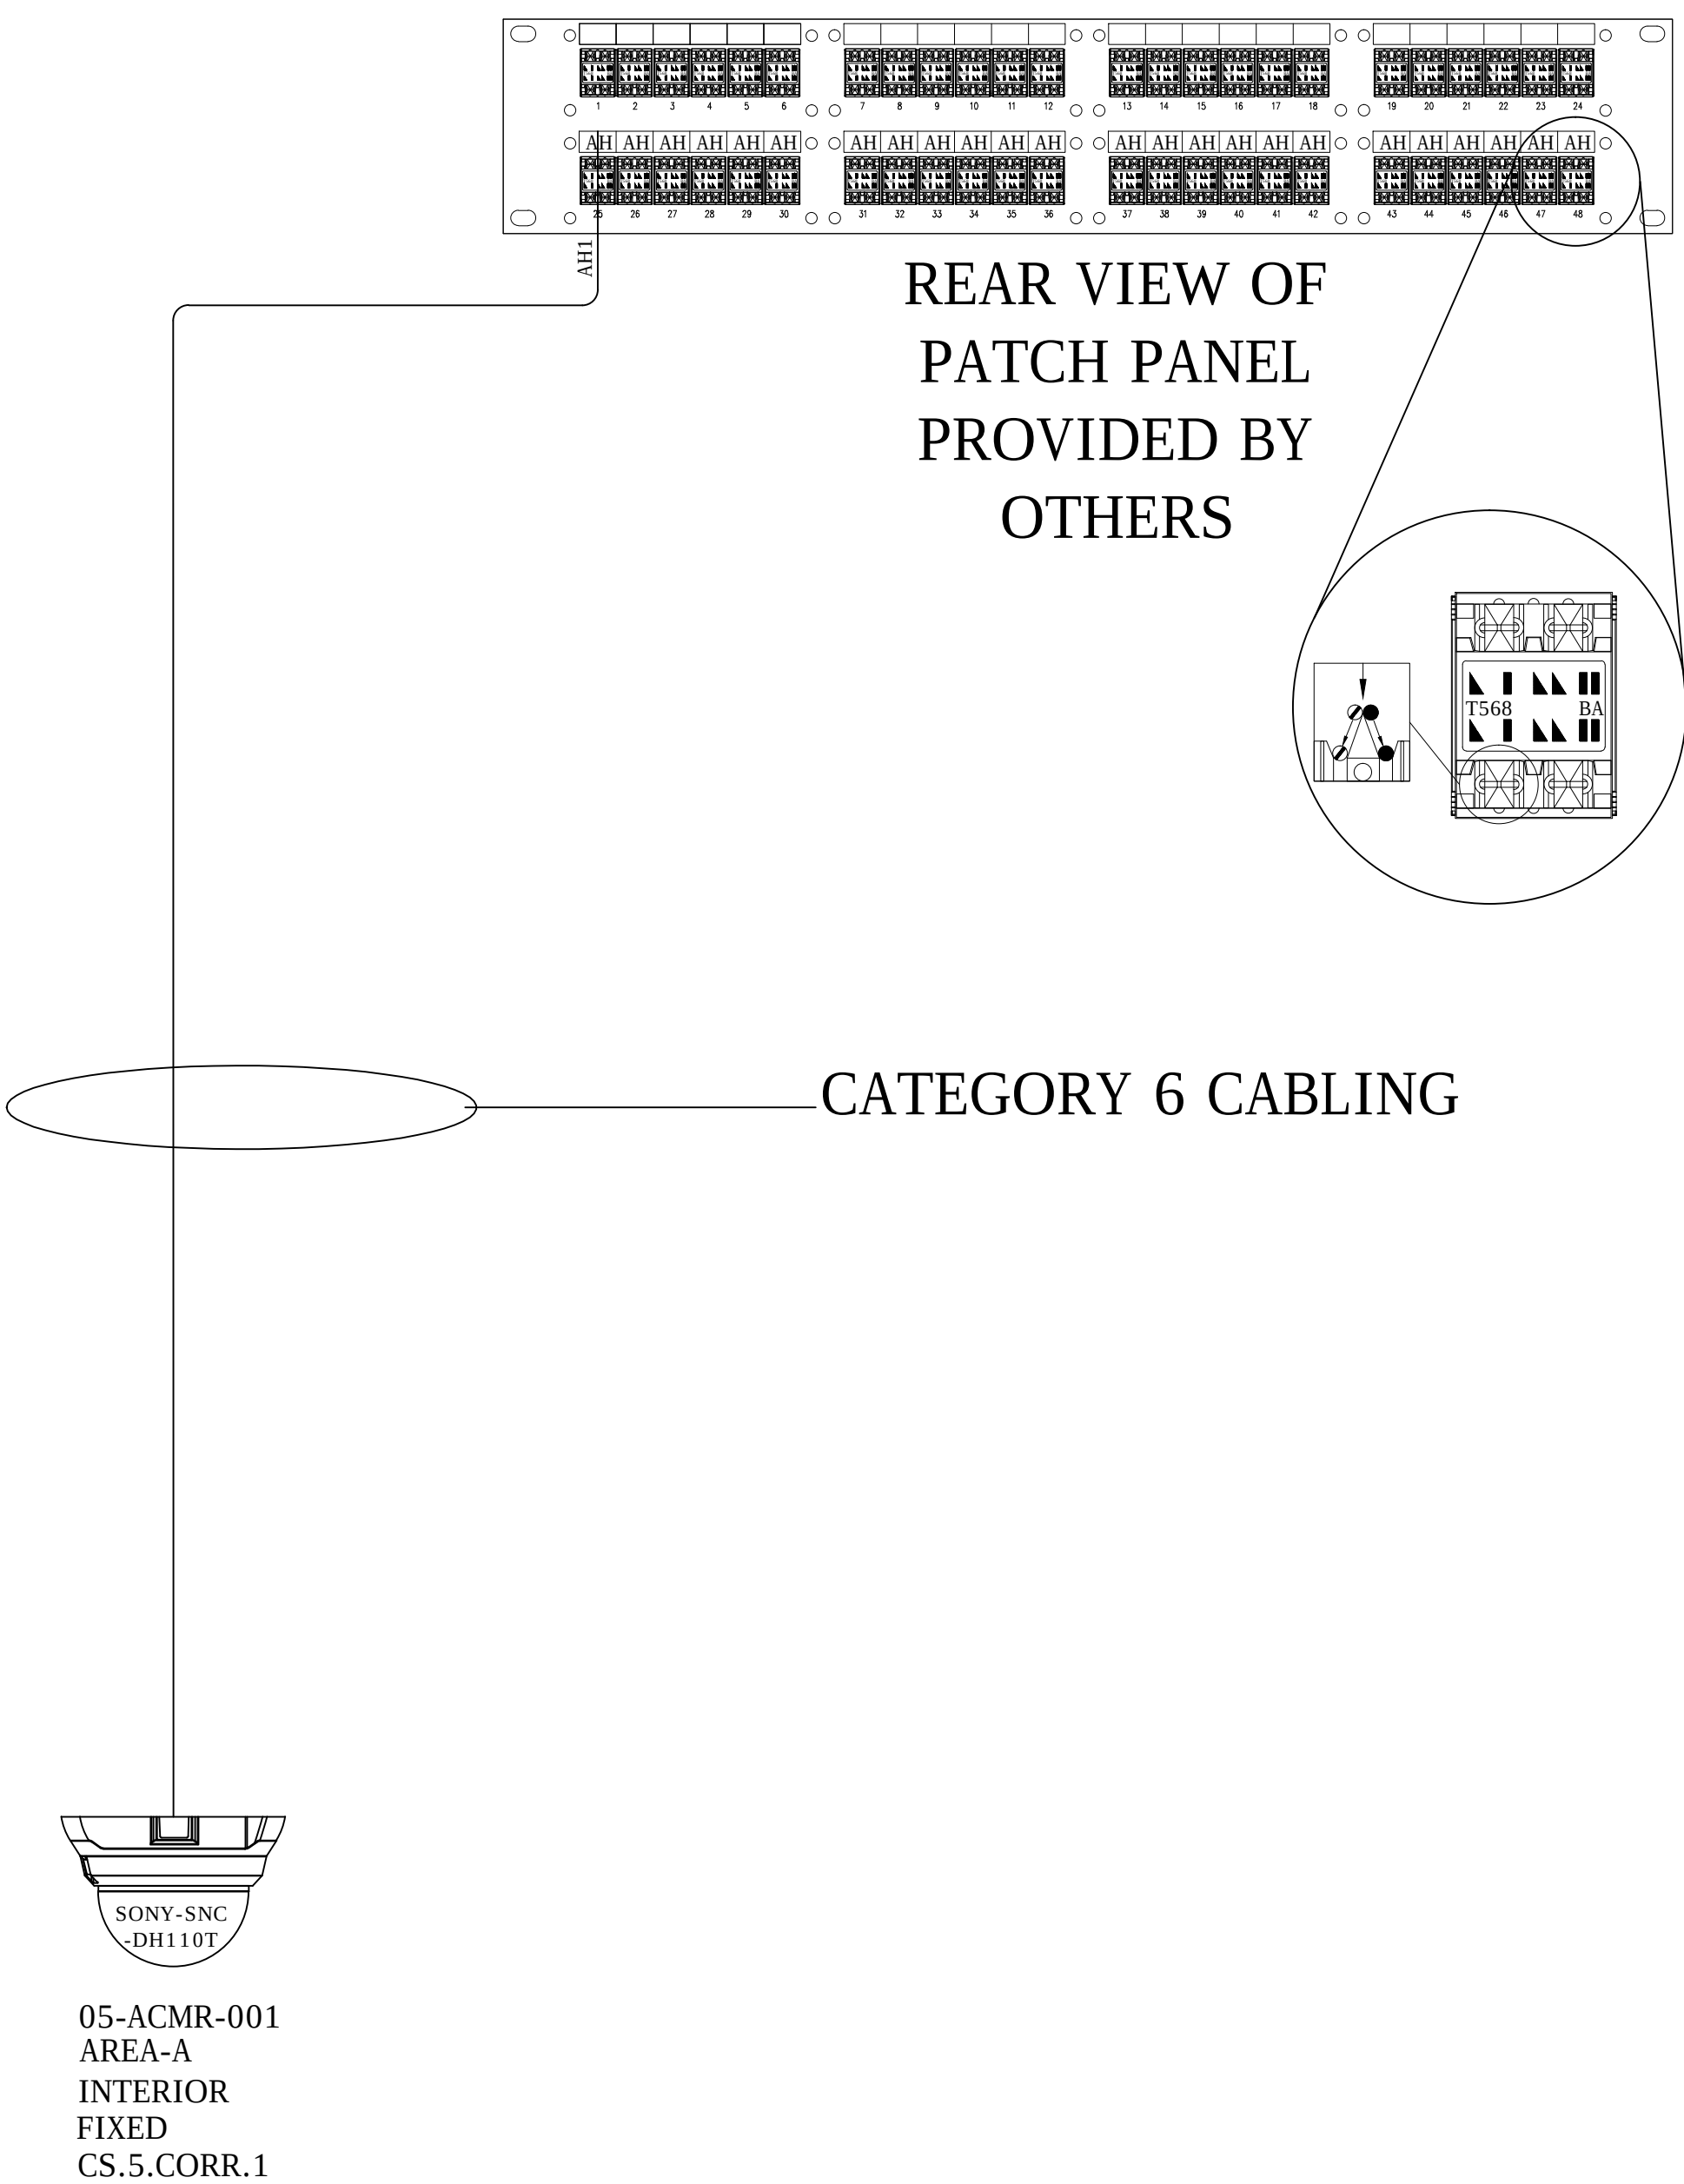

Pin outs	T568B	
5	WHITE/BLUE	T1
4	BLUE	R1
3	WHITE/GREEN	T3
6	GREEN	R3
1	WHITE/ORANGE	T2
2	ORANGE	R2
7	WHITE/BROWN	T4
8	BROWN	R4

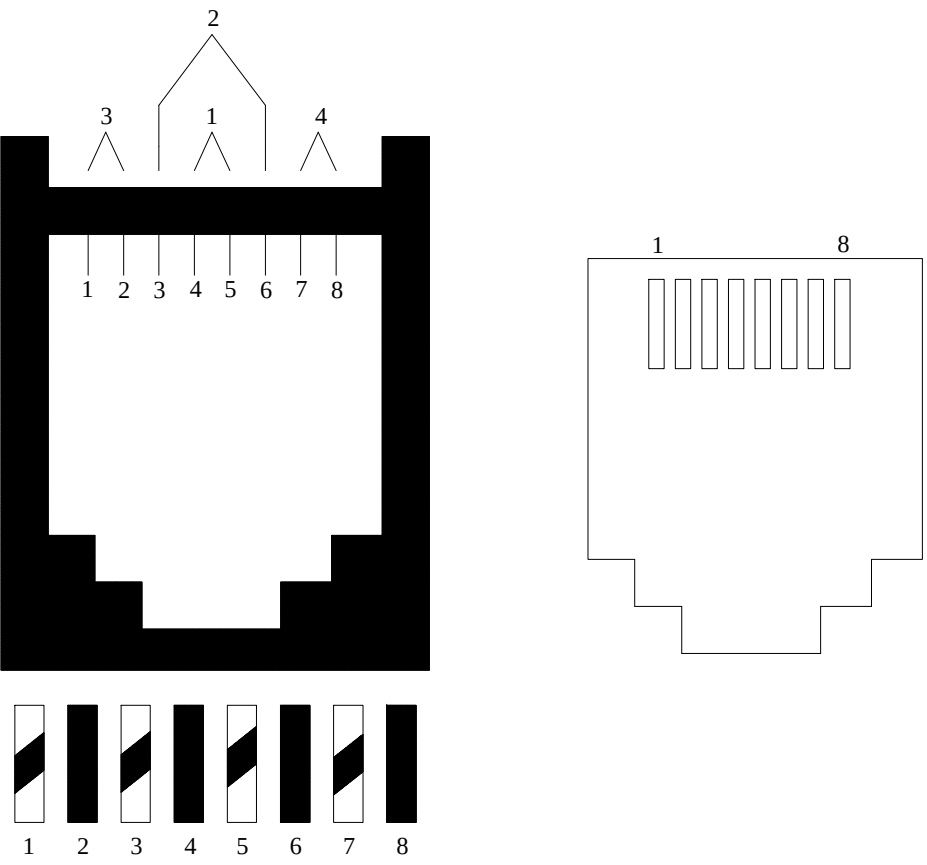

DRAWING PREPARED BY:



1511 E. ORANGETHORPE BLVD.
FULLERTON, CALIFORNIA 92831
714-525-4350 - o; 714-525-4386 - f
(c) Copyright 2012 KRATOS | HBE
All Rights Reserved.

MUST BE SIGNED BY HBE
TO AUTHENTICATE CONTENT(S).
ALL DETAILS CHECKED FOR ACCURACY.


SIGNATURE _____ DATE _____

HBE JOB #

CONFIDENTIAL

THE INFORMATION CONTAINED HERIN MAY
NOT BE USED OR REPRODUCED IN ANY
MANNER WITHOUT WRITTEN PERMISSION OF
KRATOS | HBE.

KEY PLAN

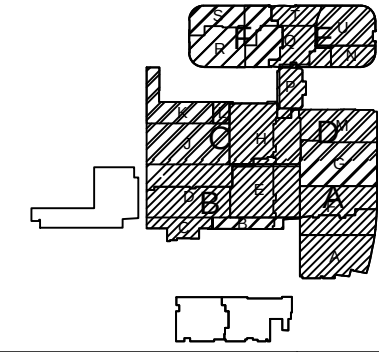

NO.	REV DESCRIPTION REV DATE	APPROVED BY
1.	AS BUILTS 08/15/2012	JOHN J. CHRISTIE



PROJECT:
CHOC CHILDREN'S
HOSPITAL
455 SOUTH MAIN ST.
ORANGE, CA 92668

DRAWING TITLE:
FIFTH LEVEL CCTV POINT
TO POINT DIAGRAM RM
5.123

DRN BY	DATE DRN	CHK BY	DATE CHK
JOSH G.	08/08/2012	JJC	
SCALE:	NTS		
DWG NO.	SE4.10		

ASBUILTS
08/15/2012

Pin outs	T568B	
5	WHITE/BLUE	T1
4	BLUE	R1
3	WHITE/GREEN	T3
6	GREEN	R3
1	WHITE/ORANGE	T2
2	ORANGE	R2
7	WHITE/BROWN	T4
8	BROWN	R4

DRAWING PREPARED BY:



1511 E. ORANGETHORPE BLVD.
FULLERTON, CALIFORNIA 92831
714-525-4350 - o; 714-525-4386 - f
(c) Copyright 2012 KRATOS | HBE
All Rights Reserved.

MUST BE SIGNED BY HBE
TO AUTHENTICATE CONTENT(S).
ALL DETAILS CHECKED FOR ACCURACY.


SIGNATURE _____ DATE _____

HBE JOB #

CONFIDENTIAL

THE INFORMATION CONTAINED HEREIN MAY
NOT BE USED OR REPRODUCED IN ANY
MANNER WITHOUT WRITTEN PERMISSION OF
KRATOS | HBE.

KEY PLAN

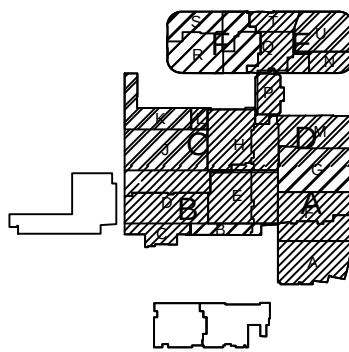

NO.	REV DESCRIPTION REV DATE	APPROVED BY
1.	AS BUILTS 08/15/2012	JOHN J. CHRISTIE

REV.	DESCRIPTION	APPROVED BY
------	-------------	-------------

CUSTOMER:




PROJECT:

CHOC CHILDREN'S
HOSPITAL
455 SOUTH MAIN ST.
ORANGE, CA 92668

DRAWING TITLE:

FIFTH LEVEL CCTV POINT
TO POINT DIAGRAM RM
5.101

DRN BY	DATE DRN	CHK BY	DATE CHK
JOSH G.	08/08/2012	JJC	
SCALE:	NTS		
DWG NO.	SE4.11		

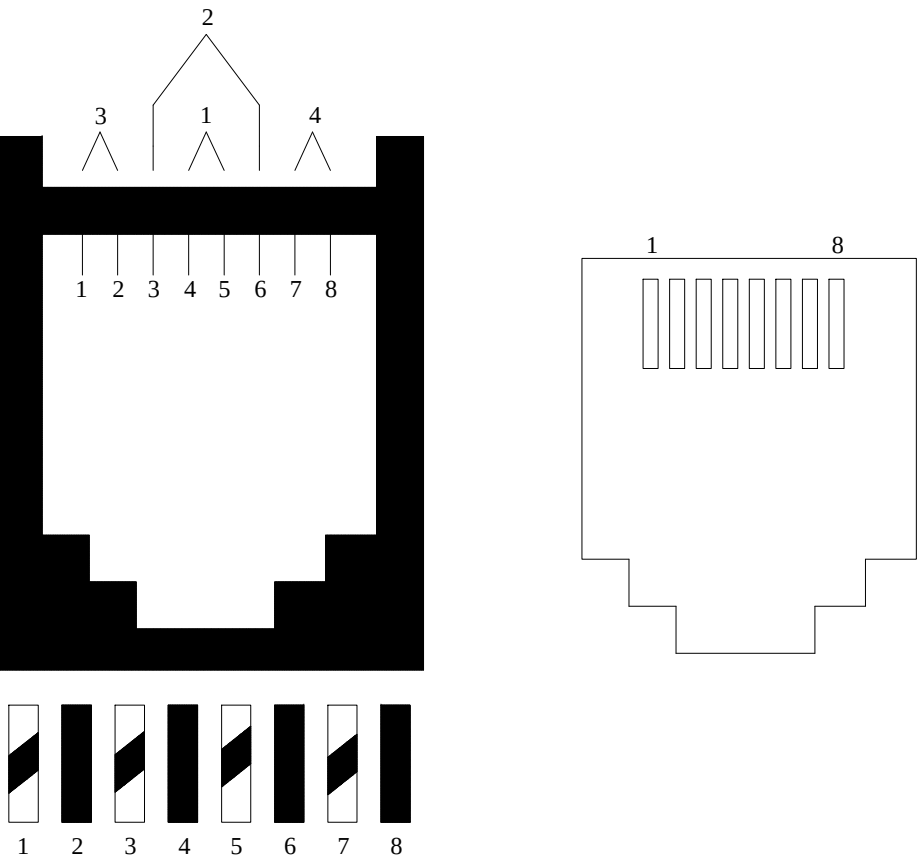


REAR VIEW OF
PATCH PANEL
PROVIDED BY
OTHERS

FRONT VIEW OF
PATCH PANEL
PROVIDED BY
OTHERS


NETWORK
SWITCH BY
OTHERS

FACTORY MADE
PATCH CABLES


CATEGORY 6 CABLING

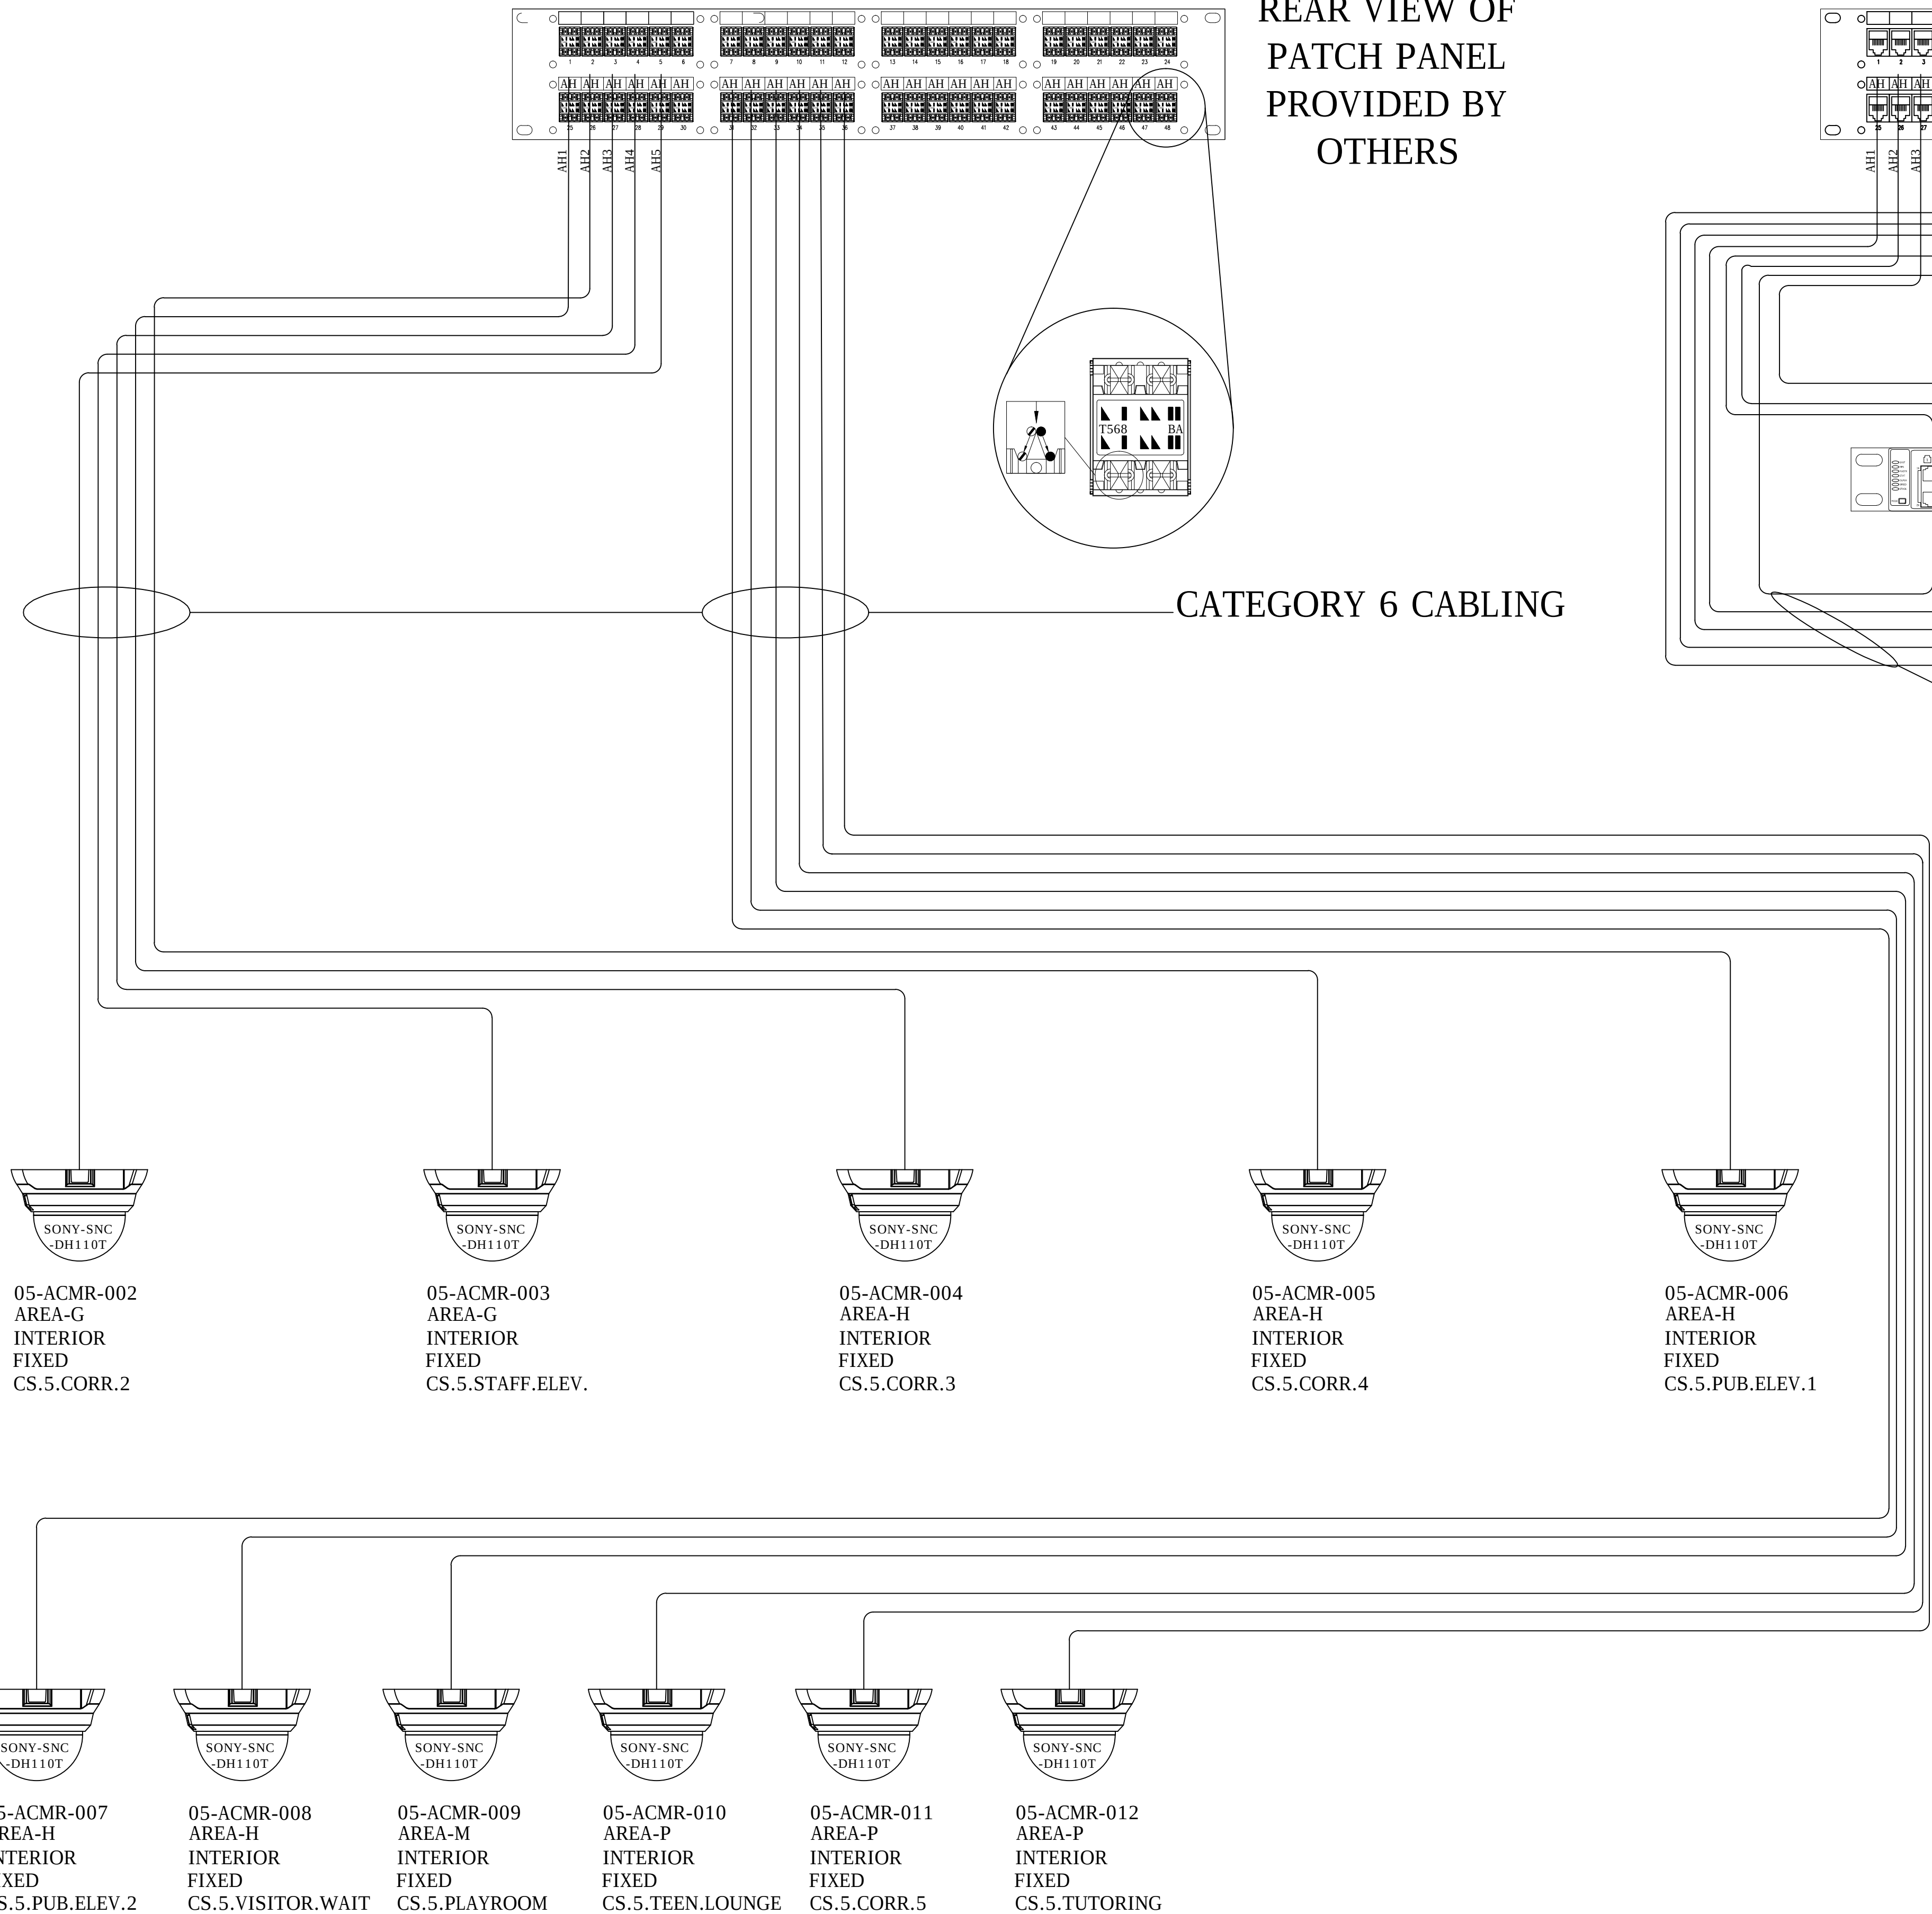

ASBUILTS
08/15/2012

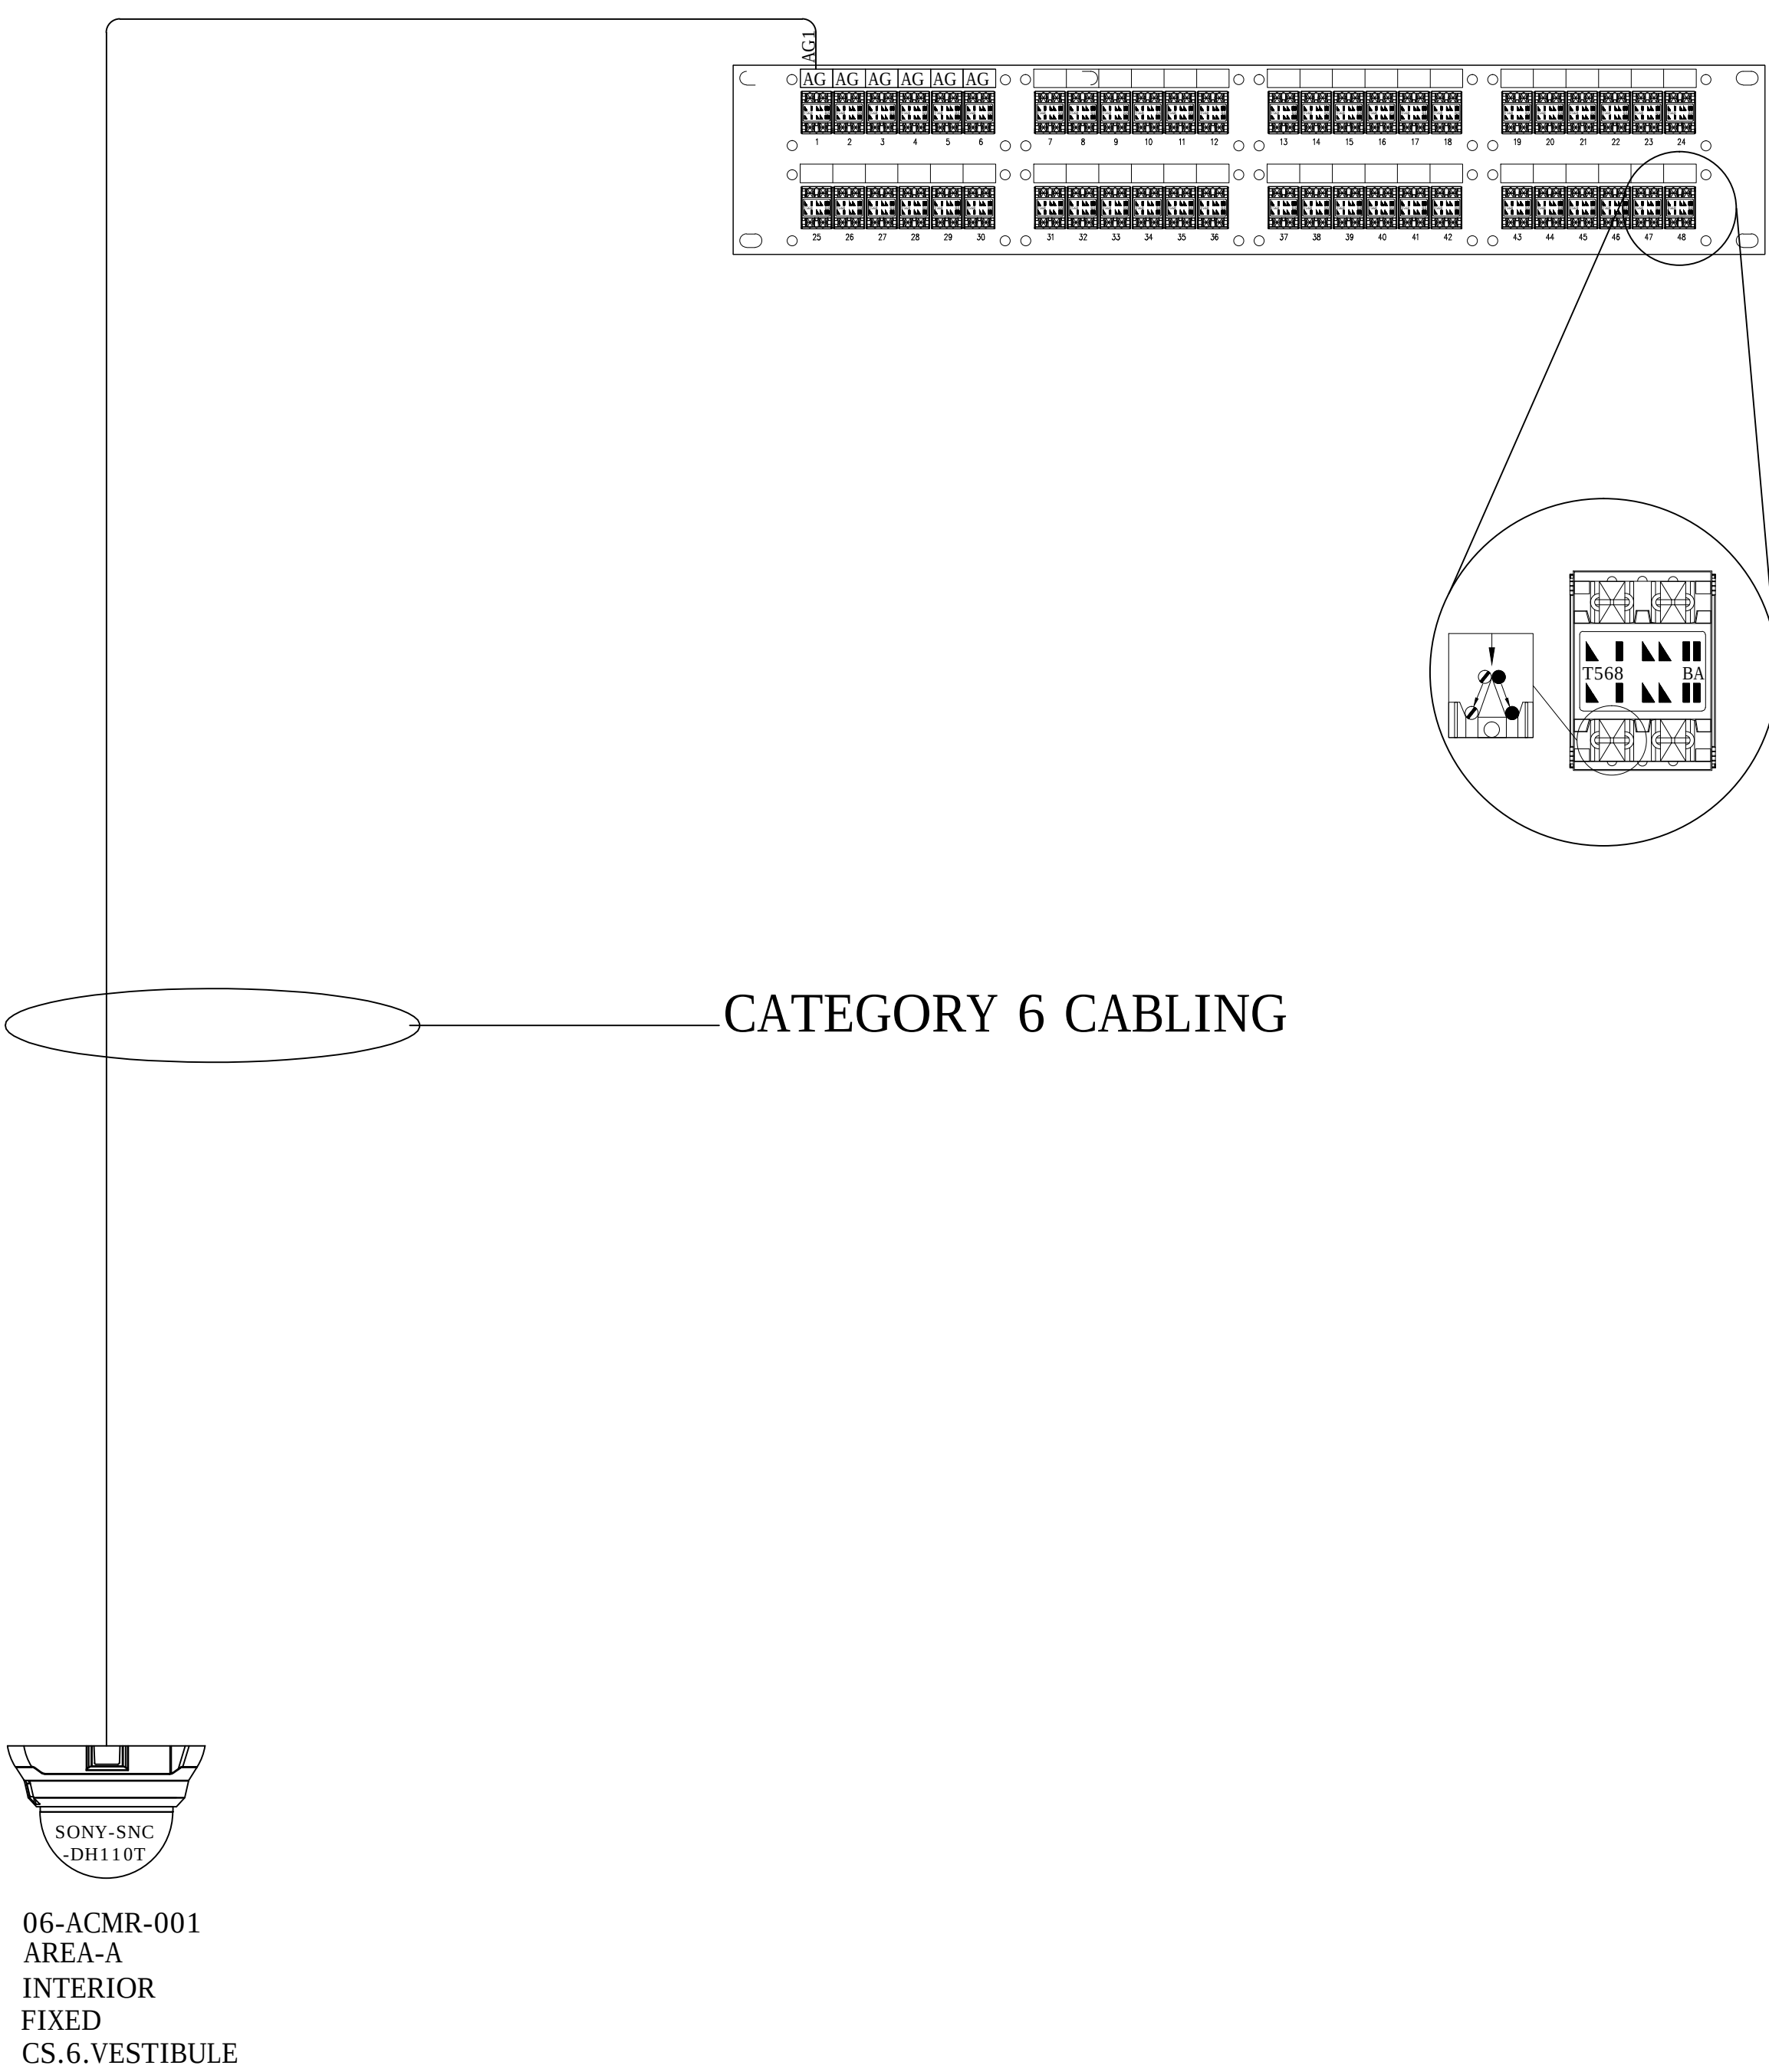


REAR VIEW OF
PATCH PANEL
PROVIDED BY
OTHERS

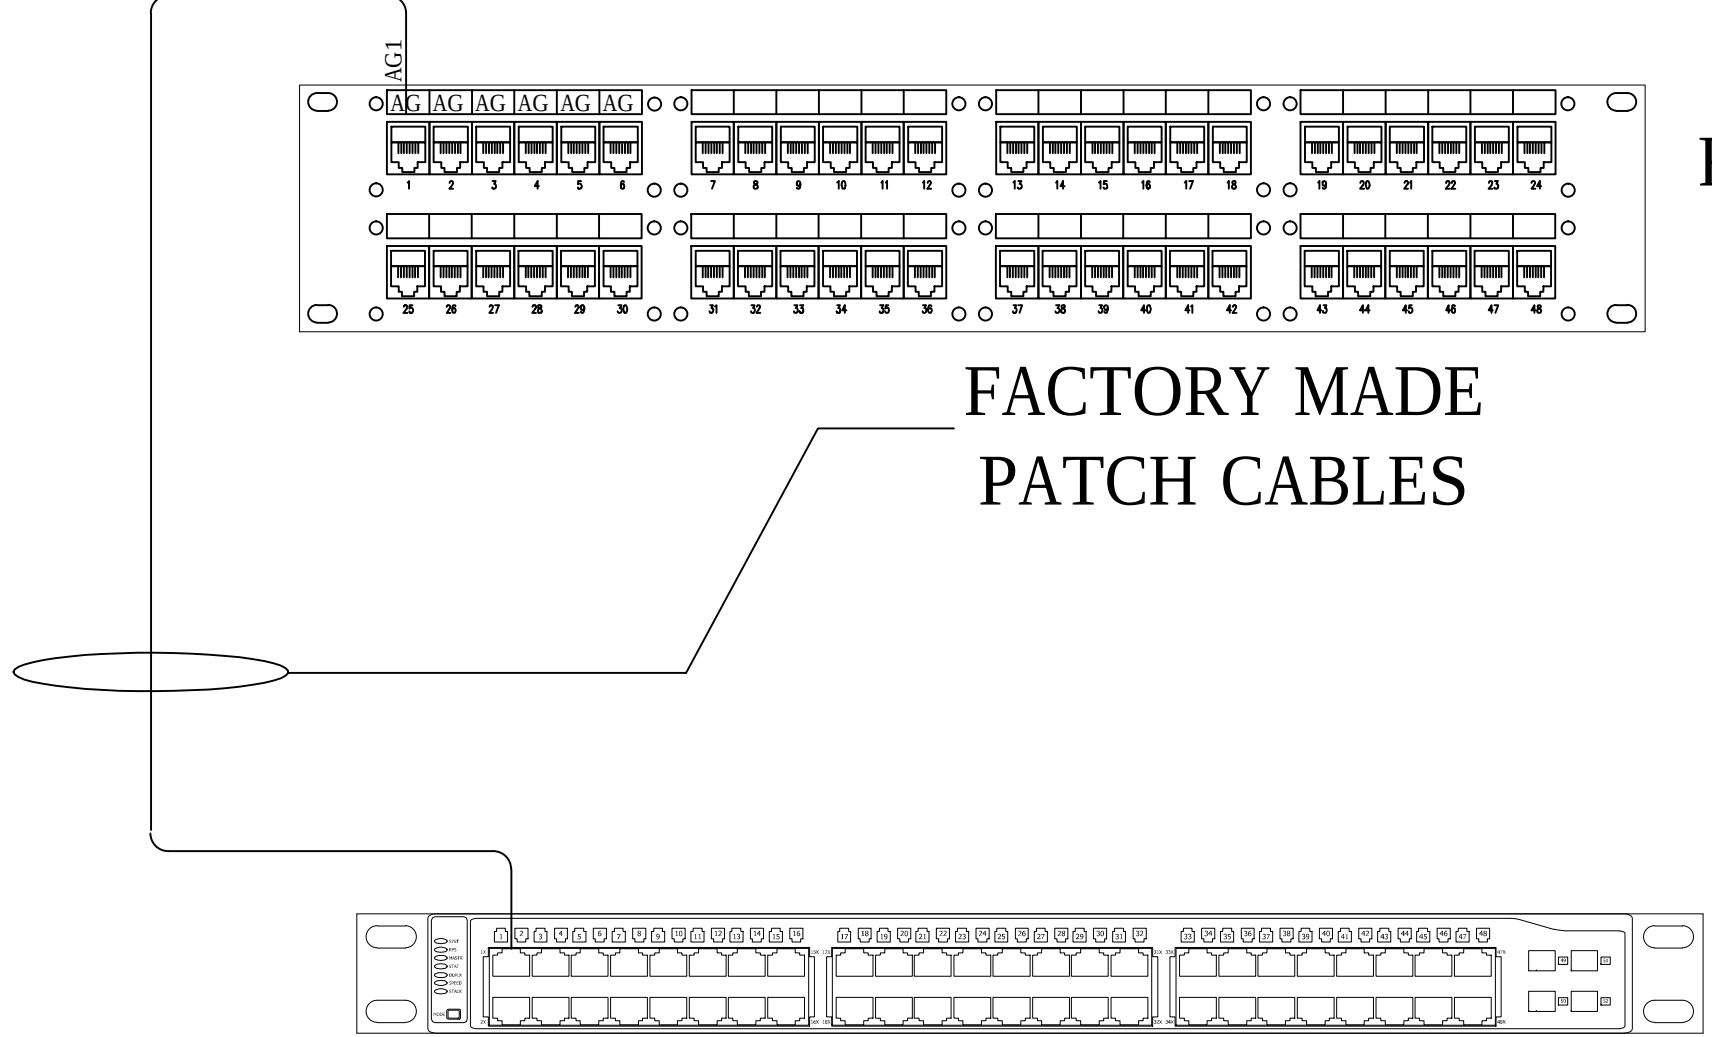

FRONT VIEW OF
PATCH PANEL
PROVIDED BY
OTHERS

Pin outs	T568B	
5	WHITE/BLUE	T1
4	BLUE	R1
3	WHITE/GREEN	T3
6	GREEN	R3
1	WHITE/ORANGE	T2
2	ORANGE	R2
7	WHITE/BROWN	T4
8	BROWN	R4

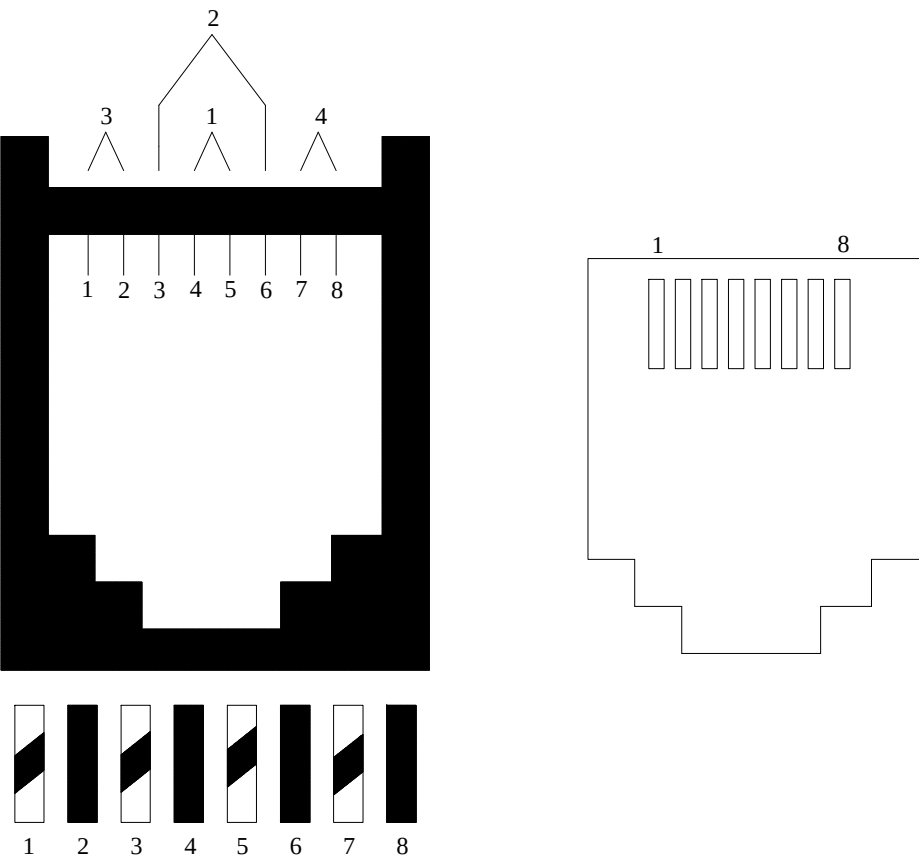

DRAWING PREPARED BY:



1511 E. ORANGETHORPE BLVD.
FULLERTON, CALIFORNIA 92831
714-525-4350 - o; 714-525-4386 - f
(c) Copyright 2012 KRATOS | HBE
All Rights Reserved.

MUST BE SIGNED BY HBE
TO AUTHENTICATE CONTENT(S).
ALL DETAILS CHECKED FOR ACCURACY.


SIGNATURE _____ DATE _____

HBE JOB #

CONFIDENTIAL

THE INFORMATION CONTAINED HERIN MAY
NOT BE USED OR REPRODUCED IN ANY
MANNER WITHOUT WRITTEN PERMISSION OF
KRATOS | HBE.

KEY PLAN

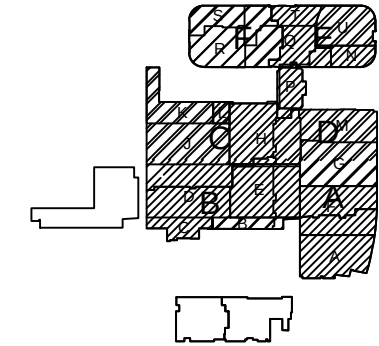

NO.	REV DESCRIPTION REV DATE	APPROVED BY
1.	AS BUILTS 08/15/2012	JOHN J. CHRISTIE

REV.	DESCRIPTION	APPROVED BY
------	-------------	-------------

CUSTOMER:





PROJECT:
CHOC CHILDREN'S
HOSPITAL
455 SOUTH MAIN ST.
ORANGE, CA 92668


DRAWING TITLE:
SIXTH LEVEL CCTV POINT
TO POINT DIAGRAM RM
6.121

DRN BY	DATE DRN	CHK BY	DATE CHK
JOSH G.	08/08/2012	JJC	
SCALE:	NTS		
DWG NO.	SE4.12		

ASBUILTS
08/15/2012

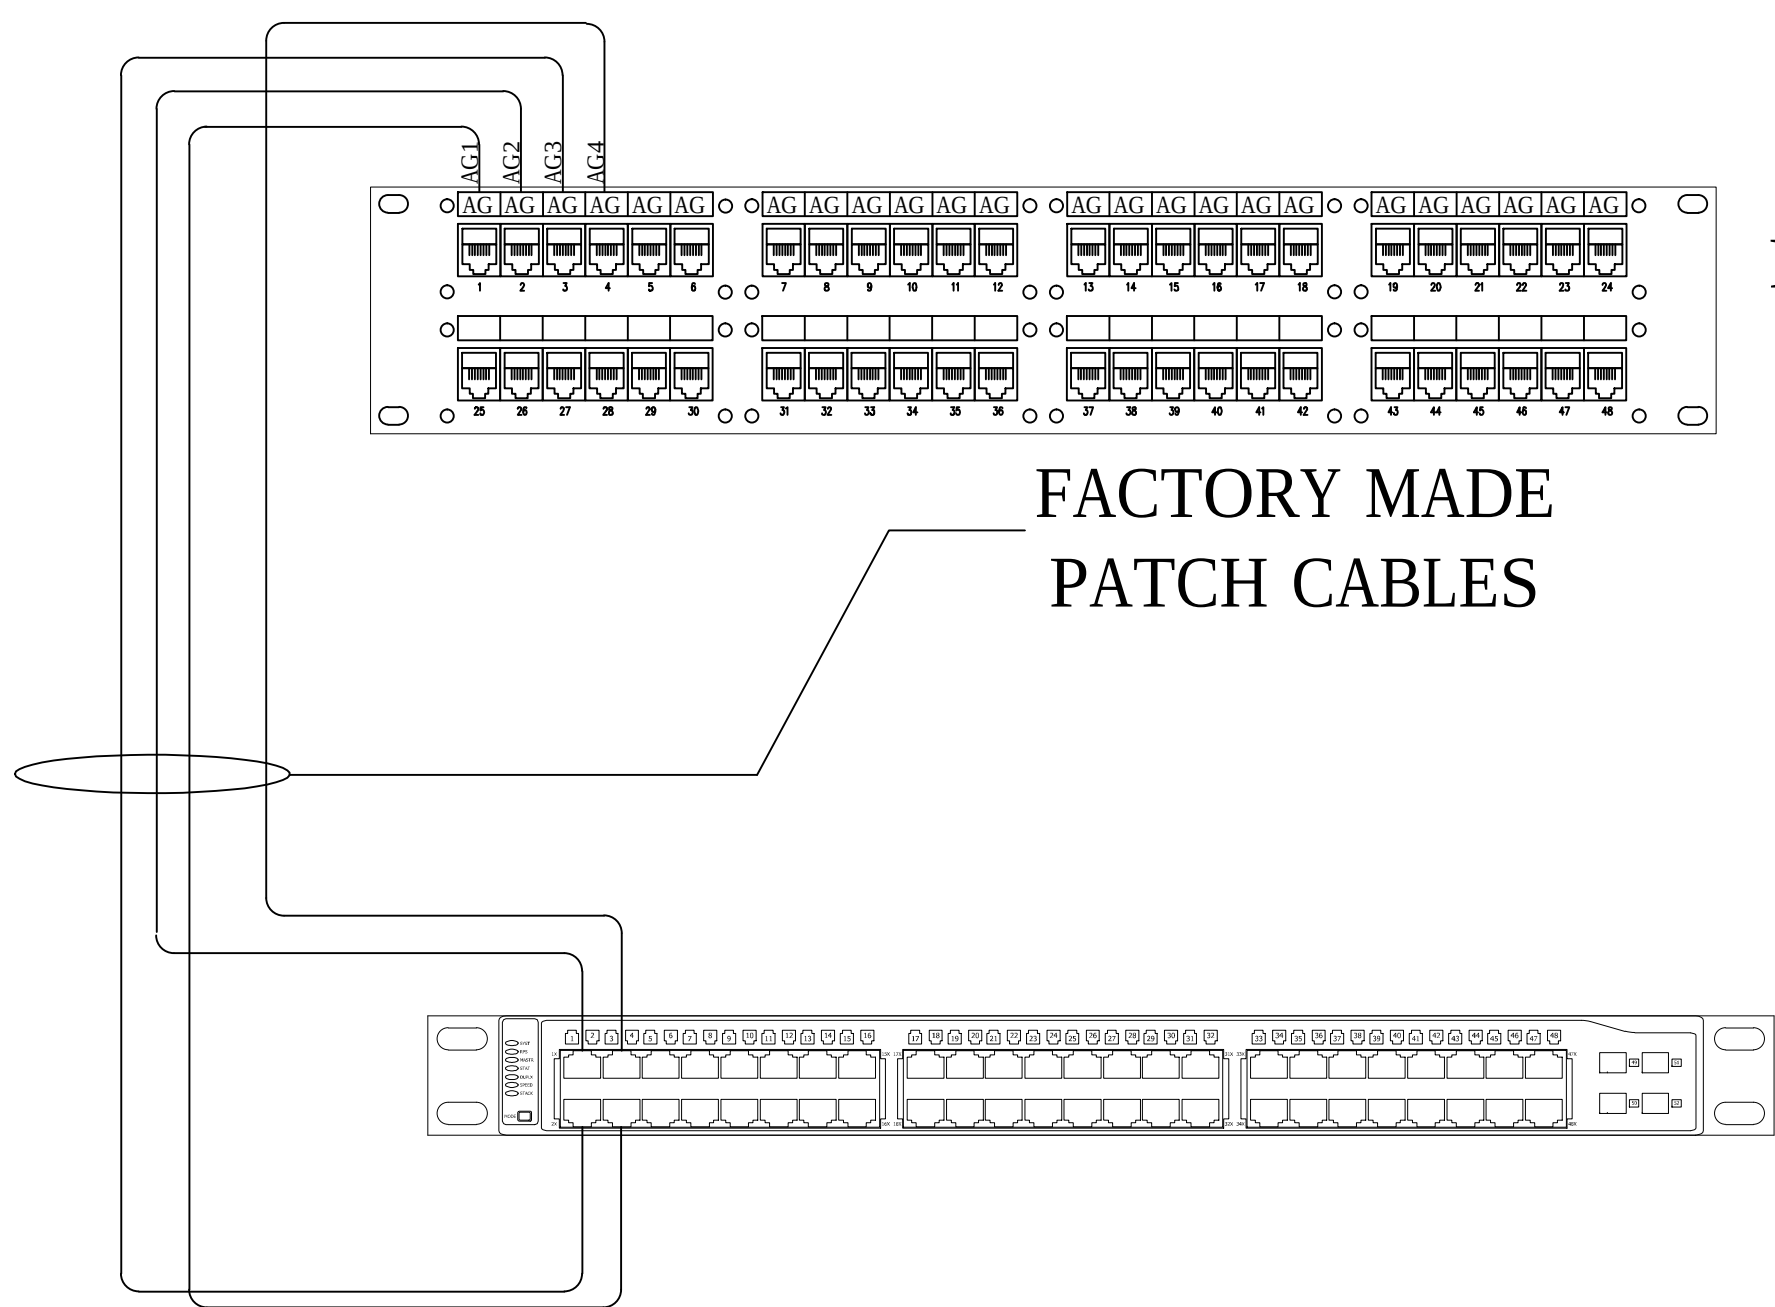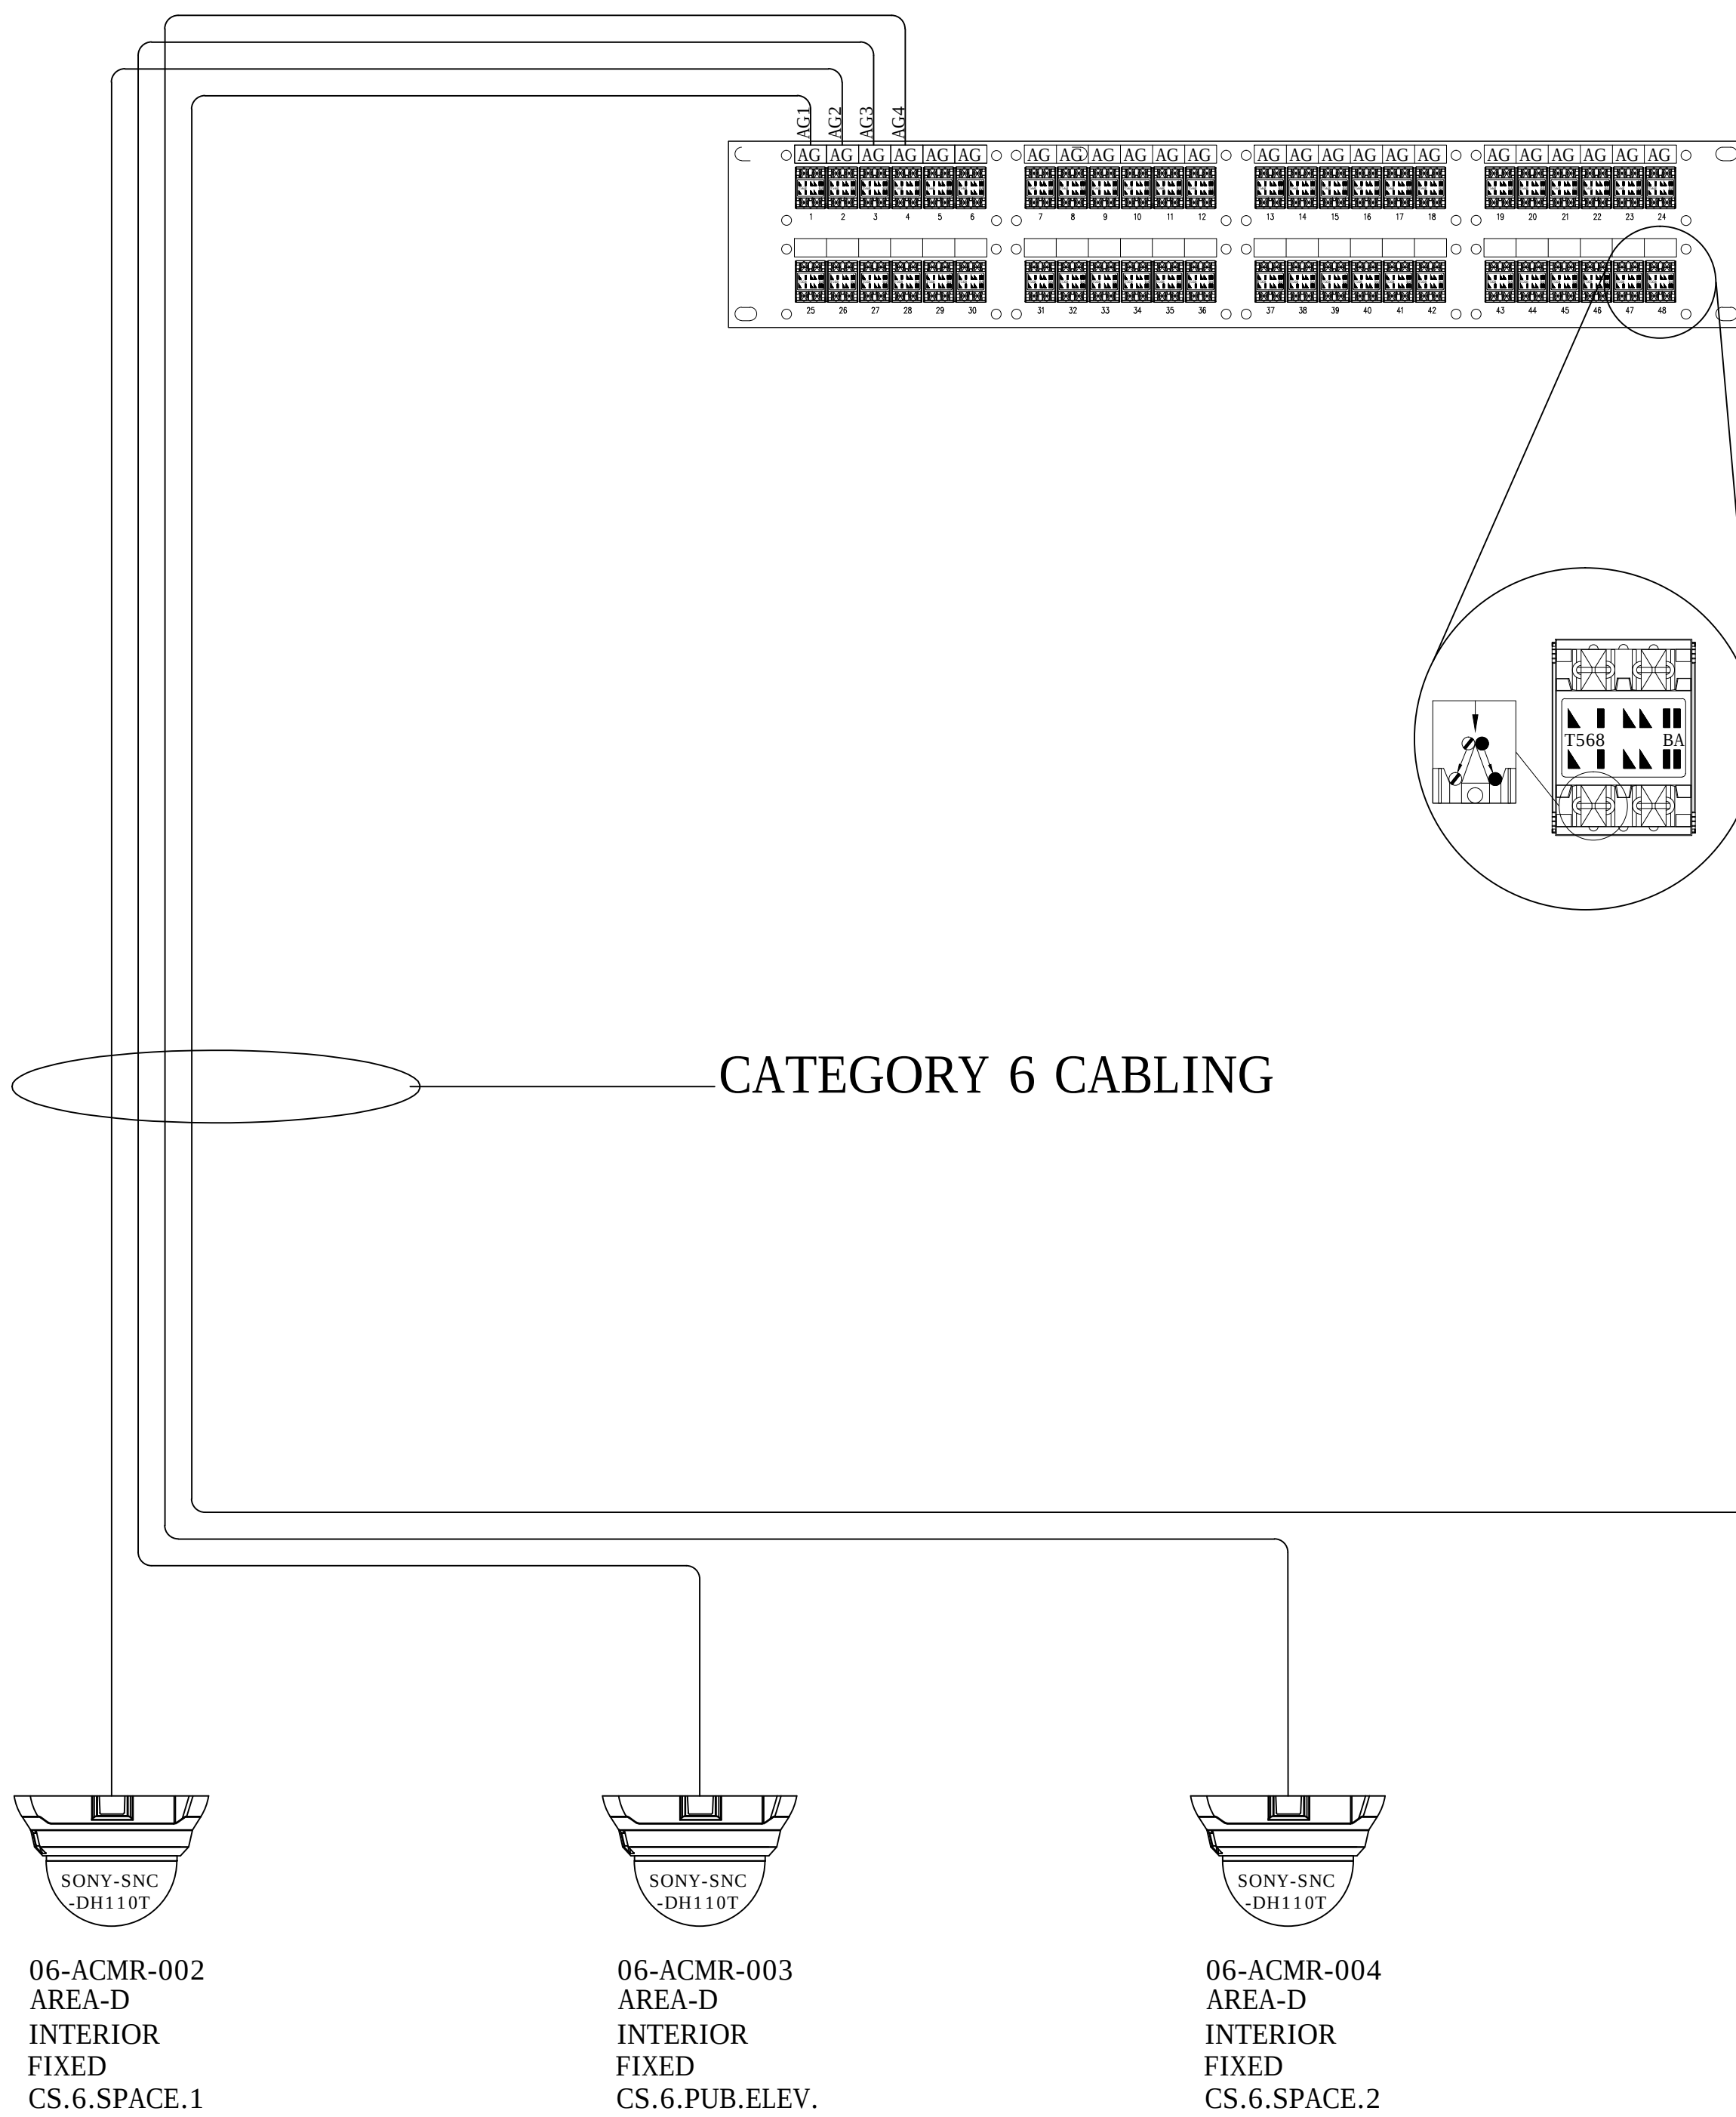

Pin outs	T568B	
5	WHITE/BLUE	T1
4	BLUE	R1
3	WHITE/GREEN	T3
6	GREEN	R3
1	WHITE/ORANGE	T2
2	ORANGE	R2
7	WHITE/BROWN	T4
8	BROWN	R4

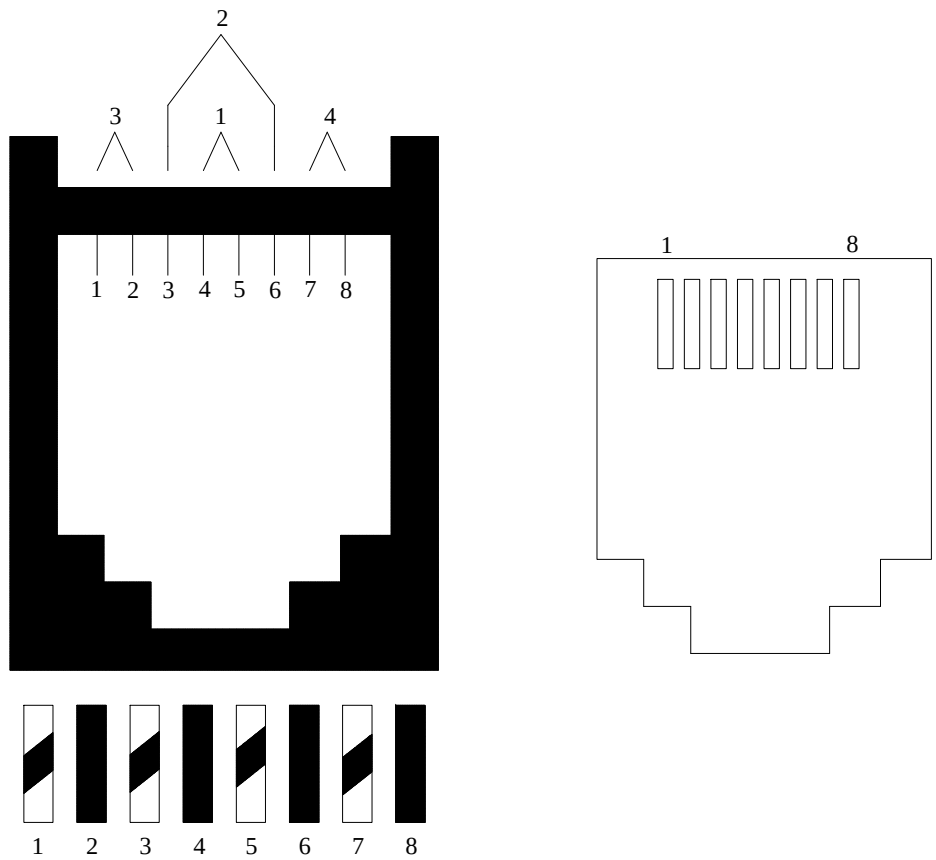

DRAWING PREPARED BY:

KRATOS
HBE

1511 E. ORANGETHORPE BLVD.
FULLERTON, CALIFORNIA 92831
714-525-4350 - o; 714-525-4386 - f
(c) Copyright 2012 KRATOS | HBE
All Rights Reserved.

MUST BE SIGNED BY HBE
TO AUTHENTICATE CONTENT(S).
ALL DETAILS CHECKED FOR ACCURACY.


SIGNATURE _____ DATE _____

HBE JOB #

CONFIDENTIAL

THE INFORMATION CONTAINED HERIN MAY
NOT BE USED OR REPRODUCED IN ANY
MANNER WITHOUT WRITTEN PERMISSION OF
KRATOS | HBE.

KEY PLAN

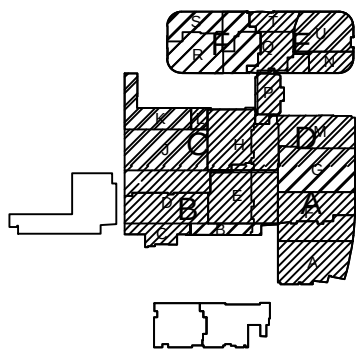

NO.	REV DESCRIPTION REV DATE	APPROVED BY
1.	AS BUILTS 08/15/2012	JOHN J. CHRISTIE

REV.	DESCRIPTION	APPROVED BY
------	-------------	-------------



CUSTOMER:
CHOC
Children's Hospital
of Orange County

PROJECT:
CHOC CHILDREN'S
HOSPITAL
455 SOUTH MAIN ST.
ORANGE, CA 92668


DRAWING TITLE:
SIXTH LEVEL CCTV POINT
TO POINT DIAGRAM RM
6.103.02

DRN BY	DATE DRN	CHK BY	DATE CHK
JOSH G.	08/08/2012	JJC	
SCALE:	NTS		
DWG NO.	SE4.13		

ASBUILTS
08/15/2012

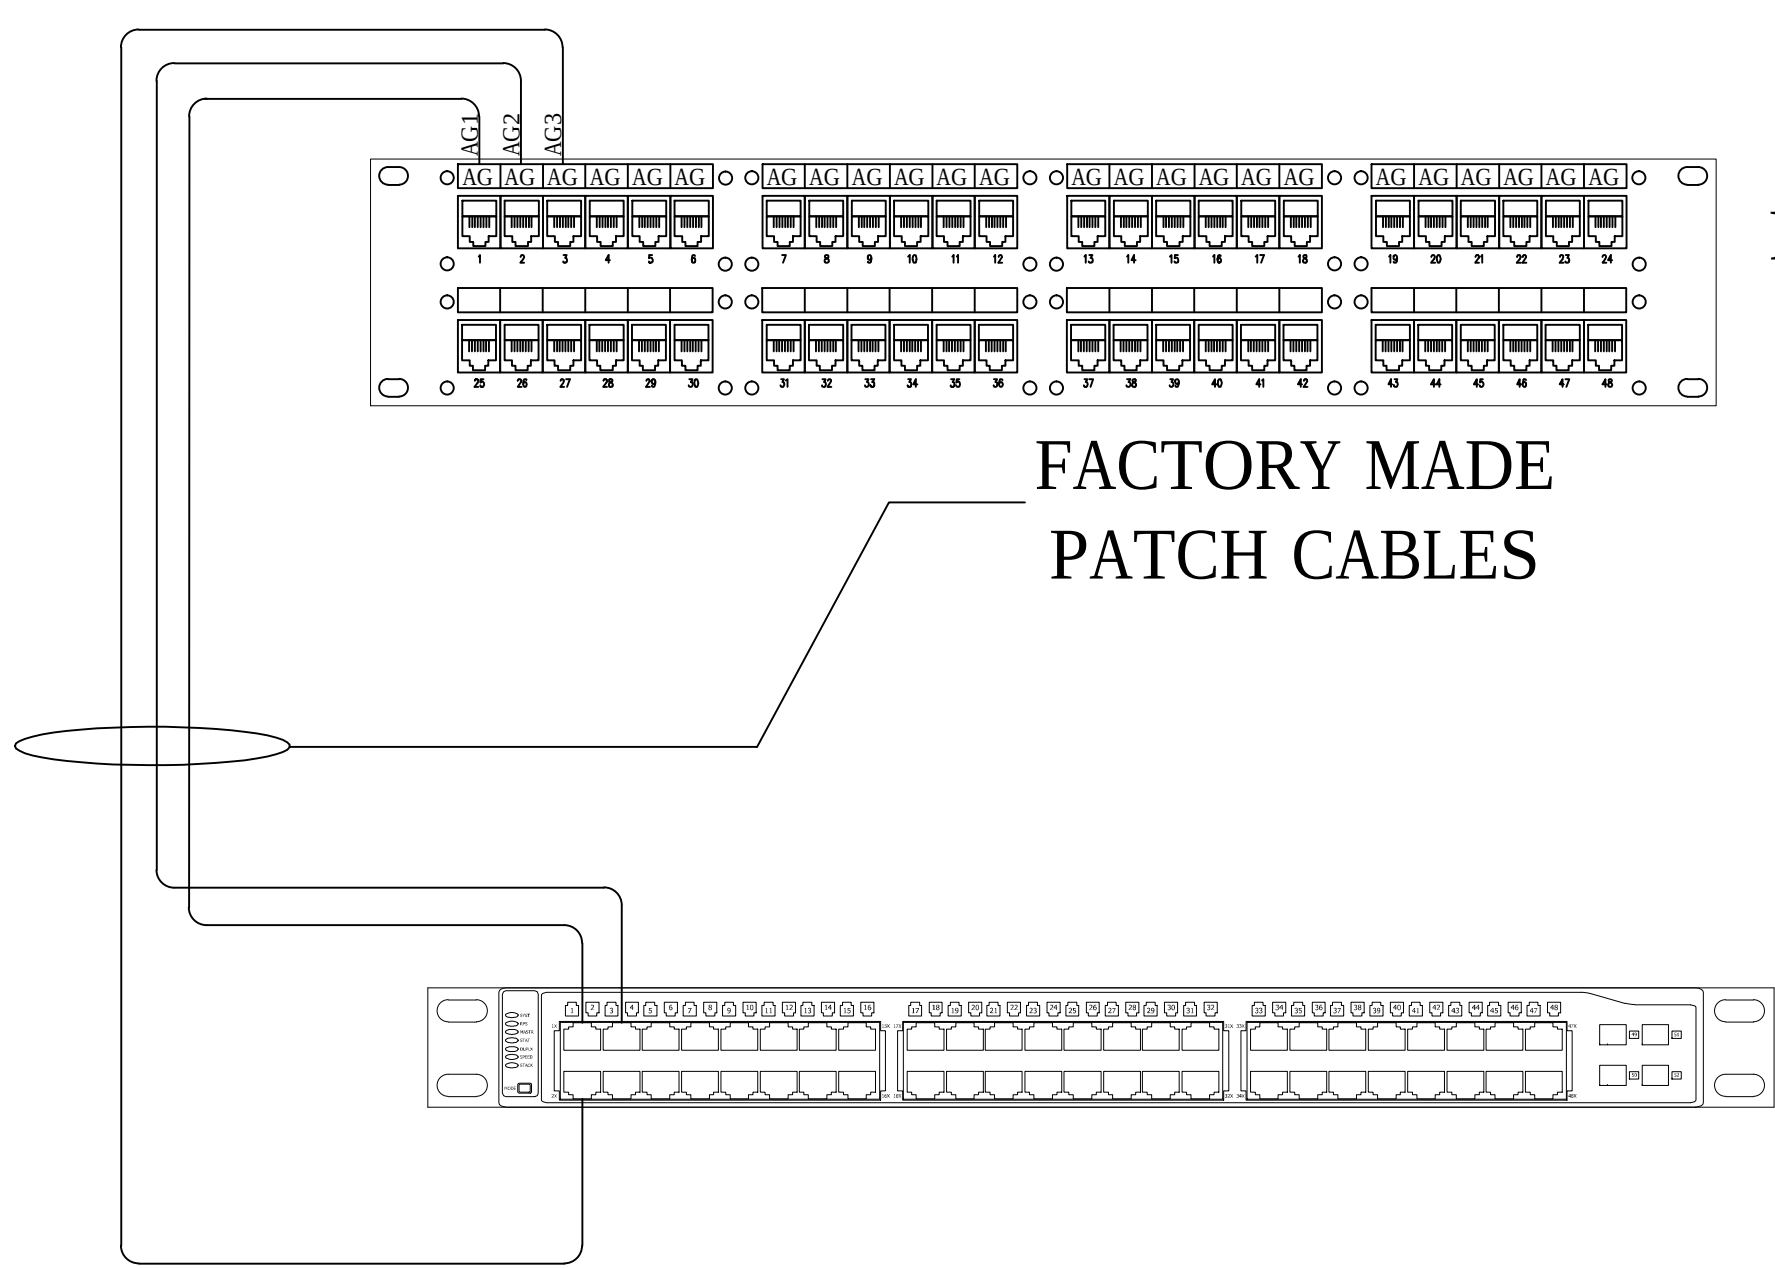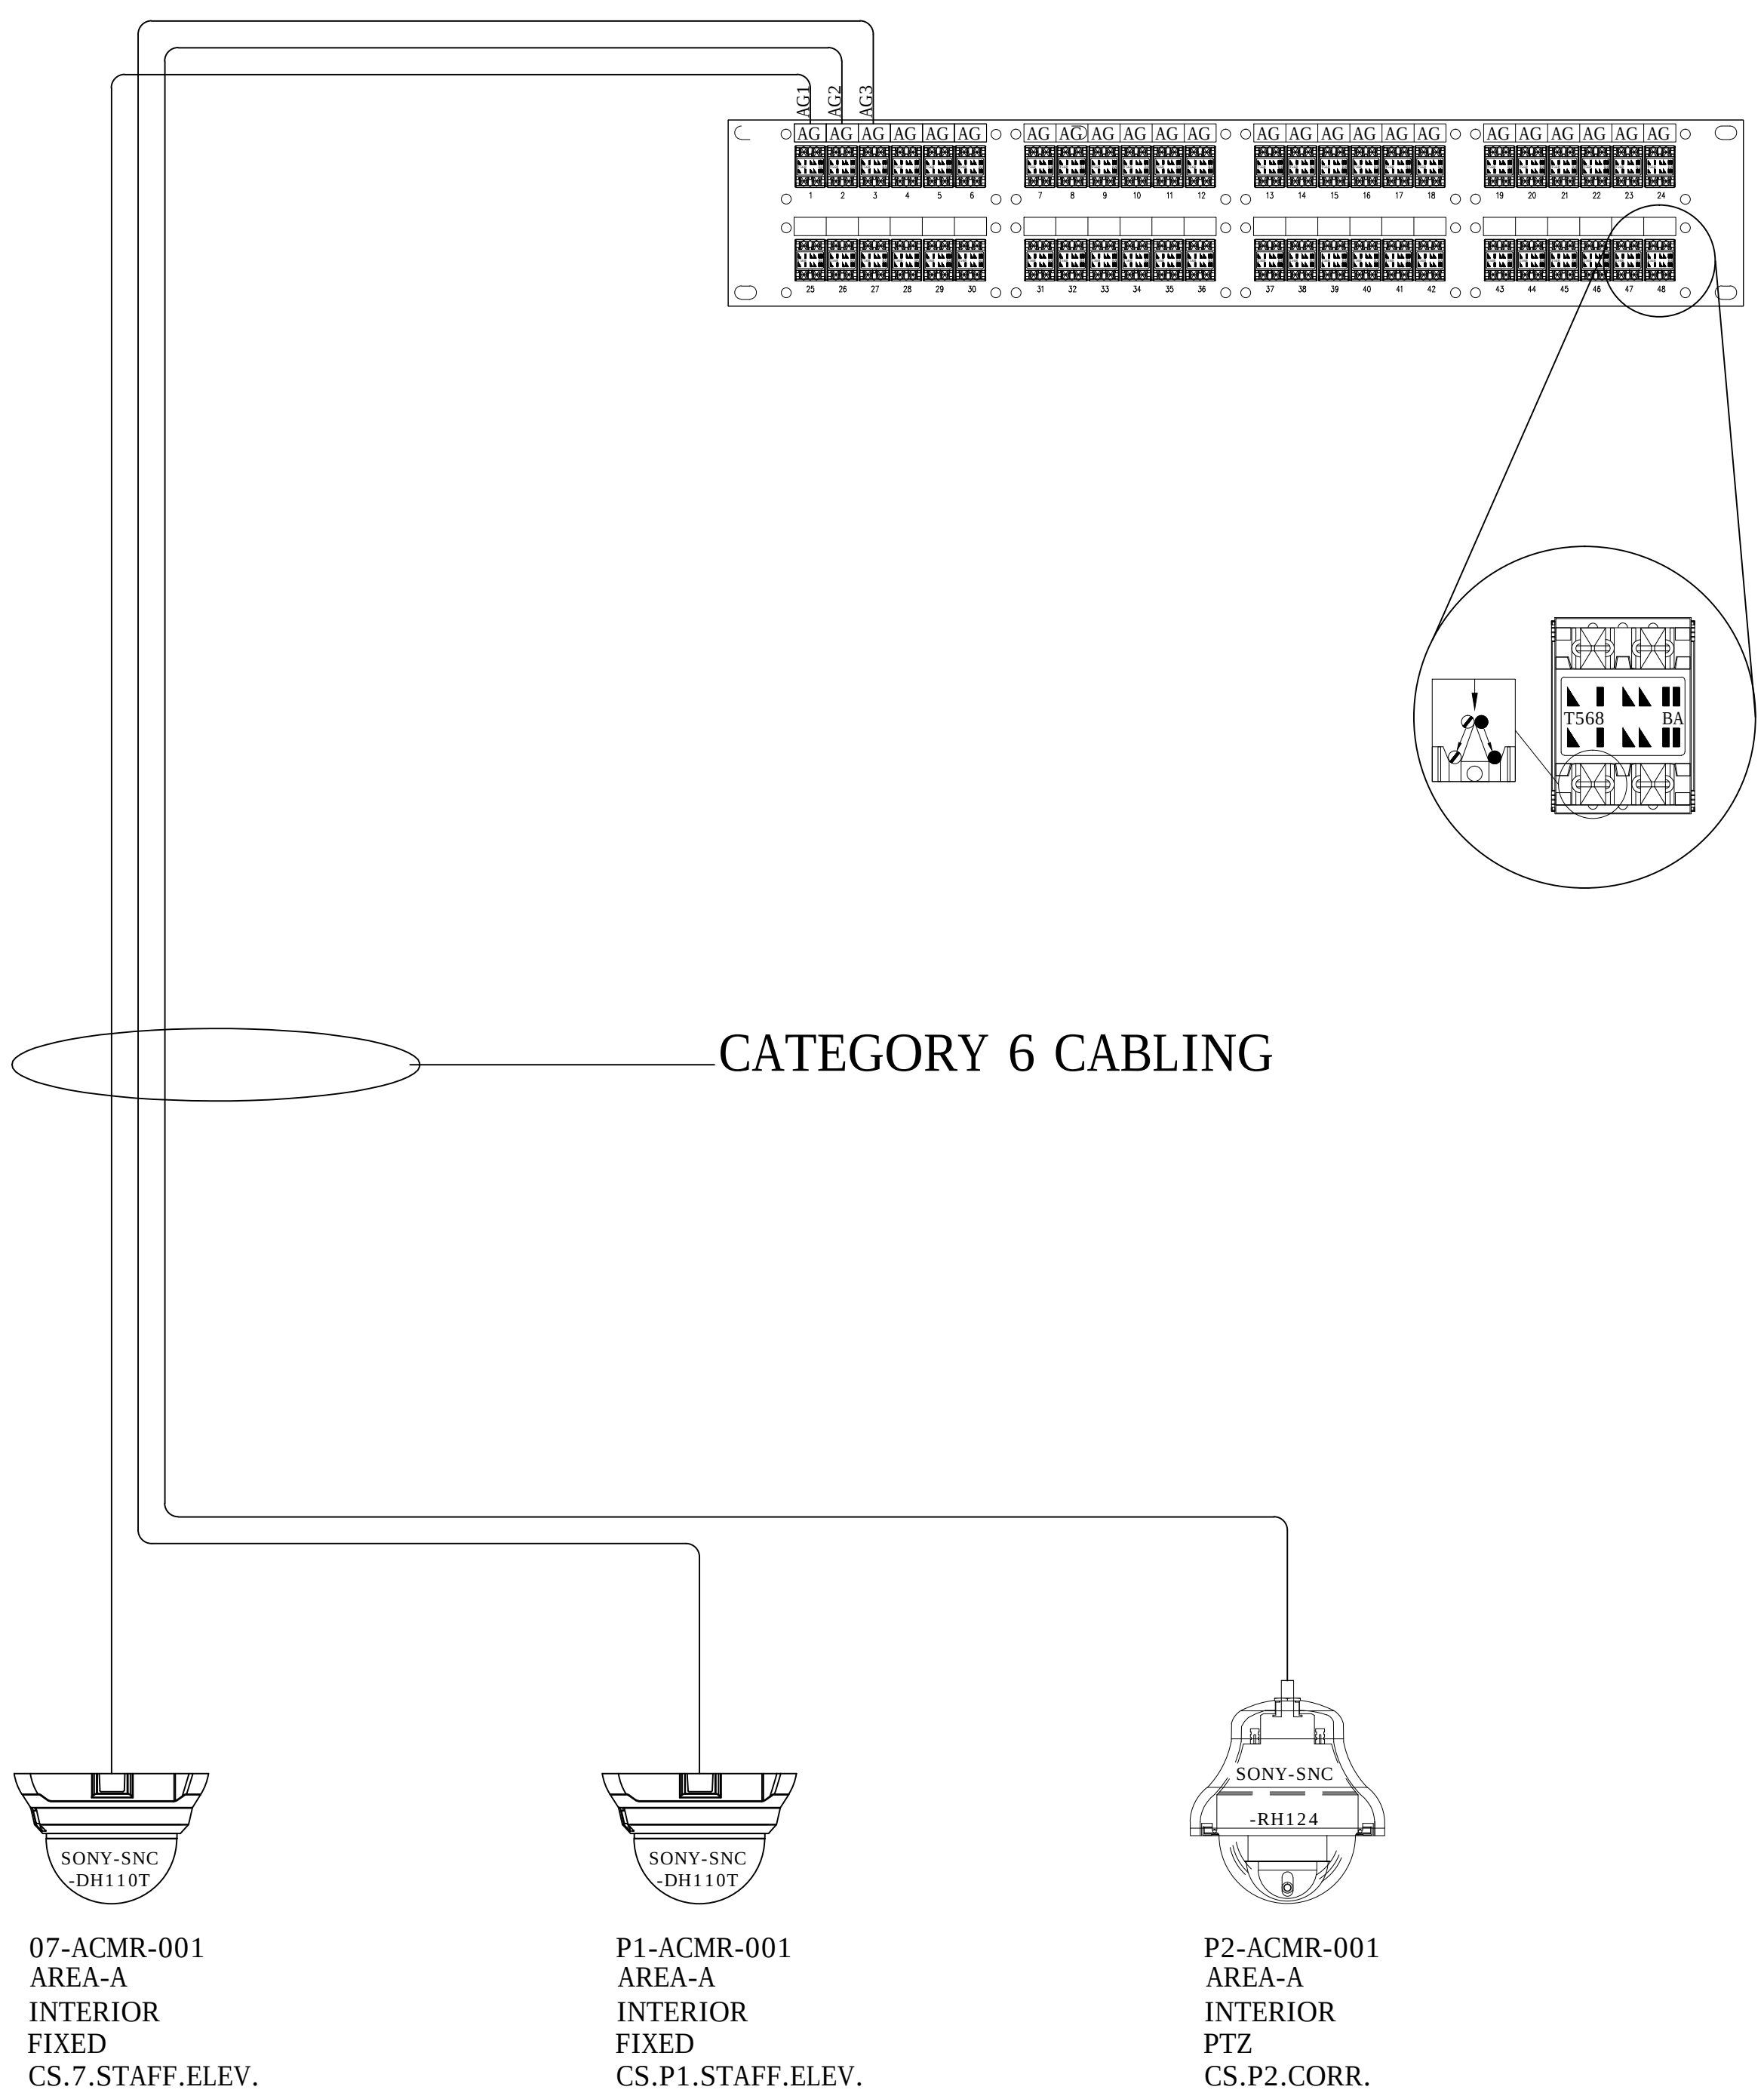

Pin outs	T568B	
5	WHITE/BLUE	T1
4	BLUE	R1
3	WHITE/GREEN	T3
6	GREEN	R3
1	WHITE/ORANGE	T2
2	ORANGE	R2
7	WHITE/BROWN	T4
8	BROWN	R4

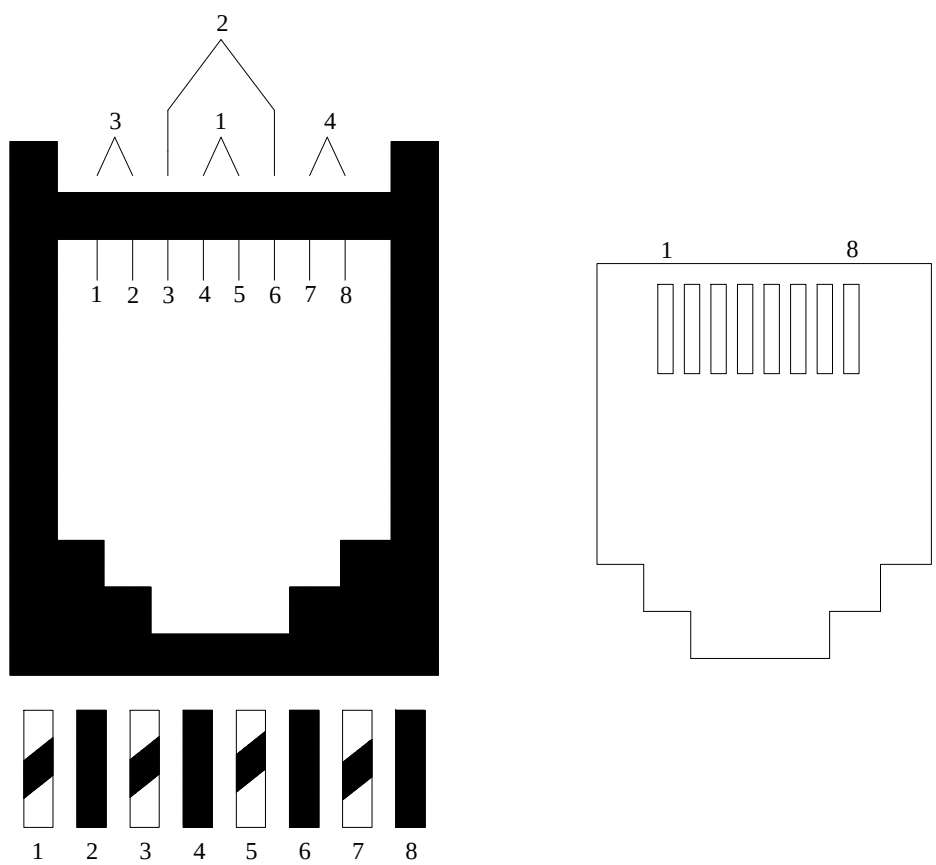

DRAWING PREPARED BY:



1511 E. ORANGETHORPE BLVD.
FULLERTON, CALIFORNIA 92831
714-525-4350 - o; 714-525-4386 - f
(c) Copyright 2012 KRATOS | HBE
All Rights Reserved.

MUST BE SIGNED BY HBE
TO AUTHENTICATE CONTENT(S).
ALL DETAILS CHECKED FOR ACCURACY.


SIGNATURE _____ DATE _____

HBE JOB #

CONFIDENTIAL

THE INFORMATION CONTAINED HERIN MAY
NOT BE USED OR REPRODUCED IN ANY
MANNER WITHOUT WRITTEN PERMISSION OF
KRATOS | HBE.

KEY PLAN

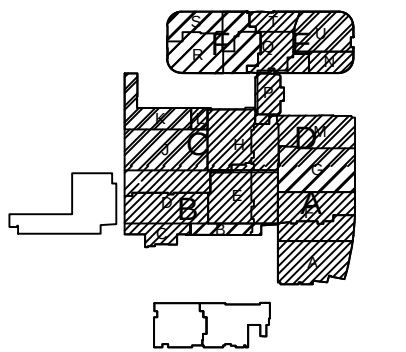

NO.	REV DESCRIPTION REV DATE	APPROVED BY
1.	AS BUILTS 08/15/2012	JOHN J. CHRISTIE

REV. DESCRIPTION APPROVED BY

CUSTOMER:



PROJECT:
CHOC CHILDREN'S
HOSPITAL
455 SOUTH MAIN ST.
ORANGE, CA 92668

DRAWING TITLE:
SEVENTH LEVEL CCTV
POINT TO POINT
DIAGRAM RM 7.121.01

DRN BY	DATE DRN	CHK BY	DATE CHK
JOSH G.	08/08/2012	JJC	
SCALE:	NTS		
DWG NO.	SE4.14		

ASBUILTS
08/15/2012



1511 E. ORANGETHORPE BLVD.
FULLERTON, CALIFORNIA 92831
714-525-4350 - o; 714-525-4386 - f
(c) Copyright 2012 KRATOS | HBE
All Rights Reserved.

MUST BE SIGNED BY HBE
TO AUTHENTICATE CONTENT(S).
ALL DETAILS CHECKED FOR ACCURACY.


SIGNATURE _____ DATE _____

HBE JOB #

CONFIDENTIAL

THE INFORMATION CONTAINED HERIN MAY
NOT BE USED OR REPRODUCED IN ANY
MANNER WITHOUT WRITTEN PERMISSION OF
KRATOS | HBE.

Pin outs	T568B	
5	WHITE/BLUE	T1
4	BLUE	R1
3	WHITE/GREEN	T3
6	GREEN	R3
1	WHITE/ORANGE	T2
2	ORANGE	R2
7	WHITE/BROWN	T4
8	BROWN	R4

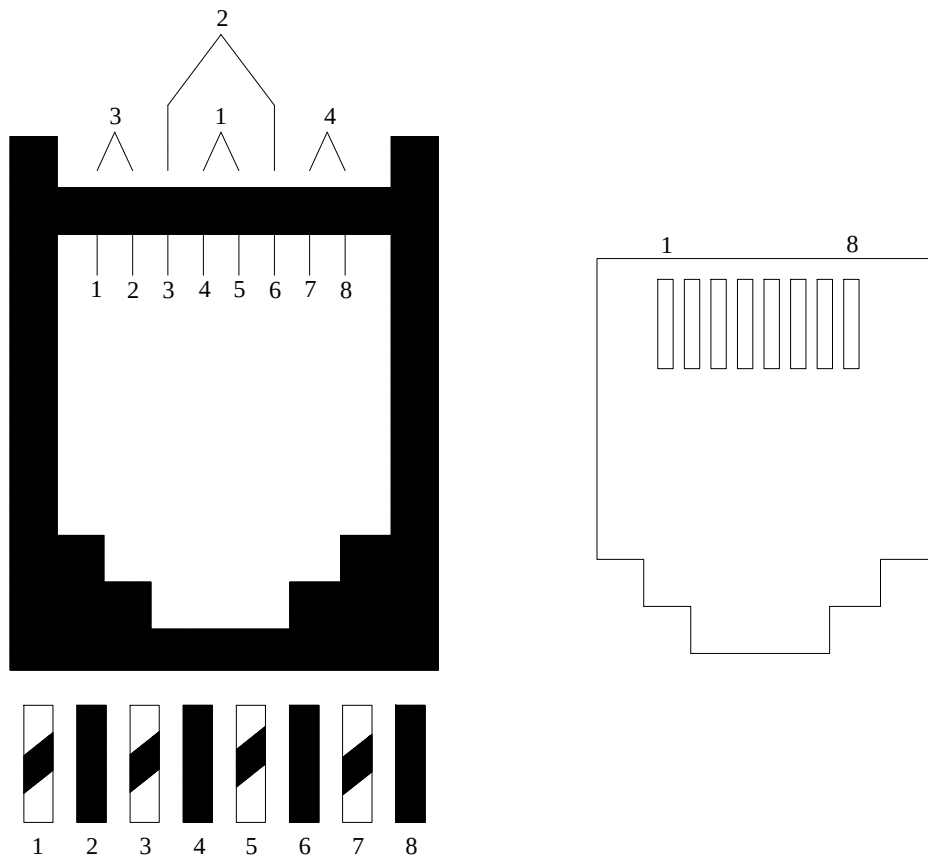


REAR VIEW OF
PATCH PANEL
PROVIDED BY
OTHERS

FRONT VIEW OF
PATCH PANEL
PROVIDED BY
OTHERS


FACTORY MADE
PATCH CABLES

NETWORK
SWITCH BY
OTHERS

CATEGORY 6 CABLING

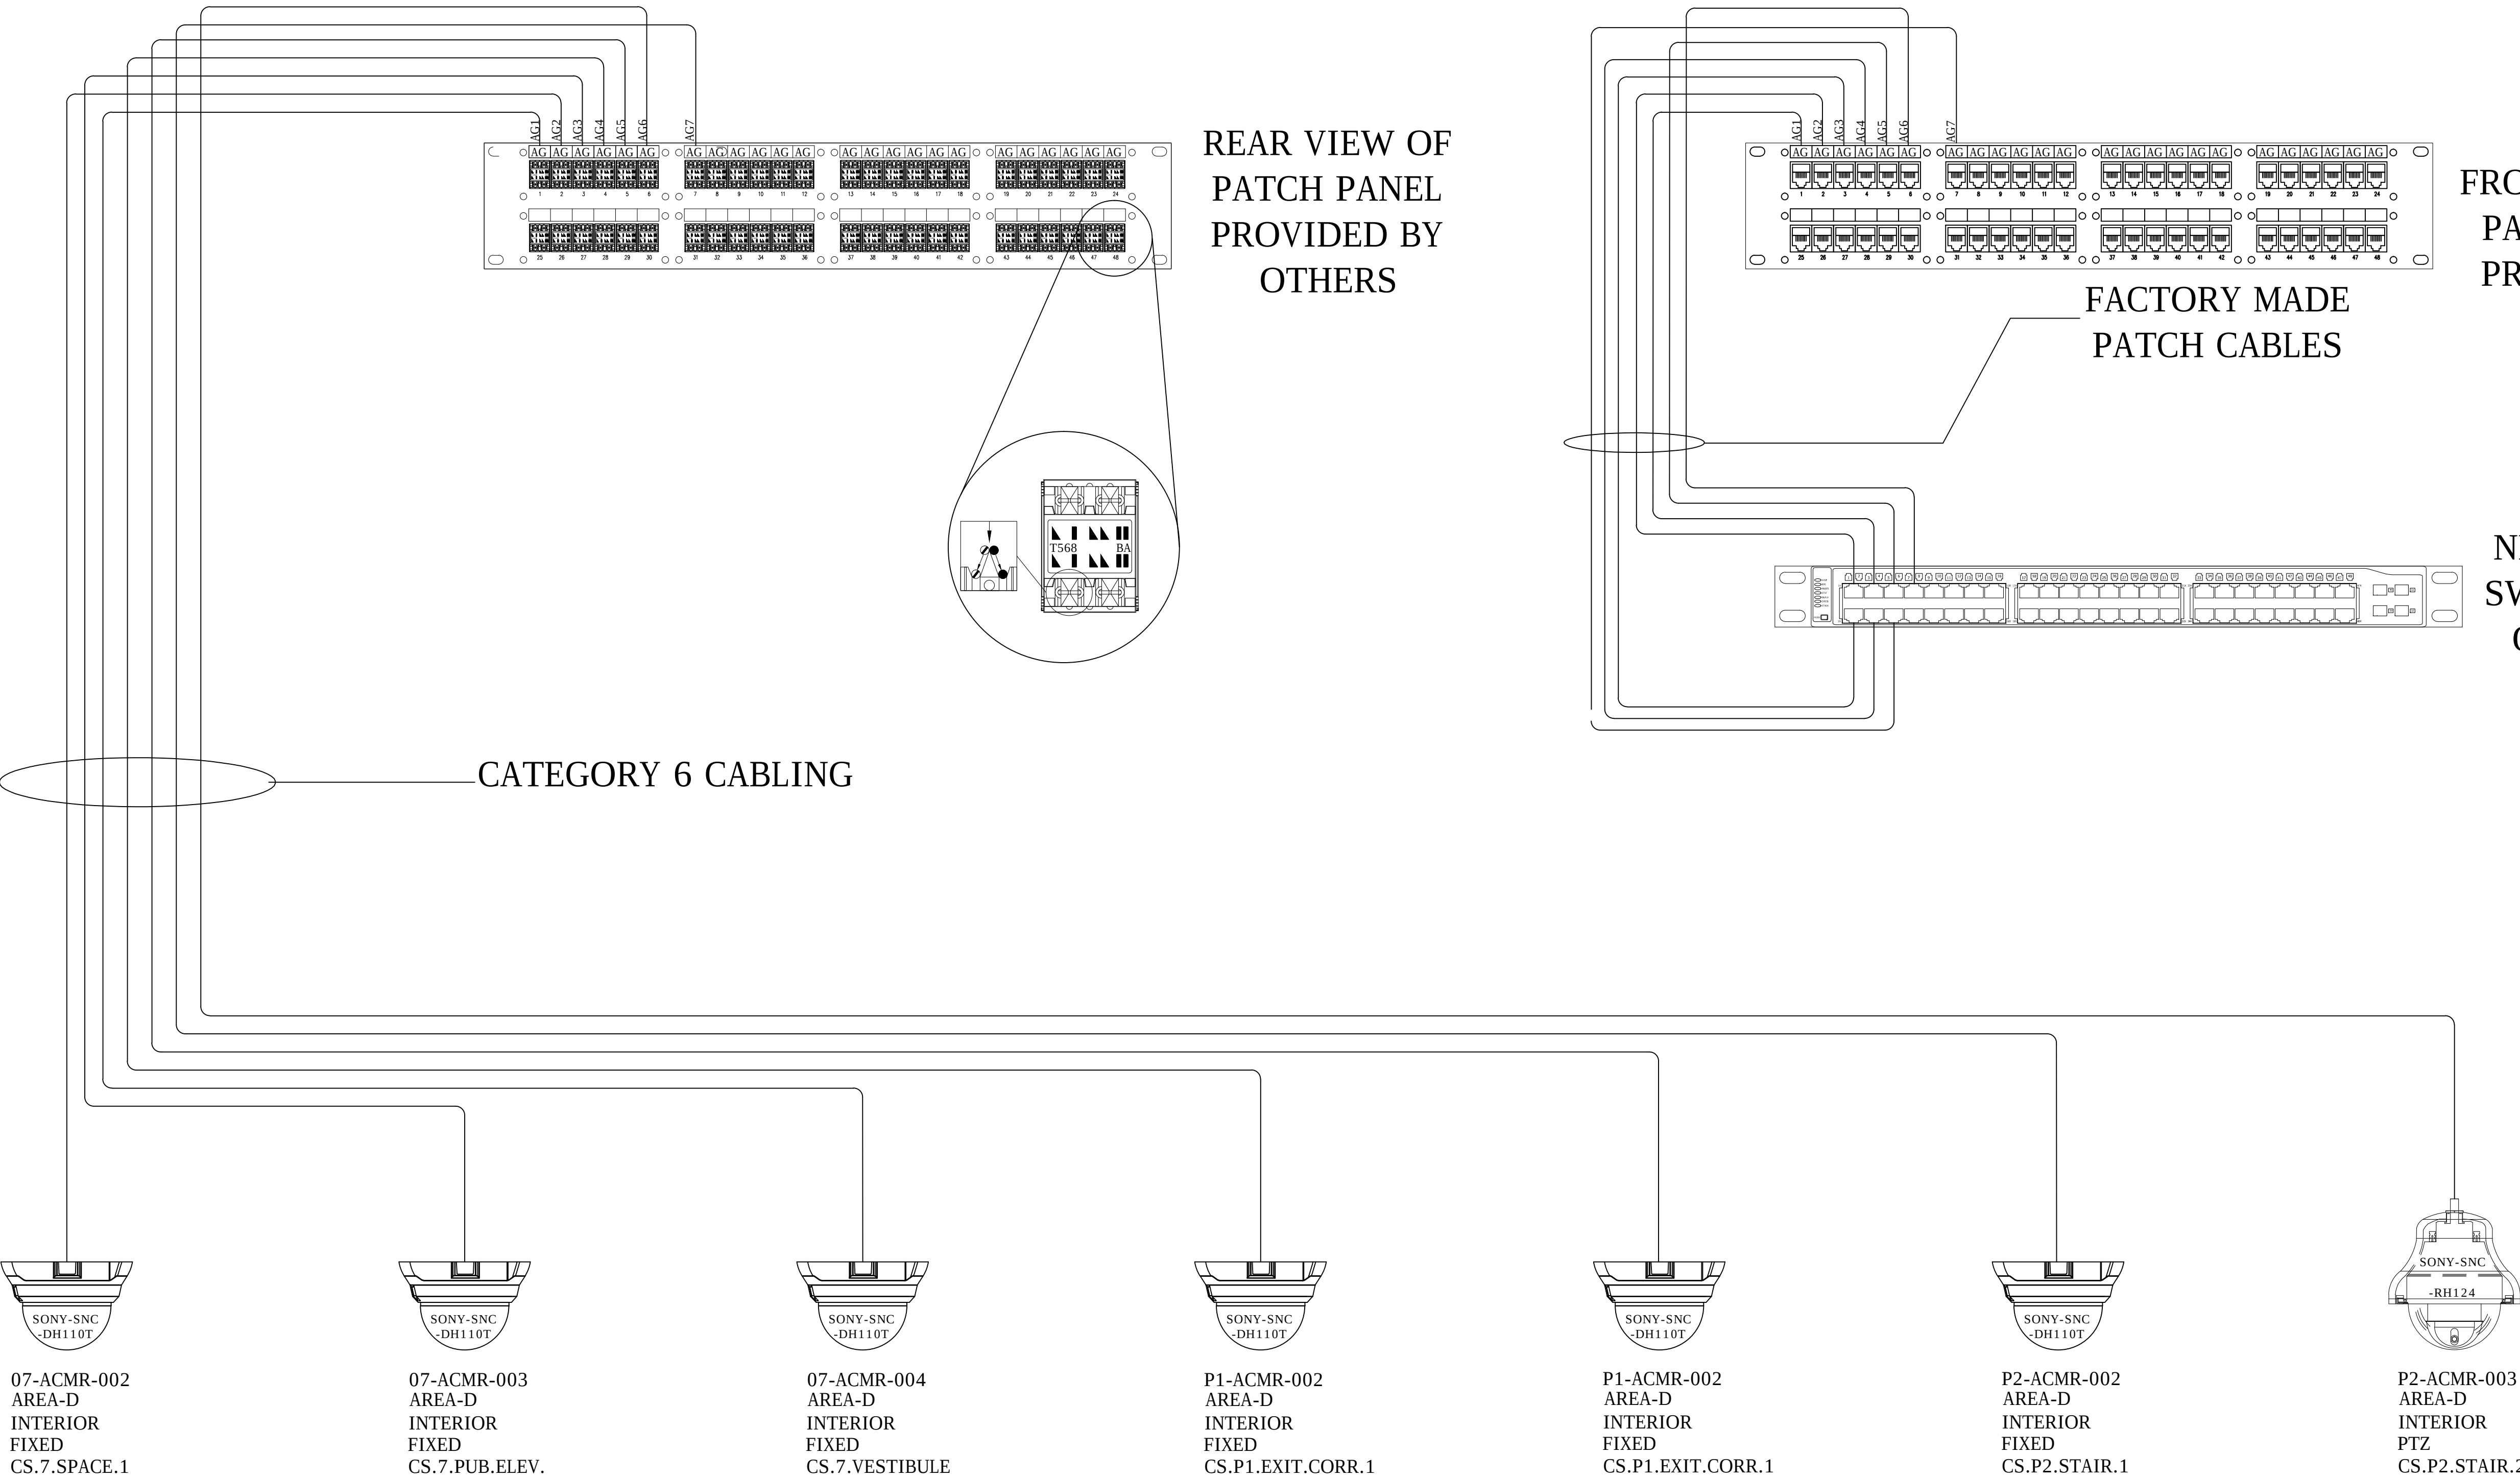

KEY PLAN

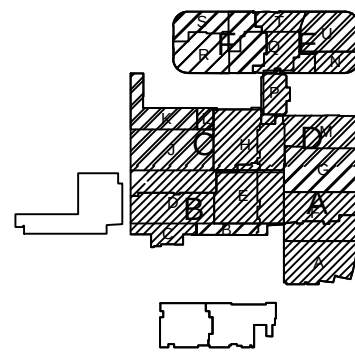

NO.	REV DESCRIPTION REV DATE	APPROVED BY
1.	AS BUILTS 08/15/2012	JOHN J. CHRISTIE

REV. DESCRIPTION APPROVED BY

CUSTOMER:



PROJECT:
CHOC CHILDREN'S
HOSPITAL
455 SOUTH MAIN ST.
ORANGE, CA 92668

DRAWING TITLE:
SEVENTH LEVEL CCTV
POINT TO POINT
DIAGRAM RM 7.103.02



DRN BY	DATE DRN	CHK BY	DATE CHK
JOSH G.	08/08/2012	JJC	
SCALE:	NTS		
DWG NO.	SE4.15		

ASBUILTS
08/15/2012



CCTV LOAD SCHEDULE

CAMERA #	PAGE NUMBER / AREA	CAMERA NAME	CAMERA TYPE	IP ADDRESS	MAC ADDRESS	IDF ROOM	LOCATION NUMBER	CABLE ID	PORT NUMBER
LOWER LEVEL									
00-ACMR-001	SE 3.0C	CS.B.MECH.CAM.1	FIXED	172.31.186.64	5453ED518B63	S0116	104		AG1
00-ACMR-002	SE 3.0G	CS.B.CORR.CAM.2	FIXED	172.31.186.65	5453ED518B6A	S0120	328		AJ4
00-ACMR-003	SE 3.0G	CS.B.TRAN.STORE	FIXED	172.31.186.66	5453ED518B69	S0120	330		AJ5
00-ACMR-004	SE 3.0H	CS.B.STAFF.ELEV.	FIXED	172.31.186.67	5453ED518B64	S0120	323		AJ2
00-ACMR-005	SE 3.0H	CS.B.PUB.ELEV.1	FIXED	172.31.186.68	5453ED518B68	S0120	336		AJ8
00-ACMR-006	SE 3.0H	CS.B.PUB.ELEV.2	FIXED	172.31.186.69	5453ED4A4F31	S0120	335		AJ7
00-ACMR-007	SE 3.0H	CS.B.TRAN.EQUIP	FIXED	172.31.186.70	5453ED4A4F33	S0120	334		AJ6
00-ACMR-008	SE 3.0J	CS.B.TEACH.ROOM	FIXED	172.31.186.71	5453ED4A4F34	S0116	130		AG3
00-ACMR-009	SE 3.0K	CS.B.CORR.CAM.1	FIXED	172.31.186.72	5453ED4A4F32	S0120	319		AJ1
00-ACMR-010	SE 3.0K	CS.B.ENT.FAM.RM.1	FIXED	172.31.186.73	5453ED4A4F2F	S0116	129		AG2
00-ACMR-011	SE 3.0K	CS.B.HIST. REC.	FIXED	172.31.186.74	5453ED4A4FC2	S0120	378		AJ15
00-ACMR-012	SE 3.0K	CS.B.AUTOPSY.1	FIXED	172.31.186.75	5453ED518B6C	S0120	372		AJ17
00-ACMR-013	SE 3.0K	CS.B.AUTOPSY.2	FIXED	172.31.186.76	5453ED4A4FB8	S0120	373		AJ10
00-ACMR-014	SE 3.0K	CS.B.BODY.HOLD.1	FIXED	172.31.186.77	5453ED4A4F38	S0120	374		AJ11
00-ACMR-015	SE 3.0K	CS.B.BODY.HOLD.2	FIXED	172.31.186.78	5453ED518B11	S0120	376		AJ13
00-ACMR-016	SE 3.0K	CS.B.HOLD.ENT.	FIXED	172.31.186.79	5453ED4A4F37	S0120	375		AJ12
00-ACMR-017	SE 3.0K	CS.B.ENT.FAM.RM.2	FIXED	172.31.186.80	5453ED4A4FC0	S0120	377		AJ14
00-ACMR-018	SE 3.0L	CS.B.MICROBIO.CAM	FIXED	172.31.186.81	5453ED518B67	S0120	389		AJ16
00-ACMR-019	SE 3.0L	CS.B.CORR.CAM.3	FIXED	172.31.186.82	5453ED518BAC	S0120	331		AJ9
00-ACMR-020	SE 3.0M	CS.B.CORR.CAM.4	FIXED	172.31.186.83	5453ED518BAA	S0120	325		AJ3
FIRST FLOOR									
01-ACMR-001	SE 3.1D	CS.1.ENT.ADMIT.	FIXED	172.31.186.96	5453ED4A5047	S1104	145		AG7
01-ACMR-002	SE 3.1D	CS.1.CASHIER.1	FIXED	172.31.186.97	5453ED4A5048	S1104	143		AG6
01-ACMR-003	SE 3.1D	CS.1.CORR.ADMIT.1	FIXED	172.31.186.98	5453ED4A5049	S1104	142		AG5
01-ACMR-004	SE 3.1D	CS.1.CASHIER.2	FIXED	172.31.186.99	5453ED4A504A	S1104	141		AG4
01-ACMR-005	SE 3.1D	CS.1.CORR.ADMIT.2	FIXED	172.31.186.100	5453ED4A504B	S1104	140		AG3
01-ACMR-006	SE 3.1E	CS.1.RECEPTION.1	FIXED	172.31.186.101	5453ED4A4FA7	S1104	136		AG2
01-ACMR-007	SE 3.1F	CS.1.ED.NURSE.1	FIXED	172.31.186.102	5453ED4A4FA8	S1101	543		AJ17
01-ACMR-008	SE 3.1F	CS.1.ED.NURSE.2	FIXED	172.31.186.103	5453ED4A4FA9	S1101	538		AJ14
01-ACMR-009	SE 3.1F	CS.1.ED.CORR.1	FIXED	172.31.186.104	5453ED4A4FAA	S1101	541		AJ16
01-ACMR-010	SE 3.1F	CS.1.ED.DISCHARGE	FIXED	172.31.186.105	5453ED4A4FAB	S1101	540		AJ15
01-ACMR-011	SE 3.1G	CS.1.PUB.ELEV.1	FIXED	172.31.186.106	5453ED4A4FAC	S1101	545		AJ20
01-ACMR-012	SE 3.1G	CS.1.PUB.ELEV.2	FIXED	172.31.186.107	5453ED4A4FAD	S1101	546		AJ22
01-ACMR-013	SE 3.1G	CS.1.OFFICE ADMIT	FIXED	172.31.186.108	5453ED4A4FAE	S1101	547		AJ21
01-ACMR-014	SE 3.1G	CS.1.ED.RECP.1	FIXED	172.31.186.109	5453ED4A4FAF	S1101	529		AJ9
01-ACMR-015	SE 3.1G	CS.1.ED.RECP.CORR	FIXED	172.31.186.110	5453ED4A4FB0	S1101	530		AJ10
01-ACMR-016	SE 3.1G	CS.1.ED.WAIT	FIXED	172.31.186.111	5453ED4A4FB1	S1101	533		AJ13
01-ACMR-017	SE 3.1G	CS.1.ED.RECP.2	FIXED	172.31.186.112	5453ED4A4FB7	S1101	532		AJ12
01-ACMR-018	SE 3.1H	CS.1.RECEPTION.2	FIXED	172.31.186.113	5453ED4A4F7C	S1101	544		AJ19
01-ACMR-019	SE 3.1K	CS.1.CORR.1	FIXED	172.31.186.114	5453ED4A4F7D	S1101	511		AJ1
01-ACMR-020	SE 3.1K	CS.1.LOAD.ENT.	FIXED	172.31.186.115	5453ED4D81CA	S1101	513		AJ2
01-ACMR-022	SE 3.1N	CS.1.ED.NURSE.3	FIXED	172.31.186.116	5453ED4A4F7E	S1101	520		AJ3
01-ACMR-023	SE 3.1N	CS.1.ED.NURSE.4	FIXED	172.31.186.117	5453ED4A4F75	S1101	521		AJ4
01-ACMR-024	SE 3.1N	CS.1.ED.AMB.ENT	FIXED	172.31.186.118	5453ED4A4F76	S1101	523		AJ5
01-ACMR-025	SE 3.1N	CS.1.STAIR.1	FIXED	172.31.186.119	5453ED4A4F77	S1101	531		AJ11
01-ACMR-026	SE 3.1P	CS.1.STAFF.ELEV	FIXED	172.31.186.120	5453ED4A4F78	S1101	550		AJ18
01-ACMR-027	SE 3.1U	CS.1.ED.PHARM.1	FIXED	172.31.186.121	5453ED4A4F79	S1101	524		AJ6
01-ACMR-028	SE 3.1U	CS.1.ED.PHARM.2	FIXED	172.31.186.122	5453ED4A504E	S1101	525		AJ7
01-ACMR-029	SE 3.1U	CS.1.ED.PHARM.3	FIXED	172.31.186.123	5453ED4A504F	S1101	526		AJ8
SECOND FLOOR									
02-ACMR-001	SE 3.2D	CS.2.ELEV.GARAGE	FIXED	172.31.186.136	5453ED1A1382	S2101	44		AG1
02-ACMR-002	SE 3.2D	CS.2.WALKWAY.	FIXED	172.31.186.137	5453ED1A1381	S2101	46		AG3
02-ACMR-003	SE 3.2D	CS.2.CONF.CORR.1	FIXED	172.31.186.138	5453ED518BD1	S2101	47		AG4
02-ACMR-004	SE 3.2D	CS.2.CONF.C	FIXED	172.31.186.139	5453ED518BD2	S2101	51		AG8
02-ACMR-005	SE 3.2D	CS.2.MEDI.PRAY.RM	FIXED	172.31.186.140	5453ED518BD3	S2101	52		AG9
02-ACMR-006	SE 3.2E	CS.2.FAM.SERV.1	FIXED	172.31.186.141	5453ED518BD4	S2101	53		AG10
02-ACMR-007	SE 3.2E	CS.2.ADMIN.ENT.1	FIXED	172.31.186.142	5453ED518BD5	S2338	141		AH12
02-ACMR-008	SE 3.2F	CS.2.ADMIN.RECEP.	FIXED	172.31.186.143	5453ED518BD6	S2338	140		AH11
02-ACMR-009	SE 3.2G	CS.2.PRE.TEEN.RM.	FIXED	172.31.186.144	5453ED518BD7	S2103	101		AH12
02-ACMR-010	SE 3.2G	CS.2.Childrens Terrace	FIXED	172.31.186.145	5453ED4D850A	S2103	99		AH10
02-ACMR-011	SE 3.2G	CS.2.TEEN.RM	FIXED	172.31.186.146	5453ED518BD9	S2103	102		AH13
02-ACMR-012	SE 3.2G	CS.2.ACTIVITY.RM	FIXED	172.31.186.147	5453ED518BDA	S2338	131		AH2
02-ACMR-013	SE 3.2G	CS.2.ADMIN.ENT.2	FIXED	172.31.186.148	5453ED4A4F93	S2338	130		AH1
02-ACMR-014	SE 3.2H	CS.2.GIFT.STORE.1	FIXED	172.31.186.149	5453ED4A4F94	S2338	139		AH10
02-ACMR-015	SE 3.2H	CS.2.GIFT.STORE.2	FIXED	172.31.186.150	5453ED4A4F95	S2338	138		AH9
02-ACMR-016	SE 3.2H	CS.2.GIFT.SHOP.1	FIXED	172.31.186.151	5453ED4A4F96	S2338	137		AH8
02-ACMR-017	SE 3.2H	CS.2.GIFT.SHOP.2	FIXED	172.31.186.152	5453ED4A4F97	S2338	136		AH7
02-ACMR-018	SE 3.2H	CS.2.INFO.CORR.1	PTZ	172.31.186.153		S2338	135		AH6
02-ACMR-019	SE 3.2H	CS.2.INFO.CORR.2	FIXED	172.31.186.154	5453ED4A4F98	S2338	132		AH3
02-ACMR-020	SE 3.2H	CS.2.PUB.ELEV.1	FIXED	172.31.186.155	5453ED4A4F99	S2338	134		AH5
02-ACMR-021	SE 3.2H	CS.2.PUB.ELEV.2	FIXED	172.31.186.156	5453ED4A4F9A	S2338	133		AH4
02-ACMR-022	SE 3.2J	CS.2.CONF.CORR.2	FIXED	172.31.186.157	5453ED4A4F9B	S2101	48		AG5
02-ACMR-023	SE 3.2J	CS.2.CONF.A.	FIXED	172.31.186.158	5453ED4A4F9C	S2101	49		AG6
02-ACMR-024	SE 3.2J	CS.2.CONF.B.	FIXED	172.31.186.159	5453ED518B59	S2101	50		AG7
02-ACMR-025	SE 3.2K	CS.2.OUT.GARDEN	PTZ	172.31.186.160		S2103	90		AG1
02-ACMR-026	SE 3.2K	CS.2.KITCHEN.OFF.	FIXED	172.31.186.161	5453ED518B5A	S2103	92		AG3
02-ACMR-027	SE 3.2L	CS.2.OUT.DINE.TR	PTZ	172.31.186.162		S2103	94		AG5
02-ACMR-028	SE 3.2L	CS.2.VESTIBULE	FIXED	172.31.186.163	5453ED518B5B	S2103	95		AG6
02-ACMR-029	SE 3.2L	CS.2.COFFEE.KIOSK.	FIXED	172.31.186.164	5453ED518B5C	S2103	98		AG9
02-ACMR-030	SE 3.2L	CS.2.STAFF.ELEV.	FIXED	172.31.186.165	5453ED518B5D	S2103	96		AG7
02-ACMR-031	SE 3.2P	CS.2.CORR.1	FIXED	172.31.186.166	5453ED4A5050				
02-ACMR-032	SE 3.2P	CS.2.Childrens Terrace	FIXED	172.31.186.167	5453ED68598A				
02-ACMR-033	SE 3.2P	Spare	FIXED	172.31.186.168					

CAMERA #	PAGE NUMBER / AREA	CAMERA NAME	CAMERA TYPE	IP ADDRESS	MAC ADDRESS	IDF ROOM	LOCATION NUMBER	CABLE ID	PORT NUMBER
THIRD FLOOR									
03-ACMR-001	SE 3.3D	CS.3.CORR.1	PTZ	172.31.186.184		S3102	196		AG1
03-ACMR-002	SE 3.3E	CS.3.CORR.2	FIXED	172.31.186.185	5453ED4A4FE3	S3618	259		AH3
03-ACMR-003	SE 3.3F	CS.3.CORR.3	FIXED	172.31.186.186	5453ED4A4FE4	S3618	252		AH2
03-ACMR-004	SE 3.3G	CS.3.RECEP.CAM	FIXED	172.31.186.187	5453ED4A4FE5	S3618	263		AH4
03-ACMR-005	SE 3.3M	CS.3.PRO.WAIT	FIXED	172.31.186.188	5453ED4A4FE6	S3618	249		AH1
03-ACMR-006	SE 3.3H	CS.3.CORR.4	FIXED	172.31.186.189	5453ED4A4FE7	S3105	235		AH2
03-ACMR-007	SE 3.3H	CS.3.STAFF.ELEV.	FIXED	172.31.186.190	5453ED4A4FE8	S3105	233		AH1
03-ACMR-008	SE 3.3H	CS.3.PUB.ELEV.1	FIXED	172.31.186.191	5453ED4A4FE9	S3618	265		AH6
03-ACMR-009	SE 3.3H	CS.3.PUB.ELEV.2	FIXED	172.31.186.192	5453ED4A4FEA	S3618	264		AH5
03-ACMR-010	SE 3.3J	CS.3.PHARM.1	FIXED	172.31.186.193	5453ED4A4FEB	S3105	239		AH5
03-ACMR-011	SE 3.3J	CS.3.PHARM.2	FIXED	172.31.186.194	5453ED4A4FEC	S3105	238		AH4
03-ACMR-012	SE 3.3J	CS.3.PHARM.3	FIXED	172.31.186.195	5453ED518B60	S3105	237		AH3
03-ACMR-013	SE 3.3K	CS.3.CORR.5	FIXED	172.31.186.196	5453ED518B5E	S3105	243		AH7
03-ACMR-014	SE 3.3L	CS.3.RN.STATION	FIXED	172.31.186.197	5453ED518B5E	S3105	241		AH6
FIFTH FLOOR									
05-ACMR-001	SE 3.5A	CS.5.CORR.1	FIXED	172.31.187.2	5453ED518BB3	S5254	237		AH1
05-ACMR-002	SE 3.5G	CS.5.CORR.2	FIXED	172.31.187.3	5453ED518BB4	S5224	211		AH5
05-ACMR-003	SE 3.5H	CS.5.STAFF.ELEV.	FIXED	172.31.187.4	5453ED518BB5	S5224	210		AH4
05-ACMR-004	SE 3.5H	CS.5.CORR.3	FIXED	172.31.187.5	5453ED518BB6	S5224			
05-ACMR-005	SE 3.5H	CS.5.CORR.4	FIXED	172.31.187.6	5453ED518BB7	S5224			
05-ACMR-006	SE 3.5H	CS.5.PUB.ELEV.1	FIXED	172.31.187.7	5453ED518BB8	S5224	209		AH3
05-ACMR-007	SE 3.5H	CS.5.PUB.ELEV.2	FIXED	172.31.187.8	5453ED518BB9	S5224	208		AH1
05-ACMR-008	SE 3.5H	CS.5.VISITOR.WAIT	FIXED	172.31.187.9	5453ED518BBA	S5224	207		AH2
05-ACMR-009	SE 3.5M	CS.5.PLAYROOM	FIXED	172.31.187.10	5453ED518BBB	S5224			
05-ACMR-010	SE 3.5P	CS.5.TEEN.LOUNGE	FIXED	172.31.187.11	5453ED518BBC	S5224			
05-ACMR-011	SE 3.5P	CS.5.CORR.5	FIXED	172.31.187.12	5453ED518BB6	S5224			
05-ACMR-012	SE 3.5P	CS.5.TUTORING	FIXED	172.31.187.13	5453ED4A504C	S5224			
SEVENTH FLOOR									
07-ACMR-001	SE 3.7A	CS.7.STAFF.ELEV.	FIXED	172.31.187.56	5453ED518BB6B	S7103	10		AG1
07-ACMR-002	SE 3.7D	CS.7.SPACE.1	FIXED	172.31.187.57	5453ED518BB65	S7101	22		AG2
07-ACMR-003	SE 3.7D	CS.7.PUB.ELEV.	FIXED	172.31.187.58	5453ED4A4F8D	S7101	20		AG3
07-ACMR-004	SE 3.7D	CS.7.VESTIBULE	FIXED	172.31.187.59	5453ED4A4FC3	S7101	21		AG1
P1 LEVEL									
P1-ACMR-001	SE 3.P1A	CS.P1.STAFF.ELEV.	FIXED	172.31.187.96	5453ED4A4AFB	S7103	12		AG3
P1-ACMR-002	SE 3.P1D	CS.P1.EXIT.CORR.1	FIXED	172.31.187.97	5453ED1A1383	S7101	24		AG4
P1-ACMR-003	SE 3.P1D	CS.P1.EXIT.CORR.2	FIXED	172.31.187.98	5453ED1A1380	S7101	23		AG5
P2 LEVEL									
P2-ACMR-001	SE 3.P2A	CS.P2.CORR	FIXED	172.31.187.104		S7103	11		AG2
P2-ACMR-002	SE 3.P2D	CS.P2.STAIR.1	FIXED	172.31.187.105		S7101	26		AG7
P2-ACMR-003	SE 3.P2D	CS.P2.STAIR.2	PTZ	172.31.187.106		S7101	25		AG6
SITE									
S-ACMR-001	SE 1.05			172.31.187.113		S2338	167		AH13
S-ACMR-002	SE 1.05			172.31.187.114					
S-ACMR-003	SE 1.05			172.31.187.115		S1104	157		AG8
S-ACMR-004	SE 1.05			172.31.187.116		S2101	44		AG1
S-ACMR-005	SE 1.05			172.31.187.117		S1101	582		AJ23
S-ACMR-006	SE 1.05			172.31.187.118					
S-ACMR-007	SE 1.05			172.31.187.119		S1101	584		AK1
S-ACMR-008	SE 1.05			172.31.187.120		S1101	583		AJ24
S-ACMR-009	SE 1.05			172.31.187.121		S1101	585		AK2
S-ACMR-010	SE 1.05			172.31.187.122					
S-ACMR-011	SE 1.05			172.31.187.123					
S-ACMR-012	SE 1.05			172.31.187.124					
S-ACMR-013	SE 1.05			172.31.187.125					
S-ACMR-014	SE 1.05			172.31.187.126					
S-ACMR-015	SE 1.05			172.31.187.127					

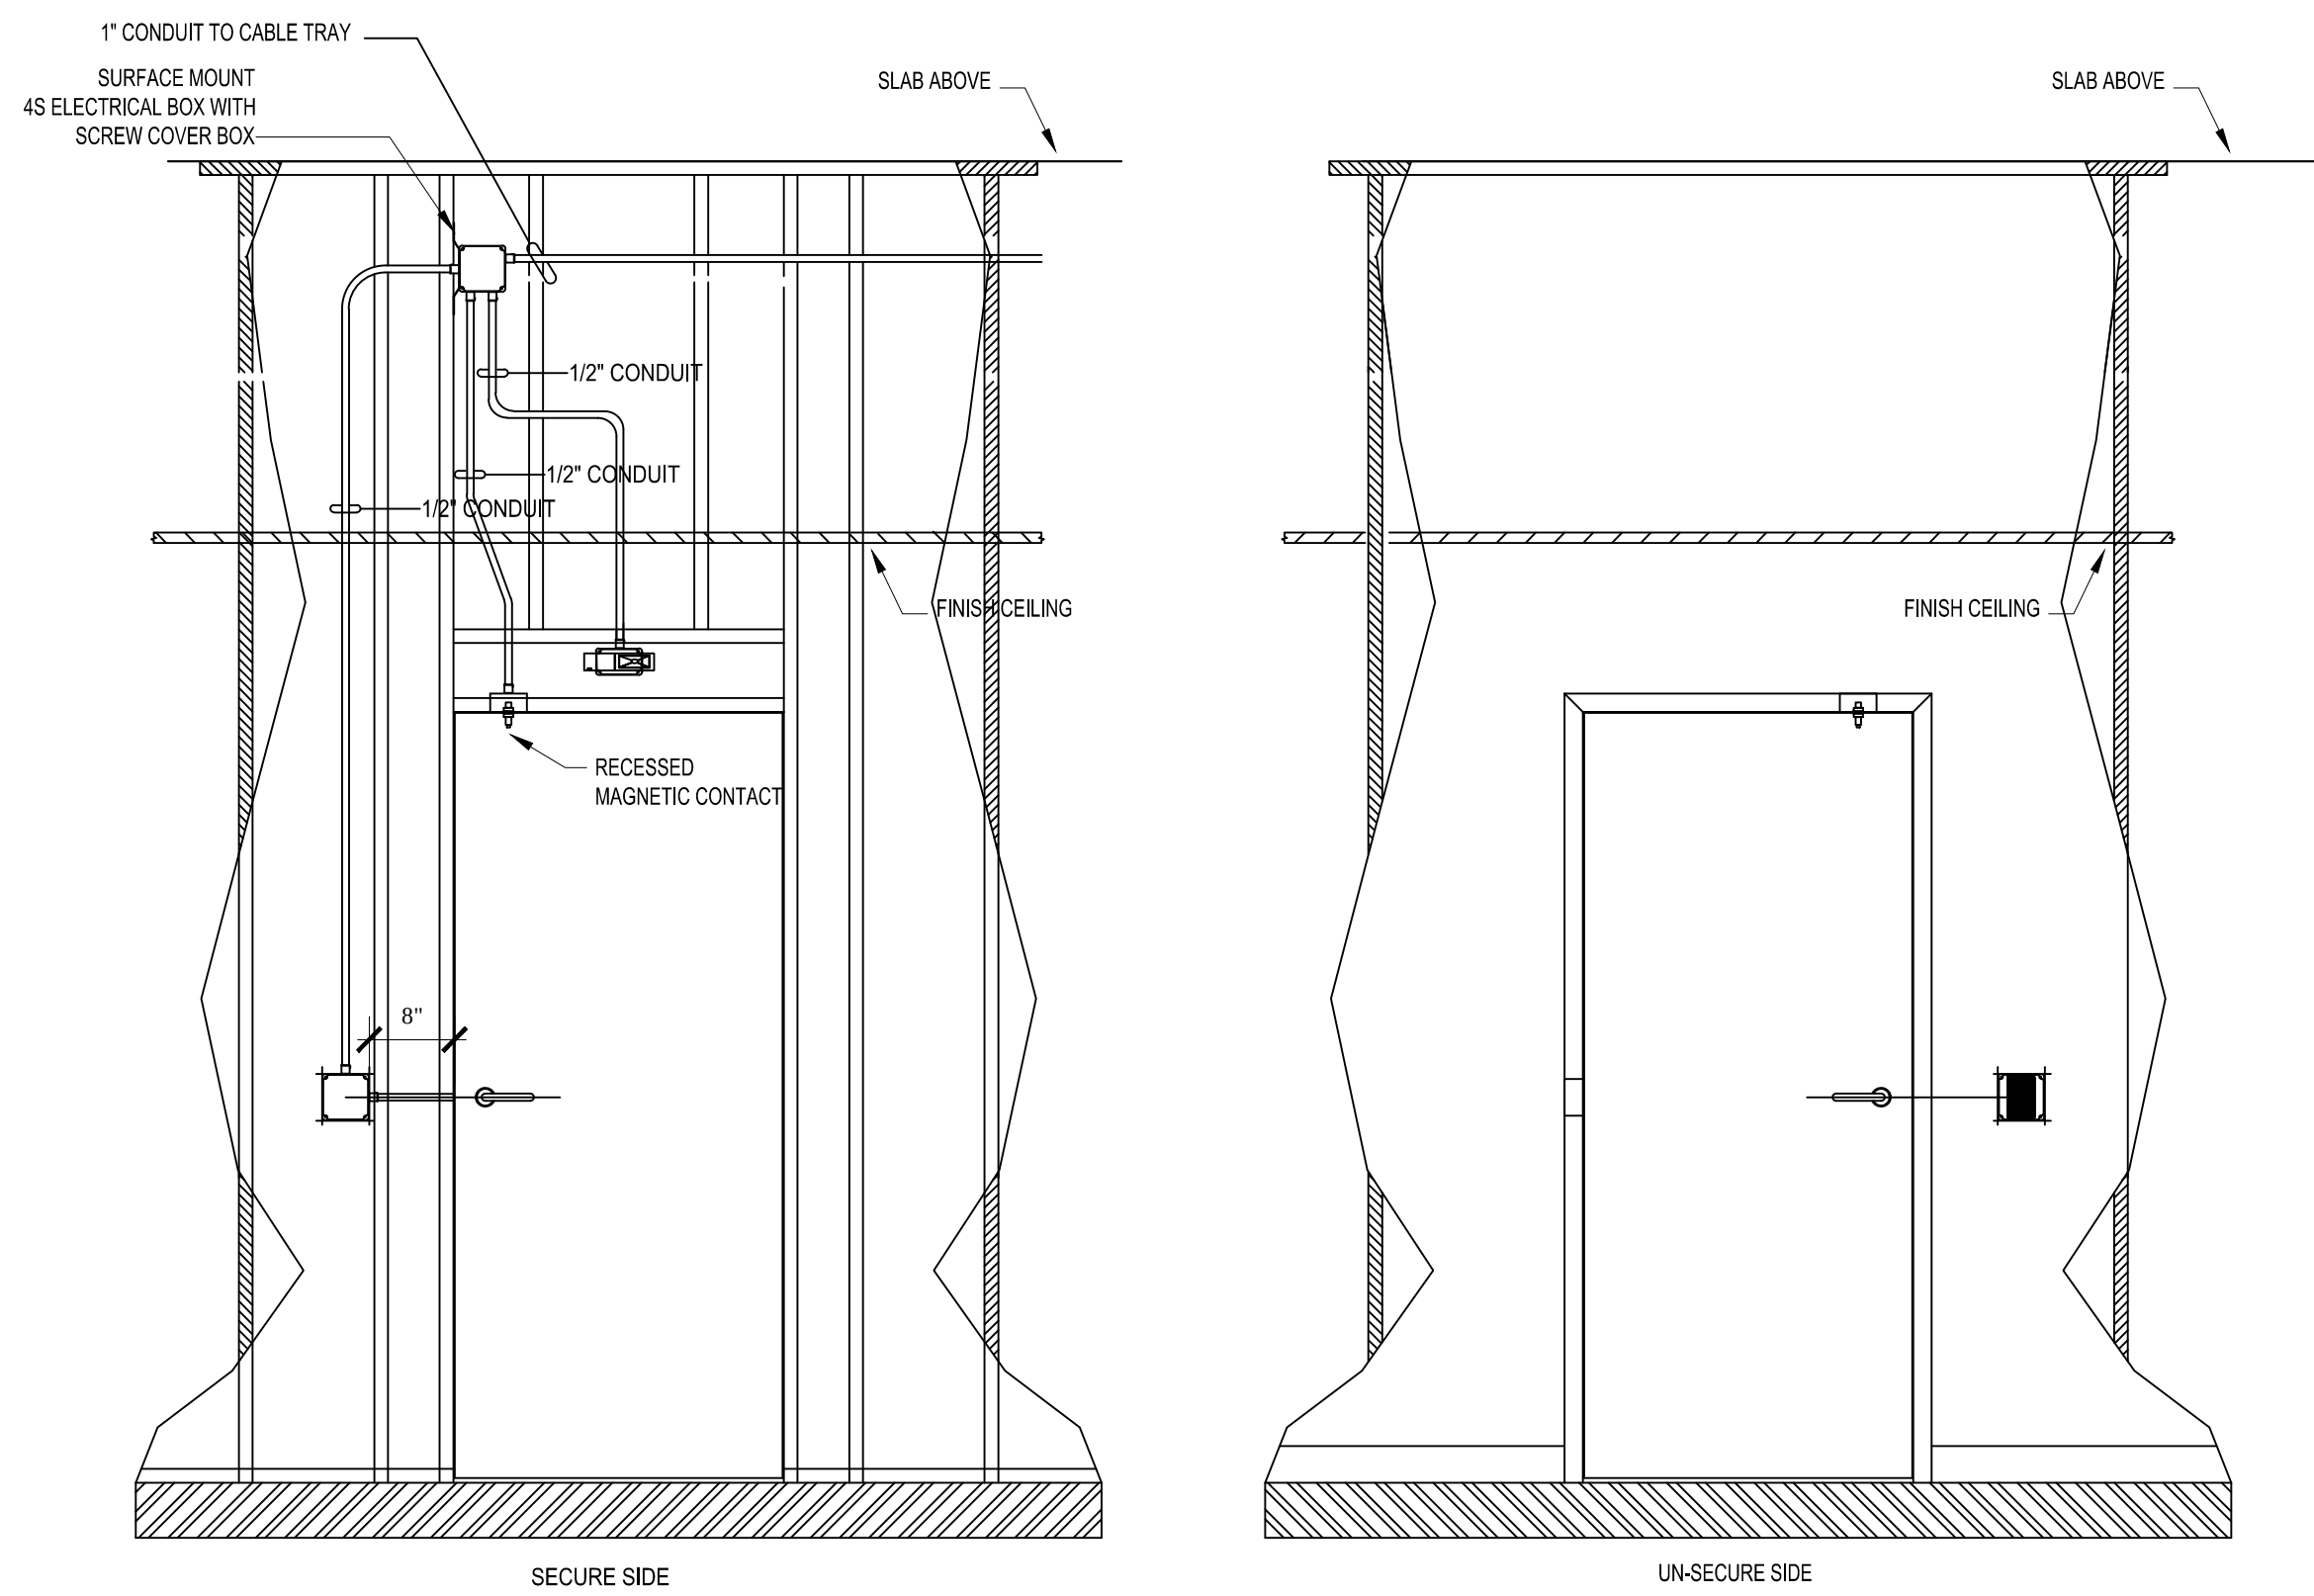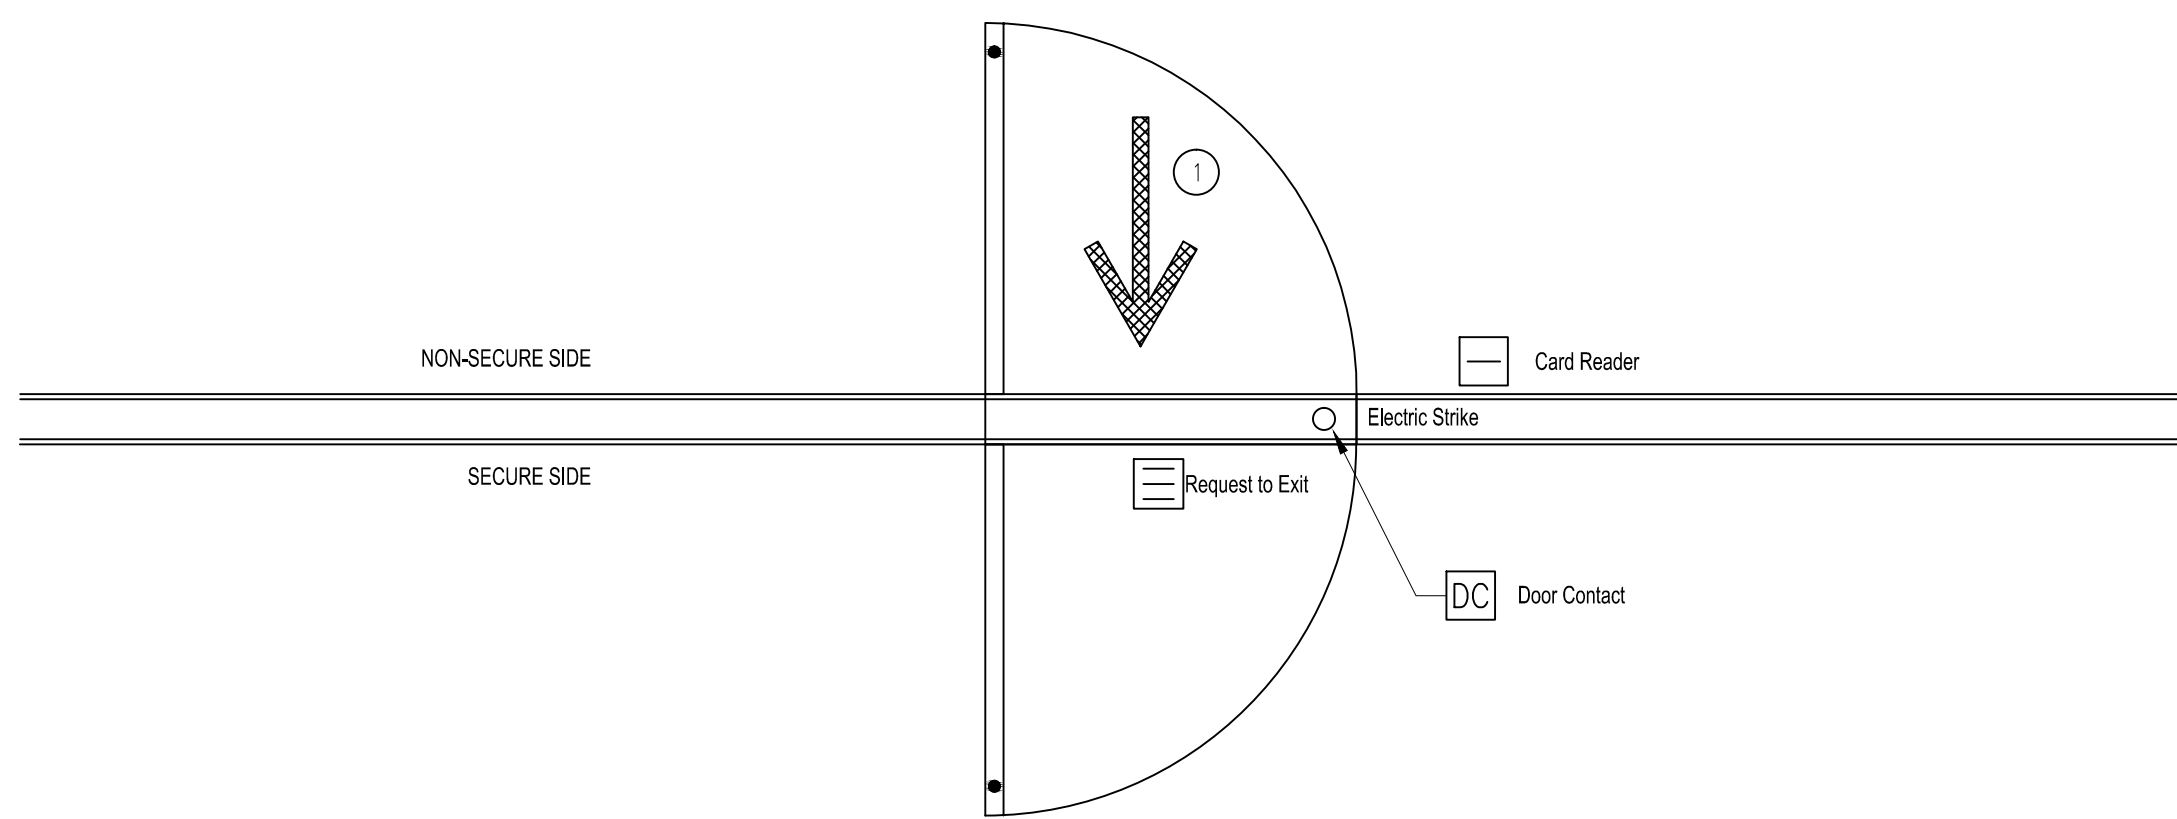

2 DOOR TYPE 2
T5.01 NTS

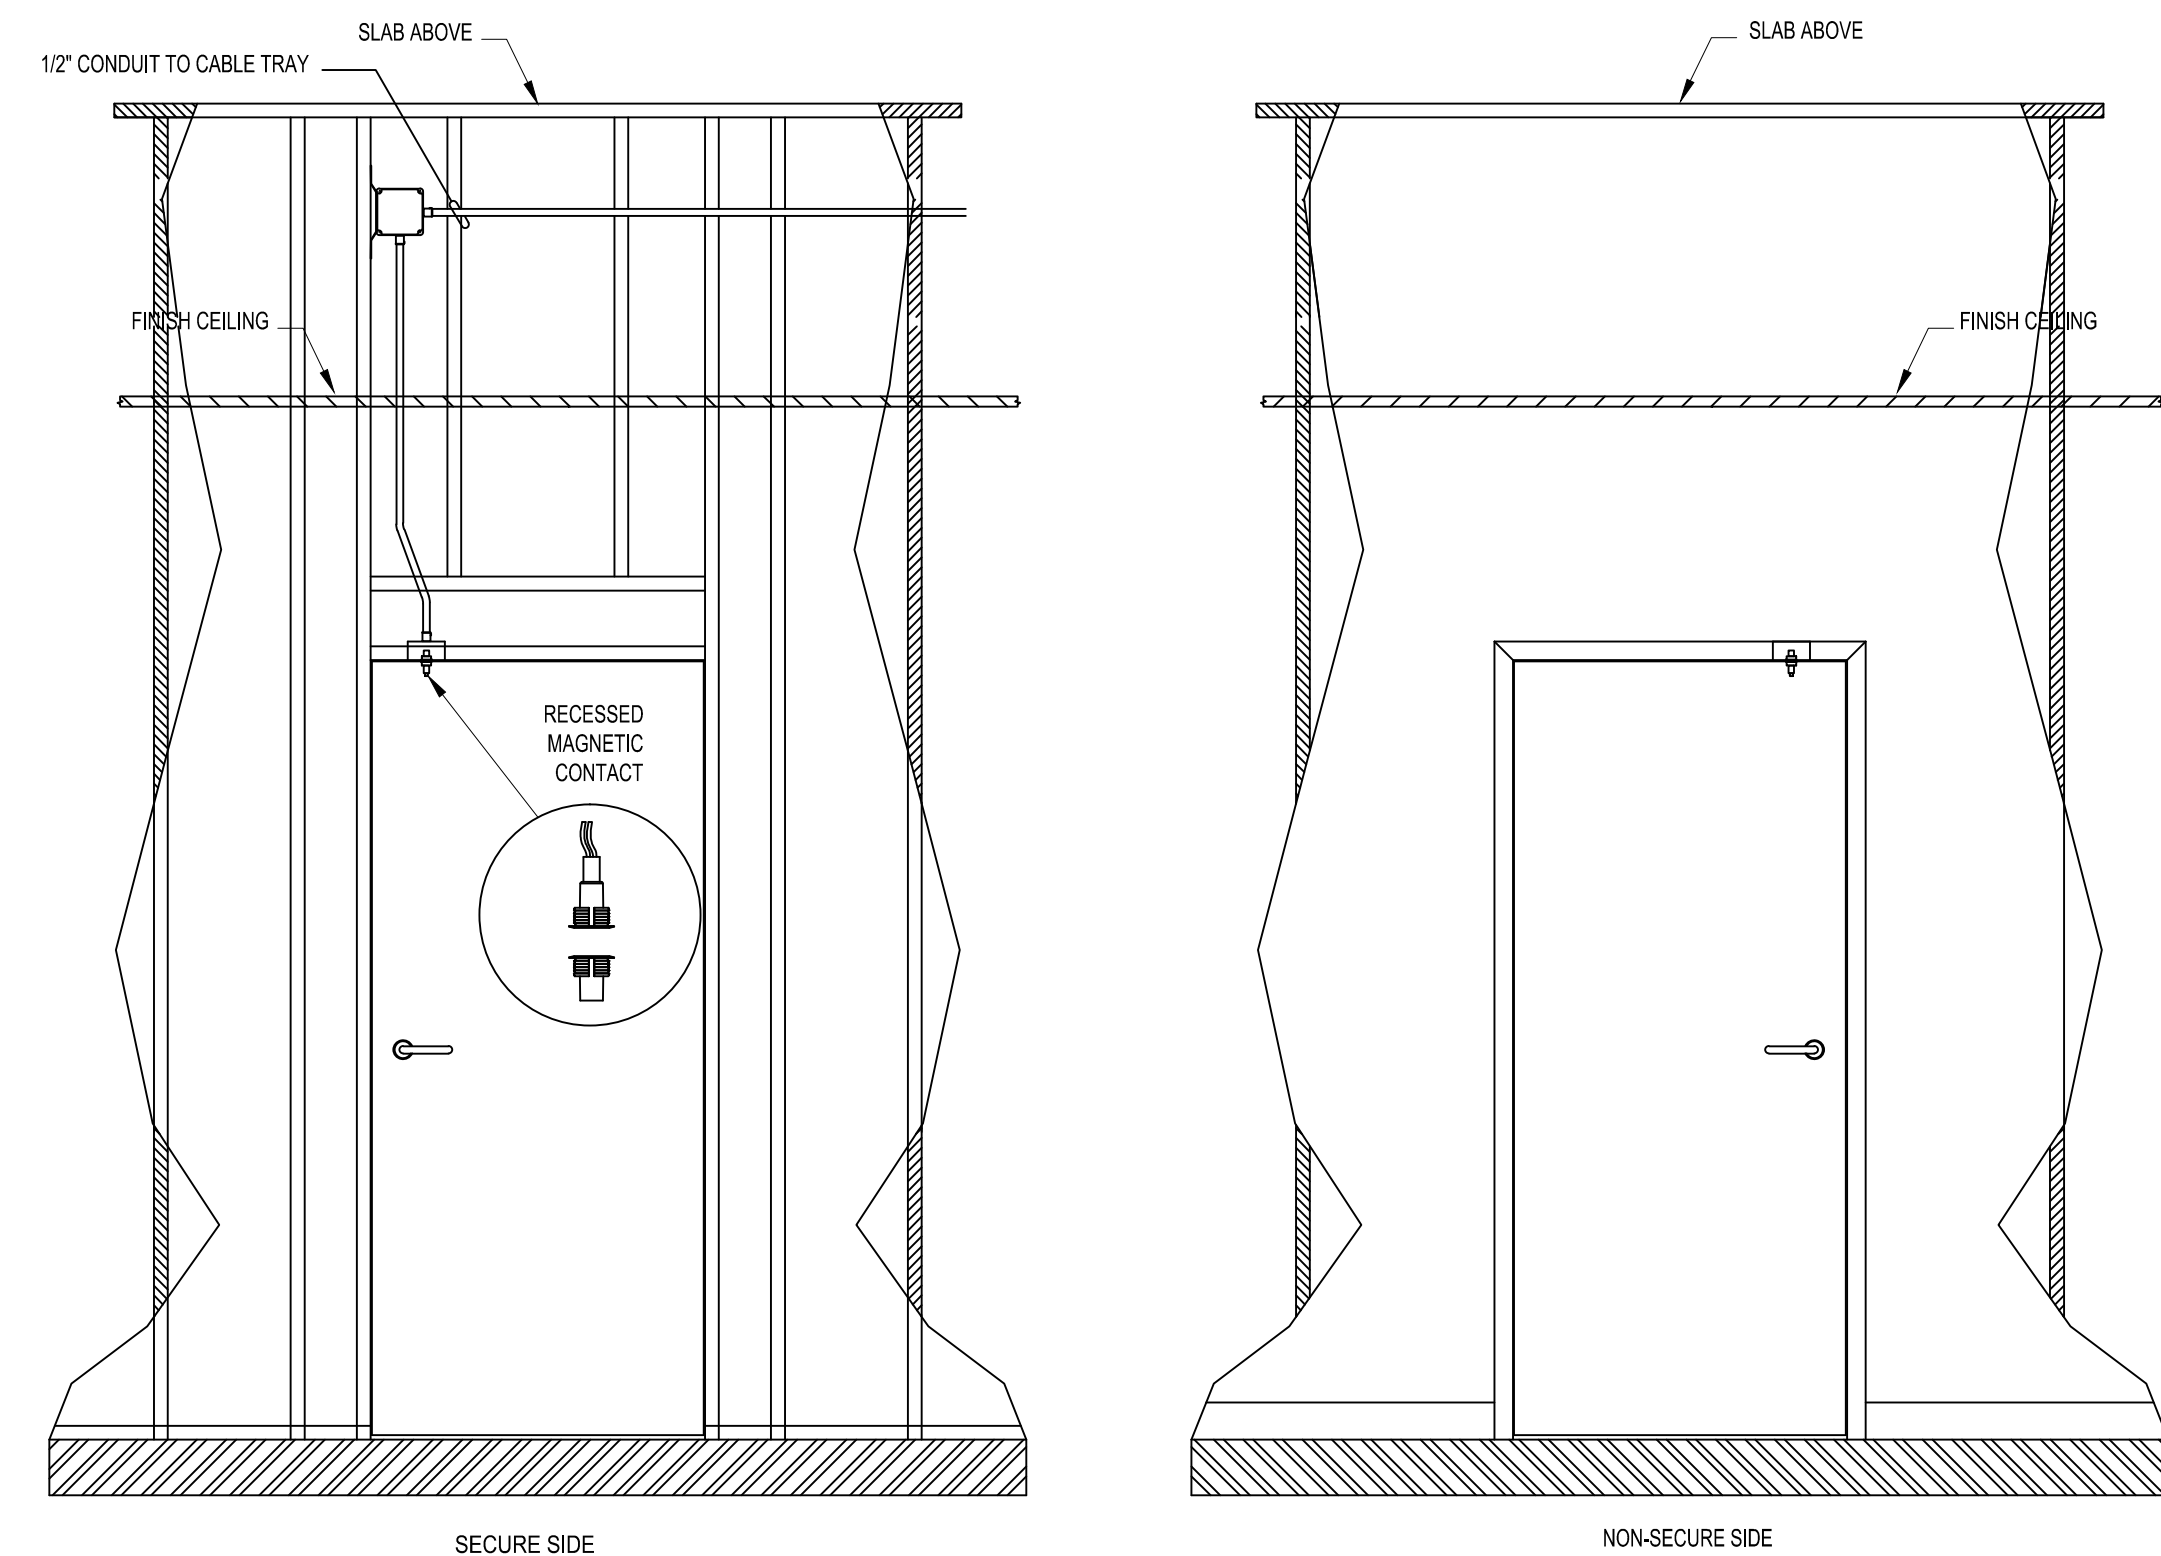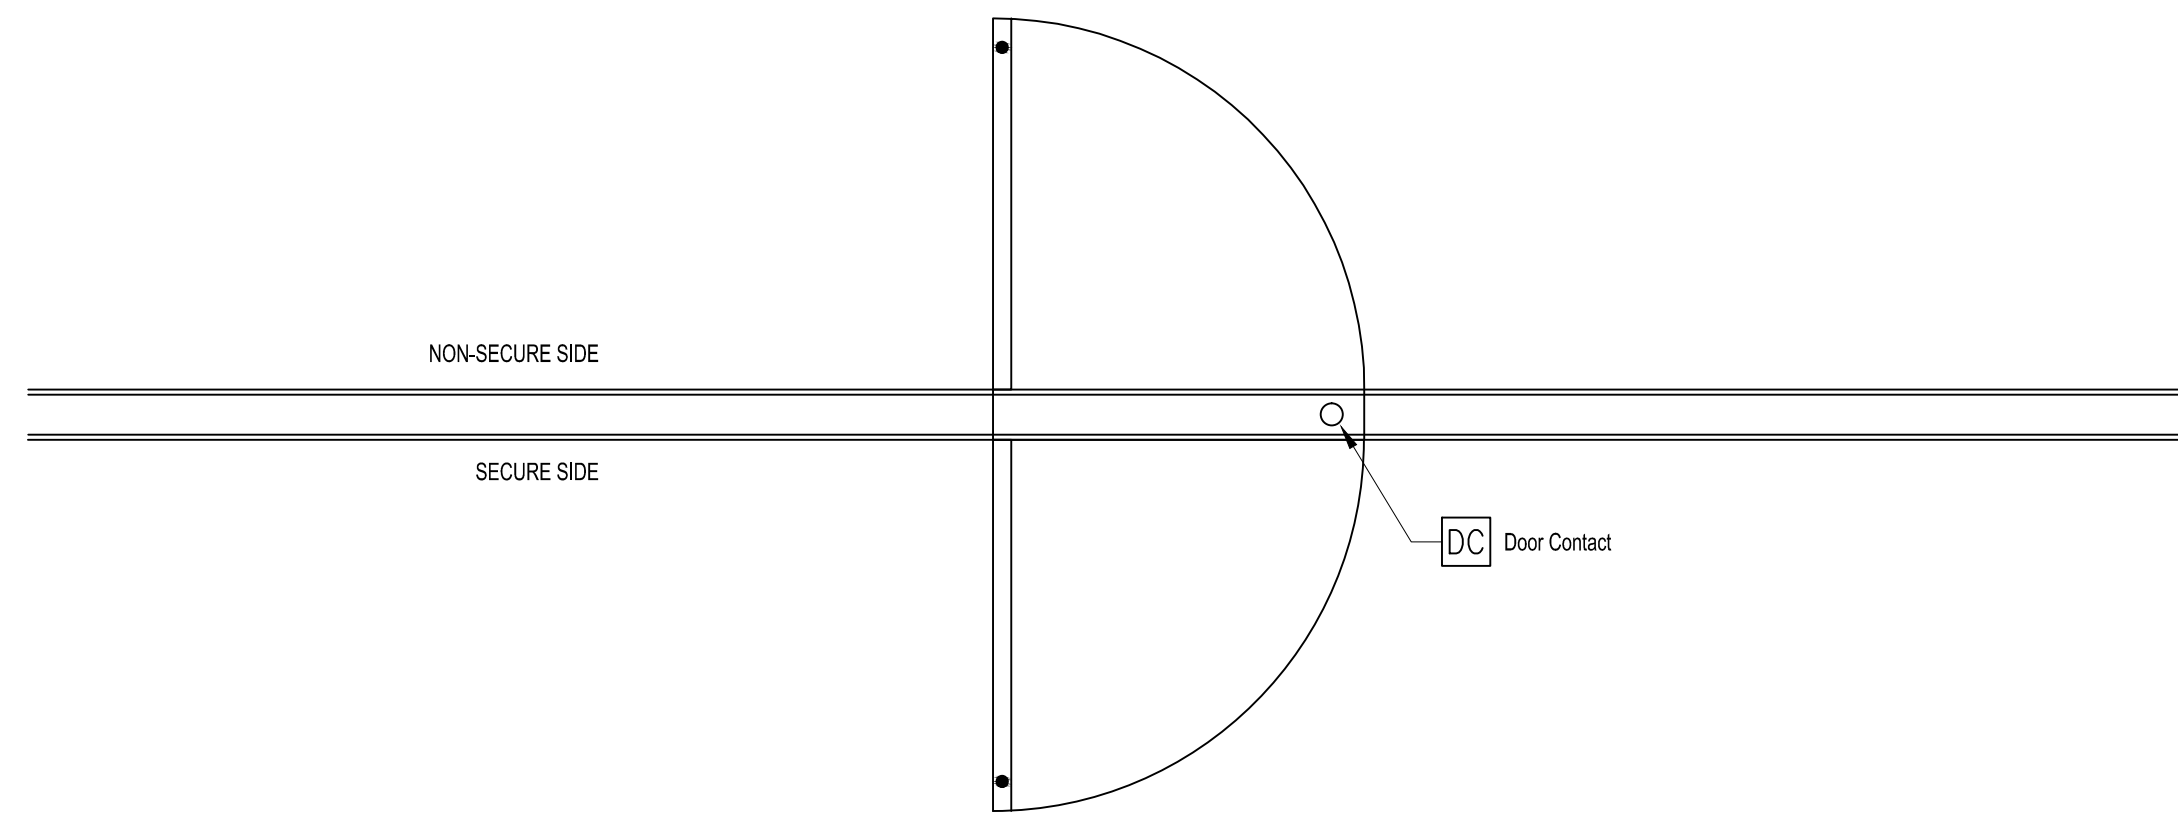

1 DOOR TYPE 1
T5.01 NTS

DRAWING PREPARED BY:



1511 E. ORANGETHORPE BLVD.
FULLERTON, CALIFORNIA 92831
714-525-4350 - o; 714-525-4386 - f
(c) Copyright 2012 KRATOS | HBE
All Rights Reserved.

MUST BE SIGNED BY HBE
TO AUTHENTICATE CONTENT(S).
ALL DETAILS CHECKED FOR ACCURACY.


SIGNATURE _____ DATE _____

HBE JOB #

CONFIDENTIAL

THE INFORMATION CONTAINED HERIN MAY
NOT BE USED OR REPRODUCED IN ANY
MANNER WITHOUT WRITTEN PERMISSION OF
KRATOS | HBE.

KEY PLAN

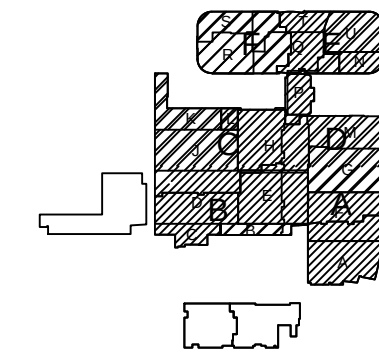

NO.	REV DESCRIPTION REV DATE	APPROVED BY
1.	AS BUILTS 08/15/2012	JOHN J. CHRISTIE

REV. DESCRIPTION APPROVED BY

CUSTOMER:





PROJECT:
CHOC CHILDREN'S
HOSPITAL
455 SOUTH MAIN ST.
ORANGE, CA 92668



DRAWING TITLE:
SECURITY SYSTEM
DOOR DETAILS

DRN BY	DATE DRN	CHK BY	DATE CHK
JOSH G.	08/08/2012	JJC	
SCALE:	AS NOTED		
DWG NO.	SE5.01		

ASBUILTS
08/15/2012

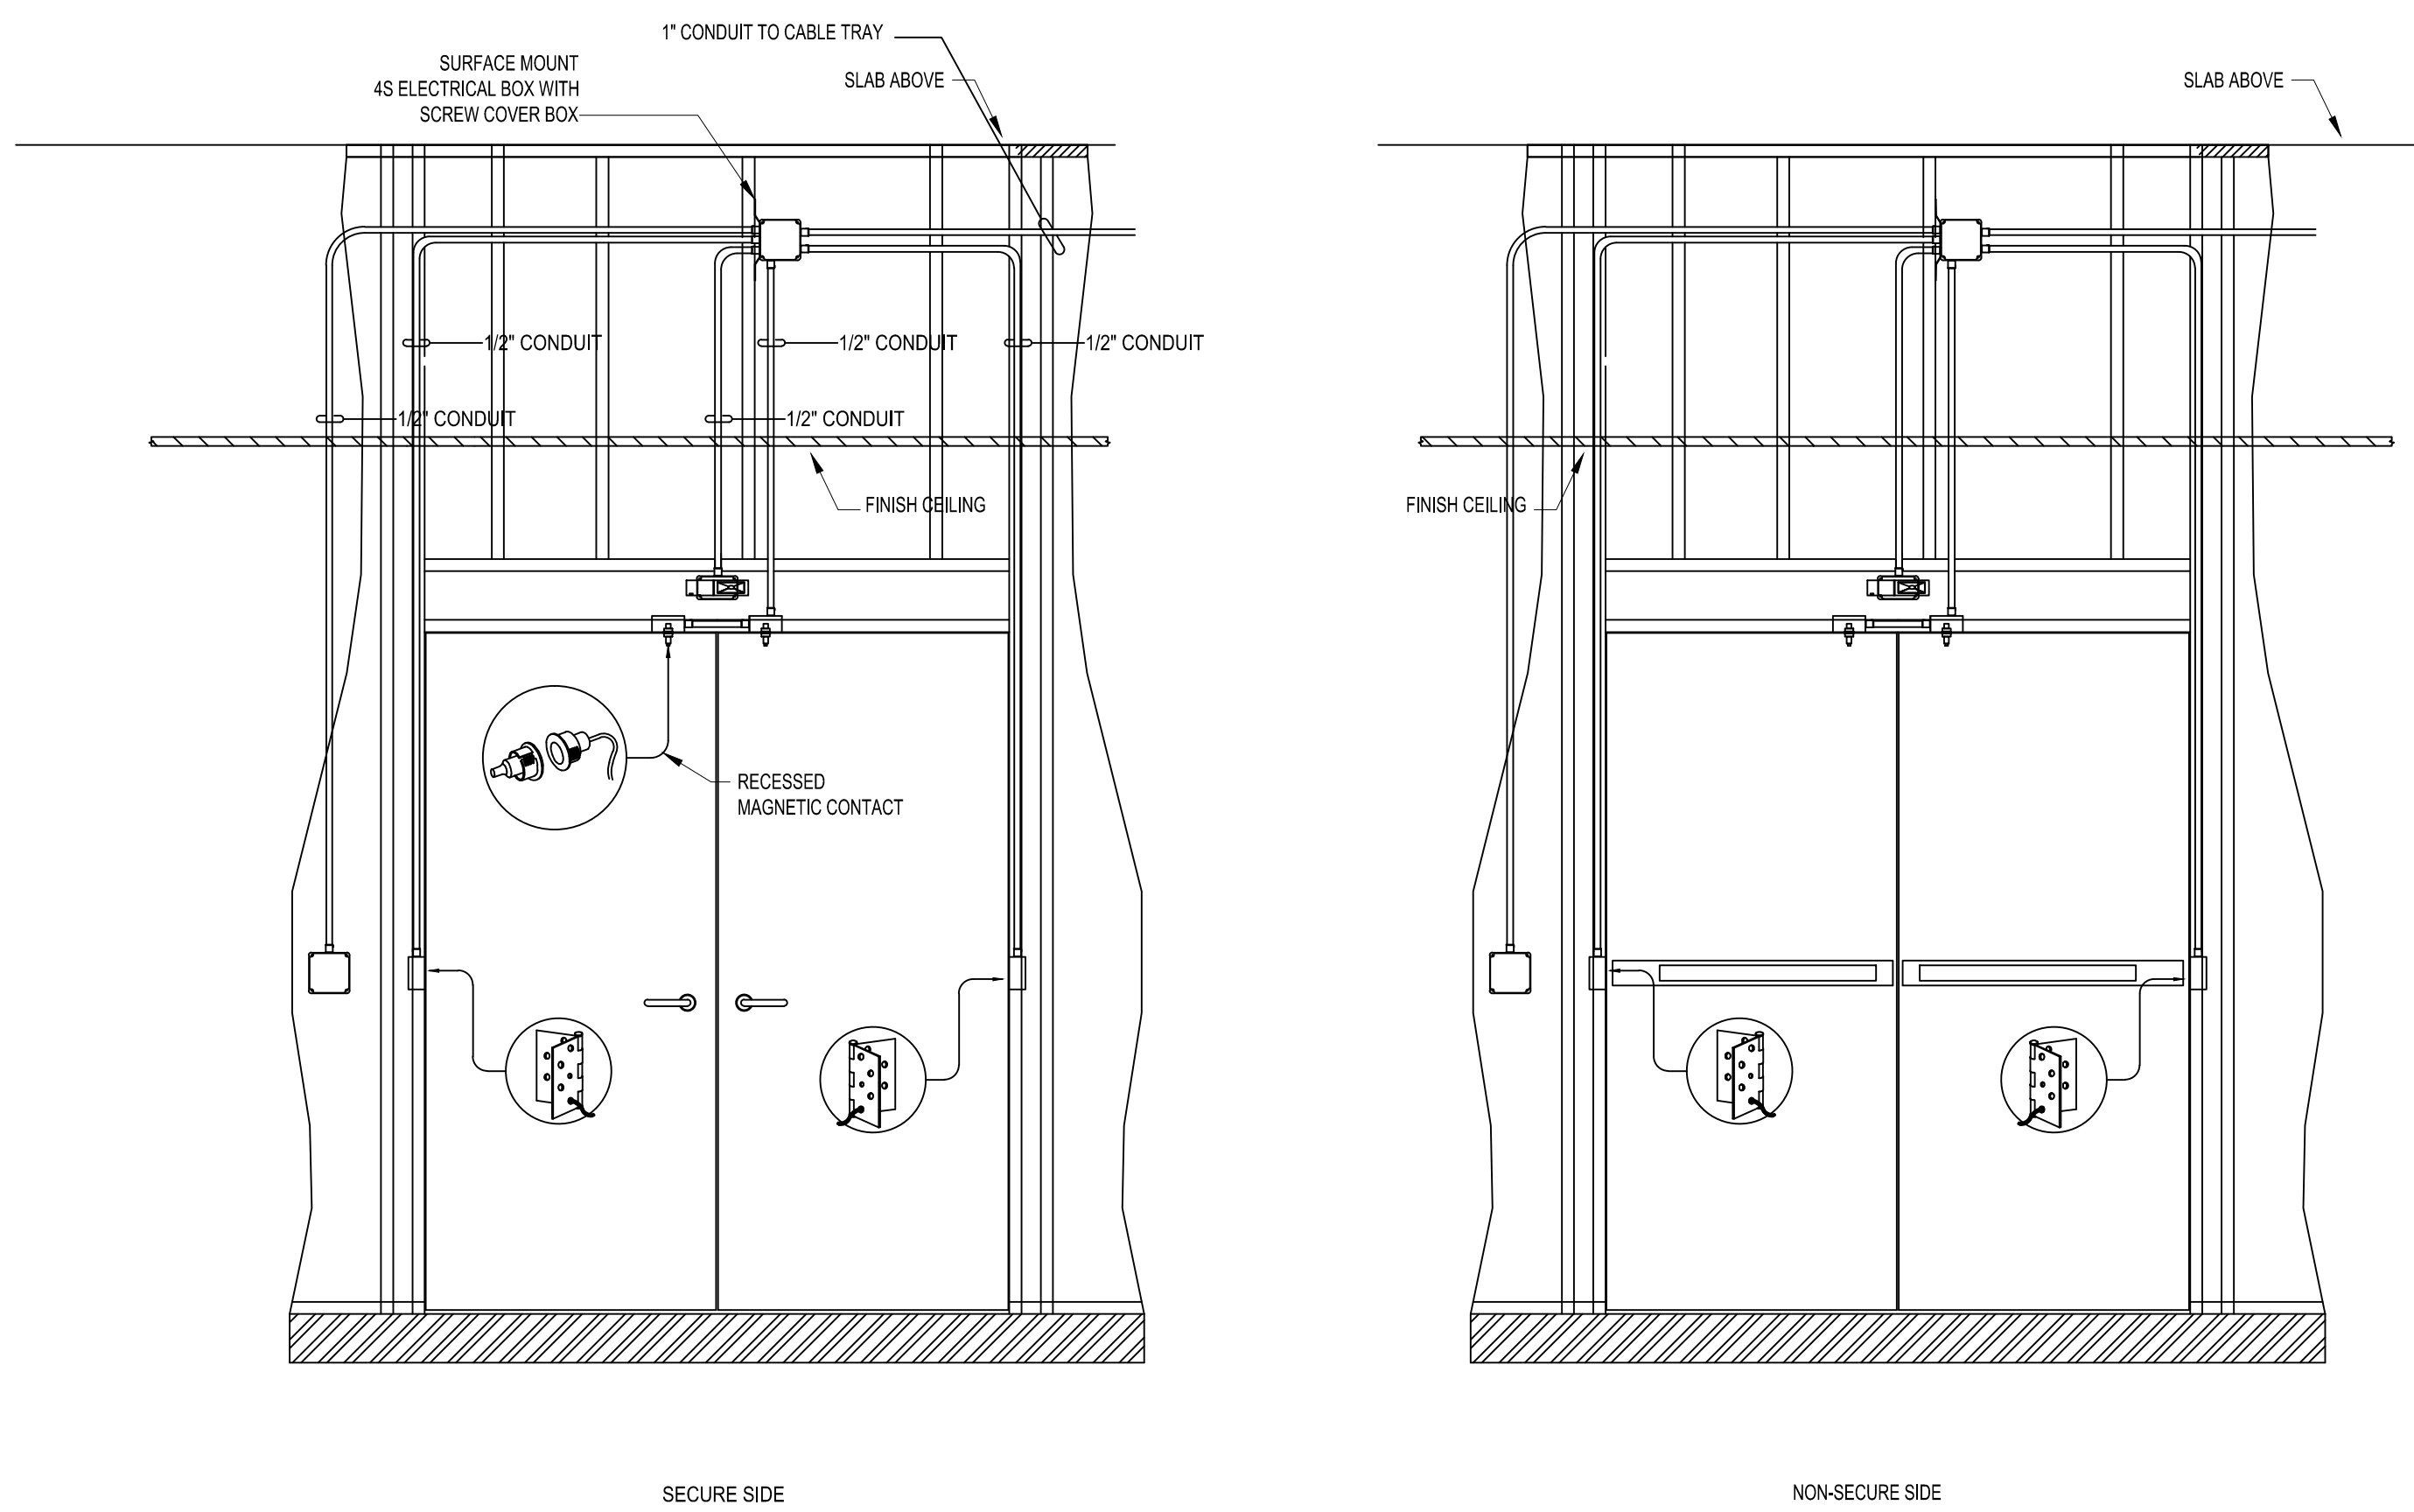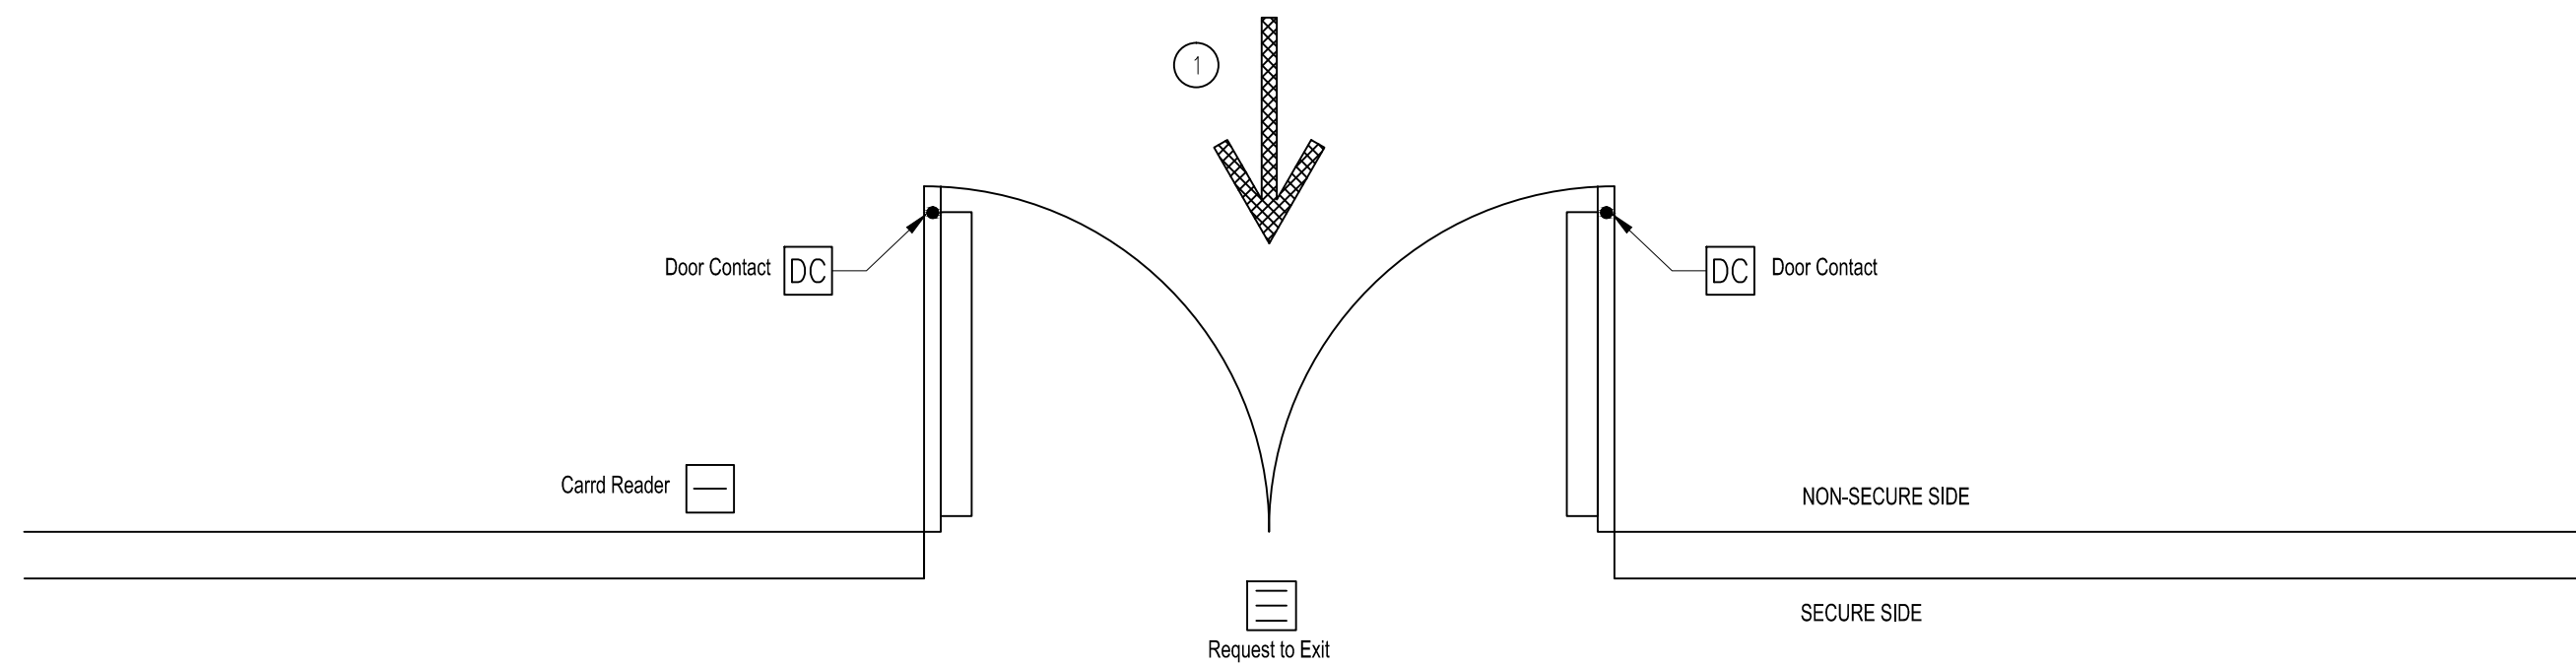

2 DOOR TYPE 4
TS.02 NTS

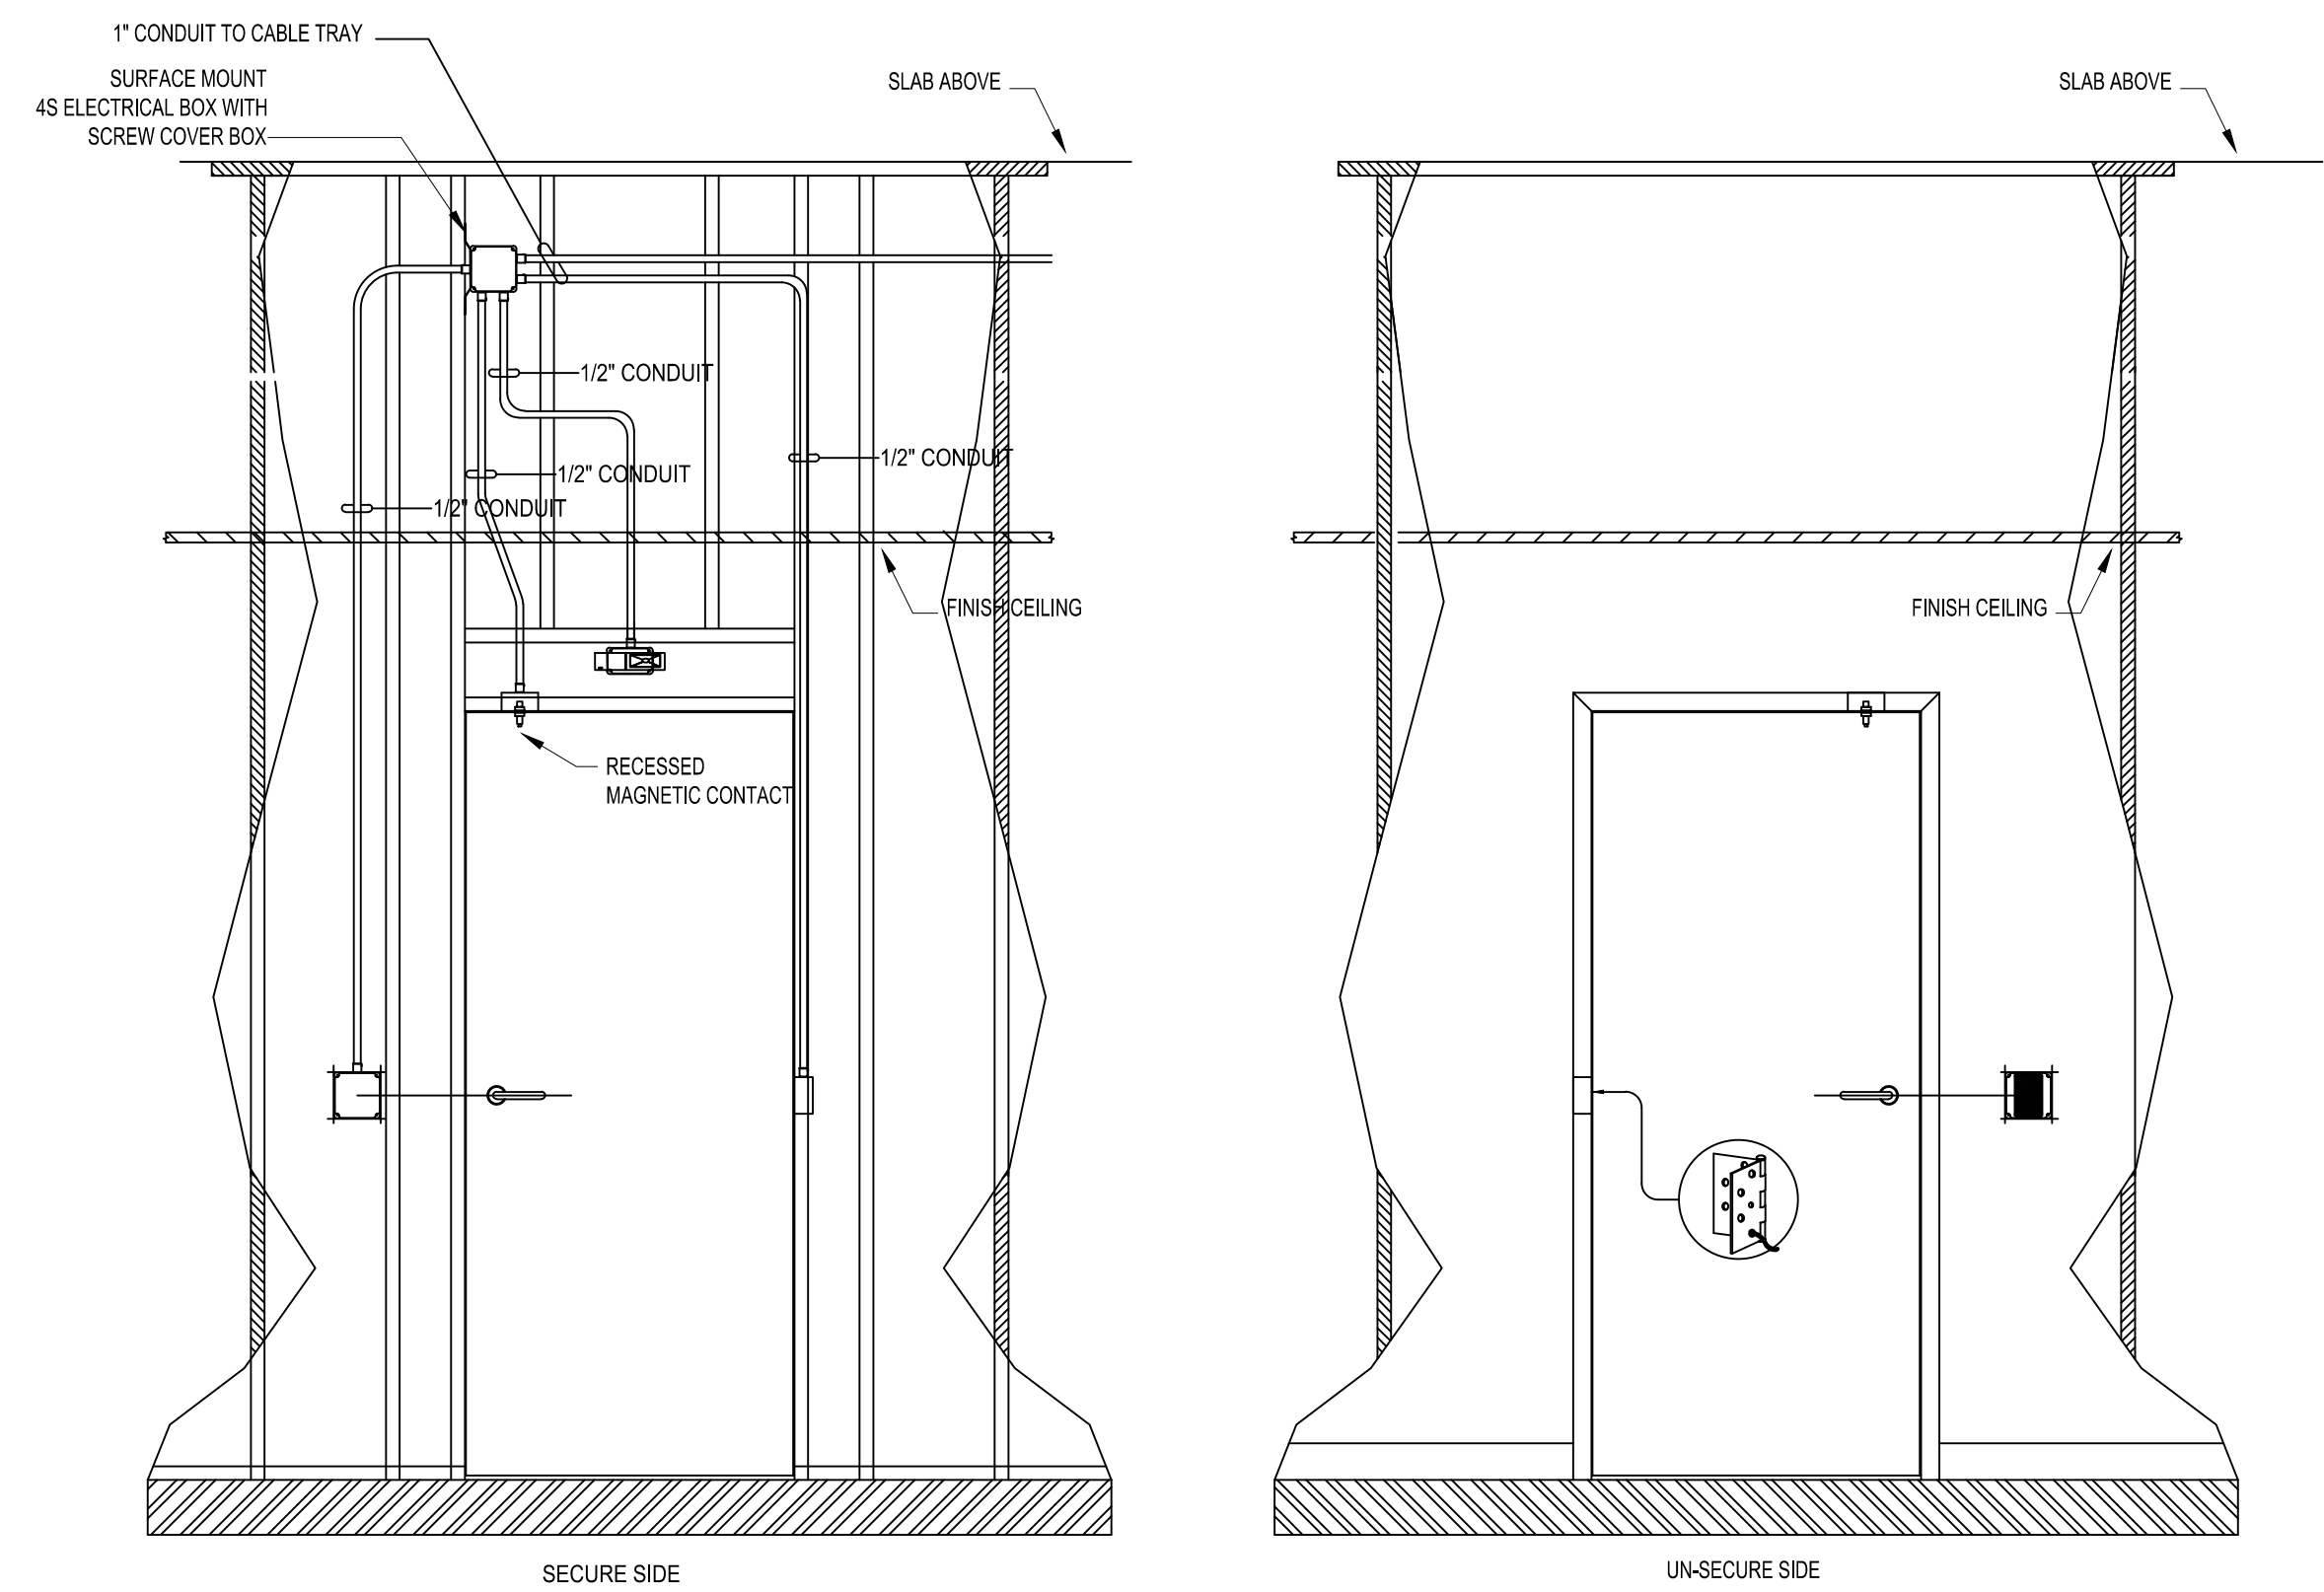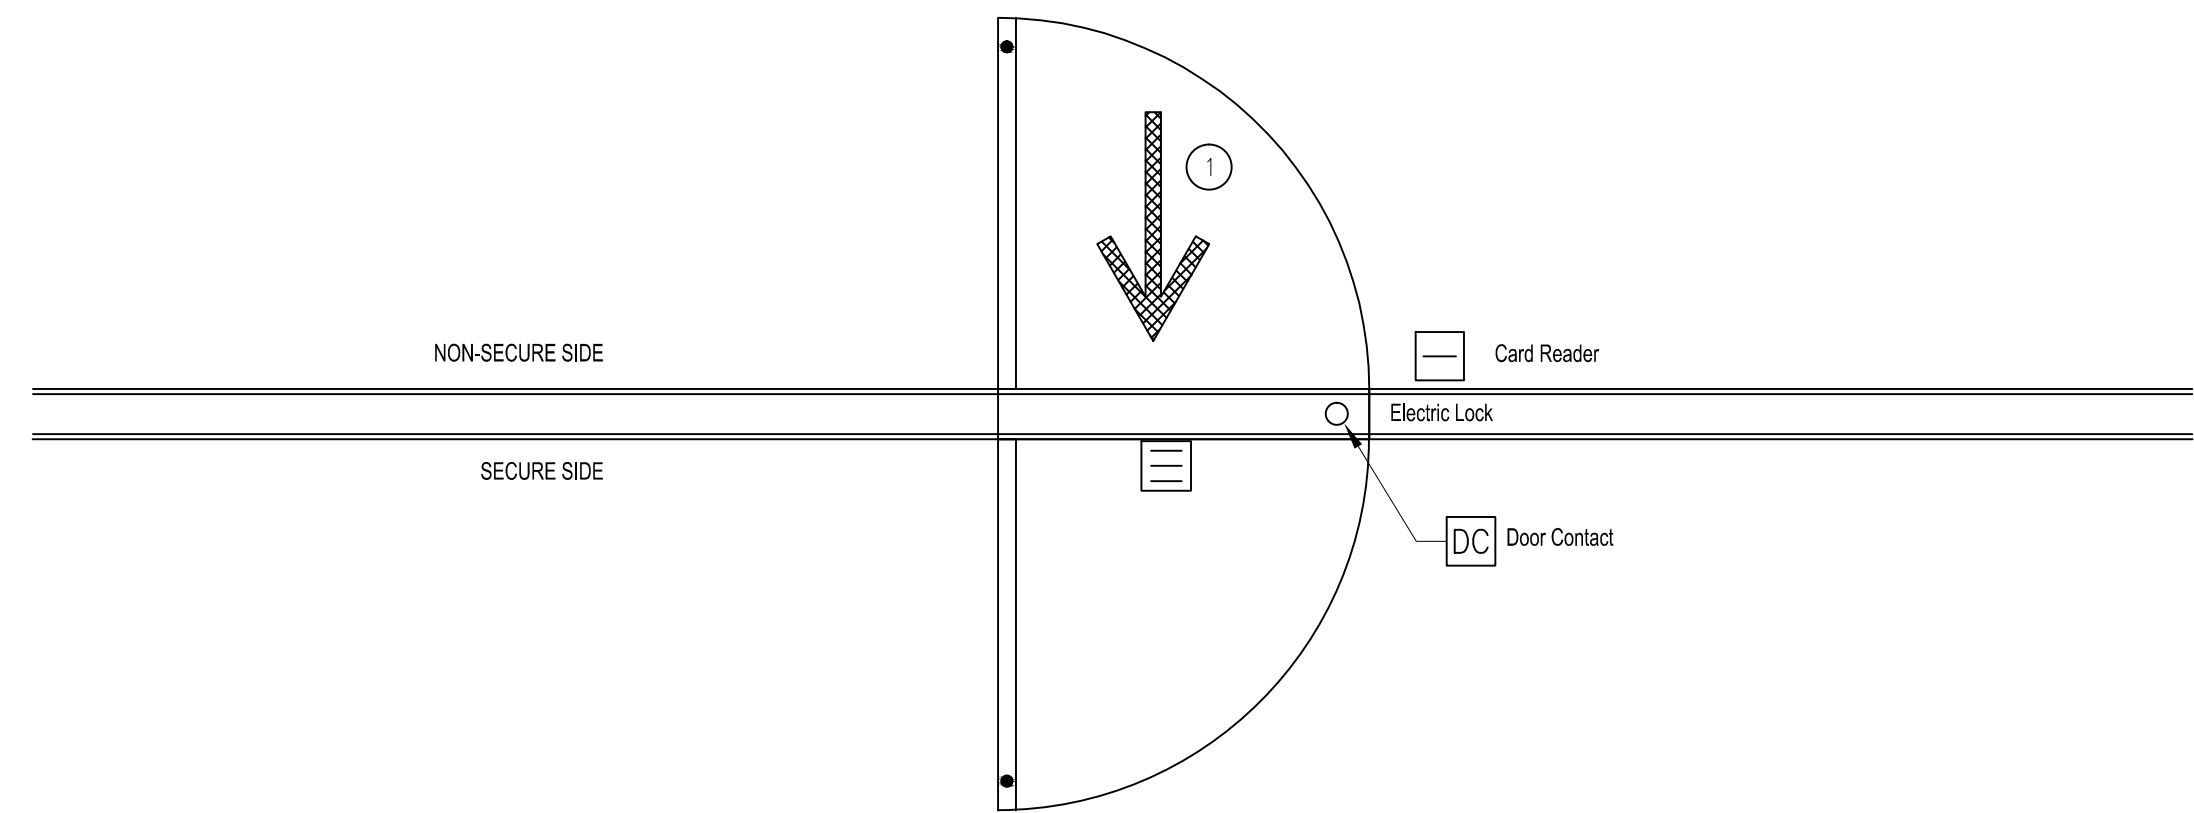

1 DOOR TYPE 3
TS.02 NTS

DRAWING PREPARED BY:



1511 E. ORANGETHORPE BLVD.
FULLERTON, CALIFORNIA 92831
714-525-4350 - o; 714-525-4386 - f
(c) Copyright 2012 KRATOS | HBE
All Rights Reserved.

MUST BE SIGNED BY HBE
TO AUTHENTICATE CONTENT(S).
ALL DETAILS CHECKED FOR ACCURACY.


SIGNATURE _____ DATE _____

HBE JOB #

CONFIDENTIAL

THE INFORMATION CONTAINED HERIN MAY
NOT BE USED OR REPRODUCED IN ANY
MANNER WITHOUT WRITTEN PERMISSION OF
KRATOS | HBE.

KEY PLAN

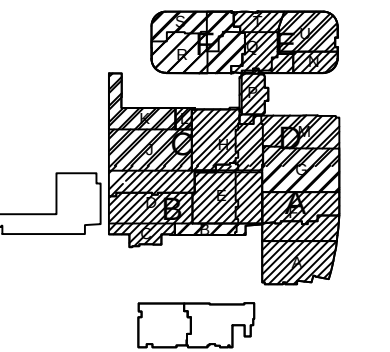

NO.	REV DESCRIPTION REV DATE	APPROVED BY
1.	AS BUILTS 08/15/2012	JOHN J. CHRISTIE

REV.	DESCRIPTION	APPROVED BY
------	-------------	-------------

CUSTOMER:



PROJECT:


CHOC CHILDREN'S
HOSPITAL
455 SOUTH MAIN ST.
ORANGE, CA 92668

DRAWING TITLE:

SECURITY SYSTEM
DOOR DETAILS

DRN BY	DATE DRN	CHK BY	DATE CHK
JOSH G.	08/08/2012	JJC	
SCALE:	AS NOTED		
DWG NO.	SE5.02		

ASBUILTS
08/15/2012

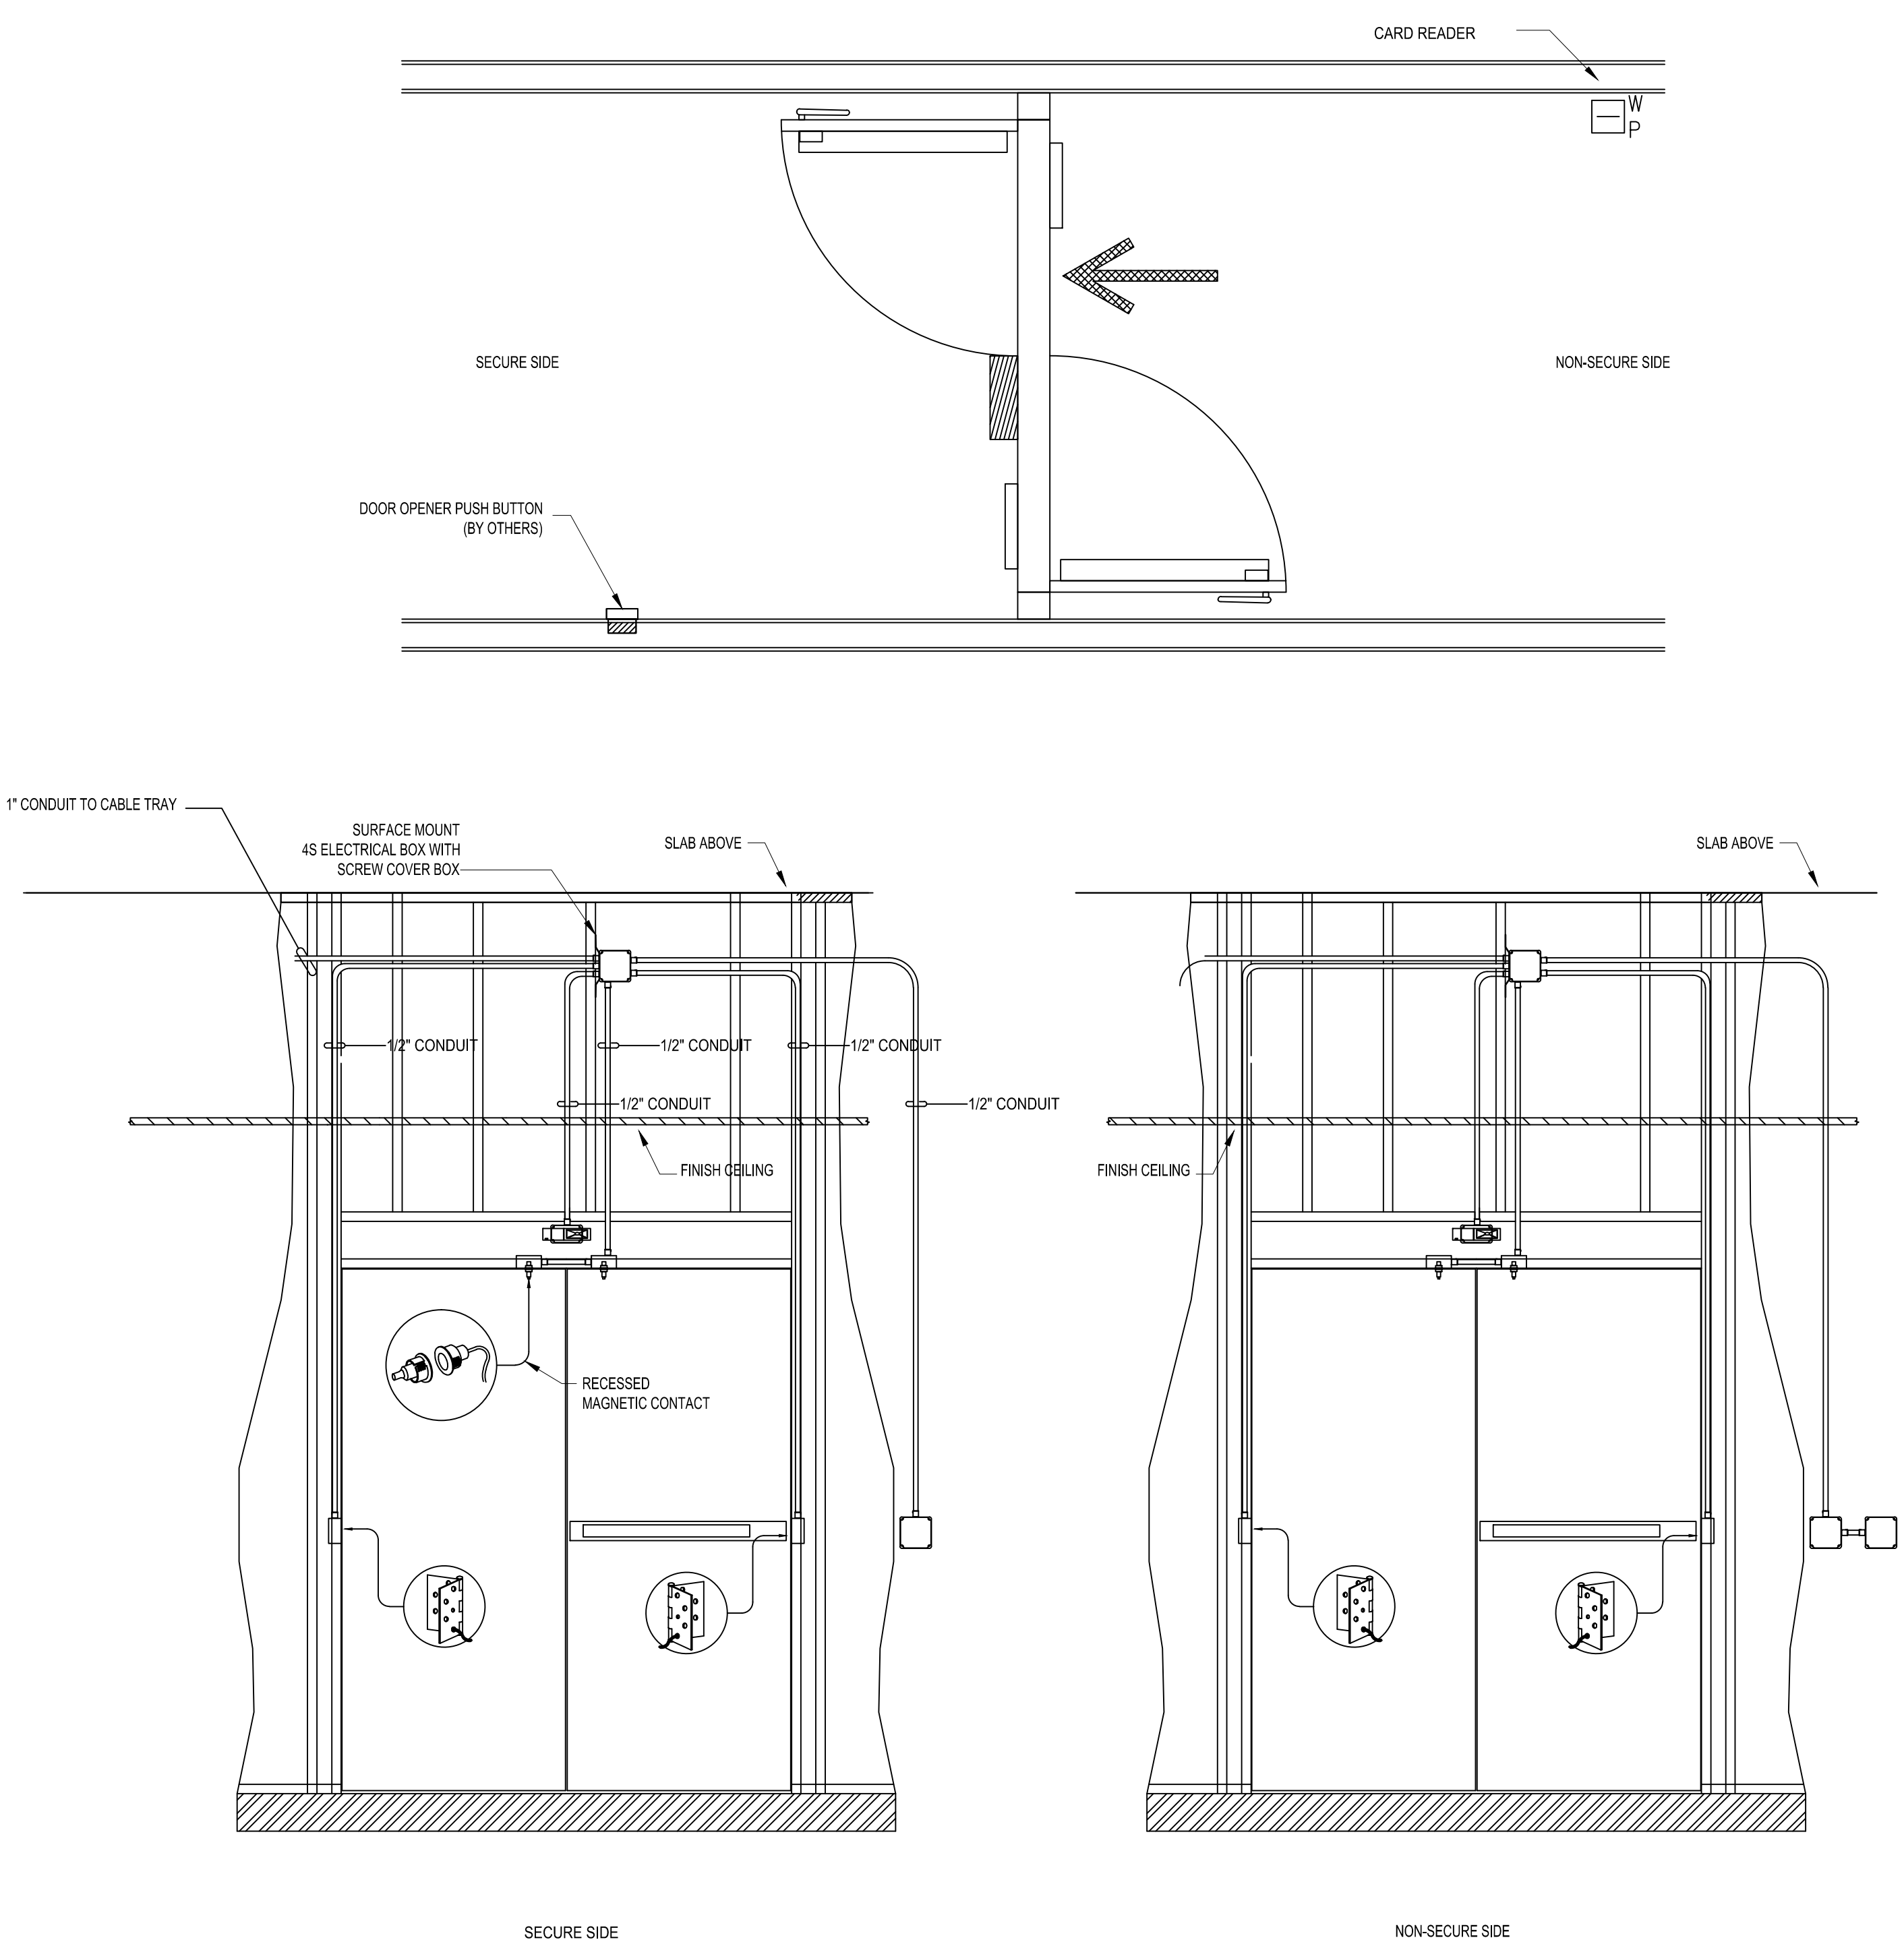

1 DOOR TYPE 5
TS.03 NTS

DRAWING PREPARED BY:




1511 E. ORANGETHORPE BLVD.
FULLERTON, CALIFORNIA 92831
714-525-4350 - o; 714-525-4386 - f
(c) Copyright 2012 KRATOS | HBE
All Rights Reserved.

MUST BE SIGNED BY HBE
TO AUTHENTICATE CONTENT(S).
ALL DETAILS CHECKED FOR ACCURACY.

SIGNATURE _____ DATE _____

HBE JOB # _____

CONFIDENTIAL
THE INFORMATION CONTAINED HEREIN MAY
NOT BE USED OR REPRODUCED IN ANY
MANNER WITHOUT WRITTEN PERMISSION OF
KRATOS | HBE.

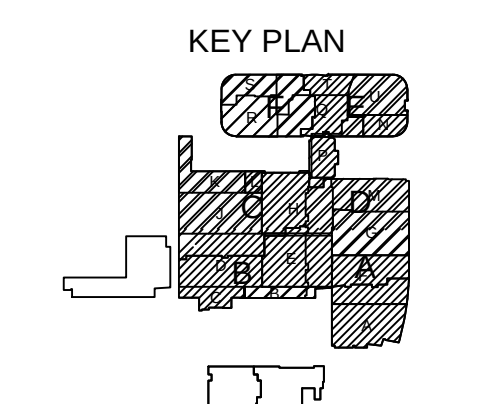

NO.	REV DESCRIPTION REV DATE	APPROVED BY
1.	AS BUILTS 08/15/2012	JOHN J. CHRISTIE

REV.	DESCRIPTION	APPROVED BY
------	-------------	-------------







PROJECT:
CHOC CHILDREN'S
HOSPITAL
455 SOUTH MAIN ST.
ORANGE, CA 92668

DRAWING TITLE:
**SECURITY SYSTEM
DOOR DETAILS**


DRN BY	DATE DRN	CHK BY	DATE CHK
JOSH G.	08/08/2012	JJC	
SCALE:	AS NOTED		
DWG NO.	SE5.03		

**ASBUILTS
08/15/2012**

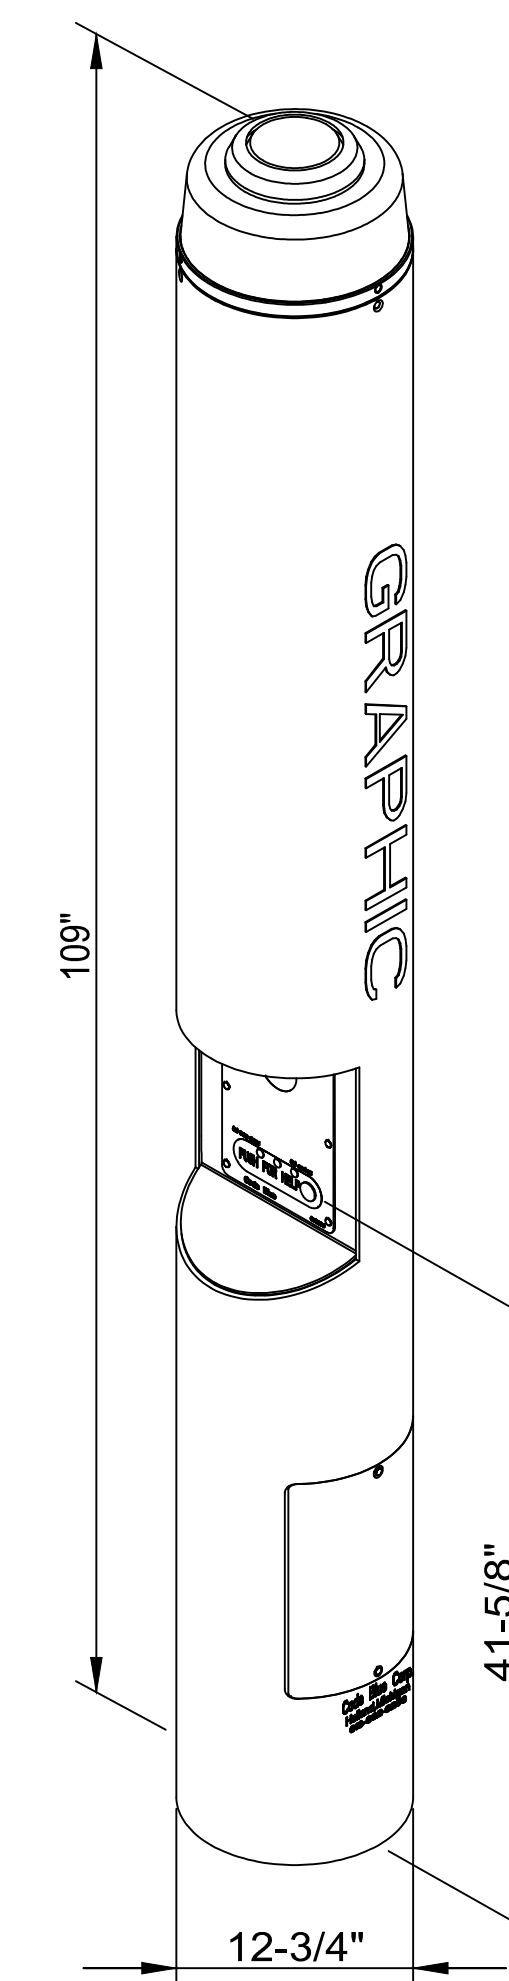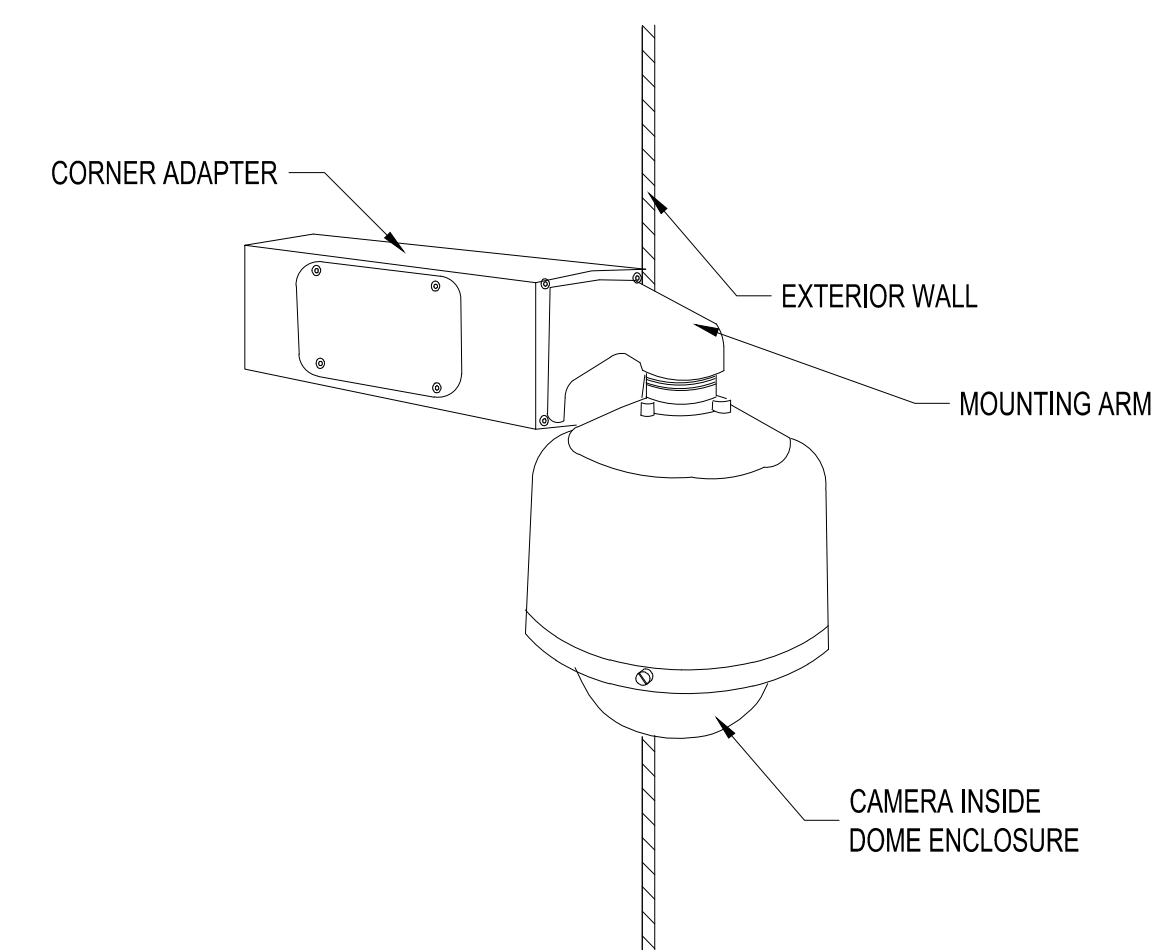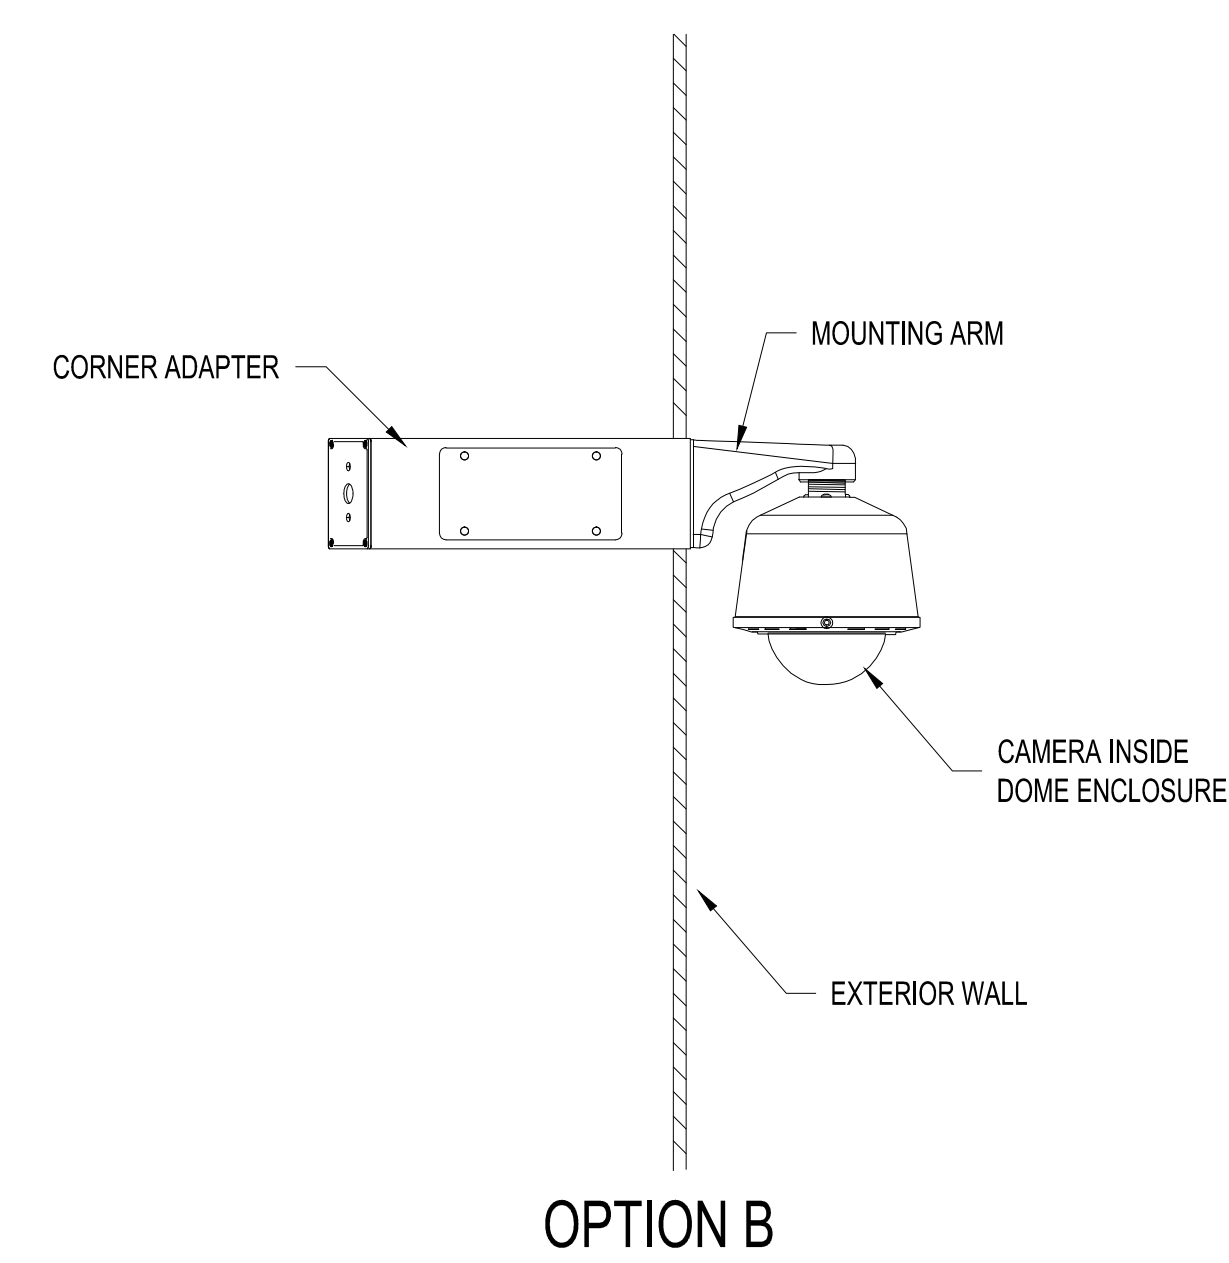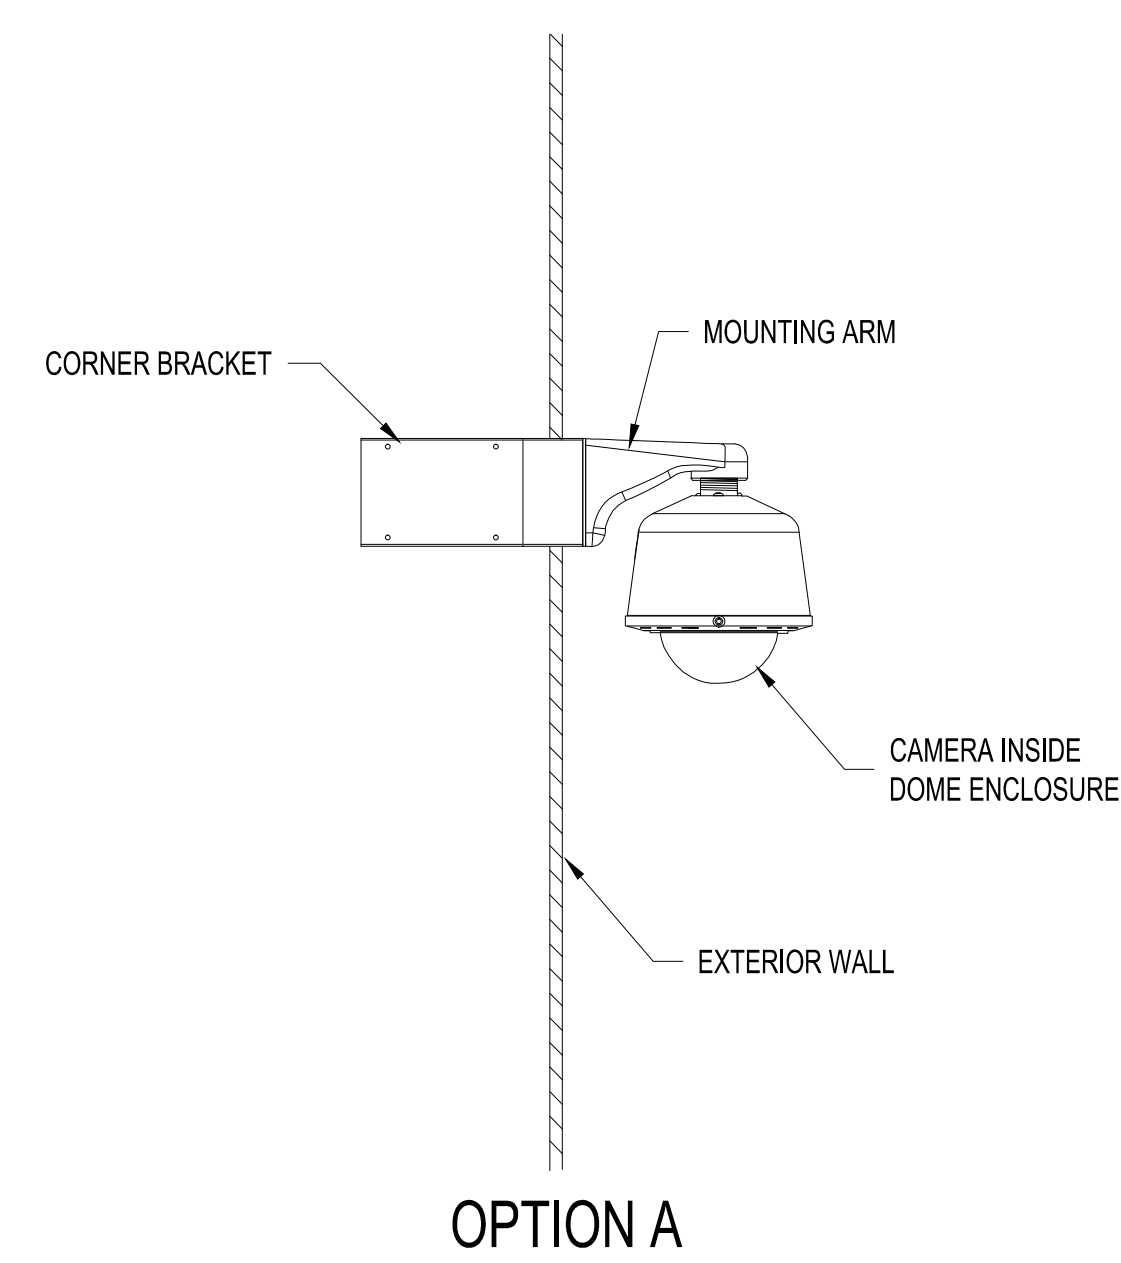


6 CCTV CORNER MOUNT DETAIL
T5.04 NTS


1 EMERGENCY PHONE DETAIL

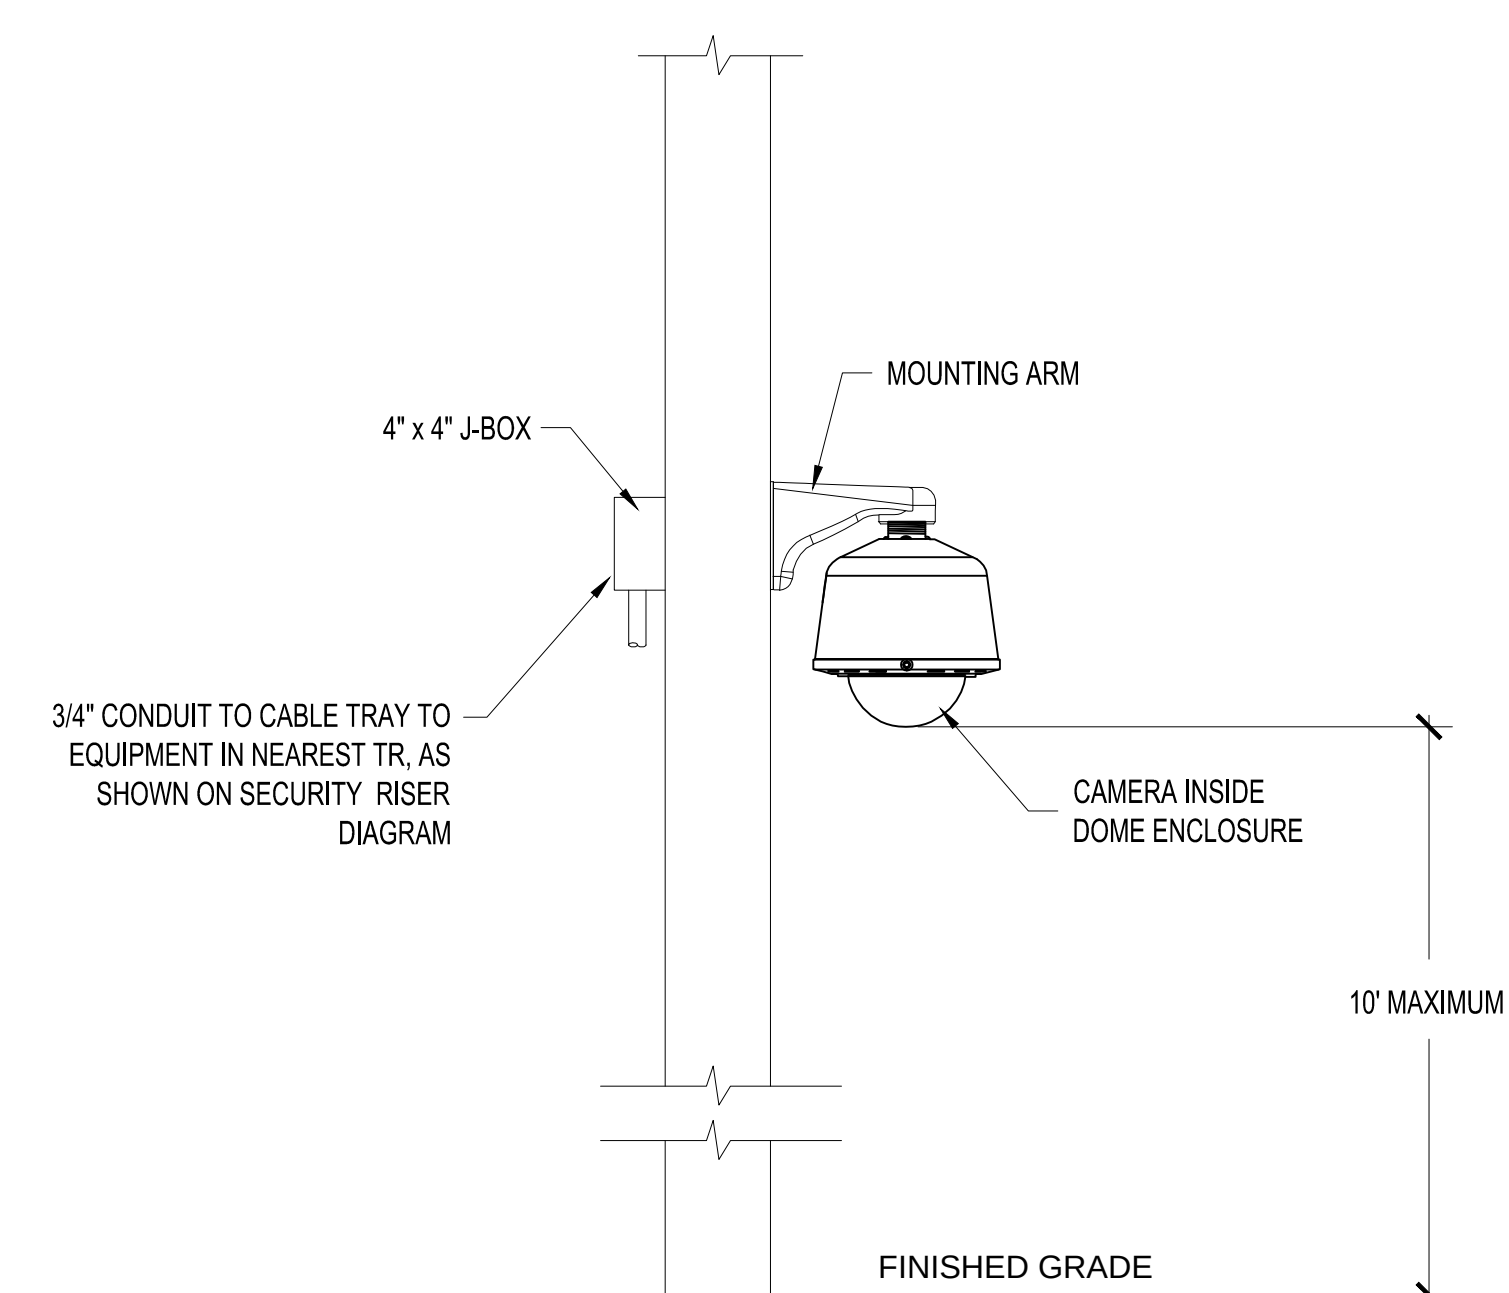

4 CCTV POLE MOUNT DETAIL
T5.04 NTS

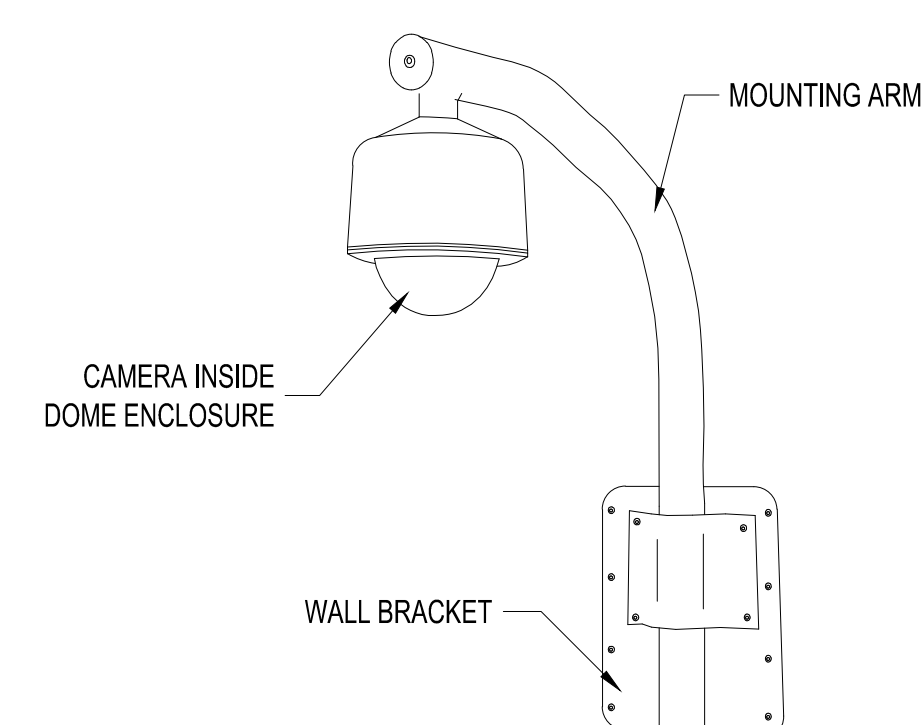

3 EXTERIOR WALL MOUNT DETAIL
T5.04 NTS

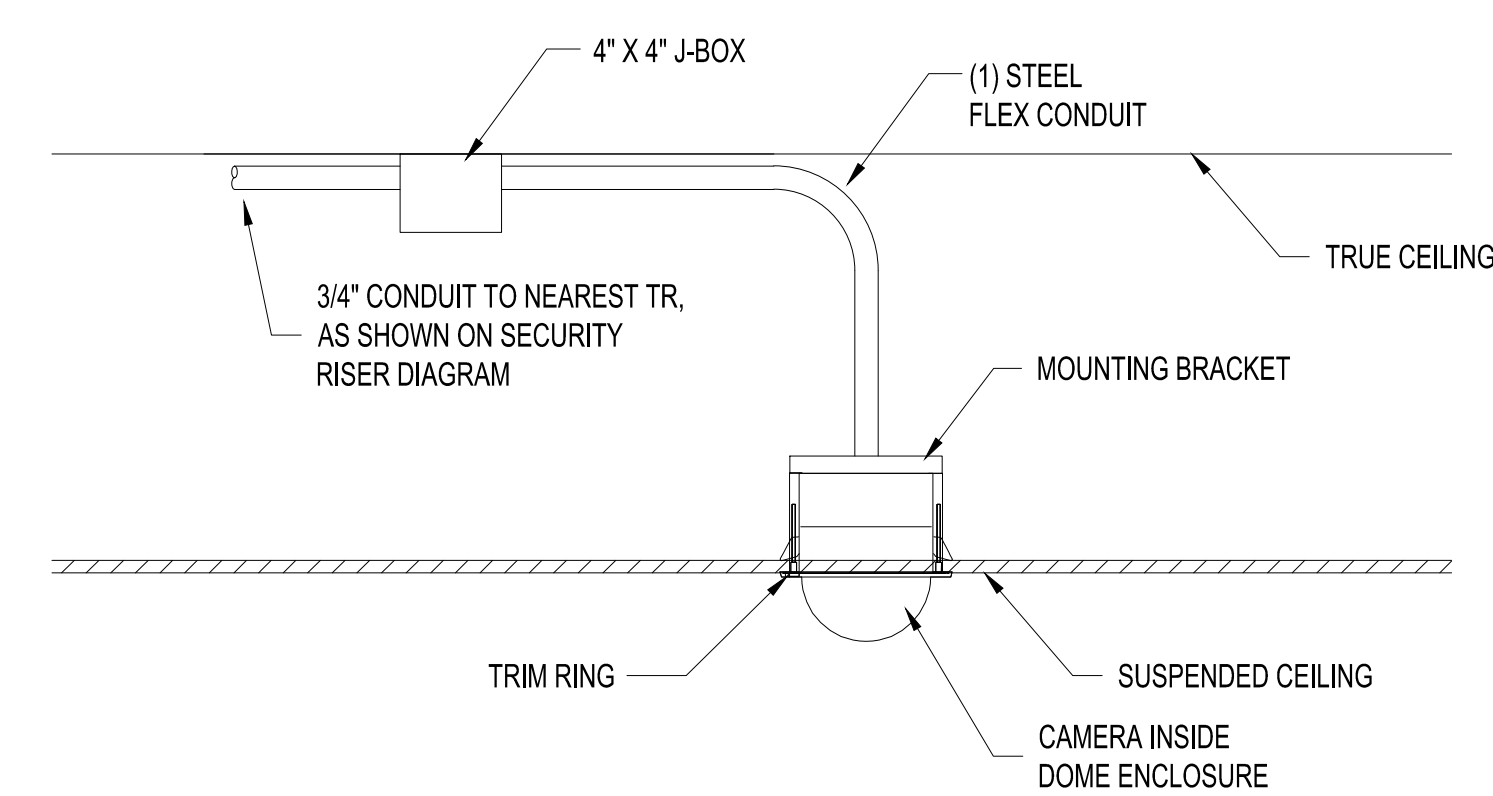

2 IP CCTV INTERIOR MOUNTING DETAIL
T5.04 NTS

DRAWING PREPARED BY:



1511 E. ORANGETHORPE BLVD.
FULLERTON, CALIFORNIA 92831
714-525-4350 - o; 714-525-4386 - f
(c) Copyright 2012 KRATOS | HBE
All Rights Reserved.

**MUST BE SIGNED BY HBE
TO AUTHENTICATE CONTENT(S).
ALL DETAILS CHECKED FOR ACCURACY.**


SIGNATURE _____ DATE _____

HBE JOB #

CONFIDENTIAL

THE INFORMATION CONTAINED HEREIN MAY NOT BE USED OR REPRODUCED IN ANY MANNER WITHOUT WRITTEN PERMISSION OF KRATOS | HBE.

KEY PLAN

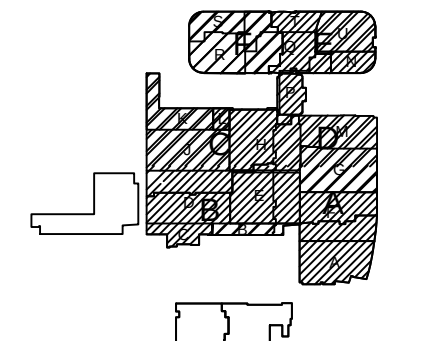

NO.	REV DESCRIPTION REV DATE	APPROVED BY
1.	AS BUILTS 08/15/2012	JOHN J. CHRISTIE
REV.	DESCRIPTION	APPROVED BY

THE FT	DEPOSIT FUND	THE FT FUND OF
CUSTOMER:		

CUSTOMER:



PROJECT:


CHOC CHILDREN'S
HOSPITAL
455 SOUTH MAIN ST.
ORANGE, CA 92668

DRAWING TITLE:

CCTV DETAILS

DRN BY	DATE DRN	CHK BY	DATE CHK
JOSH G.	08/08/2012	JJC	
SCALE:	AS NOTED		
DWG NO.	SE5.04		

ASBUILTS
08/15/2012

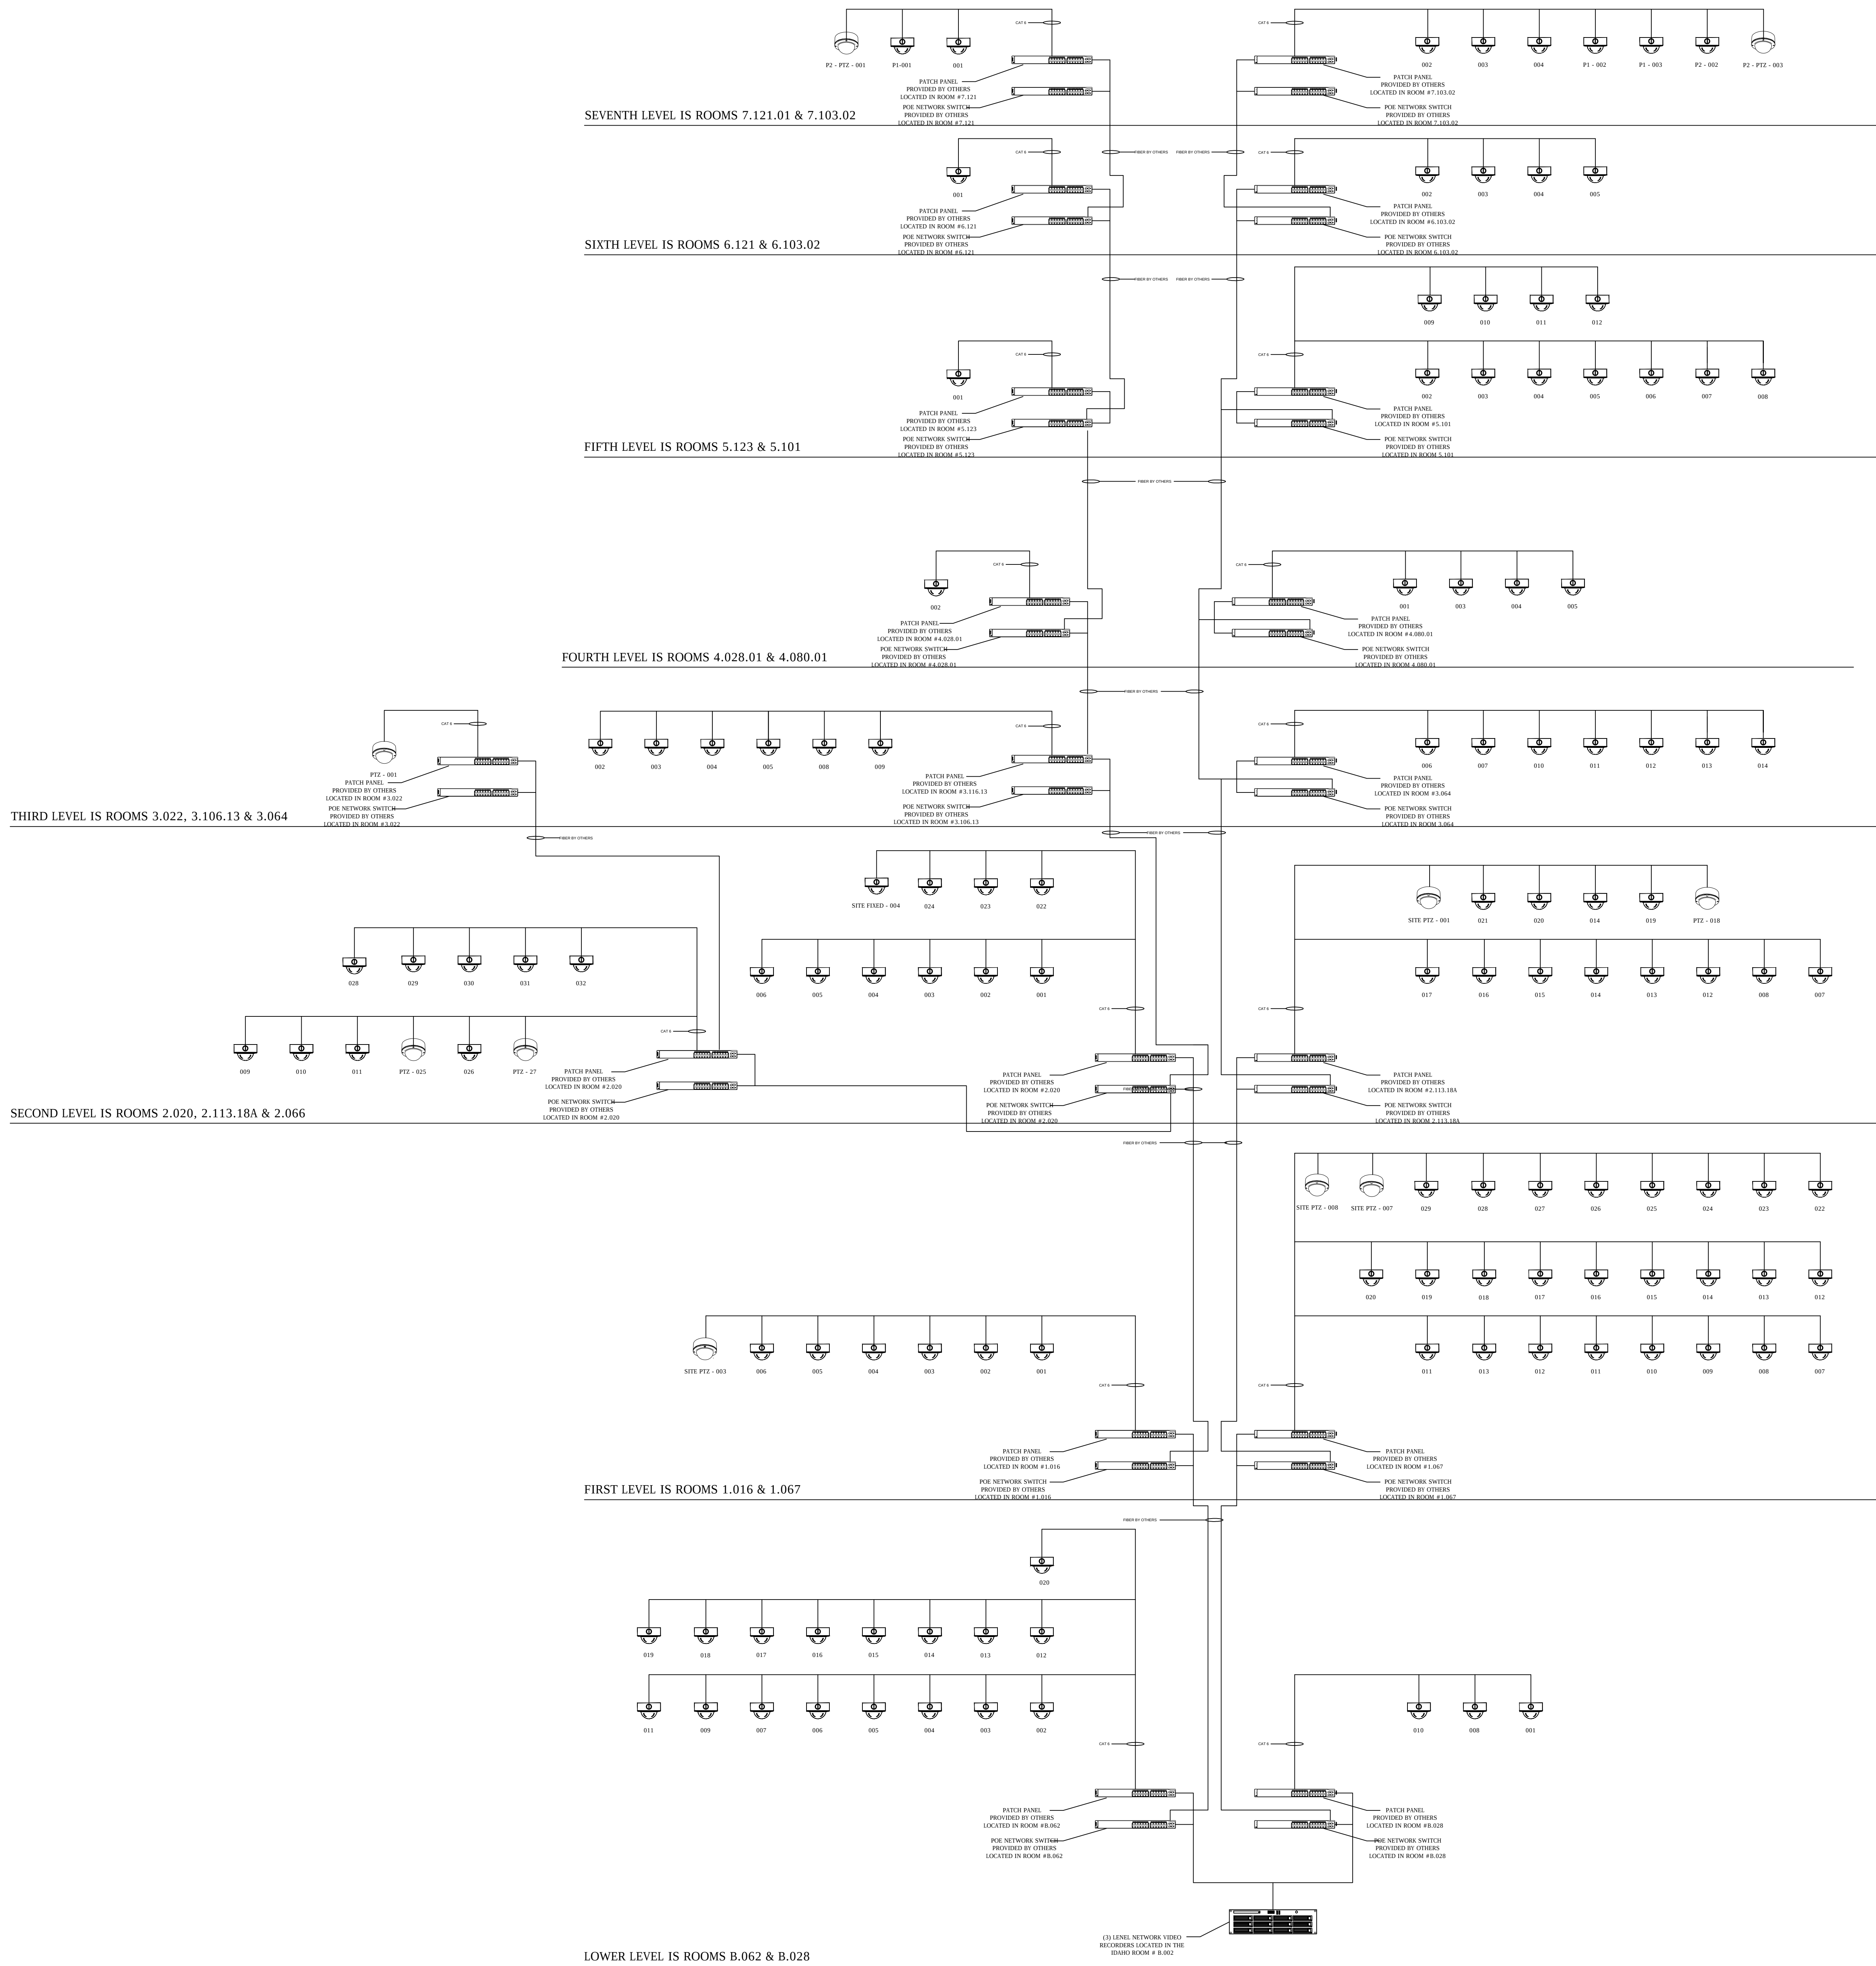

DRAWING PREPARED BY:



1511 E. ORANGETHORPE BLVD.
FULLERTON, CALIFORNIA 92831
714-525-4350 - o; 714-525-4386 - f
(c) Copyright 2012 KRATOS | HBE
All Rights Reserved.


MUST BE SIGNED BY HBE
TO AUTHENTICATE CONTENT(S).
ALL DETAILS CHECKED FOR ACCURACY.

SIGNATURE _____ DATE _____

HBE JOB #

CONFIDENTIAL
THE INFORMATION CONTAINED HEREIN MAY
NOT BE USED OR REPRODUCED IN ANY
MANNER WITHOUT WRITTEN PERMISSION OF
KRATOS | HBE.

KEY PLAN

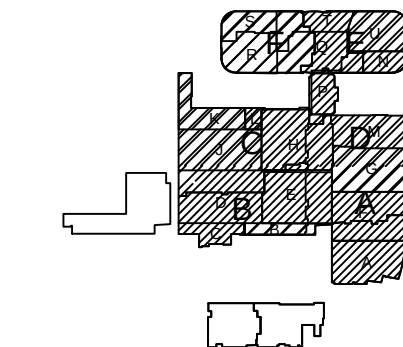

NO.	REV DESCRIPTION REV DATE	APPROVED BY
1.	AS BUILTS 09/24/2012	JOHN J. CHRISTIE
2.	CHANGE ORDER #376	JOHN J. CHRISTIE

REV.	DESCRIPTION	APPROVED BY
------	-------------	-------------

CUSTOMER:



PROJECT:
CHOC CHILDREN'S
HOSPITAL
455 SOUTH MAIN ST.
ORANGE, CA 92668

DRAWING TITLE:
CCTV SYSTEM
RISER DIAGRAM

DRN BY	DATE DRN	CHK BY	DATE CHK
JOSH G.	08/08/2012	JJC	
SCALE:	NTS		
DWG NO.	SE6.06		

ASBUILTS
09/26/2012

DRAWING PREPARED BY:



1511 E. ORANGETHORPE BLVD.
FULLERTON, CALIFORNIA 92831
714-525-4350 - o: 714-525-4386 - f
(c) Copyright 2012 KRATOS | HBE
All Rights Reserved.


MUST BE SIGNED BY HBE
TO AUTHENTICATE CONTENT(S).
ALL DETAILS CHECKED FOR ACCURACY.

SIGNATURE _____ DATE _____


HBE JOB #

CONFIDENTIAL
THE INFORMATION CONTAINED HEREIN MAY
NOT BE USED OR REPRODUCED IN ANY
MANNER WITHOUT WRITTEN PERMISSION OF
KRATOS | HBE.

KEY PLAN

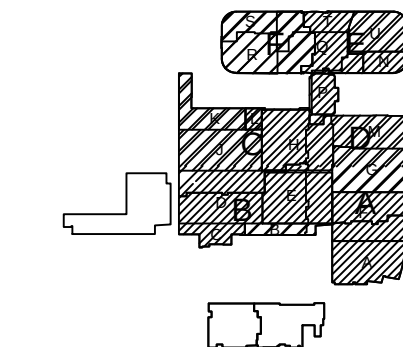

NO.	REV DESCRIPTION REV DATE	APPROVED BY
1.	AS BUILTS 09/24/2012	JOHN J. CHRISTIE
ASB	CHANGE ORDER #376	JOHN J. CHRISTIE

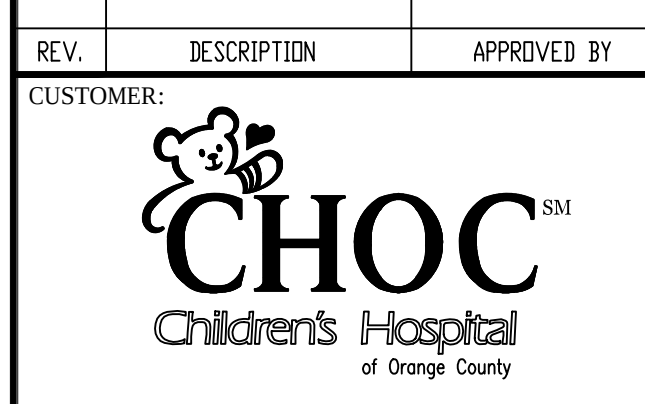

PROJECT:
CHOC CHILDREN'S
HOSPITAL
455 SOUTH MAIN ST.
ORANGE, CA 92668

DRAWING TITLE:
**ACCESS CONTROL
RISER DIAGRAM**

DRN BY	DATE DRN	CHK BY	DATE CHK
JOSH G.	08/08/2012	JJC	
SCALE:	NTS		
DWG. NO.	SE6.07		

**ASBUILTS
08/15/2012**

DEVICE	DESCRIPTION	QTY
CR-01-SACP-001	CARD READER	10
CR-01-SACP-002	DOOR CONTACT	10
CR-01-SACP-003	REQUEST TO EXIT DEVICE W/ DOOR LOCKS	10
CR-01-SACP-004	RECEIVED LOCK	10
CR-01-SACP-005	PANIC BUTTON	2
CR-01-SACP-006	INTERCOM	2
CR-01-SACP-007	ACCESS CONTROL PANEL	1
CR-01-SACP-008	RECEIVED LOCATION CITY PANEL LOCATIONS	1
CR-01-SACP-009	PROTECTION SLIDES	1

SEVENTH LEVEL IS ROOM 7.103.02

DEVICE	DESCRIPTION	QTY
CR-01-SACP-001	CARD READER	4
CR-01-SACP-002	DOOR CONTACT	4
CR-01-SACP-003	REQUEST TO EXIT DEVICE W/ DOOR LOCKS	4
CR-01-SACP-004	RECEIVED LOCK	4
CR-01-SACP-005	PANIC BUTTON	2
CR-01-SACP-006	INTERCOM	2
CR-01-SACP-007	ACCESS CONTROL PANEL	1
CR-01-SACP-008	RECEIVED LOCATION CITY PANEL LOCATIONS	1
CR-01-SACP-009	PROTECTION SLIDES	1

SIXTH LEVEL IS ROOM 6.121

DEVICE	DESCRIPTION	QTY
CR-01-SACP-001	CARD READER	23
CR-01-SACP-002	DOOR CONTACT	23
CR-01-SACP-003	REQUEST TO EXIT DEVICE W/ DOOR LOCKS	23
CR-01-SACP-004	RECEIVED LOCK	23
CR-01-SACP-005	PANIC BUTTON	2
CR-01-SACP-006	INTERCOM	2
CR-01-SACP-007	ACCESS CONTROL PANEL	1
CR-01-SACP-008	RECEIVED LOCATION CITY PANEL LOCATIONS	1
CR-01-SACP-009	PROTECTION SLIDES	1

FIFTH LEVEL IS ROOM 5.123 & 5.101

DEVICE	DESCRIPTION	QTY
CR-01-SACP-001	CARD READER	9
CR-01-SACP-002	DOOR CONTACT	9
CR-01-SACP-003	REQUEST TO EXIT DEVICE W/ DOOR LOCKS	9
CR-01-SACP-004	RECEIVED LOCK	9
CR-01-SACP-005	PANIC BUTTON	2
CR-01-SACP-006	INTERCOM	2
CR-01-SACP-007	ACCESS CONTROL PANEL	1
CR-01-SACP-008	RECEIVED LOCATION CITY PANEL LOCATIONS	1
CR-01-SACP-009	PROTECTION SLIDES	1

FOURTH LEVEL IS ROOM 4.028.01, 4.080.01 & 4.135

DEVICE	DESCRIPTION	QTY
CR-01-SACP-001	CARD READER	43
CR-01-SACP-002	DOOR CONTACT	43
CR-01-SACP-003	REQUEST TO EXIT DEVICE W/ DOOR LOCKS	43
CR-01-SACP-004	RECEIVED LOCK	43
CR-01-SACP-005	PANIC BUTTON	2
CR-01-SACP-006	INTERCOM	2
CR-01-SACP-007	ACCESS CONTROL PANEL	1
CR-01-SACP-008	RECEIVED LOCATION CITY PANEL LOCATIONS	1
CR-01-SACP-009	PROTECTION SLIDES	1

THIRD LEVEL IS ROOM 3.064, 3.022 & 3.106.13

DEVICE	DESCRIPTION	QTY
CR-01-SACP-001	CARD READER	33
CR-01-SACP-002	DOOR CONTACT	33
CR-01-SACP-003	REQUEST TO EXIT DEVICE W/ DOOR LOCKS	33
CR-01-SACP-004	RECEIVED LOCK	33
CR-01-SACP-005	PANIC BUTTON	2
CR-01-SACP-006	INTERCOM	2
CR-01-SACP-007	ACCESS CONTROL PANEL	1
CR-01-SACP-008	RECEIVED LOCATION CITY PANEL LOCATIONS	1
CR-01-SACP-009	PROTECTION SLIDES	1

SECOND LEVEL IS ROOM 2.020 & 2.066

DEVICE	DESCRIPTION	QTY
CR-01-SACP-001	CARD READER	43
CR-01-SACP-002	DOOR CONTACT	43
CR-01-SACP-003	REQUEST TO EXIT DEVICE W/ DOOR LOCKS	43
CR-01-SACP-004	RECEIVED LOCK	43
CR-01-SACP-005	PANIC BUTTON	2
CR-01-SACP-006	INTERCOM	2
CR-01-SACP-007	ACCESS CONTROL PANEL	1
CR-01-SACP-008	RECEIVED LOCATION CITY PANEL LOCATIONS	1
CR-01-SACP-009	PROTECTION SLIDES	1

FIRST LEVEL IS ROOM 1.067 & 1.016


DEVICE	DESCRIPTION	QTY
CR-01-SACP-001	CARD READER	37
CR-01-SACP-002	DOOR CONTACT	37
CR-01-SACP-003	REQUEST TO EXIT DEVICE W/ DOOR LOCKS	37
CR-01-SACP-004	RECEIVED LOCK	37
CR-01-SACP-005	PANIC BUTTON	2
CR-01-SACP-006	INTERCOM	2
CR-01-SACP-007	ACCESS CONTROL PANEL	1
CR-01-SACP-008	RECEIVED LOCATION CITY PANEL LOCATIONS	1
CR-01-SACP-009	PROTECTION SLIDES	1

LOWER LEVEL IS ROOM B.062 & B.028



1 LOWER LEVEL ROOM B.062 - ACCESS POINT TO POINT
NO SCALE

NOTE:
*SINGLE DOOR CONTACT
**DOUBLE DOOR CONTACT

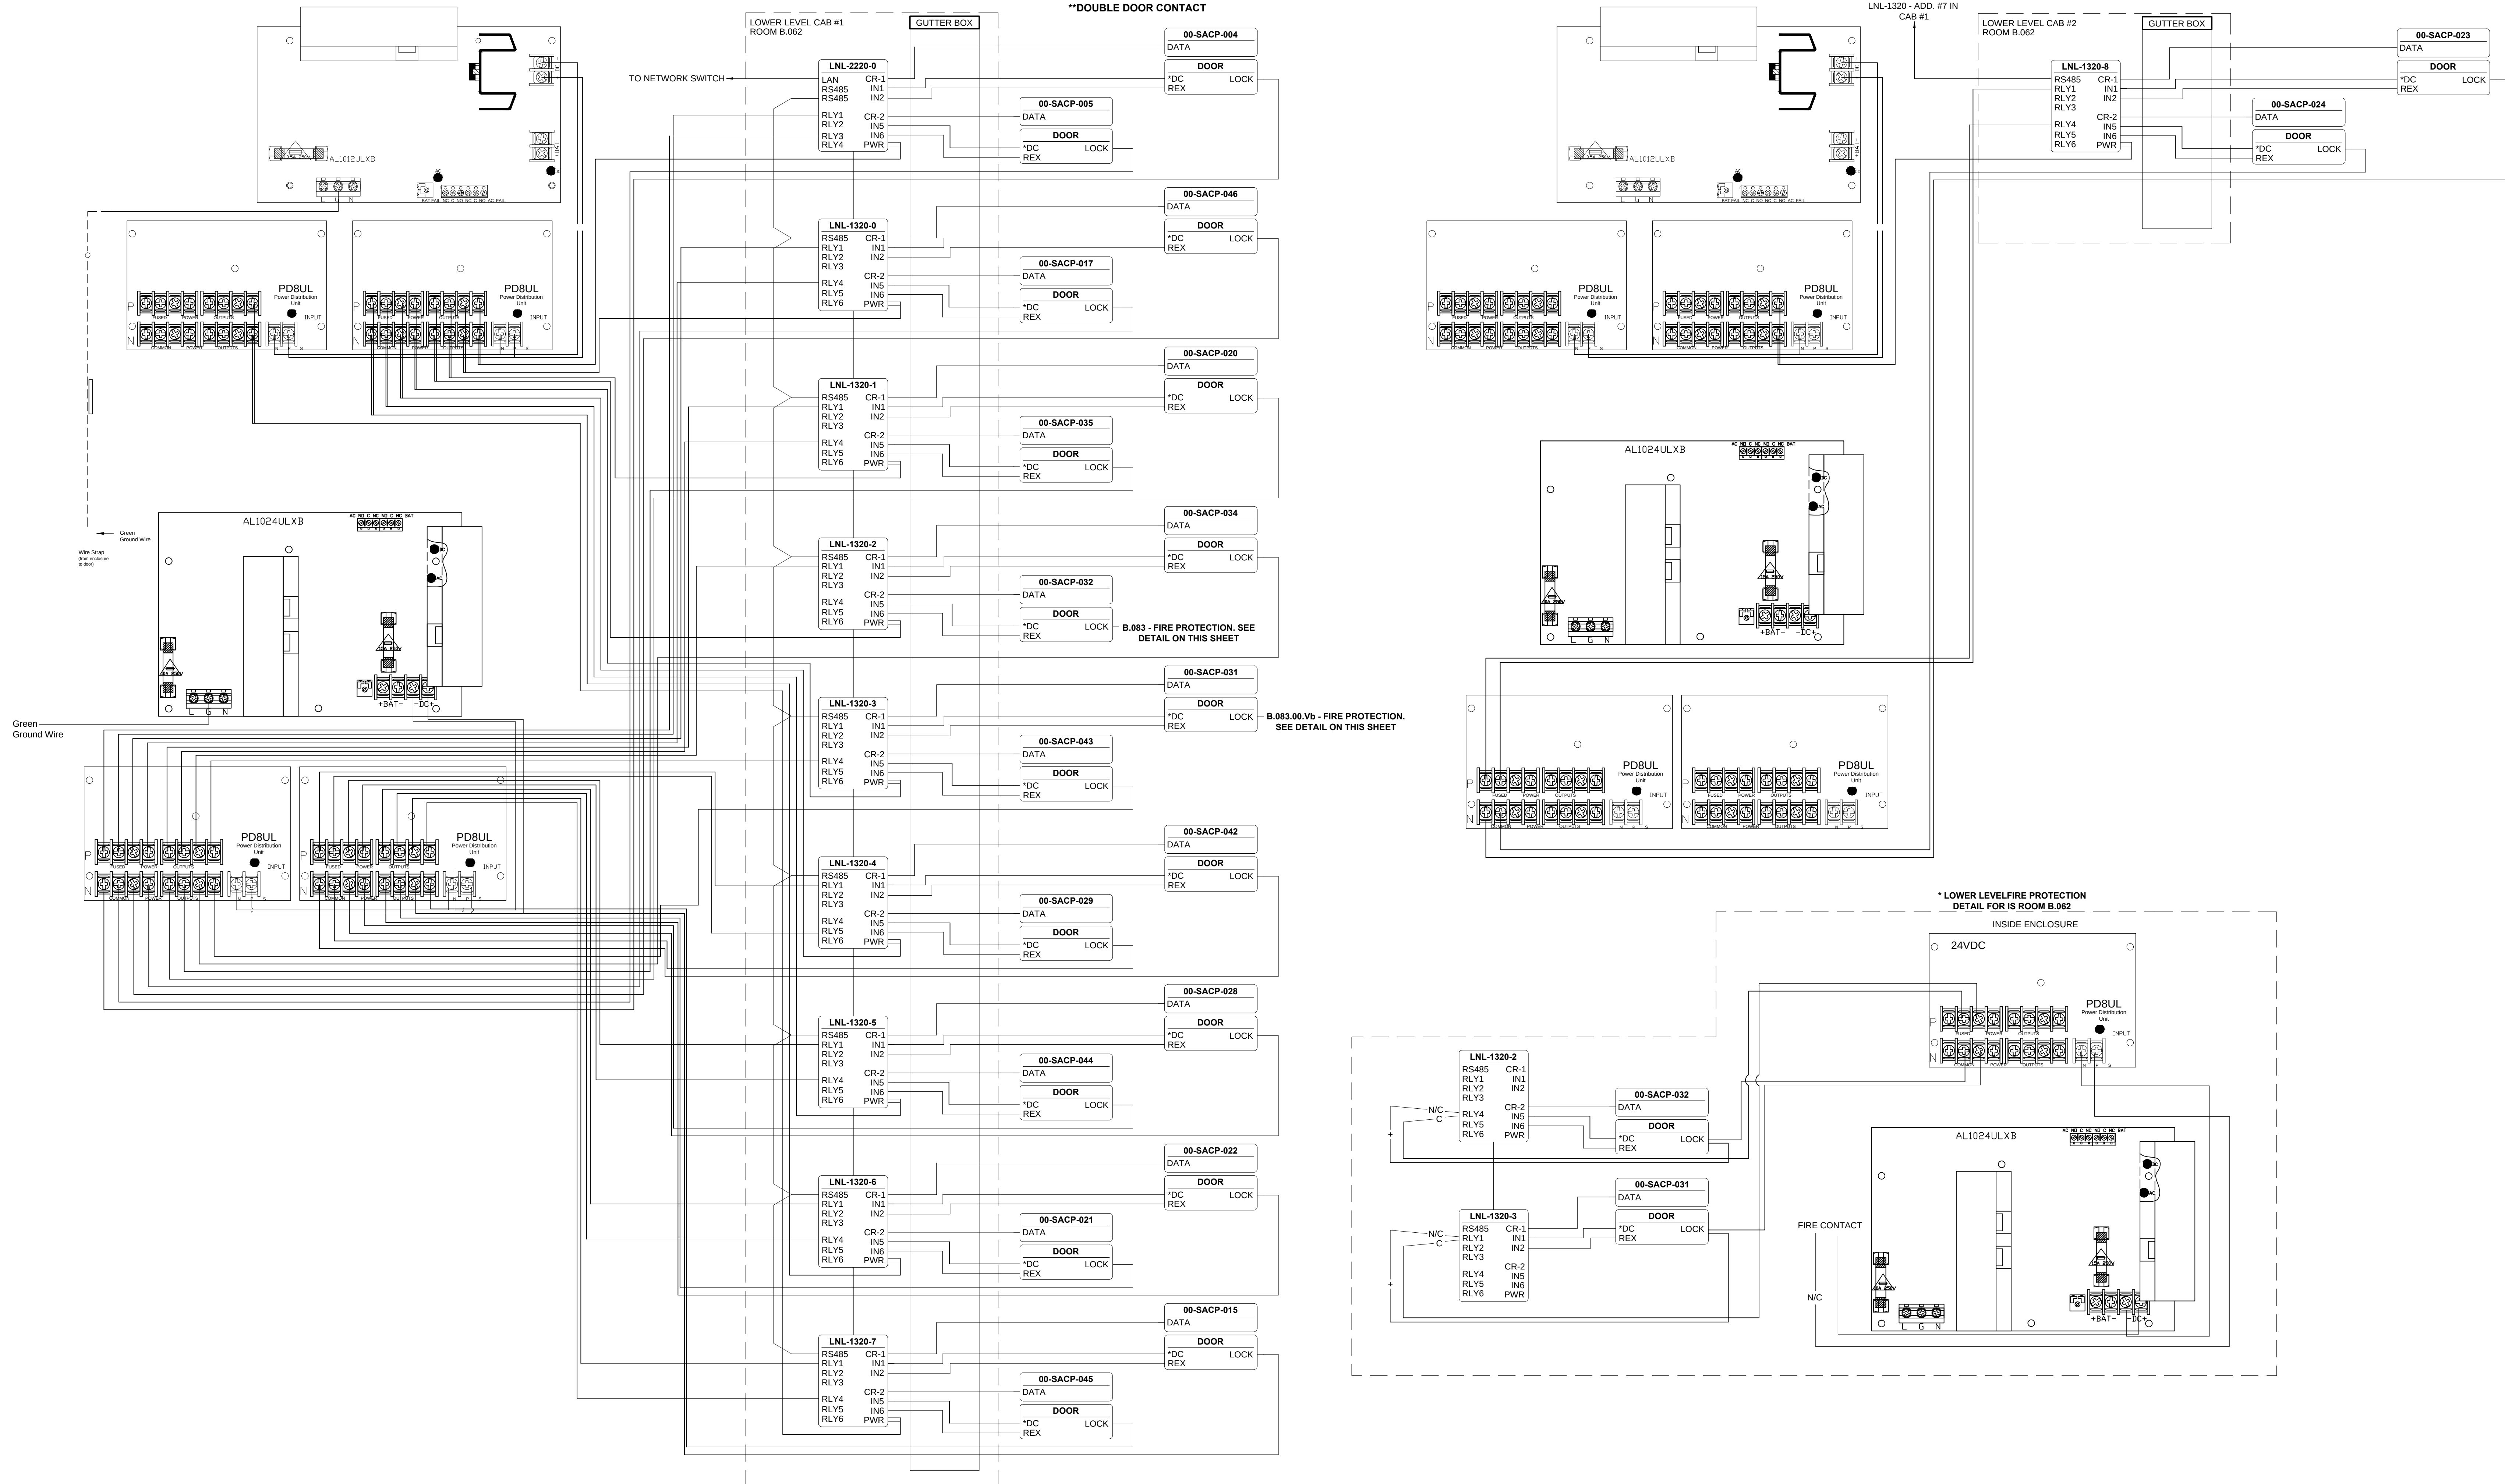

DRAWING PREPARED BY:



1511 E. ORANGETHORPE BLVD.
FULLERTON, CALIFORNIA 92831
714-525-4350 - o; 714-525-4386 - f
(c) Copyright 2012 KRATOS | HBE
All Rights Reserved.

MUST BE SIGNED BY HBE
TO AUTHENTICATE CONTENT(S).
ALL DETAILS CHECKED FOR ACCURACY.


SIGNATURE DATE

HBE JOB #

CONFIDENTIAL

THE INFORMATION CONTAINED HEREIN MAY
NOT BE USED OR REPRODUCED IN ANY
MANNER WITHOUT WRITTEN PERMISSION OF
KRATOS | HBE.

KEY PLAN

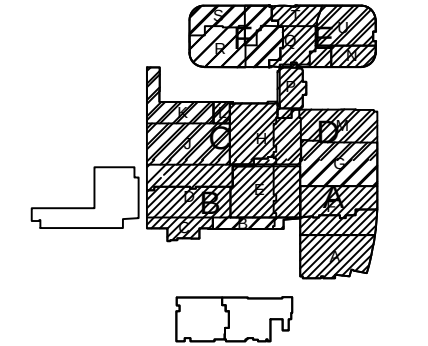

NO.	REV DESCRIPTION REV DATE	APPROVED BY
1.	AS BUILTS 08/15/2012	JOHN J. CHRISTIE

REV. DESCRIPTION APPROVED BY



PROJECT:
CHOC CHILDREN'S
HOSPITAL
455 SOUTH MAIN ST.
ORANGE, CA 92668

DRAWING TITLE:
LOWER LEVEL ACCESS
CONTROL POINT TO POINT
DIAGRAM -RMB.062

DRN BY	DATE DRN	CHK BY	DATE CHK
JOSH G.	08/08/2012	JJC	
SCALE:		NTS	
DWG NO.		SE7.00	

ASBUILTS
08/15/2012

NO SCALE

*DC LOCK — B.007.00.Cb - FIRE PROTECTION.
REF SEE DETAIL ON THIS SHEET

— B.052 - STAIR #4 - FIRE PROTECTION. SEE DETAIL ON THIS SHEET

00-SACP-040
DATA

*DC	LO
REX	

DOOR - 1.116.03

00-SACP-038

	DATA
	DOOR
*DC	LO

00-SACP-036
DATA

*DC	LO
REX	

00-SACP-006

	DATA
	DOOR
*DC	LO

TABLE 1

11

00-SACP-010
DATA

*DC	LOC
REX	

00 SACB 041

	DATA
	DOOR
*DC	LO

REX

— B.032 - STAIR #3 - FIRE
PROTECTION. SEE DETAIL O
THIS SHEET

00-SACP-019
DATA

	DOOR
*DC	LO
REX	

B-026-A STAIR #6 FIBR

PROTECTION. SEE DETAIL
ON THIS SHEET

DATA
DOOR
*DC

REX



**MUST BE SIGNED BY HBE
TO AUTHENTICATE CONTENT(S).
DETAILS CHECKED FOR ACCURACY.**

HBE JOB #

THE INFORMATION CONTAINED HEREIN MAY NOT BE USED OR REPRODUCED IN ANY MANNER WITHOUT WRITTEN PERMISSION OF KRATOS | HBE.

CUSTOMER:

 **CHOC**SM
Children's Hospital
of Orange County

DRAWING TITLE:


LOWER LEVEL ACCESS
CONTROL POINT TO POINT
DIAGRAM -RM B.028

DRN BY	DATE DRN	CHK BY	DATE CHK
JOSH G.	08/08/2012	JJC	
SCALE:	NTS		
DWG NO.	SE7.01		

ASBUILTS
08/15/2012

3 FIRST LEVEL ROOM 1.067 - ACCESS POINT TO POINT
NO SCALE

NOTE:
*SINGLE DOOR CONTACT
**DOUBLE DOOR CONTACT

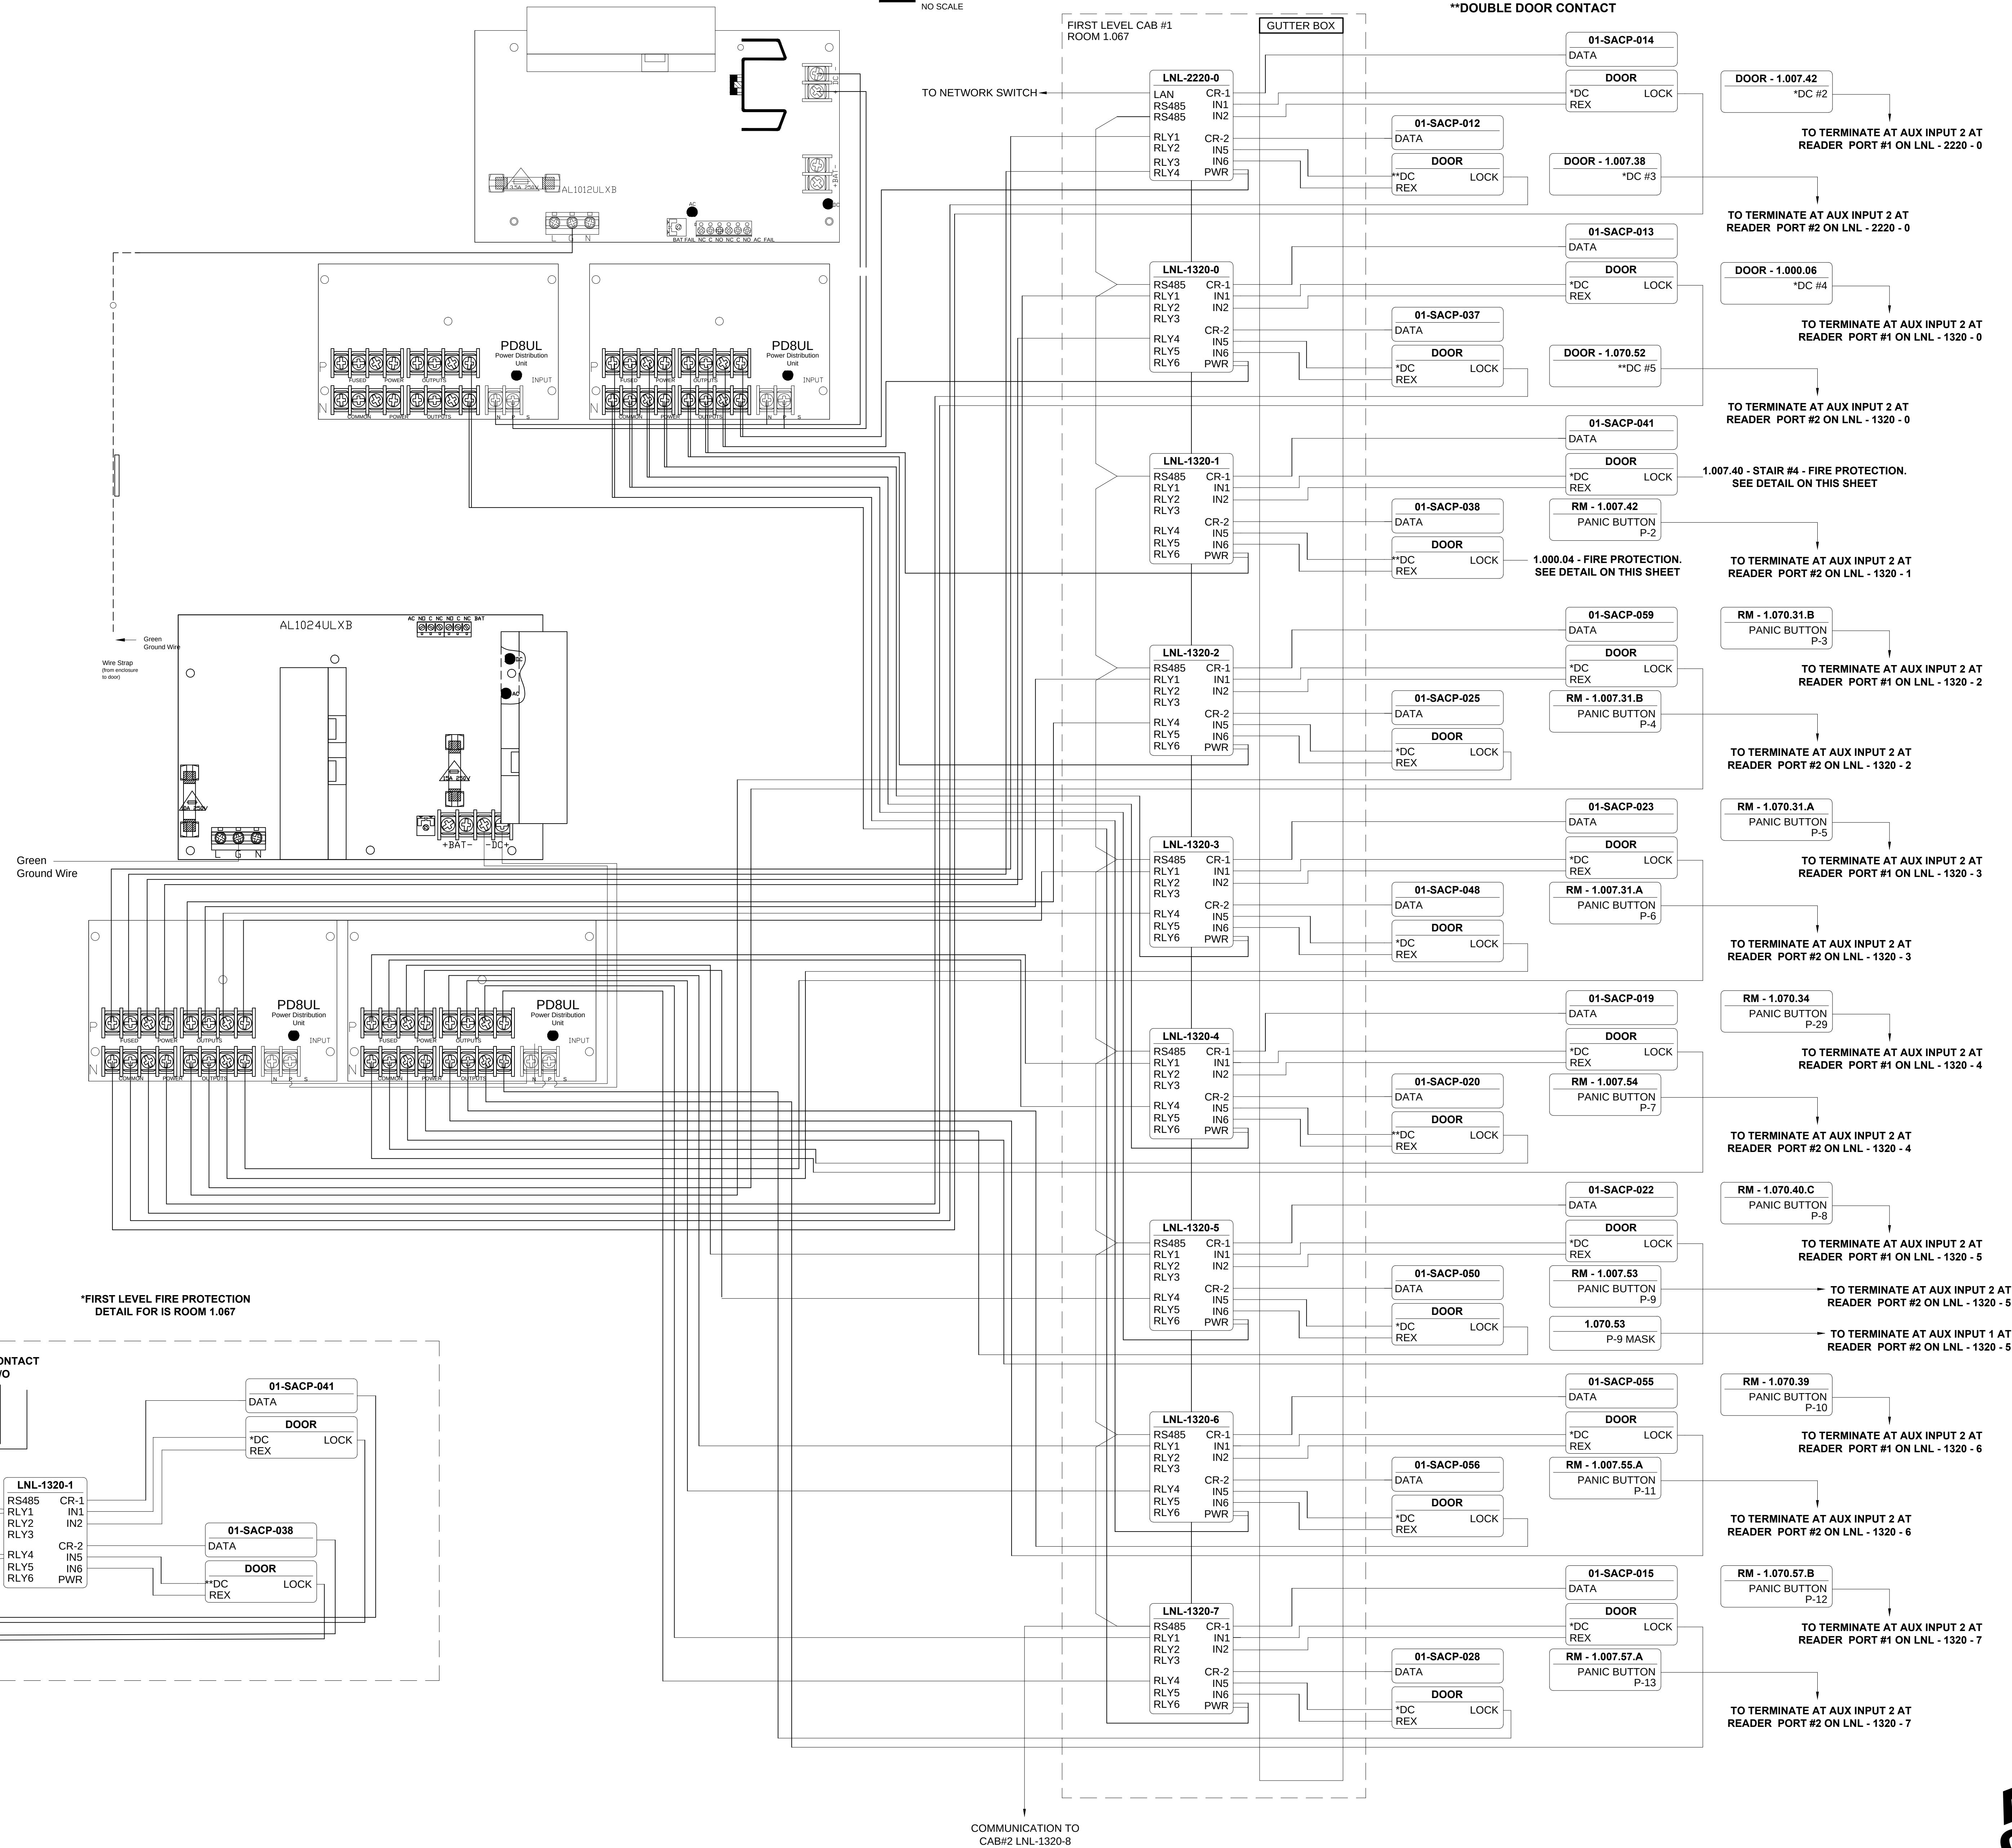

DRAWING PREPARED BY:



1511 E. ORANGETHORPE BLVD.
FULLERTON, CALIFORNIA 92831
714-525-4350 - o; 714-525-4386 - f
(c) Copyright 2012 KRATOS | HBE
All Rights Reserved.

MUST BE SIGNED BY HBE
TO AUTHENTICATE CONTENT(S).
ALL DETAILS CHECKED FOR ACCURACY.


SIGNATURE _____ DATE _____

HBE JOB # _____

CONFIDENTIAL

THE INFORMATION CONTAINED HEREIN MAY
NOT BE USED OR REPRODUCED IN ANY
MANNER WITHOUT WRITTEN PERMISSION OF
KRATOS | HBE.

KEY PLAN

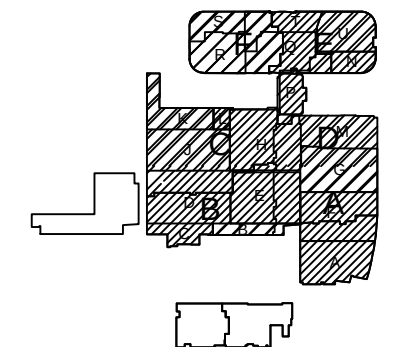

NO.	REV DESCRIPTION REV DATE	APPROVED BY
1.	AS BUILTS 08/15/2012	JOHN J. CHRISTIE

REV.	DESCRIPTION	APPROVED BY
------	-------------	-------------

CUSTOMER:




PROJECT:
CHOC CHILDREN'S
HOSPITAL
455 SOUTH MAIN ST.
ORANGE, CA 92668

DRAWING TITLE:
FIRST LEVEL ACCESS
CONTROL POINT TO POINT
DIAGRAM - RM 1.067

DRN BY	DATE DRN	CHK BY	DATE CHK
JOSH G.	08/08/2012	JJC	
SCALE:	NTS		
DWG NO.	SE7.02		

ASBUILTS
08/15/2012

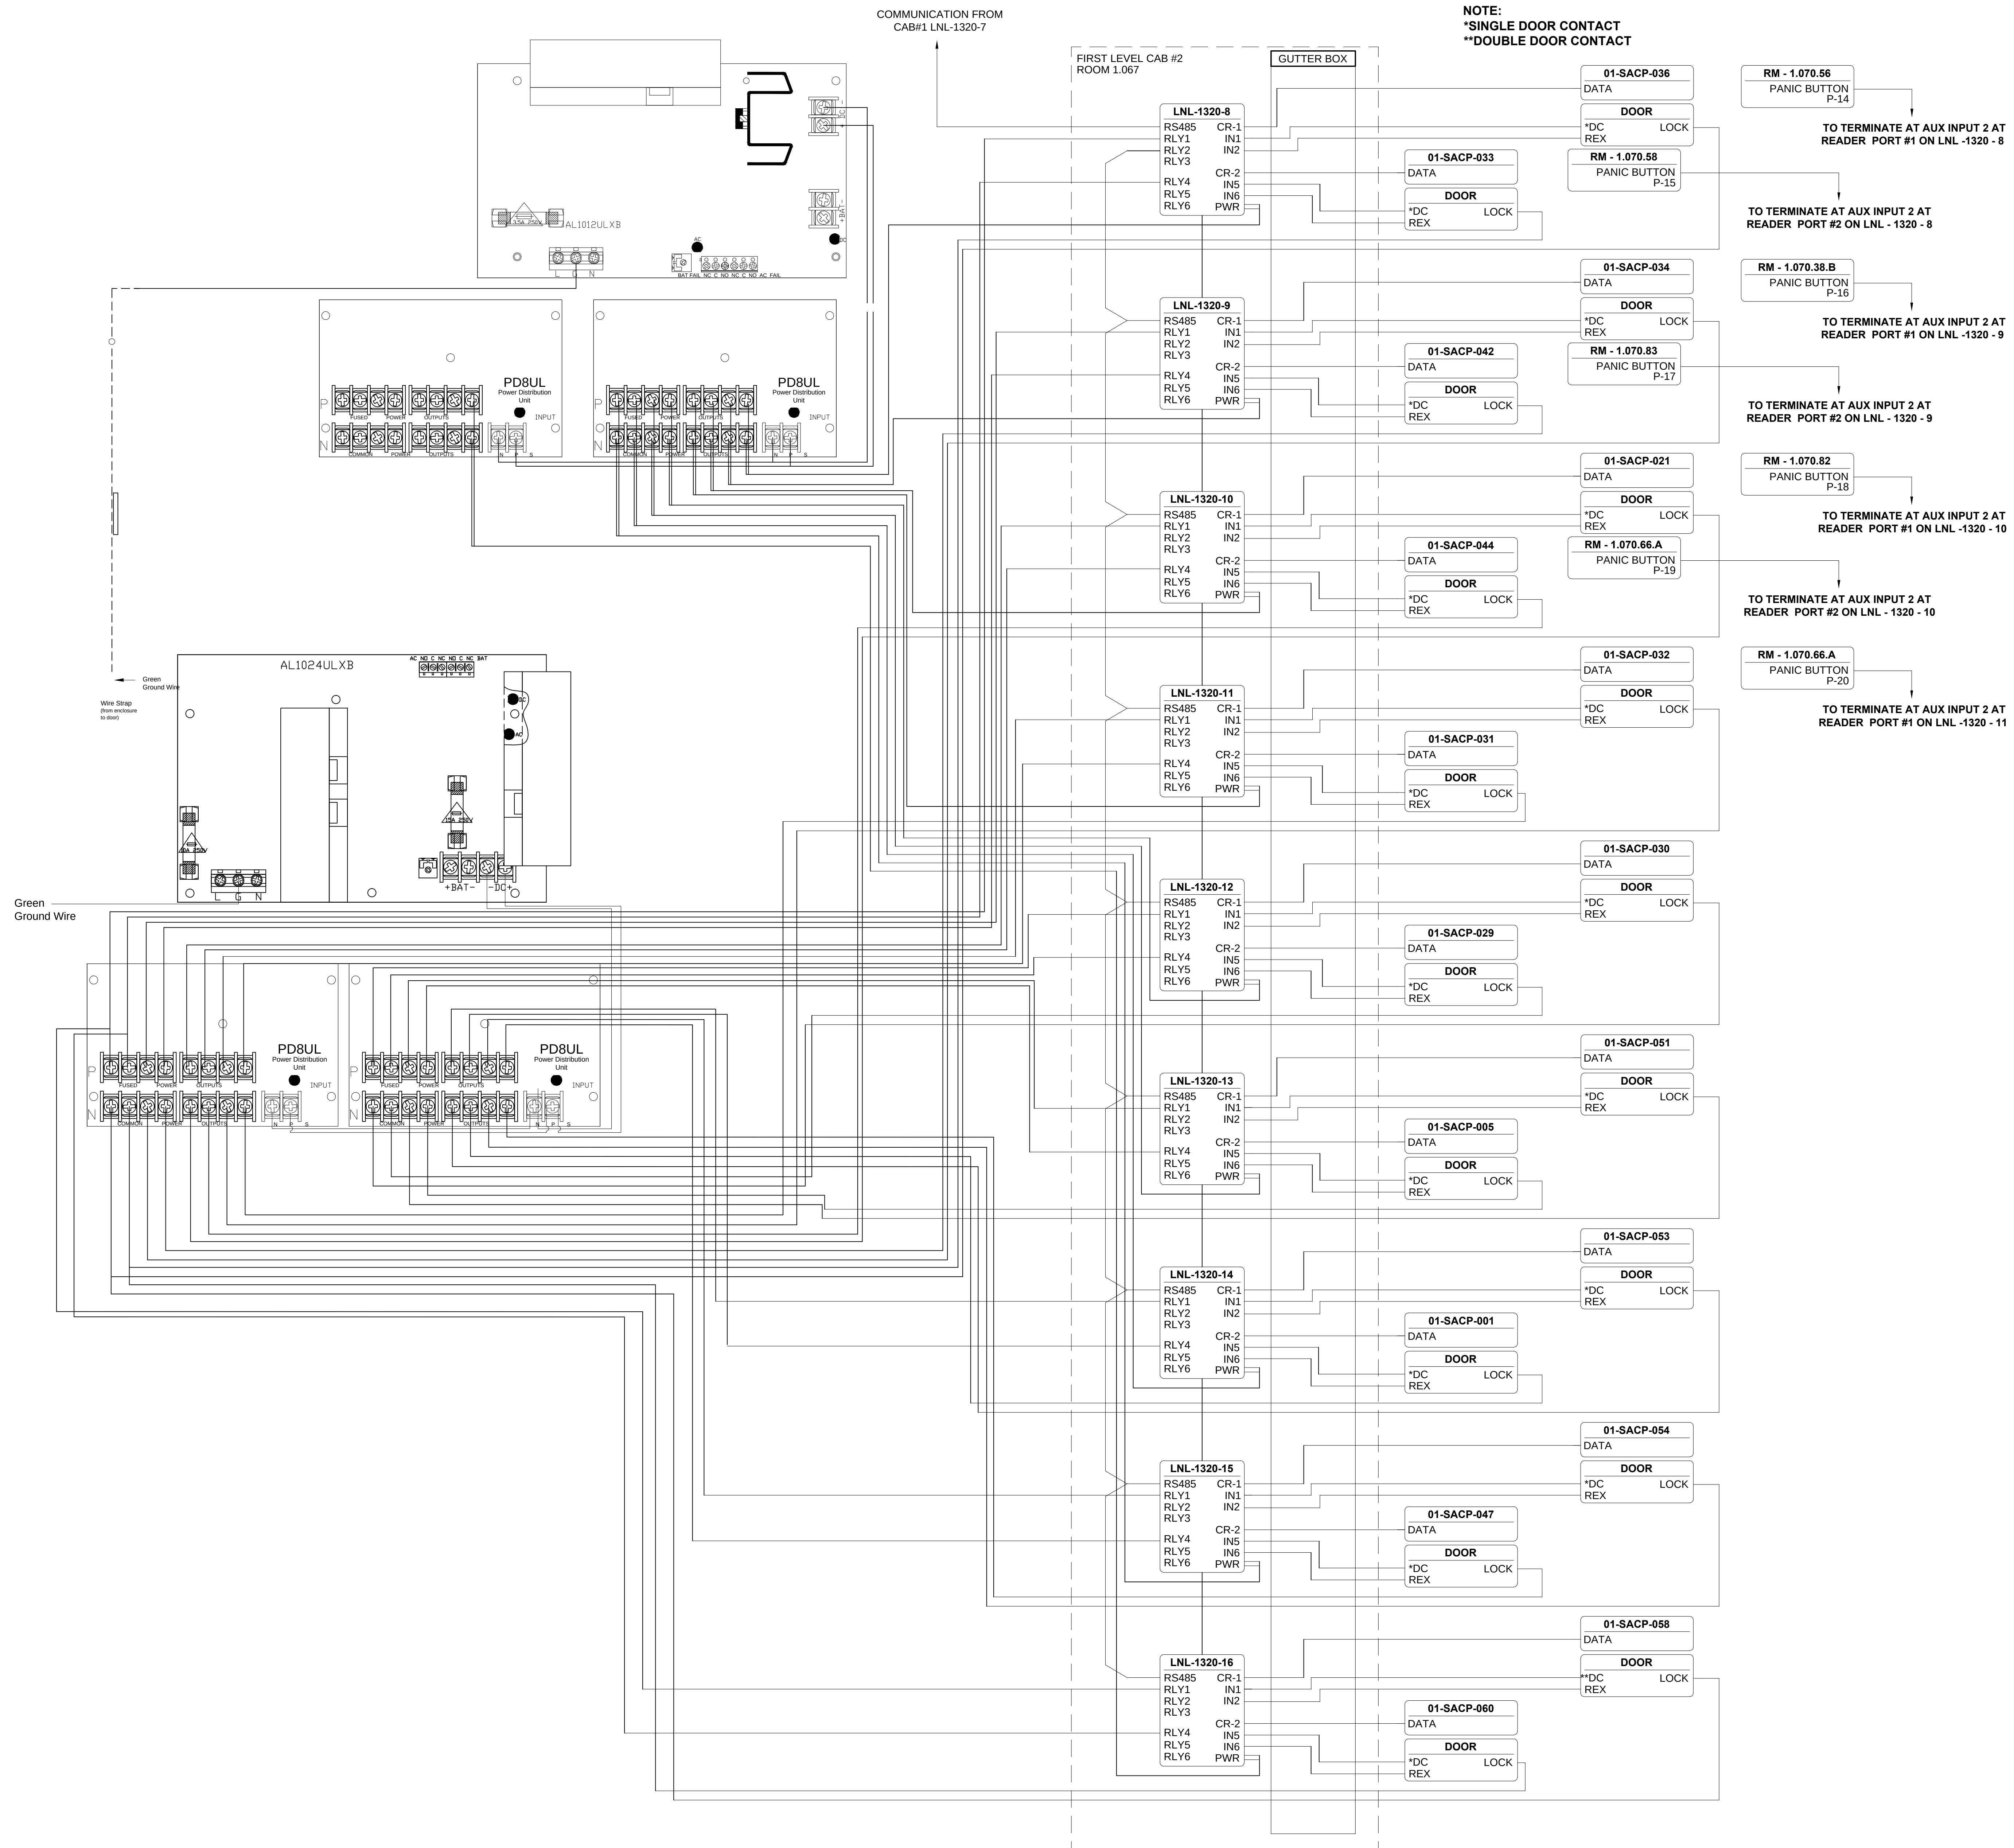

4 FIRST LEVEL ROOM 1.067 - ACCESS POINT TO POINT
NO SCALE

ASBUILTS
08/15/2012

DRAWING PREPARED BY:

KRATOS
HBE

1511 E. ORANGETHORPE BLVD.
FULLERTON, CALIFORNIA 92831
714-525-4350 - o; 714-525-4386 - f
(c) Copyright 2012 KRATOS | HBE
All Rights Reserved.

MUST BE SIGNED BY HBE
TO AUTHENTICATE CONTENT(S).
ALL DETAILS CHECKED FOR ACCURACY.

SIGNATURE _____ DATE _____

HBE JOB # _____

CONFIDENTIAL

THE INFORMATION CONTAINED HEREIN MAY
NOT BE USED OR REPRODUCED IN ANY
MANNER WITHOUT WRITTEN PERMISSION OF
KRATOS | HBE.

KEY PLAN

NO.	REV DESCRIPTION REV DATE	APPROVED BY
1.	AS BUILTS 08/15/2012	JOHN J. CHRISTIE

REV.	DESCRIPTION	APPROVED BY

CUSTOMER:

CHOC
Children's Hospital
of Orange County


PROJECT:

CHOC CHILDREN'S
HOSPITAL
455 SOUTH MAIN ST.
ORANGE, CA 92668

DRAWING TITLE:

FIRST LEVEL ACCESS
CONTROL POINT TO POINT
DIAGRAM - RM 1.067

DRN BY	DATE DRN	CHK BY	DATE CHK
JOSH G.	08/08/2012	JJC	
SCALE:		NTS	
DWG NO.	SE7.03		

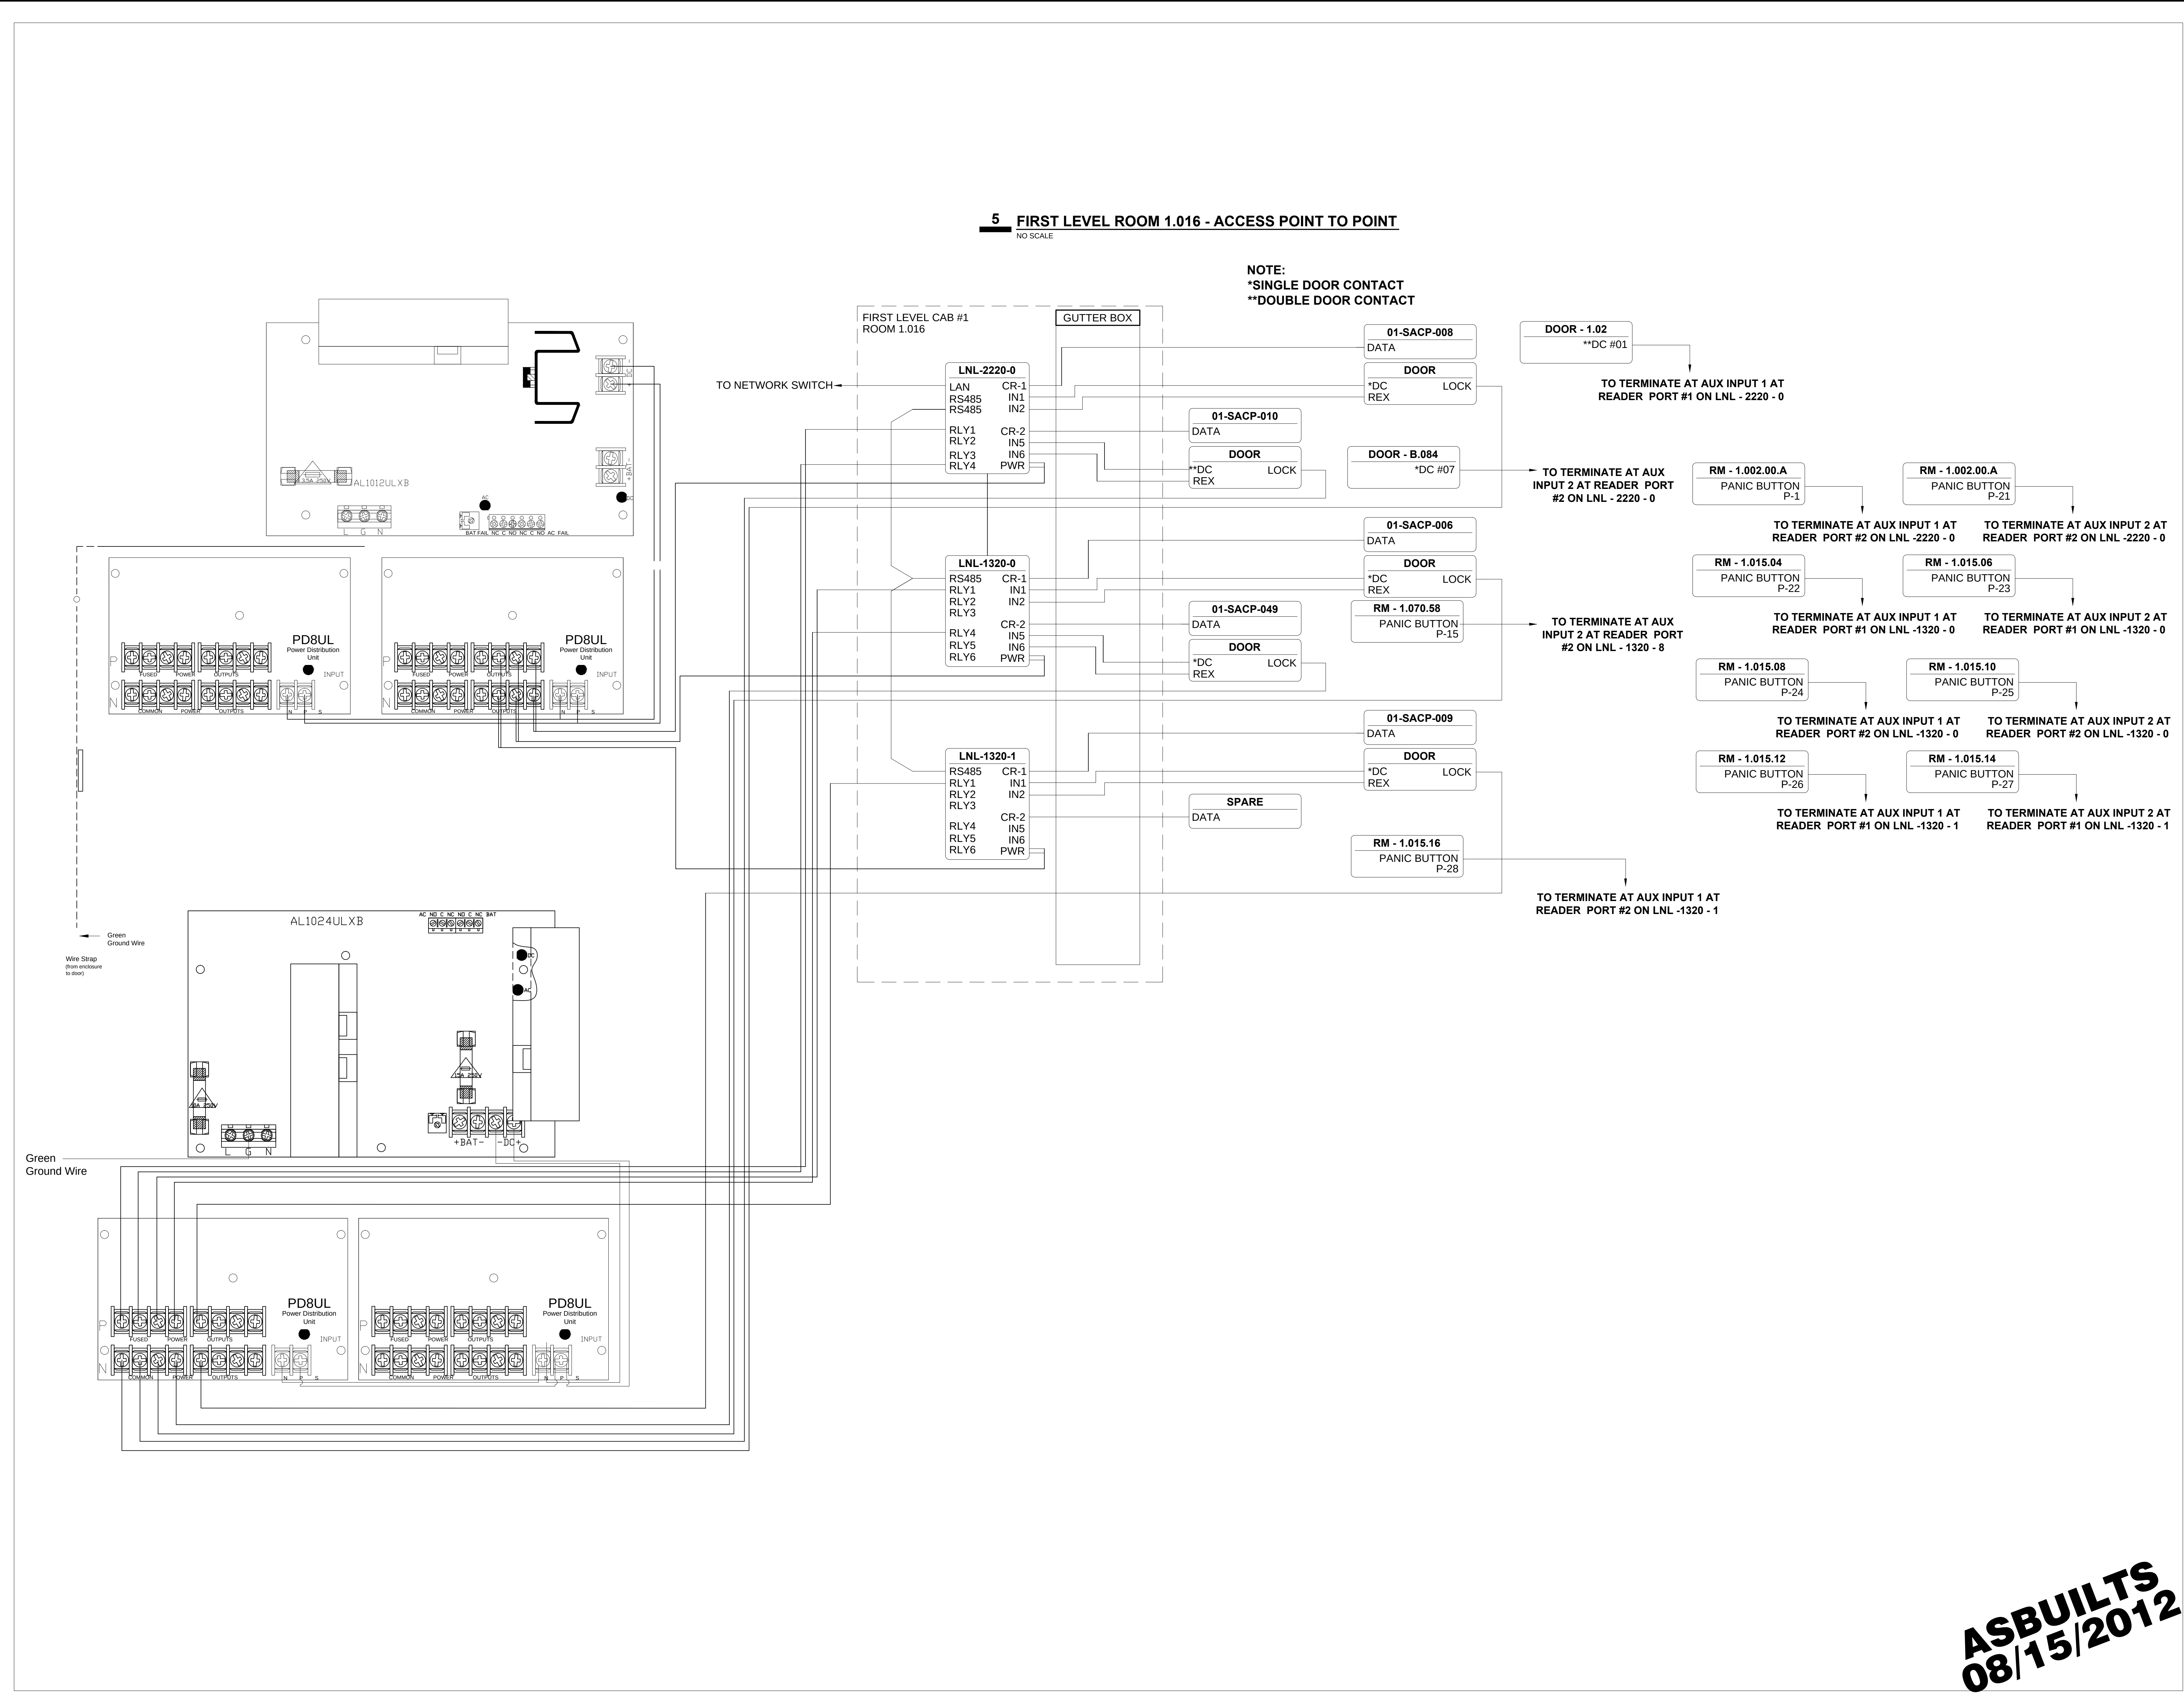

DRAWING PREPARED BY:



1511 E. ORANGETHORPE BLVD.
FULLERTON, CALIFORNIA 92831
714-525-4350 - o; 714-525-4386 - f
(c) Copyright 2012 KRATOS | HBE
All Rights Reserved.

MUST BE SIGNED BY HBE
TO AUTHENTICATE CONTENT(S).
ALL DETAILS CHECKED FOR ACCURACY.


SIGNATURE _____ DATE _____

HBE JOB #

CONFIDENTIAL

THE INFORMATION CONTAINED HEREIN MAY
NOT BE USED OR REPRODUCED IN ANY
MANNER WITHOUT WRITTEN PERMISSION OF
KRATOS | HBE.

KEY PLAN

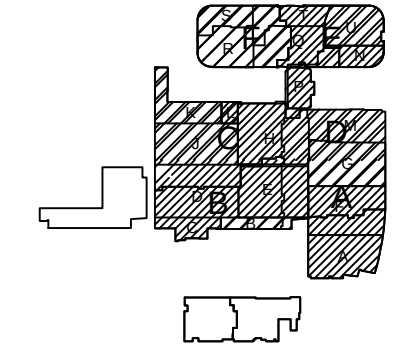

NO.	REV DESCRIPTION REV DATE	APPROVED BY
1.	AS BUILTS 08/15/2012	JOHN J. CHRISTIE

REV.	DESCRIPTION	APPROVED BY
------	-------------	-------------





PROJECT:
CHOC CHILDREN'S
HOSPITAL
455 SOUTH MAIN ST.
ORANGE, CA 92668

DRAWING TITLE:
FIRST LEVEL ACCESS
CONTROL POINT TO POINT
DIAGRAM-RM 1.016

DRN BY	DATE DRN	CHK BY	DATE CHK
JOSH G.	08/08/2012	JJC	
SCALE:	NTS		
DWG NO.	SE7.04		

6 SECOND LEVEL ROOM 2.020 - ACCESS POINT TO POINT
NO SCALE

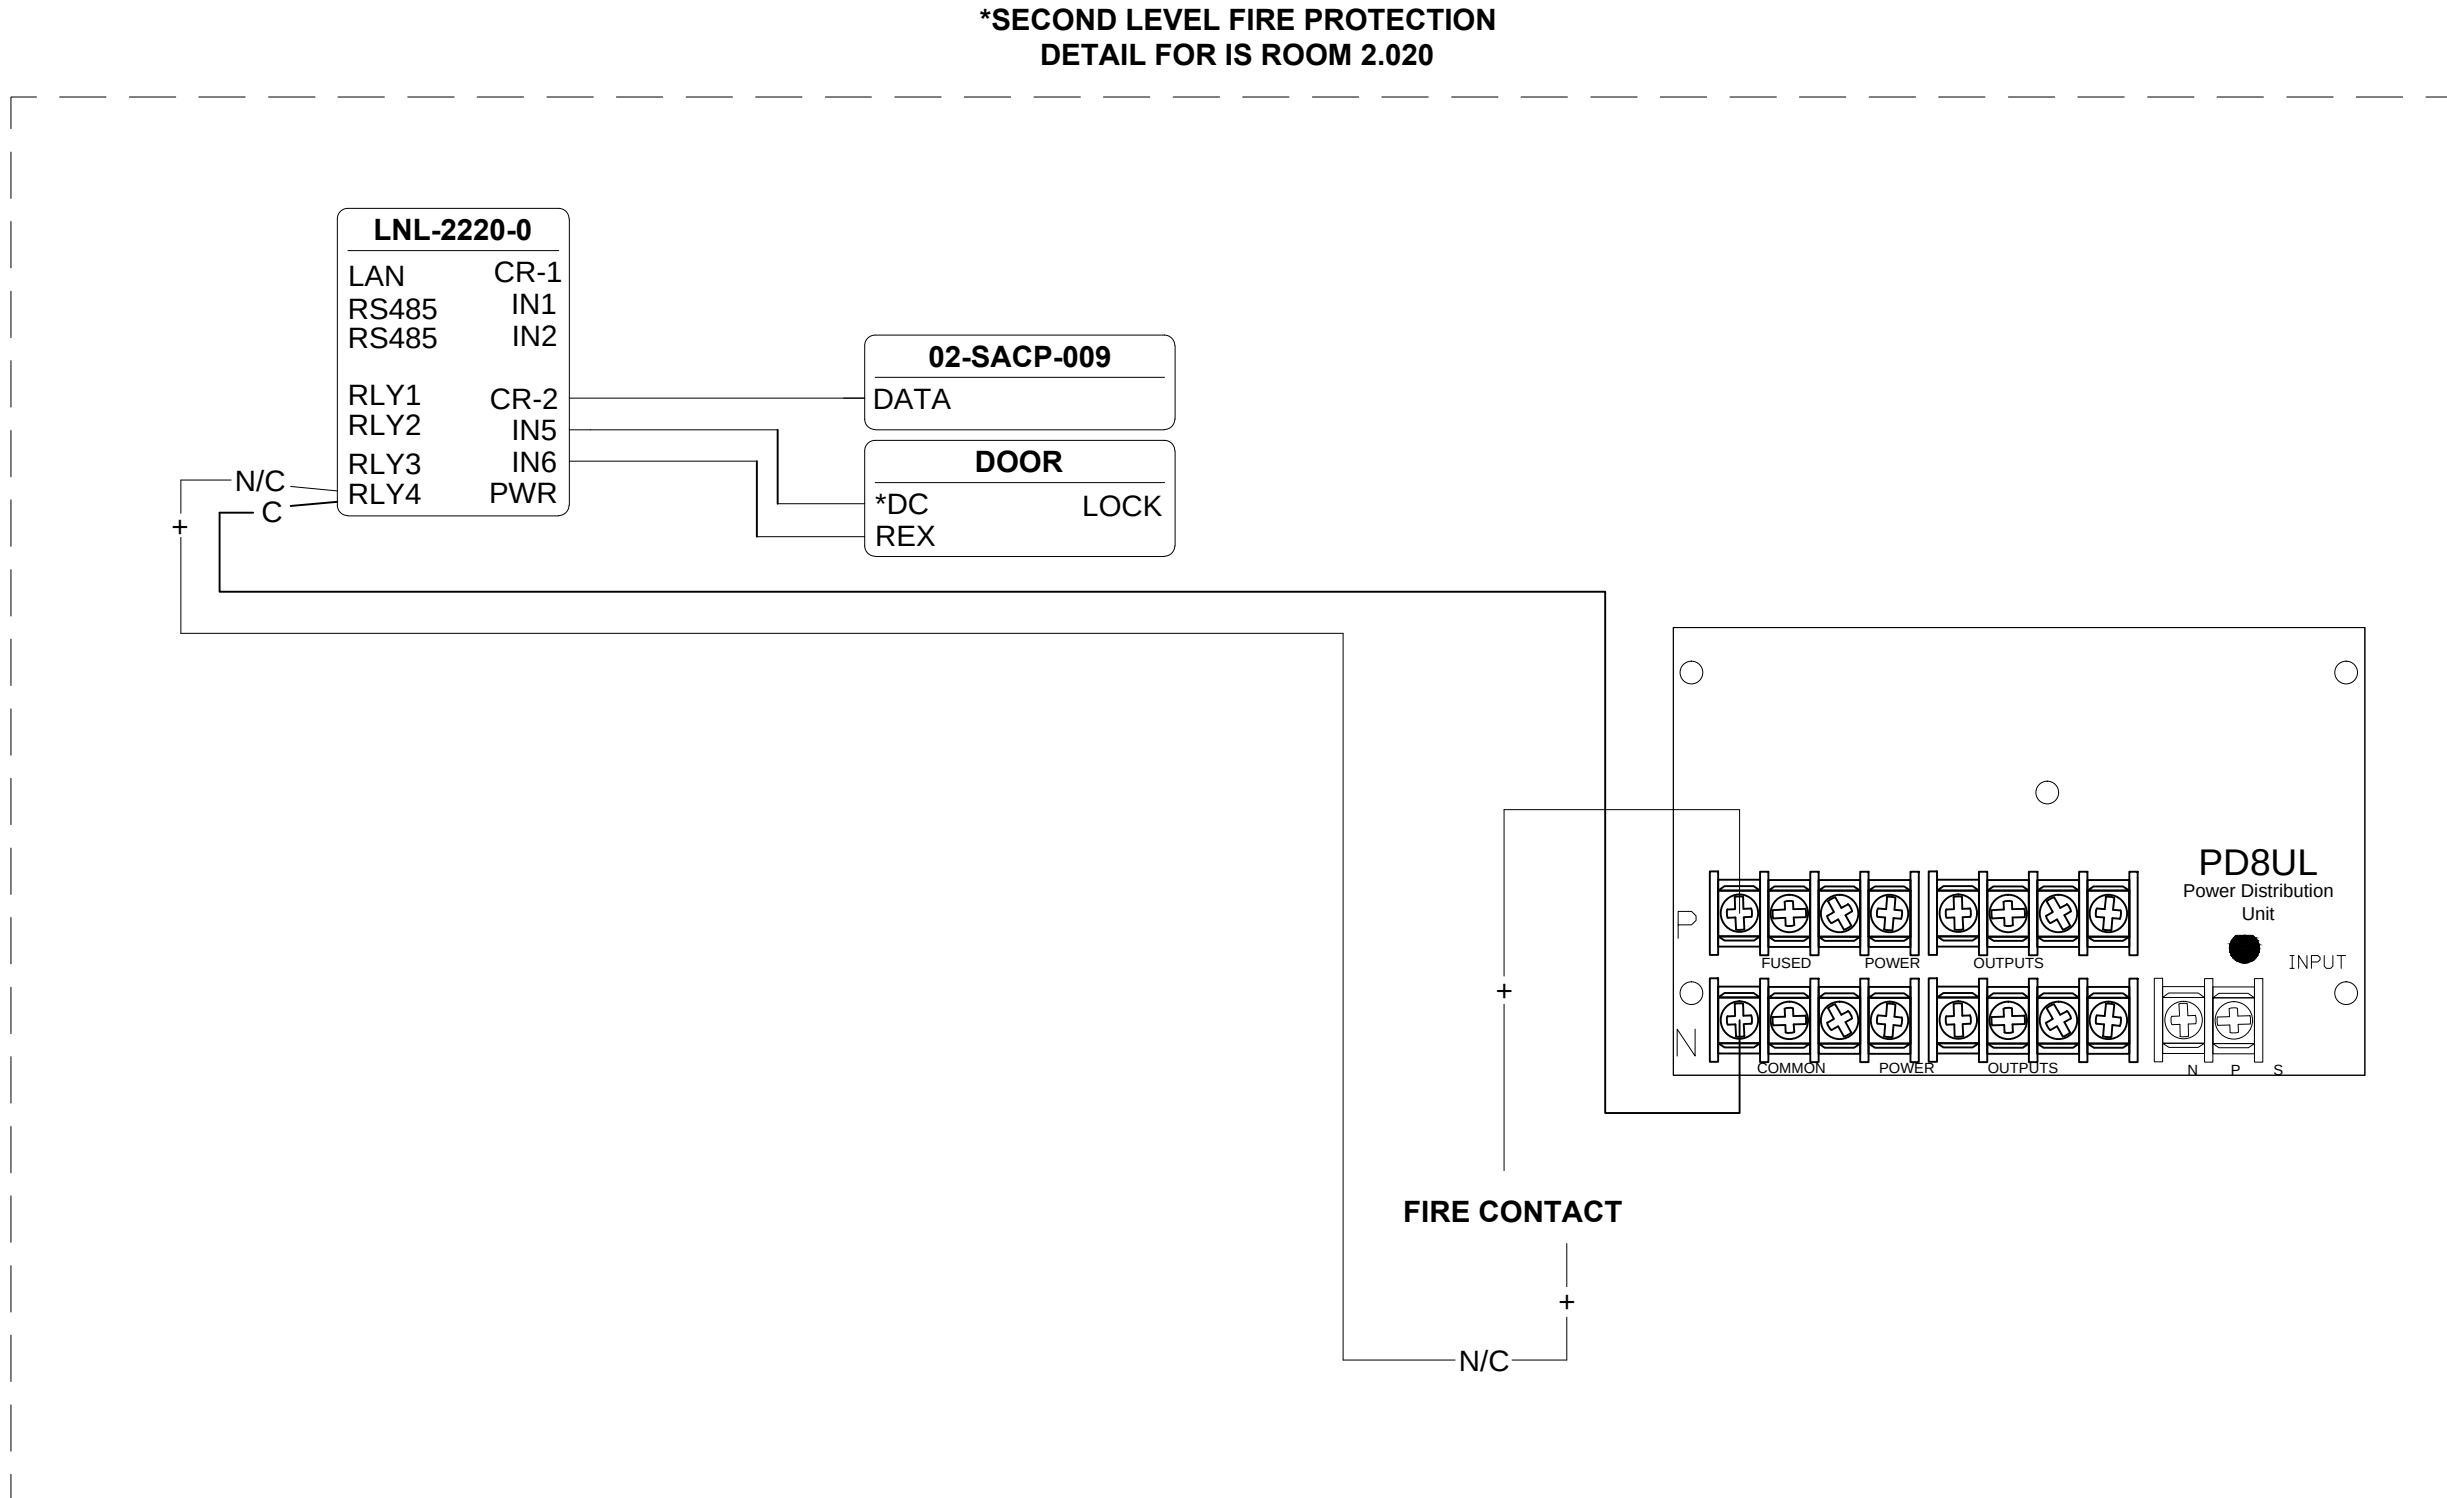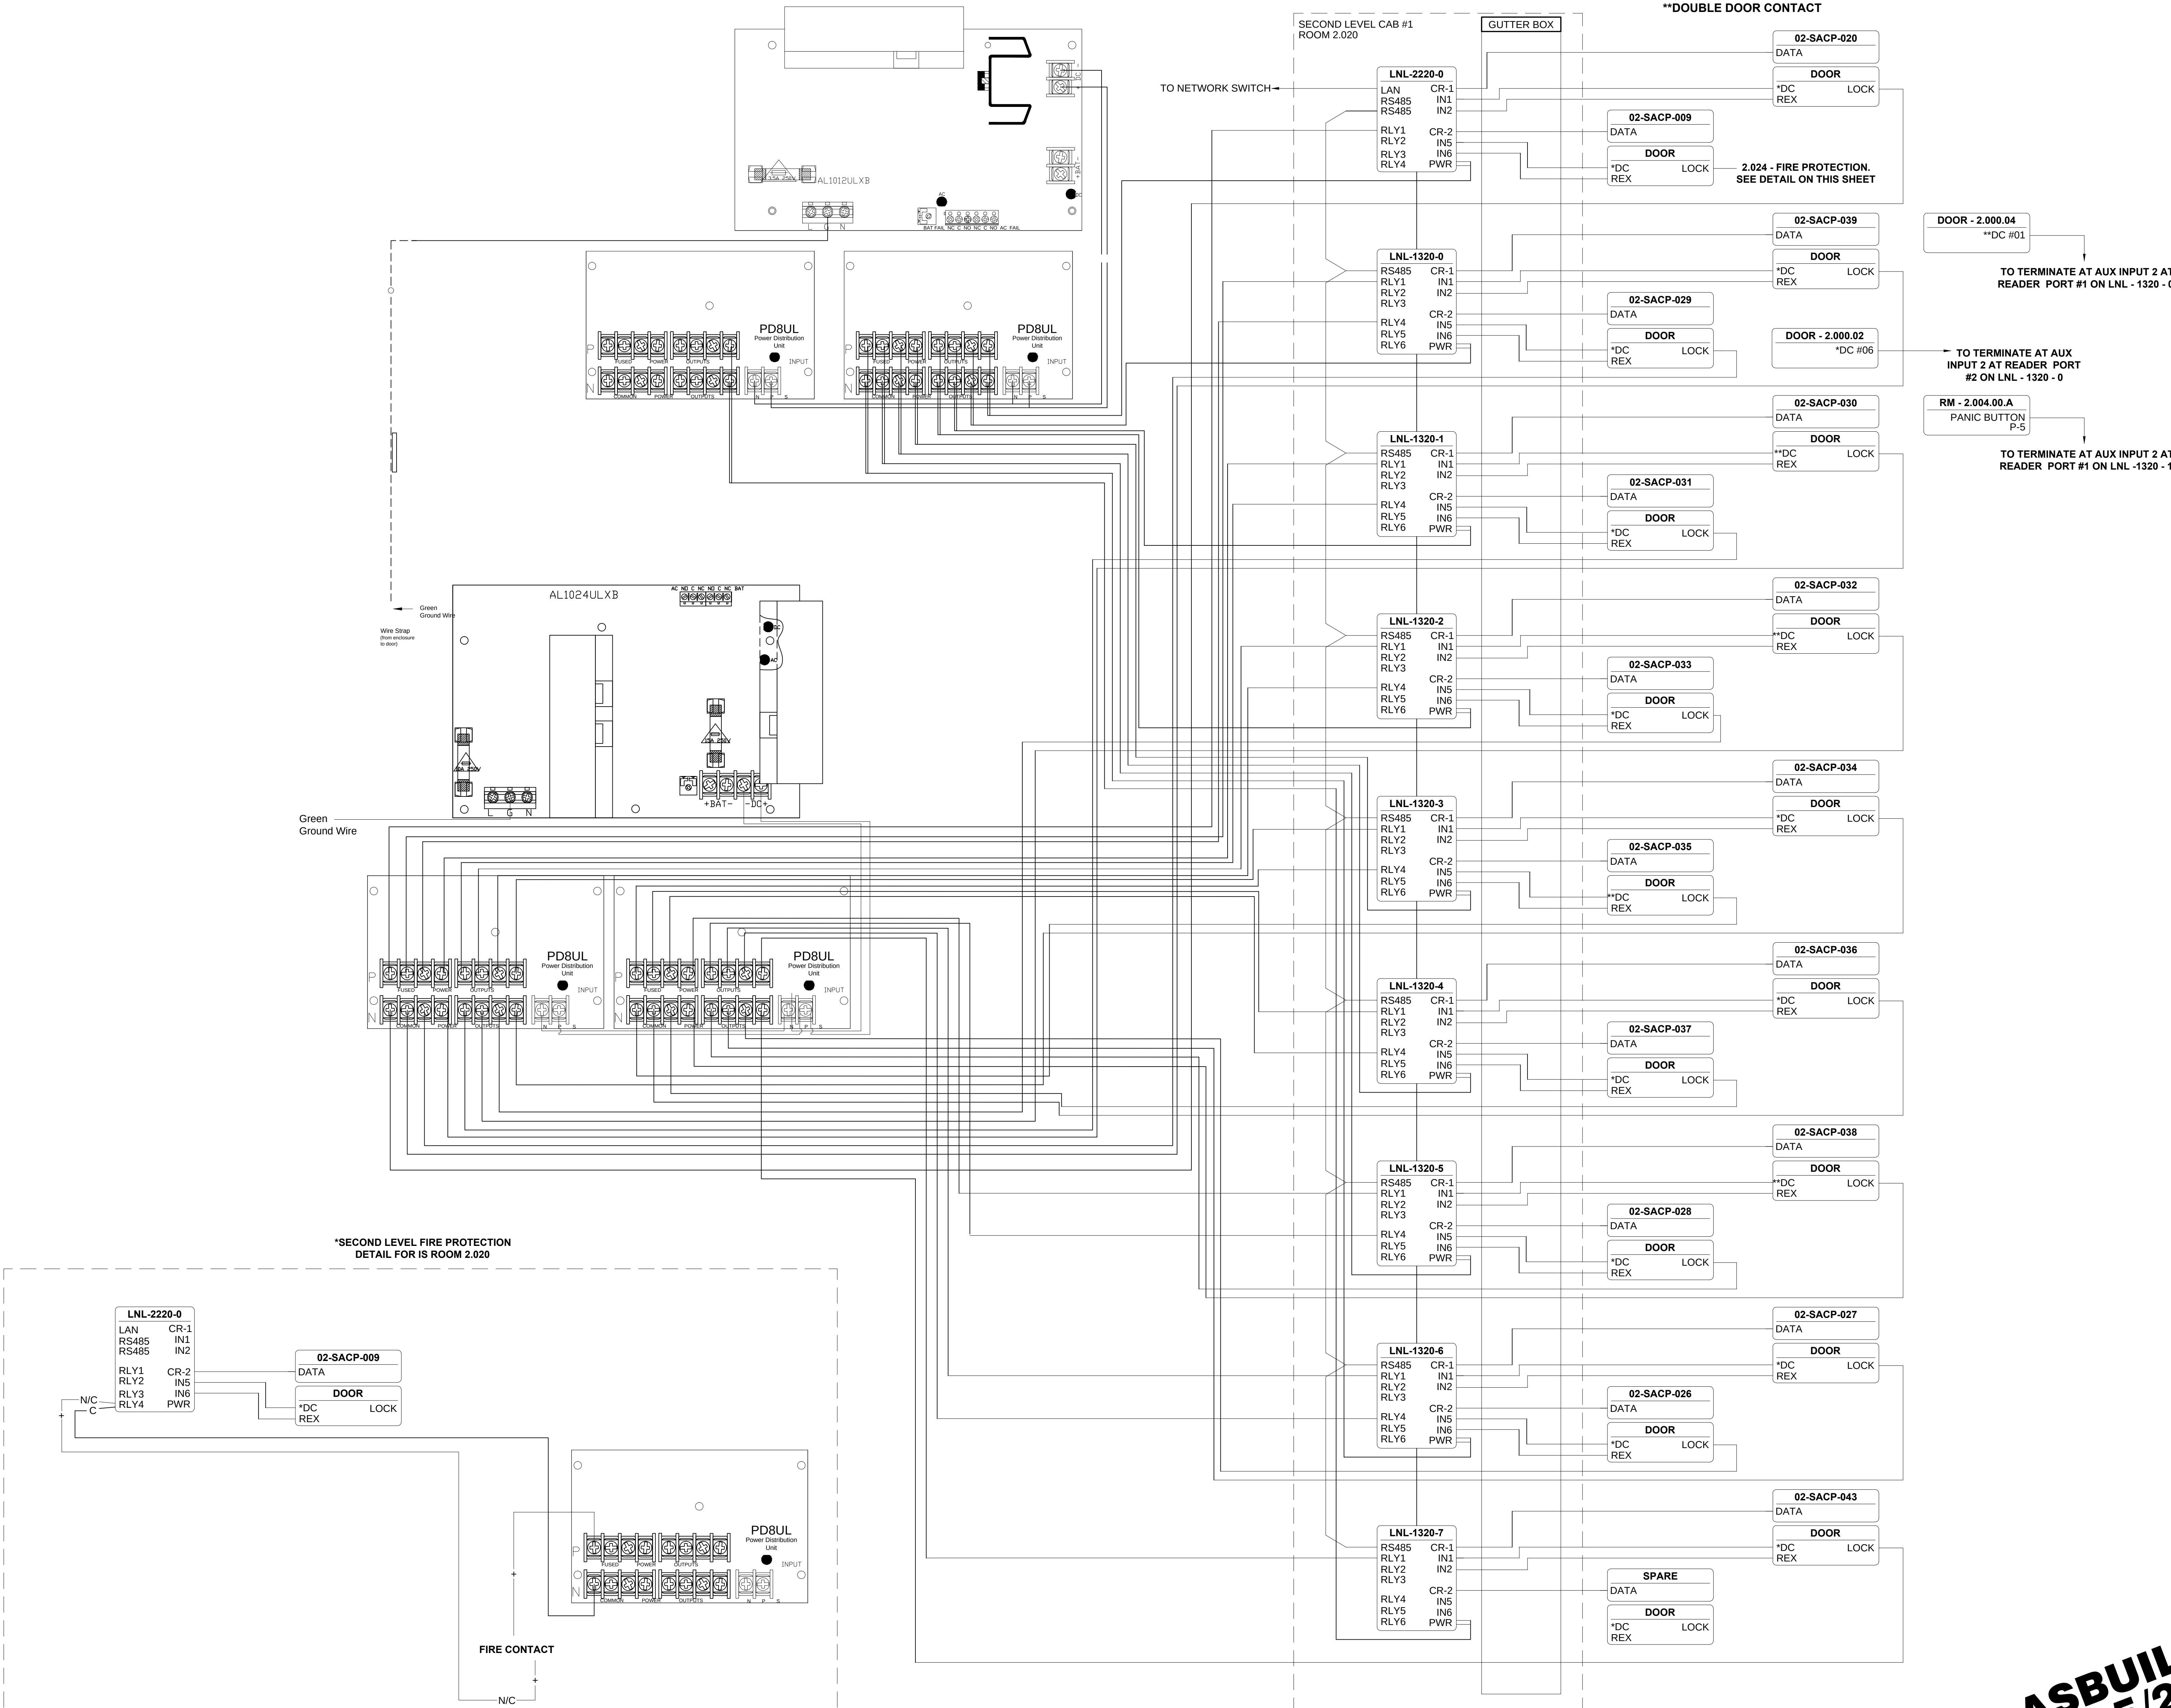

NOTE:
*SINGLE DOOR CONTACT
**DOUBLE DOOR CONTACT

02-SACP-020
DATA
DOOR
*DC REX LOCK

02-SACP-009
DATA
DOOR
*DC REX LOCK

2.024 - FIRE PROTECTION.
SEE DETAIL ON THIS SHEET

02-SACP-039
DATA
DOOR
*DC REX LOCK

DOOR - 2.000.04
**DC #01
TO TERMINATE AT AUX INPUT 2 AT
READER PORT #1 ON LNL - 1320 - 0

02-SACP-029
DATA
DOOR
*DC REX LOCK

DOOR - 2.000.02
*DC #06
TO TERMINATE AT AUX
INPUT 2 AT READER PORT
#2 ON LNL - 1320 - 0

RM - 2.004.00.A
PANIC BUTTON
P-5
TO TERMINATE AT AUX INPUT 2 AT
READER PORT #1 ON LNL - 1320 - 1

02-SACP-030
DATA
DOOR
*DC REX LOCK

02-SACP-031
DATA
DOOR
*DC REX LOCK

02-SACP-032
DATA
DOOR
*DC REX LOCK

02-SACP-033
DATA
DOOR
*DC REX LOCK

02-SACP-034
DATA
DOOR
*DC REX LOCK

02-SACP-035
DATA
DOOR
*DC REX LOCK

02-SACP-036
DATA
DOOR
*DC REX LOCK

02-SACP-037
DATA
DOOR
*DC REX LOCK

02-SACP-038
DATA
DOOR
*DC REX LOCK

02-SACP-028
DATA
DOOR
*DC REX LOCK

02-SACP-027
DATA
DOOR
*DC REX LOCK

02-SACP-026
DATA
DOOR
*DC REX LOCK

02-SACP-043
DATA
DOOR
*DC REX LOCK

SPARE
DATA
DOOR
*DC REX LOCK

DRAWING PREPARED BY:

KRATOS
HBE

1511 E. ORANGETHORPE BLVD.
FULLERTON, CALIFORNIA 92831
714-525-4350 - o; 714-525-4386 - f
(c) Copyright 2012 KRATOS | HBE
All Rights Reserved.

MUST BE SIGNED BY HBE
TO AUTHENTICATE CONTENT(S).
ALL DETAILS CHECKED FOR ACCURACY.


SIGNATURE _____ DATE _____

HBE JOB # _____

CONFIDENTIAL

THE INFORMATION CONTAINED HEREIN MAY
NOT BE USED OR REPRODUCED IN ANY
MANNER WITHOUT WRITTEN PERMISSION OF
KRATOS | HBE.

KEY PLAN

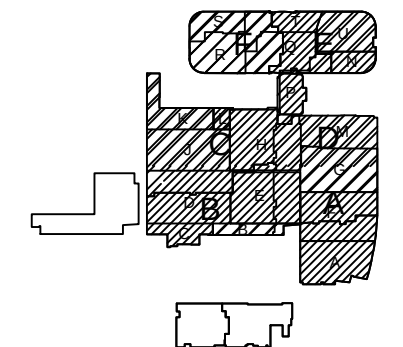

NO.	REV DESCRIPTION REV DATE	APPROVED BY
1.	AS BUILTS 08/15/2012	JOHN J. CHRISTIE

REV. DESCRIPTION APPROVED BY

CUSTOMER:

CHOC
Children's Hospital
of Orange County

PROJECT:
CHOC CHILDREN'S
HOSPITAL
455 SOUTH MAIN ST.
ORANGE, CA 92668


DRAWING TITLE:
SECOND LEVEL ACCESS
CONTROL POINT TO POINT
DIAGRAM - RM 2.020

DRN BY	DATE DRN	CHK BY	DATE CHK
JOSH G.	08/08/2012	JJC	
SCALE:	NTS		
DWG NO.	SE7.05		

ASBUILTS
08/15/2012

7 SECOND LEVEL ROOM 2.066 - ACCESS POINT TO POINT
NO SCALE

NOTE:
*SINGLE DOOR CONTACT
**DOUBLE DOOR CONTACT

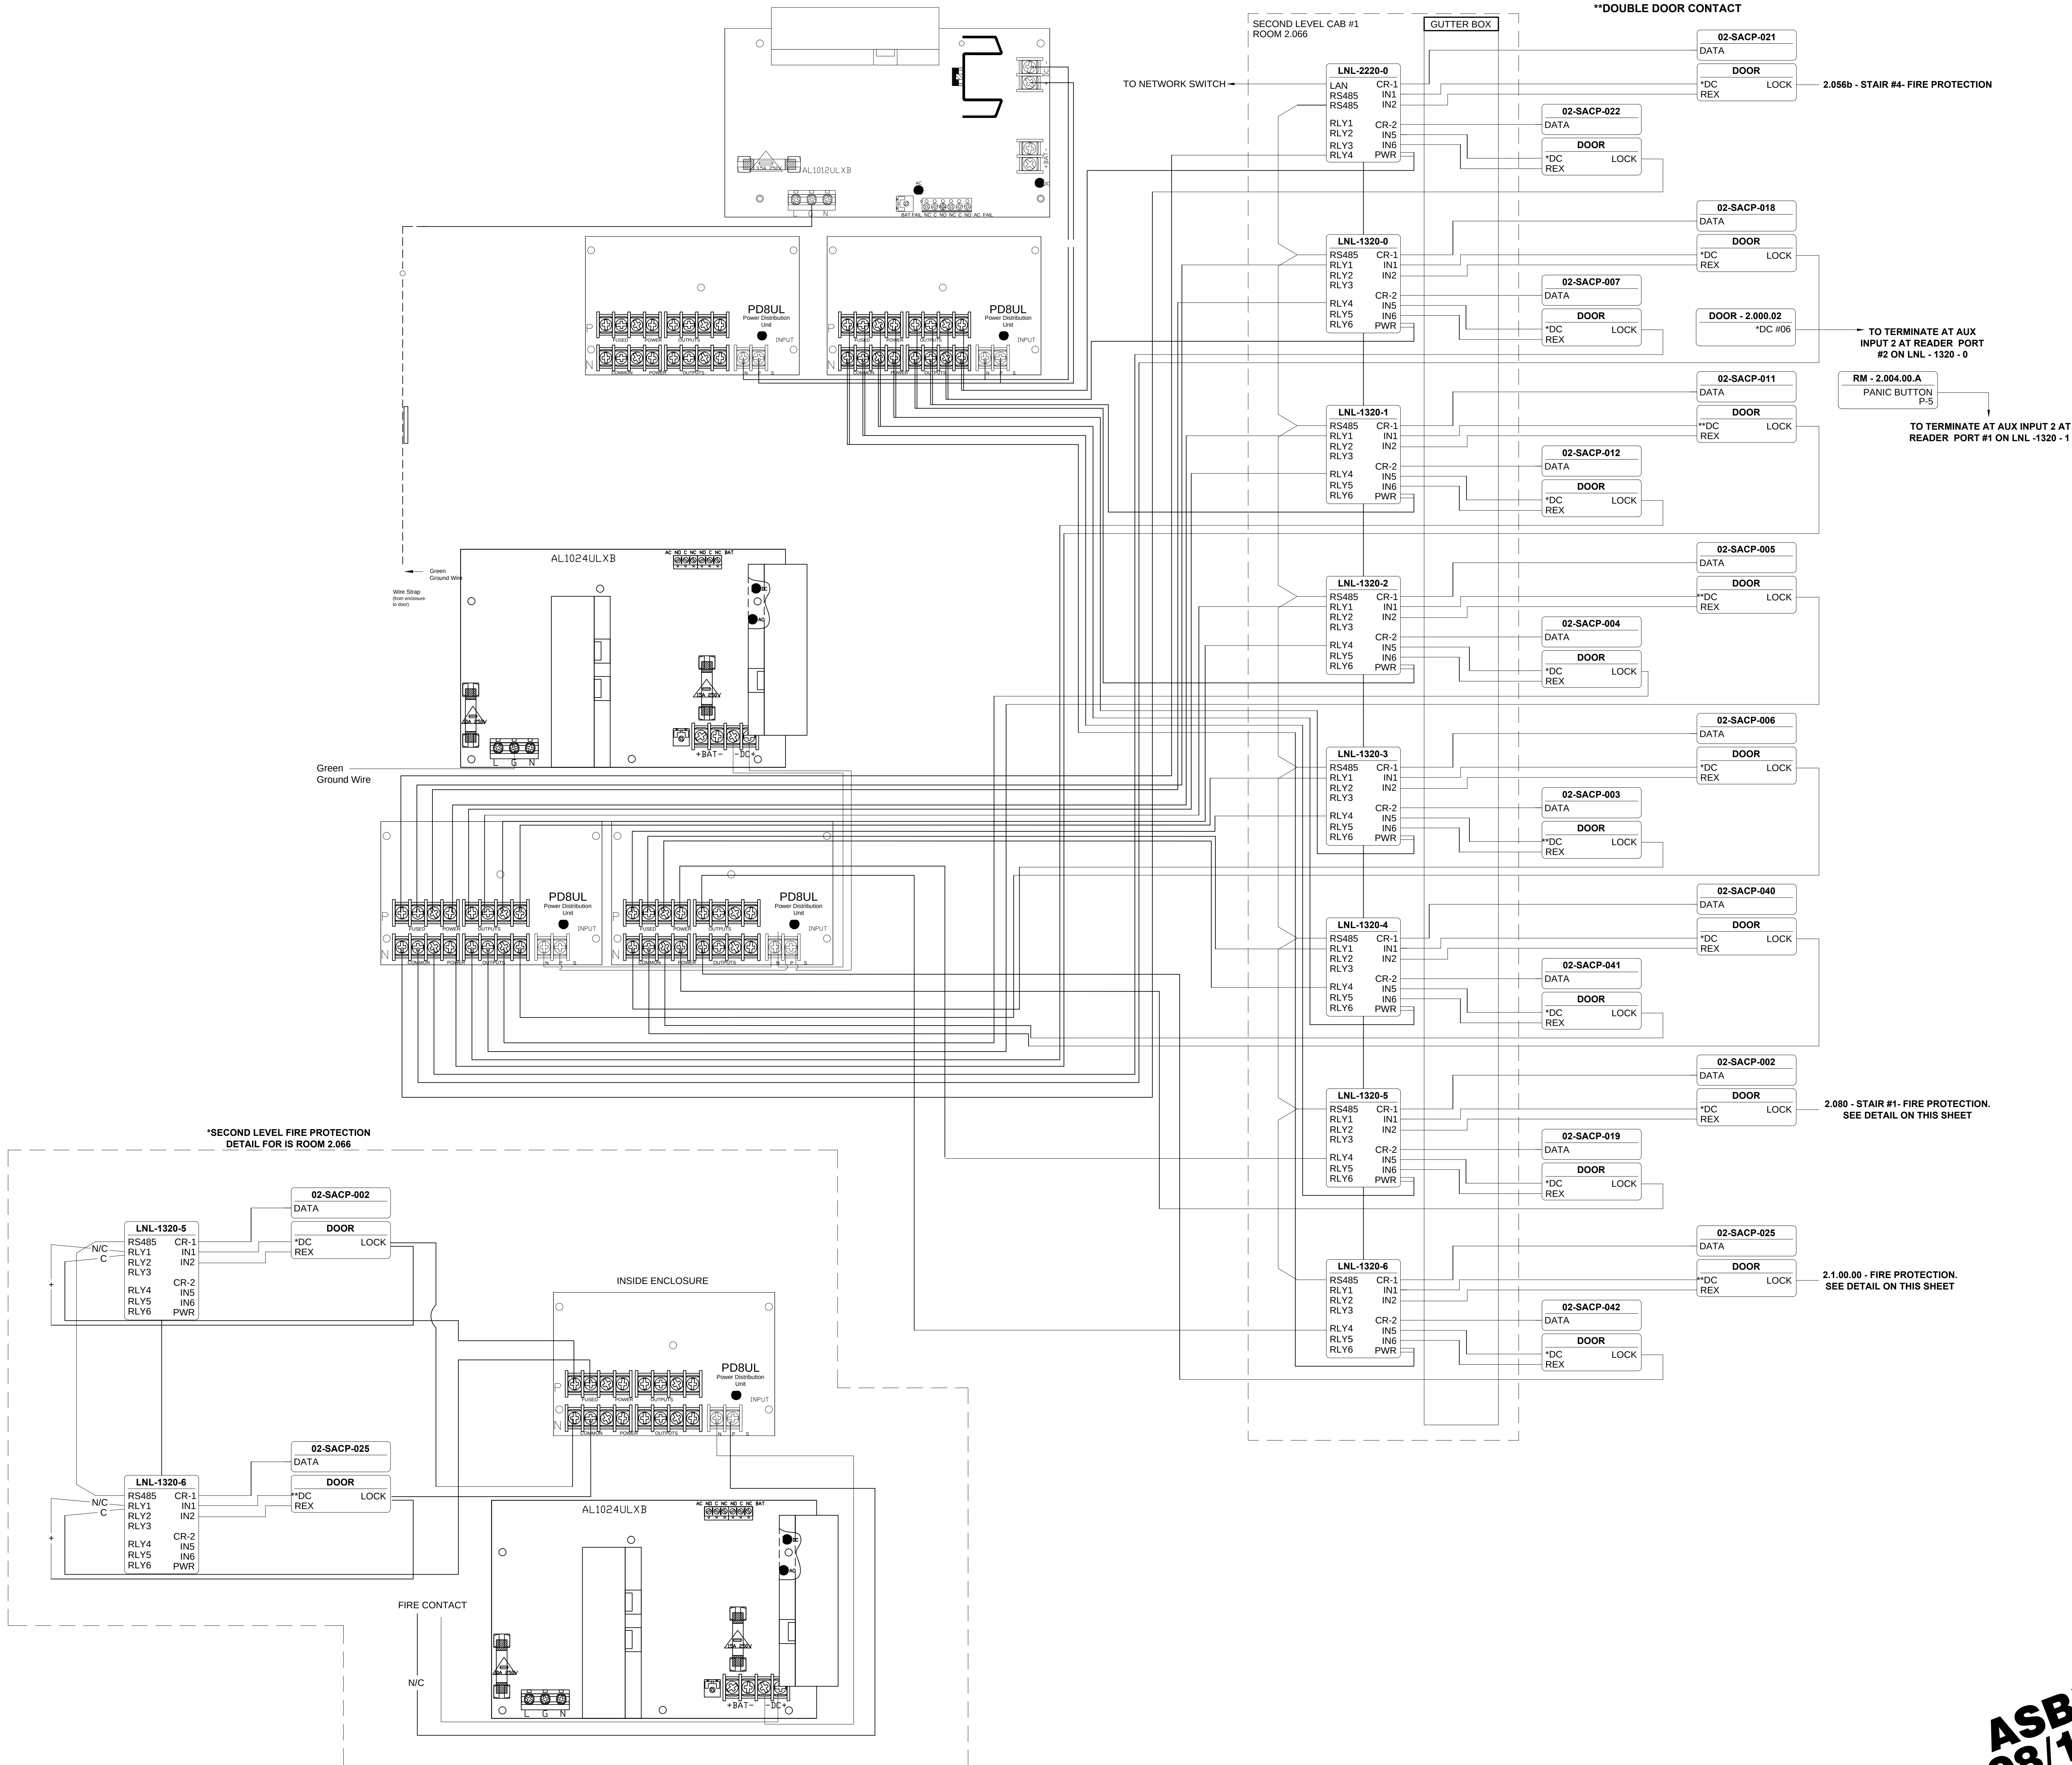

DRAWING PREPARED BY:



1511 E. ORANGETHORPE BLVD.
FULLERTON, CALIFORNIA 92831
714-525-4350 - o; 714-525-4386 - f
(c) Copyright 2012 KRATOS | HBE
All Rights Reserved.

MUST BE SIGNED BY HBE
TO AUTHENTICATE CONTENT(S).
ALL DETAILS CHECKED FOR ACCURACY.


SIGNATURE _____ DATE _____

HBE JOB #

CONFIDENTIAL

THE INFORMATION CONTAINED HEREIN MAY
NOT BE USED OR REPRODUCED IN ANY
MANNER WITHOUT WRITTEN PERMISSION OF
KRATOS | HBE.

KEY PLAN

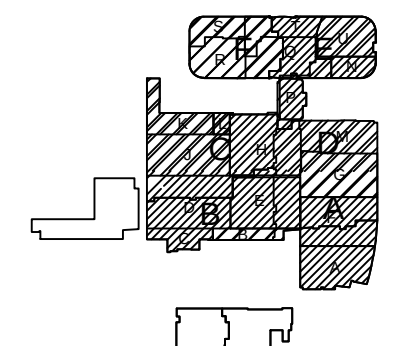

NO.	REV DESCRIPTION REV DATE	APPROVED BY
1.	AS BUILTS 08/15/2012	JOHN J. CHRISTIE

REV. DESCRIPTION APPROVED BY

CUSTOMER:



PROJECT:
CHOC CHILDREN'S
HOSPITAL
455 SOUTH MAIN ST.
ORANGE, CA 92668

DRAWING TITLE:
SECOND LEVEL ACCESS
CONTROL POINT TO POINT
DIAGRAM - RM 2.066

DRN BY	DATE DRN	CHK BY	DATE CHK
JOSH G.	08/08/2012	JJC	
SCALE:		NTS	
DWG NO.		SE7.06	

ASBUILTS
08/15/2012


NO SCALE



**MUST BE SIGNED BY HBE
TO AUTHENTICATE CONTENT(S).
ALL DETAILS CHECKED FOR ACCURACY.**

HBE JOB #

THE INFORMATION CONTAINED HEREIN MAY NOT BE USED OR REPRODUCED IN ANY MANNER WITHOUT WRITTEN PERMISSION OF KRATOS | HBE.

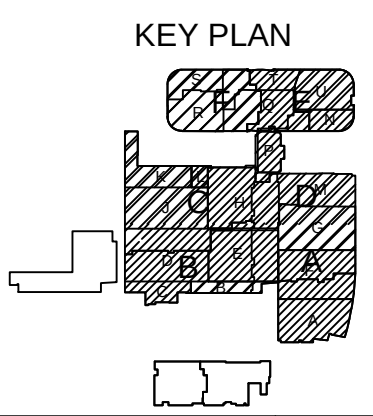

CUSTOMER:

 **CHOC**SM
Children's Hospital
of Orange County

DRAWING TITLE:

THIRD LEVEL ACCESS
CONTROL POINT TO POINT
DIAGRAM -RM 3.022

DRN BY	DATE DRN	CHK BY	DATE CHK
JOSH G.	08/08/2012	JJC	
SCALE:	NTS		
DWG NO.	SE7.07		

3.026 - STAIR #3- FIRE PROTECTION.
SEE DETAIL ON THIS SHEET

The diagram illustrates two identical components, labeled **03-SACP-043** and **03-SACP-042**. Each component is represented by a rectangular box divided into three sections:

- Top Section:** Labeled **DATA**, with an input line from the left.
- Middle Section:** Labeled **DOOR**, with an input line from the left.
- Bottom Section:** Labeled ***DC REX LOCK**, with an output line to the right.

Connections between the components are shown as follows:

- A line connects the **DATA** output of **03-SACP-043** to the **DATA** input of **03-SACP-042**.
- A line connects the **DOOR** output of **03-SACP-043** to the **DOOR** input of **03-SACP-042**.
- A line connects the ***DC REX LOCK** output of **03-SACP-042** to the ***DC REX LOCK** output of **03-SACP-043**.

Diagram illustrating data flow between two blocks:

- Block 03-SACP-037:**
 - DATA
 - DOOR
 - **DC REX LOCK
- Block 03-SACP-044:**
 - DATA
 - DOOR
 - *DC REX LOCK

Connections:

- A line connects the DATA field of 03-SACP-037 to the DATA field of 03-SACP-044.
- A line connects the DOOR field of 03-SACP-037 to the DOOR field of 03-SACP-044.

03-SACP-008
DATA
DOOR
*DC LOCK
REX

03-SACP-001
DATA
DOOR
*DC LOCK
REX

3.044 - STAIR #1- FIRE PROTECTION.
SEE DETAIL ON THIS SHEET

The diagram illustrates two data paths. The top path shows a 'DATA' block connected to a 'DOOR' block, which is then connected to a 'LOCK' block. The bottom path shows a 'DATA' block connected to a 'DOOR' block, which is then connected to a 'LOCK' block. The 'DOOR' block in the top path is labeled '03-SACP-051' and the 'DOOR' block in the bottom path is labeled '03-SACP-052'.

The diagram illustrates two door units, 03-SACP-053 and 03-SACP-054, connected to a central control unit. Unit 053 has a DATA line and a DOOR line. Unit 054 has a DATA line, a DOOR line, and a *DC REX LOCK line.

```

graph LR
    CU[Central Control Unit] --- D053[03-SACP-053]
    CU --- D054[03-SACP-054]
    D053 --- DATA053[DATA]
    D053 --- DOOR053[DOOR]
    D054 --- DATA054[DATA]
    D054 --- DOOR054[DOOR]
    D054 --- DC054[*DC REX LOCK]
  
```

The diagram illustrates a 12V power distribution system. A main horizontal line represents the 12V supply. Two door units are connected to this line. Each unit consists of a 'DATA' block and a 'DOOR' block. The 'DOOR' block is further divided into 'DC' and 'REX' sections. A 'LOCK' label is positioned to the right of the 'REX' section of each door unit. The 'DATA' block is connected to the main line, and the 'DOOR' block is connected to the 'DATA' block. The 'LOCK' label is connected to the 'REX' section of the 'DOOR' block. The 'DOOR' block is also connected to the main line. The 'LOCK' label is connected to the 'REX' section of the 'DOOR' block. The 'DOOR' block is also connected to the main line. The 'LOCK' label is connected to the 'REX' section of the 'DOOR' block.

03-SACP-059
DATA

DOOR
**DC REX LOCK

12V

03-SACP-041
DATA

DOOR
**DC REX LOCK

Diagram illustrating two data paths between two components:


- Top Path (03-SACP-063):**
 - DATA
 - DOOR
- Bottom Path (03-SACP-062):**
 - DATA
 - DOOR

The DOOR block in the top path is connected to the DOOR block in the bottom path via a line labeled ***DC REX** and **LOCK**.

ASBUILTS
08/15/2012

9 **THIRD**
NO SCALE

NOTE:
***SINGLE DOOR CONTACT**
****DOUBLE DOOR CONTACT**

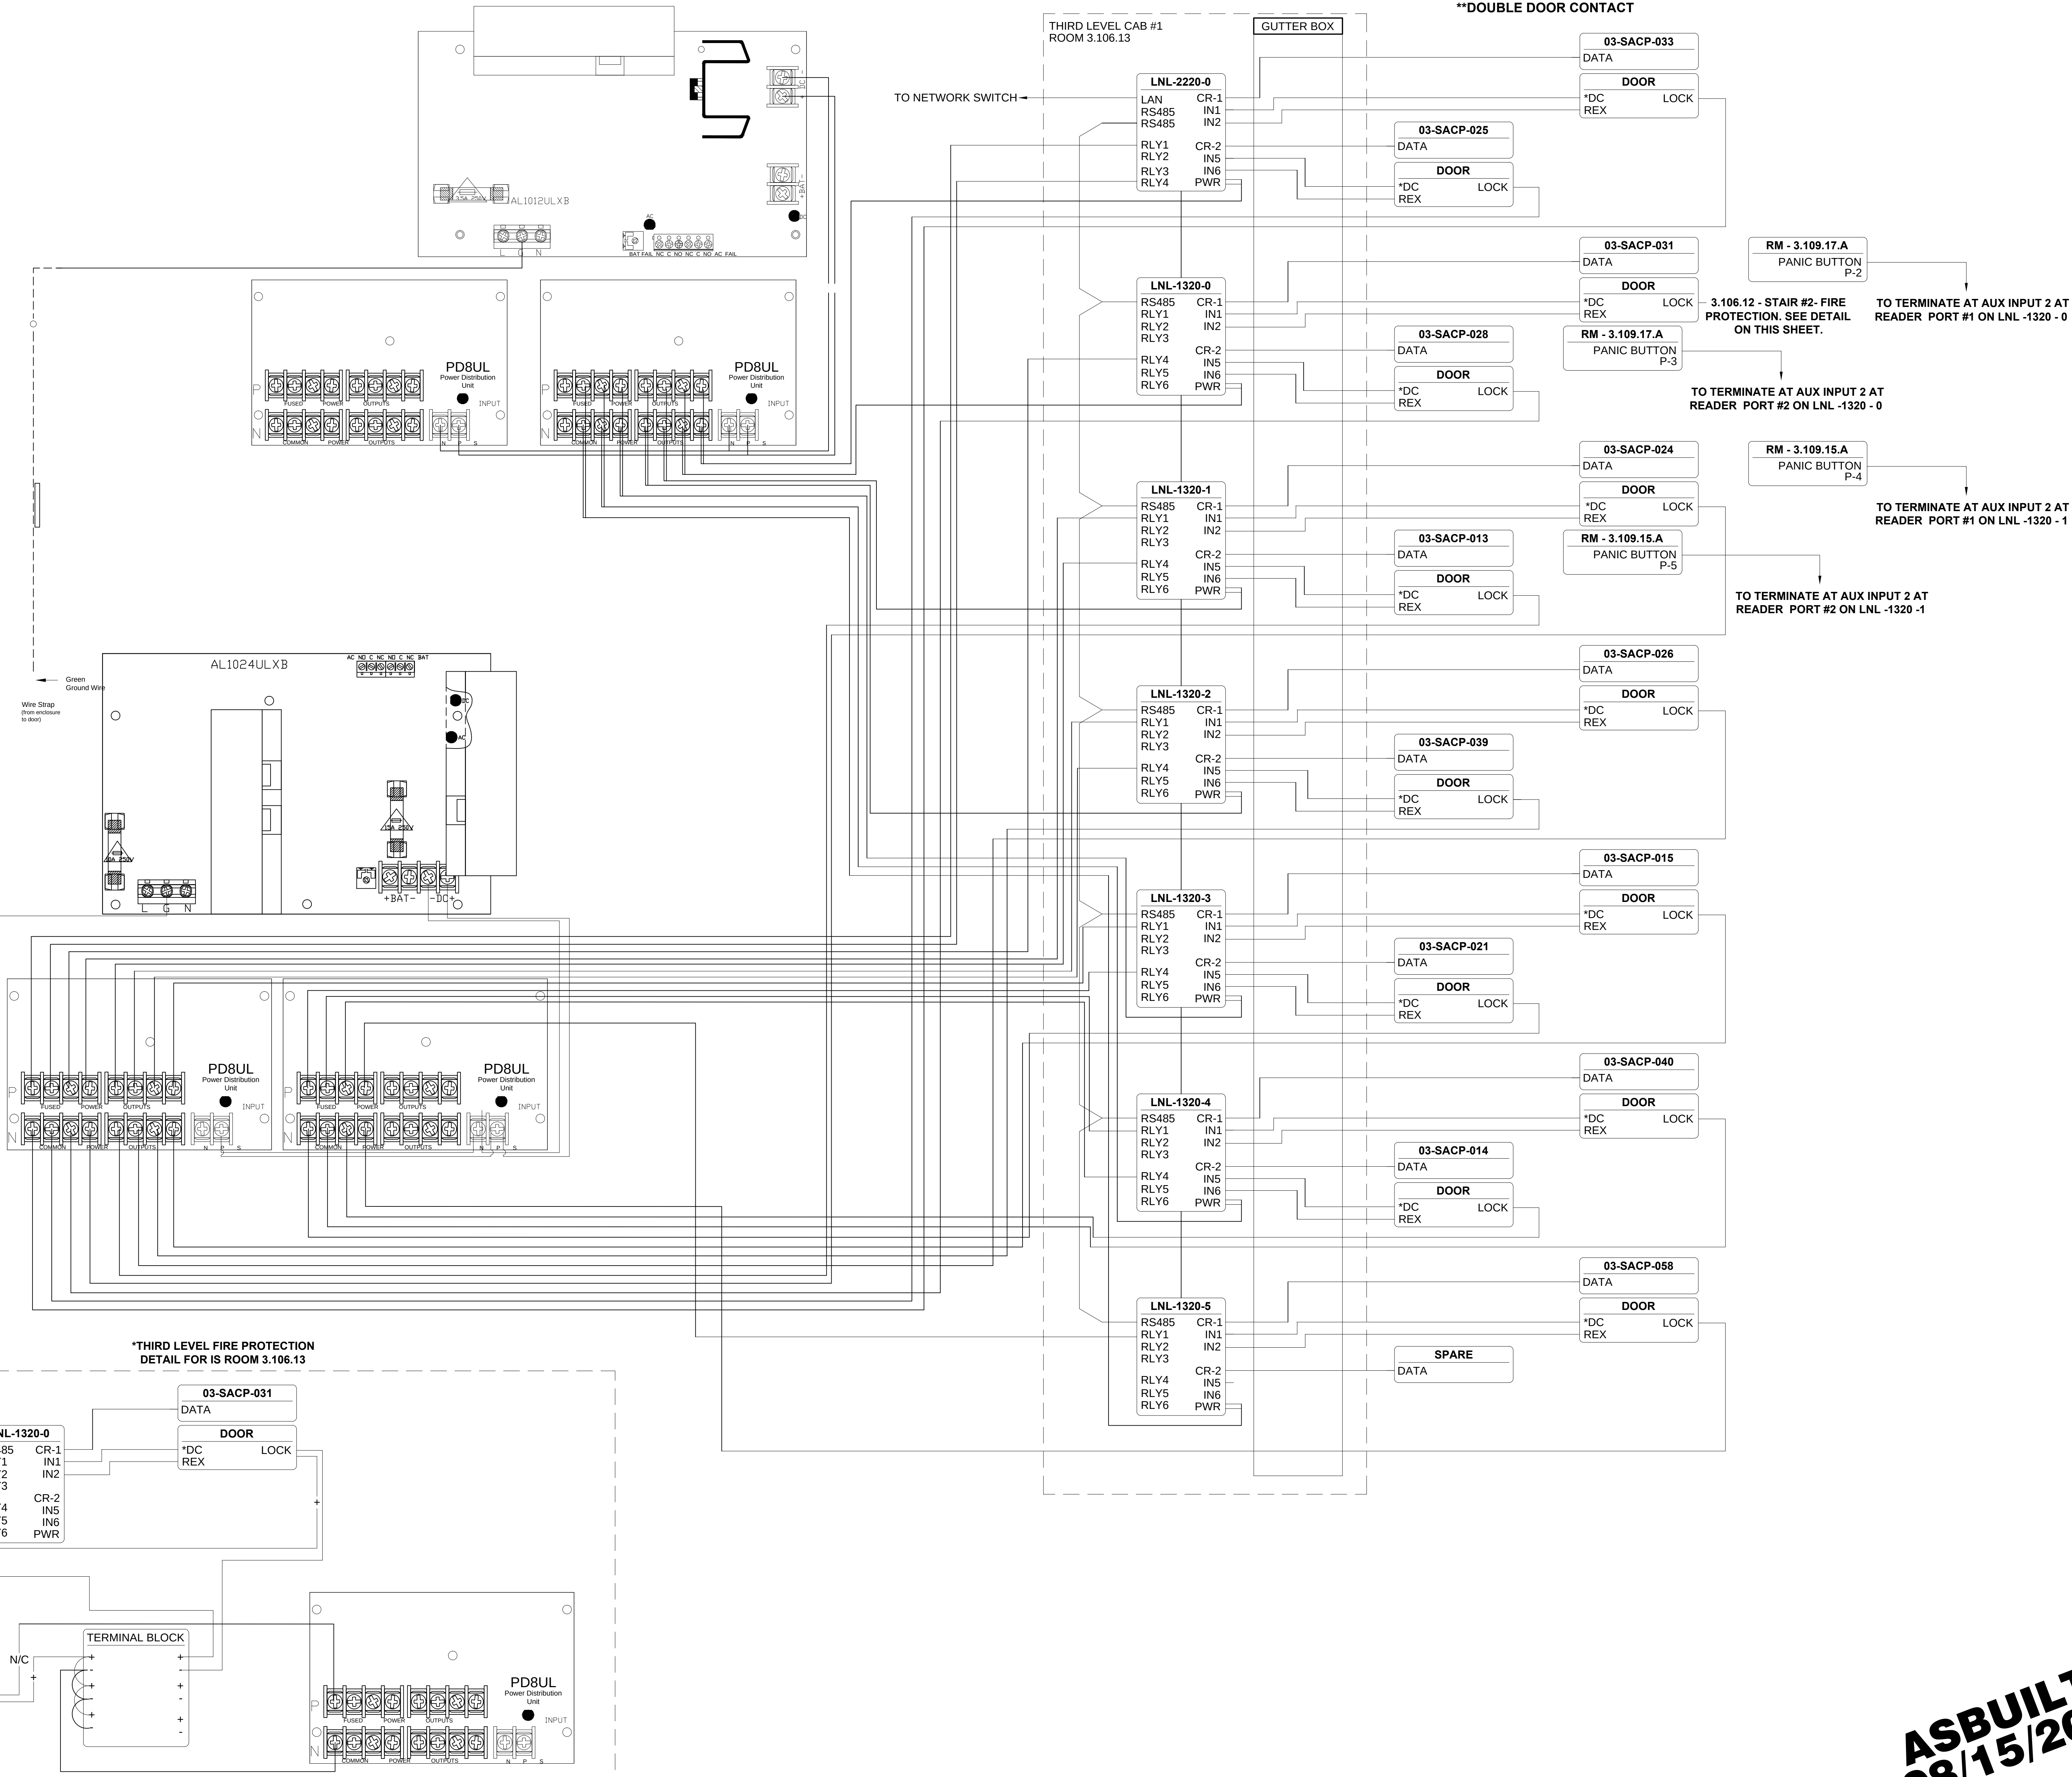

ASBUILTS
08/15/2012

DRAWING PREPARED BY:



1511 E. ORANGETHORPE BLVD.
FULLERTON, CALIFORNIA 92831
714-525-4350 - o; 714-525-4386 - f
(c) Copyright 2012 KRATOS | HBE
All Rights Reserved.


**MUST BE SIGNED BY HBE
TO AUTHENTICATE CONTENT(S).
ALL DETAILS CHECKED FOR ACCURACY.**

SIGNATURE _____ DATE _____

HBE JOB #

FIDENCIAL

THE INFORMATION CONTAINED HEREIN MAY NOT BE USED OR REPRODUCED IN ANY MANNER WITHOUT WRITTEN PERMISSION OF KRATOS | HBE.

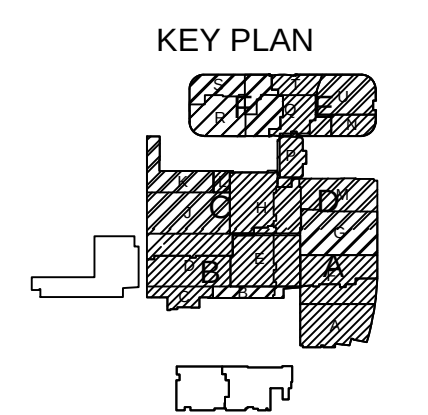

NO.	REV DESCRIPTION REV DATE	APPROVED BY
1.	AS BUILTS 08/15/2012	JOHN J. CHRISTIE
REV.	DESCRIPTION	APPROVED BY



PROJECT:

CHOC CHILDREN'S
HOSPITAL
455 SOUTH MAIN ST.
ORANGE, CA 92668

DRAWING TITLE:

THIRD LEVEL ACCESS
CONTROL POINT TO POINT
DIAGRAM -RM 3.106.13

DRN BY	DATE DRN	CHK BY	DATE CHK
JOSH G.	08/08/2012	JJC	
SCALE:	NTS		
DWG NO.	SE7.08		

**MUST BE SIGNED BY HBE
TO AUTHENTICATE CONTENT(S).
ALL DETAILS CHECKED FOR ACCURACY.**

HBE JOB #

THE INFORMATION CONTAINED HEREIN MAY NOT BE USED OR REPRODUCED IN ANY MANNER WITHOUT WRITTEN PERMISSION OF
KRATOS | HBE.


REV.	DESCRIPTION	APPROVED BY
------	-------------	-------------



CHOC
Children's Hospital
of Orange County


DRAWING TITLE:
THIRD LEVEL ACCESS
CONTROL POINT TO POINT
DIAGRAM -RM 3.064

DRN BY	DATE DRN	CHK BY	DATE CHK
JOSH G.	08/08/2012	JJC	
SCALE:	NTS		
DWG NO.	SE7.09		

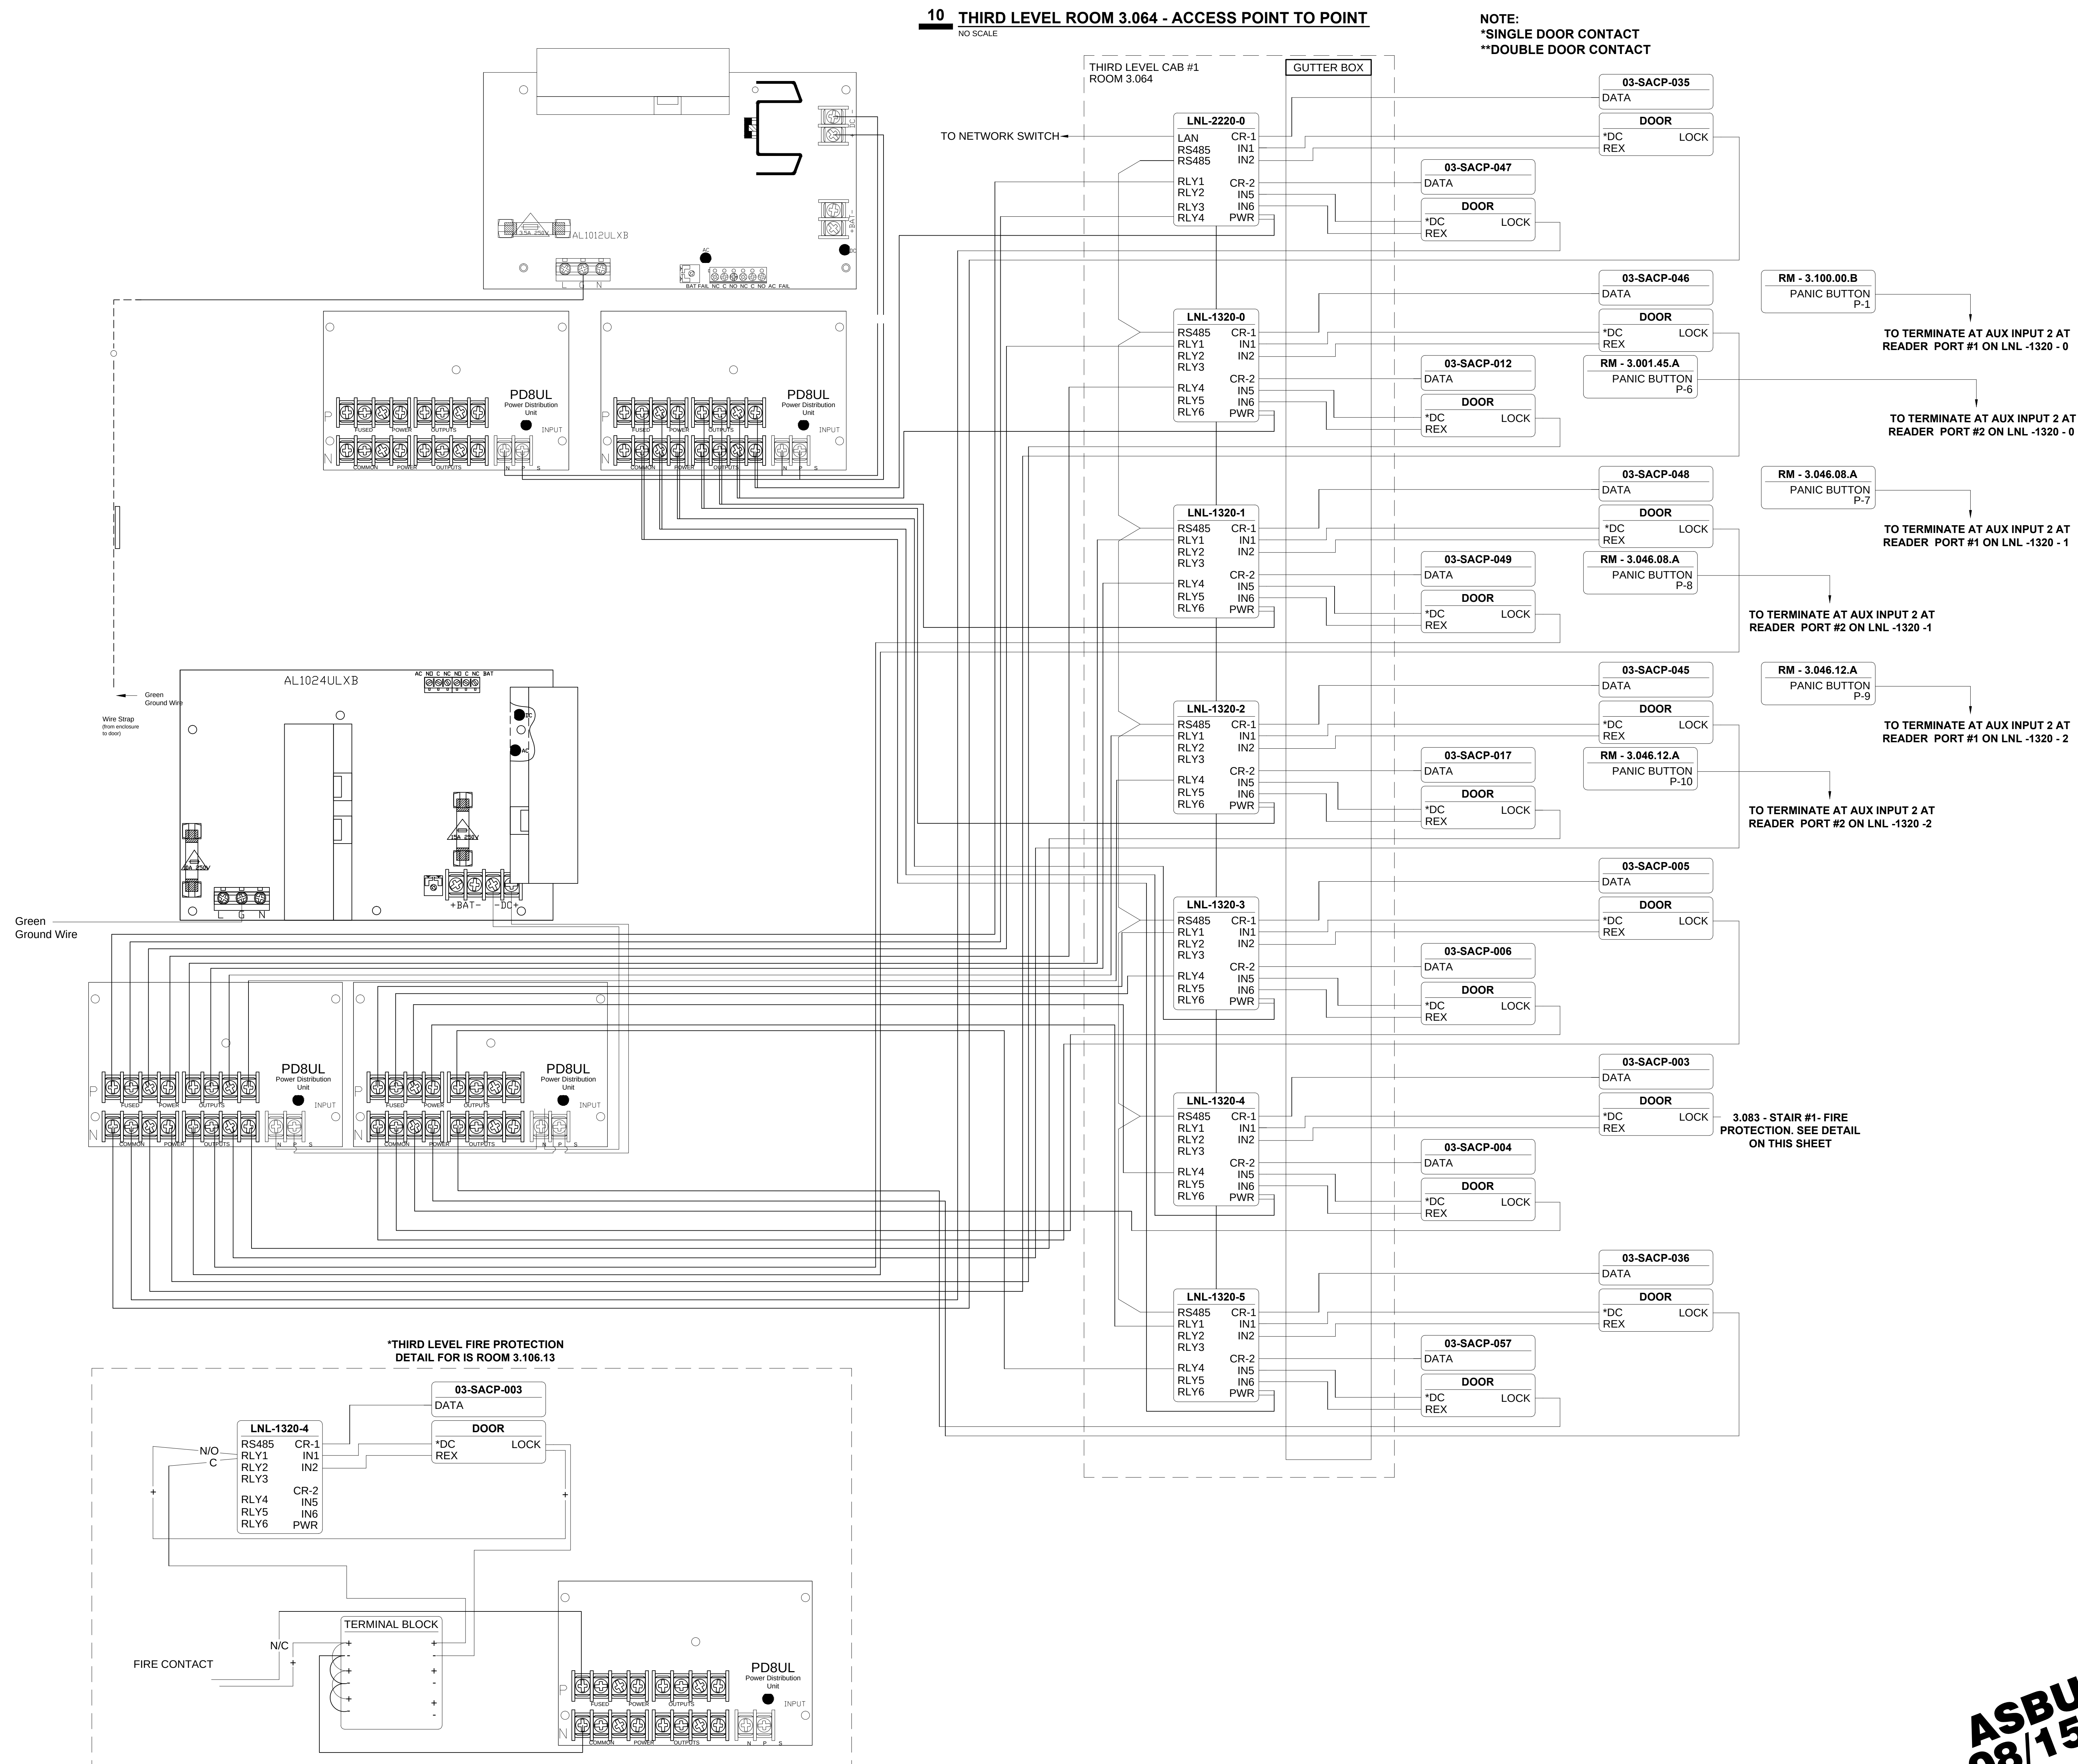


ASBUILTS
08/15/2012


1 FOURTH LEVEL ROOM 4.028.01 - ACCESS POINT TO POINT
NO SCALE

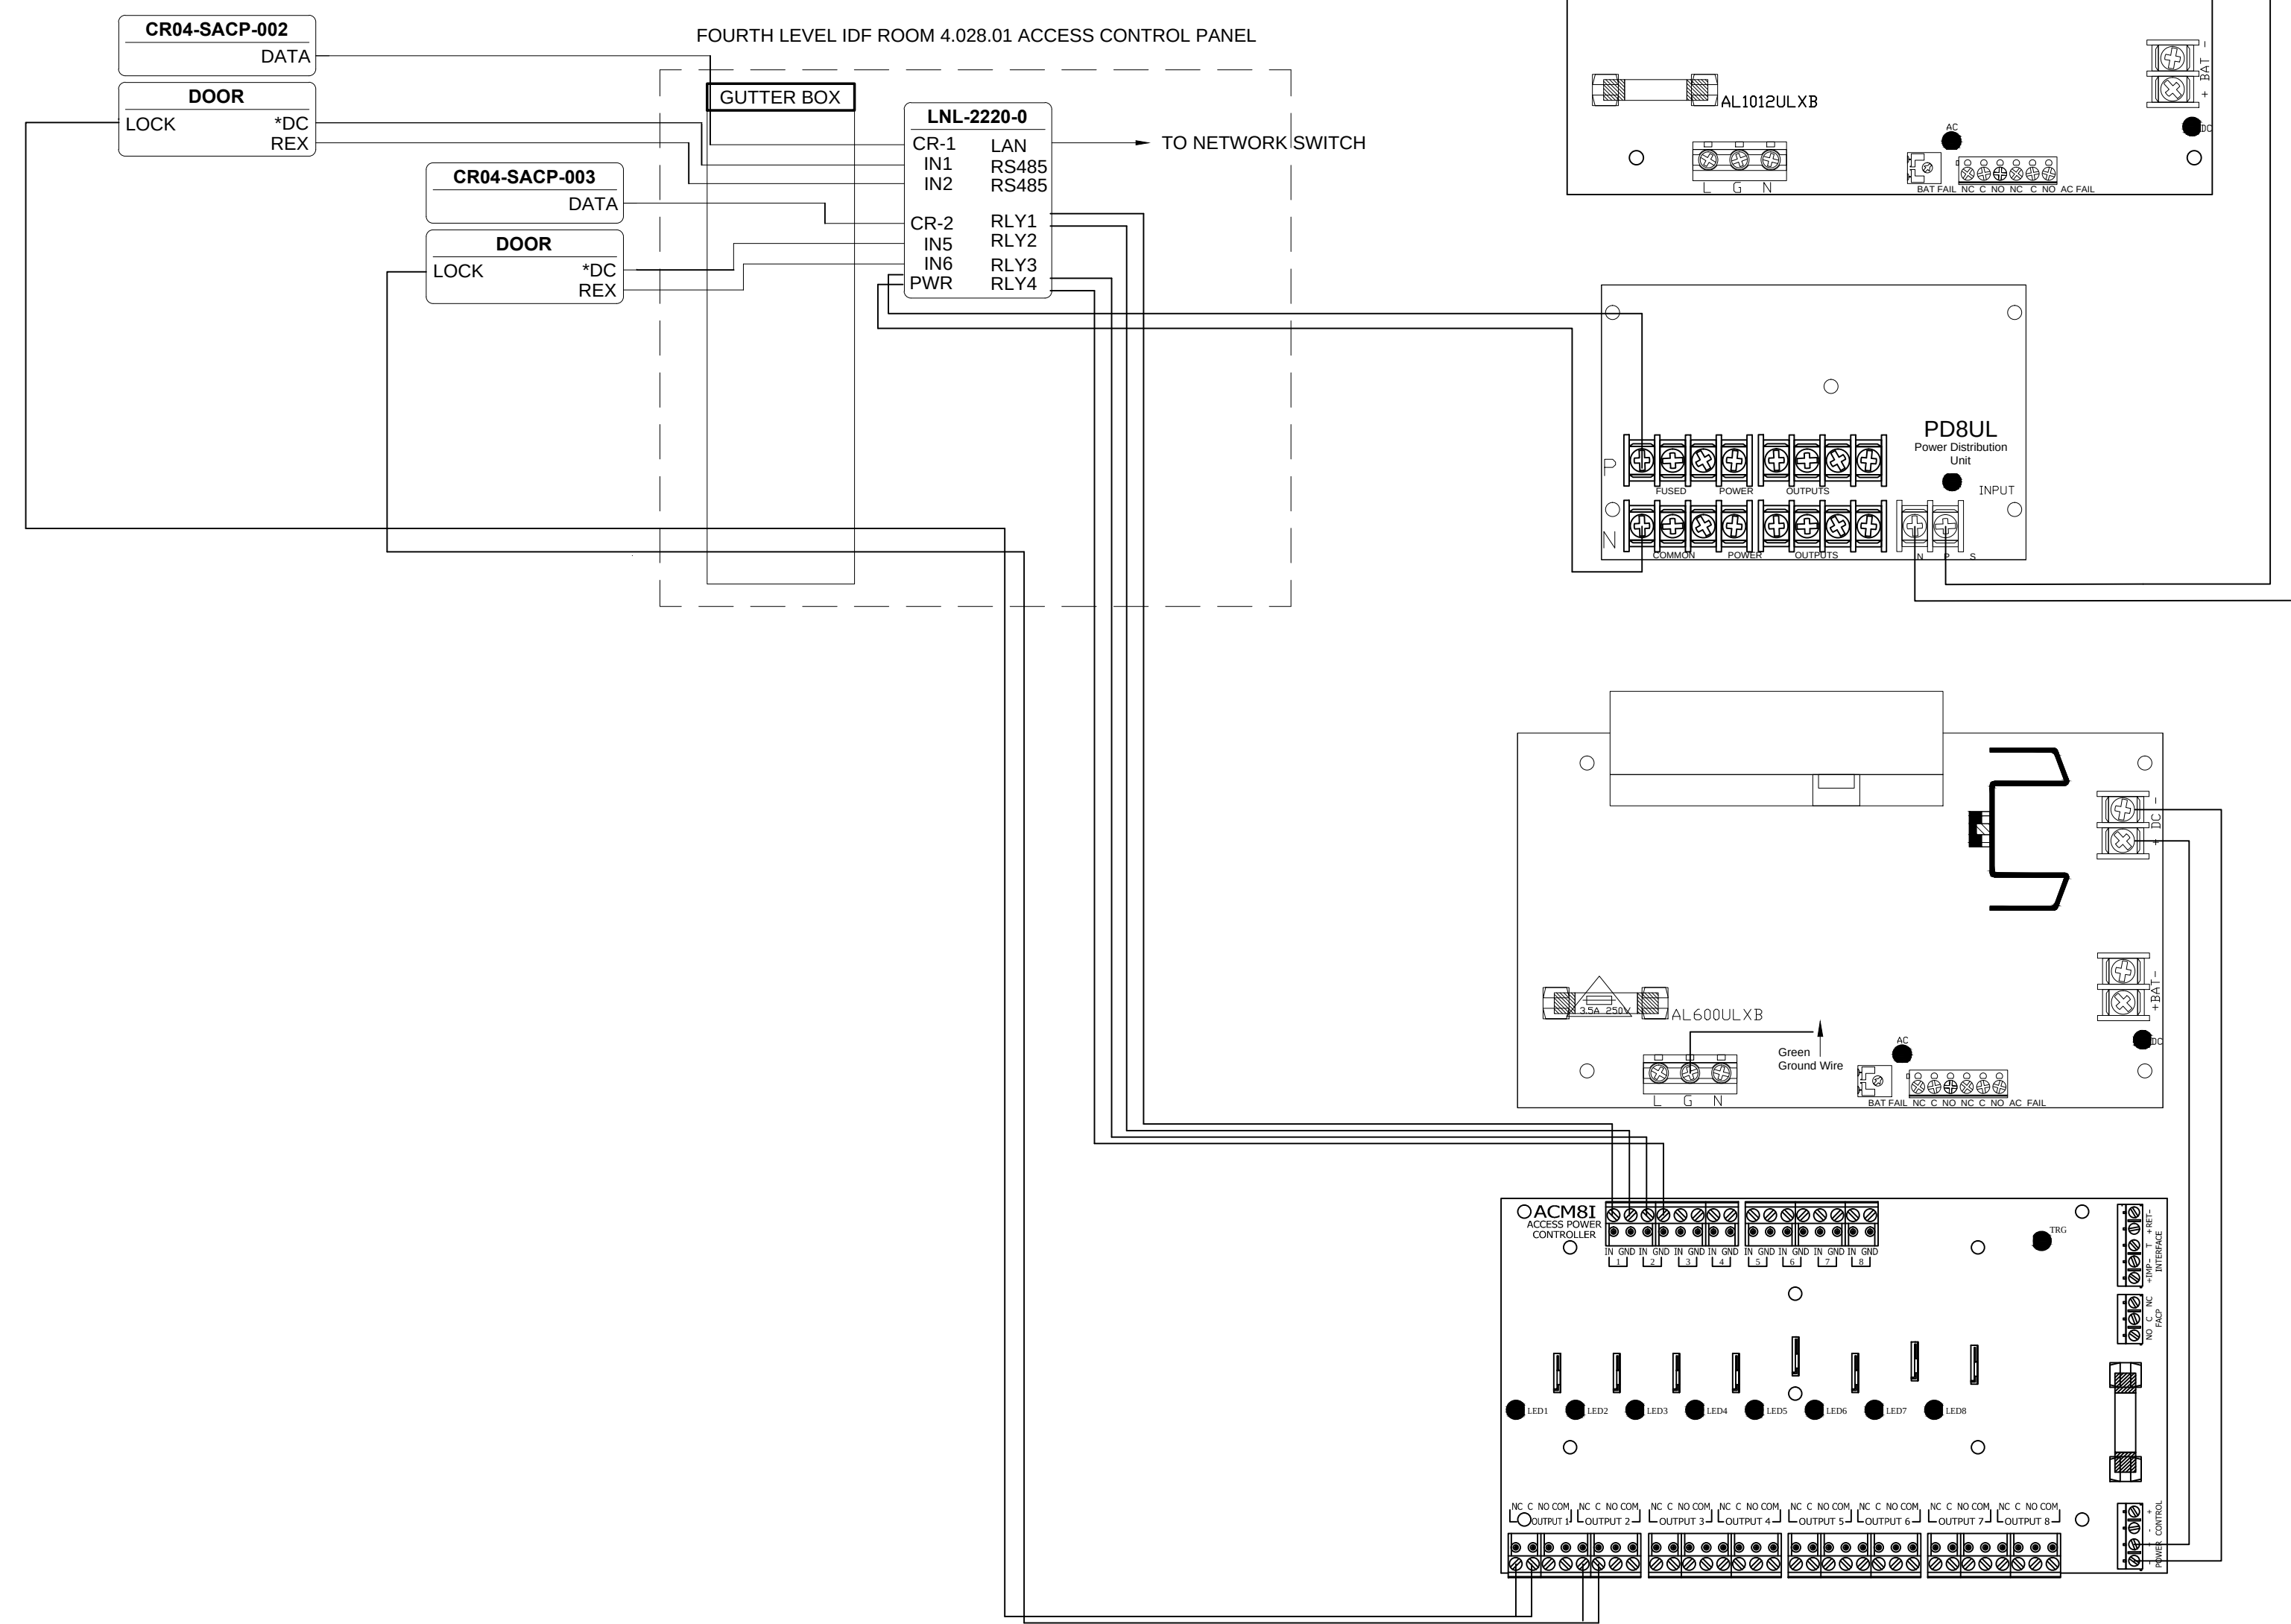

2 FOURTH LEVEL ROOM 4.80.01 - ACCESS POINT TO POINT
NO SCALE

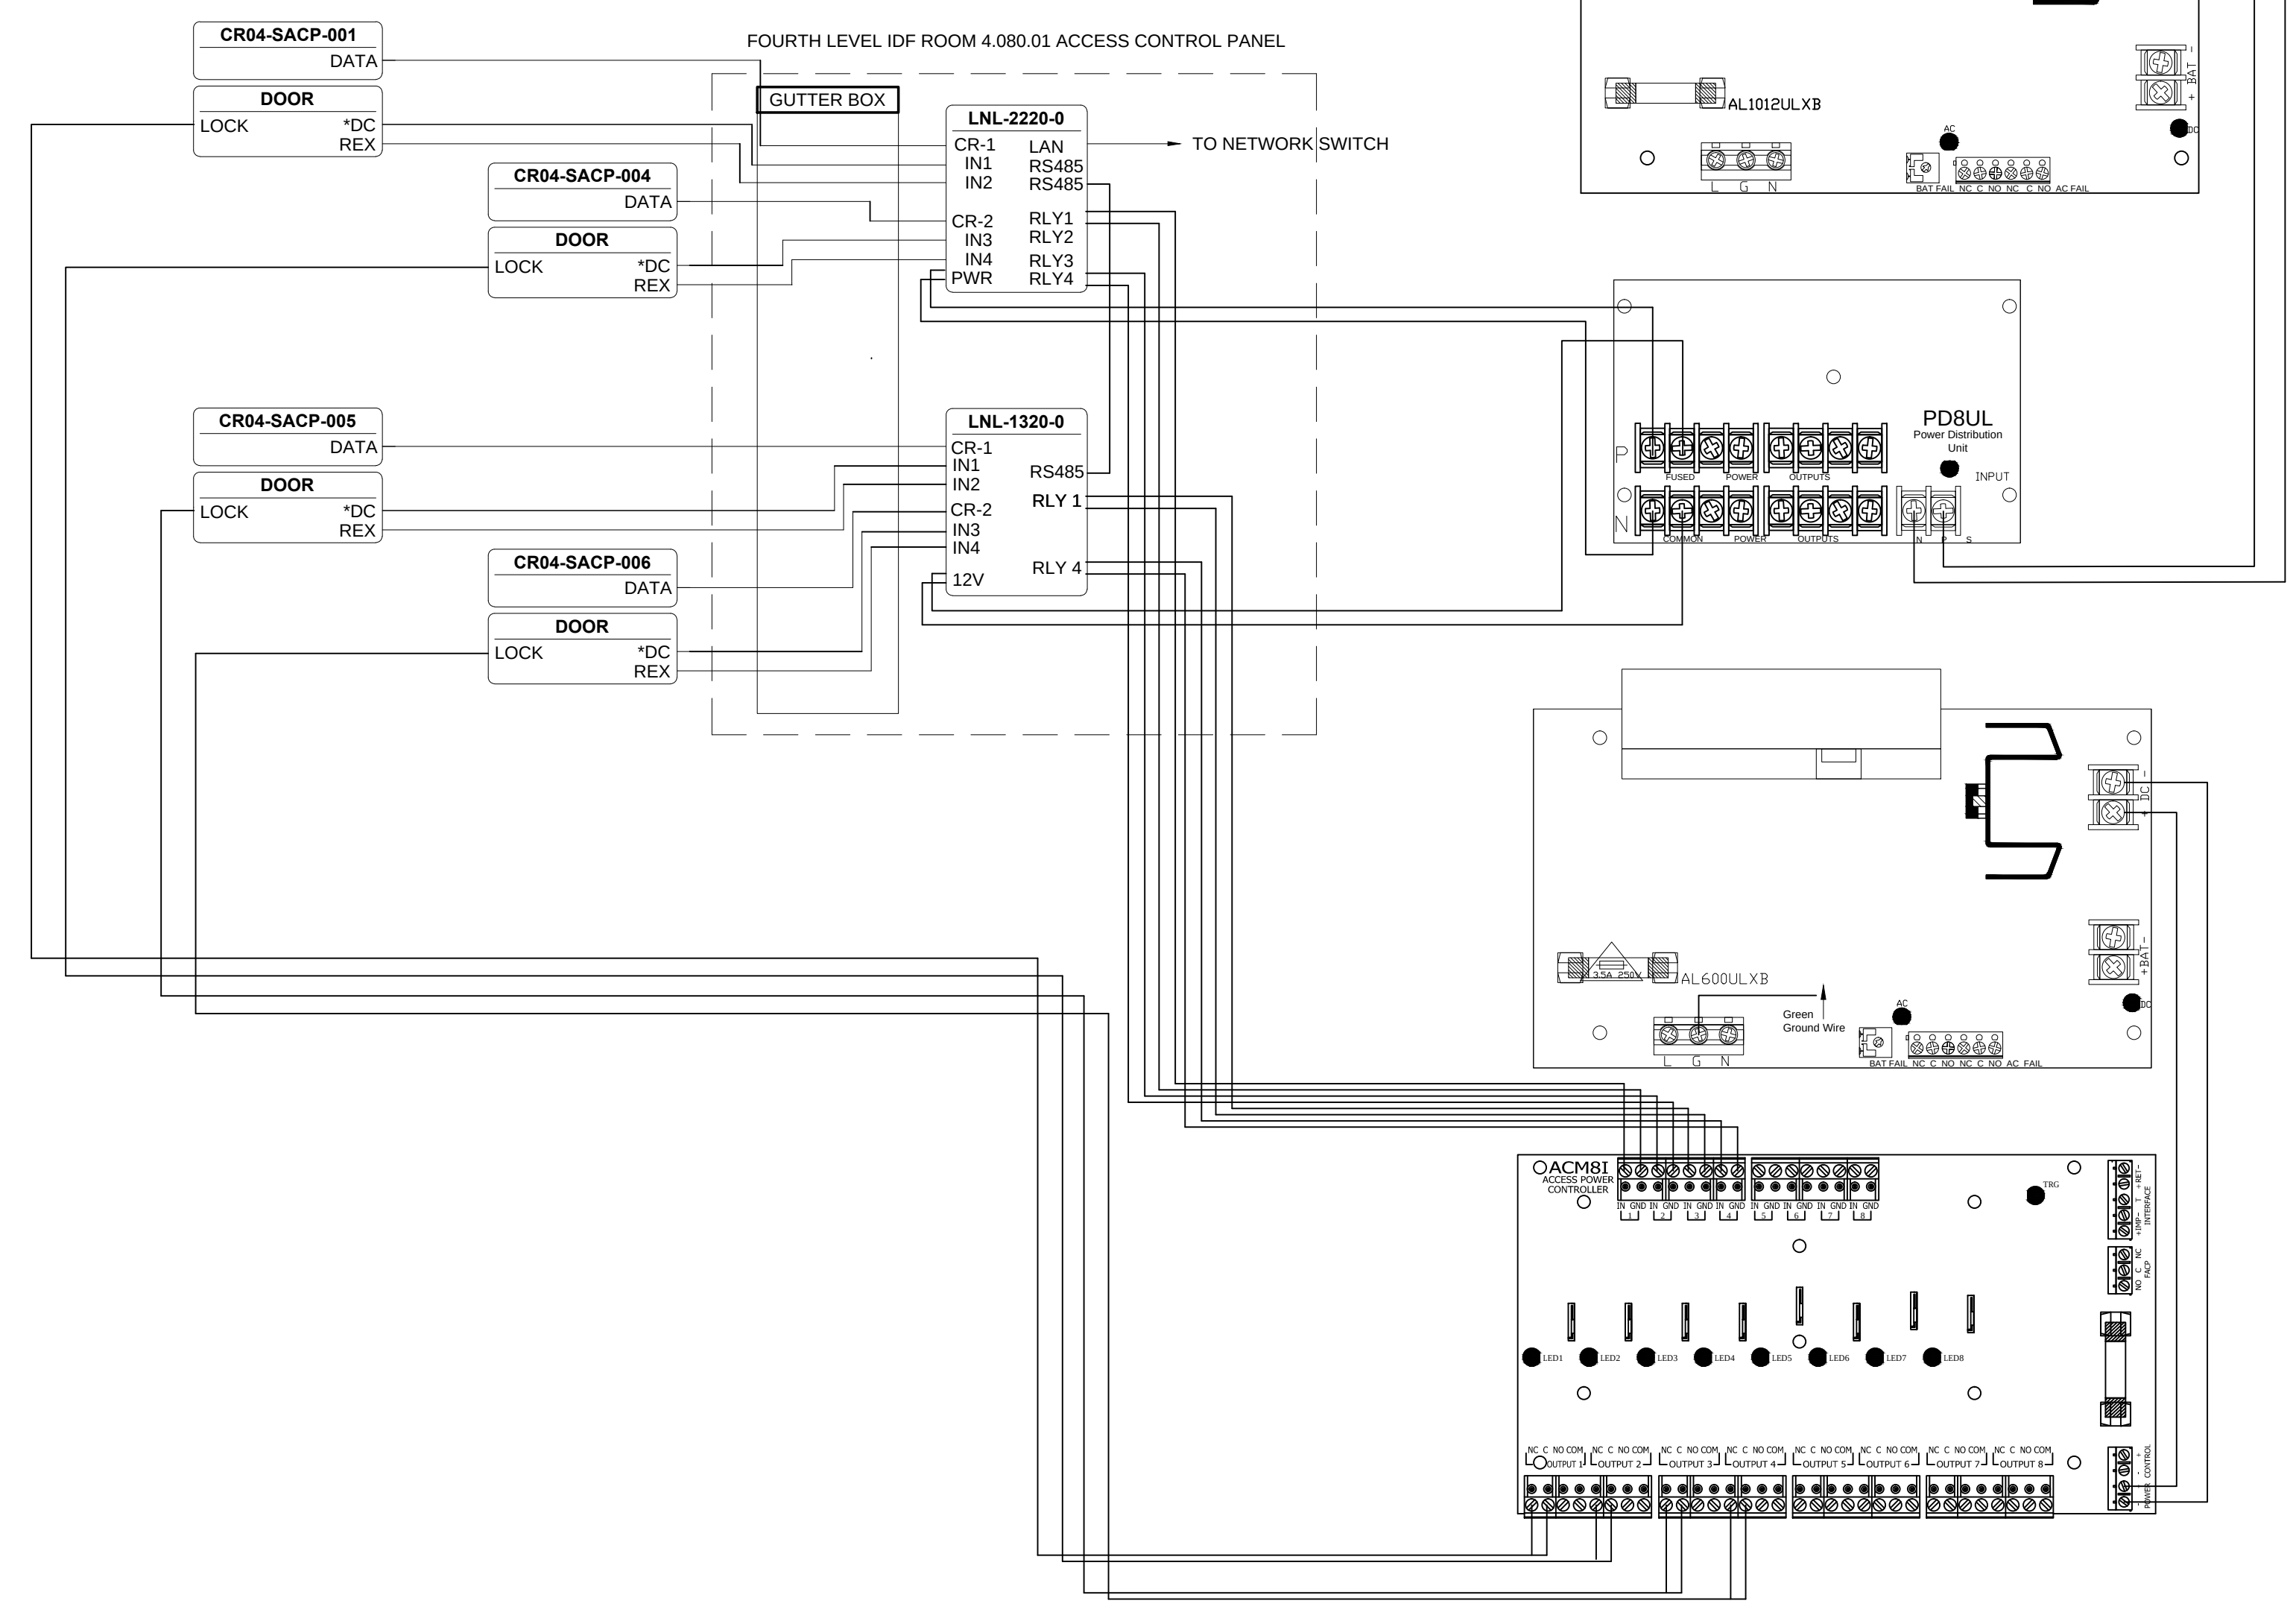

3 FOURTH LEVEL ROOM 4.135 - ACCESS POINT TO POINT
NO SCALE

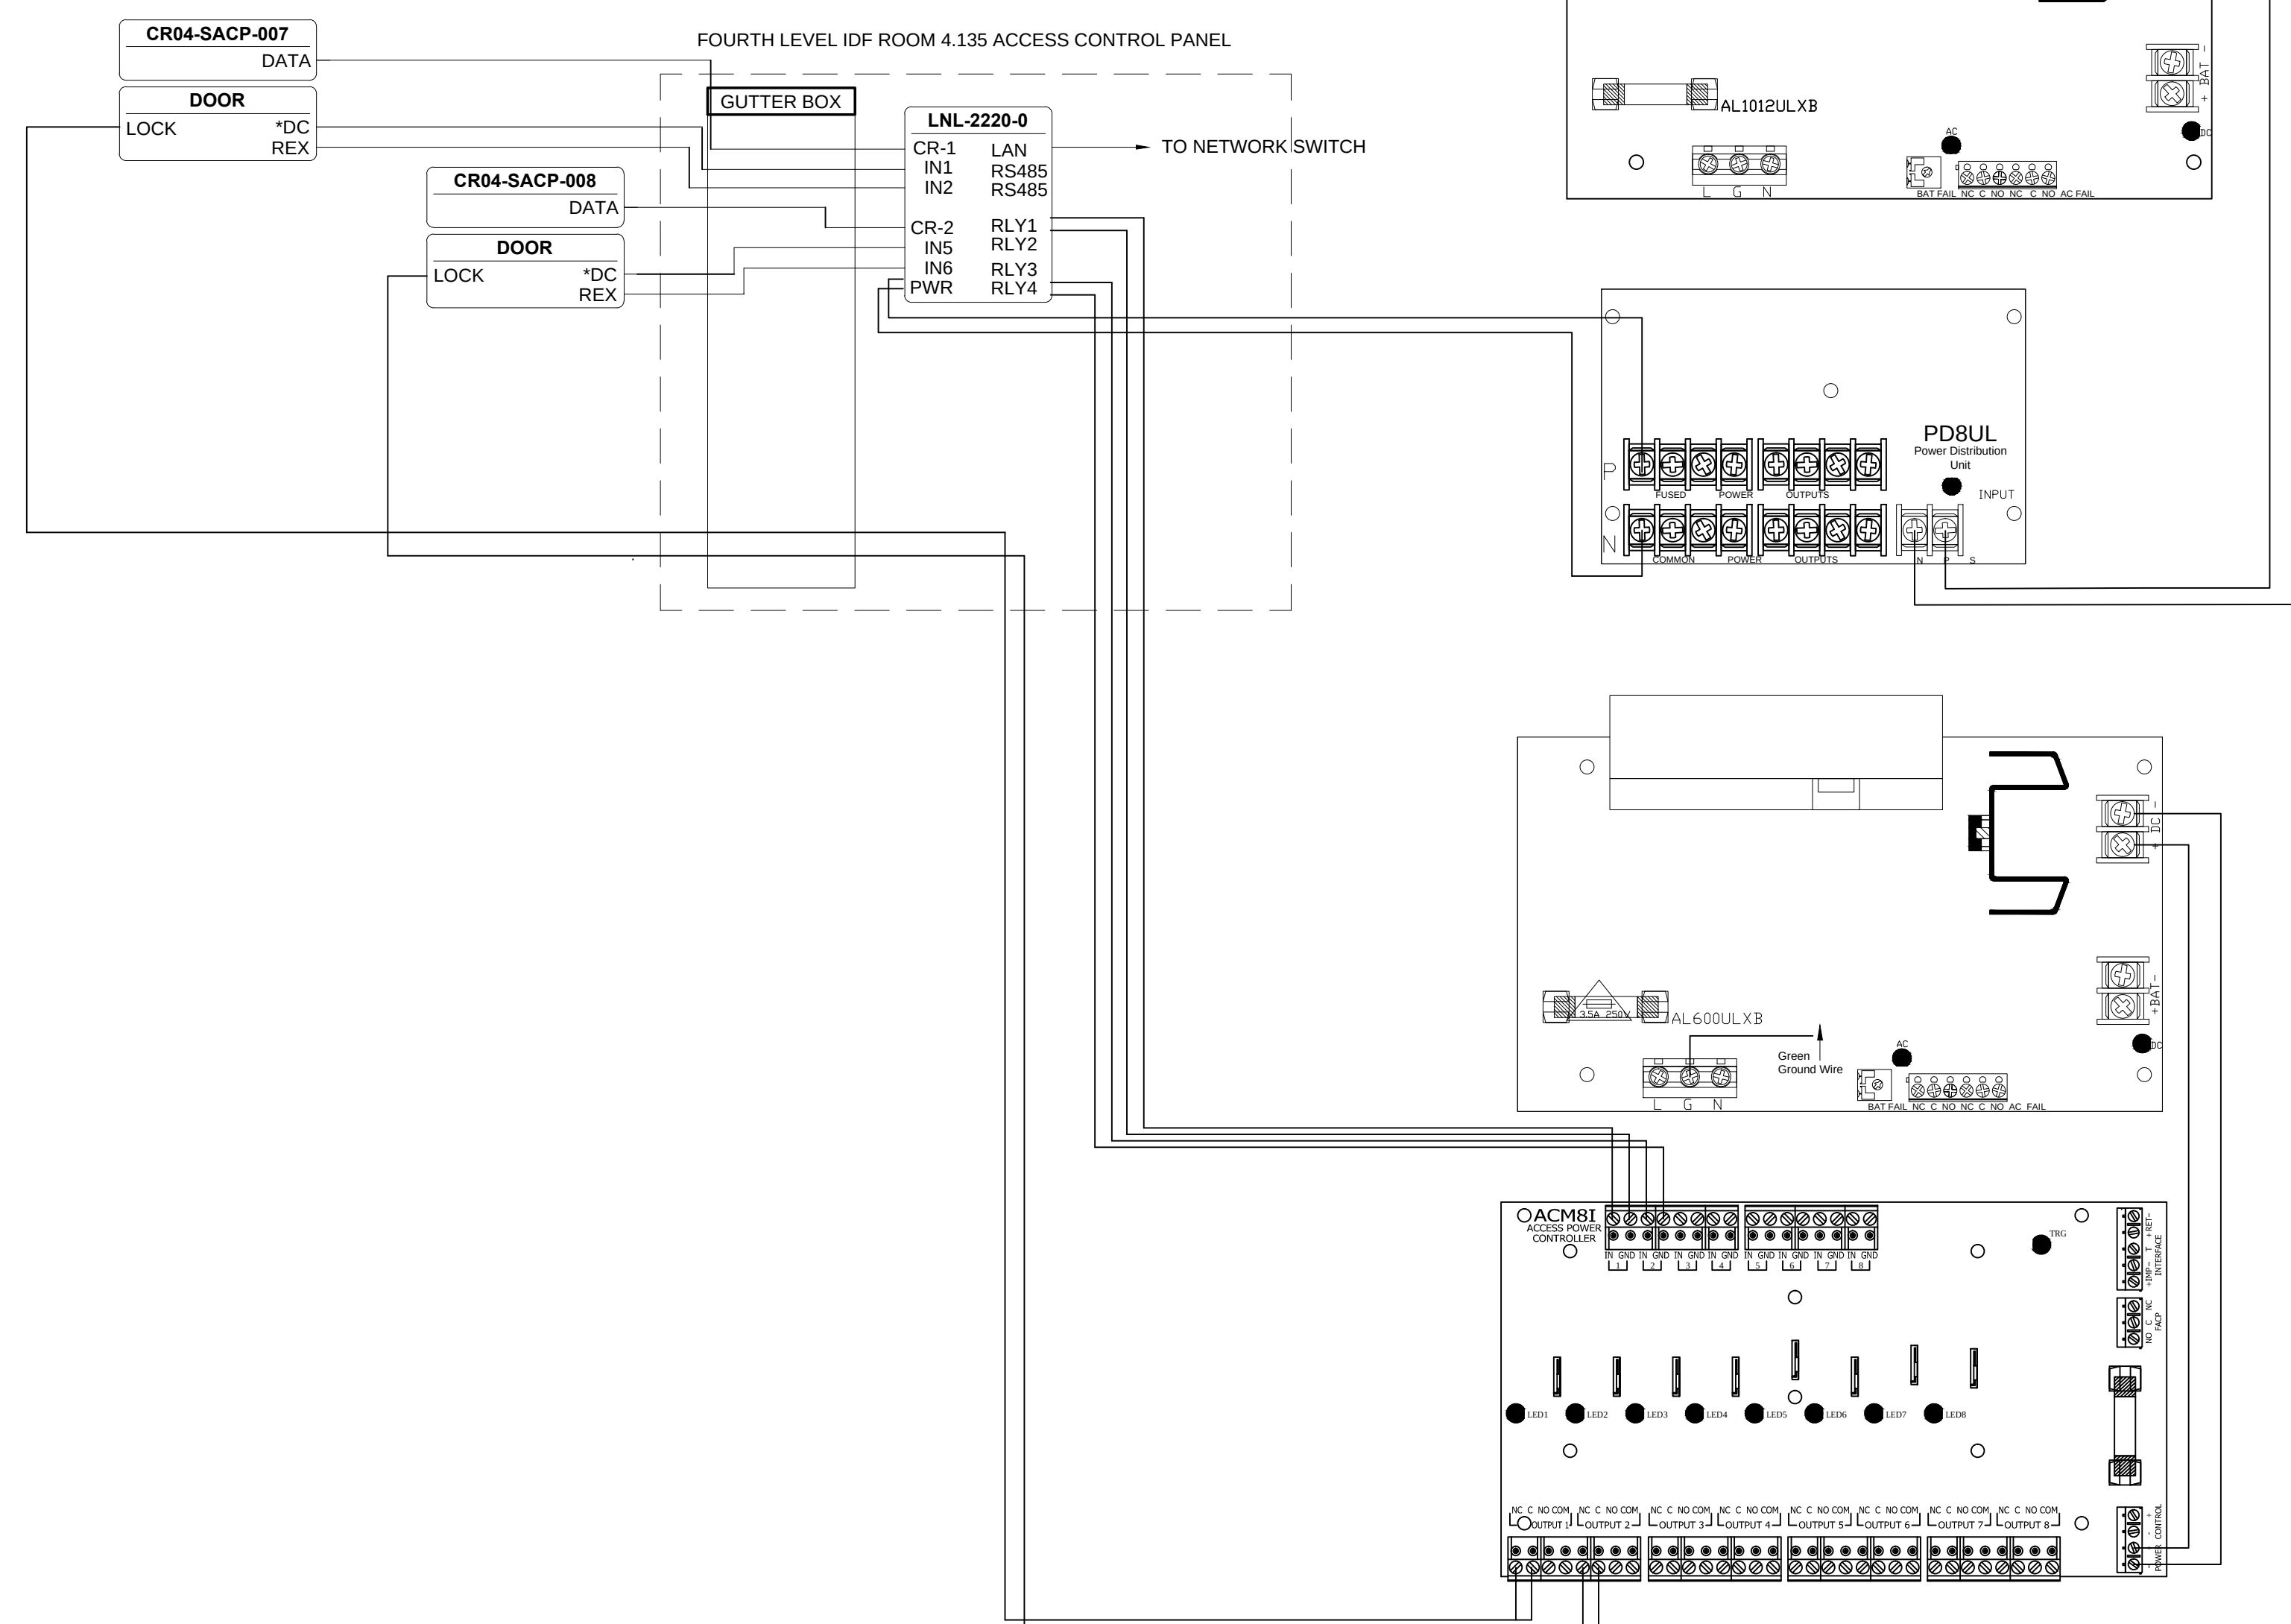

DRAWING PREPARED BY:

KRATOS
HBE

1511 E. ORANGETHORPE BLVD.
FULLERTON, CALIFORNIA 92831
714-525-4350 - o; 714-525-4386 - f
(c) Copyright 2012 KRATOS | HBE
All Rights Reserved.

**MUST BE SIGNED BY HBE
TO AUTHENTICATE CONTENT(S).
ALL DETAILS CHECKED FOR ACCURACY.**


SIGNATURE _____ DATE _____

HBE JOB # _____

CONFIDENTIAL

THE INFORMATION CONTAINED HEREIN MAY
NOT BE USED OR REPRODUCED IN ANY
MANNER WITHOUT WRITTEN PERMISSION OF
KRATOS | HBE.

KEY PLAN

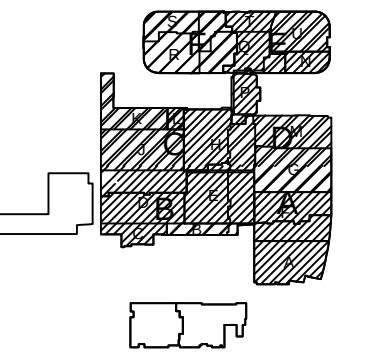

NO.	REV DESCRIPTION REV DATE	APPROVED BY
1.	AS BUILTS 09/24/2012	JOHN J. CHRISTIE
33A	CHANGE ORDER #376	JOHN J. CHRISTIE

REV.	DESCRIPTION	APPROVED BY
------	-------------	-------------

CUSTOMER:

CHOC
Children's Hospital
of Orange County

PROJECT:
CHOC CHILDREN'S
HOSPITAL
455 SOUTH MAIN ST.
ORANGE, CA 92668

DRAWING TITLE:
**FOURTH LEVEL ACCESS
CONTROL POINT TO
POINT DIAGRAM**

JOSH G.	08/08/2012	JJC
SCALE:	NTS	
DWG NO.	SE3.00	

**ASBUILTS
09/26/2012**

NO SCALE



RM - 5.127.00.B
PANIC BUTTON
P-4

TO TERMINATE AT AUX INPUT 2 AT
READER PORT #1 ON LNL -1320 -0




(c) Copyright 2012 KRATOS | HBE
All Rights Reserved.

SIGNATURE _____ DATE _____

HBE JOB #

THE INFORMATION CONTAINED HEREIN MAY
NOT BE USED OR REPRODUCED IN ANY
MANNER WITHOUT WRITTEN PERMISSION OF
KRATOS | HBE.

KEY PLAN

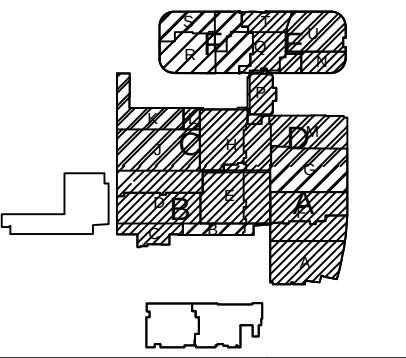

1.	AS BUILTS 08/15/2012	JOHN J. CHRISTIE
----	-------------------------	------------------



CHOC CHILDREN'S
HOSPITAL
55 SOUTH MAIN ST.
ORANGE, CA 92668

DRAWING TITLE:


FIFTH LEVEL ACCESS
CONTROL POINT TO POINT
DIAGRAM -RM 5.123

DRN BY	DATE DRN	CHK BY	DATE CHK
JOSH G.	08/08/2012	JJC	
SCALE:	NTS		
DWG NO.	SE7.10		

ASBUILTS
08/15/2012

12 FIFTH LEVEL ROOM 5.101 - ACCESS POINT TO POINT
NO SCALE

NOTE:
*SINGLE DOOR CONTACT
**DOUBLE DOOR CONTACT

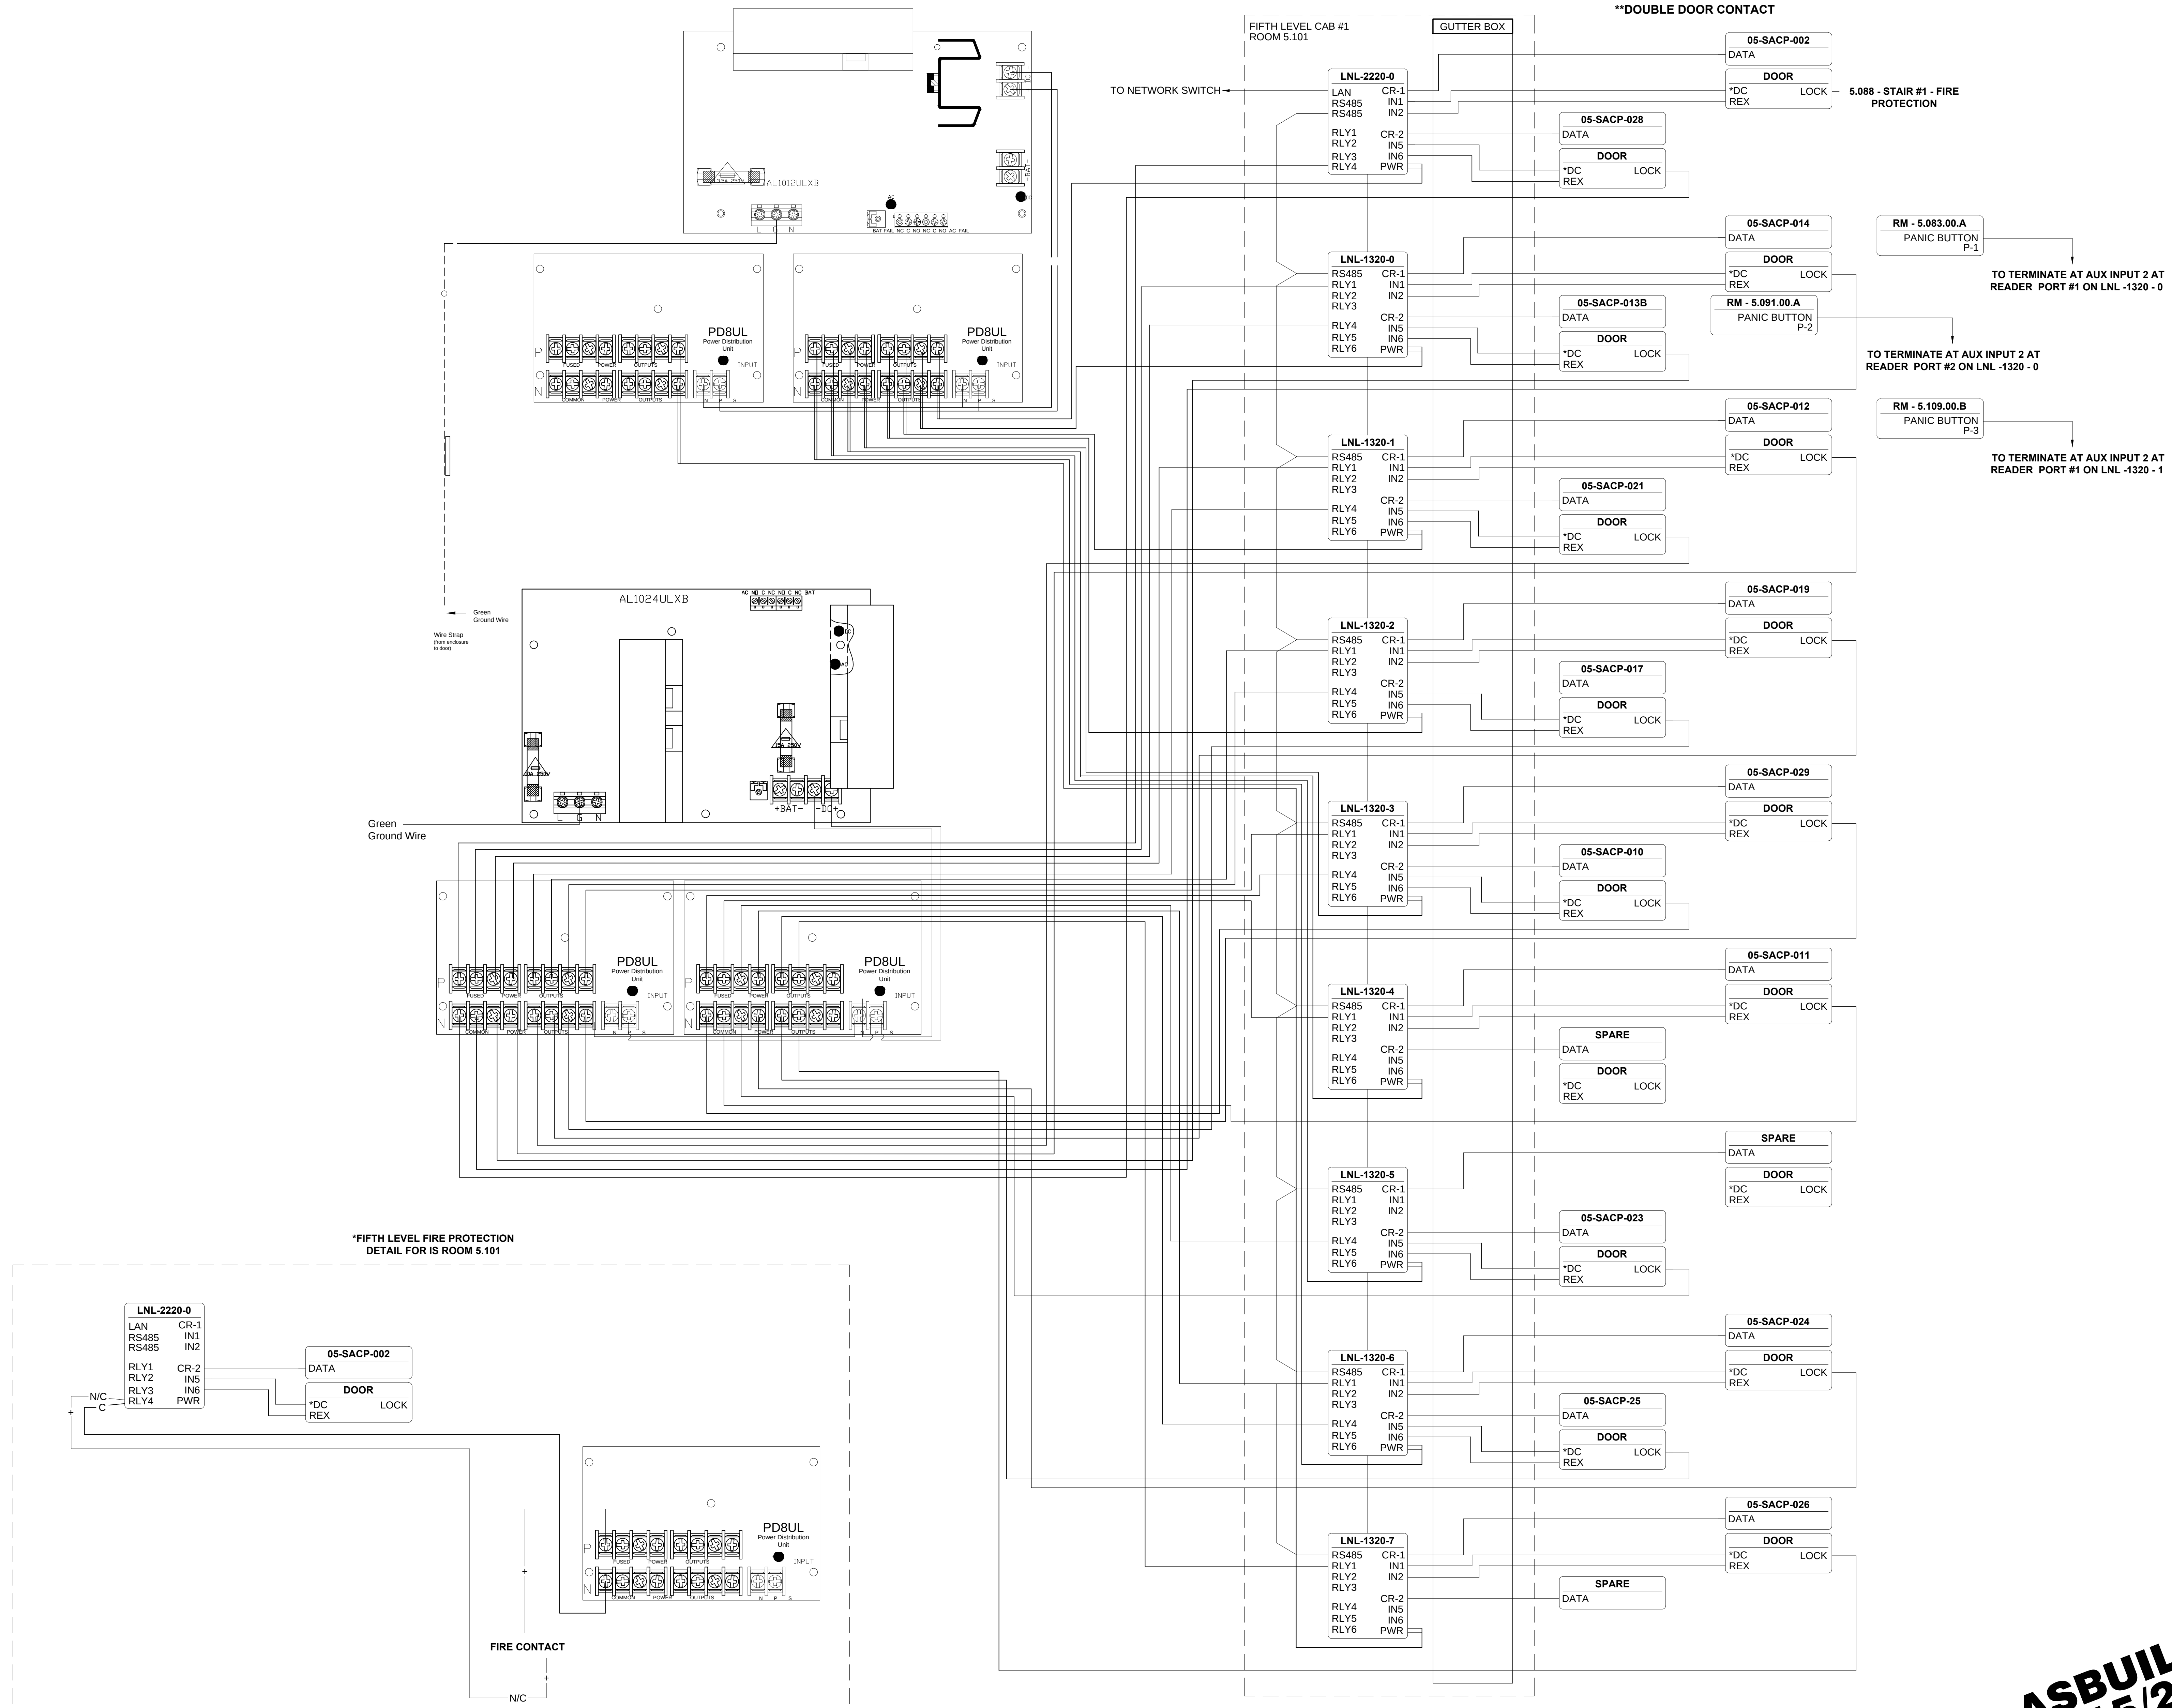

DRAWING PREPARED BY:



1511 E. ORANGETHORPE BLVD.
FULLERTON, CALIFORNIA 92831
714-525-4350 - o; 714-525-4386 - f
(c) Copyright 2012 KRATOS | HBE
All Rights Reserved.

MUST BE SIGNED BY HBE
TO AUTHENTICATE CONTENT(S).
ALL DETAILS CHECKED FOR ACCURACY.


SIGNATURE _____ DATE _____

HBE JOB #

CONFIDENTIAL

THE INFORMATION CONTAINED HEREIN MAY
NOT BE USED OR REPRODUCED IN ANY
MANNER WITHOUT WRITTEN PERMISSION OF
KRATOS | HBE.

KEY PLAN

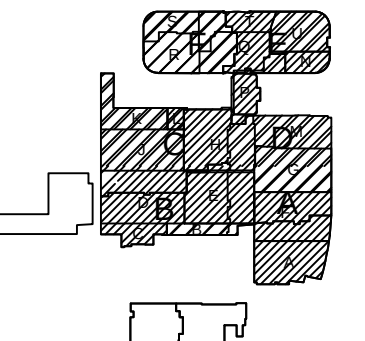

NO.	REV DESCRIPTION REV DATE	APPROVED BY
1.	AS BUILTS 08/15/2012	JOHN J. CHRISTIE

REV. DESCRIPTION APPROVED BY

CUSTOMER:




PROJECT:
CHOC CHILDREN'S
HOSPITAL
455 SOUTH MAIN ST.
ORANGE, CA 92668

DRAWING TITLE:
FIFTH LEVEL ACCESS
CONTROL POINT TO POINT
DIAGRAM - RM 5.101

DRN BY	DATE DRN	CHK BY	DATE CHK
JOSH G.	08/08/2012	JJC	
SCALE:	NTS		
DWG NO.	SE7.11		

ASBUILTS
08/15/2012

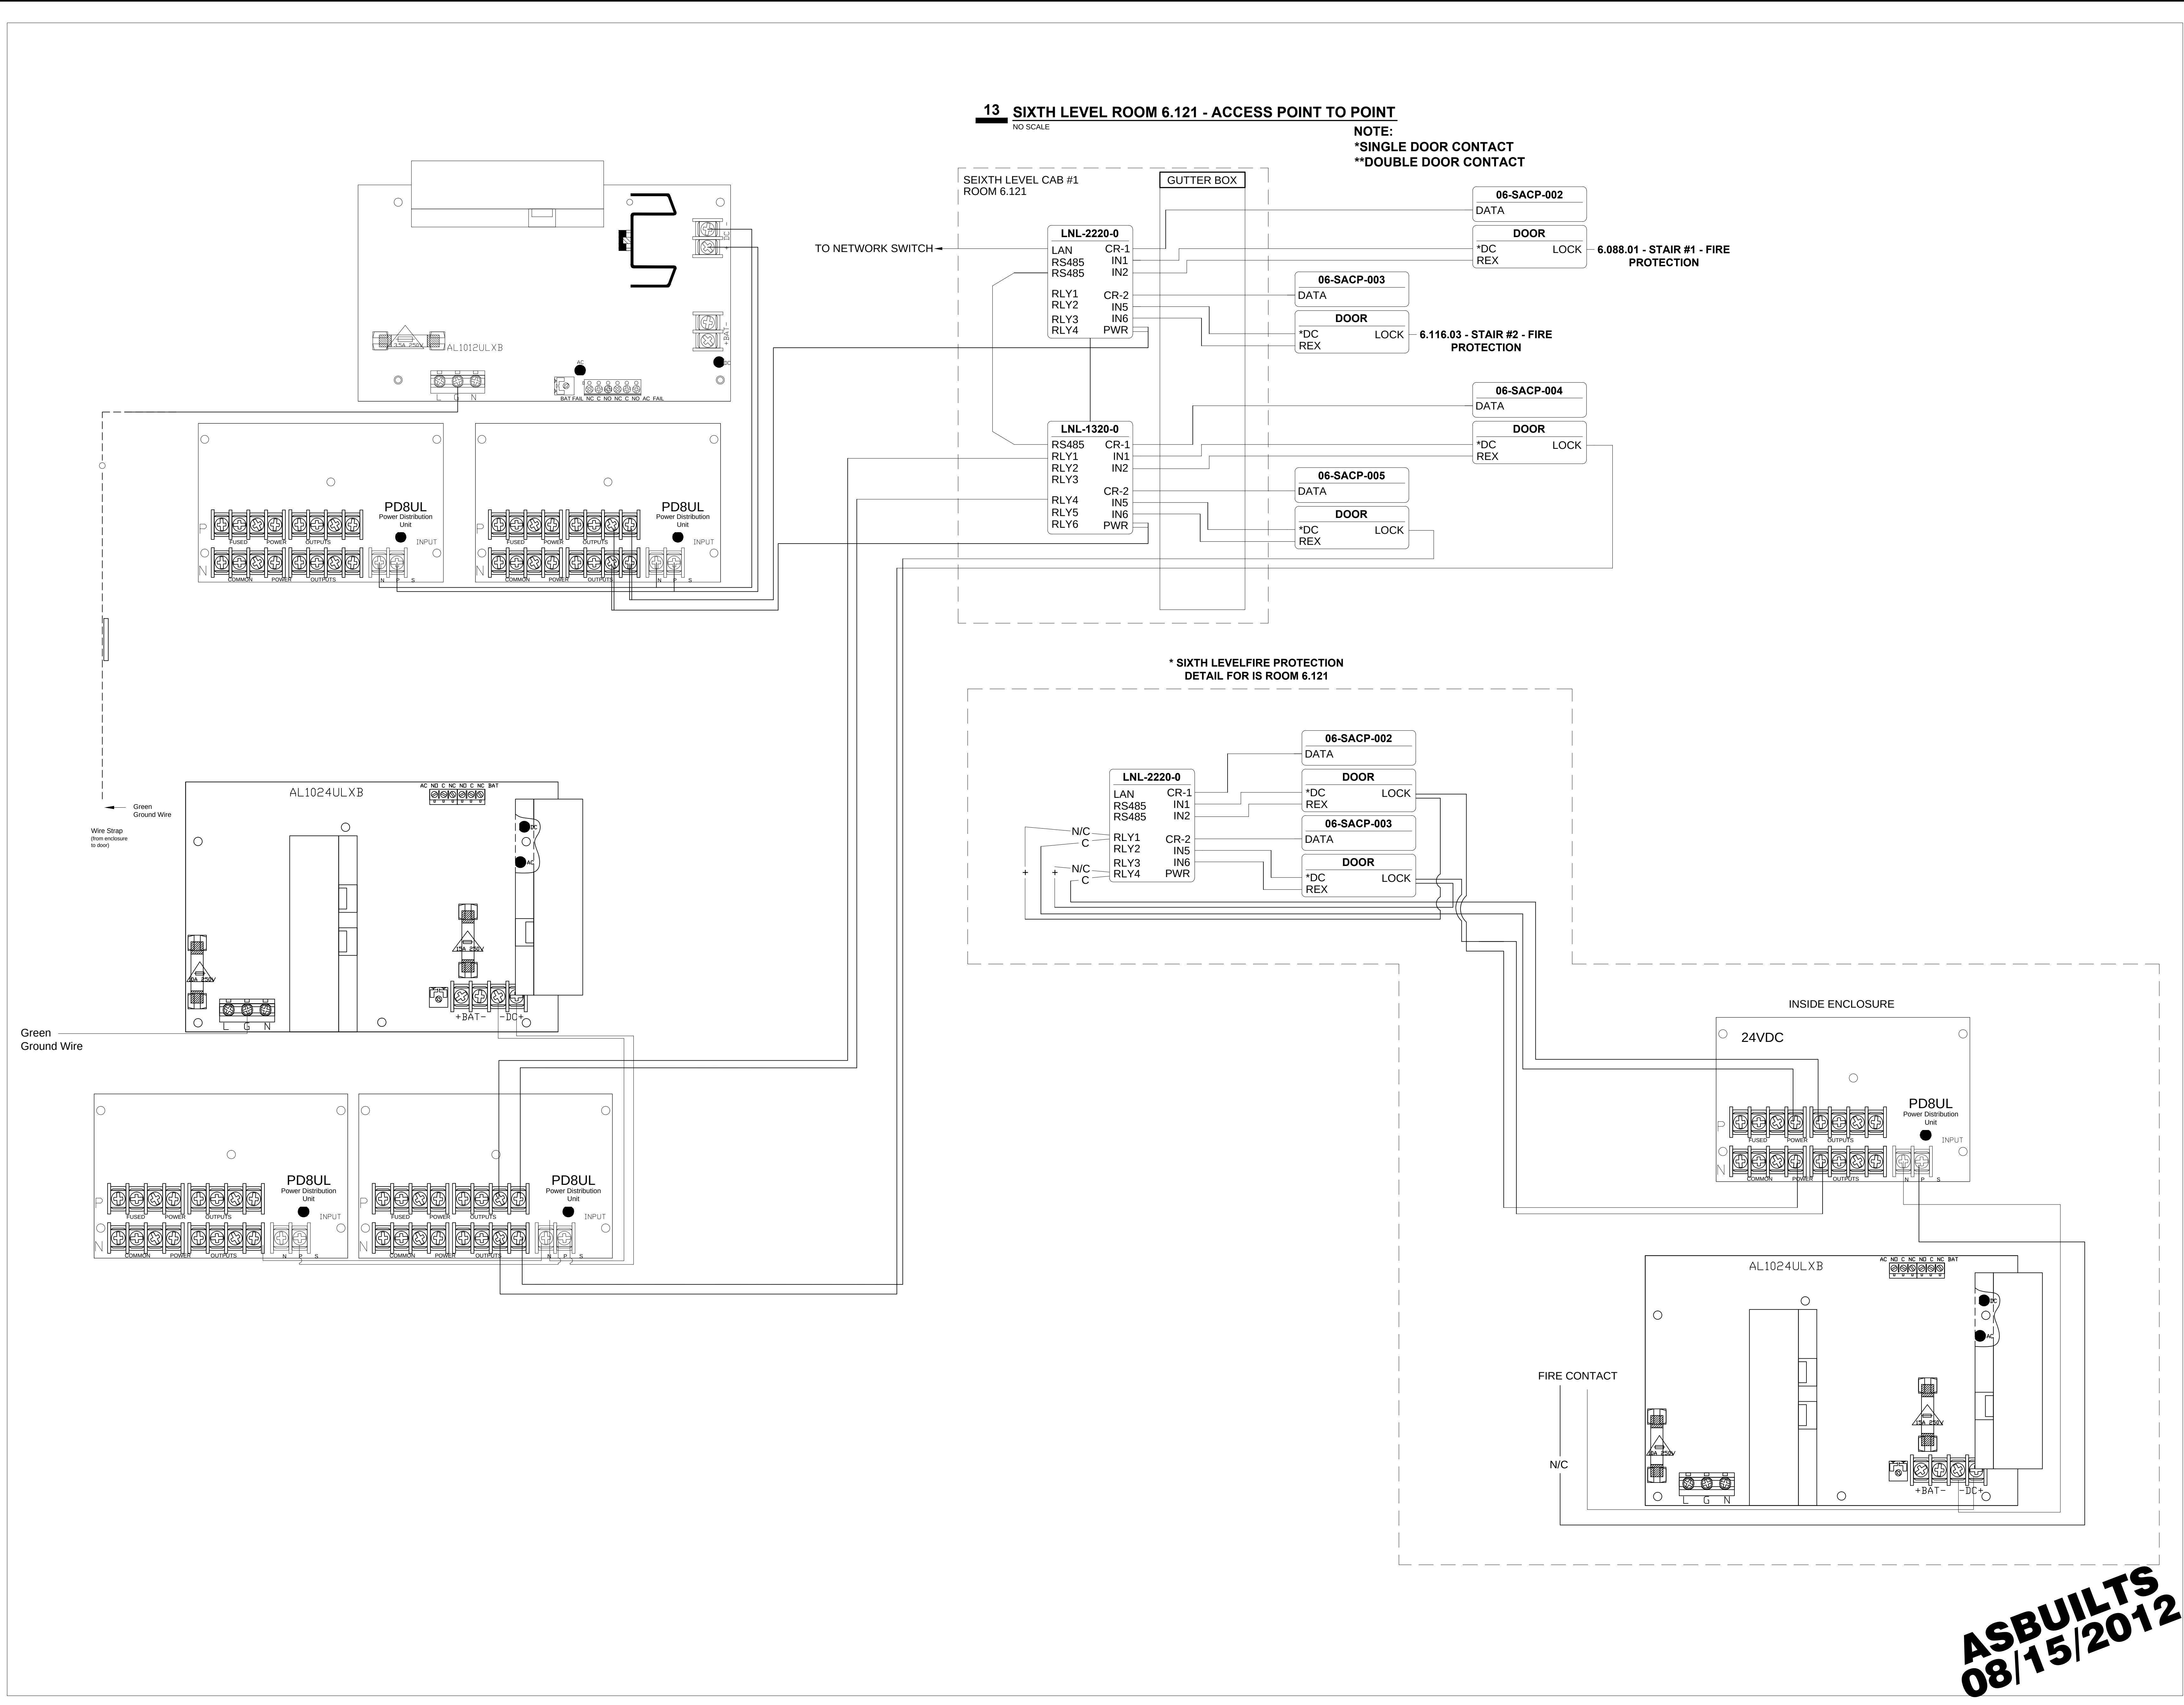

DRAWING PREPARED BY:



1511 E. ORANGETHORPE BLVD.
FULLERTON, CALIFORNIA 92831
714-525-4350 - o; 714-525-4386 - f
(c) Copyright 2012 KRATOS | HBE
All Rights Reserved.

**MUST BE SIGNED BY HBE
TO AUTHENTICATE CONTENT(S).
ALL DETAILS CHECKED FOR ACCURACY.**


SIGNATURE _____ DATE _____

HBE JOB #

CONFIDENTIAL

THE INFORMATION CONTAINED HERIN MAY
NOT BE USED OR REPRODUCED IN ANY
MANNER WITHOUT WRITTEN PERMISSION OF
KRATOS | HBE.

KEY PLAN

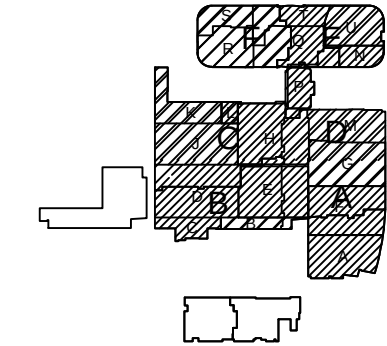

NO.	REV DESCRIPTION REV DATE	APPROVED BY
1.	AS BUILTS 08/15/2012	JOHN J. CHRISTIE

REV.	DESCRIPTION	APPROVED BY
------	-------------	-------------

CUSTOMER:




PROJECT:
**CHOC CHILDREN'S
HOSPITAL**
455 SOUTH MAIN ST.
ORANGE, CA 92668

DRAWING TITLE:
**SIXTH LEVEL ACCESS
CONTROL POINT TO POINT
DIAGRAM -RM 6.121**

DRN BY	DATE DRN	CHK BY	DATE CHK
JOSH G.	08/08/2012	JJC	
SCALE:	NTS		
DWG NO.	SE7.12		

14 SEVENTH LEVEL ROOM 7.103.02 - ACCESS POINT TO POINT
NO SCALE

NOTE:
*SINGLE DOOR CONTACT
**DOUBLE DOOR CONTACT

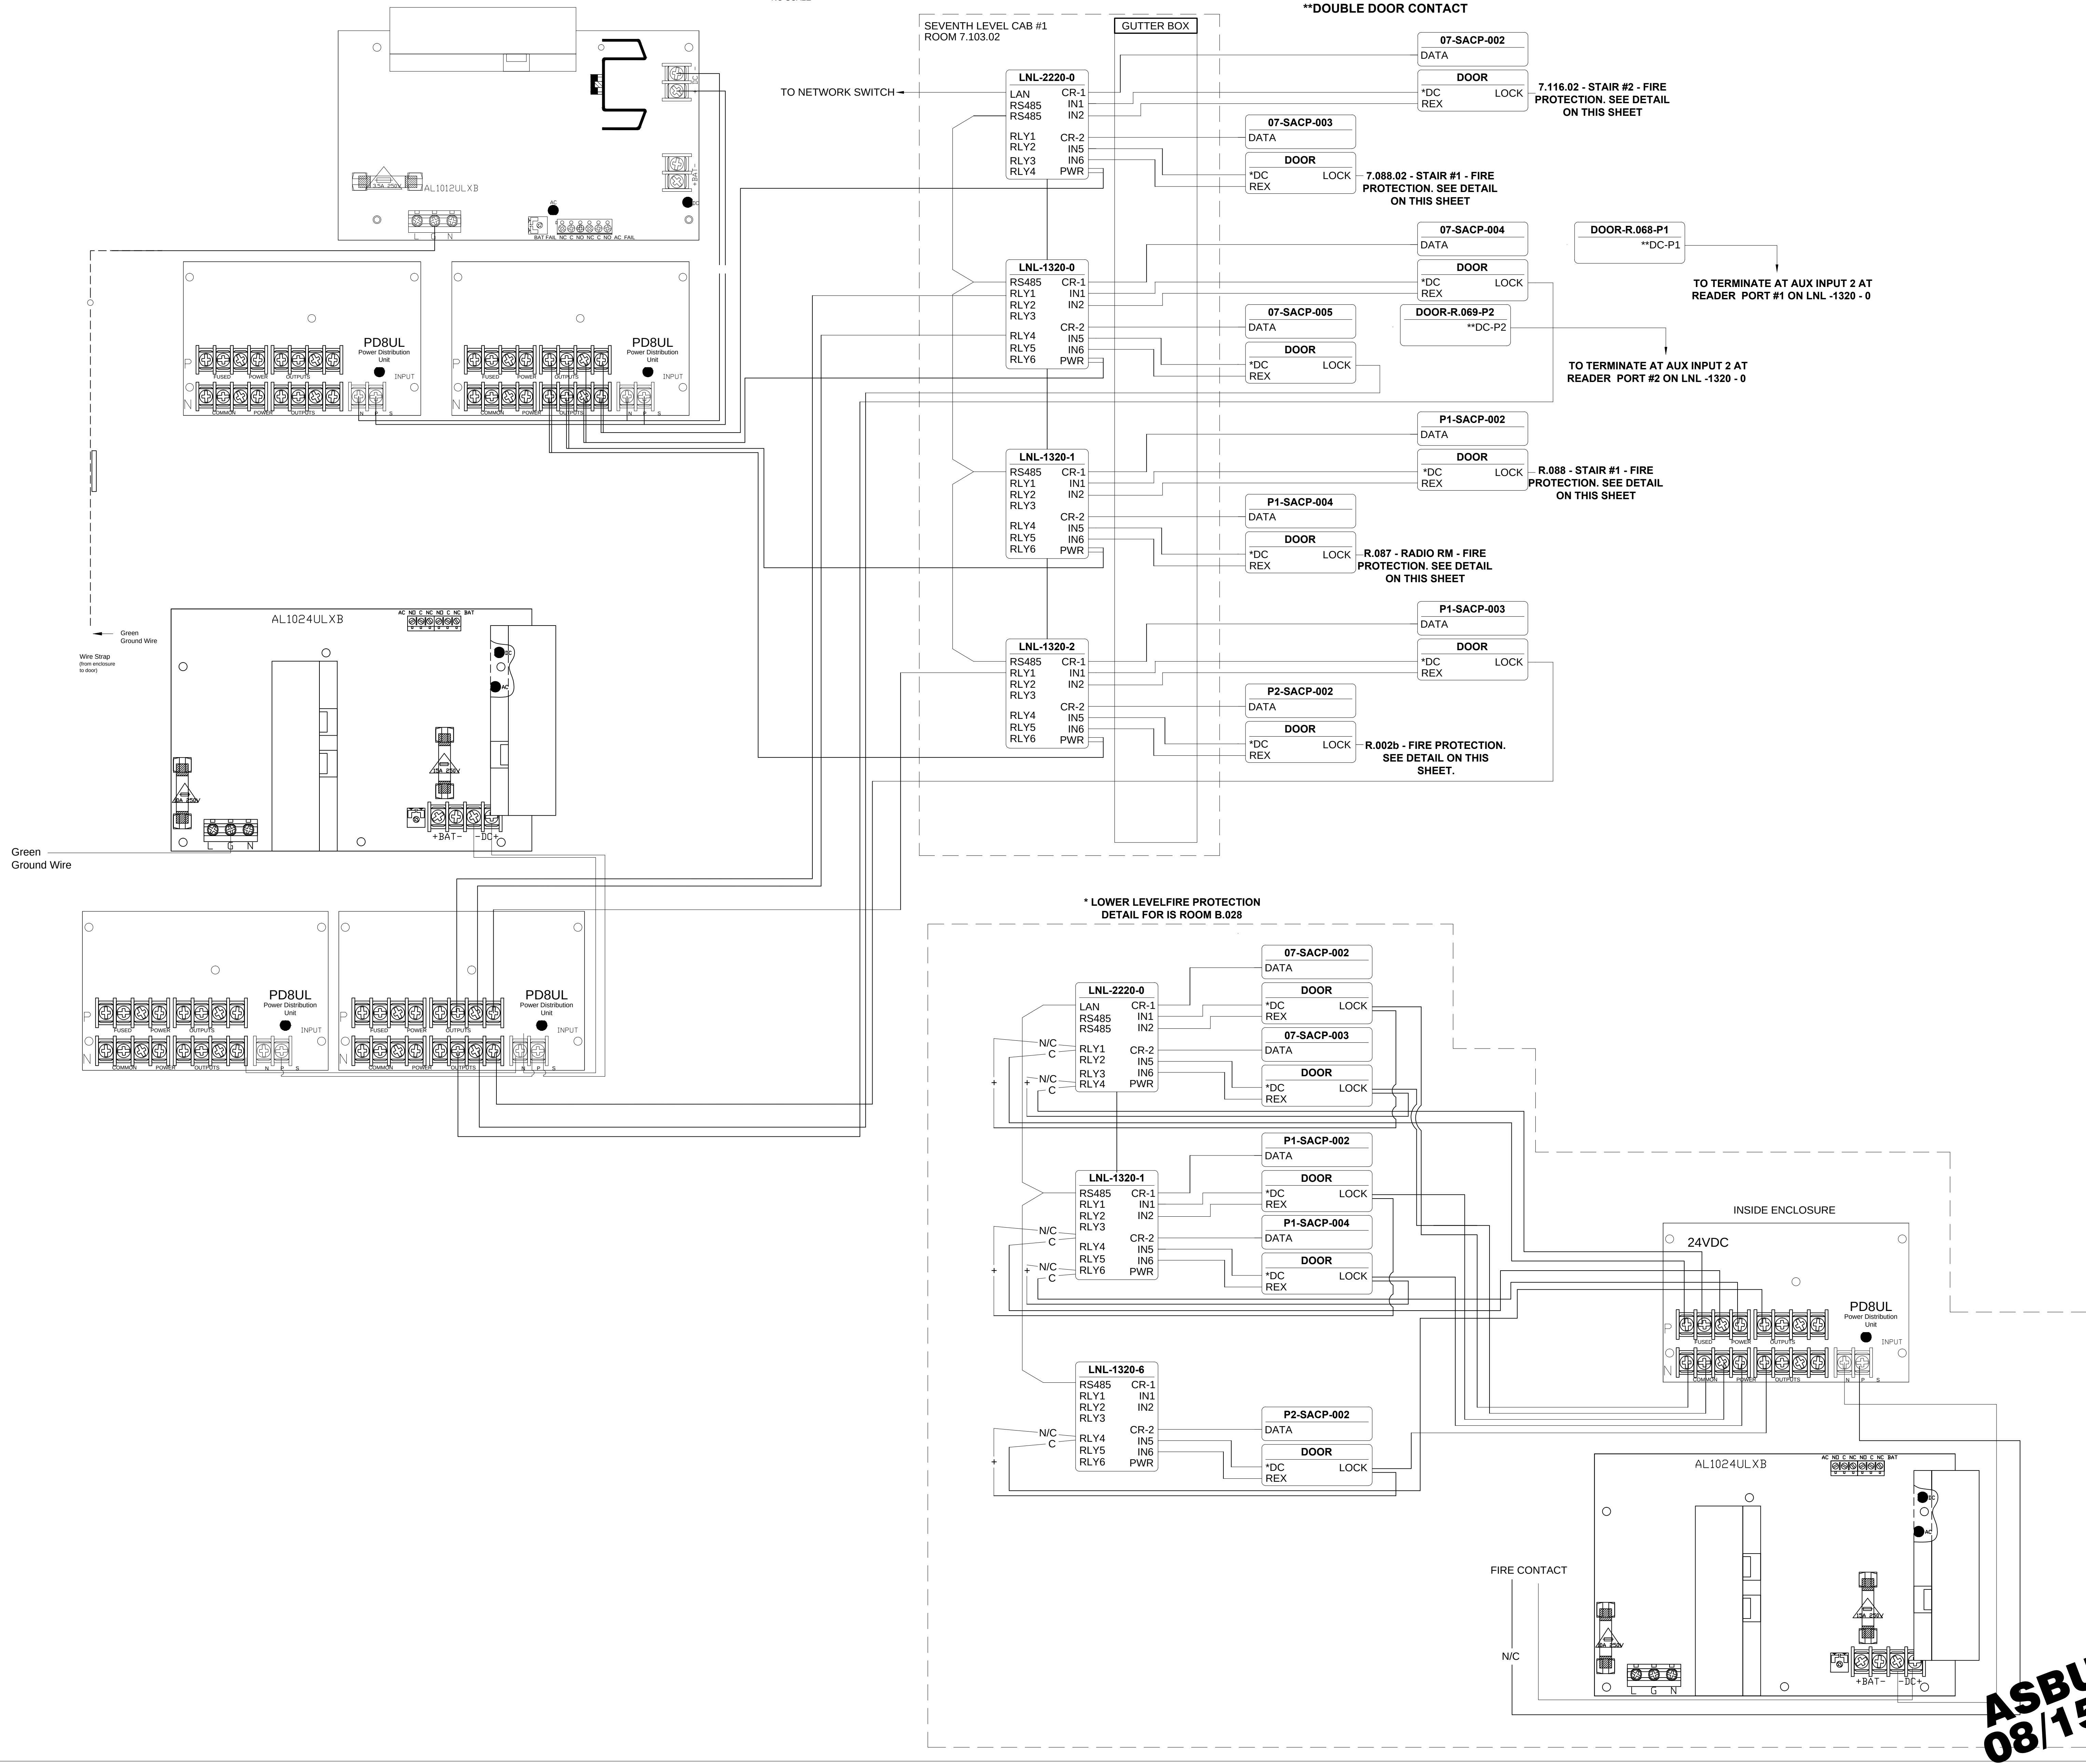

DRAWING PREPARED BY:

KRATOS
HBE

1511 E. ORANGETHORPE BLVD.
FULLERTON, CALIFORNIA 92831
714-525-4350 - o; 714-525-4386 - f
(c) Copyright 2012 KRATOS | HBE
All Rights Reserved.

MUST BE SIGNED BY HBE
TO AUTHENTICATE CONTENT(S).
ALL DETAILS CHECKED FOR ACCURACY.


SIGNATURE _____ DATE _____

HBE JOB # _____

CONFIDENTIAL

THE INFORMATION CONTAINED HEREIN MAY
NOT BE USED OR REPRODUCED IN ANY
MANNER WITHOUT WRITTEN PERMISSION OF
KRATOS | HBE.

KEY PLAN

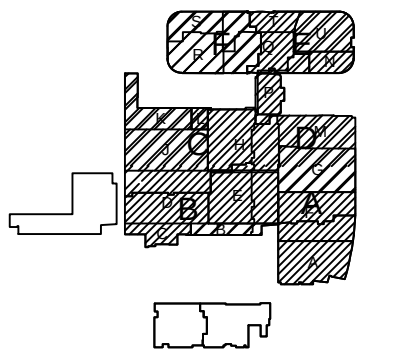

NO.	REV DESCRIPTION REV DATE	APPROVED BY
1.	AS BUILTS 08/15/2012	JOHN J. CHRISTIE

REV.	DESCRIPTION	APPROVED BY
------	-------------	-------------

CUSTOMER:

CHOC
Children's Hospital
of Orange County

PROJECT:
CHOC CHILDREN'S
HOSPITAL
455 SOUTH MAIN ST.
ORANGE, CA 92668

DRAWING TITLE:
SEVENTH LEVEL ACCESS
CONTROL POINT TO POINT
DIAGRAM - RM 7.103.02

DRN BY	DATE DRN	CHK BY	DATE CHK
JOSH G.	08/08/2012	JJC	
SCALE:	NTS		
DWG NO.	SE7.13		