

NO.	REVISION	DATE	BY
1	1ST (RFI#688)	11/03/10	KAS
2	2ND (RETURNED DWG)	5/17/11	KAS
3	UPDATED DWGS & RFI'S	10/20/11	KAS
4	4TH (RETURNED DWG)	02/24/12	KAS

NO.	FILE & FIELD	DATE	BY

GENERAL NOTES:

CORNER GUARD SYMBOL

MARK #
 104
 A1X
 CODE
 A REF. SECTION
 1 UNIT HEIGHT
 0 BASE HEIGHT/ELEV

COLOR/CODE	CODE	SECTION	UNIT HGT	BASE/ELEV	QTY
STAINLESS STEEL	F7b	F	4'-0"	N/A	3


REFERENCE MARK # X = SECTION IDENTIFICATION

1001 X
 9'

SCALED UNIT LENGTH

MATERIAL WILL BE FURNISHED IN STOCK LENGTHS TO BE FIELD CUT. MATERIAL QUANTITY SHALL BE BASED ON DIMENSIONS INDICATED AS SCALED UNIT LENGTH.

MATERIAL REQUIREMENTS				
COLOR/CODE	SECTION	MODEL	L/F REQUIRED	LINE TYPE
#253 PARCHMENT	J	HRB4C/SCR64M	81'-8"	HR/CR

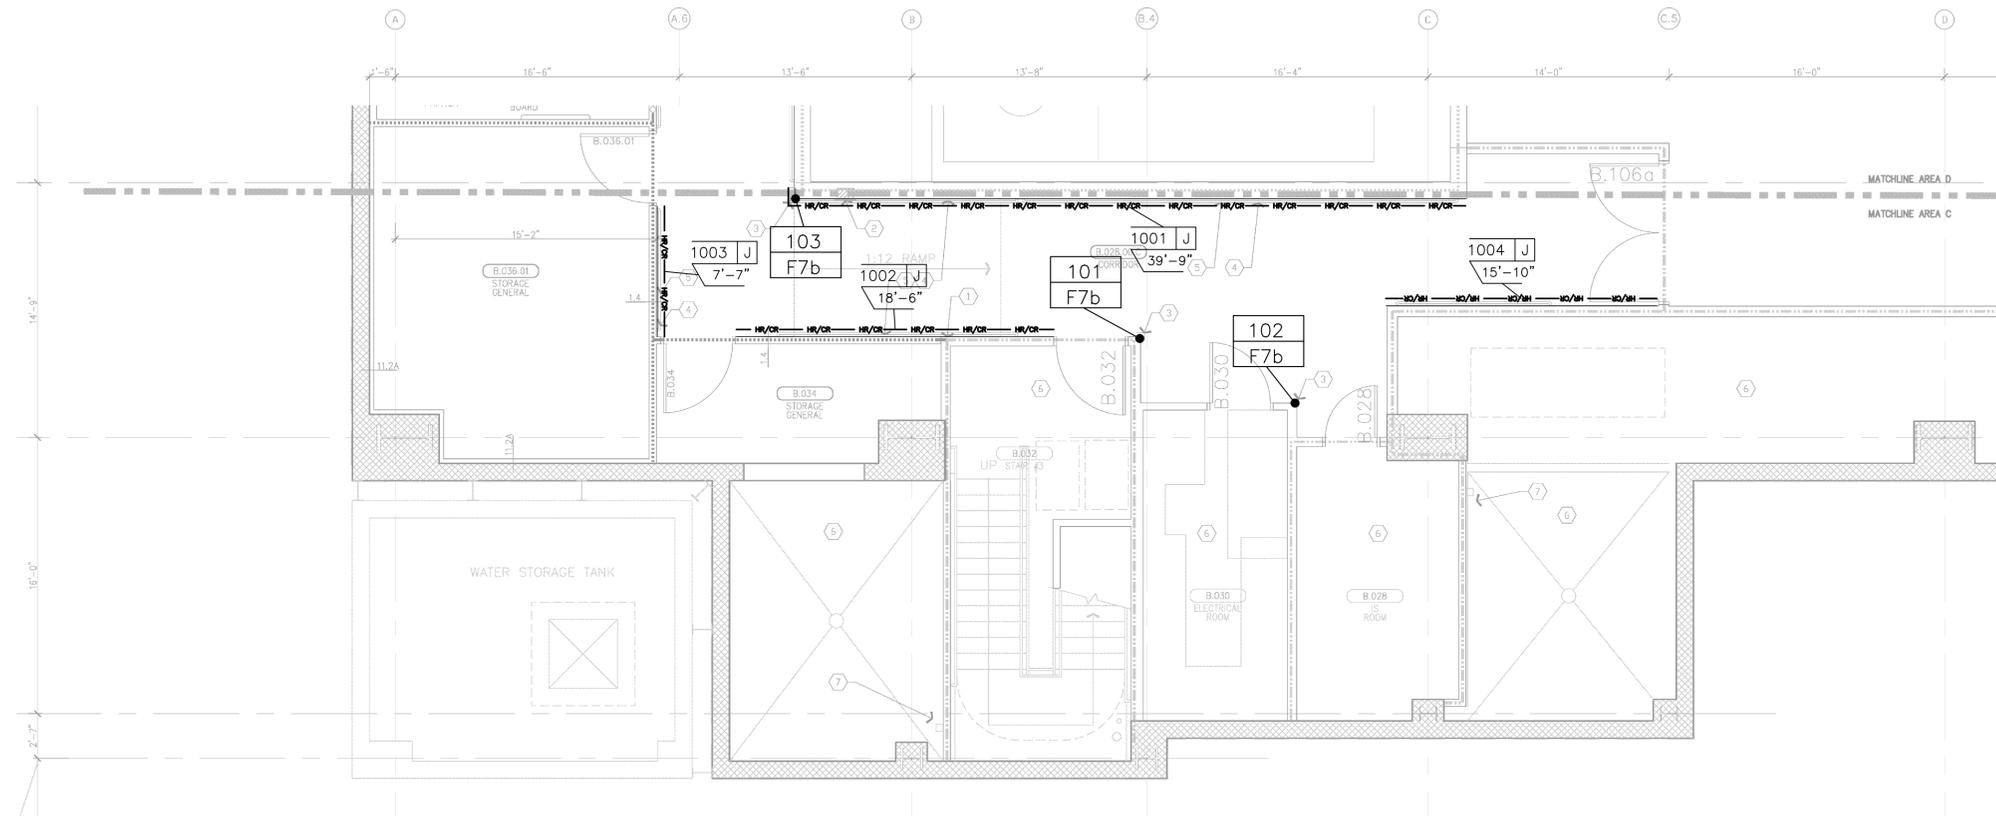

LOWER LEVEL AREA "C"
 ARCHITECTURAL DRAWING REFERENCED A3.0C DATED 05/28/2010 3/16" = 1'-0"

- MATERIAL LIST:
- A= SM20A
 - B= SSM25A
 - C= SM20M
 - D= NOT USED
 - E= NOT USED
 - F= CO8
 - G= SC08
 - H= CO8M
 - I= HRB-4C
 - J= HRB-4C/SCR64M
 - K= .060 WC @ 4'-0"
 - L= .060 WC @ FH

CS Construction Specialties
 6600 Route 405 Highway, Manly PA 17756
 (800) 233-6403 • Fax: (717) 546-6602 • www.c-s-group.com

This document is the property of Construction Specialties, Inc. and contains confidential proprietary information that is not to be disclosed to third parties and is not to be used without approval in writing from Construction Specialties, Inc.

PROJECT: CHILDREN'S HOSPITAL
 TOWER 2

JOB NO.: 759986

CUSTOMER: L2 SPECIALTIES INC.

REP: #111 IMC


DRAWN BY: KYLE SMITH

SCALE: 3/16" = 1'-0"

DATE: 07/16/2010

SHEET NO: 2

vised. No part of this document may be reproduced or utilized in any form without prior written authorization of FKP Architects, Inc.

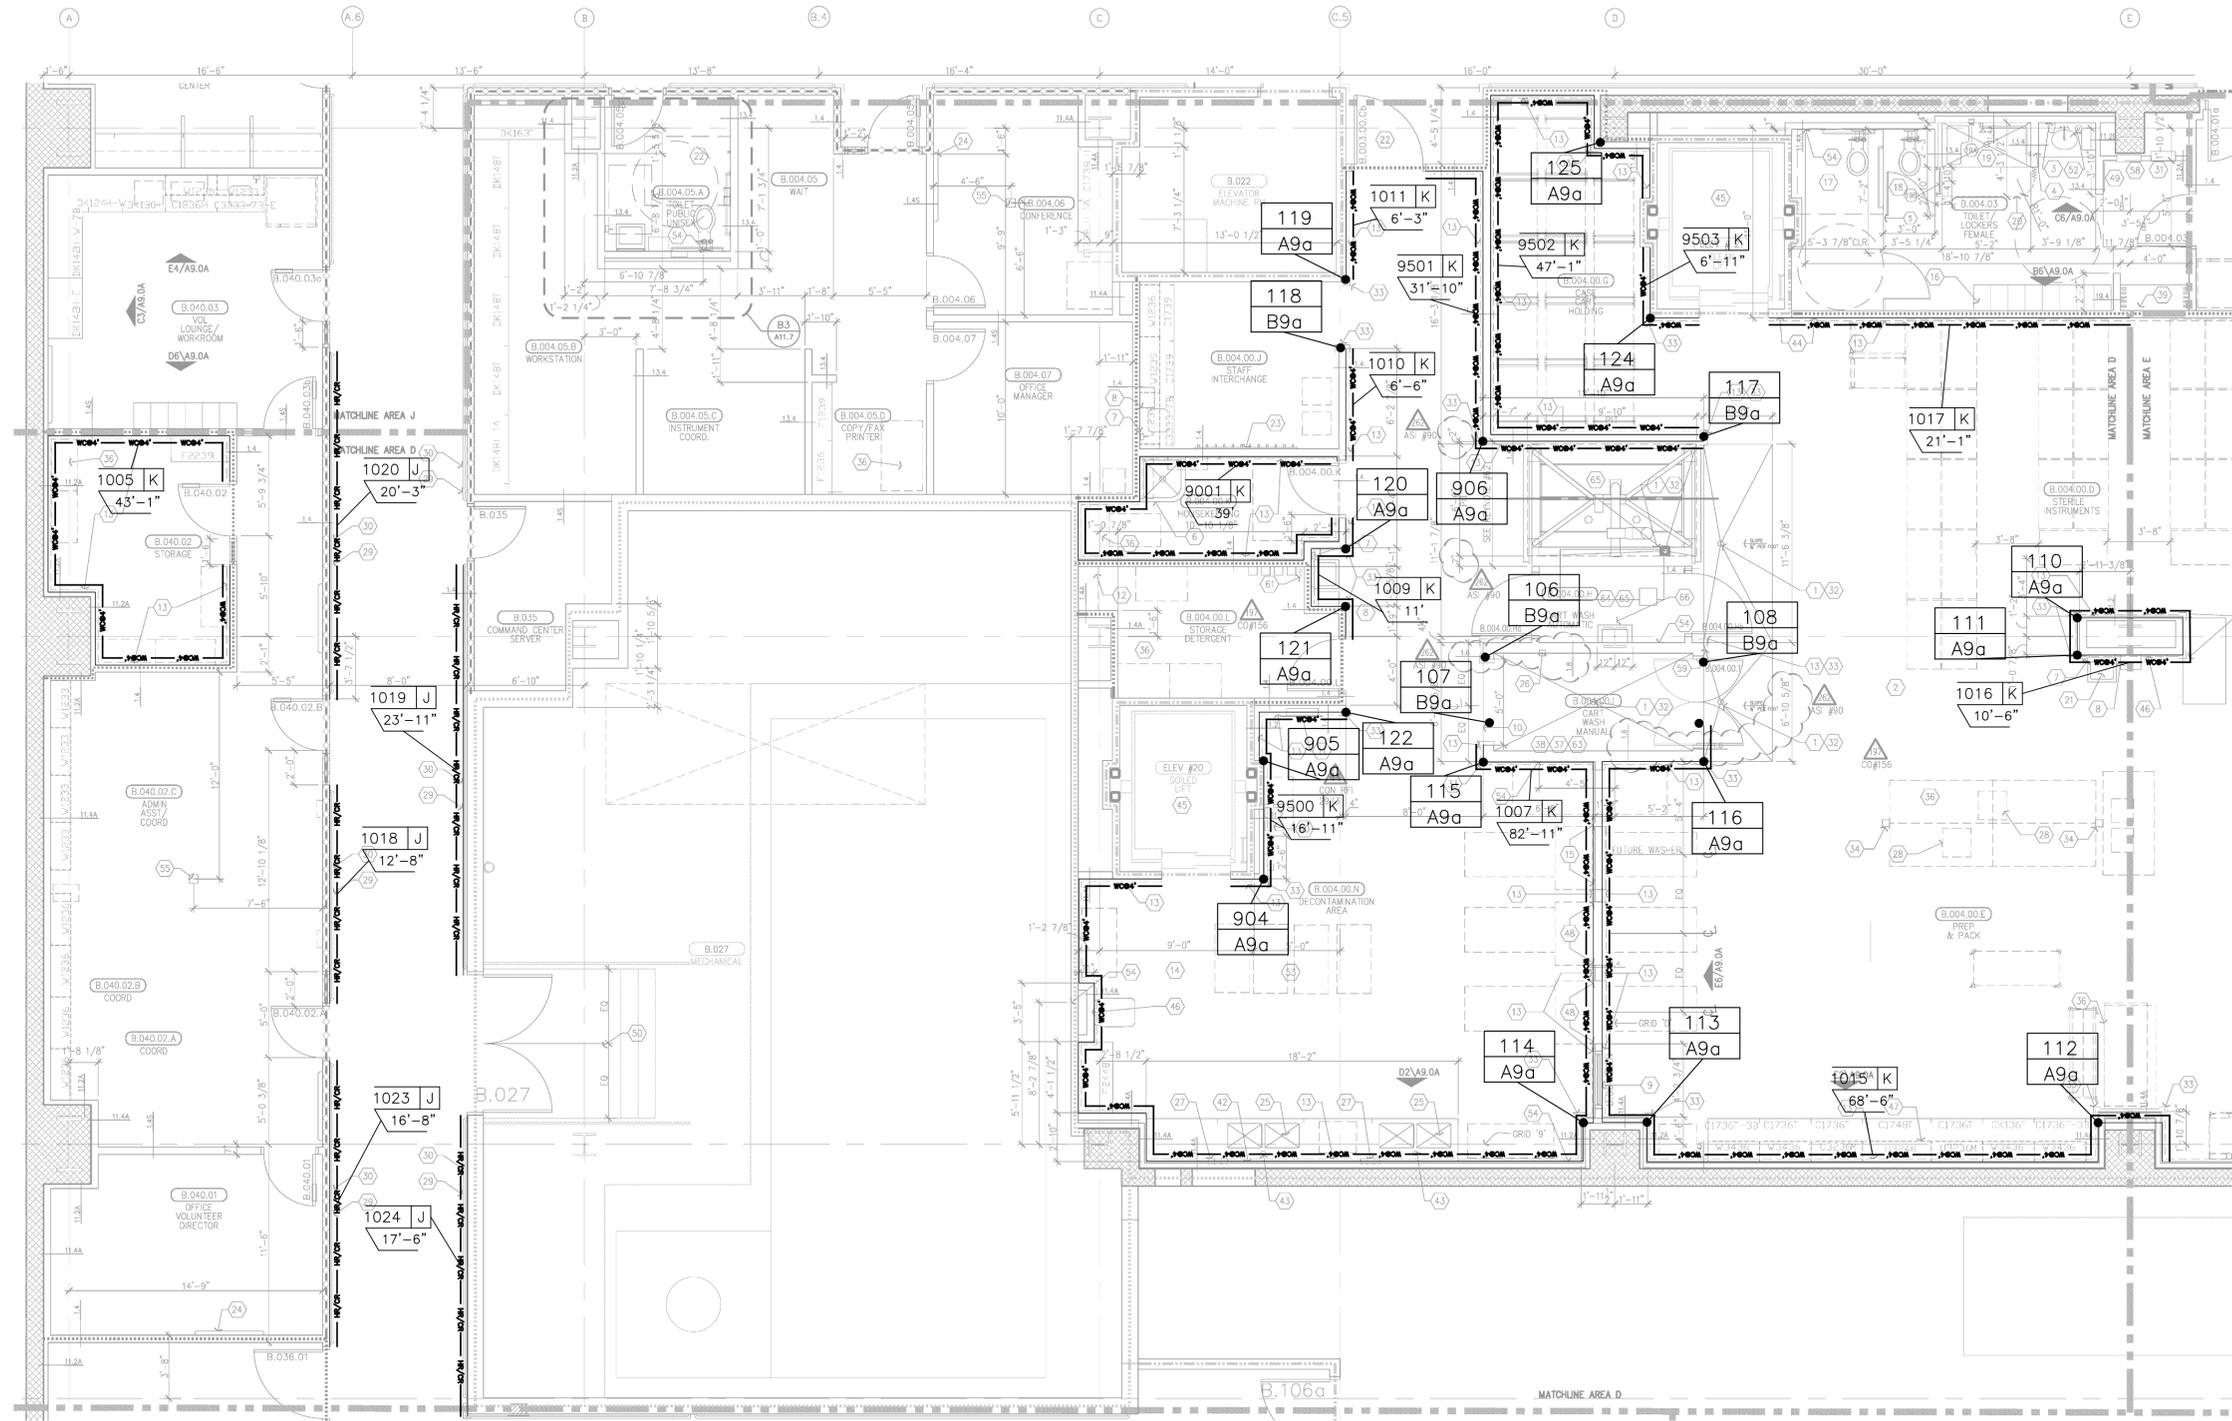

LOWER LEVEL AREA "D"
 ARCHITECTURAL DRAWING REFERENCED A3.0D DATED 05/20/2011 3/16" = 1'-0"

NO.	REVISION	DATE	BY
1	1ST (RFI#688)	11/03/10	KAS
2	2ND (RETURNED DWG)	5/17/11	KAS
3	UPDATED DWGS & RFIS	10/20/11	KAS
4	4TH (RETURNED DWG)	02/24/12	KAS


NO.	FILE & FIELD	DATE	BY

GENERAL NOTES:

CORNER GUARD SYMBOL

MARK #	A REF. SECTION
104	1 UNIT HEIGHT
104	BASE HEIGHT/ELEV

COLOR/CODE	SECTION	UNIT HGT	BASE/ELEV	QTY
#253 PARCHMENT	A9a	F	9'-0"	X 16
#253 PARCHMENT	B9a	G	9'-0"	X 5

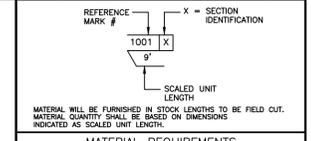

MATERIAL WILL BE FURNISHED IN STOCK LENGTHS TO BE FIELD CUT. MATERIAL QUANTITY SHALL BE BASED ON DIMENSIONS INDICATED AS SCALED UNIT LENGTHS.

MATERIAL REQUIREMENTS

COLOR/CODE	SECTION	MODEL	L/F REQUIRED	LINE TYPE
#253 PARCHMENT	J	HRB4C/SCR64M	91'-0"	HR/OR
#253 PARCHMENT	K	.040 WC @ 4'	352'-7"	WC/FH

- MATERIAL LIST:
- A= SM20A
 - B= SSM25A
 - C= SM20M
 - D= NOT USED
 - E= NOT USED
 - F= C08
 - G= SC08
 - H= C08M
 - I= HRB-4C
 - J= HRB-4C/SCR64M
 - K= .060 WC @ 4'-0"
 - L= .060 WC @ FH



This document is the property of Construction Specialties, Inc. and contains confidential proprietary information that is not to be disclosed to third parties and is not to be used without approval in writing from Construction Specialties, Inc.

PROJECT: CHILDREN'S HOSPITAL
 TOWER 2

JOB NO.: 759986

CUSTOMER: L2 SPECIALTIES INC.

REP: #111 IMC

DRAWN BY: KYLE SMITH

SCALE: 3/16" = 1'-0"

DATE: 07/16/2010

SHEET NO: 3

NO.	REVISION	DATE	BY
1	1ST (RFI#688)	11/03/10	KAS
2	2ND (RETURNED DWG)	5/17/11	KAS
3	UPDATED DWGS & RFIS	10/20/11	KAS
4	4TH (RETURNED DWG)	02/24/12	KAS

NO.	FILE & FIELD	DATE	BY

GENERAL NOTES:

CORNER GUARD SYMBOL
 MARK # A REF. SECTION
 CODE 1 UNIT HEIGHT
 o BASE HEIGHT/ELEV

COLOR/CODE	CODE	SECTION	UNIT HGT	BASE/ELEV	QTY
#253 PARCHMENT	A9a	A	9'-0"	N/A	10
STAINLESS STEEL	H7b	H	4'-0"	N/A	2

REFERENCE MARK # X = SECTION IDENTIFICATION
 1001 X
 9'
 SCALED UNIT LENGTH
 MATERIAL WILL BE FURNISHED IN STOCK LENGTHS TO BE FIELD CUT. MATERIAL QUANTITY SHALL BE BASED ON DIMENSIONS INDICATED AS SCALED UNIT LENGTH.

COLOR/CODE	SECTION	MODEL	L/F REQUIRED	LINE TYPE
#253 PARCHMENT	J	HRB4C/SCR64M	92'-3"	HR/OR
#253 PARCHMENT	K	.040 WC @ 4'-0"	188'-8"	WC/FH


- MATERIAL LIST:
- A= SM20A
 - B= SSM25A
 - C= SM20M
 - D= NOT USED
 - E= NOT USED
 - F= CO8
 - G= SCO8
 - H= CO8M
 - I= HRB-4C
 - J= HRB-4C/SCR64M
 - K= .060 WC @ 4'-0"
 - L= .060 WC @ FH

CS Construction Specialties
 6600 Ross 405 Highway, Manly PA 17756
 (903) 233-6400 • Fax: (903) 546-6002 • www.c-sgroup.com


This document is the property of Construction Specialties, Inc. and contains confidential proprietary information that is not to be disclosed to third parties and is not to be used without approval in writing from Construction Specialties, Inc.

PROJECT: CHILDREN'S HOSPITAL
 TOWER 2
 JOB NO.: 759986
 CUSTOMER: L2 SPECIALTIES INC.
 REP: #111 IMC
 DRAWN BY: KYLE SMITH
 SCALE: 3/16" = 1'-0"
 DATE: 07/16/2010
 SHEET NO: 4

no part of this document may be reproduced or utilized in any form without prior written authorization of FKP Architects, Inc.

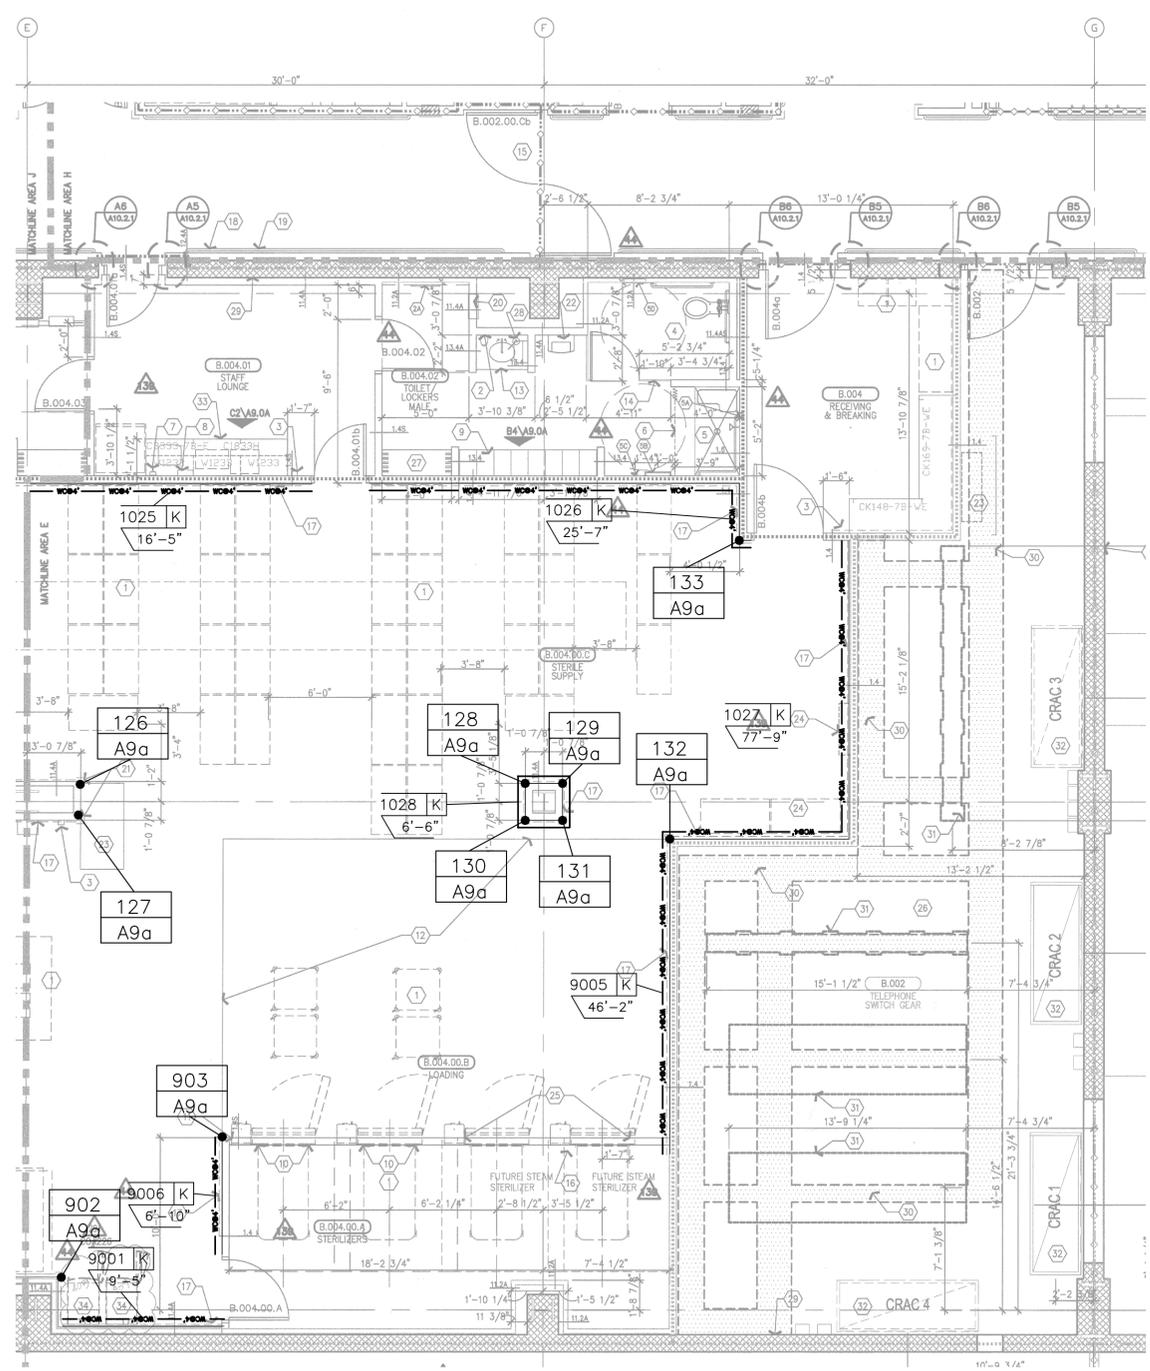


LOWER LEVEL AREA "E"
 ARCHITECTURAL DRAWING REFERENCED A3.0E DATED 07/18/2011 3/16" = 1'-0"

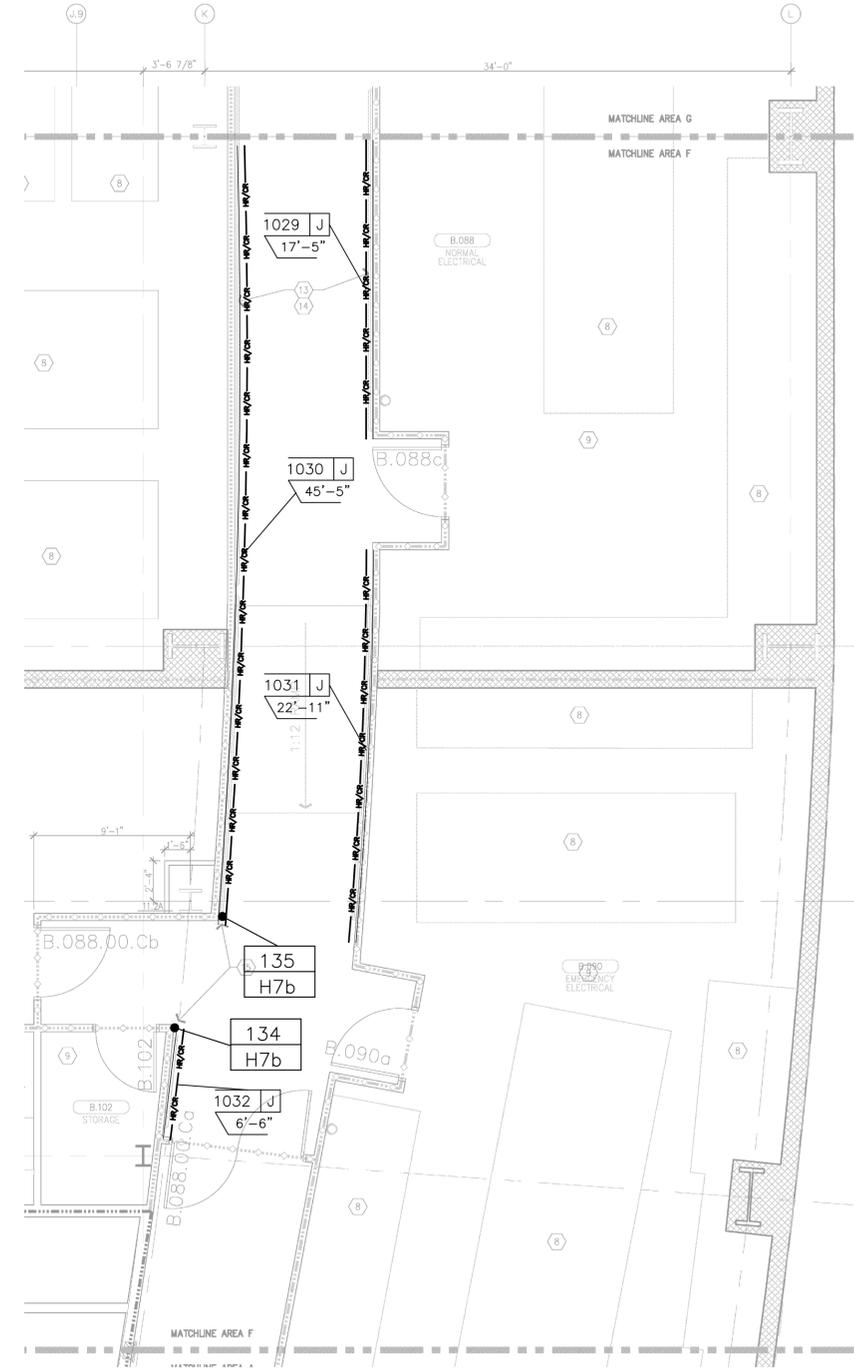

LOWER LEVEL AREA "F"
 ARCHITECTURAL DRAWING REFERENCED A3.0F DATED 05/28/2010 3/16" = 1'-0"

no part of this document may be reproduced or utilized in any form without prior written authorization of FKP Architects, Inc.

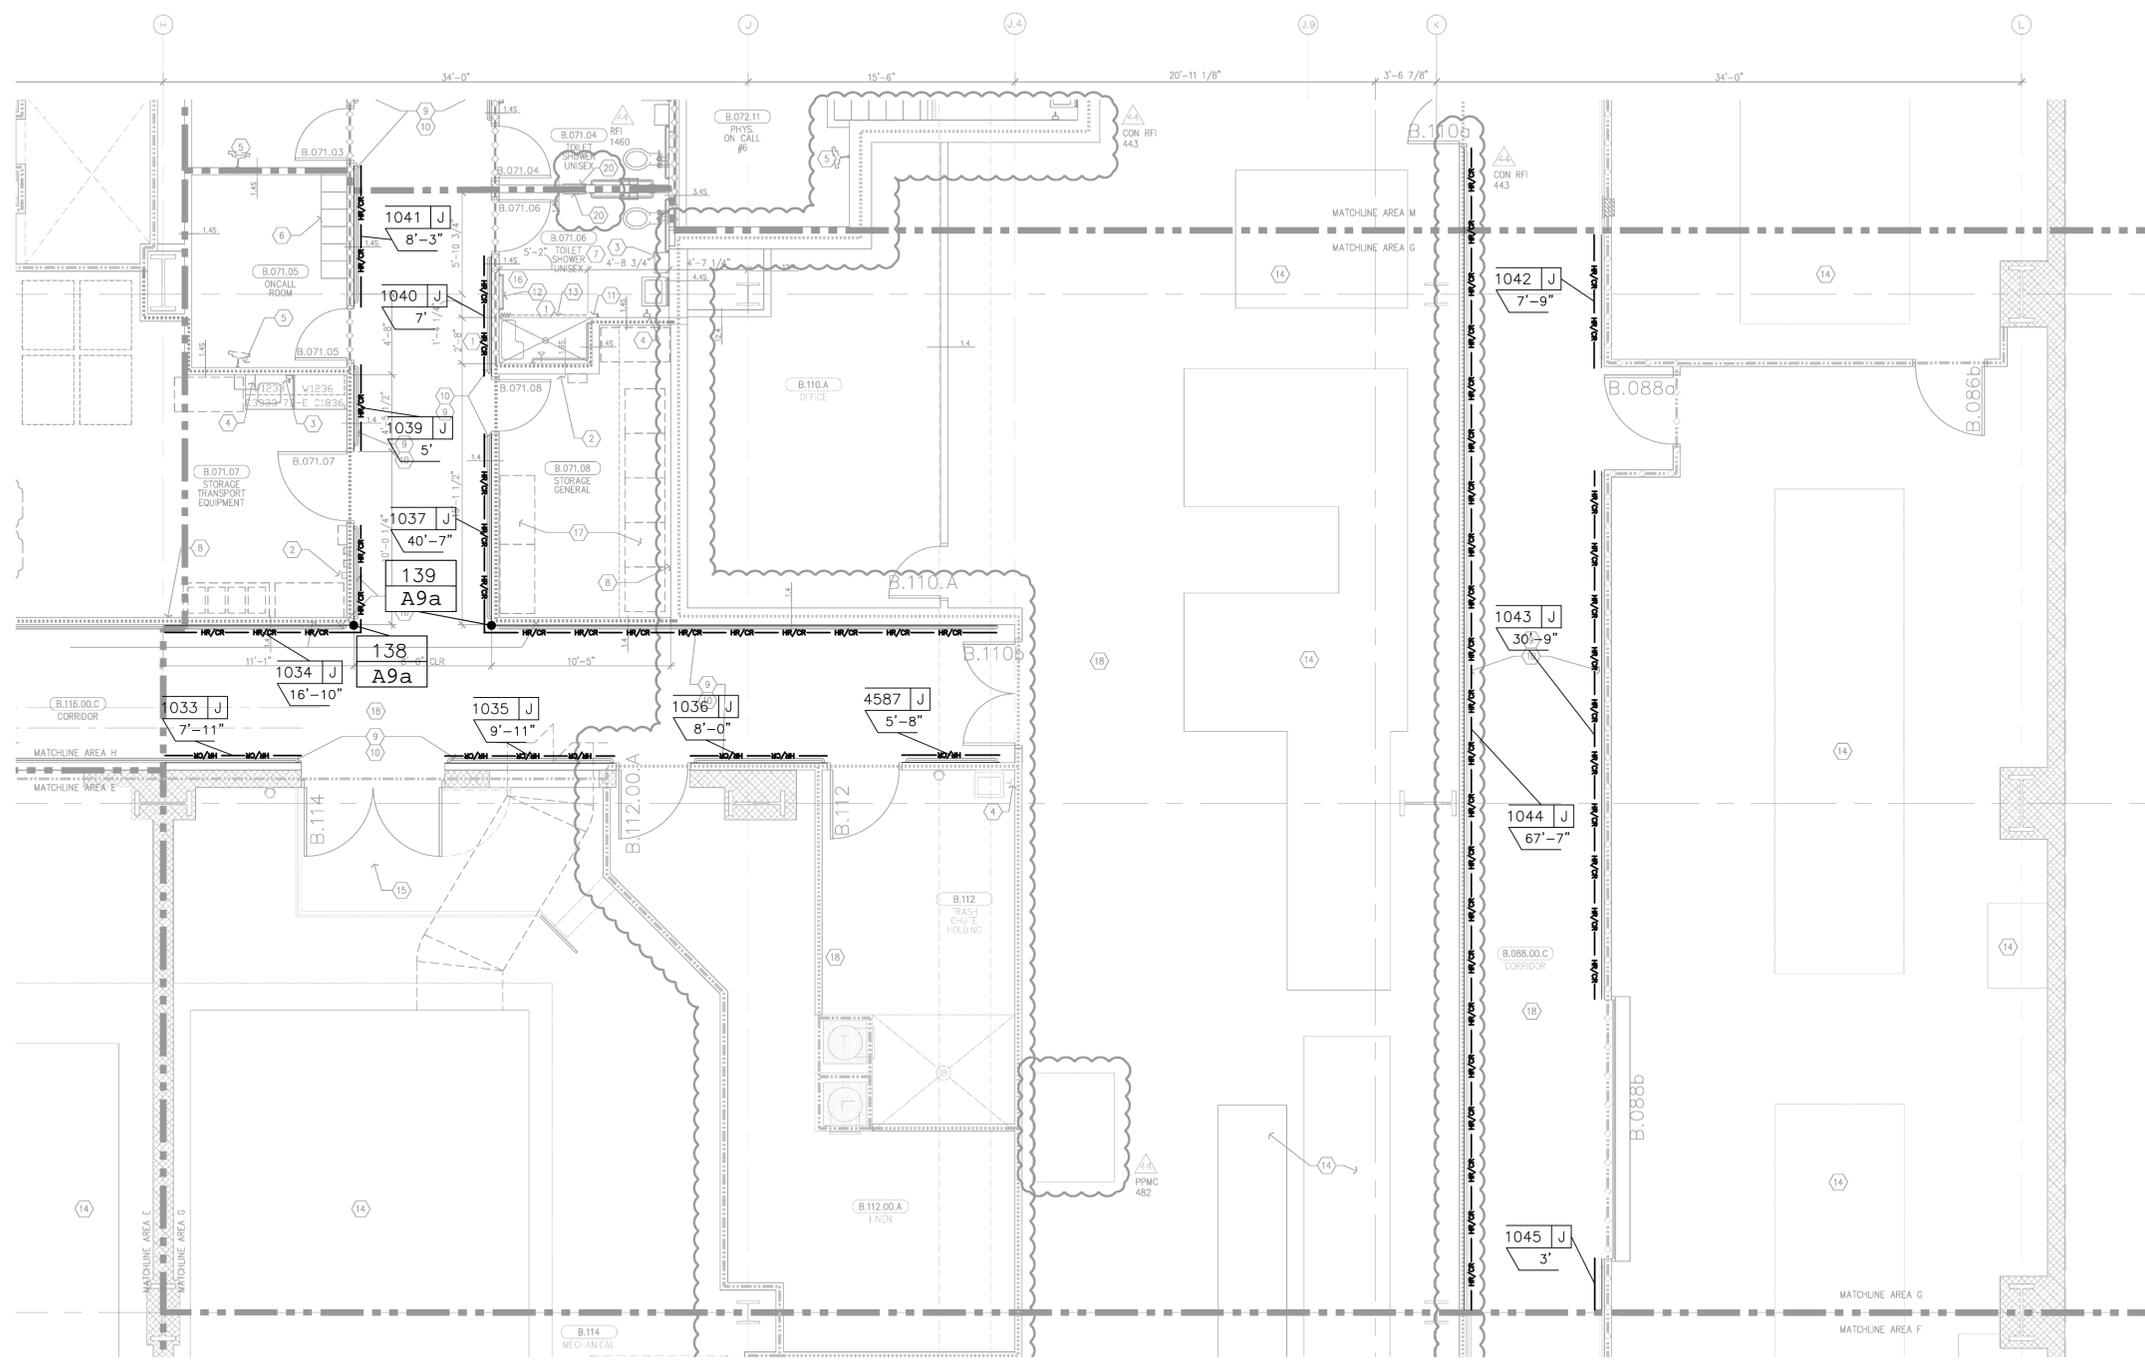

LOWER LEVEL AREA "G"
 ARCHITECTURAL DRAWING REFERENCED A3.DG DATED 05/28/2010 3/16" = 1'-0"


NO.	REVISION	DATE	BY
1	1ST (RFI#688)	11/03/10	KAS
2	2ND (RETURNED DWG)	5/17/11	KAS
3	UPDATED DWGS & RFI'S	10/20/11	KAS
4	4TH (RETURNED DWG)	02/24/12	KAS

NO.	FILE & FIELD	DATE	BY

GENERAL NOTES:

CORNER GUARD SYMBOL
 MARK # A REF. SECTION
 CODE 1 UNIT HEIGHT
 BASE HEIGHT/ELEV

COLOR/CODE	CODE	SECTION	UNIT HGT	BASE/ELEV	QTY
#253 PARCHMENT	A9a	A	9'-0"	N/A	2

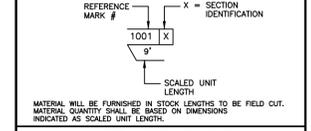

MATERIAL REQUIREMENTS


COLOR/CODE	SECTION	MODEL	L/F REQUIRED	LINE TYPE
#253 PARCHMENT	J	HRB4C/SCR64M	218'-3"	HR/CR

- MATERIAL LIST:
- A= SM20A
 - B= SSM25A
 - C= SM20M
 - D= NOT USED
 - E= NOT USED
 - F= CO8
 - G= SCO8
 - H= CO8M
 - I= HRB-4C
 - J= HRB-4C/SCR64M
 - K= .060 WC @ 4'-0"
 - L= .060 WC @ FH




This document is the property of Construction Specialties, Inc. and contains confidential proprietary information that is not to be disclosed to third parties and is not to be used without approval in writing from Construction Specialties, Inc.

PROJECT: CHILDREN'S HOSPITAL TOWER 2
 JOB NO.: 759986
 CUSTOMER: L2 SPECIALTIES INC.
 REP: #111 IMC
 DRAWN BY: KYLE SMITH
 SCALE: 3/16" = 1'-0"
 DATE: 07/16/2010
 SHEET NO: 5

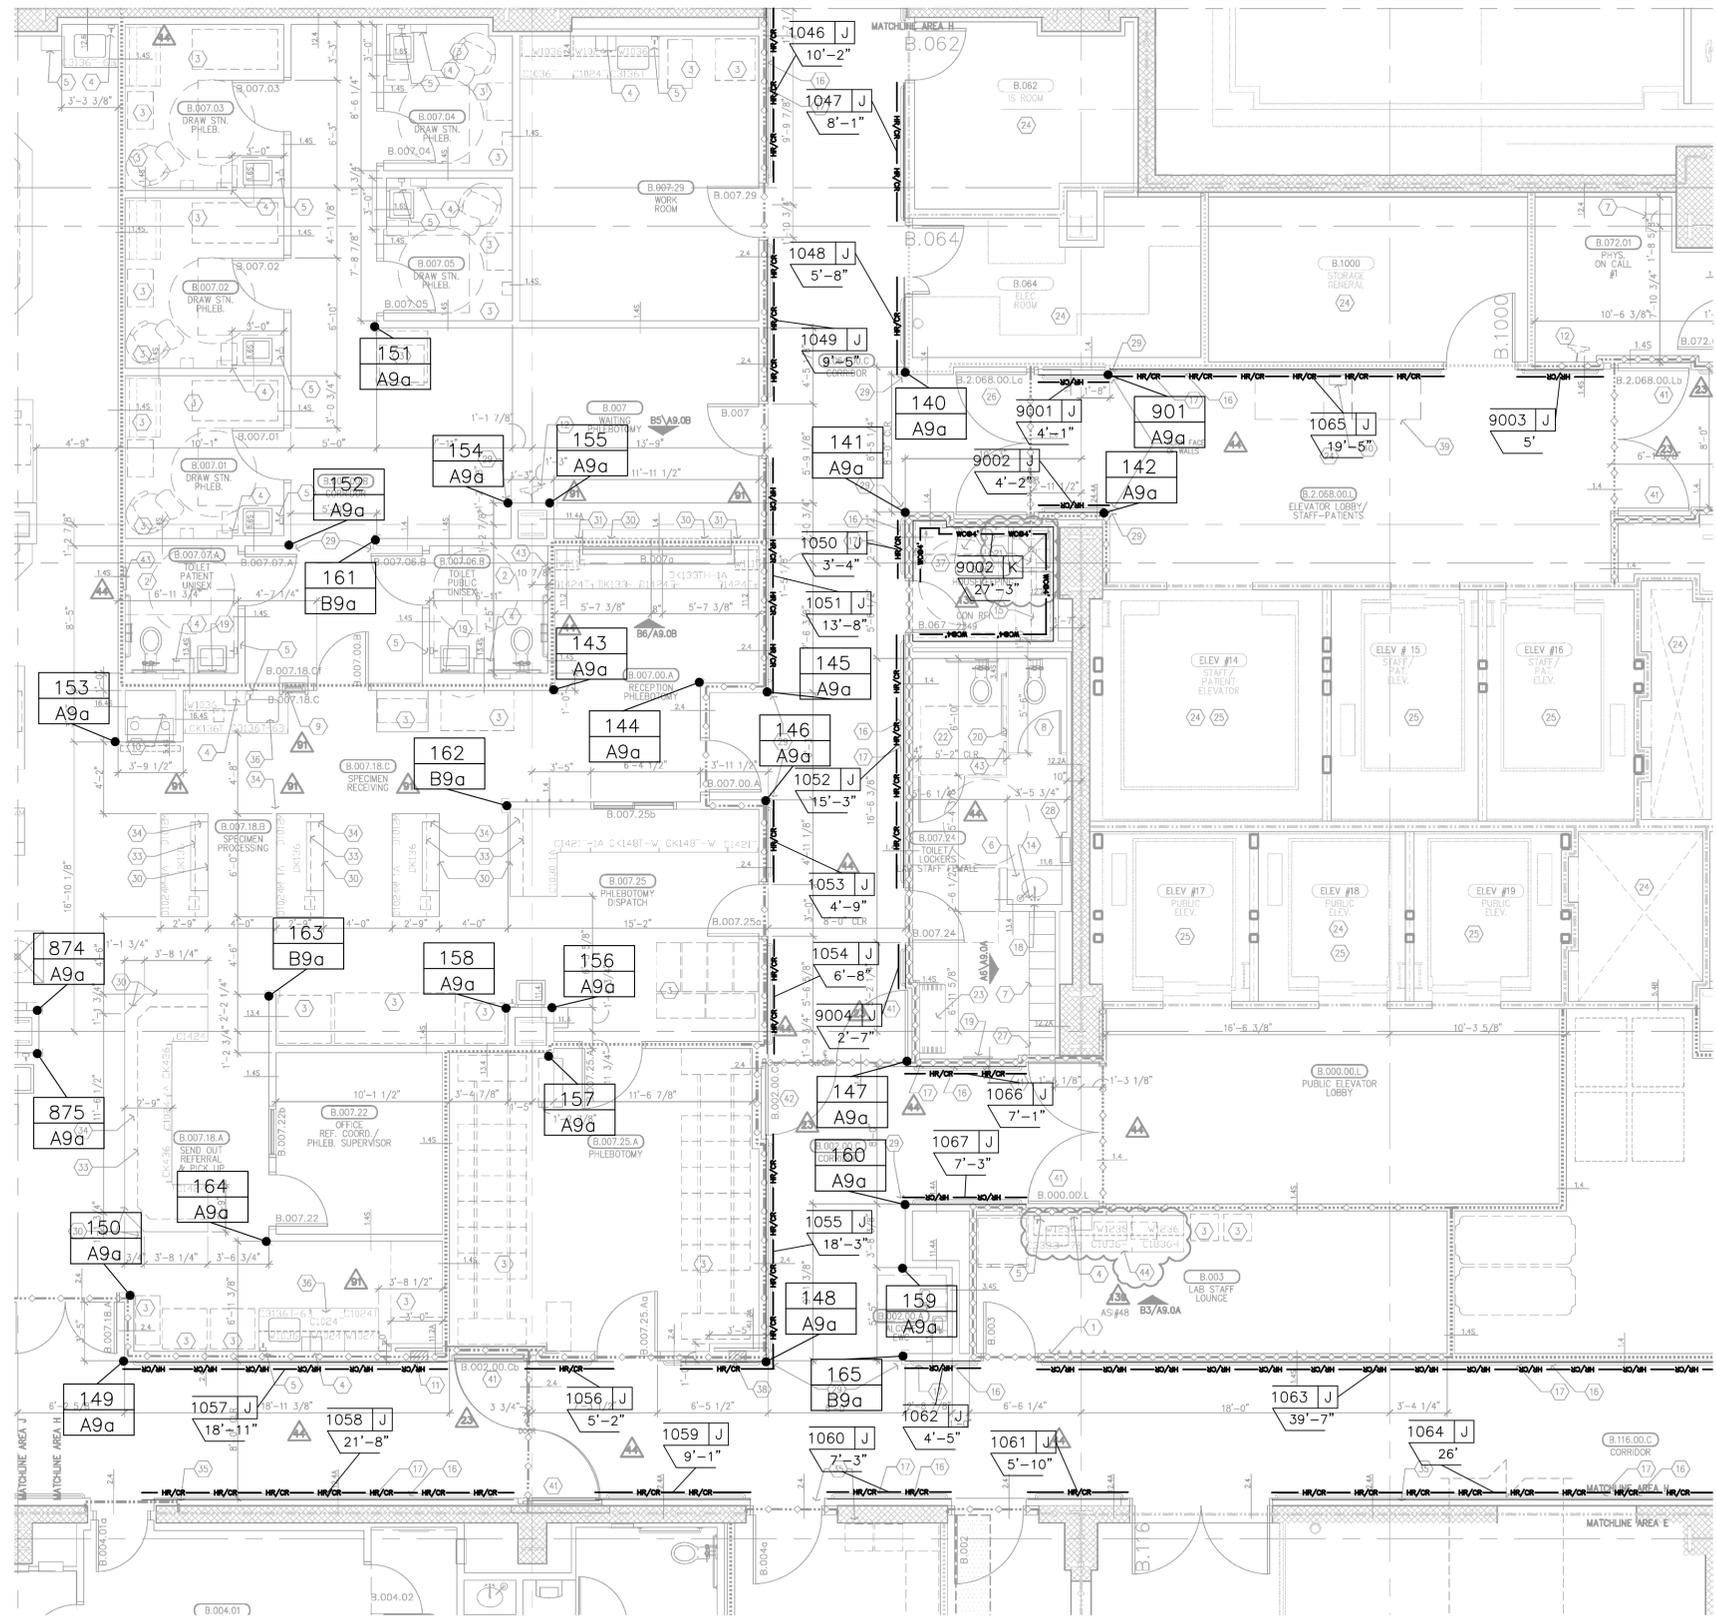


NO.	REVISION	DATE	BY
1	1ST (RFI#688)	11/03/10	KAS
2	2ND (RETURNED DWG)	5/17/11	KAS
3	UPDATED DWGS & RFIS	10/20/11	KAS
4	4TH (RETURNED DWG)	02/24/12	KAS

 GENERAL NOTES:



COLOR/CODE	SECTION	UNIT HGT	BASE/ELEV	QTY
#253 PARCHMENT	A9a	9'-0"	N/A	25
#253 PARCHMENT	B9a	9'-0"	N/A	4

 

MATERIAL REQUIREMENTS

COLOR/CODE	SECTION	MODEL	L/F REQUIRED	LINE TYPE
#253 PARCHMENT	J	HRB4C/SCR64M	282'-9"	HR/CR
#253 PARCHMENT	K	.060 WC @ 4'-0"	27'-3"	WC/FH

- MATERIAL LIST:
- A= SM20A
 - B= SSM25A
 - C= SM20M
 - D= NOT USED
 - E= NOT USED
 - F= CO8
 - G= SC08
 - H= CO8M
 - I= HRB-4C
 - J= HRB-4C/SCR64M
 - K= .060 WC @ 4'-0"
 - L= .060 WC @ FH



This document is the property of Construction Specialties, Inc. and contains confidential proprietary information that is not to be disclosed to third parties and is not to be used without approval in writing from Construction Specialties, Inc.

PROJECT: CHILDREN'S HOSPITAL
TOWER 2

JOB NO.: 759986

CUSTOMER: L2 SPECIALTIES INC.

REP: #111 IMC


DRAWN BY: KYLE SMITH

SCALE: 3/16" = 1'-0"

DATE: 07/16/2010

SHEET NO: 6

LOWER LEVEL AREA "H"
ARCHITECTURAL DRAWING REFERENCED A3.0H DATED 12/01/2010 3/16" = 1'-0"

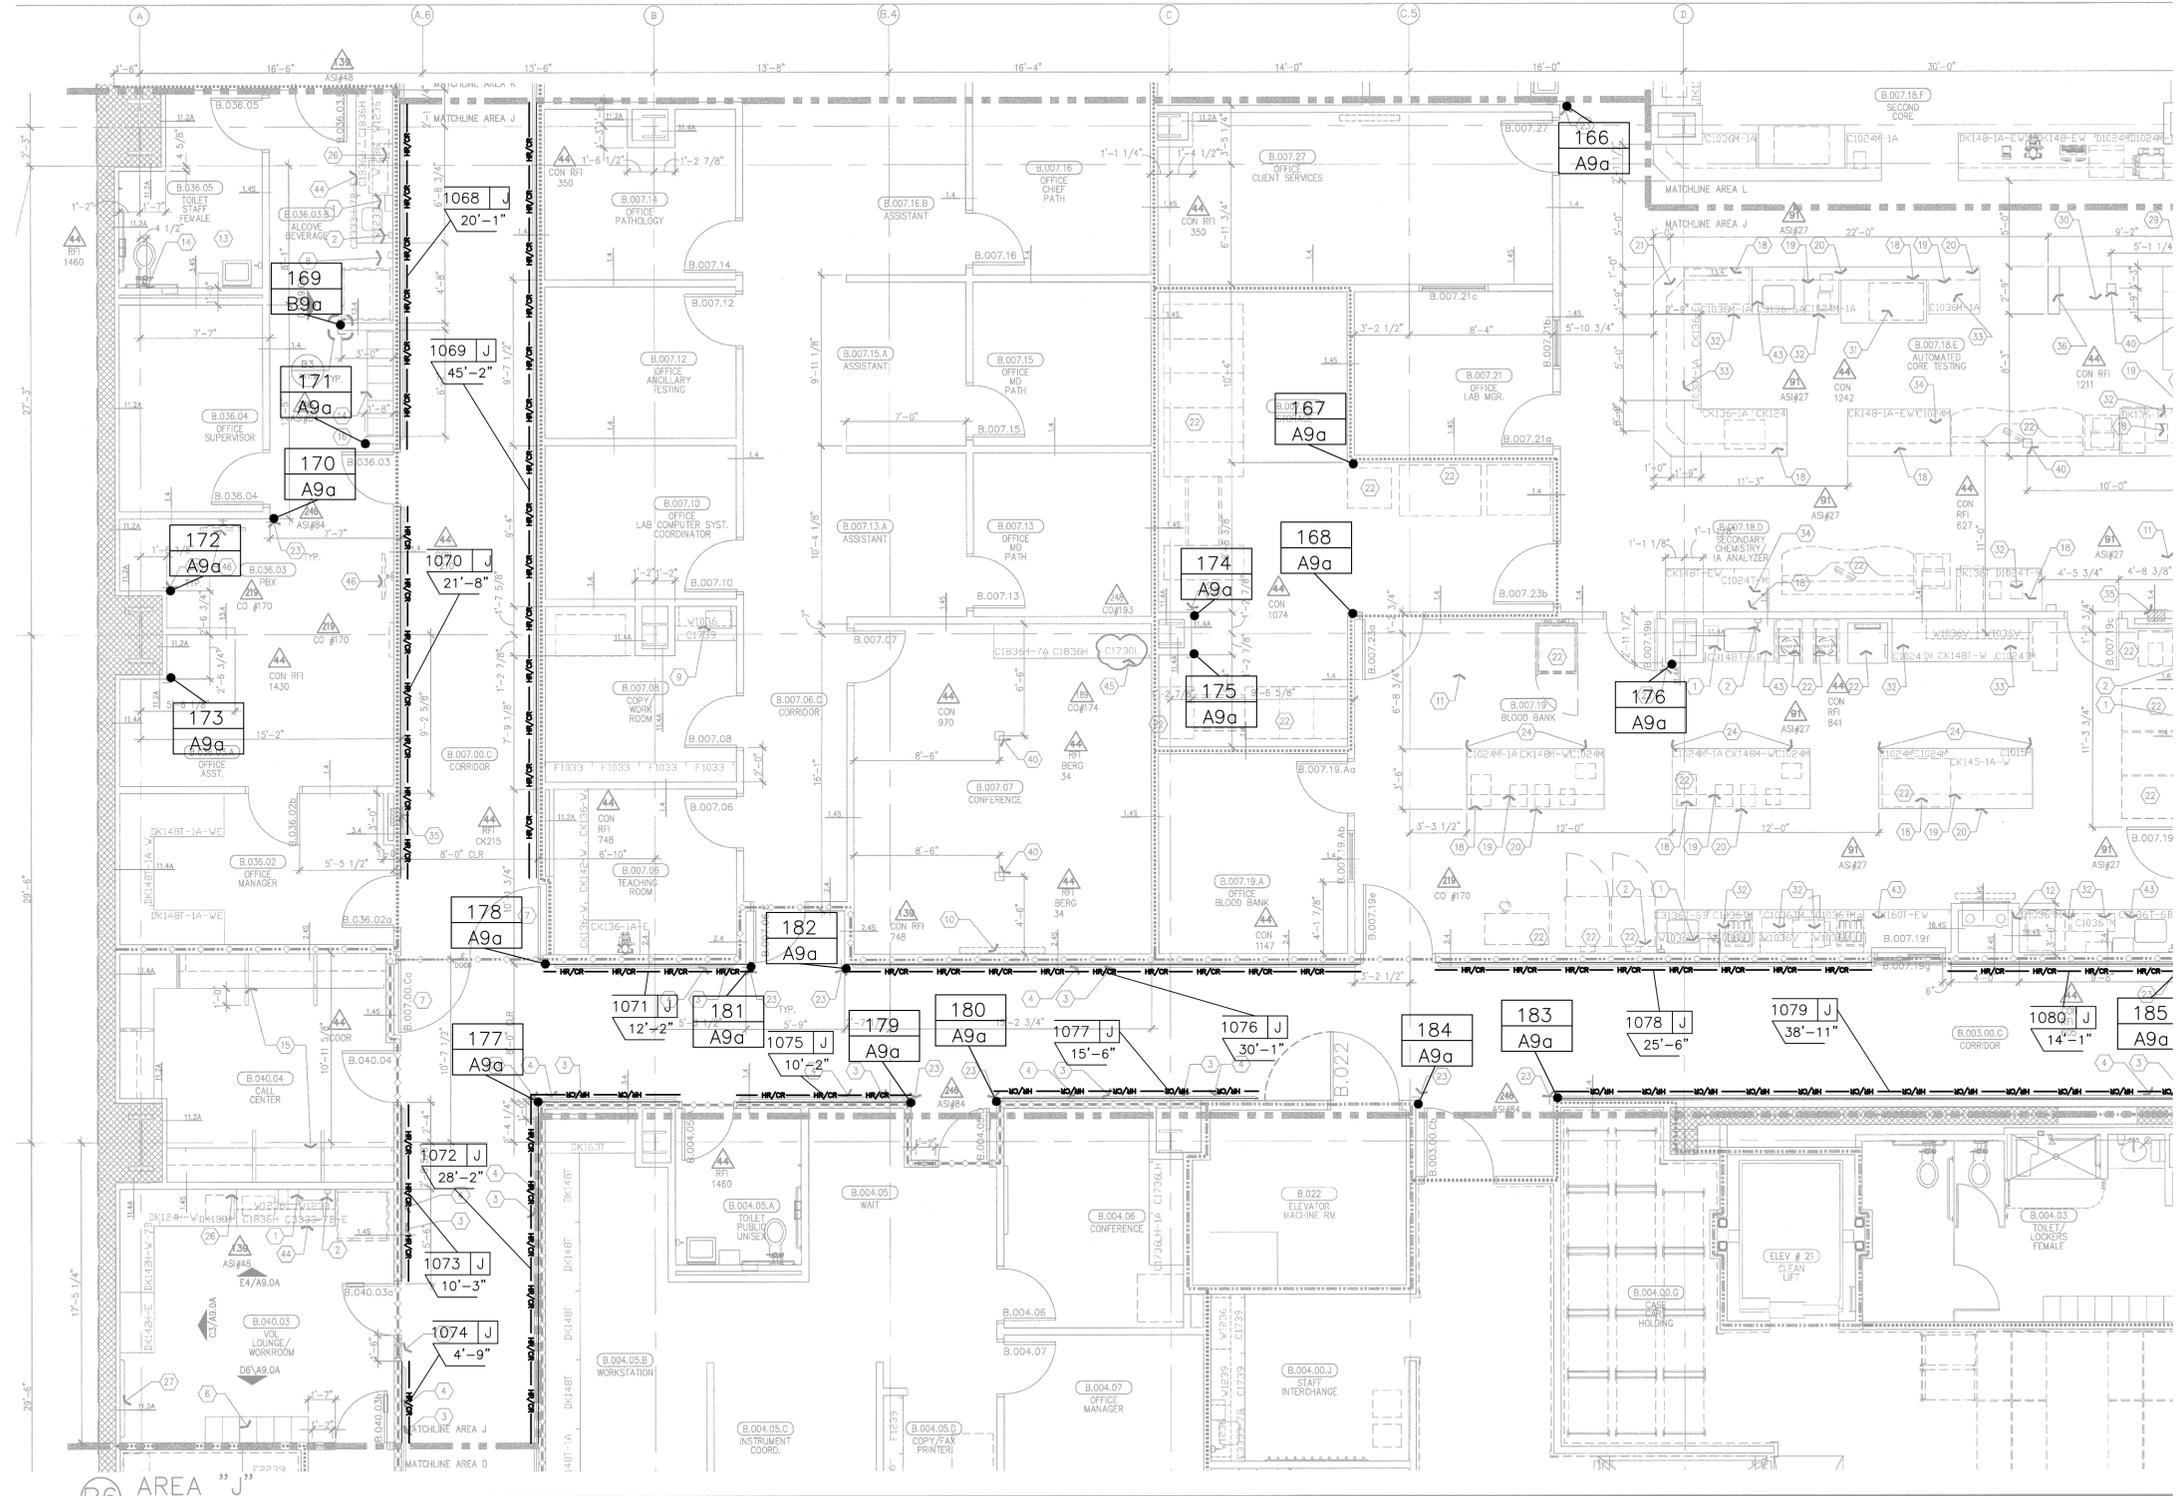

1. Paper towel dispenser, wall mounted, OFC. See Equipment plans and workbook.
2. Soap dispenser, wall mounted, OFC. See Equipment plans and workbook.
3. Bumproll. See detail B4/A11.8.
4. Handroll/crashroll. See detail B4/A11.8.
5. Fire extinguisher, cabinet wall recessed, paint to match adjacent wall, typical.

24. Modified casework/case cabinet designated with M in casework code, increase depth to 32" and pull out shelves in these cabinets.
25. File cabinets. See Furniture.
26. Microwave. See Equipment plans and workbook.
27. Tack board 60" W X 48" H, wall mounted at 38" A.F.F.
28. Undercounter refrigerator, see Equipment drawings and workbook.

A. Information shown or referred to enlarged and/or 1/4" scale drawings will generally not be shown on the smaller scale drawings.
 B. For partial enlarged plan at junior closets, see Detail A3/A11.7.
 N. Public/handicapped restroom graphics will be furnished and installed by the Owner's representative.

LOWER LEVEL AREA "J"
 ARCHITECTURAL DRAWING REFERENCED A3.0J DATED 06/07/2010 3/16" = 1'-0"

NO.	REVISION	DATE	BY
1	1ST (RFI#688)	11/03/10	KAS
2	2ND (RETURNED DWG)	5/17/11	KAS
3	UPDATED DWGS & RFIS	10/20/11	KAS
4	4TH (RETURNED DWG)	02/24/12	KAS

NO.	FILE & FIELD	DATE	BY

GENERAL NOTES:

CORNER GUARD SYMBOL

MARK # A REF. SECTION
 CODE 1 UNIT HEIGHT
 α BASE HEIGHT/ELEV

COLOR/CODE	CODE	SECTION	UNIT HGT	BASE/ELEV	QTY
#253 PARCHEMNT	A9a	A	9'-0"	N/A	19
#253 PARCHEMNT	B9a	B	9'-0"	N/A	1

REFERENCE MARK # X = SECTION IDENTIFICATION
 1001 X
 9'
 SCALED UNIT LENGTH

MATERIAL WILL BE FURNISHED IN STOCK LENGTHS TO BE FIELD CUT. MATERIAL QUANTITY SHALL BE BASED ON DIMENSIONS INDICATED AS SCALED UNIT LENGTH.

COLOR/CODE	SECTION	MODEL	L/F REQUIRED	LINE TYPE
#253 PARCHEMNT	J	HRB4C/SCR64M	276'-6"	HR/CR

- MATERIAL LIST:
- A= SM20A
 - B= SSM25A
 - C= SM20M
 - D= NOT USED
 - E= NOT USED
 - F= CO8
 - G= SC08
 - H= CO8M
 - I= HRB-4C
 - J= HRB-4C/SCR64M
 - K= .060 WC @ 4'-0"
 - L= .060 WC @ FH



This document is the property of Construction Specialties, Inc. and contains confidential proprietary information that is not to be disclosed to third parties and is not to be used without approval in writing from Construction Specialties, Inc.

PROJECT: CHILDREN'S HOSPITAL
 TOWER 2

JOB NO.: 759986

CUSTOMER: L2 SPECIALTIES INC.

REP: #111 IMC

DRAWN BY: KYLE SMITH

SCALE: 3/16" = 1'-0"

DATE: 07/16/2010

SHEET NO: 7

NO.	REVISION	DATE	BY
1	1ST (RFI#688)	11/03/10	KAS
2	2ND (RETURNED DWG)	5/17/11	KAS
3	UPDATED DWGS & RFI'S	10/20/11	KAS
4	4TH (RETURNED DWG)	02/24/12	KAS

NO.	FILE & FIELD	DATE	BY

GENERAL NOTES:

CORNER GUARD SYMBOL

MARK #	A REF. SECTION
CODE	1 UNIT HEIGHT
	o BASE HEIGHT/ELEV

COLOR/CODE	SECTION	SECTION	UNIT HGT	BASE/ELEV	QTY
#253 PARCHMENT	A9a	A	9'-0"	N/A	25
#253 PARCHMENT	B9a	B	9'-0"	N/A	3

REFERENCE MARK #

X = SECTION IDENTIFICATION

1001 X

9'

SCALED UNIT LENGTH


MATERIAL WILL BE FURNISHED IN STOCK LENGTHS TO BE FIELD CUT. MATERIAL QUANTITY SHALL BE BASED ON DIMENSIONS INDICATED AS SCALED UNIT LENGTH.

MATERIAL REQUIREMENTS

COLOR/CODE	SECTION	MODEL	L/F REQUIRED	LINE TYPE
#253 PARCHMENT	J	HRB4C/SCR64M	172'-11"	HR/OR

MATERIAL LIST:

A= SM20A
 B= SSM25A
 C= SM20M
 D= NOT USED
 E= NOT USED
 F= CO8
 G= CO8
 H= CO8M
 I= HRB-4C
 J= HRB-4C/SCR64M
 K= .060 WC @ 4'-0"
 L= .060 WC @ FH

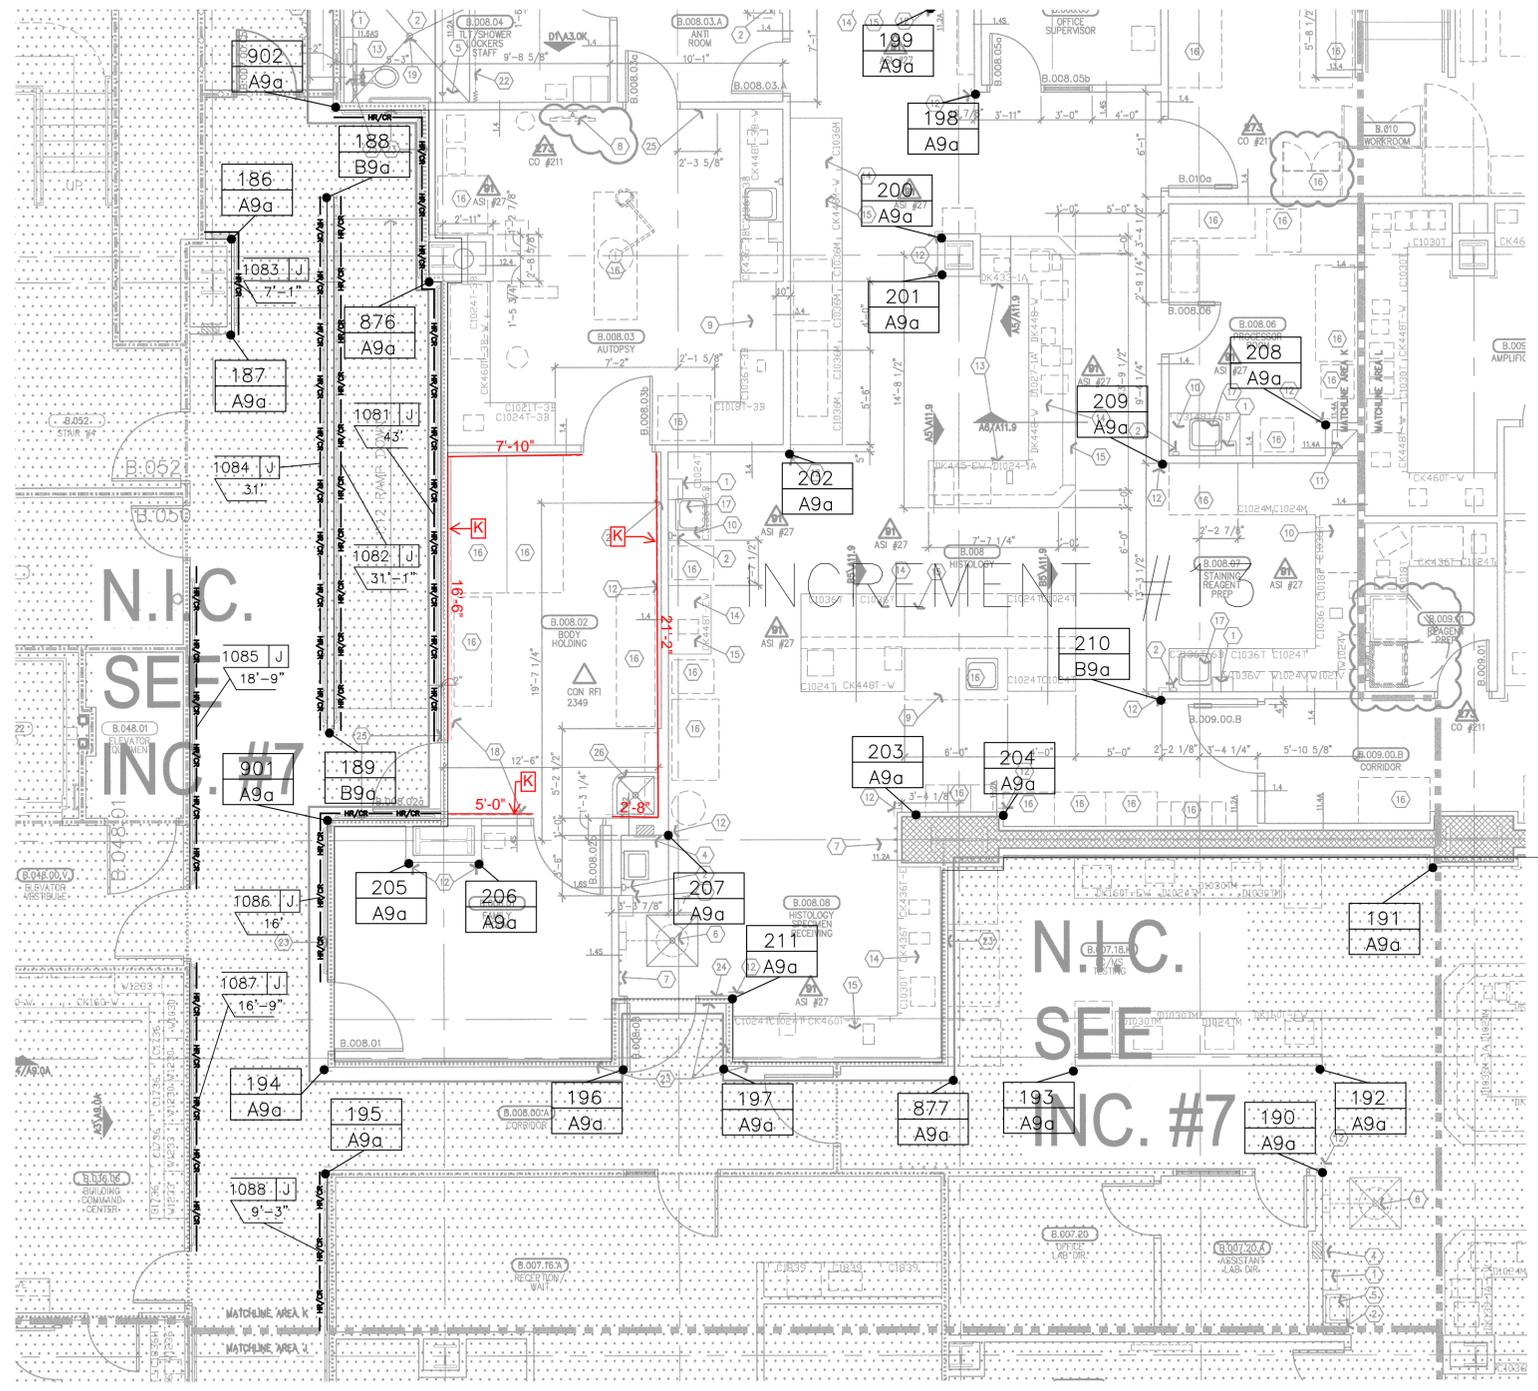

- Paper for
- Soap dish
- Provide
- Fire extn for detail
- Shower
- Safety at
- Coordinate
- For wall
- Provide
- Epoxy res
- Low oil re
- Corner gu
- See detail
- Plastic la
- Plastic la
- Floor mo
- Epoxy Res
- High impc
- Floor dral
- Closure p
- Personal
- Shower c
- Schedule
- Tactile ex
- 12" x 12"
- Finish to
- Map sink


- A. Information not be show
- B. Partition by Partition by partition by locations of accessory ic
- C. Close all joi w/insulant (etc.)
- D. Cabinet num features, see detail refer
- E. Plan dimen continue u chase wall.
- F. For vertical
- G. For vertical
- H. Public/hand graphics eq
- I. Standard eq
- J. Fire Protect
- K. Communicat
- L. Equipment r
- M. Equipment r
- N. For all door and Equipm referenced ic
- O. Doors, Fram
- P. Provide wall
- Q. For person
- R. See General
- S. Equipment r
- T. For graphics

LOWER LEVEL AREA "K"
 ARCHITECTURAL DRAWING REFERENCED A3.0K DATED 05/26/2010
 3/16" = 1'-0"

CS Construction Specialties
 6600 Ross 405 Highway, Manly PA 17756
 (800) 233-6400 • Fax: (717) 546-6000 • www.c-sgroup.com

This document is the property of Construction Specialties, Inc. and contains confidential proprietary information that is not to be disclosed to third parties and is not to be used without approval in writing from Construction Specialties, Inc.

PROJECT: CHILDREN'S HOSPITAL TOWER 2
 JOB NO.: 759986
 CUSTOMER: L2 SPECIALTIES INC.
 REP: #111 IMC
 DRAWN BY: KYLE SMITH
 SCALE: 3/16" = 1'-0"
 DATE: 07/16/2010
 SHEET NO: 8

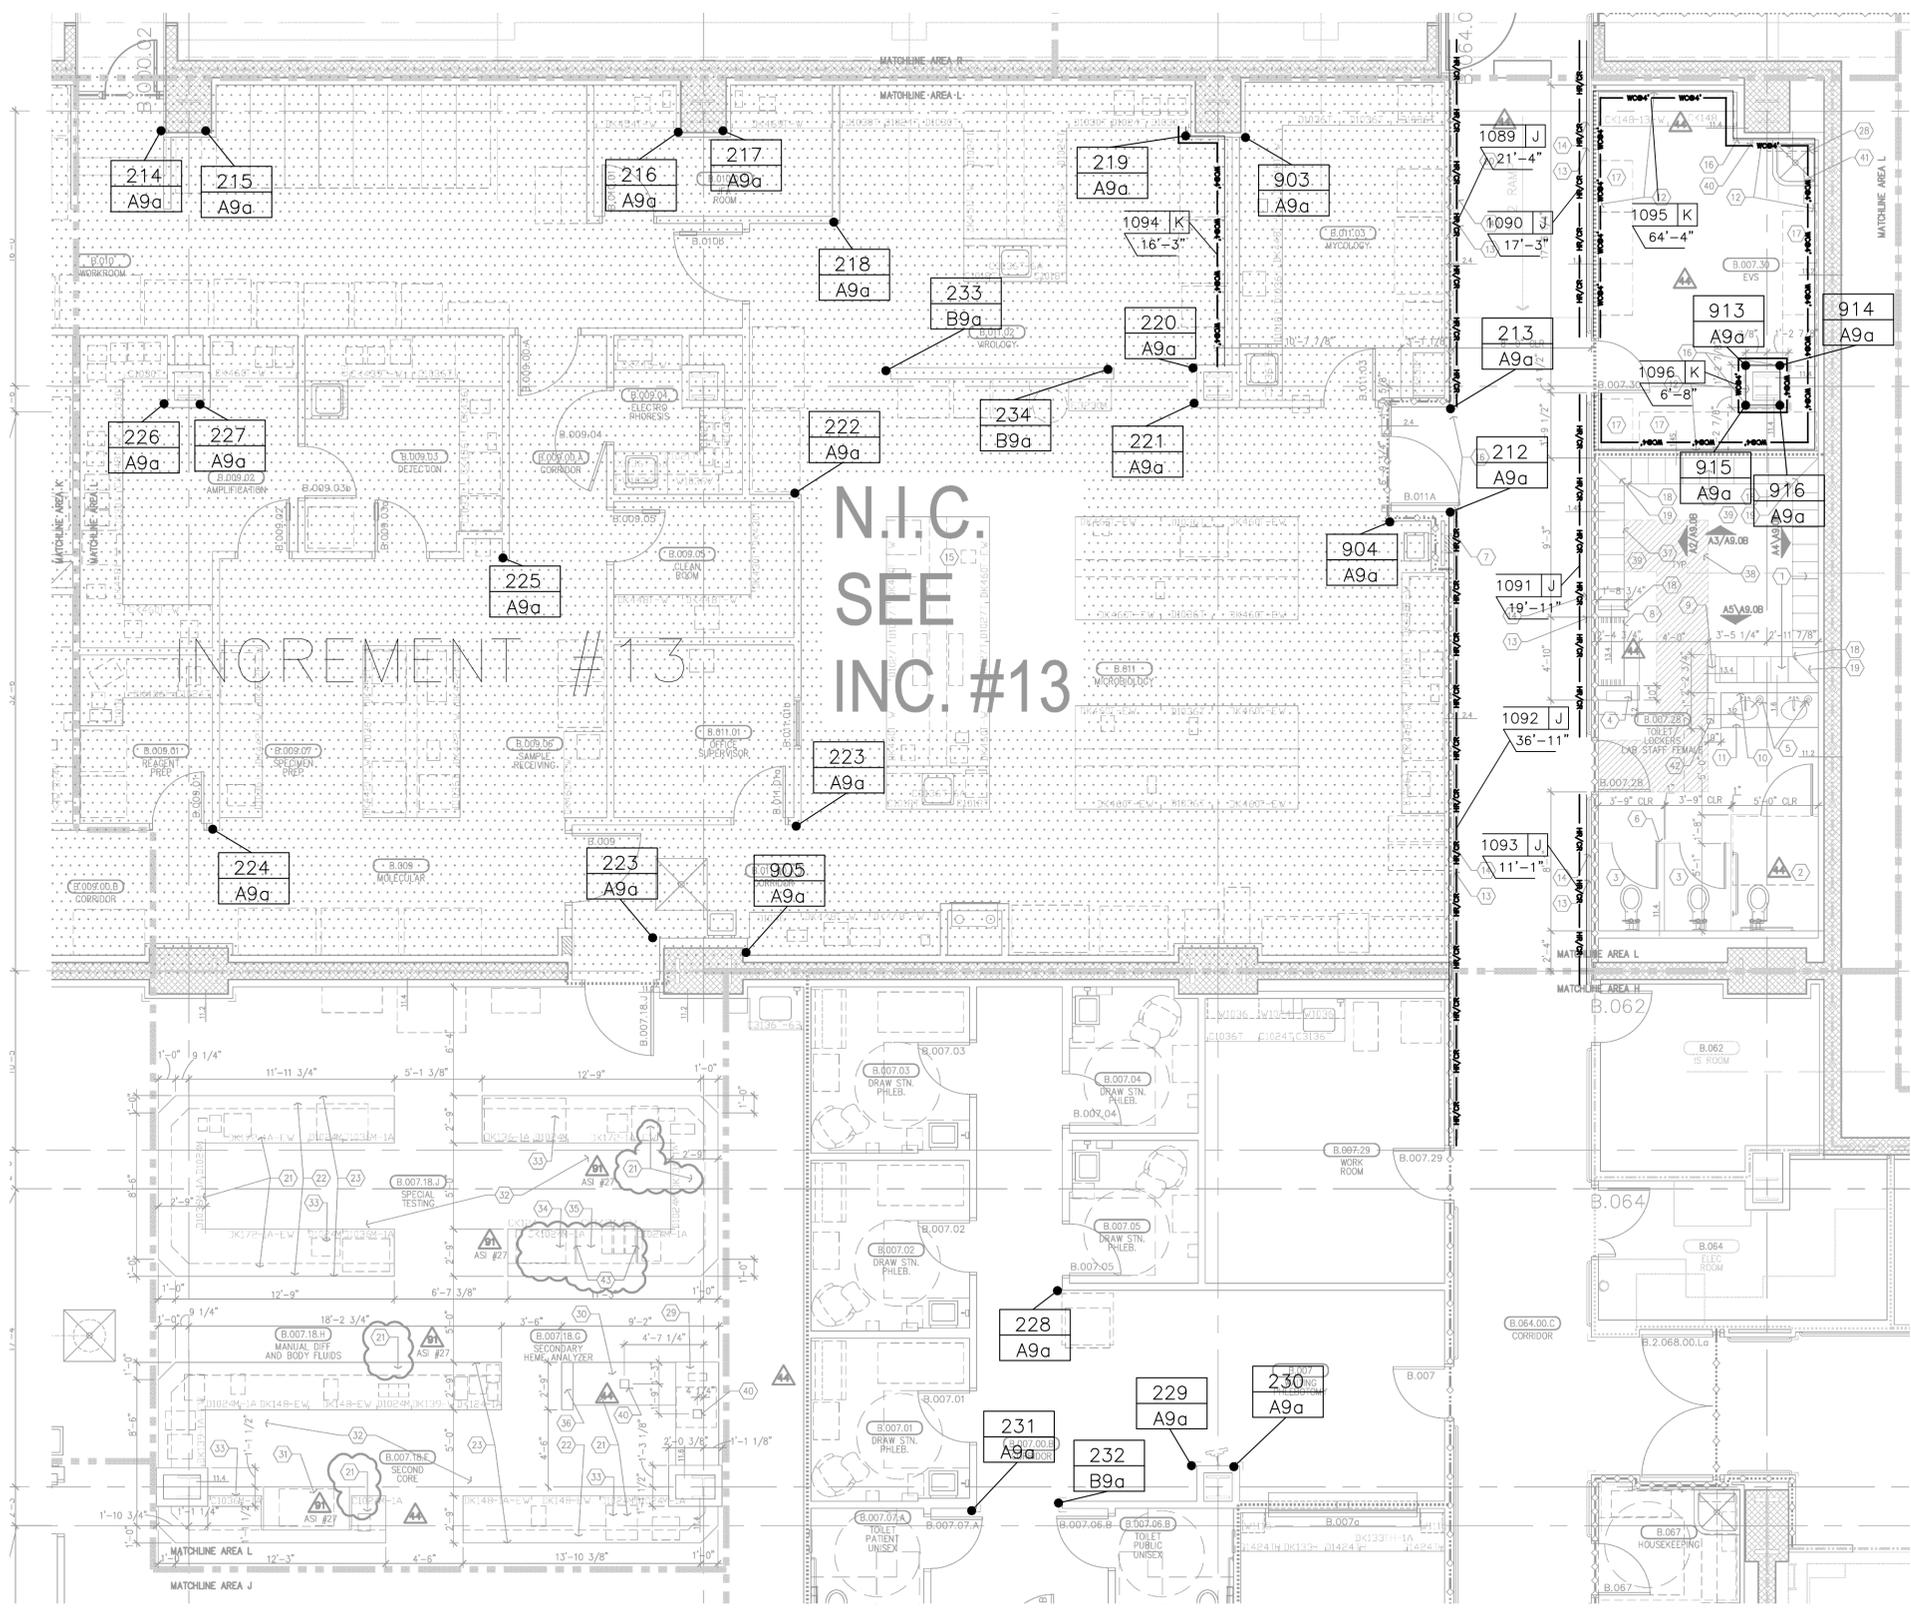

NO.	REVISION	DATE	BY
1	1ST (RF#688)	11/03/10	KAS
2	2ND (RETURNED DWG)	5/17/11	KAS
3	UPDATED DWGS & RF'S	10/20/11	KAS
4	4TH (RETURNED DWG)	02/24/12	KAS


NO.	FILE & FIELD	DATE	BY

GENERAL NOTES:

CORNER GUARD SYMBOL

MARK #	A REF. SECTION
104	1 UNIT HEIGHT
104	BASE HEIGHT/ELEV

COLOR/CODE	CODE	SECTION	UNIT HGT	BASE/ELEV	QTY
#253 PARCHMENT	A9a	A	9'-0"	N/A	25
#253 PARCHMENT	B9a	B	9'-0"	N/A	3

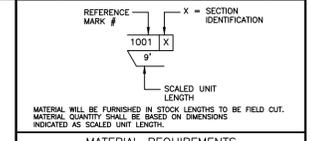

MATERIAL REQUIREMENTS

COLOR/CODE	SECTION	MODEL	L/F REQUIRED	LINE TYPE
#253 PARCHMENT	J	HRB4C/SCR64M	106'-6"	HRB
#253 PARCHMENT	K	.040 WC @ 4'-0"	87'-3"	WC

- MATERIAL LIST:
- A= SM20A
 - B= SSM25A
 - C= SM20M
 - D= NOT USED
 - E= NOT USED
 - F= C08
 - G= SC08
 - H= C08M
 - I= HRB-4C
 - J= HRB-4C/SCR64M
 - K= .060 WC @ 4'-0"
 - L= .060 WC @ FH



This document is the property of Construction Specialties, Inc. and contains confidential proprietary information that is not to be disclosed to third parties and is not to be used without approval in writing from Construction Specialties, Inc.

PROJECT: CHILDREN'S HOSPITAL
TOWER 2

JOB NO.: 759986

CUSTOMER: L2 SPECIALTIES INC.

REP: #111 IMC

DRAWN BY: KYLE SMITH

SCALE: 3/16" = 1'-0"

DATE: 07/16/2010

SHEET NO: 9

LOWER LEVEL AREA "L"
ARCHITECTURAL DRAWING REFERENCED A3.0L DATED 11/18/2010 3/16" = 1'-0"

NO.	REVISION	DATE	BY
1	1ST (RFI#688)	11/03/10	KAS
2	2ND (RETURNED DWG)	5/17/11	KAS
3	UPDATED DWGS & RFIS	10/20/11	KAS
4	4TH (RETURNED DWG)	02/24/12	KAS

NO.	FILE & FIELD	DATE	BY

GENERAL NOTES:


CORNER GUARD SYMBOL
 MARK # A REF. SECTION
 CODE 1 UNIT HEIGHT
 BASE HEIGHT/ELEV

COLOR/CODE	CODE	SECTION	UNIT HGT	BASE/ELEV	QTY
#253 PARCHMENT	A9a	A	9'-0"	N/A	6


REFERENCE MARK # X = SECTION IDENTIFICATION
 1001 X
 9'
 SCALED UNIT LENGTH
 MATERIAL WILL BE FURNISHED IN STOCK LENGTHS TO BE FIELD CUT.
 MATERIAL QUANTITY SHALL BE BASED ON DIMENSIONS INDICATED AS SCALED UNIT LENGTH.

COLOR/CODE	SECTION	MODEL	L/F REQUIRED	LINE TYPE
#253 PARCHMENT	J	HRB4C/SCR64M	187'-5"	HR/CR

MATERIAL LIST:
 A= SM20A
 B= SSM25A
 C= SM20M
 D= NOT USED
 E= NOT USED
 F= CO8
 G= SC08
 H= CO8M
 I= HRB-4C
 J= HRB-4C/SCR64M
 K= .060 WC @ 4'-0"
 L= .060 WC @ FH

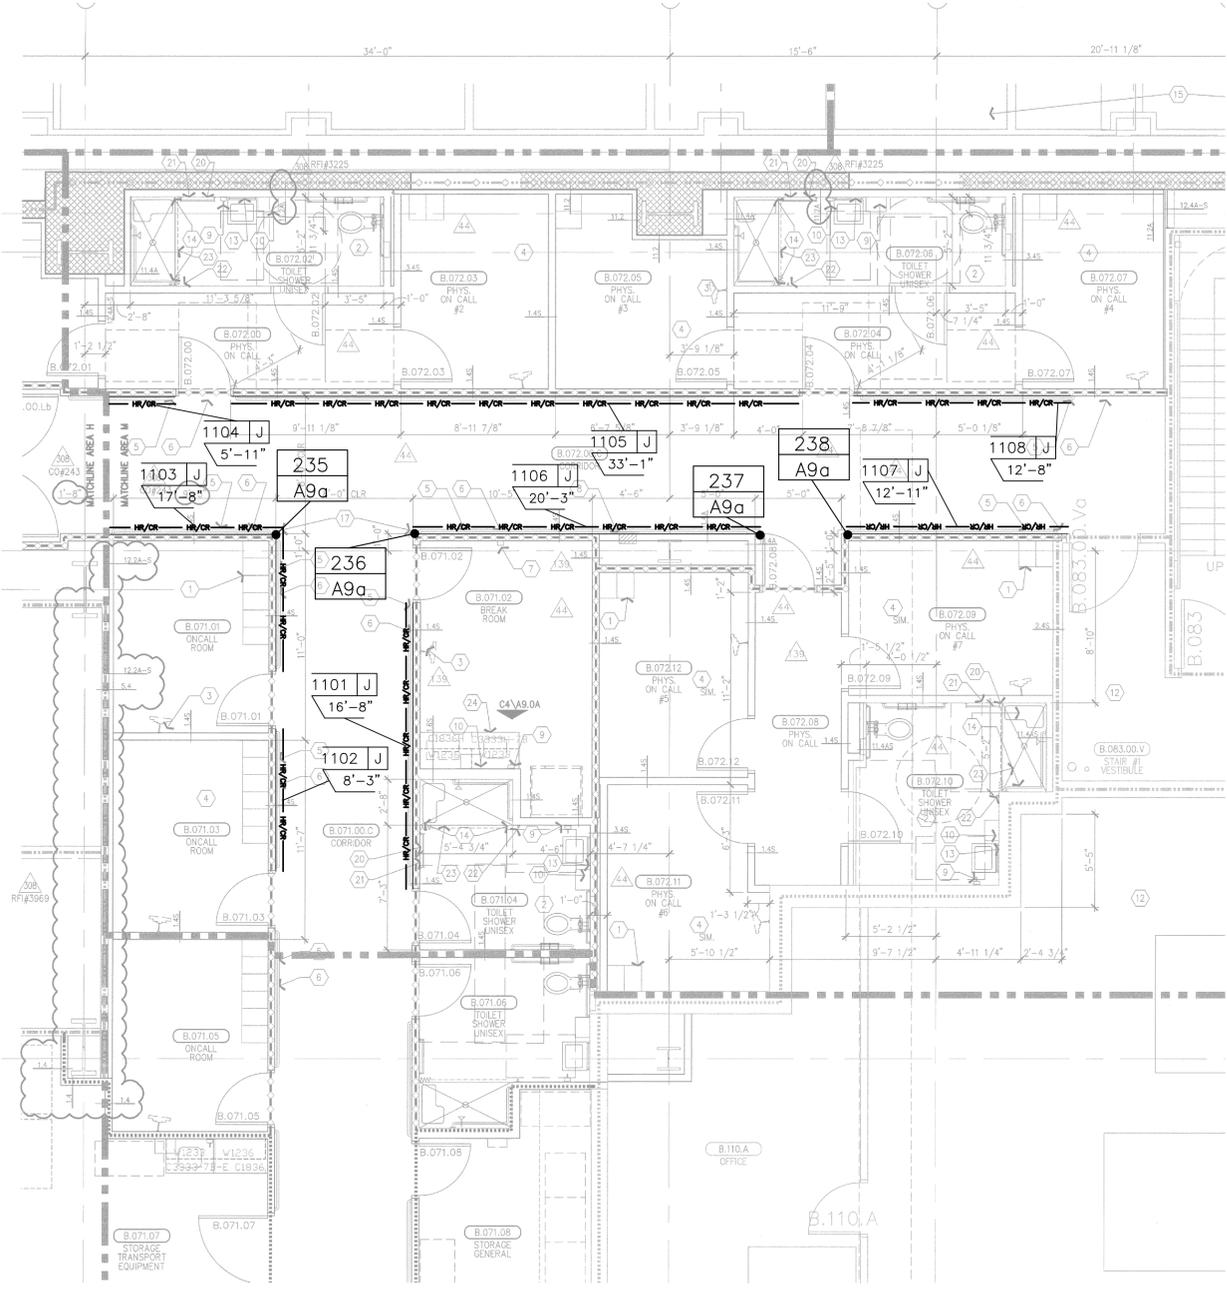

LOWER LEVEL AREA "M"
 ARCHITECTURAL DRAWING REFERENCED A3.0M DATED 07/18/2011
 3/16" = 1'-0"

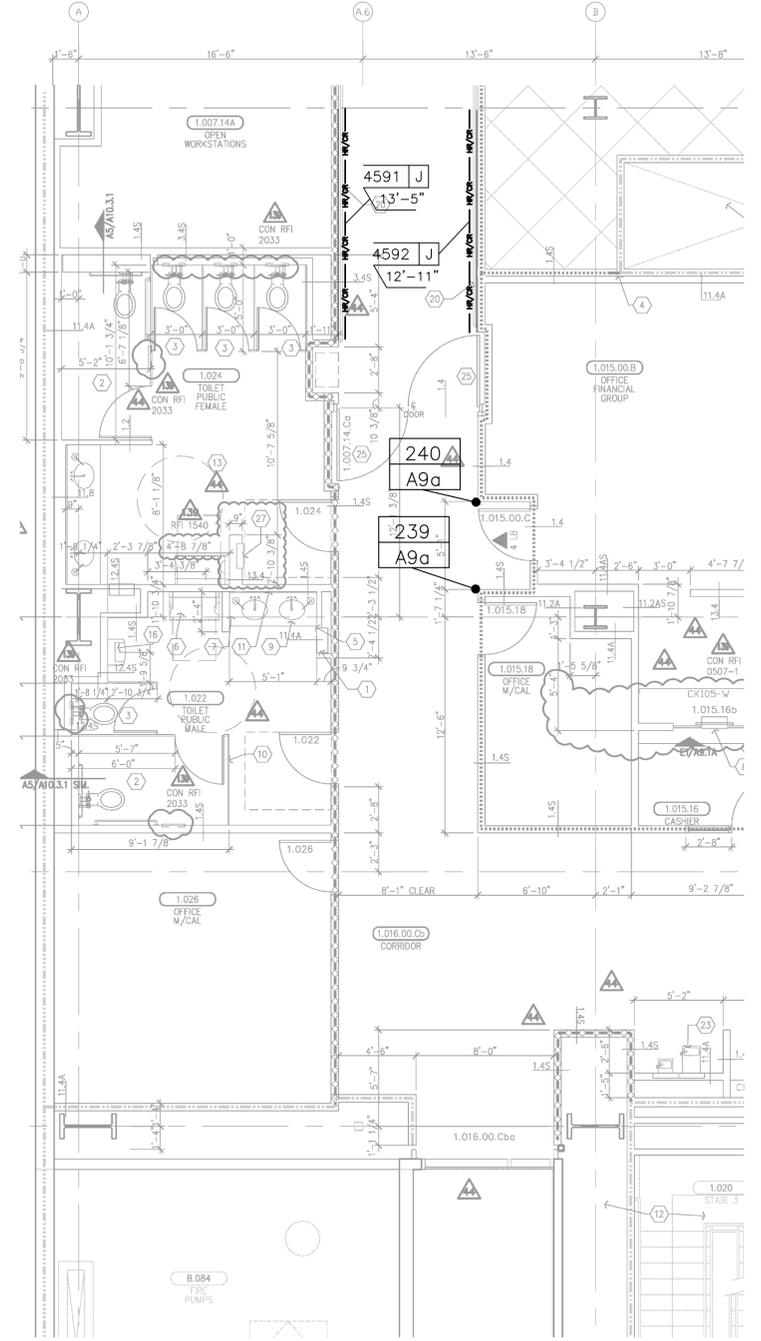

LEVEL 1 AREA "D"
 ARCHITECTURAL DRAWING REFERENCED A3.1D DATED 09/30/2008
 3/16" = 1'-0"

CS Construction Specialties
 6600 Ross 405 Highway, Manly PA 17756
 (800) 233-8400 • Fax: (717) 546-6000 • www.c-s-g.com

This document is the property of Construction Specialties, Inc. and contains confidential proprietary information that is not to be disclosed to third parties and is not to be used without approval in writing from Construction Specialties, Inc.

PROJECT: CHILDREN'S HOSPITAL
 TOWER 2
 JOB NO.: 759986
 CUSTOMER: L2 SPECIALTIES INC.
 REP: #111 IMC
 DRAWN BY: KYLE SMITH
 SCALE: 3/16" = 1'-0"
 DATE: 07/16/2010
 SHEET NO: 10

NO.	REVISION	DATE	BY
1	1ST (RFI#688)	11/03/10	KAS
2	2ND (RETURNED DWG)	5/17/11	KAS
3	UPDATED DWGS & RFI'S	10/20/11	KAS
4	4TH (RETURNED DWG)	02/24/12	KAS

NO.	FILE & FIELD	DATE	BY

GENERAL NOTES:


CORNER GUARD SYMBOL
 MARK #
 A REF. SECTION
 1 UNIT HEIGHT
 a BASE HEIGHT/ELEV

COLOR/CODE	CODE	SECTION	UNIT HGT	BASE/ELEV	QTY
#253 PARCHMENT	A9a	A	9'-0"	N/A	24
#253 PARCHMENT	B9a	B	9'-0"	N/A	4

REFERENCE MARK # X = SECTION IDENTIFICATION
 SCALED UNIT LENGTH
 MATERIAL WILL BE FURNISHED IN STOCK LENGTHS TO BE FIELD CUT. MATERIAL QUANTITY SHALL BE BASED ON DIMENSIONS INDICATED AS SCALED UNIT LENGTH.

COLOR/CODE	SECTION	MODEL	L/F REQUIRED	LINE TYPE
#253 PARCHMENT	I	HRB4C	155'-0"	HR
#253 PARCHMENT	K	.040 WC @ 4'-0"	43'-5"	WCP*

MATERIAL LIST:
 A= SM20A
 B= SSM25A
 C= SM20M
 D= NOT USED
 E= NOT USED
 F= CO8
 G= SCO8
 H= CO8M
 I= HRB-4C
 J= HRB-4C/SCR64M
 K= .060 WC @ 4'-0"
 L= .060 WC @ FH

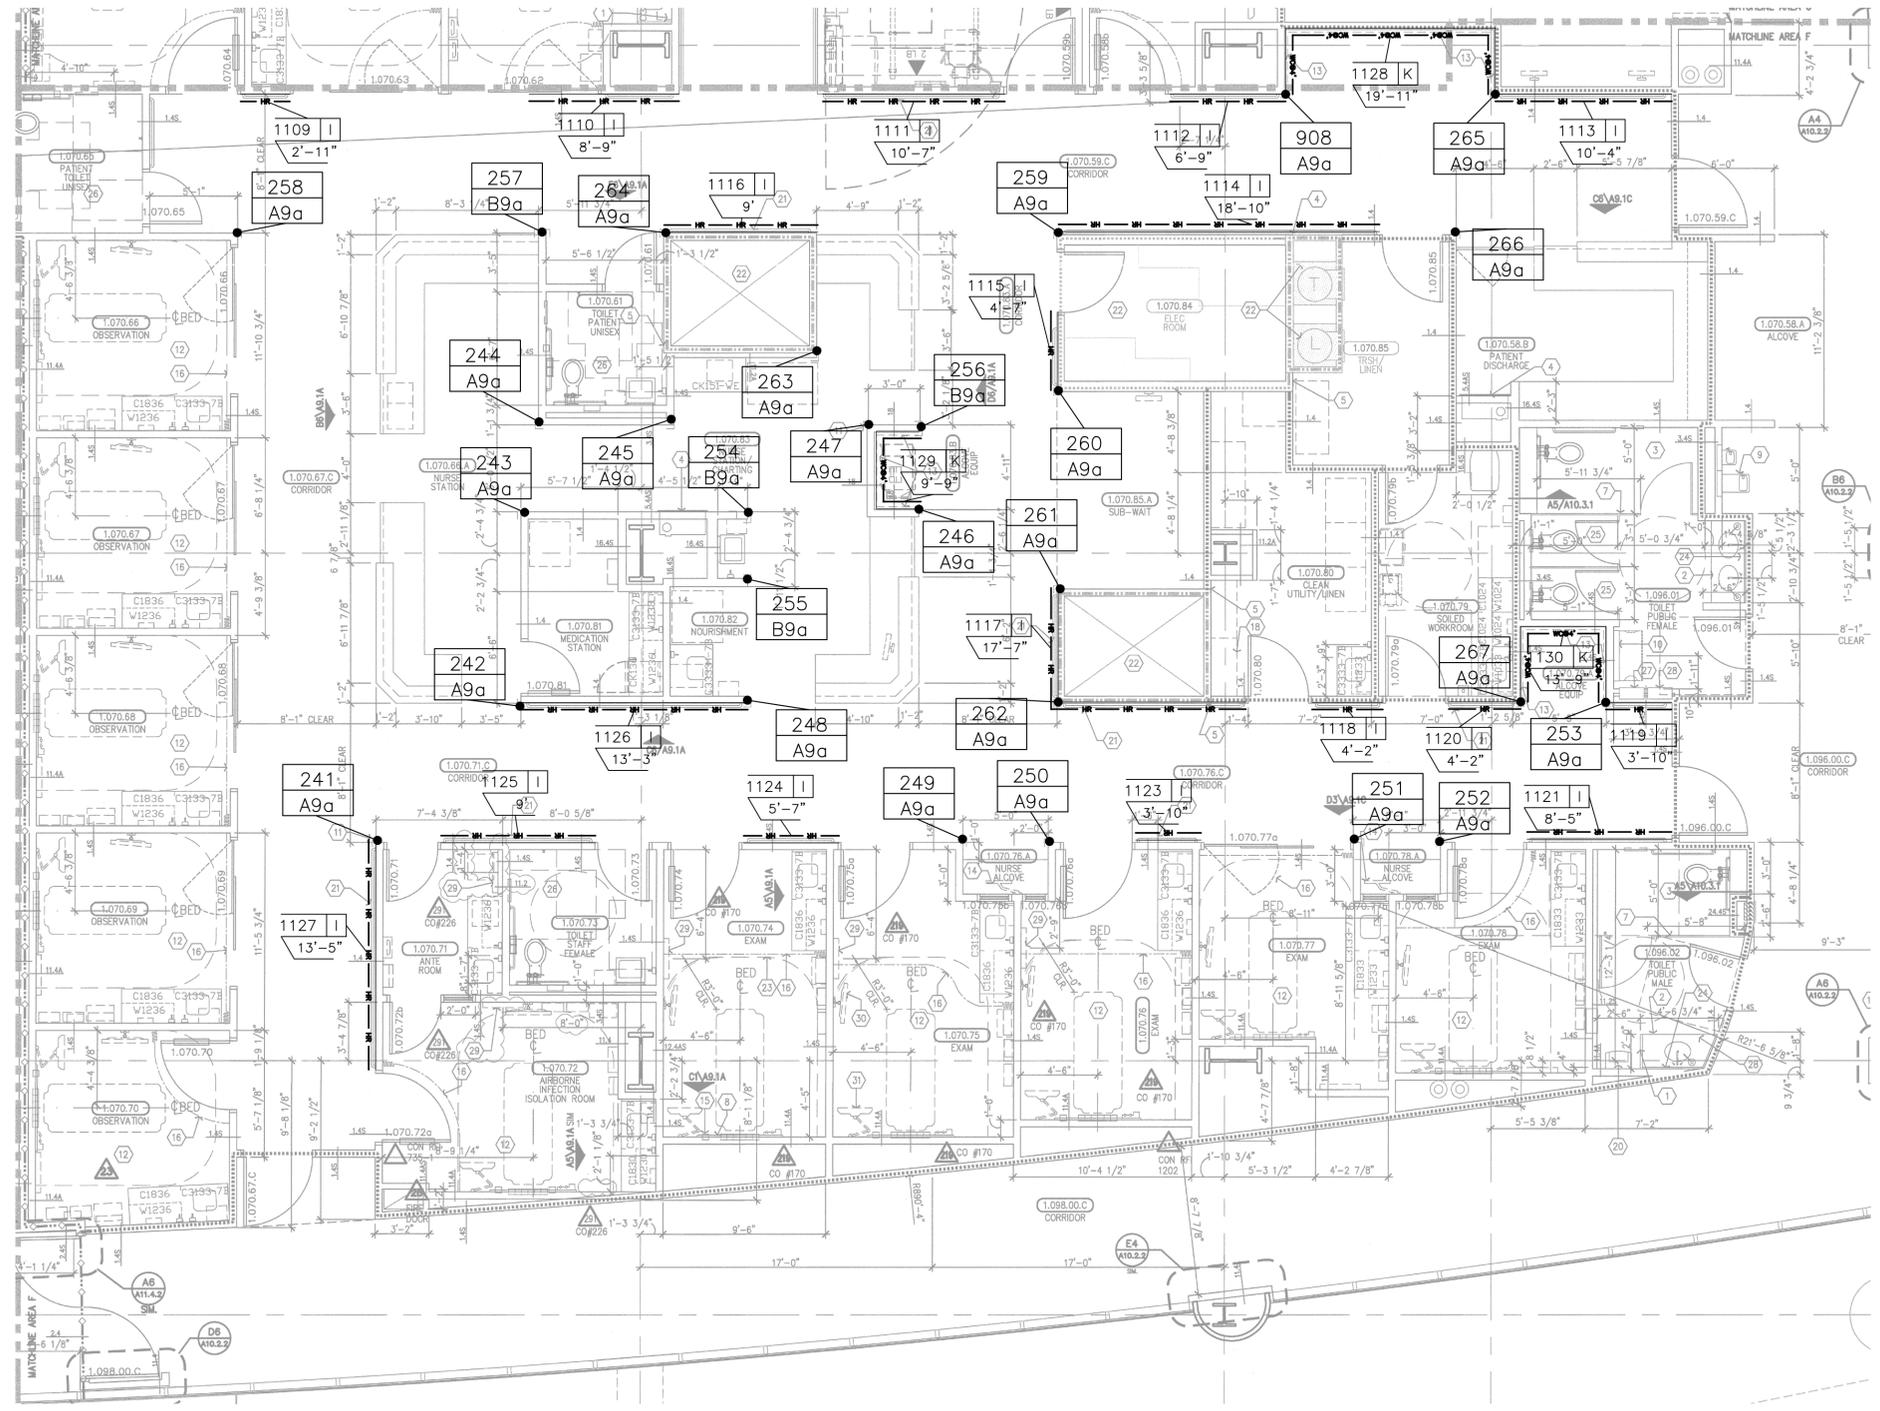

LEVEL 1 AREA "F"
 ARCHITECTURAL DRAWING REFERENCED A3.1F DATED 07/18/2010
 3/16" = 1'-0"

CS Construction Specialties
 6600 Ross 405 Highway, Manly PA 17756
 (803) 233-6400 • Fax: (717) 546-6502 • www.c-s-group.com

This document is the property of Construction Specialties, Inc. and contains confidential proprietary information that is not to be disclosed to third parties and is not to be used without approval in writing from Construction Specialties, Inc.

PROJECT: CHILDREN'S HOSPITAL
 TOWER 2
 JOB NO.: 759986
 CUSTOMER: L2 SPECIALTIES INC.
 REP: #111 IMC
 DRAWN BY: KYLE SMITH
 SCALE: 3/16" = 1'-0"
 DATE: 07/16/2010
 SHEET NO: 11

NO.	REVISION	DATE	BY
1	1ST (RFI#688)	11/03/10	KAS
2	2ND (RETURNED DWG)	5/17/11	KAS
3	UPDATED DWGS & RFI'S	10/20/11	KAS
4	4TH (RETURNED DWG)	02/24/12	KAS

GENERAL NOTES:


CORNER GUARD SYMBOL
 MARK # A REF. SECTION
 CODE 1 UNIT HEIGHT
 BASE HEIGHT/ELEV

COLOR/CODE	CODE	SECTION	UNIT HGT	BASE/ELEV	QTY
#253 PARCHMENT	A9a	A	9'-0"	N/A	5
#253 PARCHMENT	B9a	B	9'-0"	N/A	1

REFERENCE MARK # X = SECTION IDENTIFICATION
 1001 X
 9'
 SCALED UNIT LENGTH
 MATERIAL WILL BE FURNISHED IN STOCK LENGTHS TO BE FIELD CUT. MATERIAL QUANTITY SHALL BE BASED ON DIMENSIONS INDICATED AS SCALED UNIT LENGTH.

COLOR/CODE	SECTION	MODEL	L/F REQUIRED	LINE TYPE
#253 PARCHMENT	I	HRB4C	61'-6"	HR

MATERIAL LIST:
 A= SM20A
 B= SSM25A
 C= SM20M
 D= NOT USED
 E= NOT USED
 F= CO8
 G= SCO8
 H= CO8M
 I= HRB-4C
 J= HRB-4C/SCR64M
 K= .060 WC @ 4'-0"
 L= .060 WC @ FH

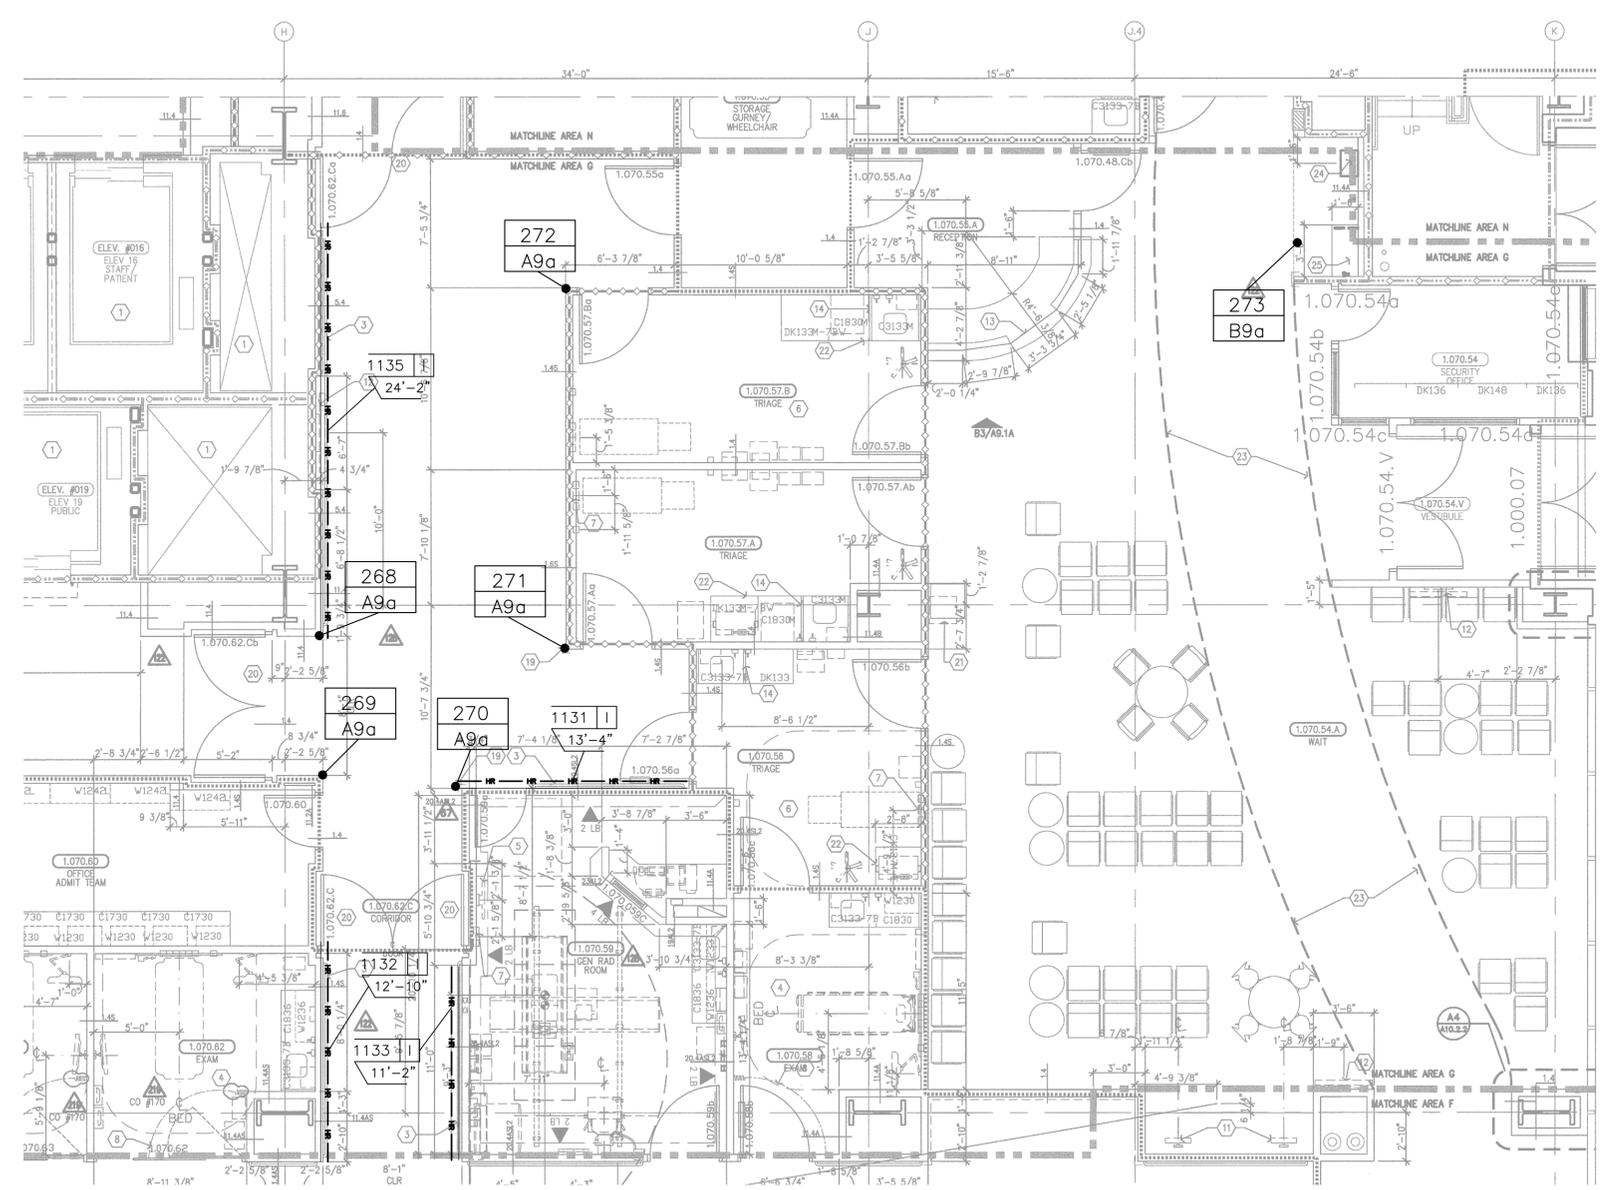

LEVEL 1 AREA "G"
 ARCHITECTURAL DRAWING REFERENCED A3.1G DATED 05/26/2011
 3/16" = 1'-0"

CS Construction Specialties
 6600 Ross 405 Highway, Manly PA 17756
 (800) 233-6400 • Fax: (717) 546-6000 • www.c-s-group.com

This document is the property of Construction Specialties, Inc. and contains confidential proprietary information that is not to be disclosed to third parties and is not to be used without approval in writing from Construction Specialties, Inc.

PROJECT: CHILDREN'S HOSPITAL
 TOWER 2
 JOB NO.: 759986
 CUSTOMER: L2 SPECIALTIES INC.
 REP: #111 IMC
 DRAWN BY: KYLE SMITH
 SCALE: 3/16" = 1'-0"
 DATE: 07/16/2010
 SHEET NO: 12

NO.	REVISION	DATE	BY
1	1ST (RFI#688)	11/03/10	KAS
2	2ND (RETURNED DWG)	5/17/11	KAS
3	UPDATED DWGS & RFI'S	10/20/11	KAS
4	4TH (RETURNED DWG)	02/24/12	KAS

GENERAL NOTES:

CORNER GUARD SYMBOL
 MARK # A REF. SECTION
 CODE 1 UNIT HEIGHT
 BASE HEIGHT/ELEV


COLOR/CODE	CODE	SECTION	UNIT HGT	BASE/ELEV	QTY
#253 PARCHMENT	A9a	A	9'-0"	N/A	10
#253 PARCHMENT	B9a	B	9'-0"	N/A	1

REFERENCE MARK # X = SECTION IDENTIFICATION
 TOILET PATERN UNISEX
 1001 X
 9'
 SCALED UNIT LENGTH
 MATERIAL WILL BE FURNISHED IN STOCK LENGTHS TO BE FIELD CUT. MATERIAL QUANTITY SHALL BE BASED ON DIMENSIONS INDICATED AS SCALED UNIT LENGTH.

COLOR/CODE	SECTION	MODEL	L/F REQUIRED	LINE TYPE
#253 PARCHMENT	I	HRB4C	143'-0"	HR
#253 PARCHMENT	K	.040 WC @ 4'-0"	12'-5"	WOP*

MATERIAL LIST:
 A= SM20A
 B= SSM25A
 C= SM20M
 D= NOT USED
 E= NOT USED
 F= CO8
 G= SCO8
 H= CO8M
 I= HRB-4C
 J= HRB-4C/SCR64M
 K= .060 WC @ 4'-0"
 L= .060 WC @ FH

ved. No part of this document may be reproduced or utilized in any form without prior written authorization of FKP Architects, Inc.

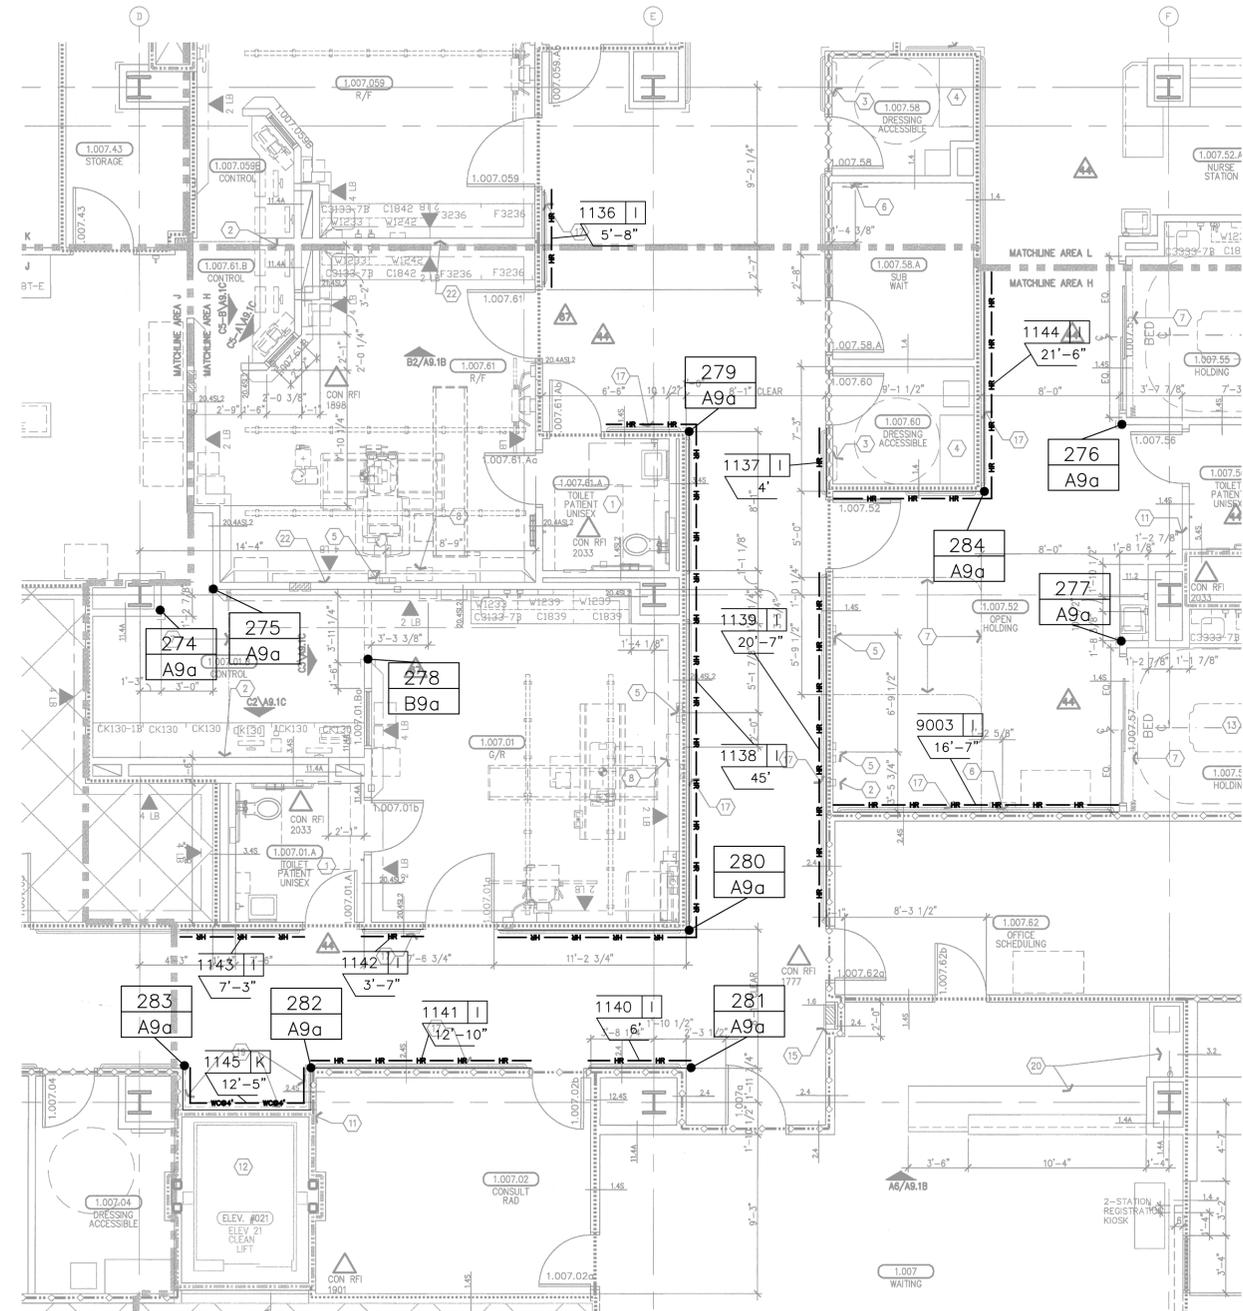

LEVEL 1 AREA "H"
 ARCHITECTURAL DRAWING REFERENCED A3.1H DATED 07/18/2011
 3/16" = 1'-0"



This document is the property of Construction Specialties, Inc. and contains confidential proprietary information that is not to be disclosed to third parties and is not to be used without approval in writing from Construction Specialties, Inc.

PROJECT: CHILDREN'S HOSPITAL
 TOWER 2
 JOB NO.: 759986
 CUSTOMER: L2 SPECIALTIES INC.
 REP: #111 IMC
 DRAWN BY: KYLE SMITH
 SCALE: 3/16" = 1'-0"
 DATE: 07/16/2010
 SHEET NO: 13

NO.	REVISION	DATE	BY
1	1ST (RF#688)	11/03/10	KAS
2	2ND (RETURNED DWG)	5/17/11	KAS
3	UPDATED DWGS & RF'S	10/20/11	KAS
4	4TH (RETURNED DWG)	02/24/12	KAS
NO.	FILE & FIELD	DATE	BY

GENERAL NOTES:


CORNER GUARD SYMBOL
 MARK # A REF. SECTION
 CODE 1 UNIT HEIGHT
 BASE HEIGHT/ELEV

COLOR/CODE	CODE	SECTION	UNIT HGT	BASE/ELEV	QTY
#253 PARCHEMENT	A9a	A	9'-0"	N/A	17
#253 PARCHEMENT	B9a	B	9'-0"	N/A	4

REFERENCE MARK # X = SECTION IDENTIFICATION
 1001 X
 9'
 SCALED UNIT LENGTH
 MATERIAL WILL BE FURNISHED IN STOCK LENGTHS TO BE FIELD CUT.
 MATERIAL QUANTITY SHALL BE BASED ON DIMENSIONS INDICATED AS SCALED UNIT LENGTH.

MATERIAL REQUIREMENTS				
COLOR/CODE	SECTION	MODEL	L/F REQUIRED	LINE TYPE
#253 PARCHEMENT	I	HRB4C	220'-10"	HR

MATERIAL LIST:
 A= SM20A
 B= SSM25A
 C= SM20M
 D= NOT USED
 E= NOT USED
 F= CO8
 G= SC08
 H= CO8M
 I= HRB-4C
 J= HRB-4C/SCR64M
 K= .060 WC @ 4'-0"
 L= .060 WC @ FH

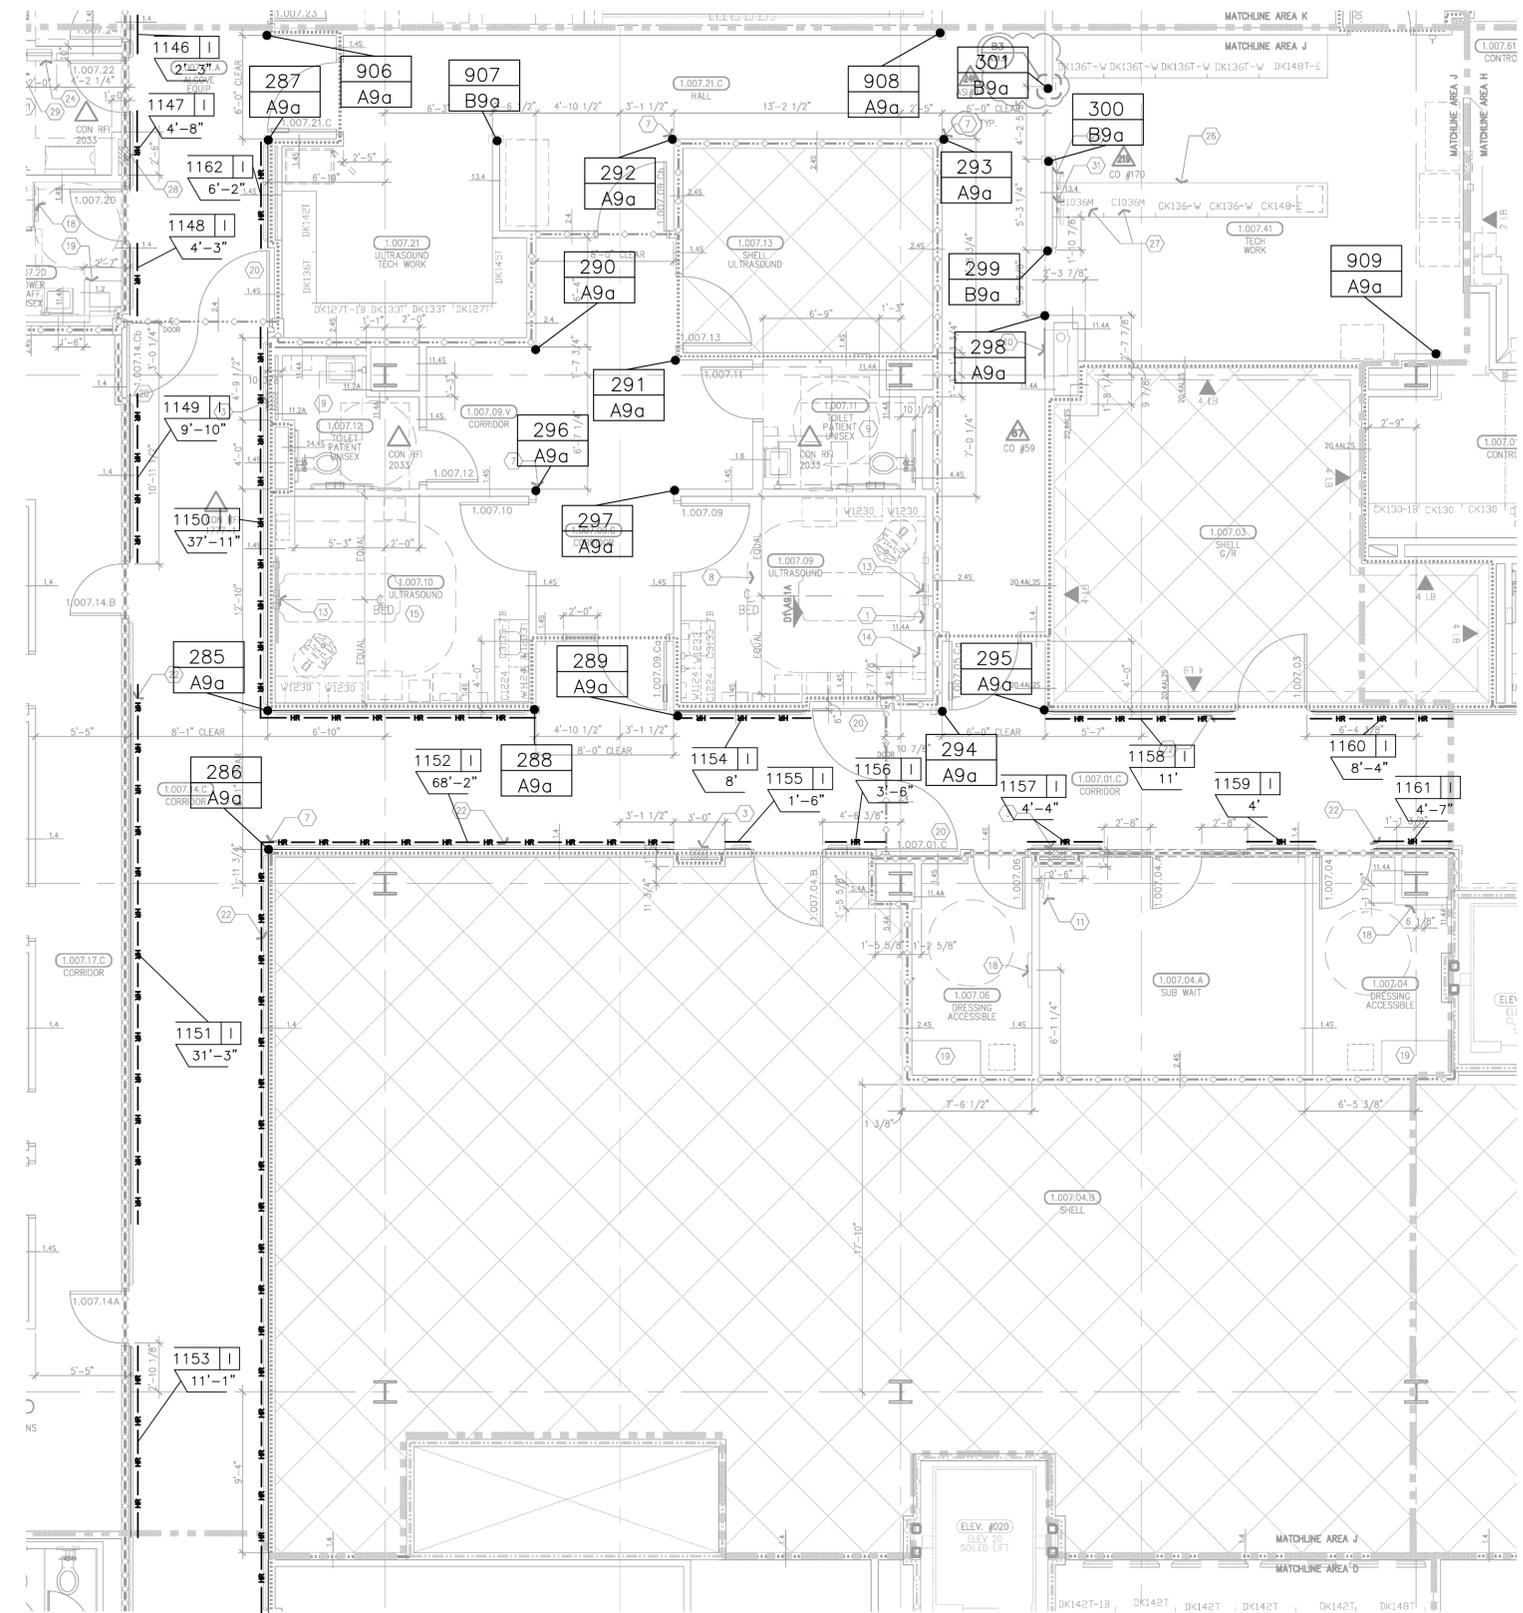


LEVEL 1 AREA "J"
 ARCHITECTURAL DRAWING REFERENCED A3.1J DATED 05-09-2011
 3/16" = 1'-0"



This document is the property of Construction Specialties, Inc. and contains confidential proprietary information that is not to be disclosed to third parties and is not to be used without approval in writing from Construction Specialties, Inc.

PROJECT: CHILDREN'S HOSPITAL
 TOWER 2
 JOB NO.: 759986
 CUSTOMER: L2 SPECIALTIES INC.
 REP: #111 IMC
 DRAWN BY: KYLE SMITH
 SCALE: 3/16" = 1'-0"
 DATE: 07/16/2010
 SHEET NO: 14

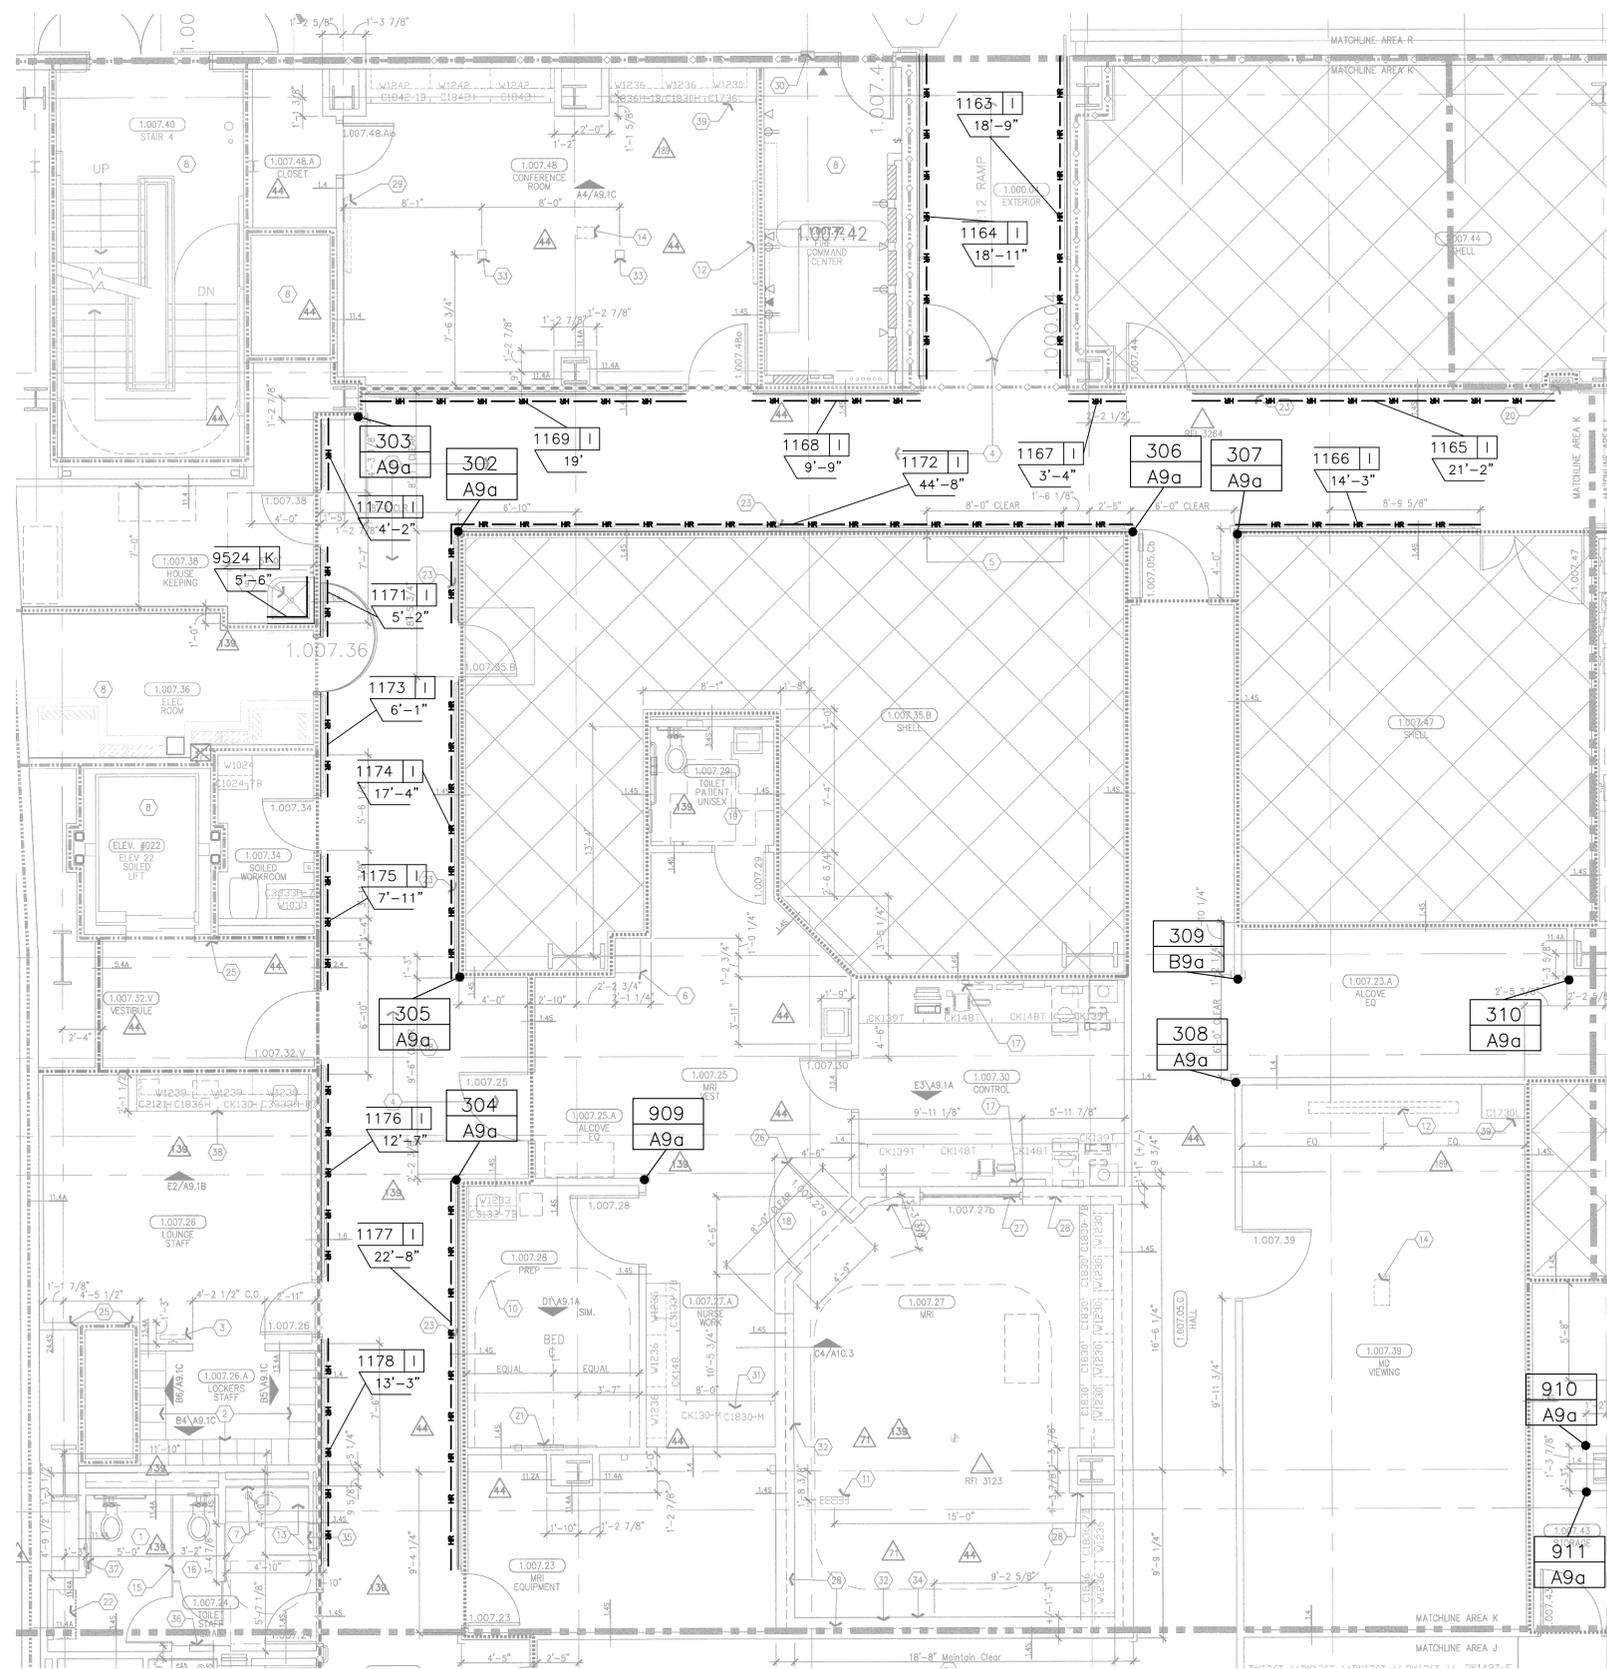

LEVEL 1 AREA "K"
 ARCHITECTURAL DRAWING REFERENCED A3.1K DATED 09/30/2008 3/16" = 1'-0"


NO.	REVISION	DATE	BY
1	1ST (RFI#688)	11/03/10	KAS
2	2ND (RETURNED DWG)	5/17/11	KAS
3	UPDATED DWGS & RFI'S	10/20/11	KAS
4	4TH (RETURNED DWG)	02/24/12	KAS

GENERAL NOTES:

CORNER GUARD SYMBOL

MARK #	A REF. SECTION
CODE	1 UNIT HEIGHT
	0 BASE HEIGHT/ELEV

COLOR/CODE	SECTION	UNIT HGT	BASE/ELEV	QTY
#253 PARCHMENT	A9a	A	9'-0"	N/A
#253 PARCHMENT	B9a	B	9'-0"	N/A

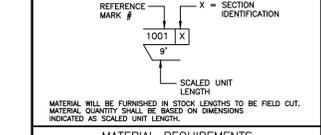

MATERIAL REQUIREMENTS

COLOR/CODE	SECTION	MODEL	L/F REQUIRED	LINE TYPE
#253 PARCHMENT	I	HRB4C	239'-0"	HR
#253 PARCHMENT	K	.060 WC @ 4'-0"	5'-6"	WC*

- MATERIAL LIST:
- A= SM20A
 - B= SSM25A
 - C= SM20M
 - D= NOT USED
 - E= NOT USED
 - F= C08
 - G= SC08
 - H= CO8M
 - I= HRB-4C
 - J= HRB-4C/SCR64M
 - K= .060 WC @ 4'-0"
 - L= .060 WC @ FH

CS Construction Specialties®
 6600 Ross 405 Highway, Manly PA 17756
 (800) 233-6400 • Fax: (317) 546-6000 • www.c-sgroup.com

This document is the property of Construction Specialties, Inc. and contains confidential proprietary information that is not to be disclosed to third parties and is not to be used without approval in writing from Construction Specialties, Inc.

PROJECT: CHILDREN'S HOSPITAL
 TOWER 2

JOB NO: 759986

CUSTOMER: L2 SPECIALTIES INC.


REP: #111 IMC

DRAWN BY: KYLE SMITH

SCALE: 3/16" = 1'-0"

DATE: 07/16/2010

SHEET NO: 15

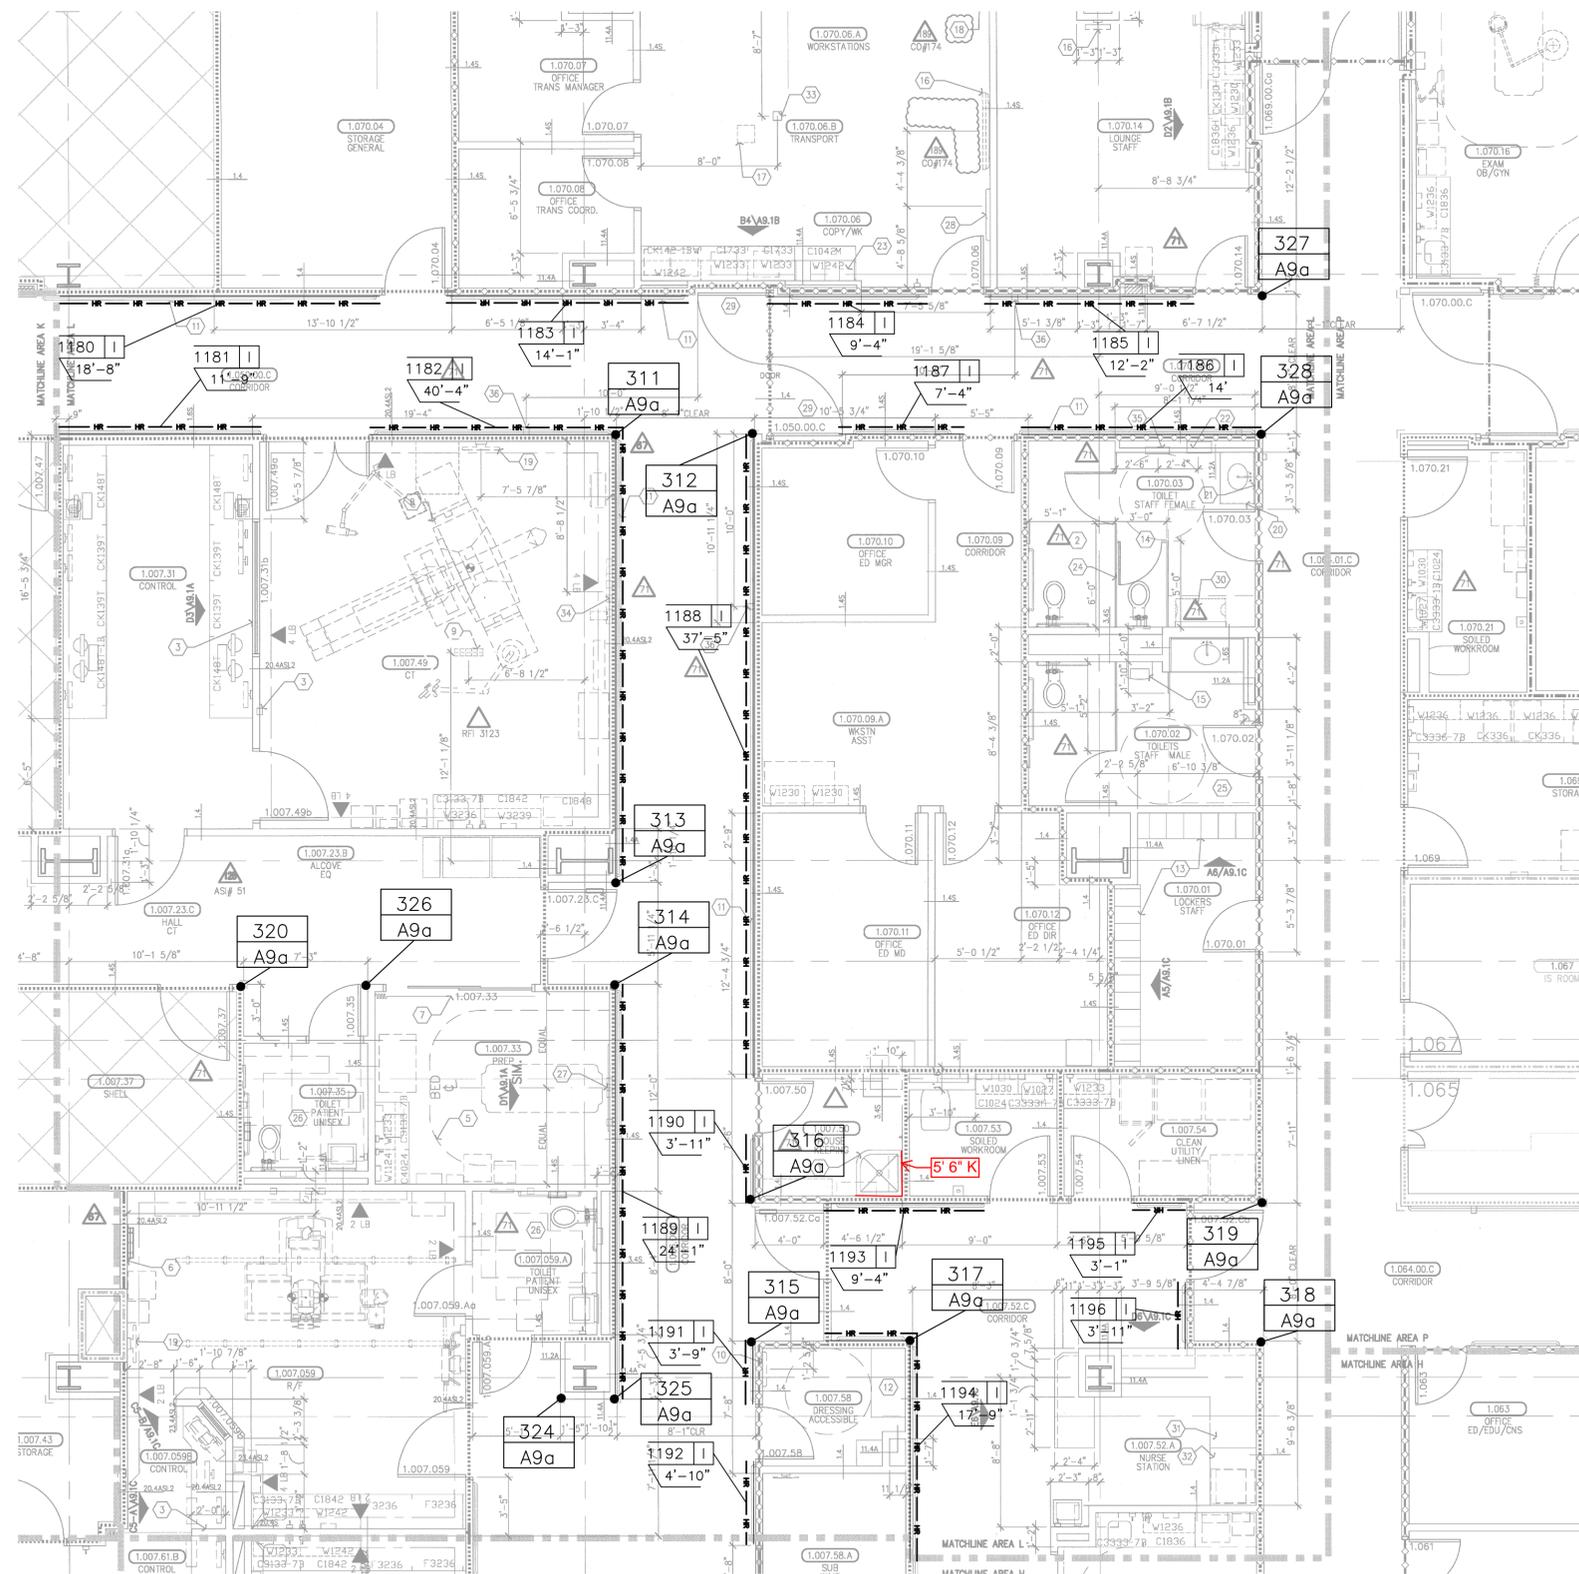

NO.	REVISION	DATE	BY
1	1ST (RFI#688)	11/03/10	KAS
2	2ND (RETURNED DWG)	5/17/11	KAS
3	UPDATED DWGS & RFIS	10/20/11	KAS
4	4TH (RETURNED DWG)	02/24/12	KAS

NO.	FILE & FIELD	DATE	BY

GENERAL NOTES:

CORNER GUARD SYMBOL
 MARK # [Symbol] A REF. SECTION
 [Symbol] CODE 1 UNIT HEIGHT
 [Symbol] BASE HEIGHT/ELEV

COLOR/CODE	CODE	SECTION	UNIT HGT	BASE/ELEV	QTY
#253 PARCHMENT	A9a	A	9'-0"	N/A	15

REFERENCE MARK # [Symbol] X = SECTION IDENTIFICATION
 [Symbol] 9'
 SCALED UNIT LENGTH
 MATERIAL WILL BE FURNISHED IN STOCK LENGTHS TO BE FIELD CUT. MATERIAL QUANTITY SHALL BE BASED ON DIMENSIONS INDICATED AS SCALED UNIT LENGTH.

COLOR/CODE	SECTION	MODEL	L/F REQUIRED	LINE TYPE
#253 PARCHMENT	I	HRB4C	235'-9"	HR

- MATERIAL LIST:
- A= SM20A
 - B= SSM25A
 - C= SM20M
 - D= NOT USED
 - E= NOT USED
 - F= C08
 - G= SC08
 - H= CO8M
 - I= HRB-4C
 - J= HRB-4C/SCR64M
 - K= .060 WC @ 4'-0"
 - L= .060 WC @ FH



This document is the property of Construction Specialties, Inc. and contains confidential proprietary information that is not to be disclosed to third parties and is not to be used without approval in writing from Construction Specialties, Inc.

LEVEL 1 AREA "L"
 ARCHITECTURAL DRAWING REFERENCED A3.1L DATED 03/28/2011 3/16" = 1'-0"

PROJECT: CHILDREN'S HOSPITAL
 TOWER 2
 JOB NO.: 759986
 CUSTOMER: L2 SPECIALTIES INC.
 REP: #111 IMC
 DRAWN BY: KYLE SMITH
 SCALE: 3/16" = 1'-0"
 DATE: 07/16/2010
 SHEET NO: 16

NO.	REVISION	DATE	BY
1	1ST (RF#688)	11/03/10	KAS
2	2ND (RETURNED DWG)	5/17/11	KAS
3	UPDATED DWGS & RF#S	10/20/11	KAS
4	4TH (RETURNED DWG)	02/24/12	KAS

NO.	FILE & FIELD	DATE	BY

GENERAL NOTES:

CORNER GUARD SYMBOL
 MARK # A REF. SECTION
 1 UNIT HEIGHT
 □ BASE HEIGHT/ELEV

COLOR/CODE	SECTION	UNIT HGT	BASE/ELEV	QTY	
#253 PARCHMENT	A9a	A	9'-0"	N/A	42
#253 PARCHMENT	B9a	B	9'-0"	N/A	1

REFERENCE MARK # X = SECTION IDENTIFICATION
 SCALED UNIT LENGTH
 MATERIAL WILL BE FURNISHED IN STOCK LENGTHS TO BE FIELD CUT.
 MATERIAL QUANTITY SHALL BE BASED ON DIMENSIONS INDICATED AS SCALED UNIT LENGTH.


COLOR/CODE	SECTION	MODEL	L/F REQUIRED	LINE TYPE
#253 PARCHMENT	I	HRB4C	230'-3"	HR
#253 PARCHMENT	K	.040 WC @ 4'-0"	36'-4"	WORK*

MATERIAL LIST:
 A= SM20A
 B= SSM25A
 C= SM20M
 D= NOT USED
 E= NOT USED
 F= C08
 G= SC08
 H= C08M
 I= HRB-4C
 J= HRB-4C/SCR64M
 K= .060 WC @ 4'-0"
 L= .060 WC @ FH




This document is the property of Construction Specialties, Inc. and contains confidential proprietary information that is not to be disclosed to third parties and is not to be used without approval in writing from Construction Specialties, Inc.

PROJECT: CHILDREN'S HOSPITAL TOWER 2
 JOB NO.: 759986
 CUSTOMER: L2 SPECIALTIES INC.
 REP: #111 IMC
 DRAWN BY: KYLE SMITH
 SCALE: 3/16" = 1'-0"
 DATE: 07/16/2010
 SHEET NO: 17

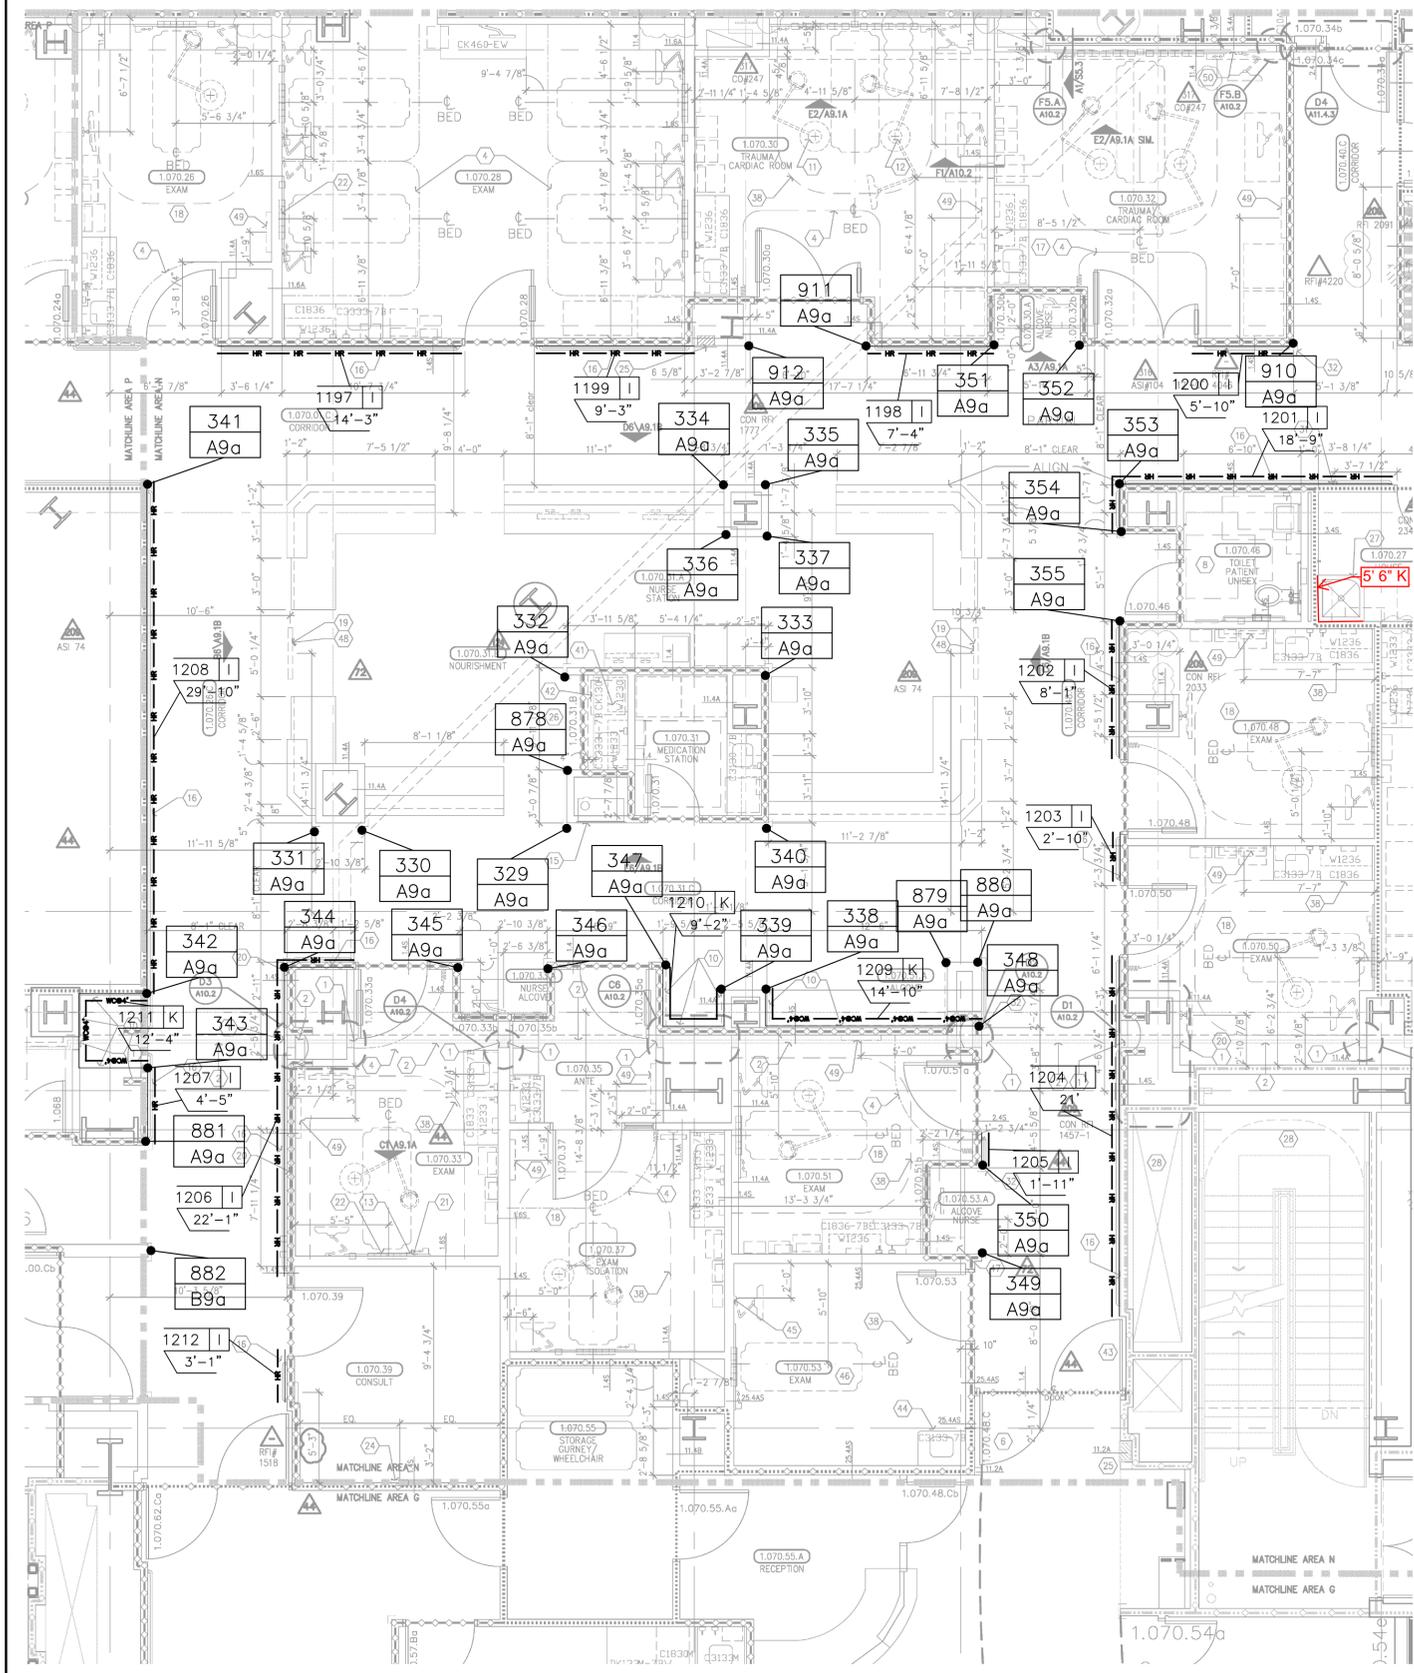

LEVEL 1 AREA "N"
 ARCHITECTURAL DRAWING REFERENCED A3.1N DATED 08/24/2011
 3/16" = 1'-0"

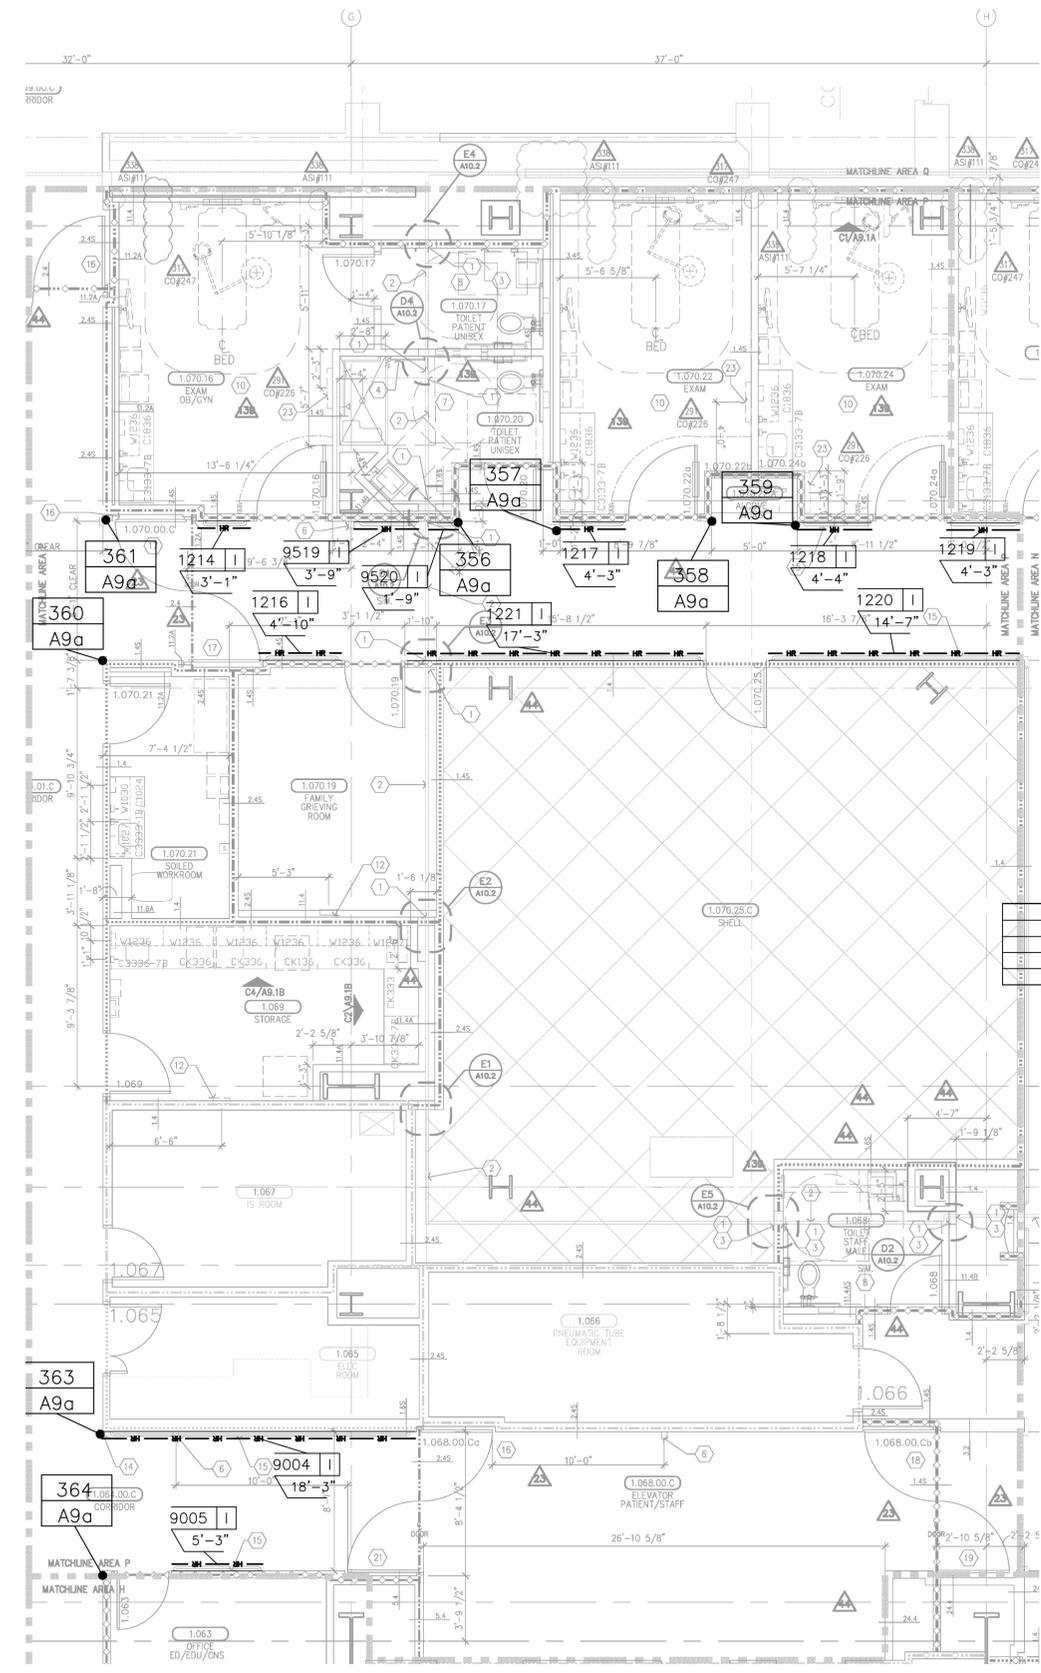

LEVEL 1 AREA "P"
 ARCHITECTURAL DRAWING REFERENCED A3.1P DATED 09/30/2008
 3/16" = 1'-0"


NO.	REVISION	DATE	BY
1	1ST (RFI#688)	11/03/10	KAS
2	2ND (RETURNED DWG)	5/17/11	KAS
3	UPDATED DWGS & RFI'S	10/20/11	KAS
4	4TH (RETURNED DWG)	02/24/12	KAS

NO.	FILE & FIELD	DATE	BY

GENERAL NOTES:

CORNER GUARD SYMBOL
 MARK #
 A REF. SECTION
 1 UNIT HEIGHT
 a BASE HEIGHT/ELEV

COLOR/CODE	SECTION	UNIT HGT	BASE/ELEV	QTY
STAINLESS STEEL	F7b	F	X	22
STAINLESS STEEL	G7b	G	X	1

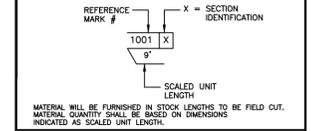

COLOR/CODE	SECTION	MODEL	L/F REQUIRED	LINE TYPE
#253 PARCHMENT	K	.040 WC @ 4'-0"	5'-4"	--- WC#
#253 PARCHMENT	L	.040 WC @ FHT	169'-10"	--- WC#


MATERIAL LIST:

A= SM20A
 B= SSM25A
 C= SM20M
 D= NOT USED
 E= NOT USED
 F= C08
 G= SC08
 H= CO8M
 I= HRB-4C
 J= HRB-4C/SCR64M
 K= .060 WC @ 4'-0"
 L= .060 WC @ FH




This document is the property of Construction Specialties, Inc. and contains confidential proprietary information that is not to be disclosed to third parties and is not to be used without approval in writing from Construction Specialties, Inc.


PROJECT: CHILDREN'S HOSPITAL
 TOWER 2
 JOB NO.: 759986
 CUSTOMER: L2 SPECIALTIES INC.
 REP: #111 IMC
 DRAWN BY: KYLE SMITH
 SCALE: 3/16" = 1'-0"
 DATE: 07/16/2010
 SHEET NO: 18

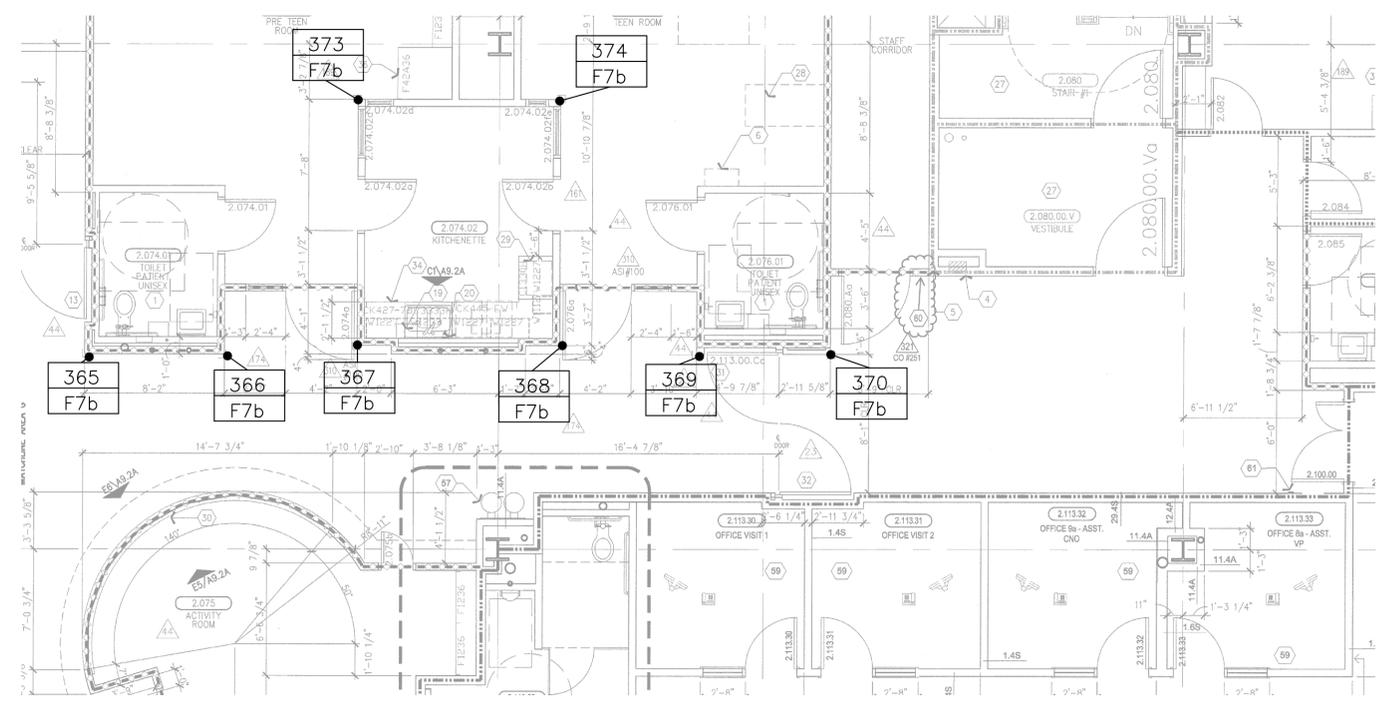

LEVEL 2 AREA "G"
 ARCHITECTURAL DRAWING REFERENCED A3.2G DATED 08/16/2011
 3/16" = 1'-0"

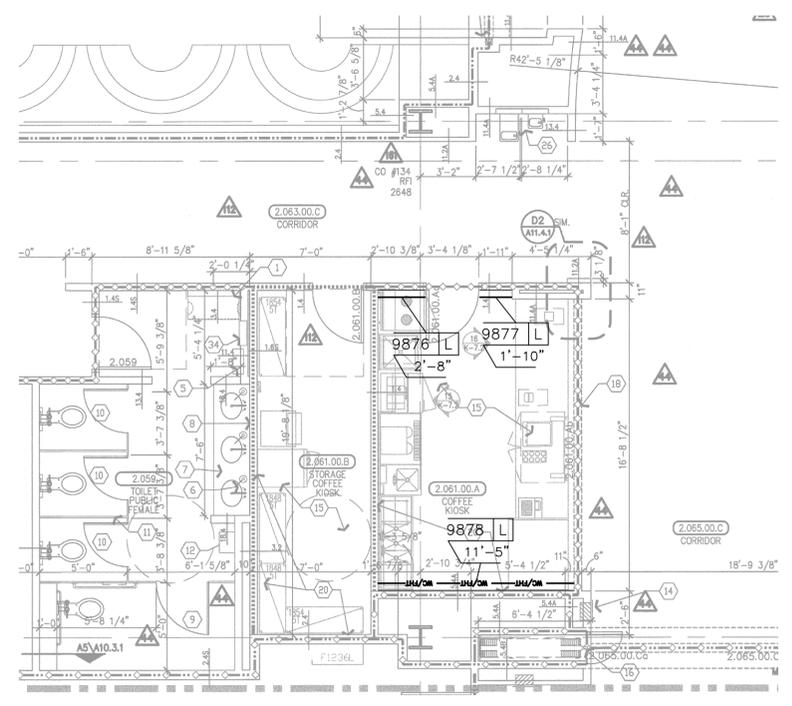

LEVEL 2 AREA "L"
 ARCHITECTURAL DRAWING REFERENCED A3.2L DATED 08/16/2011
 3/16" = 1'-0"

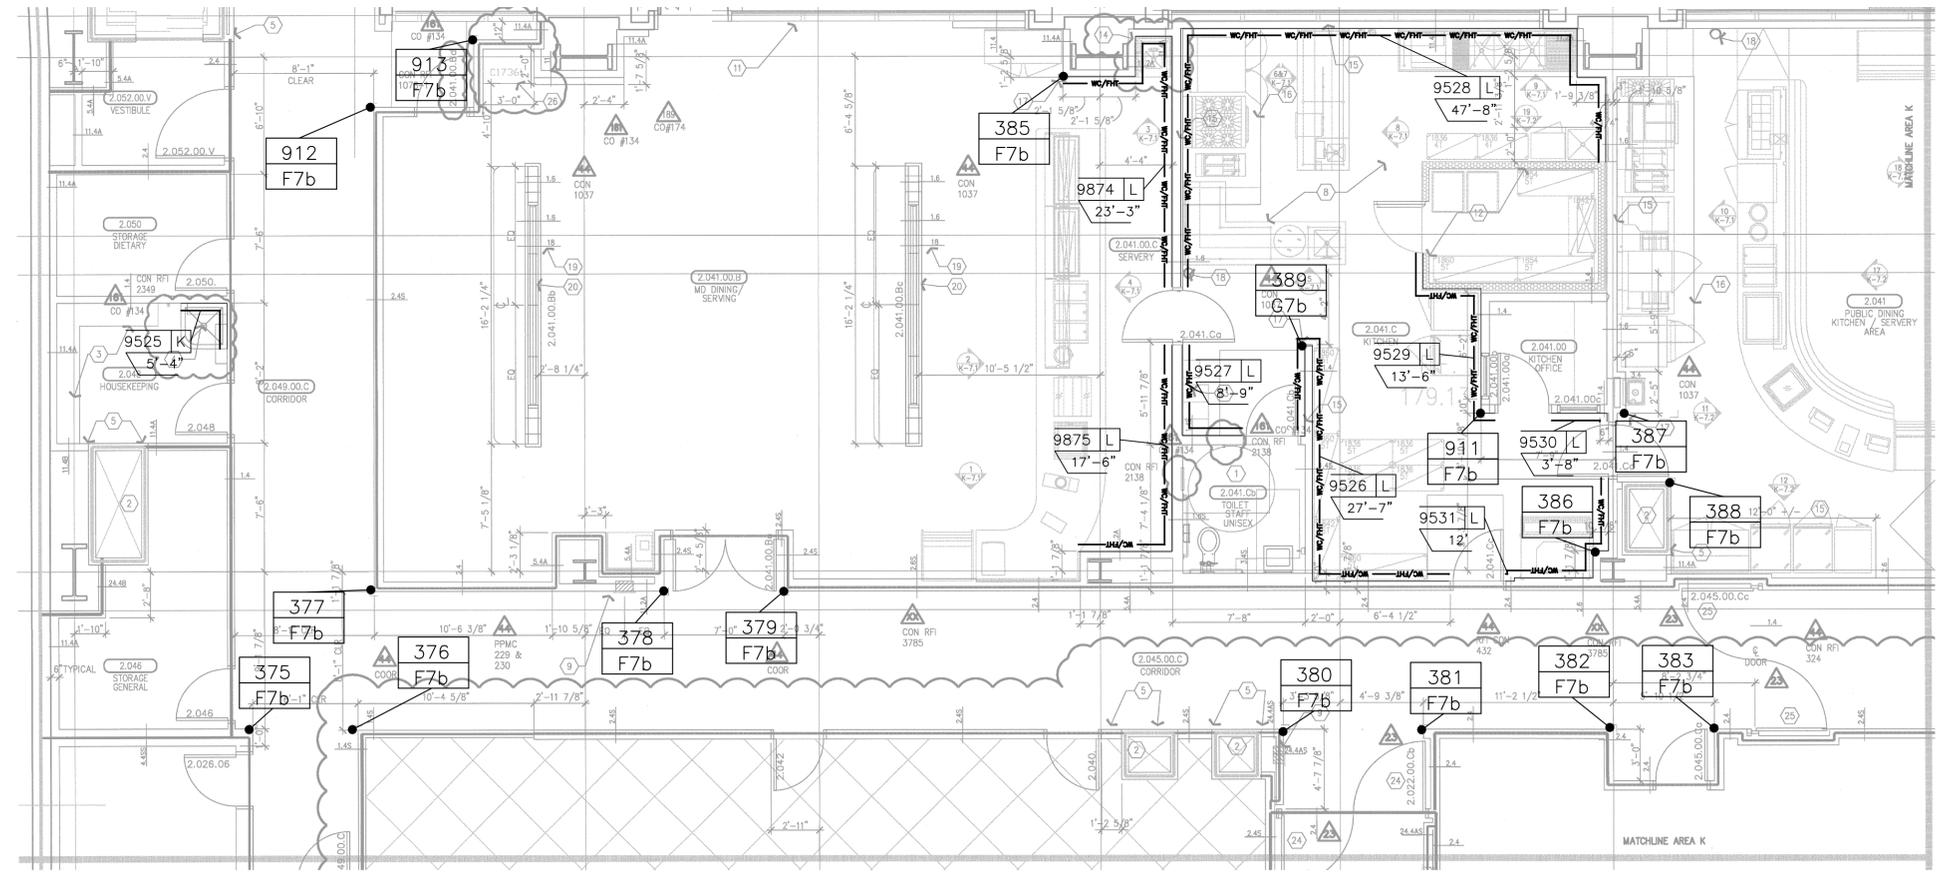

LEVEL 2 AREA "K"
 ARCHITECTURAL DRAWING REFERENCED A3.2K DATED 03/01/2011
 3/16" = 1'-0"



FKP Architects

ARCHITECT OF RECORD
Paul C. Glorid



Changes on these drawings do not consist of materially altered drawings to approved drawings and don't require a change order.
OSHPD review ACO
OSHPD review FLSO
OSHPD review DSE

REVISIONS

4A	05/28/10	ASI #08
23	05/10/10	CO #25
10	10/25/10	ASI #6
13A	12/6/10	CO #109
16	03/01/11	CO #134
6A	08/08/11	CO #135

APPROVAL



CHANGE ORDER #135
INSTRUCTION BULLETIN
DEFERRED APPROVAL #10
IDENDUM #

PROJECT NAME
CHILDREN'S HOSPITAL OF ORANGE COUNTY
455 S. Main St.
Orange, CA 92668-3874

TOWER II RECEIVED
SEPT. 21 2011
MCCARTHY



PROJECT NUMBER
12011.00
Increment #7

OSHPD - PROJECT NUMBER
IL 072072-30

ISSUE
OSHPD PERMIT


DATE
01/27/2010

SCALE
1/4" = 1' - 0"

DRAWING TITLE
LEVEL 2 ENLARGED PLAN AREA - L

DRAWING NUMBER

A3.2L

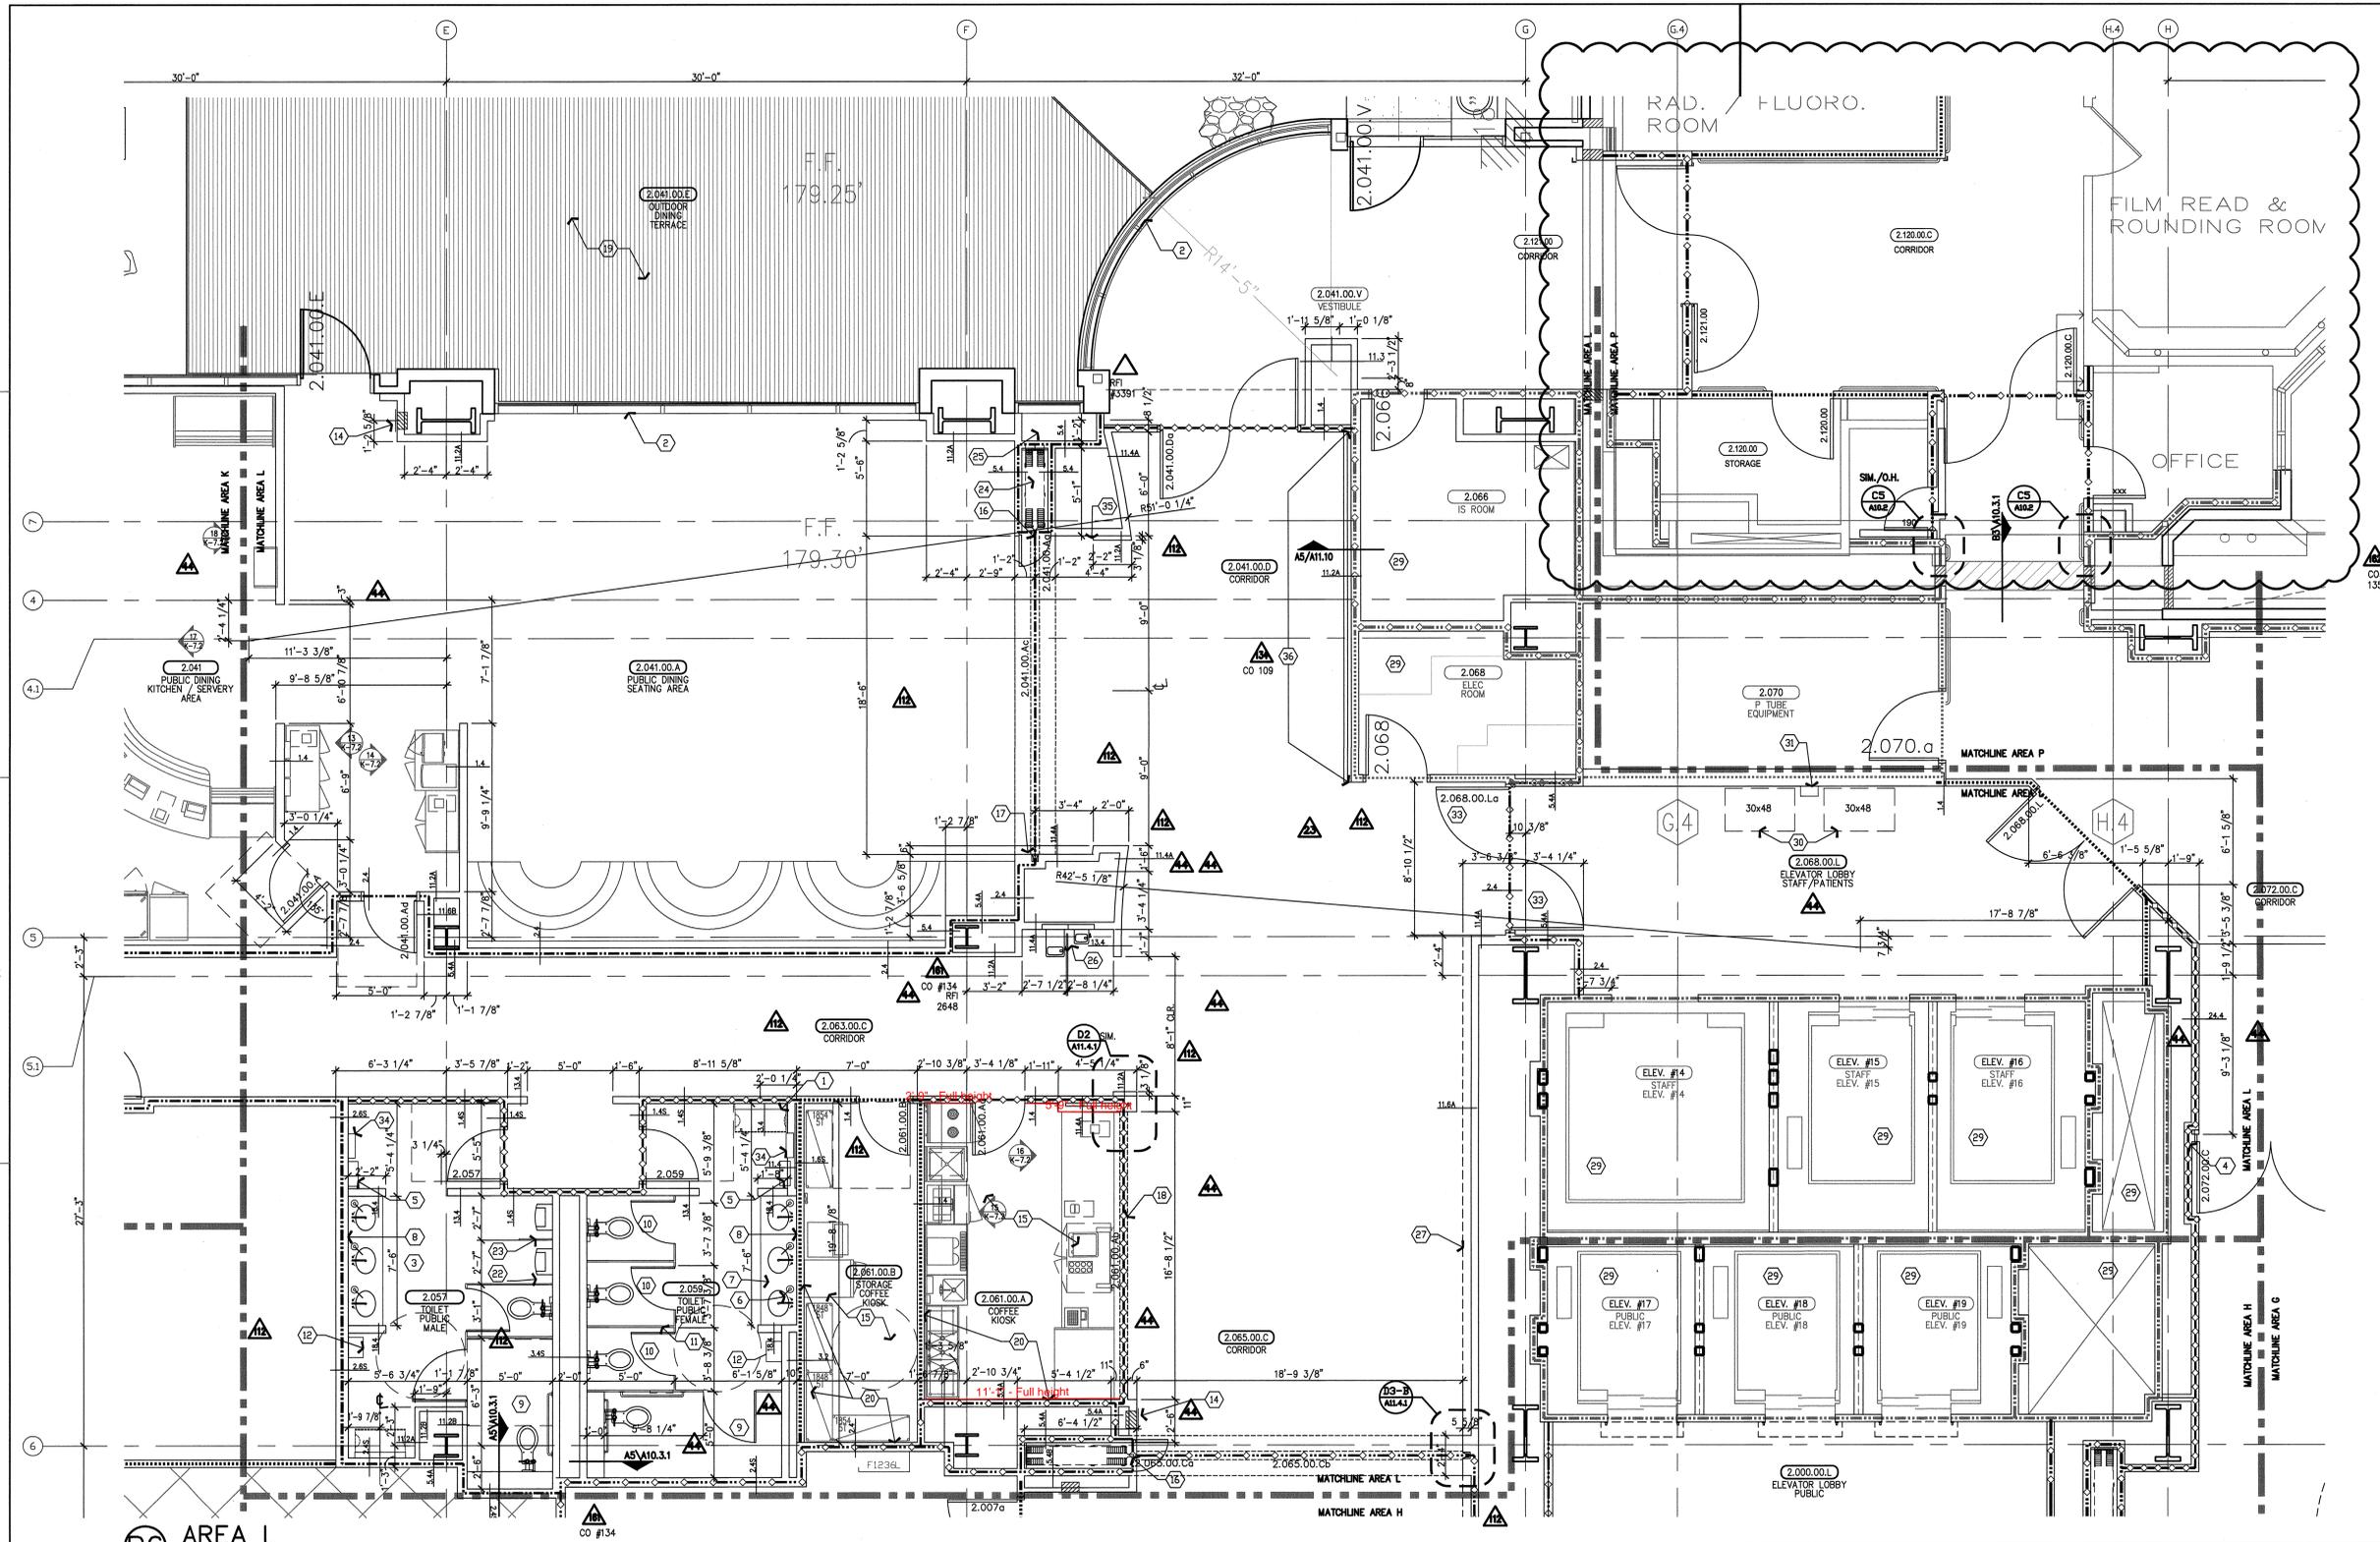


- (B6) AREA L**
1. Changing station, wall mounted, see D6/A11.8.
 2. Window treatment, roller window shade, typical at all exterior glazing. U.N.O.
 3. See room 2.059 for typical note designations.
 4. Integrated double egress door, wall recessed. See D5/A11.4 for detail.
 5. Fully recessed paper towel and trash receptacle. See B6/A11.7.
 6. Soap dispenser, lavatory mounted.
 7. Solid surface material countertop. See A2/A11.7 for detail.
 8. Mirror, full width of counter, from top of splash to 7'-0" A.F.F.
 9. Accessible toilet stall. See A5 & B5/A11.7 for detail.
 10. Toilet stall. See A4/A11.7 for mounting heights.
 11. Toilet partition, floor mounted.
 12. Paper towel dispenser, wall mounted, OFD, see Equipment drawings and workbook.
 13. Pocs, cabinet, pc, keyboard, monitor and mouse, wall mounted, see Equipment drawings and workbook. See A1/S3.6.
 14. Fire extinguisher and/or fire valve cabinet, wall recessed, point to match adjacent wall, typical. See B2/A11.8 for detail.
 15. Kitchen equipment. See Food Services drawings.
 16. Accordion fire door. See detail B4/A11.4.
 17. Accordion fire door jamb. See detail B5/A11.4.1.
 18. Fire shutter, automatic roll down, ceiling recessed.
 19. Outdoor Terrace, see landscape drawings.
 20. Provide wall blocking for partition, full height to ceiling height, U.N.O. per detail A6/A11.3.1.
 21. Wall mounted TV, see Audio Visual drawings. See Structural detail A2/S3.4 similar.
 22. Urinal. See detail D4A/A11.7.
 23. Urinal screen, wall mounted, see detail D4A/A11.7. Provide wall blocking per detail A6/A11.3.1 similar.
 24. Accordion partition pocket.
 25. Back partition to clear beam.
 26. Electric drinking fountains. See detail D2/A11.8.
 27. Decorative wall panels. See D3/A11.3.
 28. Overhead ceiling door. See Door Schedule.
 29. For construction requirements this area, see Increment #6, Vol. 2A & 2B.
 30. 30"x48" refuge space.
 31. 2-Way communication system and signage.
 32. Security grille remains open during business hours, retracts during fire alarm.
 33. Integrated double egress door, wall recessed. See D4/A11.4.2 Sm
 34. Sanitary dispenser. See B6/A11.7 for mounting location.
 35. Align edge of wall with edge of wall on south side of folding door.
 36. Proposed "Donor Signage Wall".

(A6) NOTES TO SHEET

- (A4) GENERAL NOTES**
- A. Information shown or referenced on enlarged and/or 1/4" scale drawings will generally not be shown on the smaller scale drawings.
 - B. Partition types are scheduled on plans by number. See the "General Notes to Partition Types" on B2/A11.3 and Partition Types on Sheet A11.3.1, A11.3.1, and A11.3.2 for the definition of partition type references.
 - C. Field coordinate all field routed pipe, conduit runs, etc., with locations of recessed accessories and equipment. In the event of a conflict, accessory locations take precedence.
 - D. Close all joints between plumbing fixtures/accessories and dissimilar materials w/sealant (i.e. between sinks and countertops, toilet fixtures and accessories to wall, etc.)
 - E. Cabinet numbers noted on enlarged plans refer to cabinet component numbers, fixtures, accessories, etc. that are defined or elevated on Sheet A9.0 unless specific detail references are keyed.
 - F. Plan dimensions - refer to B2/A11.3 (General Notes).
 - G. For vertical mounting heights of shower accessories, See Detail D6/A11.7.
 - H. For vertical mounting heights of accessible toilet stall accessories, See Detail A5/A11.7.
 - I. For vertical mounting heights of typical restroom accessories, See Detail B6/A11.7.
 - J. For vertical mounting heights of accessible accessories at restrooms, See Detail A5/A11.7.
 - K. For equipment not identified on plan, see Equipment drawings and workbook-Increment#7, Vol. 2E.
 - L. For equipment not identified on plan, see Equipment drawings and workbook-Increment#7, Vol. 2E.
 - M. For partial enlarged plan at janitor closets, See Detail A5/A11.7.
 - N. Public/Handcapped restroom graphics will be furnished and installed by the Owner's graphics supplier.
 - O. Standard equipment wall mounting heights, see detail A2/A11.9.
 - P. Medical equipment wall mounting heights, see details A4/A11.9, D3/A11.9 & Q0-Increment #7, Vol. 2E.
 - Q. Fire Protection equipment wall Mounting Heights, see detail D2/A11.9 & R. Communication equipment wall Mounting Heights, see detail A3/A11.9.
 - S. Equipment mounting heights at Countertops, see detail D3/A11.9.
 - T. Equipment mounting heights of Desks, see detail A4/A11.9.
 - U. A minimum head clearance of 6'-8" must be maintained at all points in stairways including stair and landing framing.
 - V. For all dashed in equipment not identified, refer to EQ drawing series-Increment #7, Vol. 2E and Equipment workbook. Specific items requiring structural support are cross referenced to structural support details via matrix shown on the Equipment drawing-Increment #7, Vol. 2E.
 - W. All elevator hoist way entrance frames to have an embossed stainless steel graphic plaque with the floor landing number and Standard Braille markings for the blind. Conform to governing Accessibility codes and standards.
 - X. All stair floor landings to receive stencil painted, semi-gloss enamel floor landing numerals 12" high adjacent to the door at 5'-0" AFF in a contrasting color to the scheduled wall color unless a graphic plaque is specifically detailed or noted.
 - Y. Elevator Equipment wall mounting heights, see detail A6/A11.9 and B3/A11.9.
 - Z. Doors, Frames, Sidelites and Windows: (See Door Schedule). See A11 sheet series.
 - AA. Provide wall blocking for items weighing 20lbs or less. See A6/A11.3.1.
 - BB. For personal effects storage unit types and sizes see A4/A11.8.
 - CC. For typical equipment backing support, see A4/S3.1-Increment #5.
 - DD. For boundaries of alternates and phases, see the AP drawing series.
 - EE. Provide 3" grommet, unless otherwise noted at 3'-0" O.C. maximum, field located at all electrical components at Nurses stations and Reception desks.
 - FF. For vertical mounting heights of service accessories, See Detail A3/A11.7-Increment#7, Vol. 2E.
 - GG. Provide access points below the Patient Room countertops to serve as inspection

(A4) GENERAL NOTES

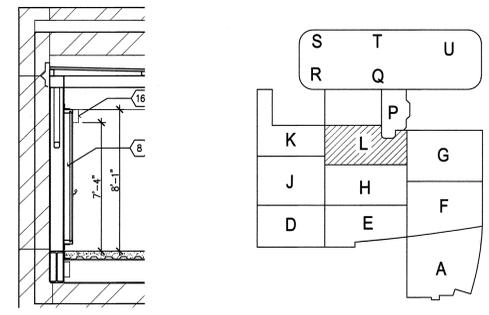

(A1) KEY PLAN

NO.	REVISION	DATE	BY
1	1ST (RFI#688)	11/03/10	KAS
2	2ND (RETURNED DWG)	5/17/11	KAS
3	UPDATED DWGS & RFIS	10/20/11	KAS
4	4TH (RETURNED DWG)	02/24/12	KAS


NO.	FILE & FIELD	DATE	BY

GENERAL NOTES:

CORNER GUARD SYMBOL

MARK #	A REF. SECTION
CODE	1 UNIT HEIGHT
BASE HEIGHT/ELEV	


COLOR/CODE	SECTION	UNIT HGT	BASE/ELEV	QTY
#253 PARCHMENT	A9a	A	9'-0"	N/A
#253 PARCHMENT	B9a	B	9'-0"	N/A

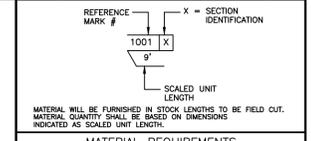

MATERIAL REQUIREMENTS

COLOR/CODE	SECTION	MODEL	L/F REQUIRED	LINE TYPE
#253 PARCHMENT	I	HRB4C	119'-4"	HR
#253 PARCHMENT	K	.040 WC @ 4'-0"	14'-11"	WCP

- MATERIAL LIST:
- A= SM20A
 - B= SSM25A
 - C= SM20M
 - D= NOT USED
 - E= NOT USED
 - F= CO8
 - G= SC08
 - H= CO8M
 - I= HRB-4C
 - J= HRB-4C/SCR64M
 - K= .060 WC @ 4'-0"
 - L= .060 WC @ FH

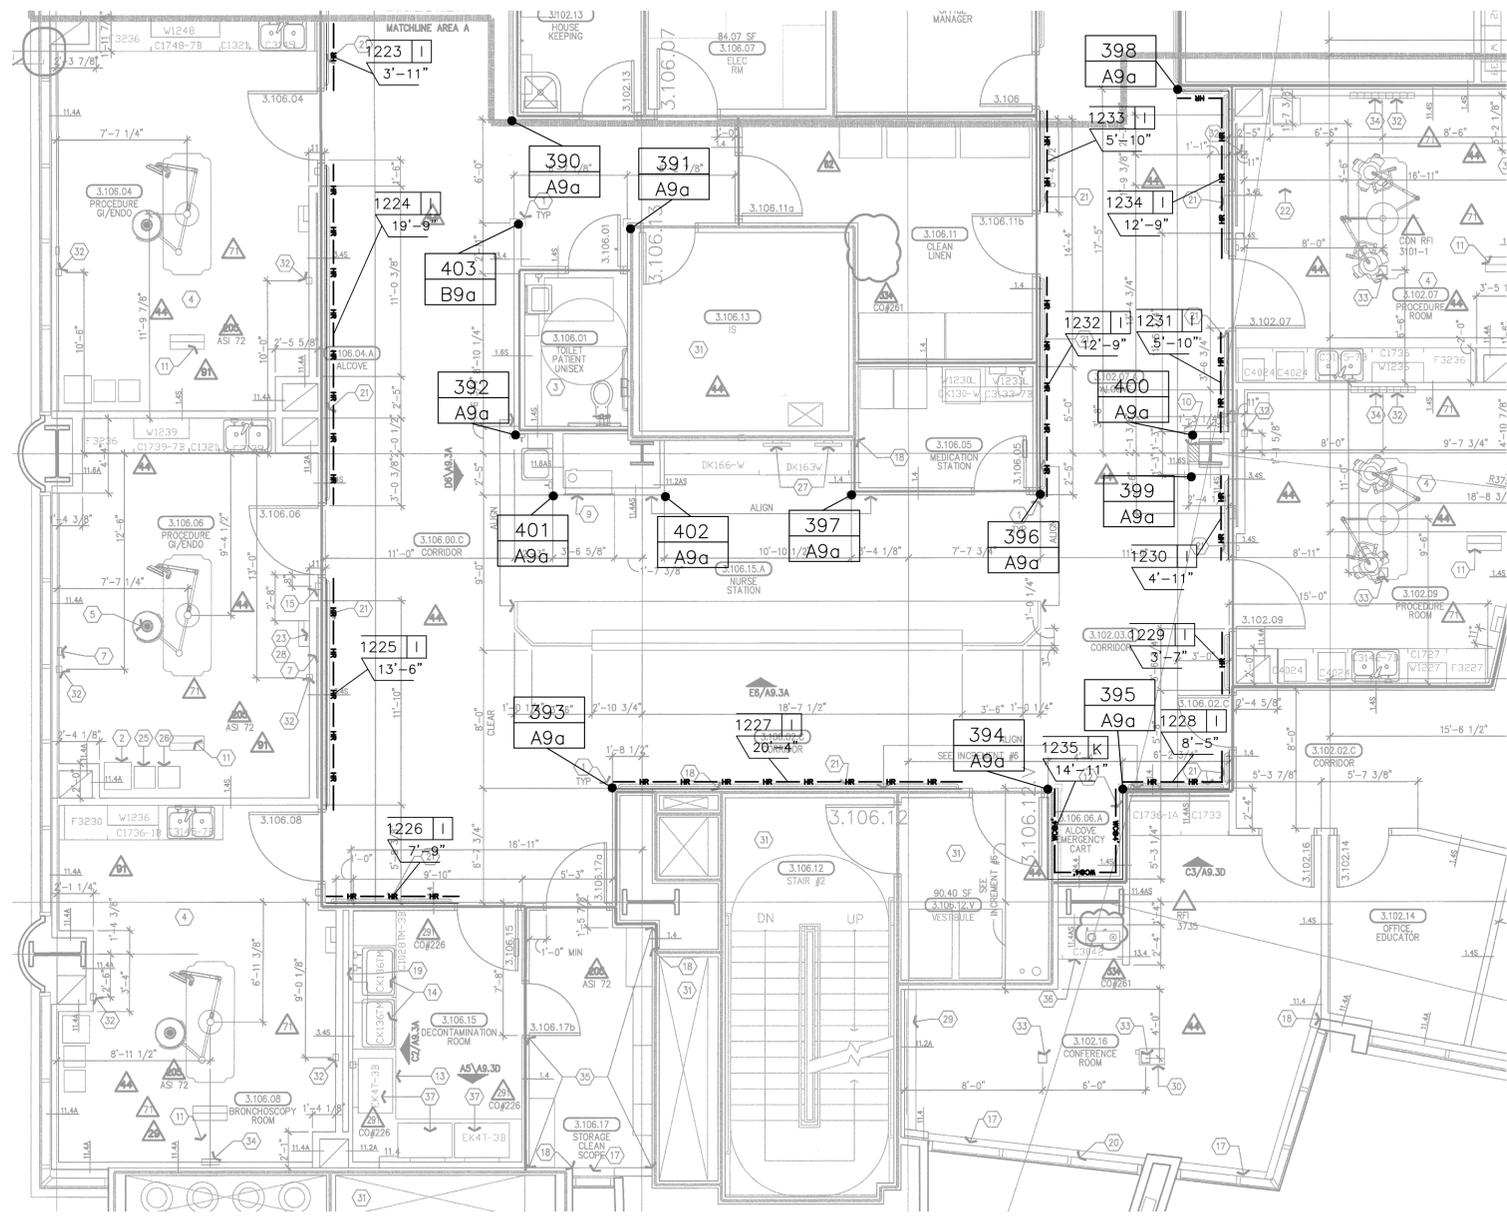

LEVEL 3 AREA "A"
ARCHITECTURAL DRAWING REFERENCED A3.3A DATED 09/09/2011 3/16" = 1'-0"

CS Construction Specialties
6600 Ross 405 Highway, Manly PA 17756
(800) 233-8400 • Fax: (717) 546-6000 • www.c-s-group.com

This document is the property of Construction Specialties, Inc. and contains confidential proprietary information that is not to be disclosed to third parties and is not to be used without approval in writing from Construction Specialties, Inc.

PROJECT: CHILDREN'S HOSPITAL TOWER 2
JOB NO.: 759986
CUSTOMER: L2 SPECIALTIES INC.
REP: #111 IMC
DRAWN BY: KYLE SMITH
SCALE: 3/16" = 1'-0"
DATE: 07/16/2010
SHEET NO: 19

NO.	REVISION	DATE	BY
1	1ST (RFI#688)	11/03/10	KAS
2	2ND (RETURNED DWG)	5/17/11	KAS
3	UPDATED DWGS & RFI'S	10/20/11	KAS
4	4TH (RETURNED DWG)	02/24/12	KAS


NO.	FILE & FIELD	DATE	BY

GENERAL NOTES:

CORNER GUARD SYMBOL

MARK #	A REF. SECTION
CODE	1 UNIT HEIGHT
	0 BASE HEIGHT/ELEV

COLOR/CODE	CODE	SECTION	UNIT HGT	BASE/ELEV	QTY
#253 PARCHMENT	A9a	A	9'-0"	N/A	12
#253 PARCHMENT	B9a	B	9'-0"	N/A	1

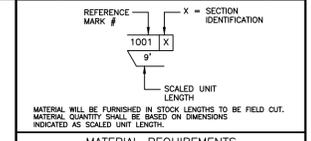

MATERIAL REQUIREMENTS

COLOR/CODE	SECTION	MODEL	L/F REQUIRED	LINE TYPE
#253 PARCHMENT	I	HRB4C	248'-4"	HR
#253 PARCHMENT	K	.040 WC @ 4'-0"	11'-10"	WCP

- MATERIAL LIST:
- A= SM20A
 - B= SSM25A
 - C= SM20M
 - D= NOT USED
 - E= NOT USED
 - F= CO8
 - G= SC08
 - H= CO8M
 - I= HRB-4C
 - J= HRB-4C/SCR64M
 - K= .060 WC @ 4'-0"
 - L= .060 WC @ FH



This document is the property of Construction Specialties, Inc. and contains confidential proprietary information that is not to be disclosed to third parties and is not to be used without approval in writing from Construction Specialties, Inc.

PROJECT: CHILDREN'S HOSPITAL
TOWER 2

JOB NO.: 759986

CUSTOMER: L2 SPECIALTIES INC.


REP: #111 IMC

DRAWN BY: KYLE SMITH

SCALE: 3/16" = 1'-0"

DATE: 07/16/2010

SHEET NO: 20

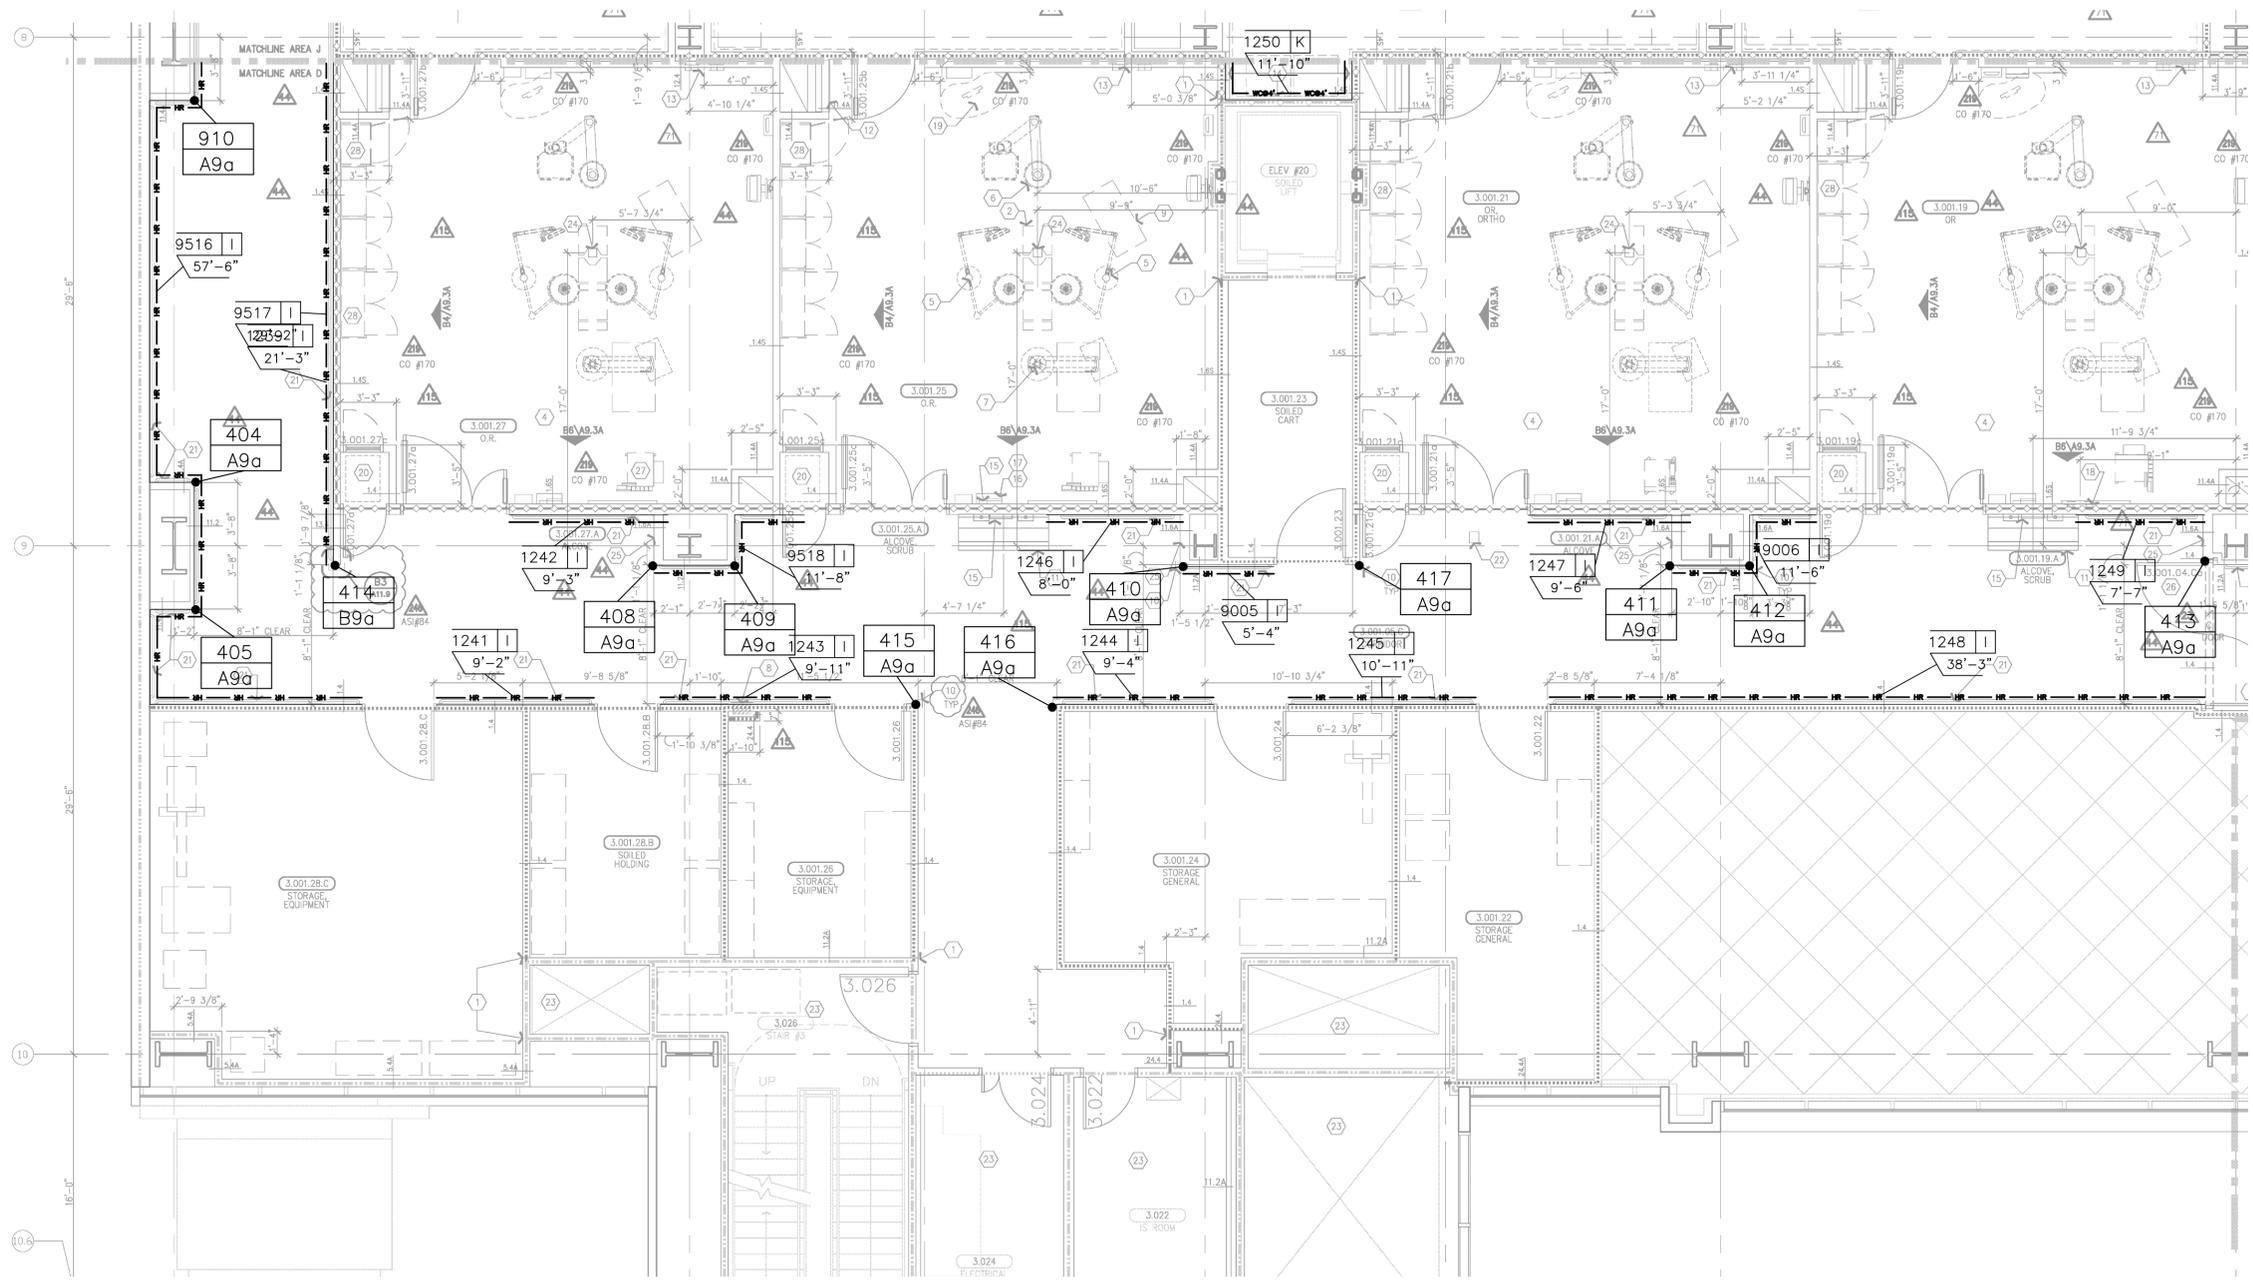


LEVEL 3 AREA "D"
ARCHITECTURAL DRAWING REFERENCED A3.3D DATED 05/09/11 3/16" = 1'-0"

NO.	REVISION	DATE	BY
1	1ST (RFI#688)	11/03/10	KAS
2	2ND (RETURNED DWG)	5/17/11	KAS
3	UPDATED DWGS & RFI'S	10/20/11	KAS
4	4TH (RETURNED DWG)	02/24/12	KAS

NO.	FILE & FIELD	DATE	BY

GENERAL NOTES:


COLOR/CODE	SECTION	UNIT	HGT	BASE/ELEV	QTY
#253 PARCHMENT	A9a	A	9'-0"	N/A	13
#253 PARCHMENT	B9a	B	9'-0"	N/A	2
#253 PARCHMENT	C9a	C	9'-0"	N/A	1

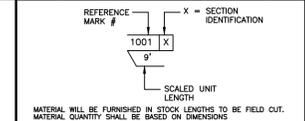

MATERIAL REQUIREMENTS				
COLOR/CODE	SECTION	MODEL	L/F REQUIRED	LINE TYPE
#253 PARCHMENT	I	HRB4C	289'-10"	HR
#253 PARCHMENT	K	.040 WC @ 4'-0"	21'-10"	WOP

MATERIAL LIST:

A= SM20A
 B= SSM25A
 C= SM20M
 D= NOT USED
 E= NOT USED
 F= C08
 G= SC08
 H= C08M
 I= HRB-4C
 J= HRB-4C/SCR64M
 K= .060 WC @ 4'-0"
 L= .060 WC @ FH

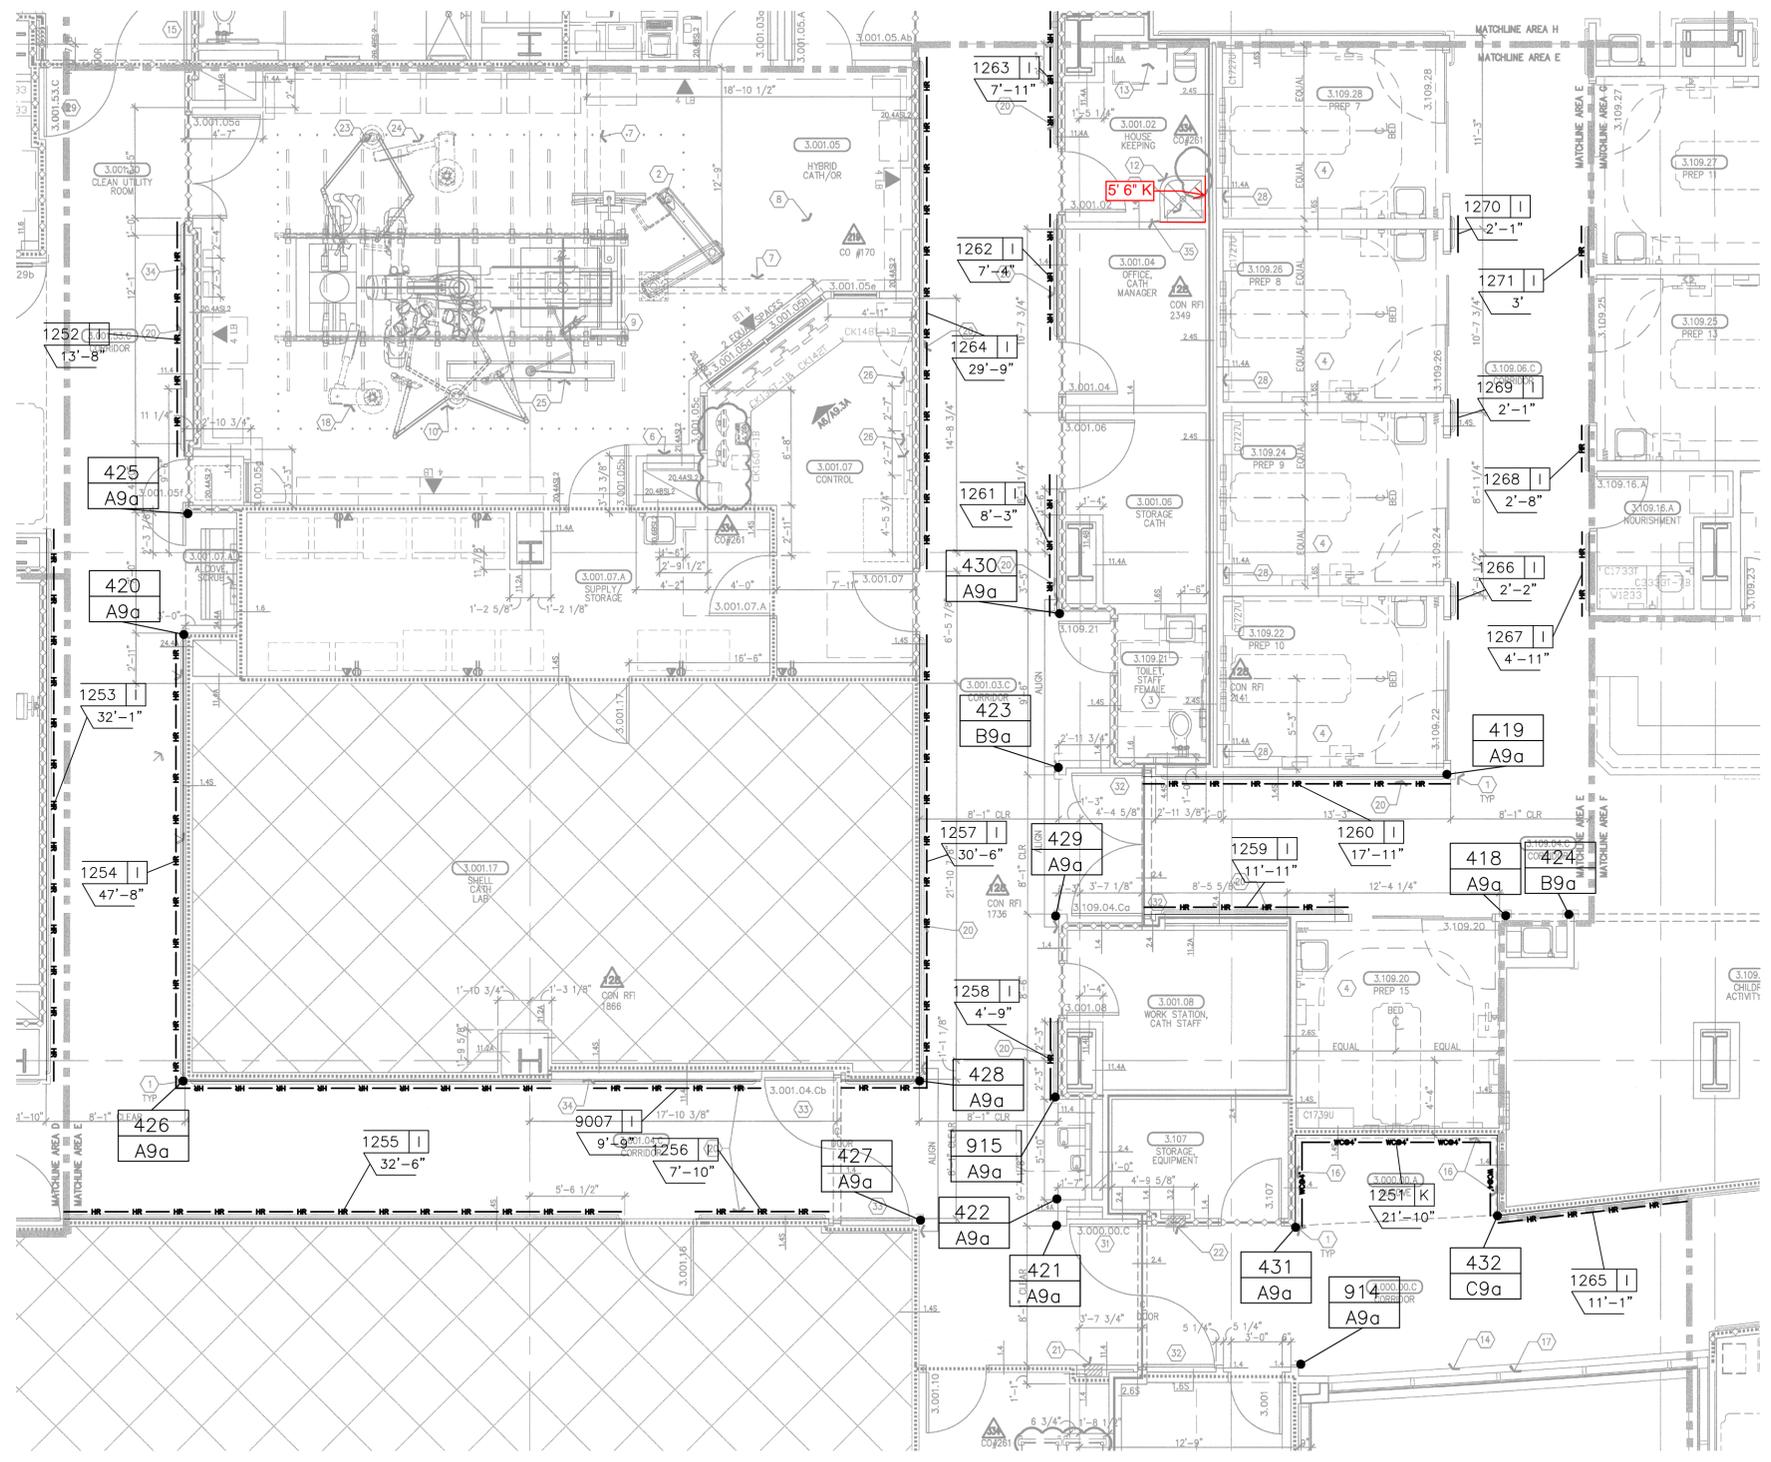

#7 det
 11. Not a
 12. Janitor
 13. 14" dia
 14. 8" dia
 15. Integro
 16. Sheet
 17. Window
 18. U.I.O.
 19. Anesth
 20. Increm
 21. Clock,
 22. proceed
 23. Handro
 24. Fire vo
 25. or A2/
 26. Fire vo
 27. wall, t)
 28. Suppor
 29. Equipm
 30. Perfusi
 31. Equipm
 32. X-ray
 33. Equipm
 34. Apron
 35. Equipm
 36. OSHPD
 37. Elimino
 38. Integro
 39. Integro
 40. Integro
 41. Integro
 42. Operall
 43. Pol h
 44. Chemi

D1 N
 2 L REF
 4 L REF
 C1 LE
 B1 GE

A. Informator not be sh
 B. Partition (Partition T for the de
 C. Field coor accessories: precedences
 D. Close oil w/seatant, etc.)
 E. Cabinet nu Sutures, or detail refer
 F. Fin dimer
 G. For vertico A5/A11.7.
 H. For vertico A6/A11.7.
 I. For equipr workbooks
 J. For partial N. Public/hon graphics as
 O. Standard e
 P. Medical eq Q0.02-inc
 Q. Fire Protec R. Communic
 S. Equipmen
 T. Equipmen U. A minimum including s
 V. For oil dos Vol. 2E on cross refer drawings-ll
 W. All elevato plaque with Conform to
 X. All stair ls numero 1 scheduled
 Y. Elevator Et
 Z. Doors, Fire AA. Provide v
 BB. For pers
 CC. For typic
 DD. For boan
 EE. Provide J
 FF. For verti
 GG. Provide c parts for

LEVEL 3 AREA "E"
 ARCHITECTURAL DRAWING REFERENCED A3.3E DATED 09/30/2008 3/16" = 1'-0"



This document is the property of Construction Specialties, Inc. and contains confidential proprietary information that is not to be disclosed to third parties and is not to be used without approval in writing from Construction Specialties, Inc.

PROJECT: CHILDREN'S HOSPITAL TOWER 2
 JOB NO.: 759986
 CUSTOMER: L2 SPECIALTIES INC.
 REP: #111 IMC
 DRAWN BY: KYLE SMITH
 SCALE: 3/16" = 1'-0"
 DATE: 07/16/2010
 SHEET NO: 21

NO.	REVISION	DATE	BY
1	1ST (RFI#688)	11/03/10	KAS
2	2ND (RETURNED DWG)	5/17/11	KAS
3	UPDATED DWGS & RFI'S	10/20/11	KAS
4	4TH (RETURNED DWG)	02/24/12	KAS

NO.	FILE & FIELD	DATE	BY

GENERAL NOTES:


CORNER GUARD SYMBOL
 MARK # A REF. SECTION
 CODE 1 UNIT HEIGHT
 o BASE HEIGHT/ELEV

COLOR/CODE	CODE	SECTION	UNIT HGT	BASE/ELEV	QTY
#253 PARCHMENT	A9a	A	9'-0"	N/A	14
#253 PARCHMENT	B9a	B	9'-0"	N/A	3
#253 PARCHMENT	C9a	C	9'-0"	N/A	2

REFERENCE MARK # X = SECTION IDENTIFICATION
 1001 X
 9'
 SCALED UNIT LENGTH
 MATERIAL WILL BE FURNISHED IN STOCK LENGTHS TO BE FIELD CUT. MATERIAL QUANTITY SHALL BE BASED ON DIMENSIONS INDICATED AS SCALED UNIT LENGTH.

COLOR/CODE	SECTION	MODEL	L/F REQUIRED	LINE TYPE
#253 PARCHMENT	I	HRB4C	202'-6"	HR
#253 PARCHMENT	K	.040 WC @ 4'-0"	15'-0"	WC*

MATERIAL LIST:
 A= SM20A
 B= SSM25A
 C= SM20M
 D= NOT USED
 E= NOT USED
 F= CO8
 G= SCO8
 H= CO8M
 I= HRB-4C
 J= HRB-4C/SCR64M
 K= .060 WC @ 4'-0"
 L= .060 WC @ FH

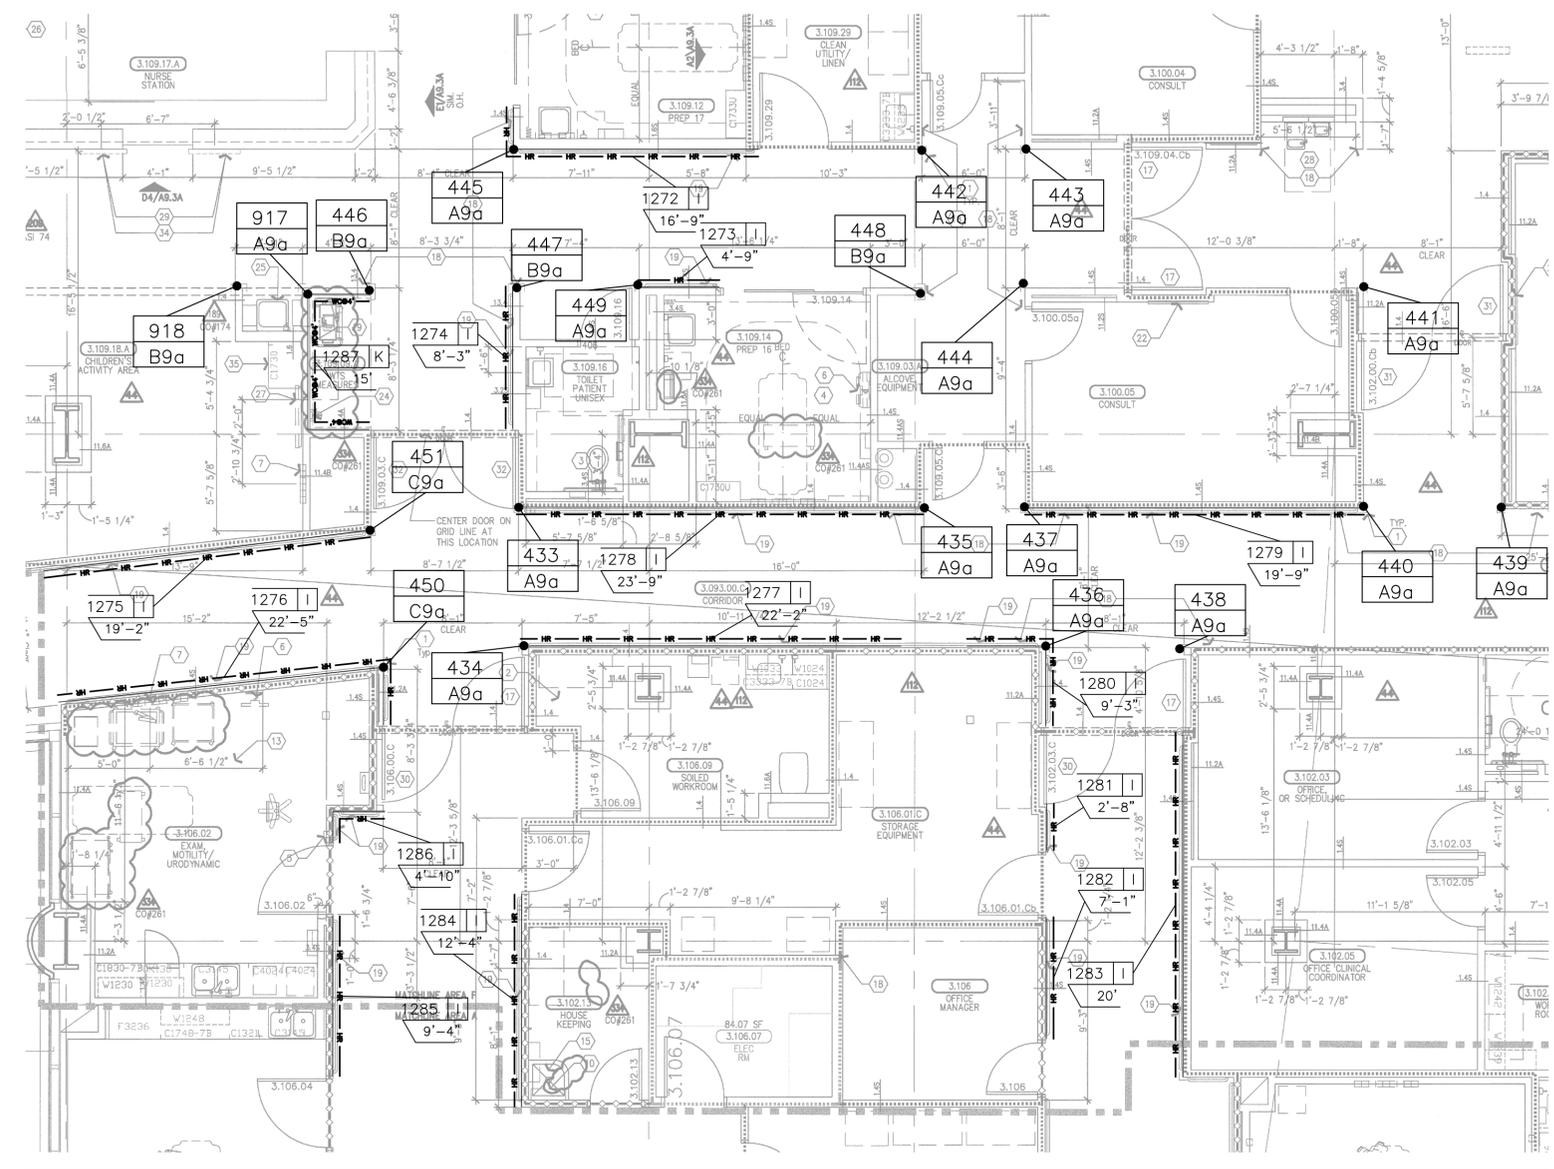

Detail B4/A11.8
 Detail B3/A11.7
 vocal note designations.

A. Information shown or referenced on enlarged and/or 1/4" scale drawings will generally not be shown on the smaller scale drawings.
 M. For partial enlarged plan at janitor closets, See Detail A3/A11.7.
 N. Dual-Phase-Flushed restroom urinals will be furnished, not installed by I.

LEVEL 3 AREA "F"
 ARCHITECTURAL DRAWING REFERENCED A3.3F DATED 09/19/2011
 3/16" = 1'-0"

CS Construction Specialties
 6600 Ross 405 Highway, Manly PA 17756
 (800) 233-6400 • Fax: (717) 546-6000 • www.c-sgroup.com

This document is the property of Construction Specialties, Inc. and contains confidential proprietary information that is not to be disclosed to third parties and is not to be used without approval in writing from Construction Specialties, Inc.

PROJECT: CHILDREN'S HOSPITAL
 TOWER 2
 JOB NO.: 759986
 CUSTOMER: L2 SPECIALTIES INC.
 REP: #111 IMC
 DRAWN BY: KYLE SMITH
 SCALE: 3/16" = 1'-0"
 DATE: 07/16/2010
 SHEET NO: 22

NO.	REVISION	DATE	BY
1	1ST (RFI#688)	11/03/10	KAS
2	2ND (RETURNED DWG)	5/17/11	KAS
3	UPDATED DWGS & RFI'S	10/20/11	KAS
4	4TH (RETURNED DWG)	02/24/12	KAS


NO.	FILE & FIELD	DATE	BY

GENERAL NOTES:

CORNER GUARD SYMBOL

	MARK #	A REF. SECTION
	CODE	1 UNIT HEIGHT
		o BASE HEIGHT/ELEV


COLOR/CODE	SECTION	UNIT HGT	BASE/ELEV	QTY
#253 PARCHMENT	A9a	A	9'-0"	N/A
#253 PARCHMENT	B9a	B	9'-0"	N/A

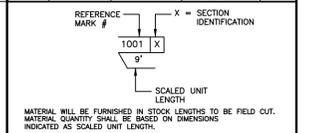

MATERIAL REQUIREMENTS

COLOR/CODE	SECTION	MODEL	L/F REQUIRED	LINE TYPE
#253 PARCHMENT	I	HRB4C	63'-6"	HR

- MATERIAL LIST:
- A= SM20A
 - B= SSM25A
 - C= SM20M
 - D= NOT USED
 - E= NOT USED
 - F= CO8
 - G= SC08
 - H= CO8M
 - I= HRB-4C
 - J= HRB-4C/SCR64M
 - K= .060 WC @ 4'-0"
 - L= .060 WC @ FH

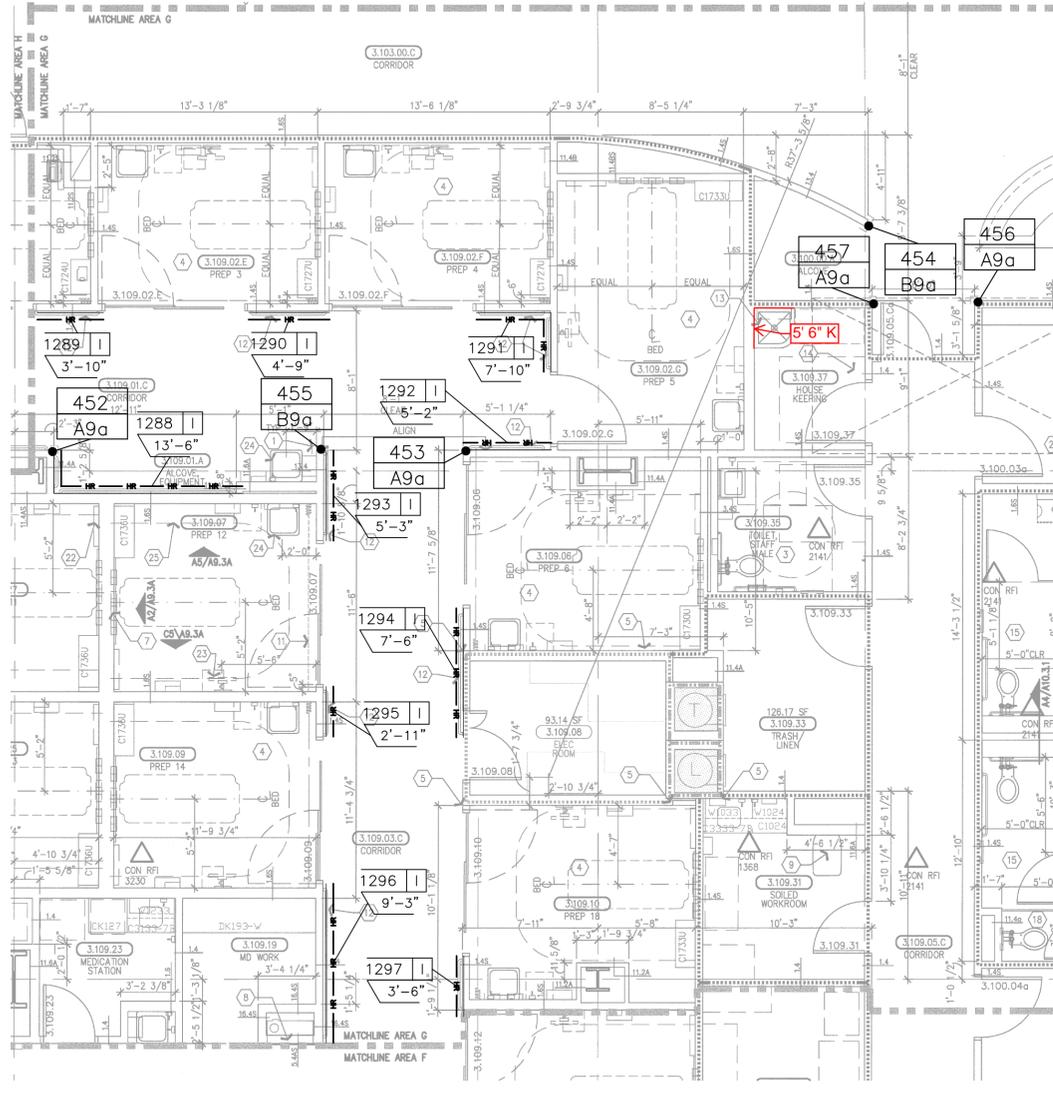

Itc. See B4/A11.8 for detail.

LEVEL 3 AREA "G"
 ARCHITECTURAL DRAWING REFERENCED A3.3G DATED 09/30/2008 3/16" = 1'-0"



This document is the property of Construction Specialties, Inc. and contains confidential proprietary information that is not to be disclosed to third parties and is not to be used without approval in writing from Construction Specialties, Inc.

PROJECT: CHILDREN'S HOSPITAL
 TOWER 2

JOB NO.: 759986

CUSTOMER: L2 SPECIALTIES INC.

REP: #111 IMC

DRAWN BY: KYLE SMITH

SCALE: 3/16" = 1'-0"

DATE: 07/16/2010

SHEET NO: 23

NO.	REVISION	DATE	BY
1	1ST (RFI#688)	11/03/10	KAS
2	2ND (RETURNED DWG)	5/17/11	KAS
3	UPDATED DWGS & RFI'S	10/20/11	KAS
4	4TH (RETURNED DWG)	02/24/12	KAS


NO.	FILE & FIELD	DATE	BY

GENERAL NOTES:

CORNER GUARD SYMBOL

MARK #	A REF. SECTION
1	UNIT HEIGHT
0	BASE HEIGHT/ELEV

COLOR/CODE	CODE	SECTION	UNIT HGT	BASE/ELEV	QTY
#253 PARCHMENT	A9a	A	9'-0"	N/A	16
#253 PARCHMENT	B9a	B	9'-0"	N/A	4

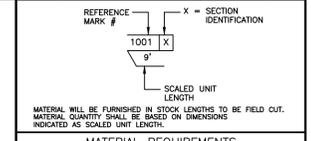

MATERIAL REQUIREMENTS

COLOR/CODE	SECTION	MODEL	L/F REQUIRED	LINE TYPE
#253 PARCHMENT	I	HRB4C	139'-7"	HR

- MATERIAL LIST:
- A= SM20A
 - B= SSM25A
 - C= SM20M
 - D= NOT USED
 - E= NOT USED
 - F= CO8
 - G= SC08
 - H= CO8M
 - I= HRB-4C
 - J= HRB-4C/SCR64M
 - K= .060 WC @ 4'-0"
 - L= .060 WC @ FH



This document is the property of Construction Specialties, Inc. and contains confidential proprietary information that is not to be disclosed to third parties and is not to be used without approval in writing from Construction Specialties, Inc.

PROJECT: CHILDREN'S HOSPITAL
TOWER 2

JOB NO.: 759986

CUSTOMER: L2 SPECIALTIES INC.


REP: #111 IMC

DRAWN BY: KYLE SMITH

SCALE: 3/16" = 1'-0"

DATE: 07/16/2010

SHEET NO: 24

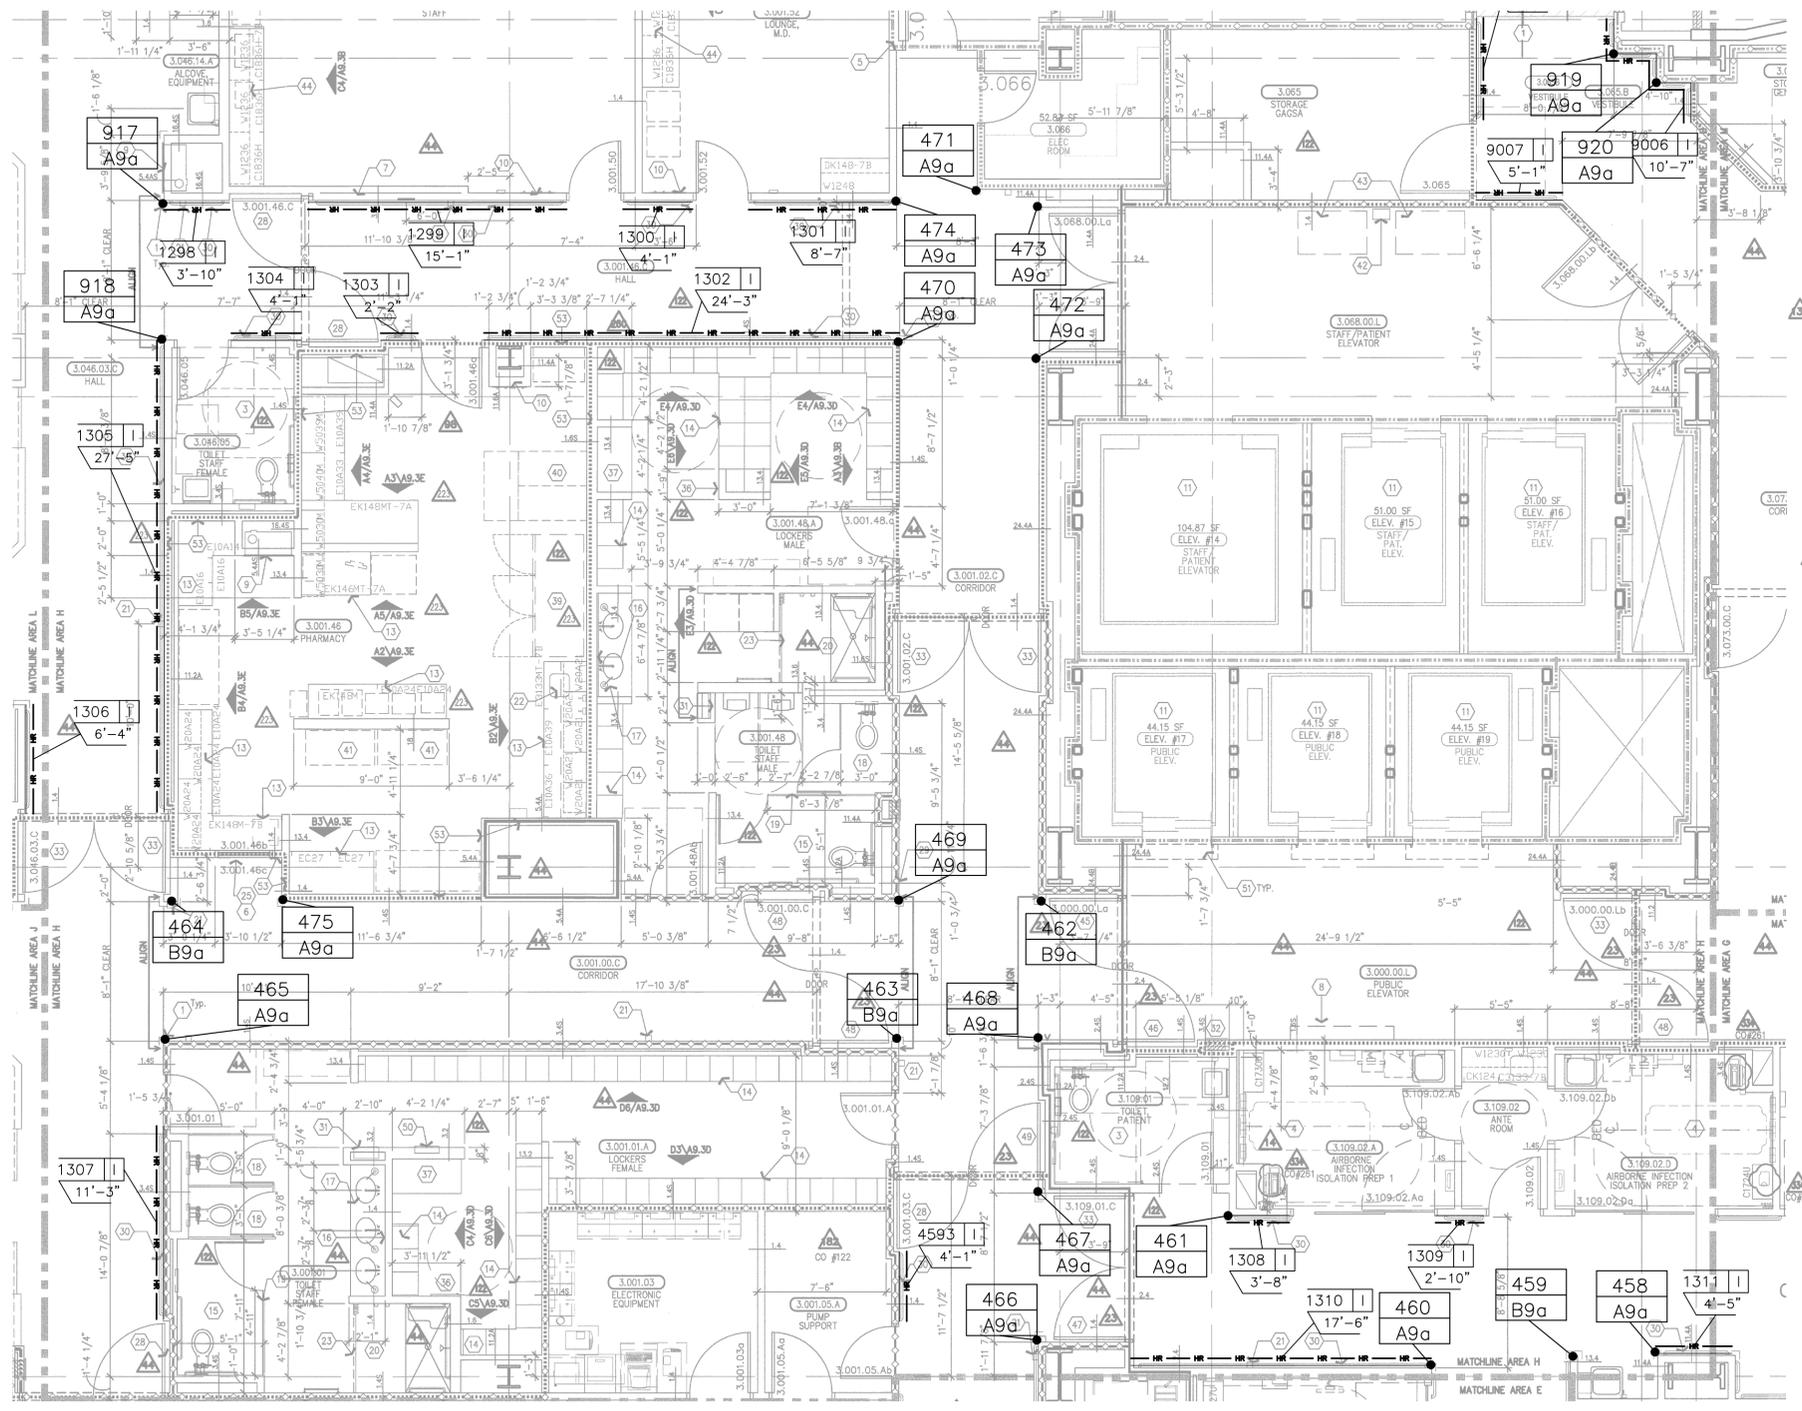

LEVEL 3 AREA "H"
ARCHITECTURAL DRAWING REFERENCED A3.3H DATED 09/19/2011 3/16" = 1'-0"

NO.	REVISION	DATE	BY
1	1ST (RFI#688)	11/03/10	KAS
2	2ND (RETURNED DWG)	5/17/11	KAS
3	UPDATED DWGS & RFI'S	10/20/11	KAS
4	4TH (RETURNED DWG)	02/24/12	KAS


NO.	FILE & FIELD	DATE	BY

GENERAL NOTES:

CORNER GUARD SYMBOL

MARK #	A REF. SECTION
104	1 UNIT HEIGHT
ATX	BASE HEIGHT/ELEV

COLOR/CODE	CODE	SECTION	UNIT HGT	BASE/ELEV	QTY
#253 PARCHMENT	A9a	A	9'-0"	N/A	21
#253 PARCHMENT	B9a	B	9'-0"	N/A	1

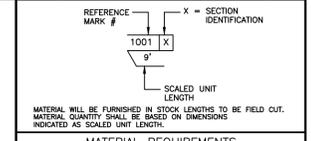

MATERIAL REQUIREMENTS

COLOR/CODE	SECTION	MODEL	L/F REQUIRED	LINE TYPE
#253 PARCHMENT	I	HRB4C	303'-7"	HR
#253 PARCHMENT	K	.040 WC @ 4'-0"	237'-2"	WCB*

- MATERIAL LIST:
- A= SM20A
 - B= SSM25A
 - C= SM20M
 - D= NOT USED
 - E= NOT USED
 - F= C08
 - G= SC08
 - H= CO8M
 - I= HRB-4C
 - J= HRB-4C/SCR64M
 - K= .060 WC @ 4'-0"
 - L= .060 WC @ FH



This document is the property of Construction Specialties, Inc. and contains confidential proprietary information that is not to be disclosed to third parties and is not to be used without approval in writing from Construction Specialties, Inc.

PROJECT: CHILDREN'S HOSPITAL
TOWER 2

JOB NO.: 759986

CUSTOMER: L2 SPECIALTIES INC.


REP: #111 IMC

DRAWN BY: KYLE SMITH

SCALE: 3/16" = 1'-0"


DATE: 07/16/2010

SHEET NO: 25

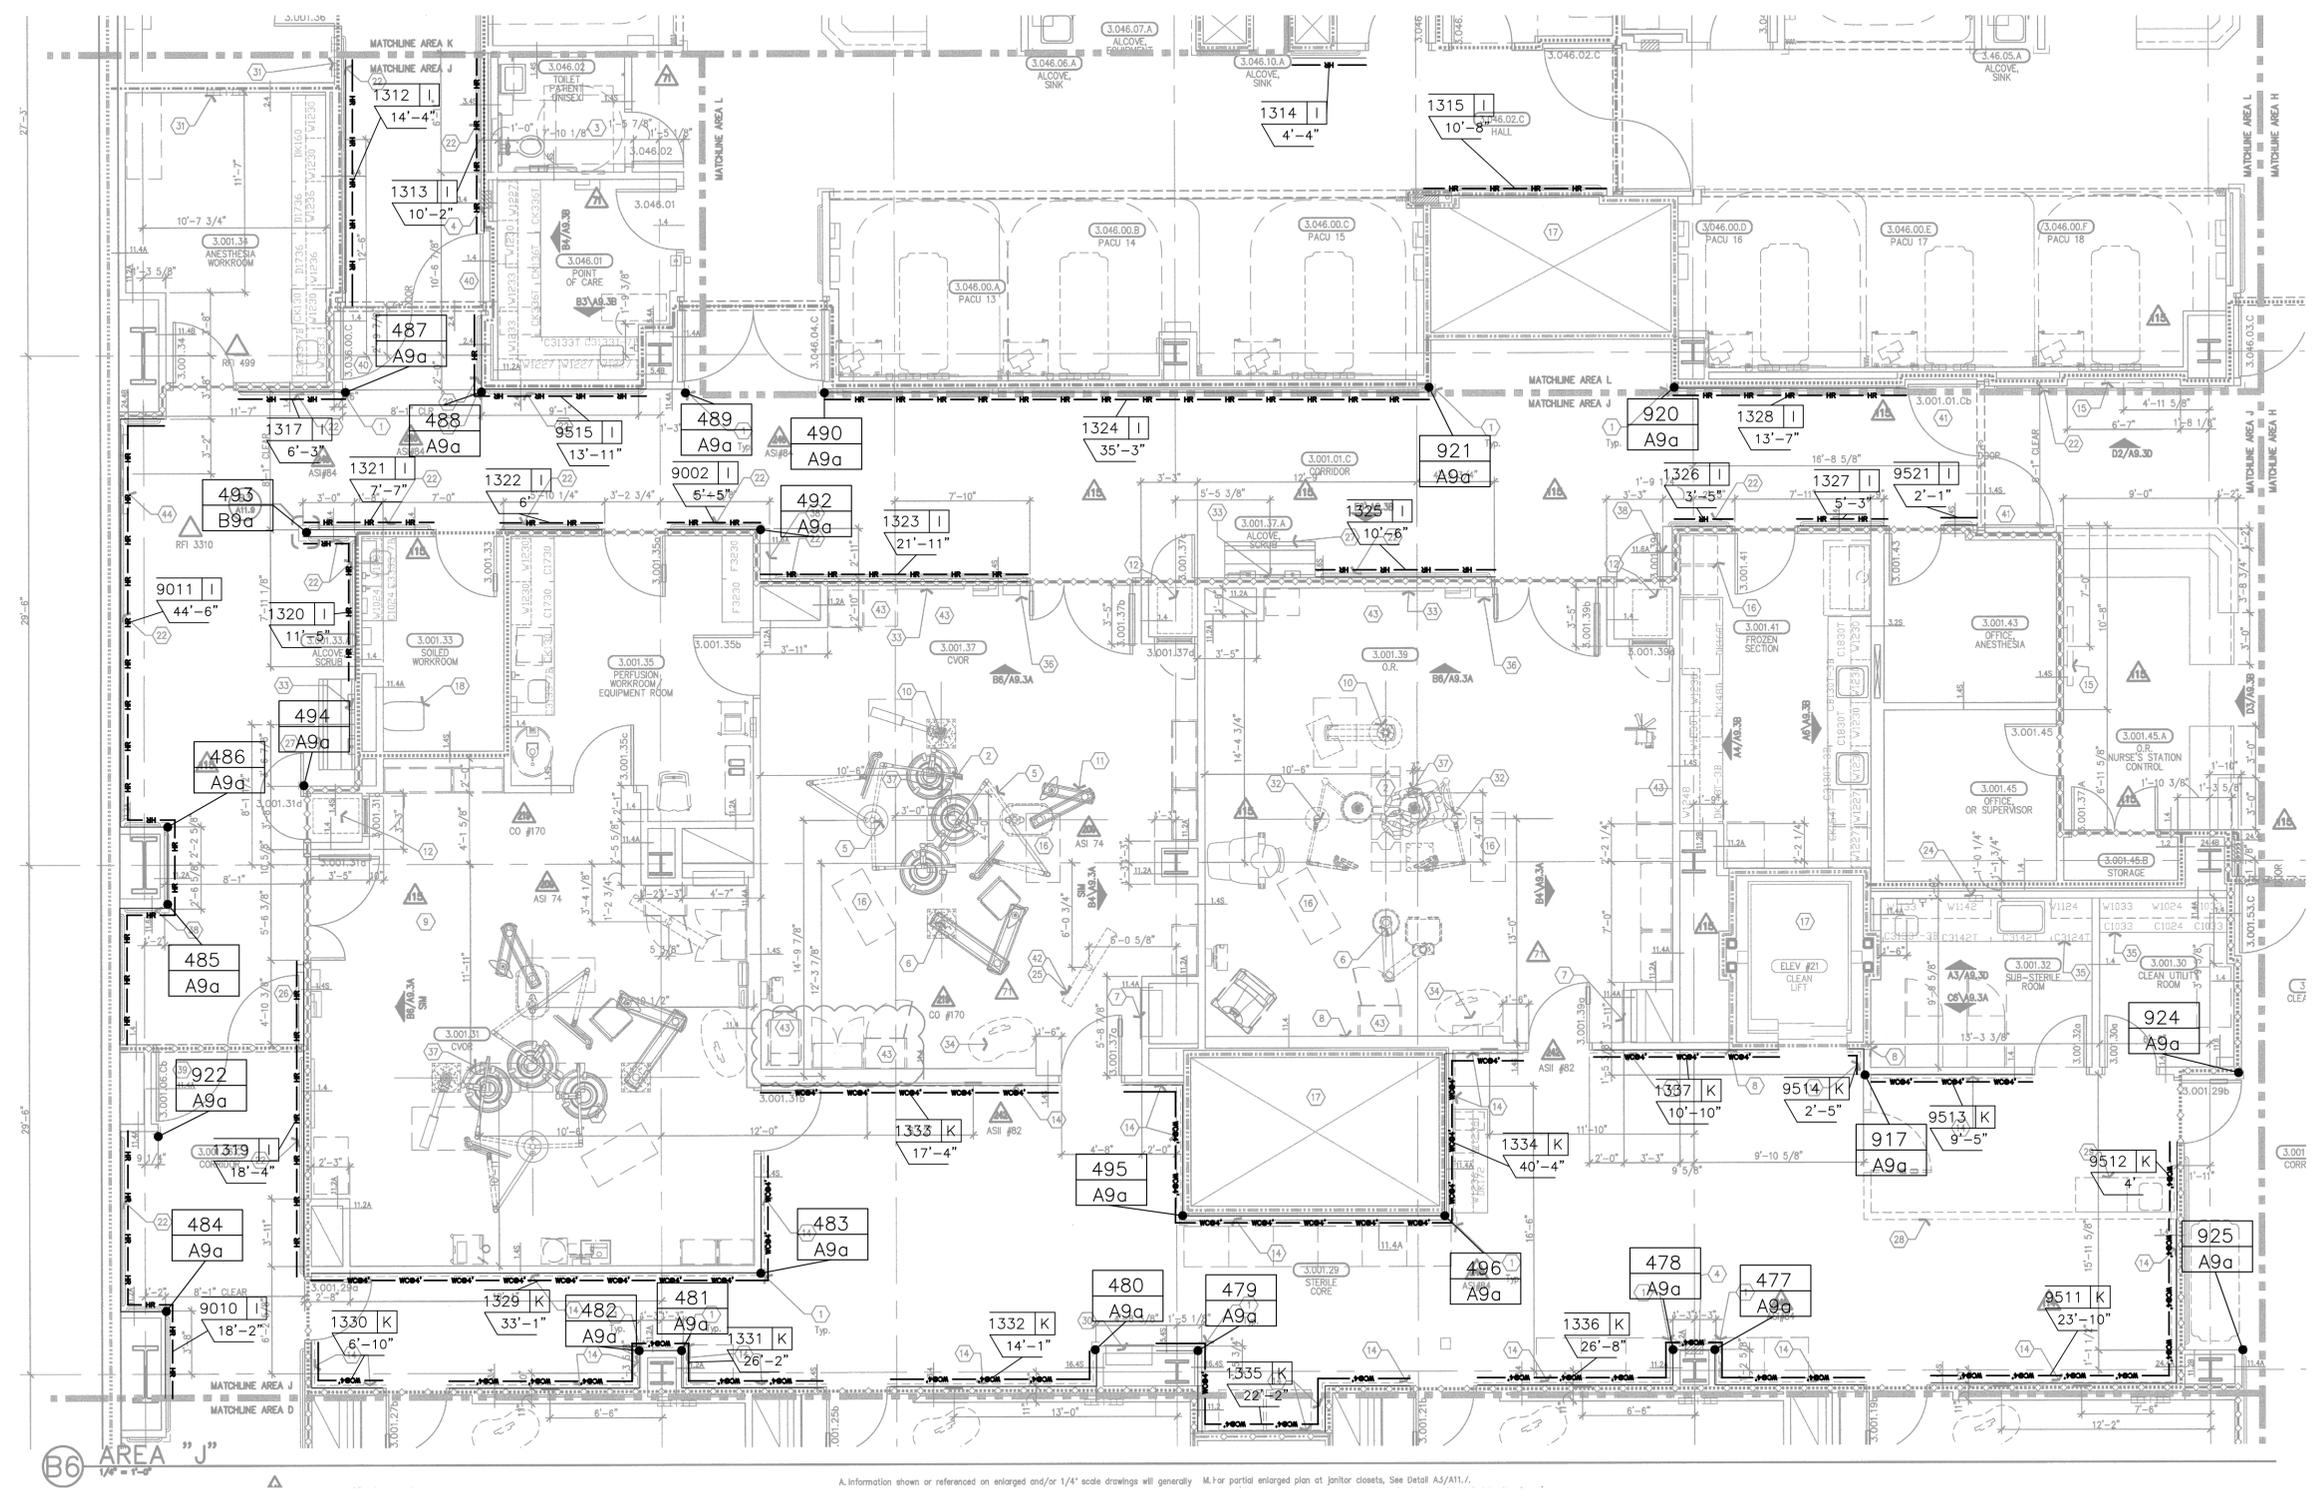


LEVEL 3 AREA "J"
ARCHITECTURAL DRAWING REFERENCED A3.3J DATED 05/26/2011 3/16" = 1'-0"

A. Information shown or referenced on enlarged 3/16" scale drawings will generally be for partial enlarged plan at junction closets. See Detail A3/A11.1.

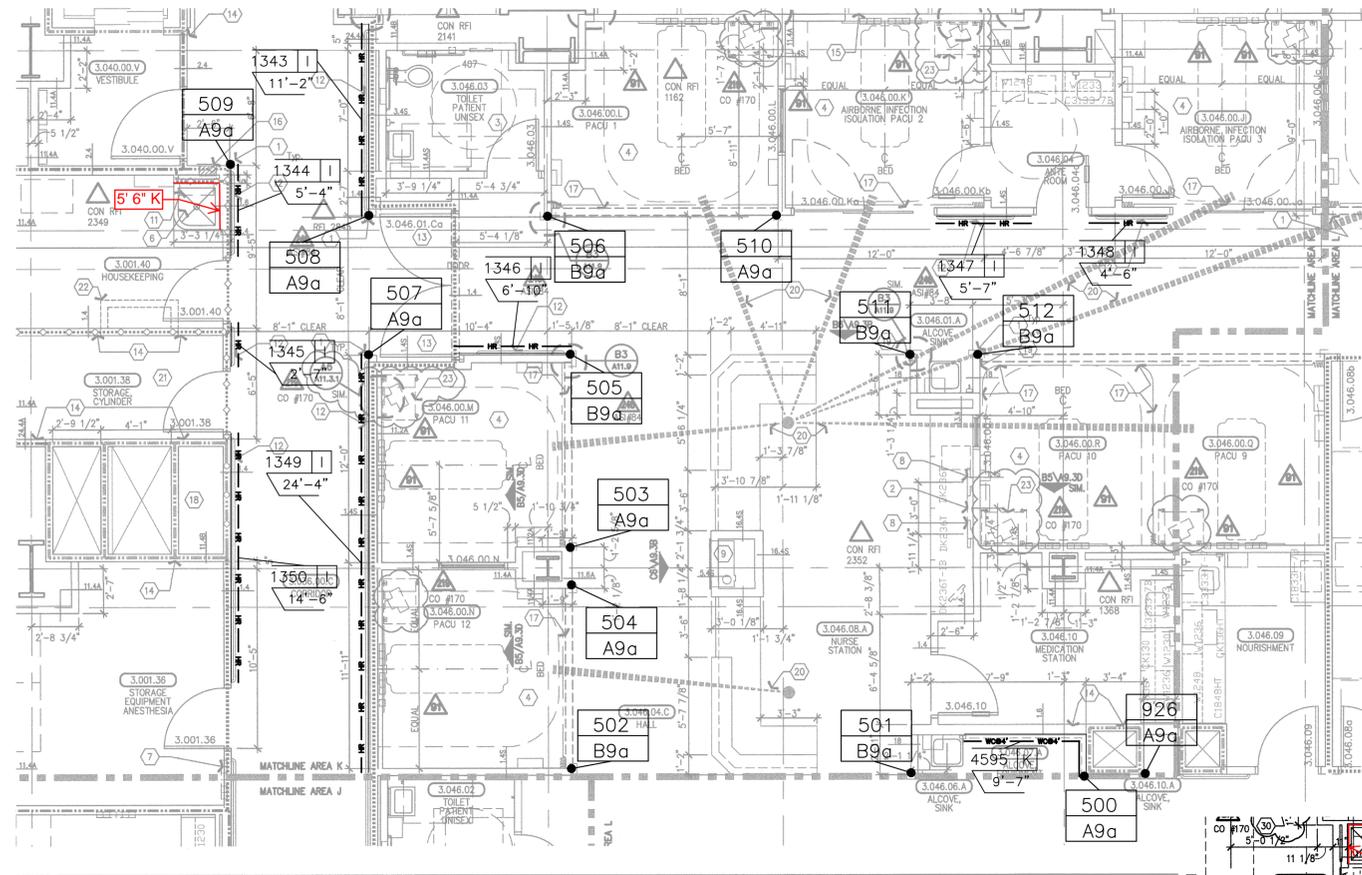

LEVEL 3 AREA "K"
 ARCHITECTURAL DRAWING REFERENCED A3.3K DATED 09/30/2008
 3/16" = 1'-0"

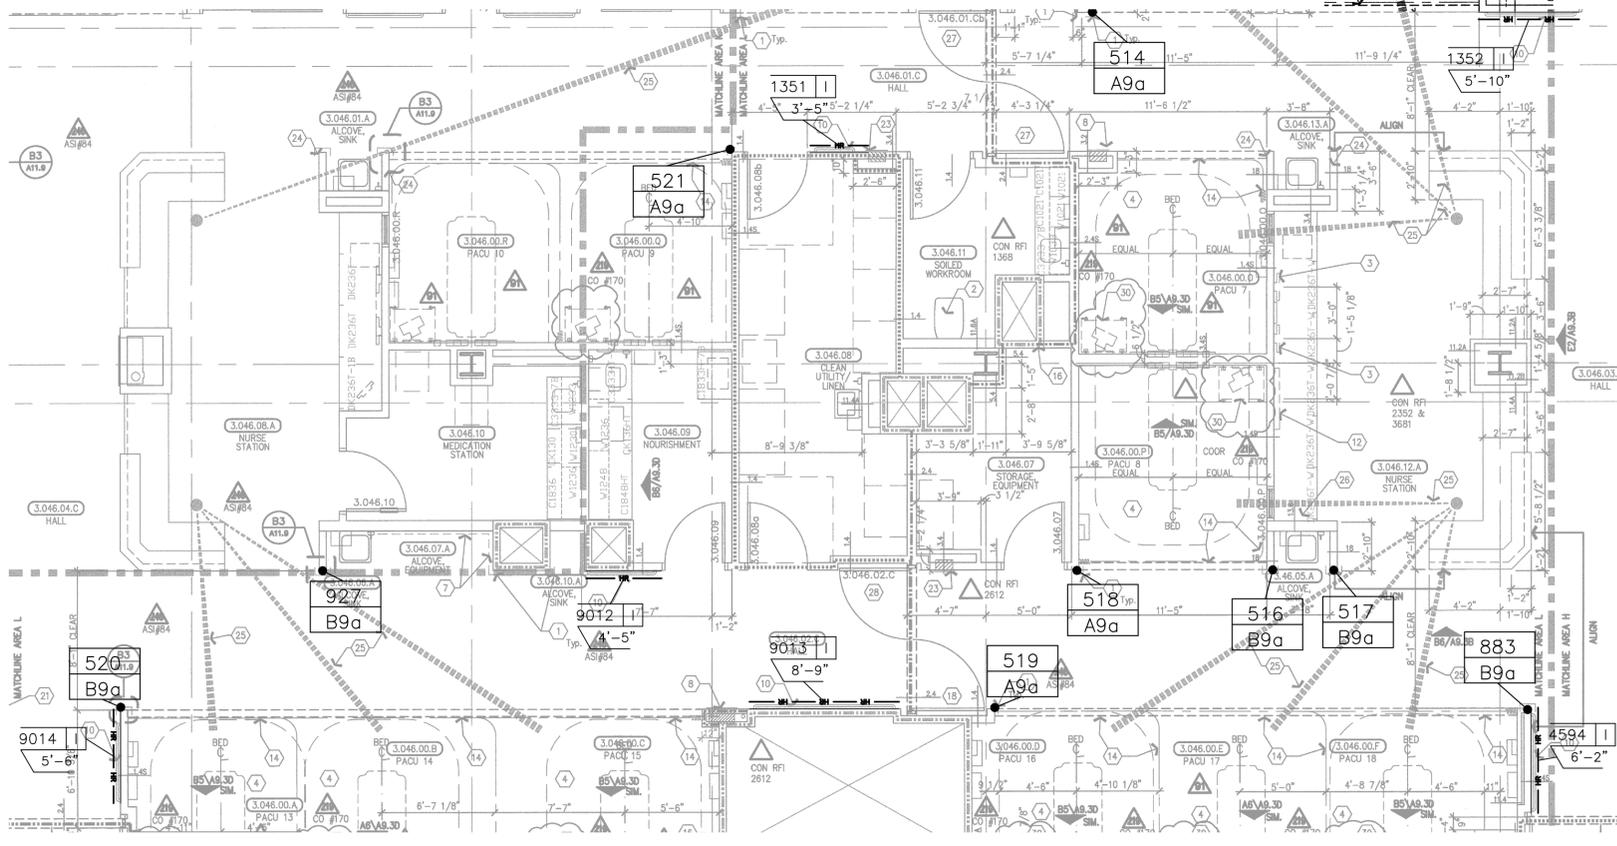

LEVEL 3 AREA "L"
 ARCHITECTURAL DRAWING REFERENCED A3.3L DATED 09/30/2008
 3/16" = 1'-0"


NO.	REVISION	DATE	BY
1	1ST (RFI#688)	11/03/10	KAS
2	2ND (RETURNED DWG)	5/17/11	KAS
3	UPDATED DWGS & RFI'S	10/20/11	KAS
4	4TH (RETURNED DWG)	02/24/12	KAS

GENERAL NOTES:

CORNER GUARD SYMBOL

MARK #	A REF. SECTION
CODE	1 UNIT HEIGHT
	o BASE HEIGHT/ELEV

COLOR/CODE	CODE	SECTION	UNIT HGT	BASE/ELEV	QTY
#253 PARCHMENT	A9a	A	9'-0"	N/A	12
#253 PARCHMENT	B9a	B	9'-0"	N/A	11

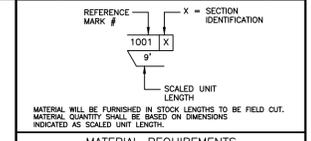

MATERIAL REQUIREMENTS


COLOR/CODE	SECTION	MODEL	L/F REQUIRED	LINE TYPE
#253 PARCHMENT	I	HRB4C	108'-11"	HR
#253 PARCHMENT	K	.060 WC @ 4'-0"	9'-7"	WCB*

- MATERIAL LIST:
- A= SM20A
 - B= SSM25A
 - C= SM20M
 - D= NOT USED
 - E= NOT USED
 - F= CO8
 - G= SC08
 - H= CO8M
 - I= HRB-4C
 - J= HRB-4C/SCR64M
 - K= .060 WC @ 4'-0"
 - L= .060 WC @ FH



This document is the property of Construction Specialties, Inc. and contains confidential proprietary information that is not to be disclosed to third parties and is not to be used without approval in writing from Construction Specialties, Inc.

PROJECT: CHILDREN'S HOSPITAL TOWER 2
 JOB NO.: 759986
 CUSTOMER: L2 SPECIALTIES INC.
 REP: #111 IMC
 DRAWN BY: KYLE SMITH
 SCALE: 3/16" = 1'-0"
 DATE: 07/16/2010
 SHEET NO: 26

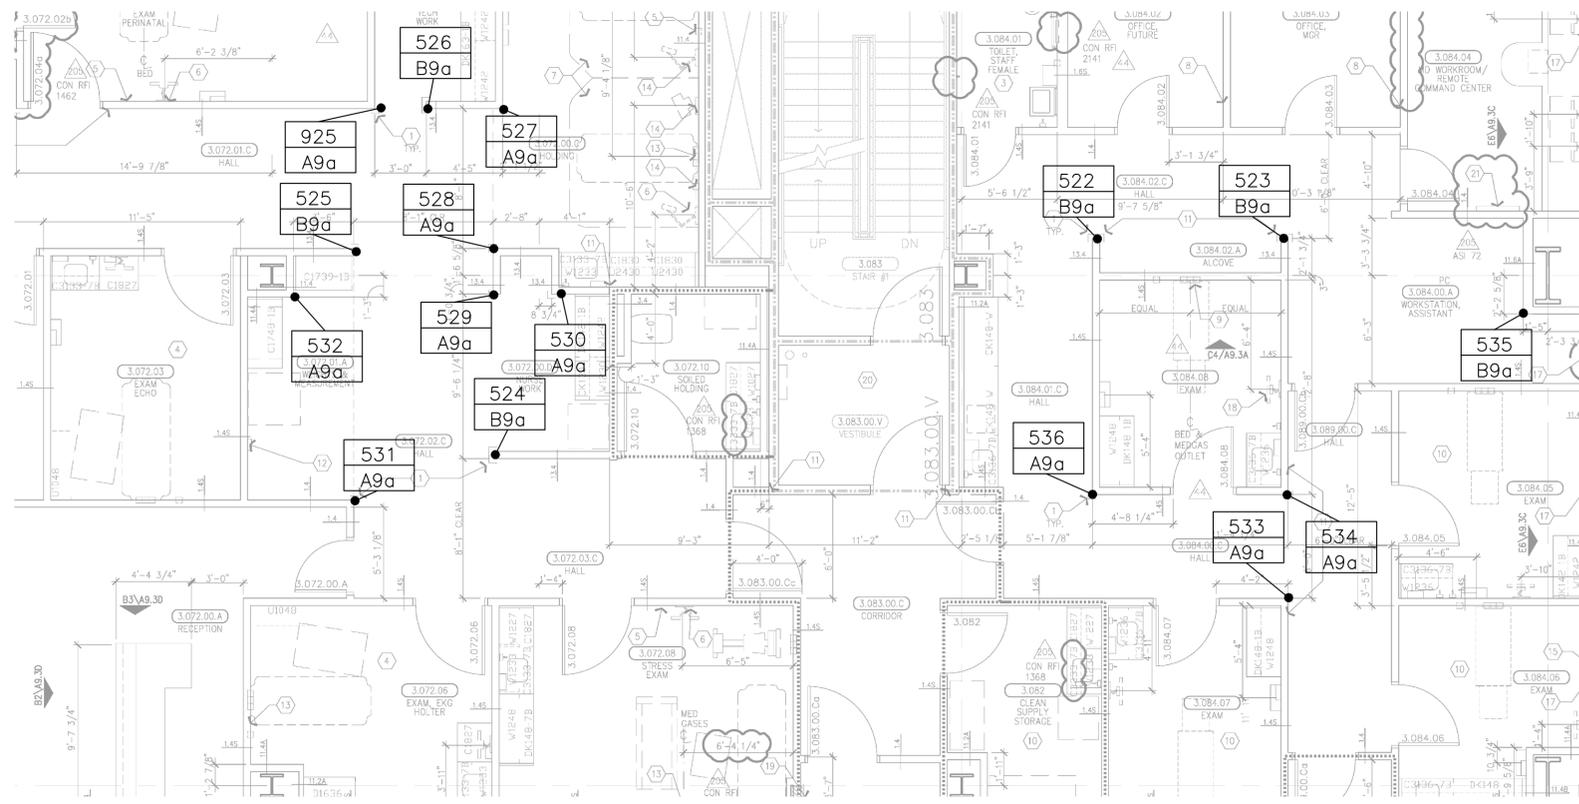


LEVEL 3 AREA "M"
 ARCHITECTURAL DRAWING REFERENCED A3.3M DATED 09/30/2008 3/16" = 1'-0"

NO.	REVISION	DATE	BY
1	1ST (RFI#688)	11/03/10	KAS
2	2ND (RETURNED DWG)	5/17/11	KAS
3	UPDATED DWGS & RFIS	10/20/11	KAS
4	4TH (RETURNED DWG)	02/24/12	KAS


GENERAL NOTES:

 CORNER GUARD SYMBOL



COLOR/CODE	SECTION	UNIT	HGT	BASE/ELEV	QTY
#253 PARCHMENT	A9a	A	9'-0"	N/A	23
#253 PARCHMENT	B9a	B	9'-0"	N/A	6

 REFERENCE MARK #



MATERIAL WILL BE FURNISHED IN STOCK LENGTHS TO BE FIELD CUT. MATERIAL QUANTITY SHALL BE BASED ON DIMENSIONS INDICATED AS SCALED UNIT LENGTH.

MATERIAL REQUIREMENTS

COLOR/CODE	SECTION	MODEL	L/F REQUIRED	LINE TYPE
#253 PARCHMENT	I	HRB4C	18'-3"	HR

MATERIAL LIST:

- A= SM20A
- B= SSM25A
- C= SM20M
- D= NOT USED
- E= NOT USED
- F= CO8
- G= SC08
- H= CO8M
- I= HRB-4C
- J= HRB-4C/SCR64M
- K= .060 WC @ 4'-0"
- L= .060 WC @ FH



This document is the property of Construction Specialties, Inc. and contains confidential proprietary information that is not to be disclosed to third parties and is not to be used without approval in writing from Construction Specialties, Inc.

PROJECT: CHILDREN'S HOSPITAL TOWER 2

JOB NO.: 759986

CUSTOMER: L2 SPECIALTIES INC.

REP: #111 IMC

DRAWN BY: KYLE SMITH

SCALE: 3/16" = 1'-0"

DATE: 07/16/2010

SHEET NO: 27

NO.	REVISION	DATE	BY
1	1ST (RFI#688)	11/03/10	KAS
2	2ND (RETURNED DWG)	5/17/11	KAS
3	UPDATED DWGS & RFIS	10/20/11	KAS
4	4TH (RETURNED DWG)	02/24/12	KAS


NO.	FILE & FIELD	DATE	BY

GENERAL NOTES:

CORNER GUARD SYMBOL

MARK #	A REF. SECTION
104	1 UNIT HEIGHT
ATX	BASE HEIGHT/ELEV

COLOR/CODE	CODE	SECTION	UNIT HGT	BASE/ELEV	QTY
#253 PARCHMENT	A9a	A	9'-0"	N/A	11
#253 PARCHMENT	B9a	B	9'-0"	N/A	1
#253 PARCHMENT	C9a	C	9'-0"	N/A	1

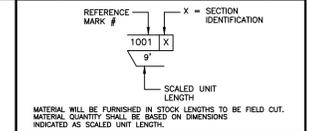

MATERIAL WILL BE FURNISHED IN STOCK LENGTHS TO BE FIELD CUT. MATERIAL QUANTITY SHALL BE BASED ON DIMENSIONS INDICATED AS SCALED UNIT LENGTH.

MATERIAL REQUIREMENTS

COLOR/CODE	SECTION	MODEL	L/F REQUIRED	LINE TYPE
#253 PARCHMENT	I	HRB4C	189'-1"	HR

- MATERIAL LIST:
- A= SM20A
 - B= SSM25A
 - C= SM20M
 - D= NOT USED
 - E= NOT USED
 - F= C08
 - G= SC08
 - H= C08M
 - I= HRB-4C
 - J= HRB-4C/SCR64M
 - K= .060 WC @ 4'-0"
 - L= .060 WC @ FH



This document is the property of Construction Specialties, Inc. and contains confidential proprietary information that is not to be disclosed to third parties and is not to be used without approval in writing from Construction Specialties, Inc.

PROJECT: CHILDREN'S HOSPITAL
TOWER 2

JOB NO.: 759986

CUSTOMER: L2 SPECIALTIES INC.


REP: #111 IMC

DRAWN BY: KYLE SMITH

SCALE: 3/16" = 1'-0"

DATE: 07/16/2010

SHEET NO: 32

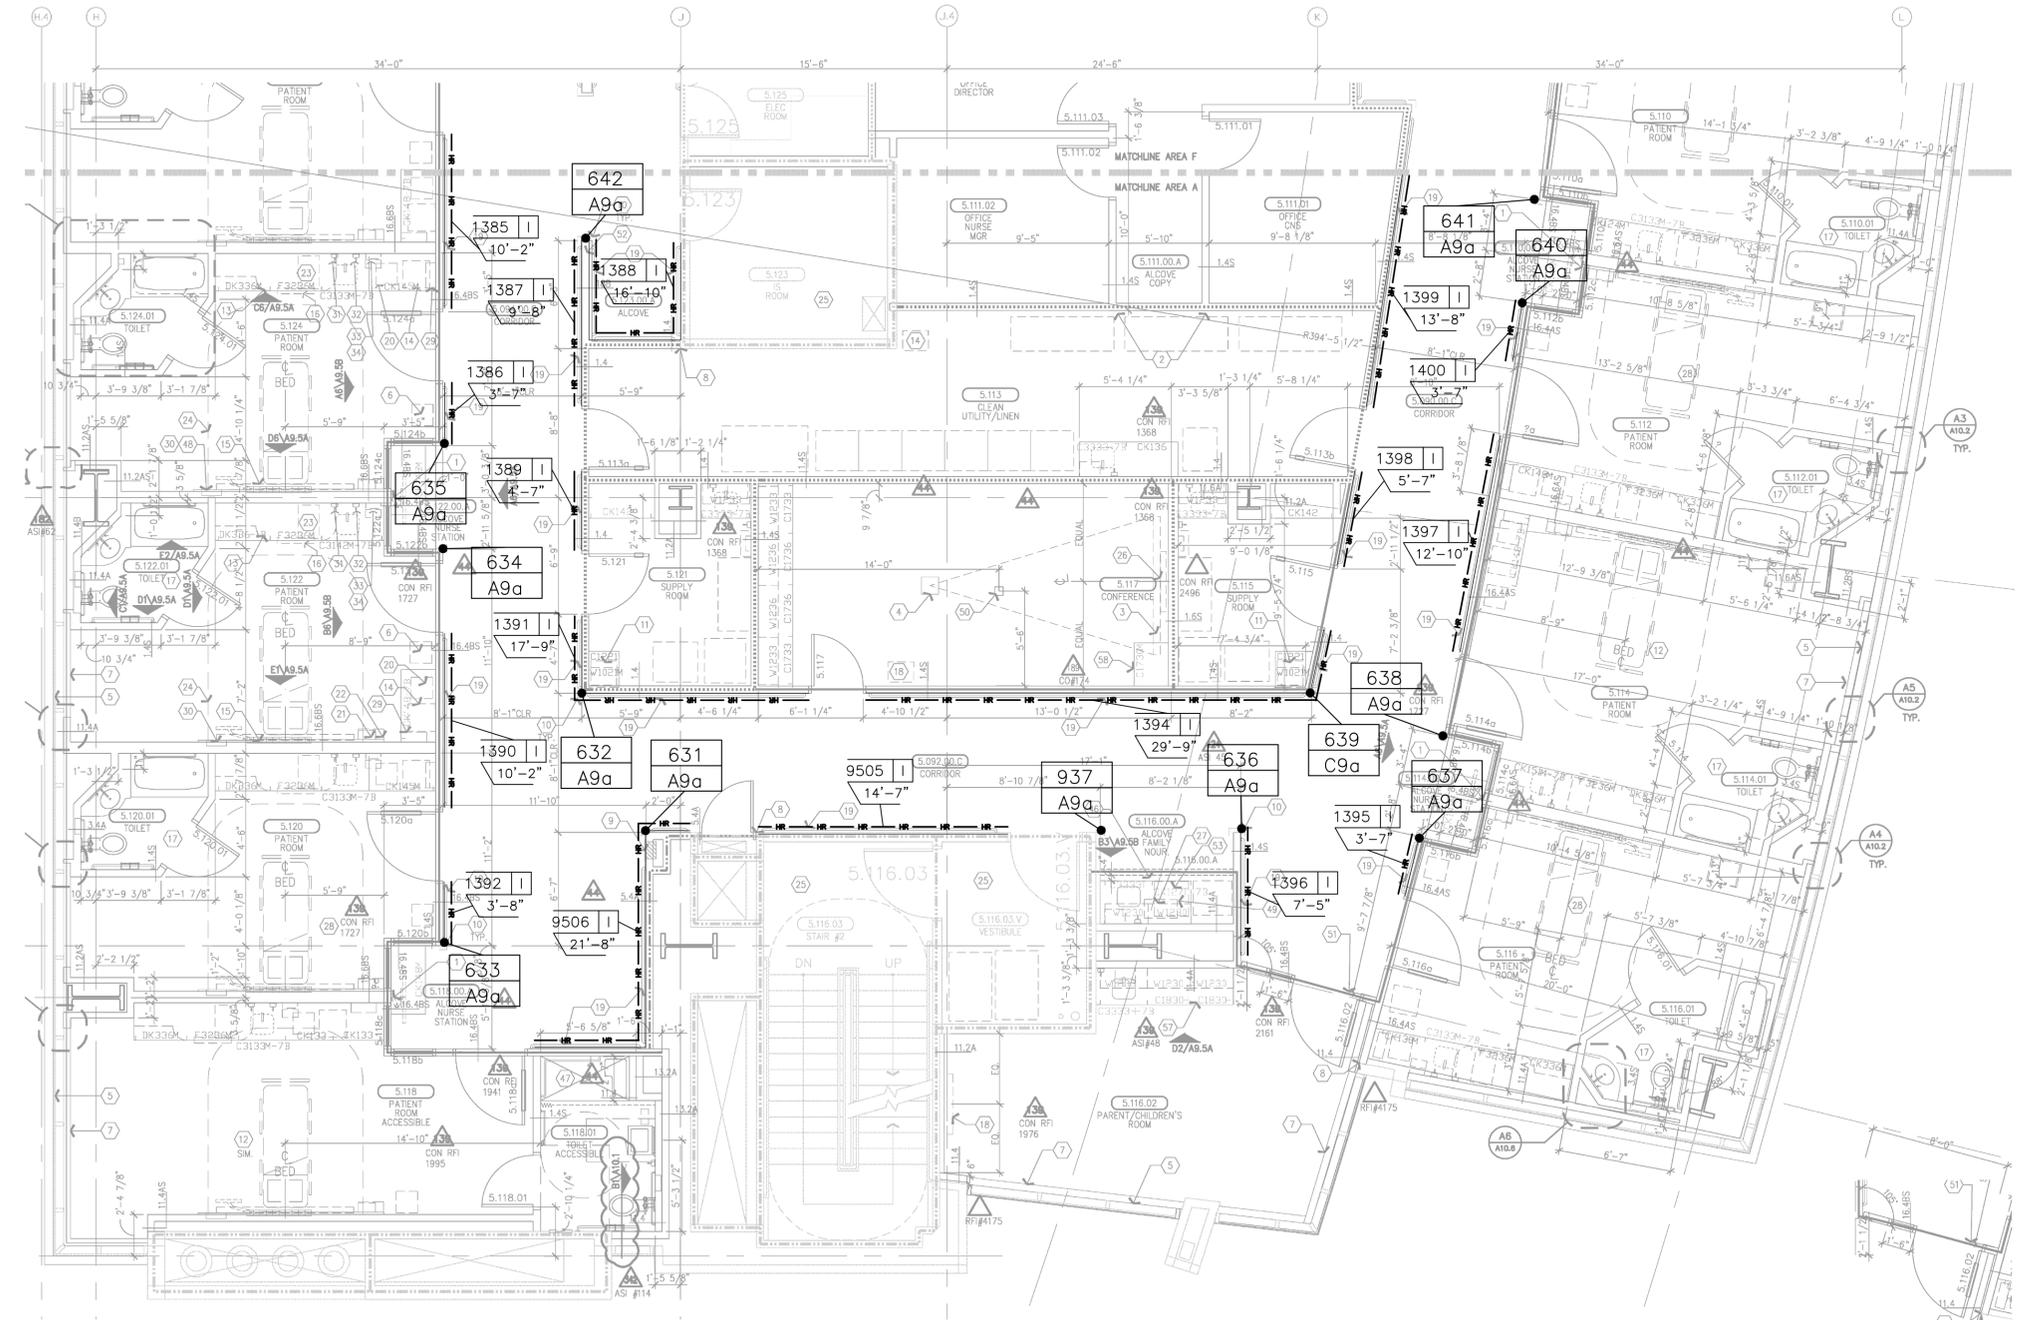

LEVEL 5 AREA "A"
ARCHITECTURAL DRAWING REFERENCED A3.5A DATED 09/02/2011 3/16" = 1'-0"

NO.	REVISION	DATE	BY
1	1ST (RFI#688)	11/03/10	KAS
2	2ND (RETURNED DWG)	5/17/11	KAS
3	UPDATED DWGS & RFIS	10/20/11	KAS
4	4TH (RETURNED DWG)	02/24/12	KAS

NO.	FILE & FIELD	DATE	BY

GENERAL NOTES:

CORNER GUARD SYMBOL
 MARK # A REF. SECTION
 CODE 1 UNIT HEIGHT
 BASE HEIGHT/ELEV

COLOR/CODE	CODE	SECTION	UNIT HGT	BASE/ELEV	QTY
#253 PARCHEMENT	A9a	A	9'-0"	N/A	16
#253 PARCHEMENT	B9a	B	9'-0"	N/A	2
#253 PARCHEMENT	C9a	C	9'-0"	N/A	1

REFERENCE MARK # X = SECTION IDENTIFICATION
 1001 X
 9'
 SCALED UNIT LENGTH
 MATERIAL WILL BE FURNISHED IN STOCK LENGTHS TO BE FIELD CUT. MATERIAL QUANTITY SHALL BE BASED ON DIMENSIONS INDICATED AS SCALED UNIT LENGTH.


COLOR/CODE	SECTION	MODEL	L/F REQUIRED	LINE TYPE
#253 PARCHEMENT	I	HRB4C	233'-6"	HR
#253 PARCHEMENT	K	.060 WC @ 4'-0"	5'-5"	WC*

MATERIAL LIST:
 A= SM20A
 B= SSM25A
 C= SM20M
 D= NOT USED
 E= NOT USED
 F= C08
 G= SC08
 H= C08M
 I= HRB-4C
 J= HRB-4C/SCR64M
 K= .060 WC @ 4'-0"
 L= .060 WC @ FH



This document is the property of Construction Specialties, Inc. and contains confidential proprietary information that is not to be disclosed to third parties and is not to be used without approval in writing from Construction Specialties, Inc.

PROJECT: CHILDREN'S HOSPITAL TOWER 2
 JOB NO.: 759986
 CUSTOMER: L2 SPECIALTIES INC.
 REP: #111 IMC
 DRAWN BY: KYLE SMITH
 SCALE: 3/16" = 1'-0"
 DATE: 07/16/2010
 SHEET NO: 33

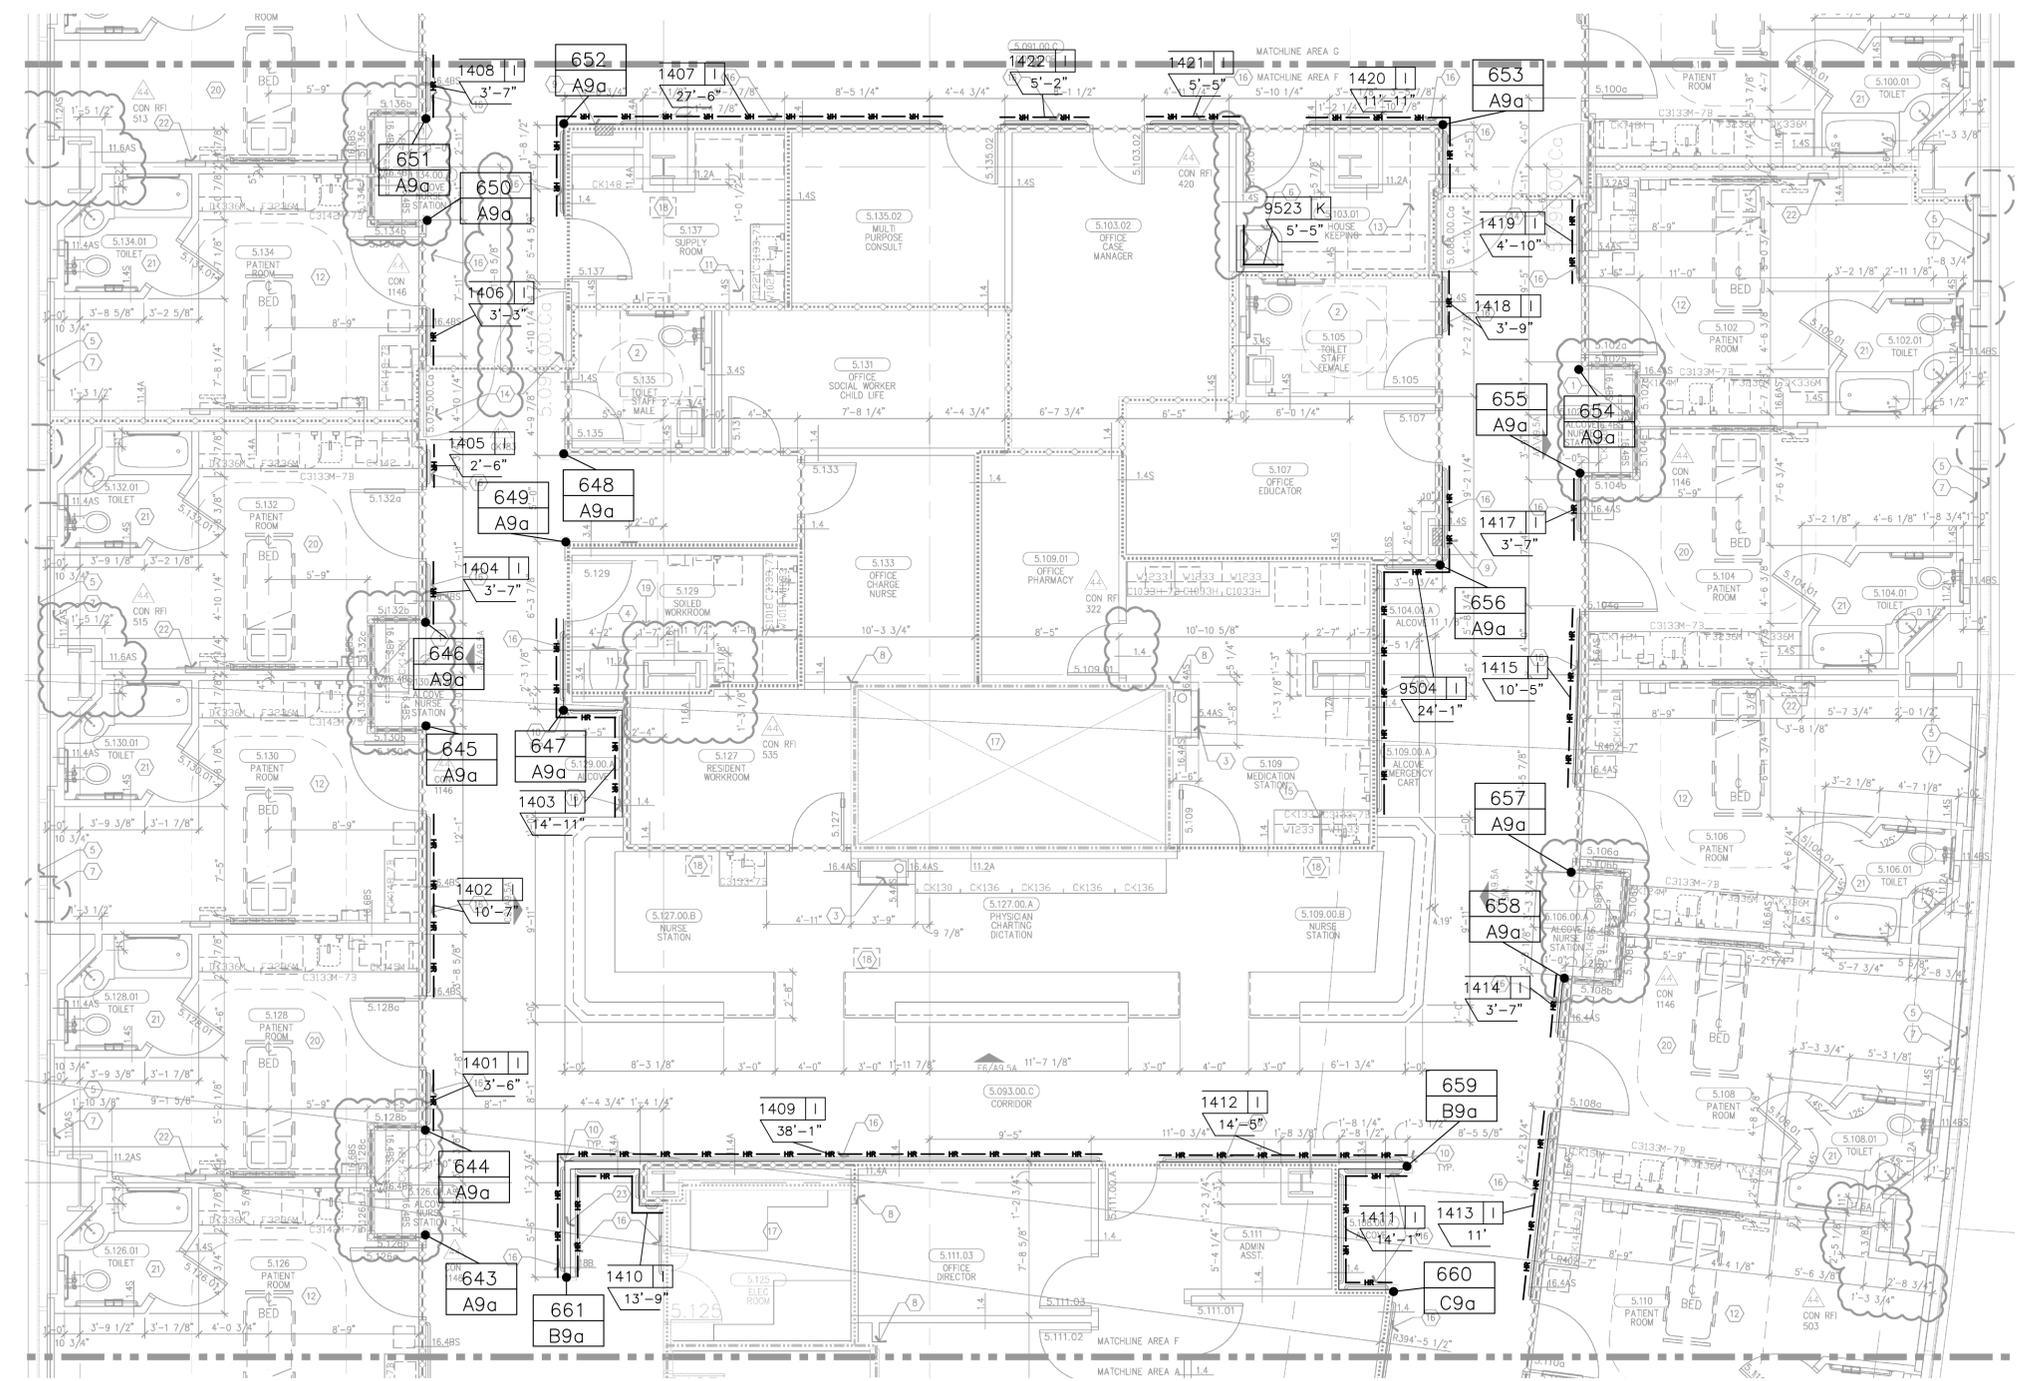

LEVEL 5 AREA "F"
 ARCHITECTURAL DRAWING REFERENCED A3.5F DATED 05/28/2011 3/16" = 1'-0"

NO.	REVISION	DATE	BY
1	1ST (RFI#688)	11/03/10	KAS
2	2ND (RETURNED DWG)	5/17/11	KAS
3	UPDATED DWGS & RFIS	10/20/11	KAS
4	4TH (RETURNED DWG)	02/24/12	KAS

NO.	FILE & FIELD	DATE	BY

GENERAL NOTES:

CORNER GUARD SYMBOL

MARK #	A REF. SECTION
104	1 UNIT HEIGHT
ATX	BASE HEIGHT/ELEV

COLOR/CODE	CODE	SECTION	UNIT HGT	BASE/ELEV	QTY
#253 PARCHMENT	A9a	A	9'-0"	N/A	16
#253 PARCHMENT	B9a	B	9'-0"	N/A	3

REFERENCE MARK # X = SECTION IDENTIFICATION

1001 X

9'

SCALED UNIT LENGTH

MATERIAL WILL BE FURNISHED IN STOCK LENGTHS TO BE FIELD CUT. MATERIAL QUANTITY SHALL BE BASED ON DIMENSIONS INDICATED AS SCALED UNIT LENGTHS.

COLOR/CODE	SECTION	MODEL	L/F REQUIRED	LINE TYPE
#253 PARCHMENT	I	HRB4C	194'-0"	HR
#253 PARCHMENT	K	.060 WC @ 4'-0"	5'-5"	WC*

MATERIAL LIST:

- A= SM20A
- B= SSM25A
- C= SM20M
- D= NOT USED
- E= NOT USED
- F= C08
- G= SC08
- H= C08M
- I= HRB-4C
- J= HRB-4C/SCR64M
- K= .060 WC @ 4'-0"
- L= .060 WC @ FH

CS Construction Specialties®
 6600 Ross 405 Highway, Manly PA 17756
 (800) 233-6463 • Fax: (317) 546-6502 • www.cs-sps.com

This document is the property of Construction Specialties, Inc. and contains confidential proprietary information that is not to be disclosed to third parties and is not to be used without approval in writing from Construction Specialties, Inc.

PROJECT: CHILDREN'S HOSPITAL
TOWER 2

JOB NO.: 759986

CUSTOMER: L2 SPECIALTIES INC.


REP: #111 IMC

DRAWN BY: KYLE SMITH


SCALE: 3/16" = 1'-0"

DATE: 07/16/2010

SHEET NO: 34

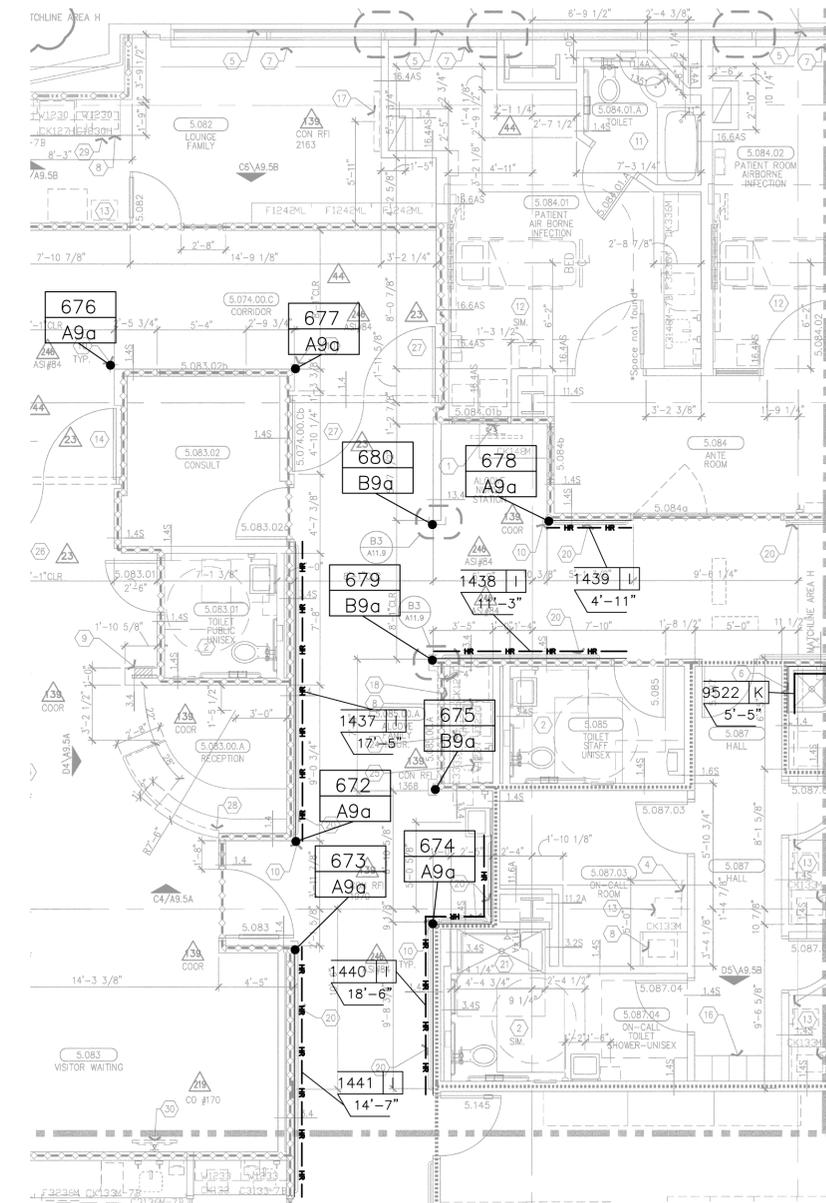

LEVEL 5 AREA "H"
ARCHITECTURAL DRAWING REFERENCED A3.5H DATED 08/08/2011 3/16" = 1'-0"

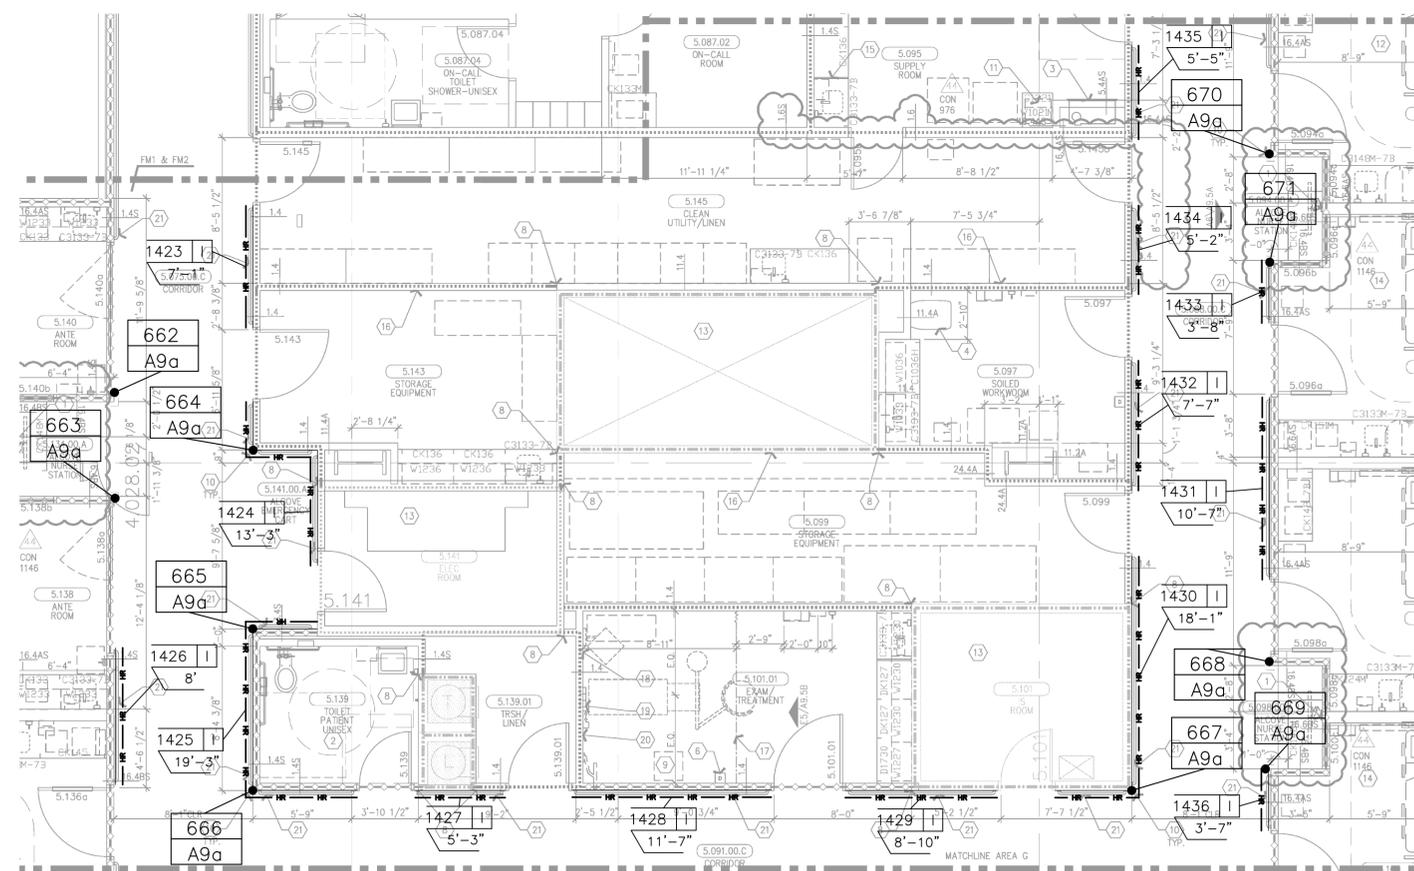

LEVEL 5 AREA "G"
ARCHITECTURAL DRAWING REFERENCED A3.5G DATED 05/28/2010 3/16" = 1'-0"

NO.	REVISION	DATE	BY
1	1ST (RFI#688)	11/03/10	KAS
2	2ND (RETURNED DWG)	5/17/11	KAS
3	UPDATED DWGS & RFI'S	10/20/11	KAS
4	4TH (RETURNED DWG)	02/24/12	KAS

NO.	FILE & FIELD	DATE	BY

GENERAL NOTES:

CORNER GUARD SYMBOL

MARK #	A REF. SECTION
104	1 UNIT HEIGHT
ATX	BASE HEIGHT/ELEV

COLOR/CODE	CODE	SECTION	UNIT HGT	BASE/ELEV	QTY
#253 PARCHMENT	A9a	A	9'-0"	N/A	9
#253 PARCHMENT	B9a	B	9'-0"	N/A	1

REFERENCE MARK # X = SECTION IDENTIFICATION

1001 X
9'

SCALED UNIT LENGTH

MATERIAL WILL BE FURNISHED IN STOCK LENGTHS TO BE FIELD CUT. MATERIAL QUANTITY SHALL BE BASED ON DIMENSIONS INDICATED AS SCALED UNIT LENGTH.


COLOR/CODE	SECTION	MODEL	L/F REQUIRED	LINE TYPE
#253 PARCHMENT	I	HRB4C	68'-9"	HR

- MATERIAL LIST:
- A= SM20A
 - B= SSM25A
 - C= SM20M
 - D= NOT USED
 - E= NOT USED
 - F= C08
 - G= SC08
 - H= C08M
 - I= HRB-4C
 - J= HRB-4C/SCR64M
 - K= .060 WC @ 4'-0"
 - L= .060 WC @ FH


CS Construction Specialties™
 6600 Route 405 Highway, Manly PA 17756
 (800) 233-6400 • Fax: (317) 546-6000 • www.c-sgroup.com

This document is the property of Construction Specialties, Inc. and contains confidential proprietary information that is not to be disclosed to third parties and is not to be used without approval in writing from Construction Specialties, Inc.

PROJECT: CHILDREN'S HOSPITAL TOWER 2
 JOB NO.: 759986
 CUSTOMER: L2 SPECIALTIES INC.
 REP: #111 IMC
 DRAWN BY: KYLE SMITH
 SCALE: 3/16" = 1'-0"
 DATE: 07/16/2010
 SHEET NO: 35


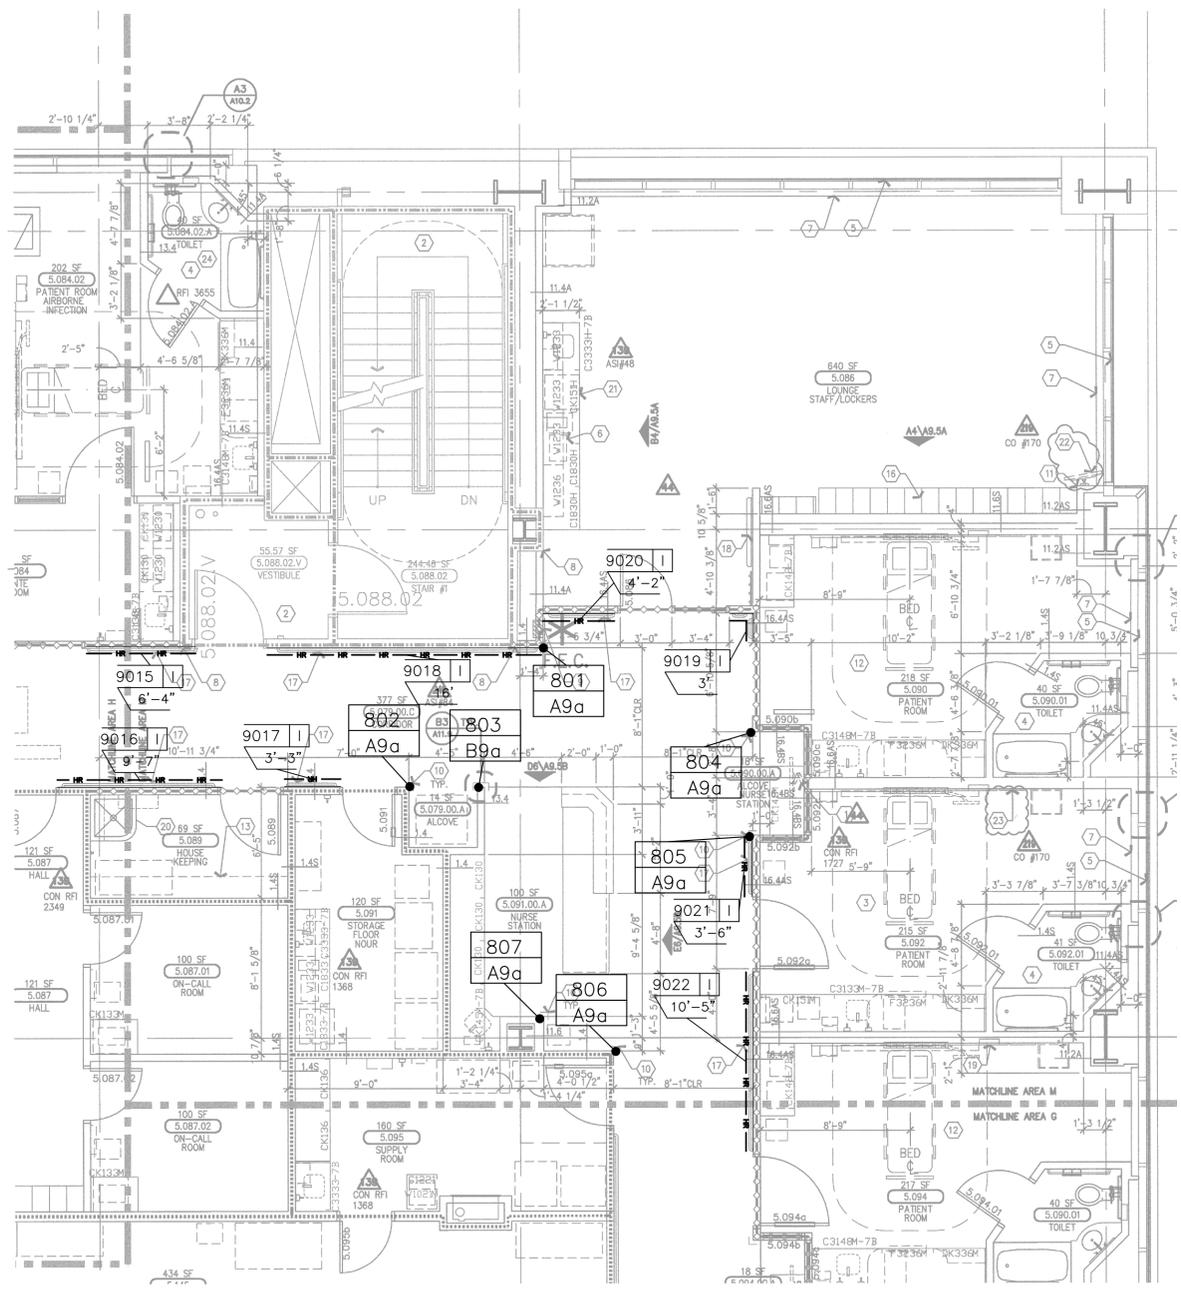


LEVEL 5 AREA "M"
 ARCHITECTURAL DRAWING REFERENCED A3.5M DATED 05/26/2011
 3/16" = 1'-0"

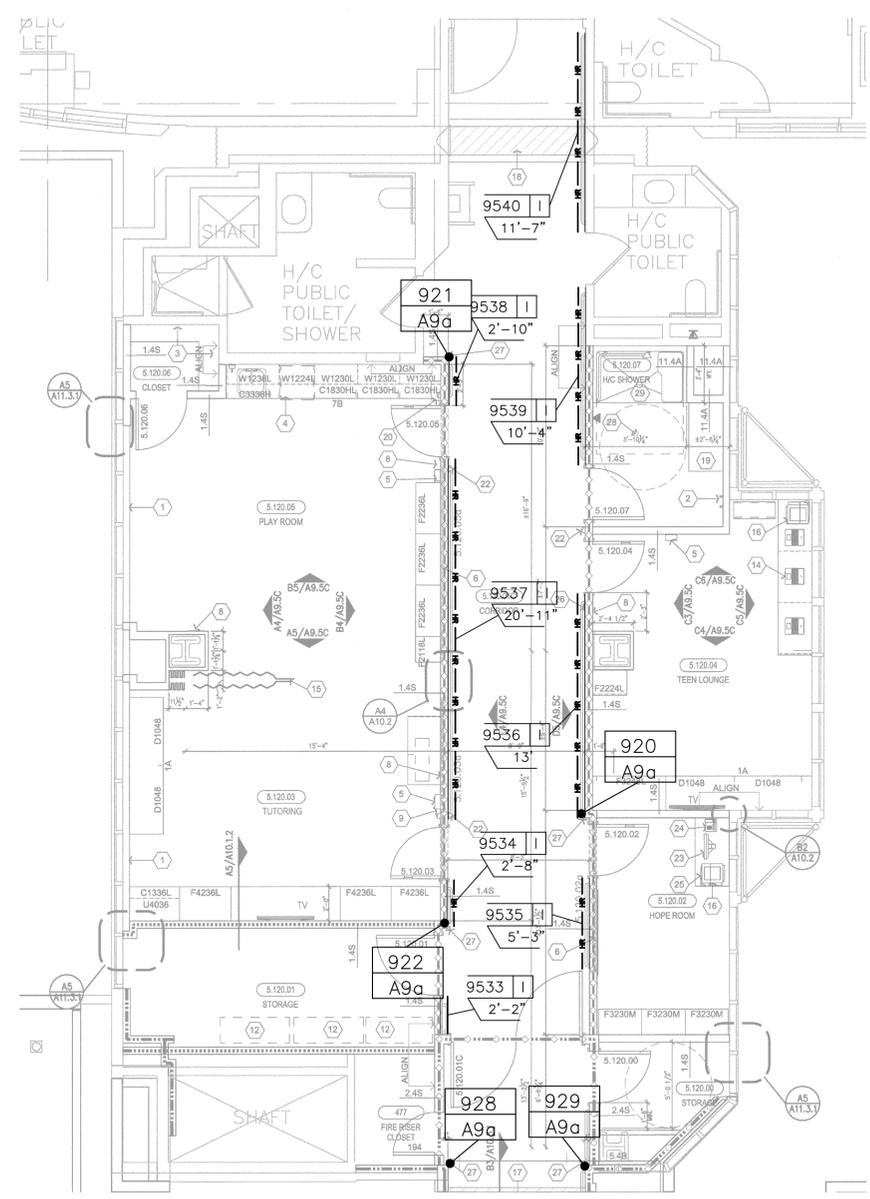


LEVEL 5 AREA "P"
 ARCHITECTURAL DRAWING REFERENCED A3.5P DATED 08/08/2011
 3/16" = 1'-0"

RELEASE INFO						
RELEASE	LOCATION	CODE	COLOR	RETAINER HEIGHT	COVER HEIGHT	QTY
XXXXX	----	XXX	XXX	XXX	XXX	XXX

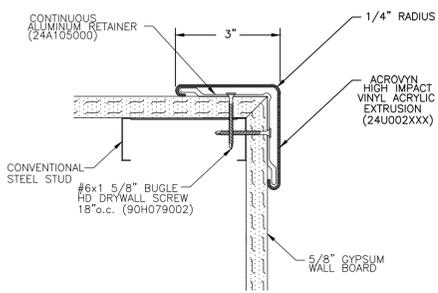
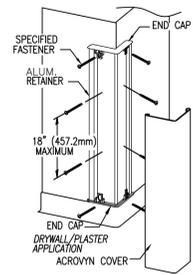


SM-20A
SECTION A

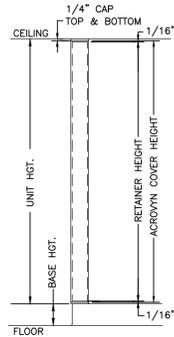


SURFACE MOUNTED GUARD AT FULL HEIGHT ELEVATION

RELEASE INFO								
RELEASE	LOCATION	CODE	COLOR	RETAINER HEIGHT	COVER HEIGHT	WIDTH	QTY	
XXXXX	----	XXX	XXX	XXX	XXX	XXX	XXX	

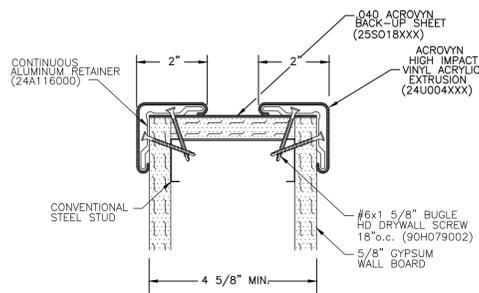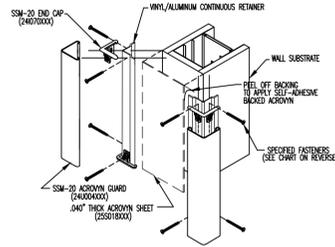

SECTION B



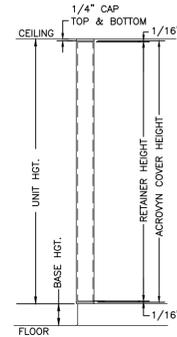


SURFACE MOUNTED GUARD AT FULL HEIGHT ELEVATION


RELEASE INFO							
RELEASE	LOCATION	CODE	COLOR	RETAINER HEIGHT	COVER HEIGHT	ANGLE	QTY
XXXXX	----	XXX	XXX	XXX	XXX	XX'	XXX

NOTE: MATERIAL MUST BEACHT MIN 24 HOURS PRIOR TO INSTALLATION. THIS IS ESSENTIAL TO MINIMIZE EXPANSION AND CONTRACTION OF THE MATERIAL.

Angle	Deciml Inches	Fractional Inches	Milimeters
45	1.657	1 21/32	42.088
50	1.768	1 3/4	44.289
55	1.870	1 51/64	46.492
60	1.960	1 29/32	48.260
65	1.970	1 31/32	50.038
70	2.050	2 1/64	51.308
75	2.092	2 3/64	52.121
80	2.095	2 5/64	52.984
85	2.110	2 7/64	53.984
90			
95	2.126	2 1/8	54.000
100	2.132	2 9/64	54.153
105	2.154	2 5/32	54.712
110	2.162	2 3/16	55.433
115	2.219	2 7/32	56.363
120	2.241	2 1/4	56.961
125	2.255	2 17/64	57.531
130	2.285	2 9/32	58.039
135	2.300	2 5/16	58.432
140	2.310	2 5/16	58.674
145	2.318	2 21/64	58.877
150	2.320	2 21/64	59.055

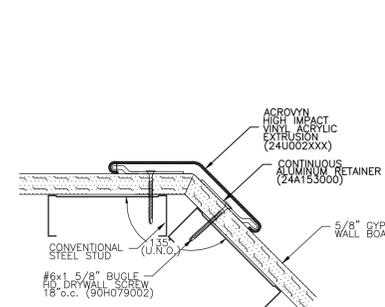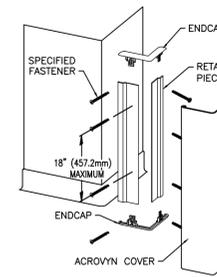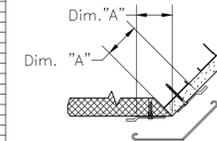

SM-20M
SECTION C
ANGLES ONLY AVAILABLE BETWEEN 45° - 160°

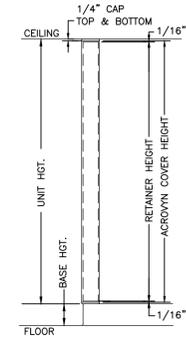

SURFACE MOUNTED GUARD AT FULL HEIGHT ELEVATION



NO.	REVISION	DATE	BY
1	1ST (RFI#688)	11/03/10	KAS
2	2ND (RETURNED DWG)	5/17/11	KAS
3	UPDATED DWGS & RFI'S	10/20/11	KAS
4	4TH (RETURNED DWG)	02/24/12	KAS
NO.	FILE & FIELD	DATE	BY

GENERAL NOTES:


*See installation instructions included with the shipments for complete instructions when installing the material.

RELEASE INFO						
RELEASE	LOCATION	CODE	COLOR	RETAINER HEIGHT	COVER HEIGHT	QTY
XXXXX	----	XXX	XXX	XXX	XXX	XXX

STAINLESS STEEL GUARDS TO BE 16 GA, TYPE #304 ALLOY WITH #4 SATIN FINISH, SHIPPED WITH PROTECTIVE STRIPPABLE COATING.

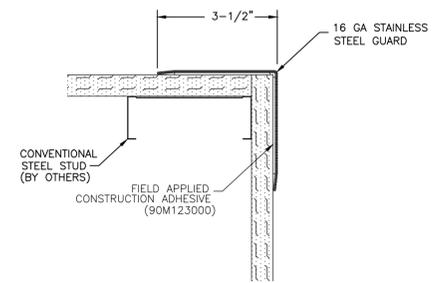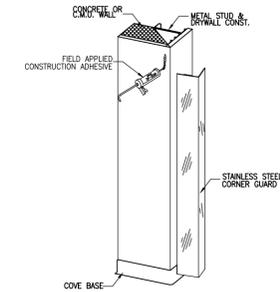

CO-8

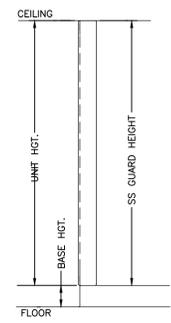

STAINLESS STEEL GUARD AT FULL HEIGHT ELEVATION

SECTION D

SECTION E

SECTION F

CS Construction Specialties
6600 Route 405 Highway, Manly PA 17756
(909) 233-6400 • Fax: (973) 546-6002 • www.c-sgroup.com

This document is the property of Construction Specialties, Inc. and contains confidential proprietary information that is not to be disclosed to third parties and is not to be used without approval in writing from Construction Specialties, Inc.

PROJECT: CHILDREN'S HOSPITAL TOWER 2
JOB NO.: 759986
CUSTOMER: L2 SPECIALTIES INC.
REP: #111 IMC
DRAWN BY: KYLE SMITH
SCALE: NTS
DATE: 07/16/2010
SHEET NO: 36

RELEASE INFO						
RELEASE	LOCATION	CODE	COLOR	RETAINER HEIGHT	COVER HEIGHT	QTY
XXXXX	----	XXX	XXX	XXX	XXX	XXX






RELEASE INFO							
RELEASE	LOCATION	CODE	COLOR	RETAINER HEIGHT	COVER HEIGHT	ANGLE	QTY
XXXXX	----	XXX	XXX	XXX	XXX	XX'	XXX

.XXX SHEET FABRICATION SCHEDULE			
NO.	REVISION	DATE	BY
1	1ST (RFI#688)	11/03/10	KAS
2	2ND (RETURNED DWG)	5/17/11	KAS
3	UPDATED DWGS & RFI'S	10/20/11	KAS
4	4TH (RETURNED DWG)	02/24/12	KAS


MATERIAL REQUIRED				QTY REQUIRED			
4' x 8' SHEETS							
4' x 10' SHEETS							
WAINSCOT TRIM @ 10'							
VERTICAL TRIM @ 10'							
OUTSIDE TRIM @ 10'							
INSIDE TRIM @ 10'							
90° O.S. T.F.C							
135° O.S. T.F.C							
COLOR MATCH CAULK							

GENERAL NOTES:
 *See installation instructions included with the shipments for complete instructions when installing the material.



NOTE:
 STAINLESS STEEL GUARDS TO BE 16 GA. TYPE #304 ALLOY WITH #4 SATIN FINISH, SHIPPED WITH PROTECTIVE STRIPPABLE COATING.

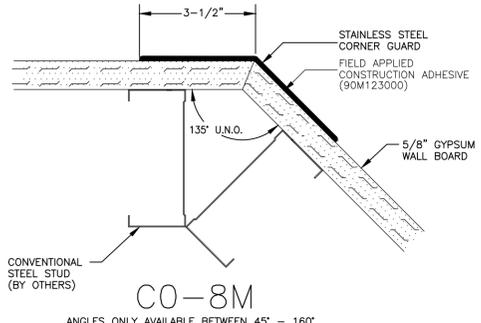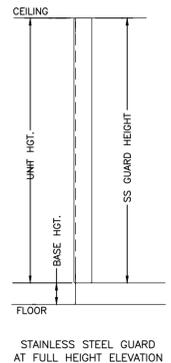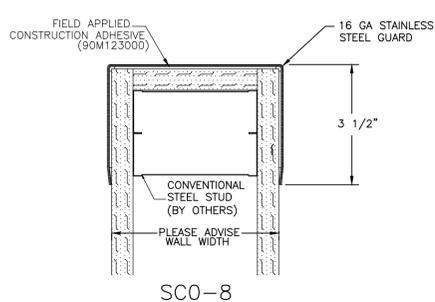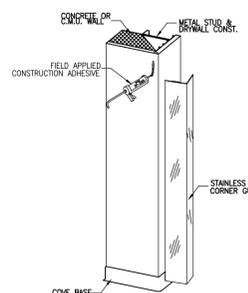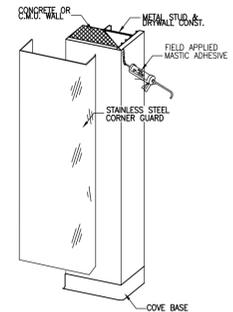



SECTION H

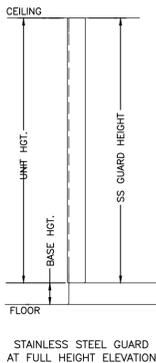

SECTION I

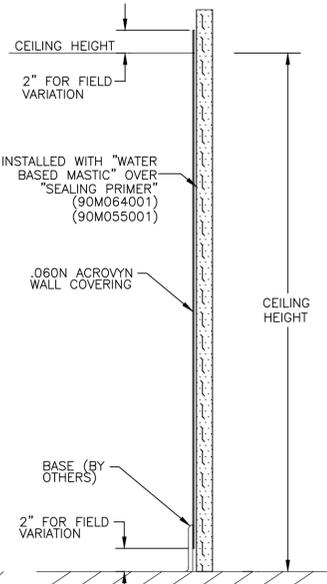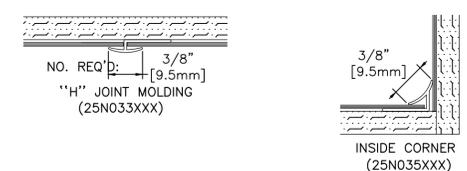

SECTION L

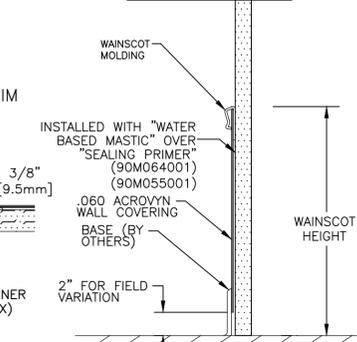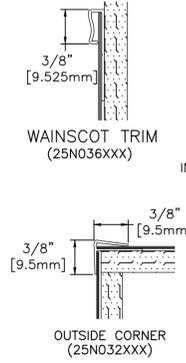


SECTION K


- INSTALLATION NOTES:
 1) WAINSCOT TRIM QUANTITY IS CALCULATED FOR WAINSCOT USE ONLY. NOT FOR EDGE TRIM.
 2) INSIDE CORNER TRIM QUANTITY IS BASED ON WHERE SHEET IS ON ADJOINING WALLS.
 3) OUTSIDE CORNER TRIM QUANTITY IS BASED ON SHEET ON BOTH WALLS AT CORNER.

MODEL XXXXXX FABRICATION SCHEDULE	
RELEASE:	
FLOOR:	
COLOR:	
MATERIAL REQUIRED	QTY REQUIRED
LINEAL FOOTAGE	
STD ENDCAPS	
90° OUTSIDE CORNER	
90° INSIDE CORNER	
SPLICE	

MODEL XXXXXX FABRICATION SCHEDULE	
RELEASE:	
FLOOR:	
COLOR:	
MATERIAL REQUIRED	QTY REQUIRED
LINEAL FOOTAGE	
STD ENDCAPS	
90° OUTSIDE CORNER	
90° INSIDE CORNER	
SPLICE	

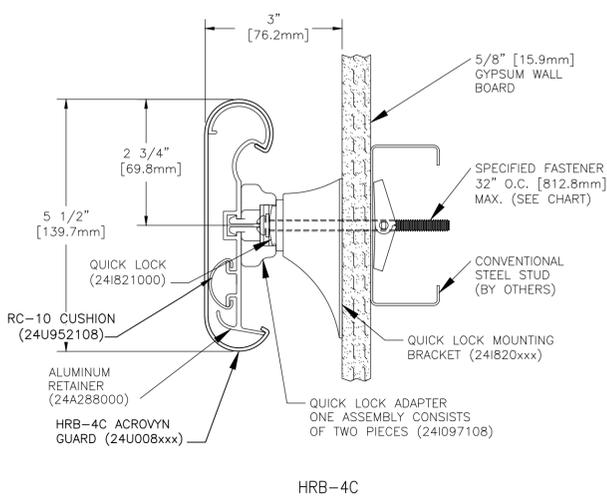

SECTIONS I & J

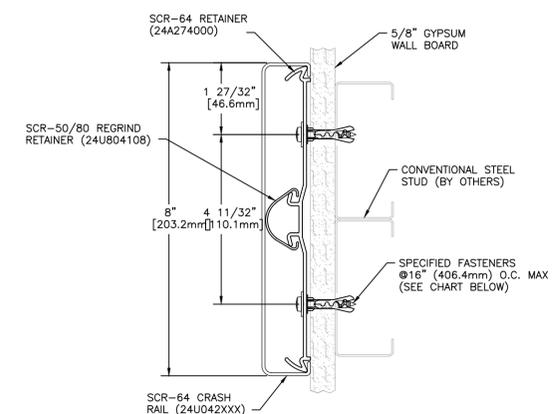

SECTION J



This document is the property of Construction Specialties, Inc. and contains confidential proprietary information that is not to be disclosed to third parties and is not to be used without approval in writing from Construction Specialties, Inc.

PROJECT: CHILDREN'S HOSPITAL TOWER 2
 JOB NO.: 759986
 CUSTOMER: L2 SPECIALTIES INC.
 REP: #111 IMC
 DRAWN BY: KYLE SMITH
 SCALE: NTS
 DATE: 07/16/2010
 SHEET NO: 37