



FKP Architects

ARCHITECT OF RECORD  
Paul C. Gloriod



REVISIONS  
02/05/10 INFORMATION BULLETIN #5  
05/28/10 ASI #06

APPROVAL

PROJECT NAME  
CHILDREN'S HOSPITAL  
OF ORANGE COUNTY  
455 S. Main St.  
Orange, CA 92868-3874

TOWER II



PROJECT NUMBER  
12011.00  
Increment #7  
OSHPD - PROJECT NUMBER  
IL 072072-30

ISSUE  
OSHPD PERMIT


DATE  
01/27/2010

SCALE  
1/4"=1'-0"

DRAWING TITLE  
LOWER LEVEL ENLARGED  
PLAN AREA - A

DRAWING NUMBER

A3.0A

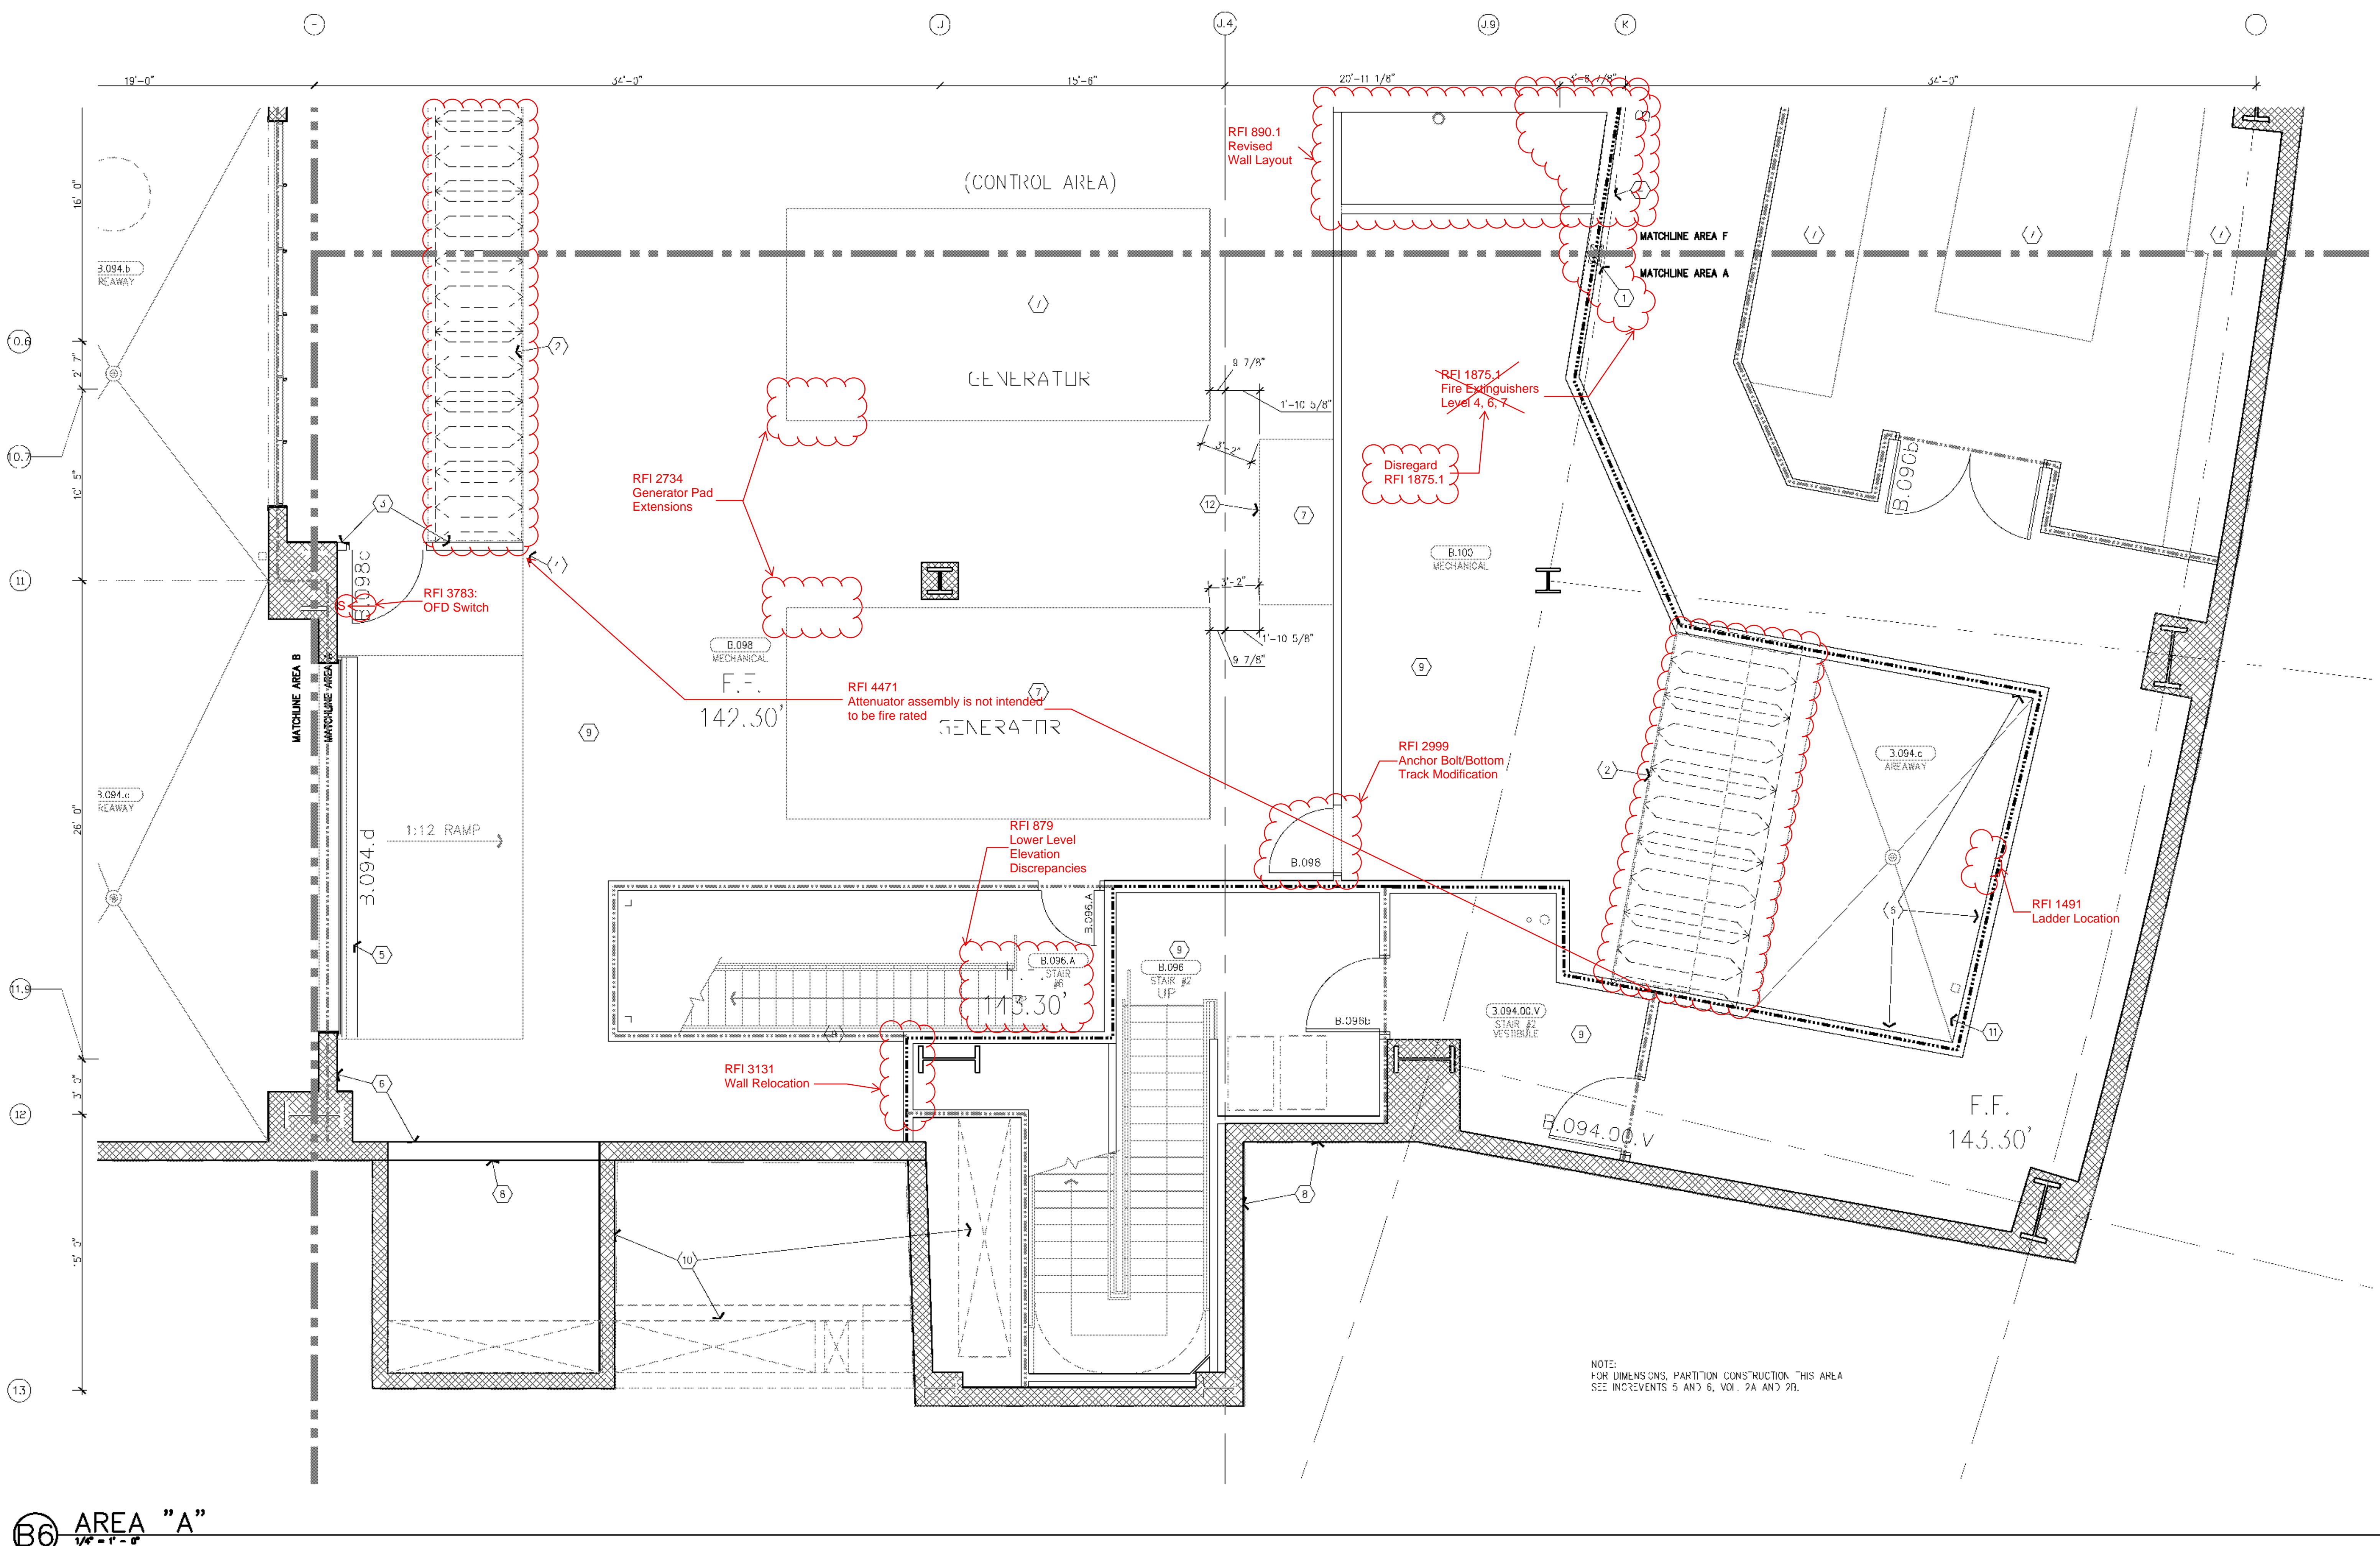

**B6 AREA "A"**

- Fire extinguisher cabinet, wa recessed, paint to match adjacent wall, typica. See Ref# A11.4 for detail.
- Exterior wall surface material, see Increment 6 for requirements.
- Exterior door, stainless steel, to 4'-0" A.F.
- Roll up exterior door, see Increment 6, Vol. 2A and 2B.
- Exterior wall construction. See Increment 6, Vol. 2A and 2B.
- Housekeeping panel, VEL/VEL/VEL, vol.
- Door closers, see Increment 6, Vol. 2A and 2B for requirements.
- For construction requirements this area, see Increment 6, Vol. 2A and 23.
- The o' close/closets above.
- Moisture sensor, cutible alarm monitor at -3' A.F.
- Equipment pad for two generator cog tanks of 100 gallons each, total of 200 gallons of fuel.

A. Intersection shown or references on enlarged end/or 1/4" scale drawings will generally not be shown on the smaller scale drawings.

B. Partition types, see General Notes to Partition Types on Sheet A11.3 and Partition Types on Sheet A11.3.1, etc. A11.5.2 for the definition of partition type reference.

C. Fix coordinate or field routed pipe, conduit, wire, etc., with sections of recessed ceiling or other equipment. In the event of a conflict, necessary sections take precedence.

D. Conceal joints between plumbing fixtures/accessories and ceiling materials w/space (i.e. between sinks, counters, toilet fixtures and accessories to wall, etc.)

E. Callout numbers noted on enlarged plans refer to Cabinet component numbers, fixtures, accessories, etc. that are defined or detailed on Sheet A9.0 unless specific callout notes state otherwise. See Ref# A11.4 (General Notes).

F. For partial enlarged plan at janitor closets, See detail A3/A11.1.

G. Individual suspended restroom graphics will be furnished and installed by the Owner's graphic supplier.

H. Standard equipment wall mounting heights, see detail A2/A11.9.

I. Medical equipment; wall mounting heights, see detail A7/A11.9, D3/A11.9 & Q9.02-Increment #7, Vol. 2E.

J. For vertical mounting heights of accessible toilet stall accessories, See detail A5/A11.7.

K. For vertical mounting heights of typical restroom accessories, See detail R5/A11.7.

L. For vertical mounting heights of accessible accessories of restrooms, See detail A6/A11.7.

M. For equipment not identified on plan, see Equipment drawings and workbooks-Increment #7, Vol. 2C.

N. For partial enlarged plan at janitor closets, See detail A3/A11.1.

O. Individual suspended restroom graphics will be furnished and installed by the Owner's graphic supplier.

P. Medical equipment; wall mounting heights, see detail A7/A11.9.

Q. For vertical mounting heights of accessible toilet stall accessories, See detail A5/A11.7.

R. For vertical mounting heights of typical restroom accessories, See detail A3/A11.9.

S. Equipment mounting heights on Countertops, see detail D3/A11.9.

T. Equipment mounting heights at Desks, see detail A4/A11.9.

U. A minimum head clearance of 6'-0" must be maintained at all points in stairways and areas where head clearance is limited.

V. For a dashed or equipment not identified, refer to -G drawing series-Increment #7, Vol. 2E and Equipment Workbooks. Specific items requiring structural support are cross-referenced to site council support details via notches shown on the Equipment drawings.

W.A. elevator hoist way entrance frames to have an embossed stainless steel graphic plaque with the floor having number and Standard A3.1 markings for the circ.

X. A. after floor, bridge to exterior steel perimeter—gloss enamel floor coating numerals 10' high, orange, to the rear of 5'-0" AFR in a contrasting color to the scheduled wall colors a graphic plaque's specifically detailed or noted.

Y. Elevator equipment wall mounting heights, see detail A6/A11.9 and 33/A11.9.

Z. For vertical mounting heights of accessible toilet stall accessories, See detail A3/A11.1.

AA. Provide wall blocking/bracing for floors weighing 200bs or less. See A5/A11.3.

BB. For vertical mounting heights of accessible toilet stall accessories, See detail A3/A11.3.

CC. For optical equipment support, see A4/S1-Increment #3.

DD. For vertical mounting heights of accessible toilet stall accessories, See detail A3/A11.3.

EE. For vertical mounting heights of accessible toilet stall accessories, See detail A3/A11.3.

FF. For vertical mounting heights of accessible toilet stall accessories, See detail A3/A11.3.

GG. Provide access schedule below the Pictures. Room countants to serve as inspection

RFI 5099-0 for Grommet Locations;  
Typ. all levels & areas

S	T	U
R	Q	
K	L	P
		N
J	H	M
D	E	G
C	B	F
		A

**A6 NOTES TO SHEET**

**A5 GENERAL NOTES**

**A1 KEY PLAN**