




PUBLIC RESTROOM - RCP

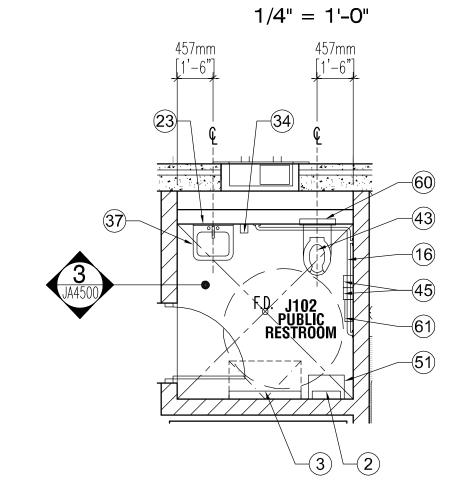

PUBLIC RESTROOM - PLAN 3 1/4" = 1'-0"

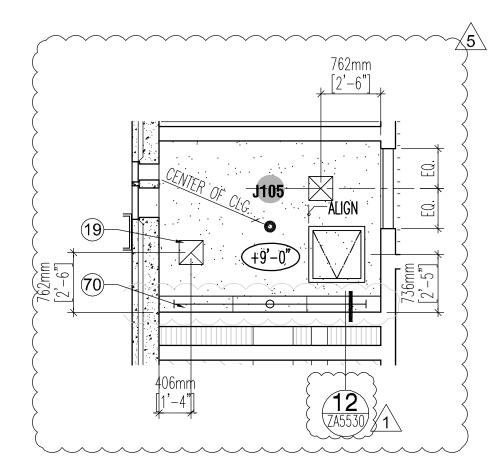

STAFF RESTROOM - RCP 1/4" = 1'-0"

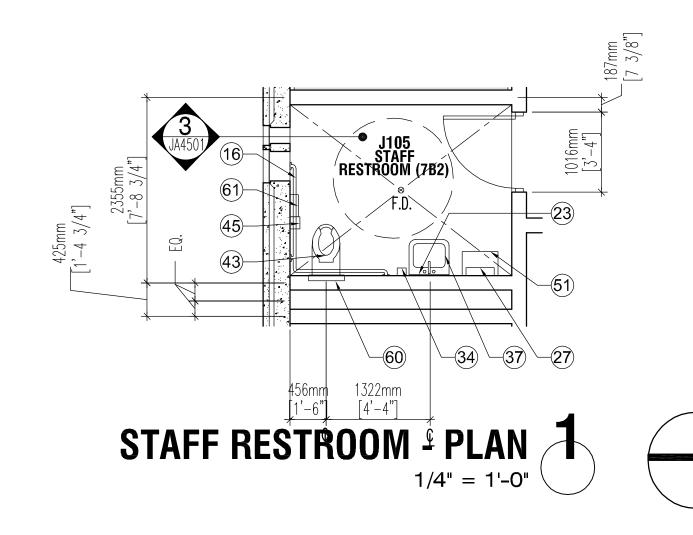

KEY NOTES) ACCESS PANEL FOR TRAP PRIMER (2) HD-1: ELECTRIC HAND DRYER (3) CS-1: CHANGING STATION (4) C.I.P. CONCRETE BENCH (5) FOR INFORMATION THIS AREA REF. ARCHITECTURAL ENLARGED SITE PLAN SHEET ZA5200 (6) C.I.P. CONCRETE WALL 7) KENNEL FENCING AND GATE SYSTEM - REF SPECS. 13 19 13 (8) DRINKING FOUNTAIN, REF. PLUMBING, COORD. OPENINGS IN CONC. w/ EDF MFR WHERE OCCUR (9) ELECTRICAL EQUIPMENT, REF. ELECTRICAL **GENERAL NOTES** 10) EMERGENCY EYEWASH/ SHOWER, REF. PLUMBING (11) EQUIPMENT, REF. EQUIPMENT DRAWINGS & SCHEDULE (12) GLAZING BARRIER WALL (13) FIRE RISER, REF. FIRE PROTECTION (14) FIRE PANEL, REF. FIRE PROTECTION (15) PEDESTRIAN BARRIER SYSTEM, FLOOR MOUNTED (16) GB-1 : GRAB BAR, TOILET (17) GB-2 : GRAB BAR, SHOWER (18) HK-1: HOOK (19) HVAC DIFFUSER, REF. MECHANICAL (20) I.T. EQUIPMENT, N.I.C., REF. TELECOM FLOOR / CEILING PLAN LEGEND (21) LIGHT FIXTURE, REF. ELECTRICAL (22) MILLWORK, REF. INTERIOR ELEVATIONS (23) MIRROR, REF. INTERIOR ELEVATIONS (24) MOP SINK, REF. PLMBG, w/ MS-1: MOP SINK SHELF ABOVE (25) OPEN/ NO ROOF (26) BOLLARD (27) PTD-1: PAPER TOWEL DISPENSER (28) PARTITION WALL, REF. INTERIORS (29) FOR INFORMATION THIS AREA REF. ENLARGED LANDSCAPE DWG. (30) PERF. PANEL o/ RUST FINISH STL. FRAMING, REF. SPECIFICATIONS FOR PANEL TYPE & SCHEDULE FOR COLOR (31) ACCESS FLOOR SYSTEM (32) RECESSED RESTRAINT RINGS (33) SLIDING KENNEL GATE W/ HINGED ATTACHMENT (34) SD-1: SOAP DISPENSER, WALL MOUNTED (35) SHOWER HEAD, REF. PLUMBING (36) SS-1 : SHOWER SEAT (37) SINK, REF. PLUMBING (38) SC-1: SHOWER CURTAIN, HOOKS, AND ROD (39) STEEL, RUST FINISH 40 STEEL PIPE HANDRAIL, S.STL. (41) STEEL PIPE GUARDRAIL, S.STL. (42) STEEL PIPE POST, S.STL. 43 TOILET, REF. PLUMBING 44) TOILET/SINK/EDF, PENAL GRADE, REF. PLUMBING (45) TPD-1: TOILET PAPER DISPENSER, MULTI-ROLL (46) TOILET PARTITIONS - CEILING HUNG 47 TRENCH DRAIN, REF. PLUMBING U.N.O. 48) TURNSTILE - TYPE 3 (FULL HT.) REF. SPECIAL EQUIP. PLANS 49 URINAL, REF. PLUMBING 50 VENDING MACHINE, N.I.C. 1) WR-1: WASTE RECEPTACLE (52) PLUMBING FIXTURE / EQUIPMENT, REF. PLUMBING (53) SKYLIGHT GLAZING, REF ROOF PLAN FOR TYPE & LOCATIONS (54) URINAL SCREEN (55) CONTINUOUS TRENCH, REF. DETAIL 1/ZA5530 (56) TURNSTILE - TYPE 1 (WAIST HIGH) REF. SPECIAL EQUIP. PLANS (57) TURNSTILE — TYPE 2 (ADA GATE) REF. SPECIAL EQUIP. PLANS (58) SD-2: SOAP DISPENSER, COUNTER MOUNTED (59) TPD-2: TOILET PAPER DISPENSER W/ SEAT COVER DISPENSER & SANITARY NAPKIN DISPOSAL 60 SCD-1: SEAT COVER DISPENSER (61) SND-1: SANITARY NAPKIN DISPOSAL (62) SNV-1: SANITARY NAPKIN VENDOR

WALL & SYMBOL LEGEND

65 CABLE ANCHOR 66 SD-3: SOAP DISH

CONCRETE TILT UP WALL, TEXTURED INSULATED CONCRETE TILT UP WALL, TEXTURED CONCRETE MASONRY UNIT WALL, REF. FINISH SCHEDULE FOR INTERIOR FINISH & EXT. ELEVS.

5 TO LIGHT COVE LC-1, REF. ELECTRICAL FOR ADDITIONAL INFO

63) FENCING, REF. ARCH. ENLARGED SITE PLAN SHEET ZA5200

(64) ACOUSTIC TREATMENT & LIGHTING FEATURE ABOVE

67 CEILING ACCESS PANEL: TYPE 1 (TYPICAL) (68) CEILING ACCESS PANEL: TYPE 2 (FIRE RATED) 69 CEILING ACCESS PANEL: TYPE 3 (SECURITY)

WIRE FACED MSE WALL / GABION BASKET WALL GLAZING FRAMING SYSTEM

INTERIOR PARTITION WALL, 6" MTL FRAMING, REF.
FINISH SCHEDULE, ACOUSTIC BATTS PER WALL TYPES • I STEEL COLUMN, NATURAL FINISH, REF. STRUCTURAL

ROUND 'PUNCH' WINDOW IN FURRED CONCRETE TILT—UP WALL, REF. PANEL ELEVATIONS FOR DIMENSIONS & LOCATIONS $[\]\ [\]\$ Furniture and equipment shown dashed is n.i.c.

OVERHEAD SHELVING OR CABINETS, REF. INT. ELEV.

————— 1-HOUR RATED WALL CONSTRUCTION — · · · · · · SMOKE PARTITION,

 $\pm_{
m H.B.}$ HOSE BIBB, REF. INT./EXT. ELEVATIONS FOR LOCATION AND PLUMBING DRAWINGS FOR TYPE AD: F.D. AREA DRAIN / FLOOR DRAIN, REF. PLUMBING. SLOPE

1-HOUR RATED WALL CONSTRUCTION

SURROUNDING FLOOR TO DRAIN AS INDICATED c.c. ⊏ c.c. ⊏ CORNER GUARD

SKYLIGHT ABOVE CEILING, REF. ROOF PLAN FOR TYPE, SIZE, AND LOCATION

SECURITY CAMERA

• FIRE SPRINKLER HEAD, REF. FIRE PROTECTION

DESCRIPTION

. FURNITURE FIXTURES AND EQUIPMENT ARE NOT PART OF THE

PROJECT SCOPE AND CONSTRUCTION CONTRACT. THE SERVICES

TO PROVIDE FOR FFE ITEMS IS THE RESPONSIBILITY OF GSA

2. REFERENCE PROJECT MANUAL FOR DOOR & FINISH SCHEDULES.

3. REF. INT./ EXT. ELEVATIONS & PROJECT MANUAL FOR GLAZING

GYPSUM BOARD o/ SUSPENDED METAL FRAMING

BAFFLED CEILING SYSTEM, CLEAR SEALED/ 'NAT.

STRUCTURE, DECKING, HVAC EQUIPMENT, & ELEC FIXTURES ABOVE BAFFLES ARE TO BE PAINTED.

REF. FINISH SCHEDULE FOR COLOR. AT EXTERIOR

STRUCTURE ABOVE BAFFLES IS TO BE RUST FINISH

SILVER' METAL BAFFLES. AT INTERIOR : ALL

EXPOSED METAL DECK & STRUCTURE

AND THEIR RESPECTIVE TENANTS FOR THIS PROJECT.

MILLWORK

ADDENDUM DELTA TYPES \times issued by addnm. Sketch or by Re-issued sheet Xm ISSUED BY ADDNM. NARRATIVE (TEXT) ONLY ISSUED BY ADDNM. RESPONSE TO BIDDER QUESTION ONLY

DATE

02/01/10 ADDENDUM #1

06/28/10 DESIGN CLARIFICATIONS

DRAWING TITLE ENLARGED FLOOR PLANS FILE NAME J-A4000-NAZ00001.DWG FLOOR NO.

의DRAWN BY DATE DRAFTED: 01/03/2010 | **E** CHECKED BY SHEET SIZE: 30 X 42 DRAWING NO. PACKAGE DISC. TYPE SHEET NO.

SENSITIVE BUT UNCLASSIFIED (SBU) PROPERTY OF THE UNITED STATES GOVERNMENT. COPYING, DISSEMINATION, OR DISTRIBUTION OF THIS DOCUMENT TO UNAUTHORIZED RECIPIENTS IS PROHIBITED. DO NOT REMOVE THIS NOTICE. PROPERLY DESTROY OR RETURN DOCUMENTS WHEN NO LONGER NEEDED.