



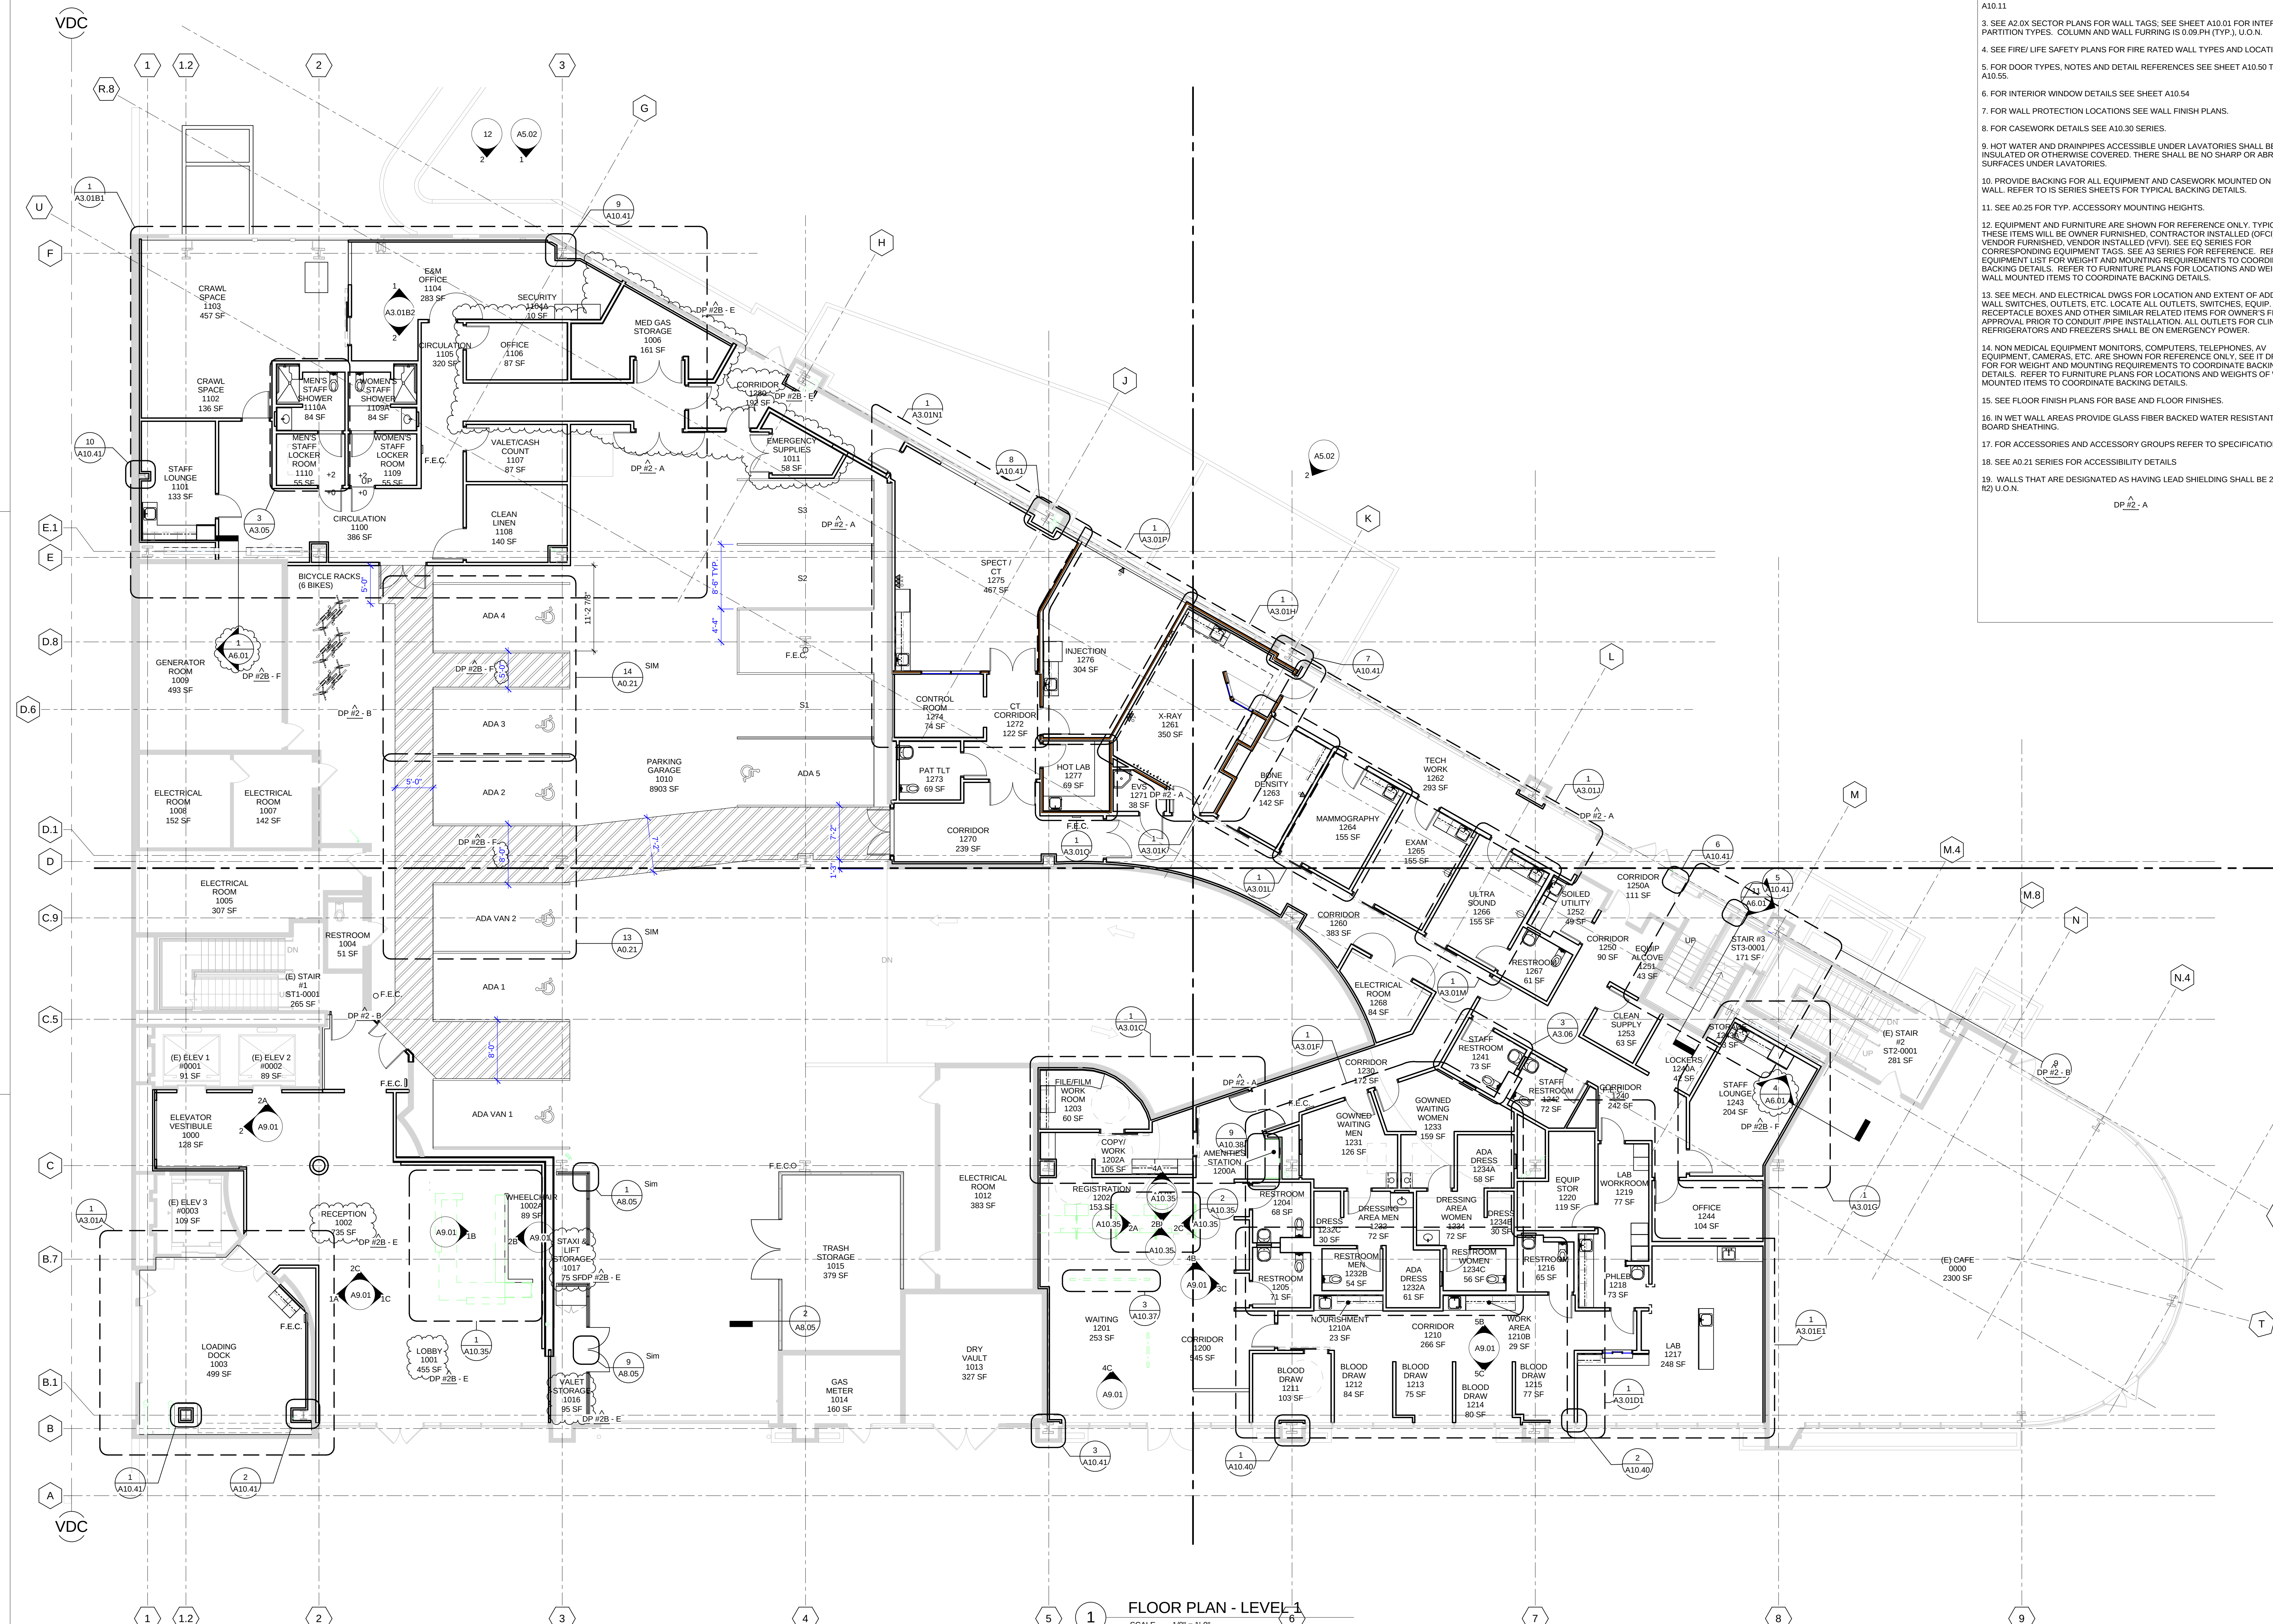


- GENERAL NOTES**
- DIMENSIONS ARE TO FACE OF FINISH OR CENTERLINE OF COLUMN, U.O.N. DIMENSION STRINGS ARE STARTED AT STRUCTURAL GRIDLINES.
 - FOR TYPICAL WALL FRAMING CONDITIONS AND DETAILING SEE SHEETS A10.00 - A10.11
 - SEE A2.0X SECTOR PLANS FOR WALL TAGS; SEE SHEET A10.01 FOR INTERIOR PARTITION TYPES. COLUMN AND WALL FURRING IS 0.09 PH (TYP.), U.O.N.
 - SEE FIRE/LIFE SAFETY PLANS FOR FIRE RATED WALL TYPES AND LOCATIONS.
 - FOR DOOR TYPES, NOTES AND DETAIL REFERENCES SEE SHEET A10.50 TO A10.55.
 - FOR INTERIOR WINDOW DETAILS SEE SHEET A10.54
 - FOR WALL PROTECTION LOCATIONS SEE WALL FINISH PLANS.
 - FOR CASEWORK DETAILS SEE A10.30 SERIES.
 - HOT WATER AND DRAINPIES ACCESSIBLE UNDER LAVATORIES SHALL BE INSULATED OR OTHERWISE COVERED. THERE SHALL BE NO SHARP OR ABRASIVE SURFACES UNDER LAVATORIES.
 - PROVIDE BACKING FOR ALL EQUIPMENT AND CASEWORK MOUNTED ON THE WALL. REFER TO IS SERIES SHEETS FOR TYPICAL BACKING DETAILS.
 - SEE A0.25 FOR TYP. ACCESSORY MOUNTING HEIGHTS.
 - EQUIPMENT AND FURNITURE ARE SHOWN FOR REFERENCE ONLY. TYPICALLY THESE ITEMS WILL BE OWNER FURNISHED. CONTRACTOR INSTALLED (OFCI). VENDOR FURNISHED. VENDOR INSTALLED (VFI). SEE EQ SERIES FOR CORRESPONDING EQUIPMENT TAGS. SEE A3 SERIES FOR REFERENCE. REFER TO EQUIPMENT LIST FOR WEIGHT AND MOUNTING REQUIREMENTS TO COORDINATE BACKING DETAILS. REFER TO FURNITURE PLANS FOR LOCATIONS AND WEIGHTS OF WALL MOUNTED ITEMS TO COORDINATE BACKING DETAILS.
 - SEE MECH. AND ELECTRICAL DWGS FOR LOCATION AND EXTENT OF ADDITIONAL WALL SWITCHES, OUTLETS, ETC. LOCATE ALL OUTLETS, SWITCHES, EQUIP. RECEPTACLE BOXES AND OTHER SIMILAR RELATED ITEMS FOR OWNER'S FINAL APPROVAL PRIOR TO CONDUIT/PIPE INSTALLATION. ALL OUTLETS FOR CLINICAL REFRIGERATORS AND FREEZERS SHALL BE ON EMERGENCY POWER.
 - NON MEDICAL EQUIPMENT MONITORS, COMPUTERS, TELEPHONES, AV EQUIPMENT, CAMERAS, ETC. ARE SHOWN FOR REFERENCE ONLY. SEE IT DRAWINGS FOR WEIGHT AND MOUNTING REQUIREMENTS TO COORDINATE BACKING DETAILS. REFER TO FURNITURE PLANS FOR LOCATIONS AND WEIGHTS OF WALL MOUNTED ITEMS TO COORDINATE BACKING DETAILS.
 - SEE FLOOR FINISH PLANS FOR BASE AND FLOOR FINISHES.
 - IN WET WALL AREAS PROVIDE GLASS FIBER BACKED WATER RESISTANT WALL BOARD SHEATHING.
 - FOR ACCESSORIES AND ACCESSORY GROUPS REFER TO SPECIFICATIONS.
 - SEE A0.21 SERIES FOR ACCESSIBILITY DETAILS
 - WALLS THAT ARE DESIGNATED AS HAVING LEAD SHIELDING SHALL BE 2# (2lbs/ft²) U.O.N.

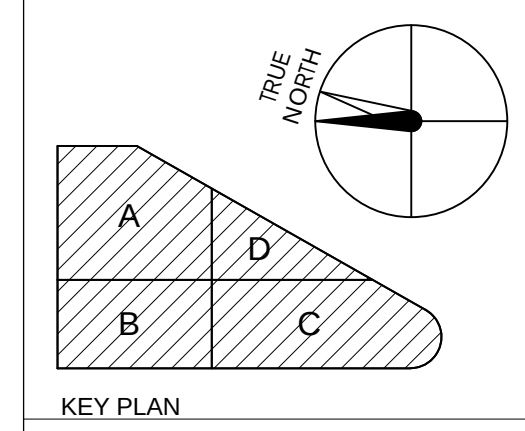

HENSEL PHELPS
Plan. Build. Manage.

K M D ARCHITECTS
ARCHITECTURE PLANNING
222 VALLEJO SAN FRANCISCO, CA 94111
(415) 398-5151 FAX (415) 394-7158


NO.	DATE	ISSUED FOR
1	2016/01/29	RESPONSE TO PLAN REVIEW
2	2016/01/29	RESPONSE TO FIRE REVIEW
3	2016/01/29	RESPONSE TO PLAN REVIEW
4	2016/01/29	DP #2 - 100% CD PACKAGE
5	2016/01/29	DP #2 - 50% CD PACKAGE
6	2016/01/29	DESIGN DEVELOPMENT
7	2016/01/29	BP #3 ADDENDUM A
8	2016/01/29	ISSUED FOR

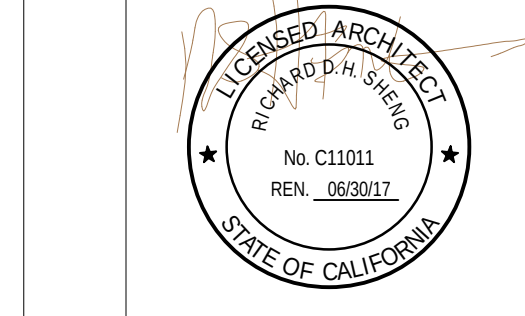



CERTIFIED BY
HEALTH CENTER EMERYVILLE
5800 HOLLIS STREET
EMERYVILLE, CA 94608

PLAN CHECK#
PROJECT NO.
106-201

FLOOR PLAN - LEVEL 1

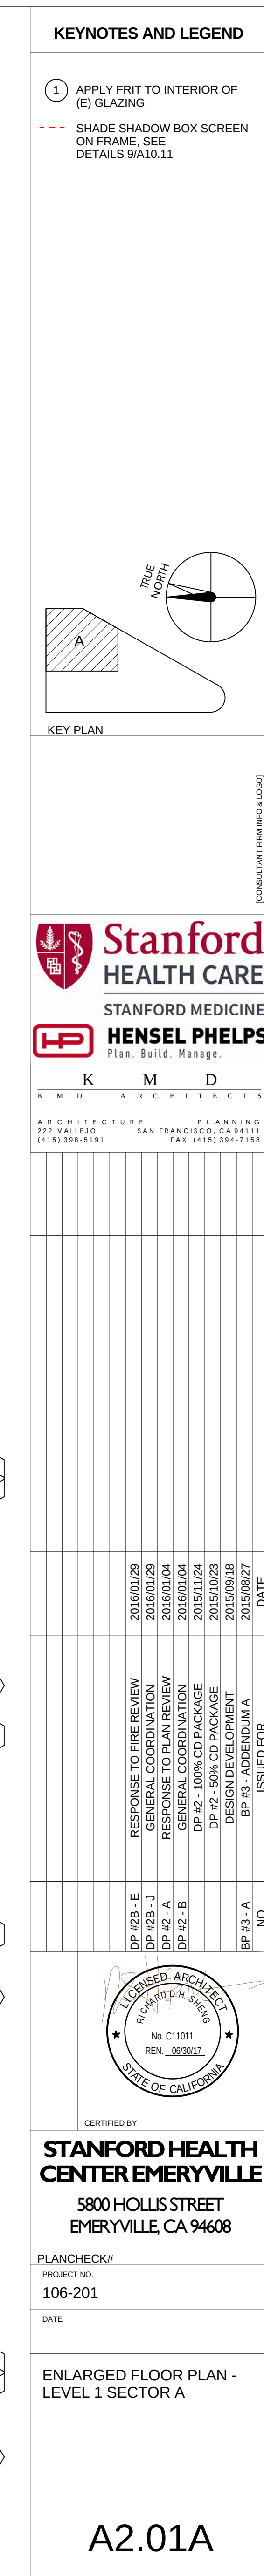


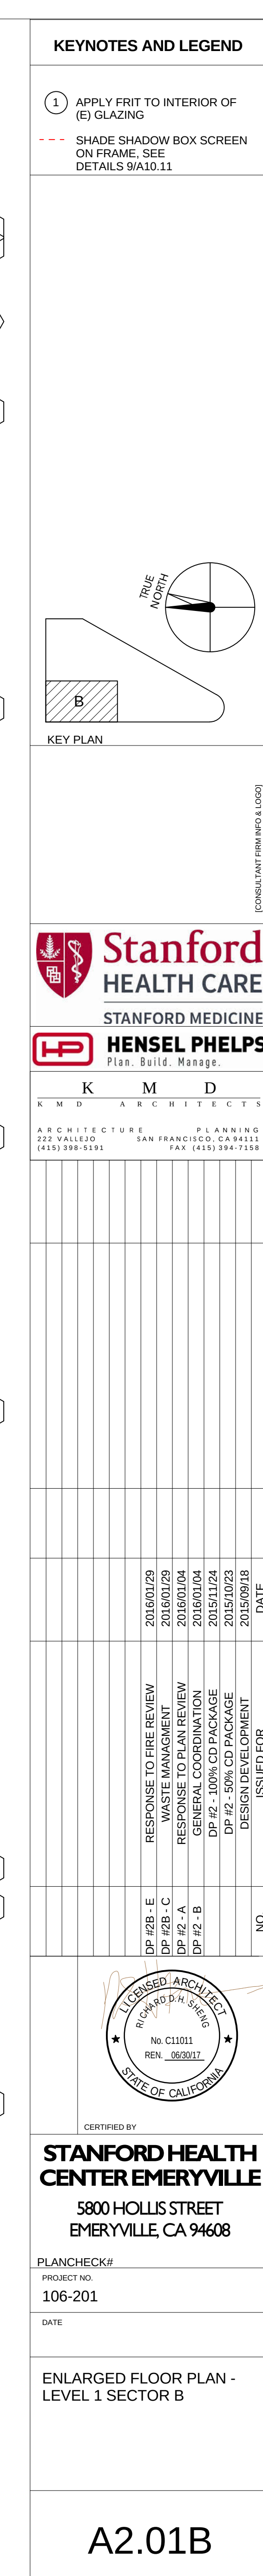

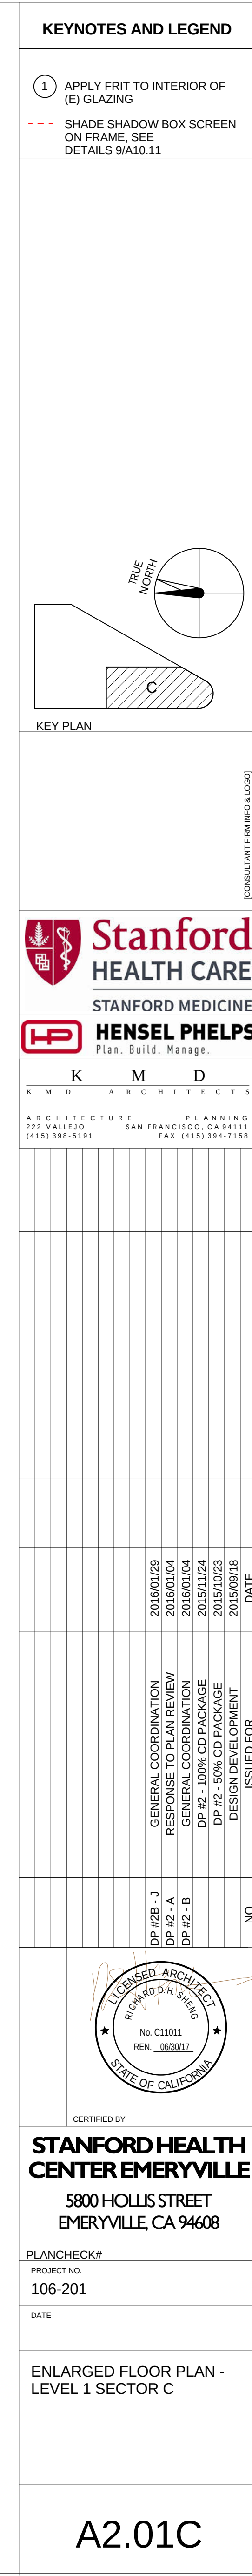

KEYNOTES AND LEGEND


- ① APPLY FRIT TO INTERIOR OF (E) GLAZING
- SHADE SHADOW BOX SCREEN ON FRAME. SEE DETAILS 9/A10.11

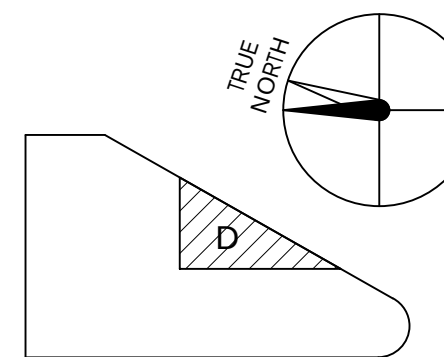

KEY PLAN

K M D ARCHITECTS
CONSULTANT/ARCHITECTSTANFORD MEDICINE
HENSEL PHELPS
Plan. Build. Manage.K M D ARCHITECTS
ARCHITECTURE PLANNING
222 WILLOW SAN FRANCISCO, CA 94111
(415) 398-9131 FAX (415) 394-7158

NO.	DATE	ISSUED FOR
2016/01/29	2016/01/29	RESPONSE TO PLAN REVIEW
2016/01/29	2016/01/29	REVISIONS
2016/01/29	2016/01/29	GENERAL COORDINATION
2016/01/29	2016/01/29	DP #2 - 100% CD PACKAGE
2016/01/29	2016/01/29	DP #2 - 50% CD PACKAGE
2016/01/29	2016/01/29	DESIGN DEVELOPMENT

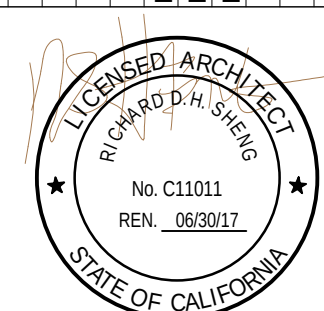

CERTIFIED BY

STANFORD HEALTH
CENTER EMERYVILLE5800 HOLIS STREET
EMERYVILLE, CA 94608

PLAN CHECK#

PROJECT NO.
106-201

DATE


ENLARGED FLOOR PLAN -
LEVEL 1 SECTOR D

A2.01D



1 ENLARGED FLOOR PLAN - LVL 1 - SECTOR D

SCALE 1/4" = 1'-0"

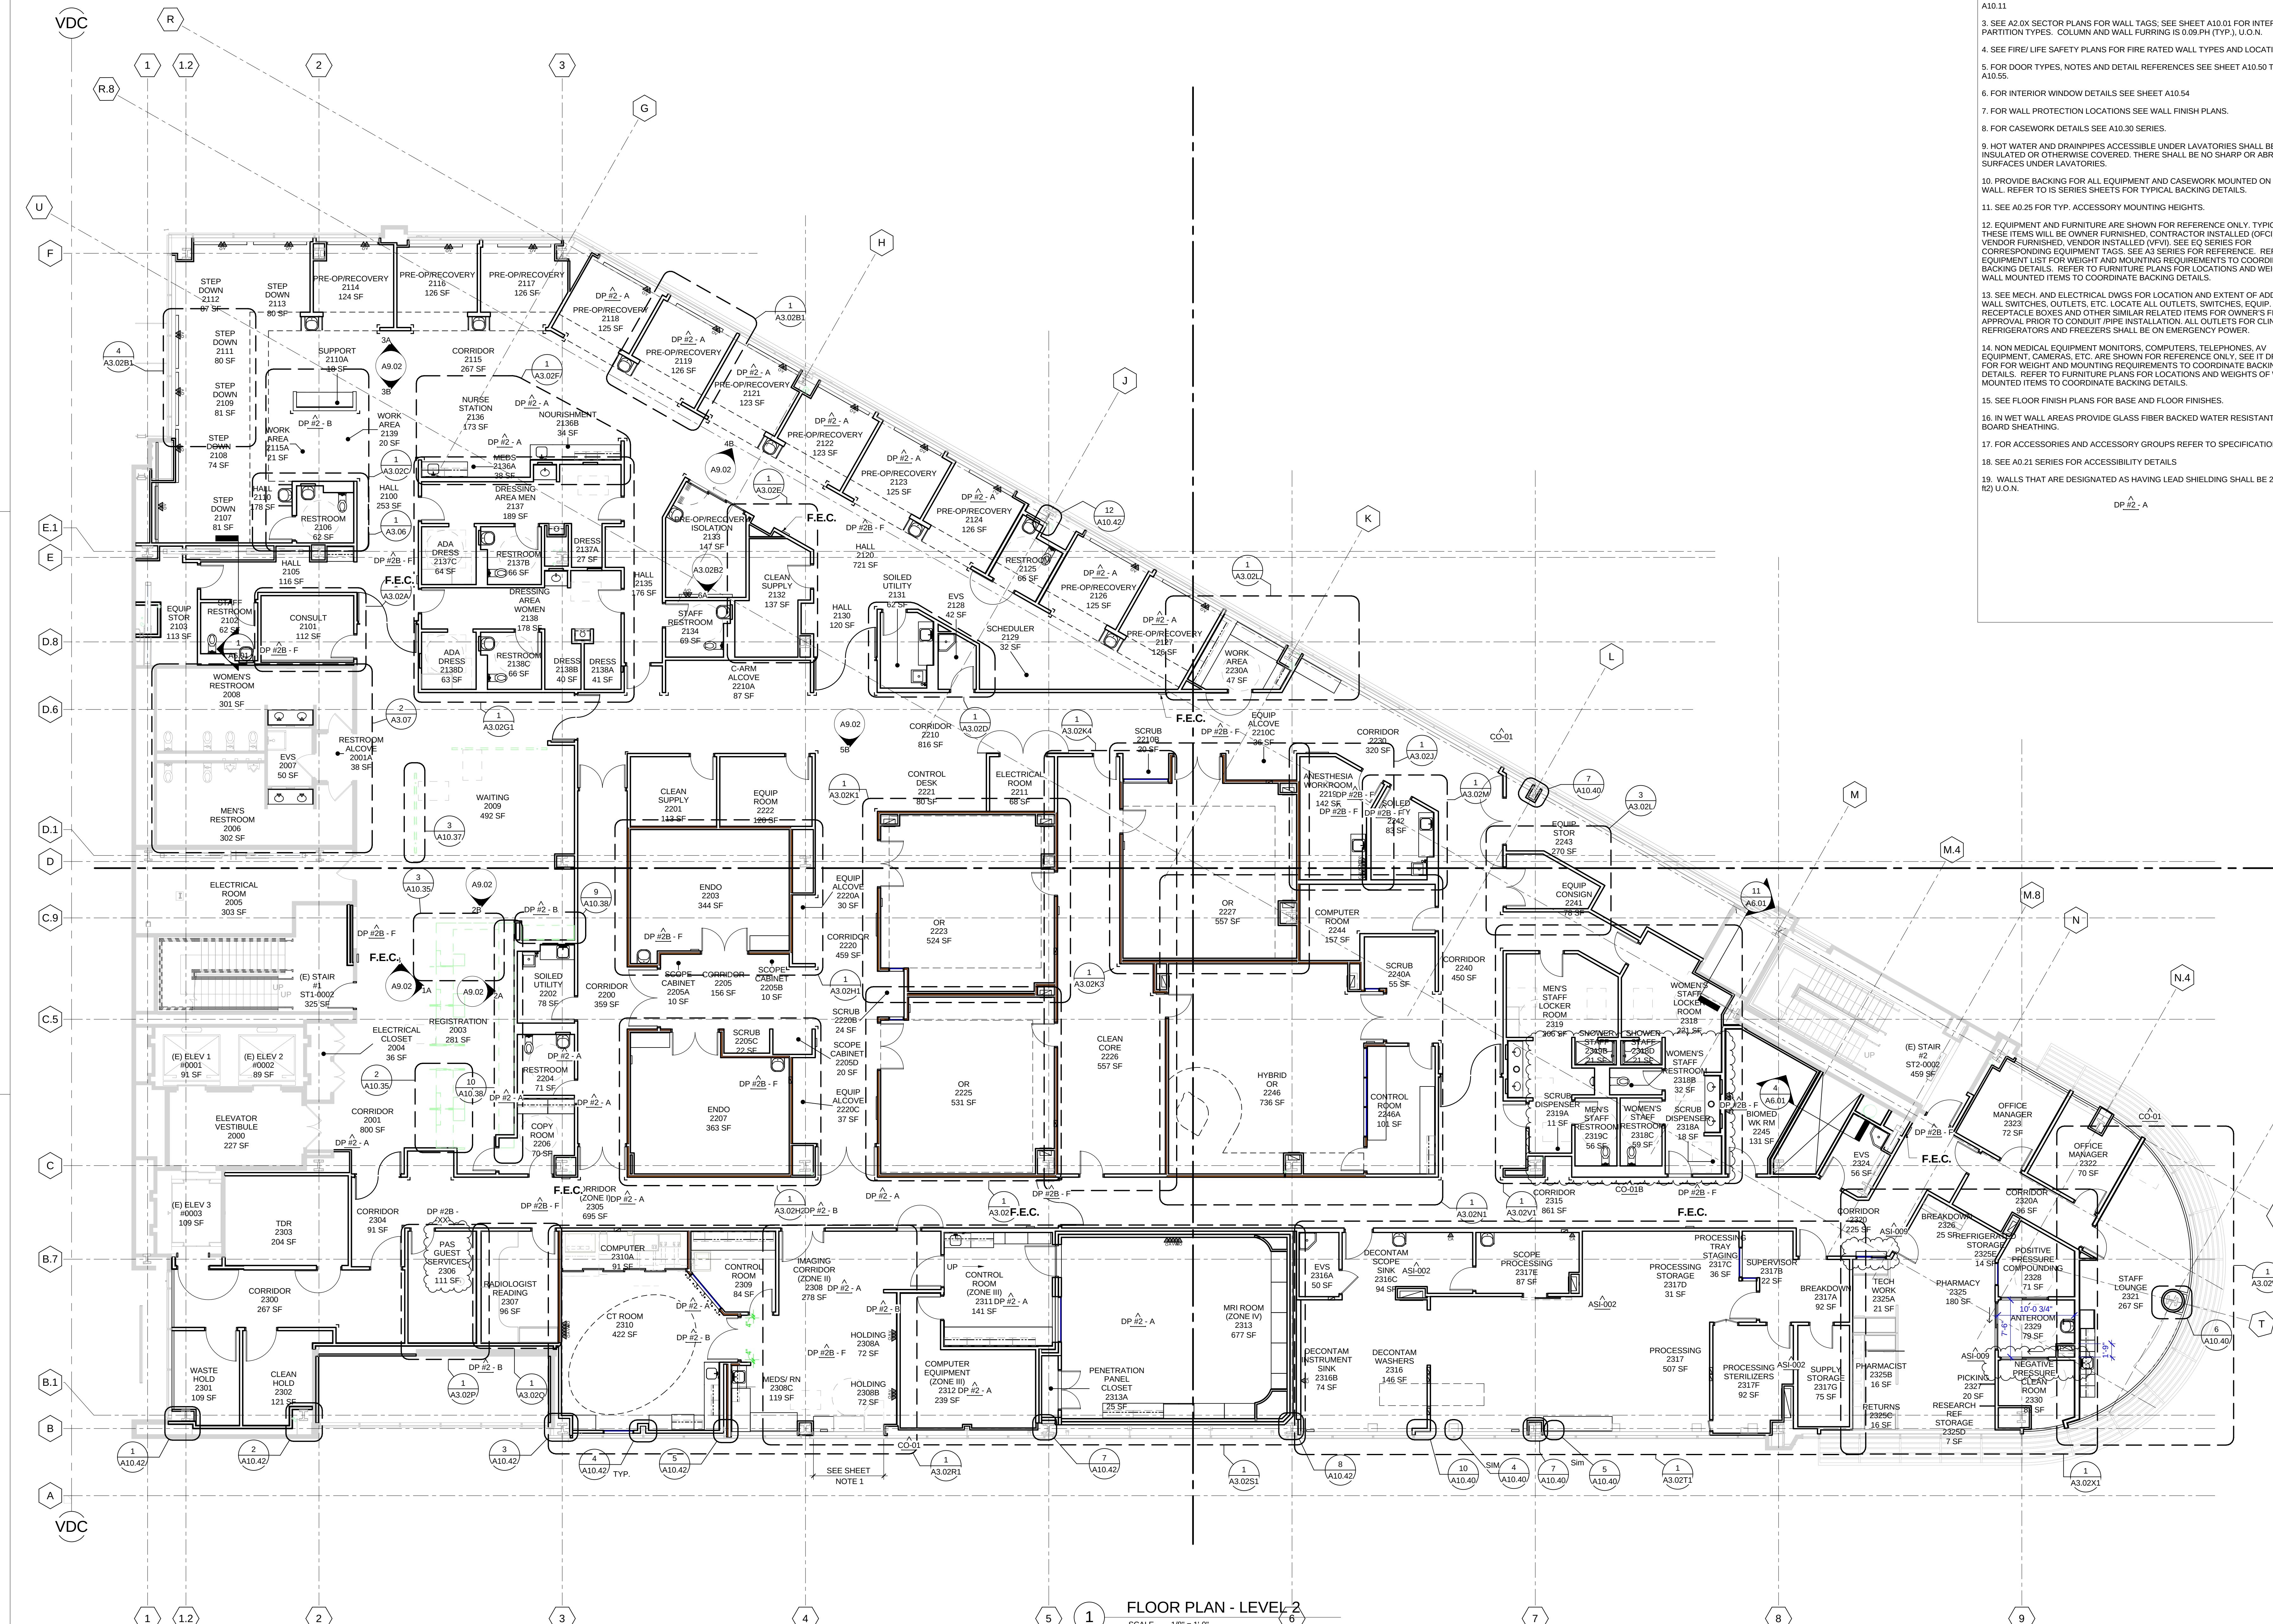

GENERAL NOTES

- DIMENSIONS ARE TO FACE OF FINISH OR CENTERLINE OF COLUMN, U.O.N. DIMENSION STRINGS ARE STARTED AT STRUCTURAL GRIDLINES.
- FOR TYPICAL WALL FRAMING CONDITIONS AND DETAILING SEE SHEETS A10.00 - A10.11.
- SEE A2.0X SECTOR PLANS FOR WALL TAGS; SEE SHEET A10.01 FOR INTERIOR PARTITION TYPES. COLUMN AND WALL FURRING IS 0.09 PH (TYP.), U.O.N.
- SEE FIRE/LIFE SAFETY PLANS FOR FIRE RATED WALL TYPES AND LOCATIONS.
- FOR DOOR TYPES, NOTES AND DETAIL REFERENCES SEE SHEET A10.50 TO A10.55.
- FOR INTERIOR WINDOW DETAILS SEE SHEET A10.54.
- FOR WALL PROTECTION LOCATIONS SEE WALL FINISH PLANS.
- FOR CASEWORK DETAILS SEE A10.30 SERIES.
- HOT WATER AND DRAINPIES ACCESSIBLE UNDER LAVATORIES SHALL BE INSULATED OR OTHERWISE COVERED. THERE SHALL BE NO SHARP OR ABRASIVE SURFACES UNDER LAVATORIES.
- PROVIDE BACKING FOR ALL EQUIPMENT AND CASEWORK MOUNTED ON THE WALL. REFER TO IS SERIES SHEETS FOR TYPICAL BACKING DETAILS.
- SEE A0.25 FOR TYP. ACCESSORY MOUNTING HEIGHTS.
- EQUIPMENT AND FURNITURE ARE SHOWN FOR REFERENCE ONLY. TYPICALLY THESE ITEMS WILL BE OWNER FURNISHED. CONTRACTOR INSTALLED (OFCI). VENDOR FURNISHED. VENDOR INSTALLED (VFI). SEE EQ SERIES FOR CORRESPONDING EQUIPMENT TAGS. SEE A3 SERIES FOR REFERENCE. REFER TO EQUIPMENT LIST FOR WEIGHT AND MOUNTING REQUIREMENTS TO COORDINATE BACKING DETAILS. REFER TO FURNITURE PLANS FOR LOCATIONS AND WEIGHTS OF WALL MOUNTED ITEMS TO COORDINATE BACKING DETAILS.
- SEE MECH. AND ELECTRICAL DWGS FOR LOCATION AND EXTENT OF ADDITIONAL WALL SWITCHES, OUTLETS, ETC. LOCATE ALL OUTLETS, SWITCHES, EQUIP. RECEPTACLE BOXES AND OTHER SIMILAR RELATED ITEMS FOR OWNER'S FINAL APPROVAL PRIOR TO CONDUIT PIPE INSTALLATION. ALL OUTLETS FOR CLINICAL REFRIGERATORS AND FREEZERS SHALL BE ON EMERGENCY POWER.
- NON MEDICAL EQUIPMENT MONITORS, COMPUTERS, TELEPHONES, AV EQUIPMENT, CAMERAS, ETC. ARE SHOWN FOR REFERENCE ONLY. SEE IT DRAWINGS FOR WEIGHT AND MOUNTING REQUIREMENTS TO COORDINATE BACKING DETAILS. REFER TO FURNITURE PLANS FOR LOCATIONS AND WEIGHTS OF WALL MOUNTED ITEMS TO COORDINATE BACKING DETAILS.
- SEE FLOOR FINISH PLANS FOR BASE AND FLOOR FINISHES.
- IN WET WALL AREAS PROVIDE GLASS FIBER BACKED WATER RESISTANT WALL BOARD SHEATHING.
- FOR ACCESSORIES AND ACCESSORY GROUPS REFER TO SPECIFICATIONS.
- SEE A0.21 SERIES FOR ACCESSIBILITY DETAILS.
- WALLS THAT ARE DESIGNATED AS HAVING LEAD SHIELDING SHALL BE 2# (2lbs/12) U.O.N.

SHEET NOTES

- PROVIDE BRACING OF LOW PARTITION AT PERIMETER CURTAIN WALL:
A. WHERE SPAN IS LESS THAN 10'-6", USE DETAILS 2B/ AND 2C/A10.11.
B. WHERE SPAN IS GREATER THAN 10'-6", PROVIDE DOUBLE STUD BRACES PER DETAILS 2B/ AND 6A10.11.


Stanford HEALTH CARE
STANFORD MEDICINE

HENSEL PHELPS
Plan. Build. Manage.

K	M	D
KMD	ARCHITECTS	PLANNING
222 W. HAY STREET, SUITE 200, SAN FRANCISCO, CA 94102 (415) 398-5131 FAX (415) 394-7158		


NO.	DATE	ISSUED FOR
1	2016/04/26	GENERAL COORDINATION
2	2016/04/26	RESPONSE TO VAC3 PLAN REVIEW
3	2016/04/26	PHARMACY PRESENTATIONS
4	2016/04/26	CHS SPO UPDATES
5	2016/04/26	RESPONSE TO PLAN REVIEW
6	2016/04/26	RESPONSE TO PLAN REVIEW
7	2016/04/26	DP #2 - A
8	2016/04/26	DP #2 - B
9	2016/04/26	DP #2 - 100% CD PACKAGE
10	2016/04/26	DP #2 - 50% CD PACKAGE
11	2016/04/26	DESIGN DEVELOPMENT
12	2016/04/26	BP #3 - ADDENDUM A
13	2016/04/26	ISSUED FOR

CERTIFIED BY
STANFORD HEALTH CENTER EMERYVILLE
5800 HOLLIS STREET
EMERYVILLE, CA 94608
PLAN CHECK#
PROJECT NO.
106-201
DATE
FLOOR PLAN - LEVEL 2

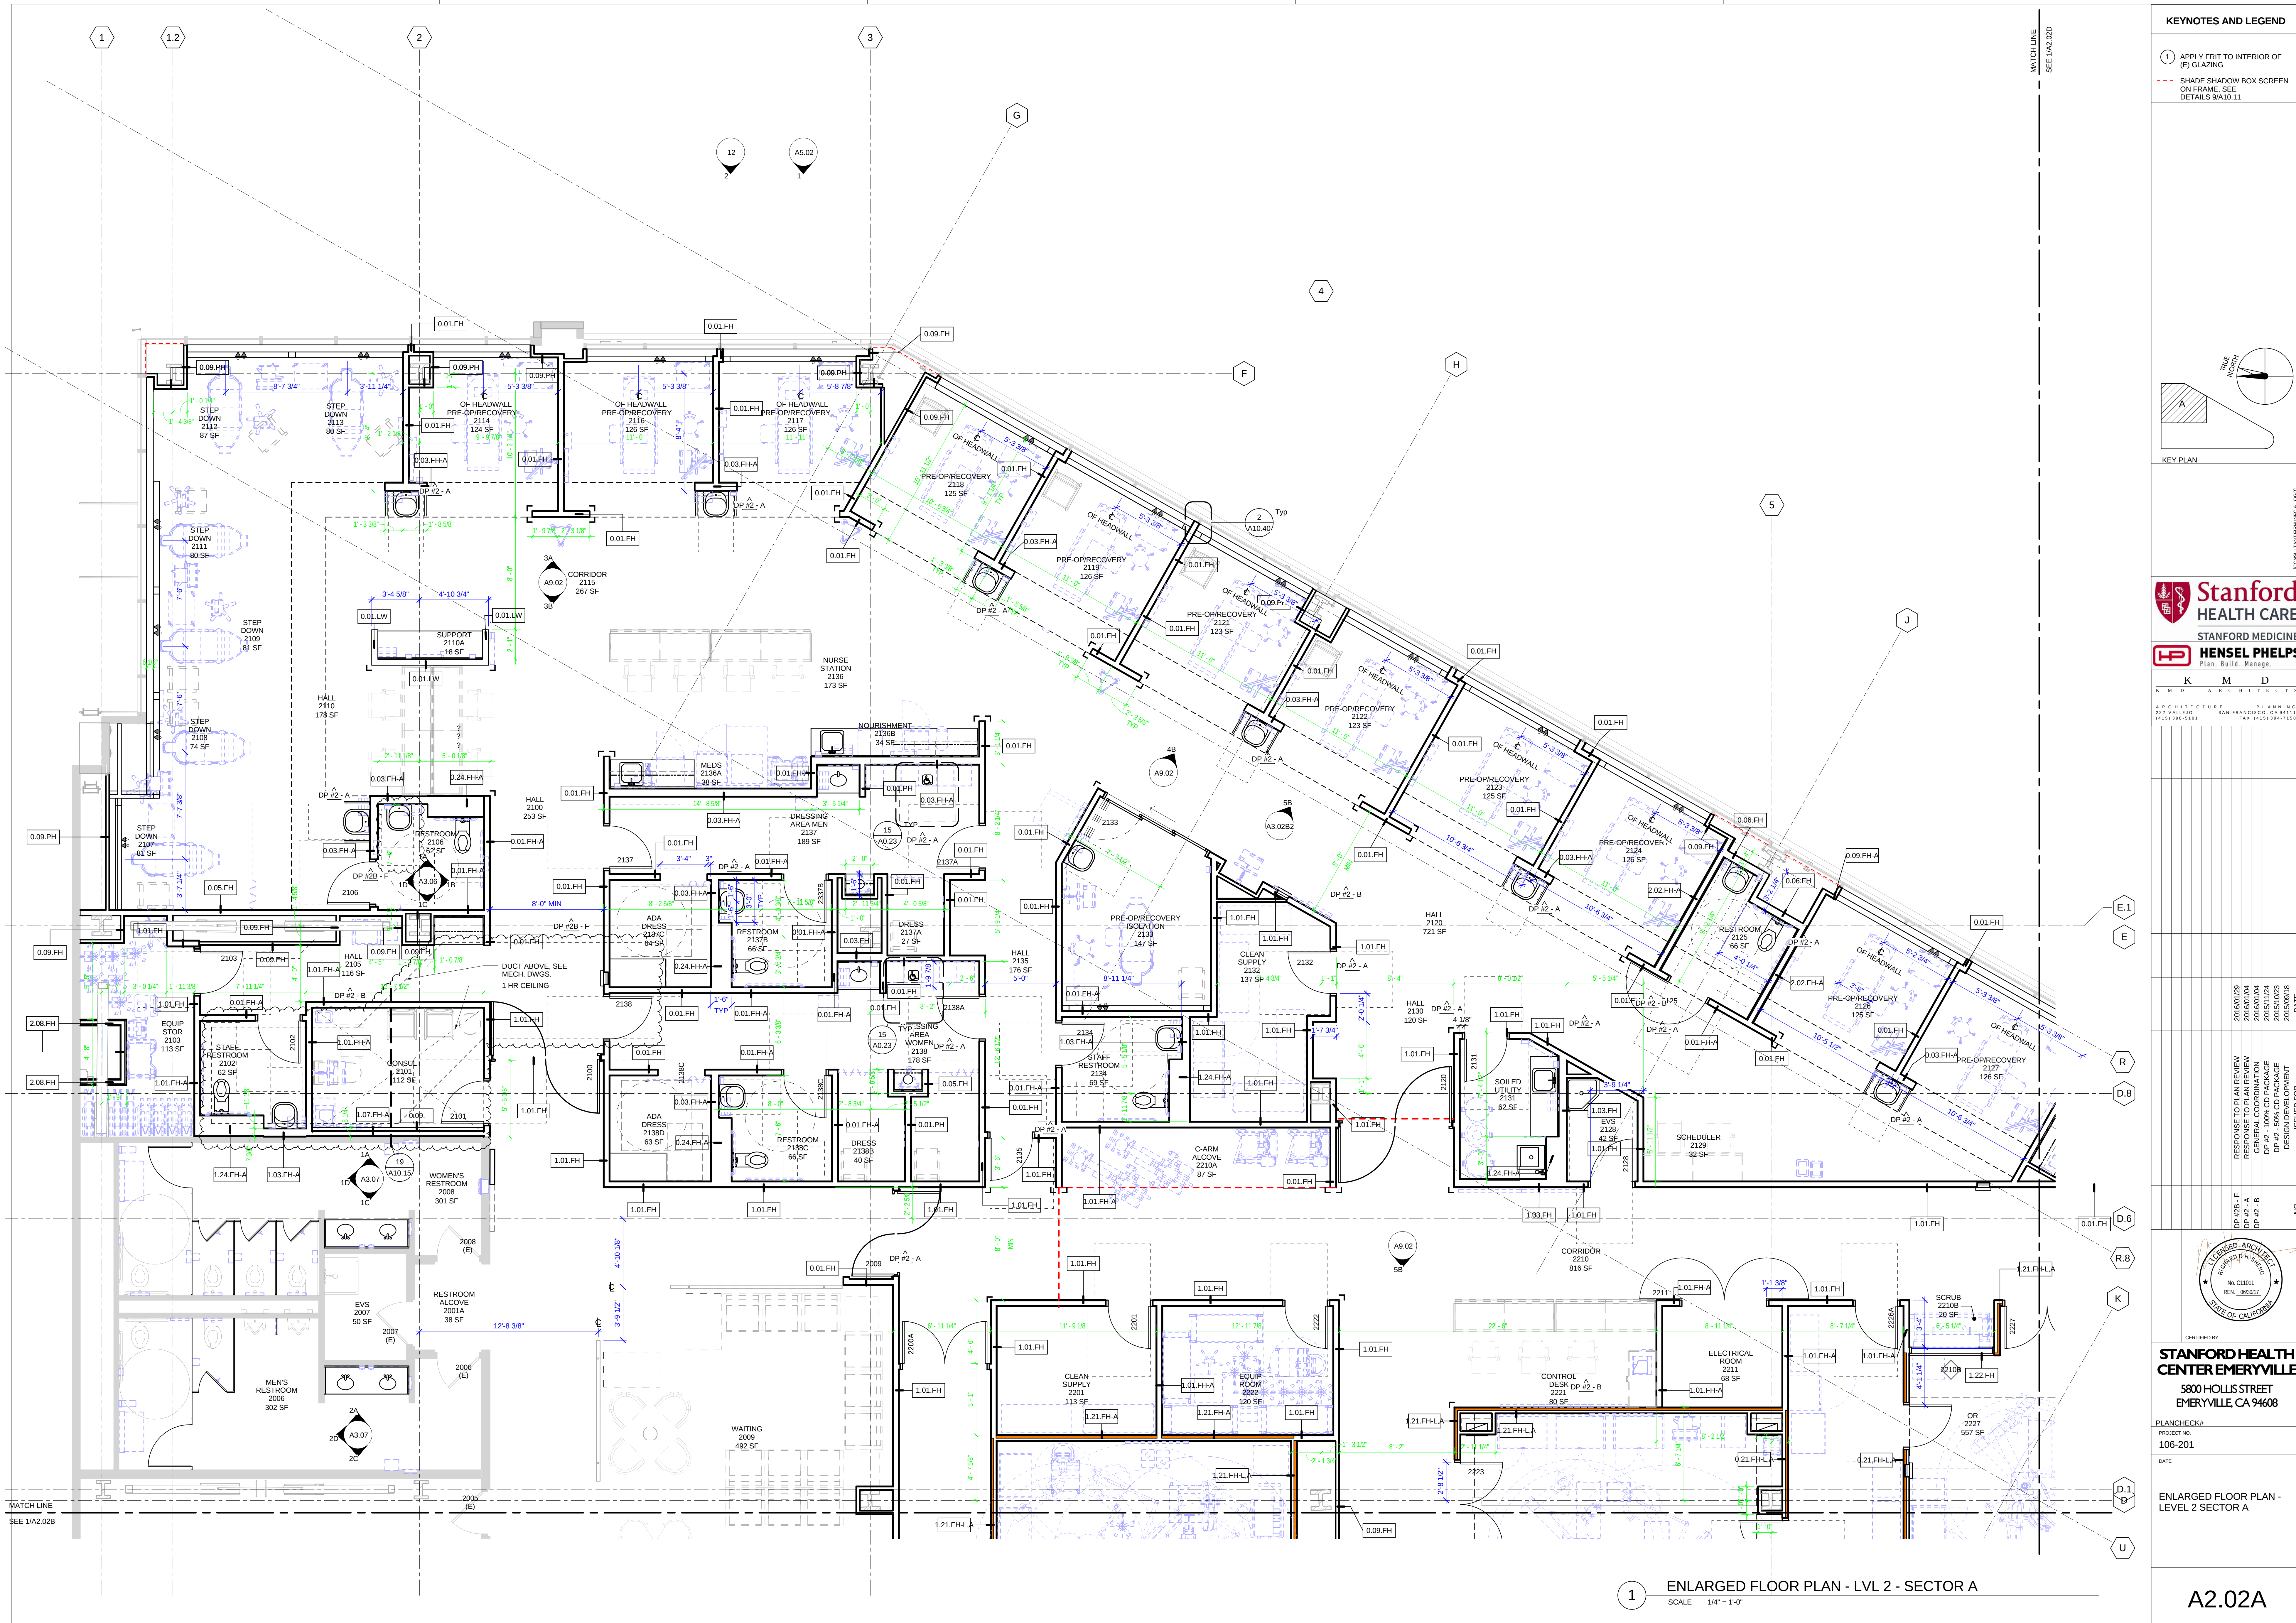

KEYNOTES AND LEGEND


- 1 APPLY FRIT TO INTERIOR OF (E) GLAZING
- SHADE SHADOW BOX SCREEN ON FRAME. SEE DETAILS 9/A10.11

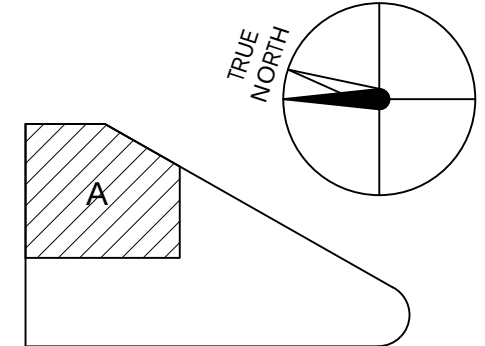

KEY PLAN

Stanford HEALTH CARE
STANFORD MEDICINE
HENSEL PHELPS
Plan. Build. Manage.
K M D ARCHITECTS
ARCHITECTURE PLANNING
222 WALLACE SAN FRANCISCO, CA 94104
(415) 398-9131 FAX (415) 394-7158

NO.	DATE	ISSUED FOR
2016/01/29	RESPONSE TO PLAN REVIEW	
2016/02/04	REVISIONS	
2016/01/04	GENERAL COORDINATION	
2015/11/24	DP #2 - 100% CD PACKAGE	
2015/10/23	DP #2 - 50% CD PACKAGE	
2015/09/18	DESIGN DEVELOPMENT	

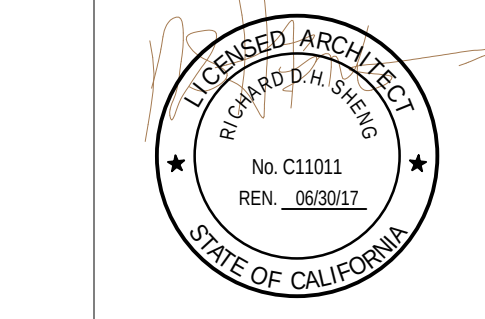


CERTIFIED BY
STANFORD HEALTH CENTER EMERYVILLE
5800 HOLLS STREET
EMERYVILLE, CA 94608

PLANCHECK#
PROJECT NO.
106-201
DATE

ENLARGED FLOOR PLAN - LEVEL 2 SECTOR A

A2.02A

1 ENLARGED FLOOR PLAN - LVL 2 - SECTOR A
SCALE 1/4" = 1'-0"

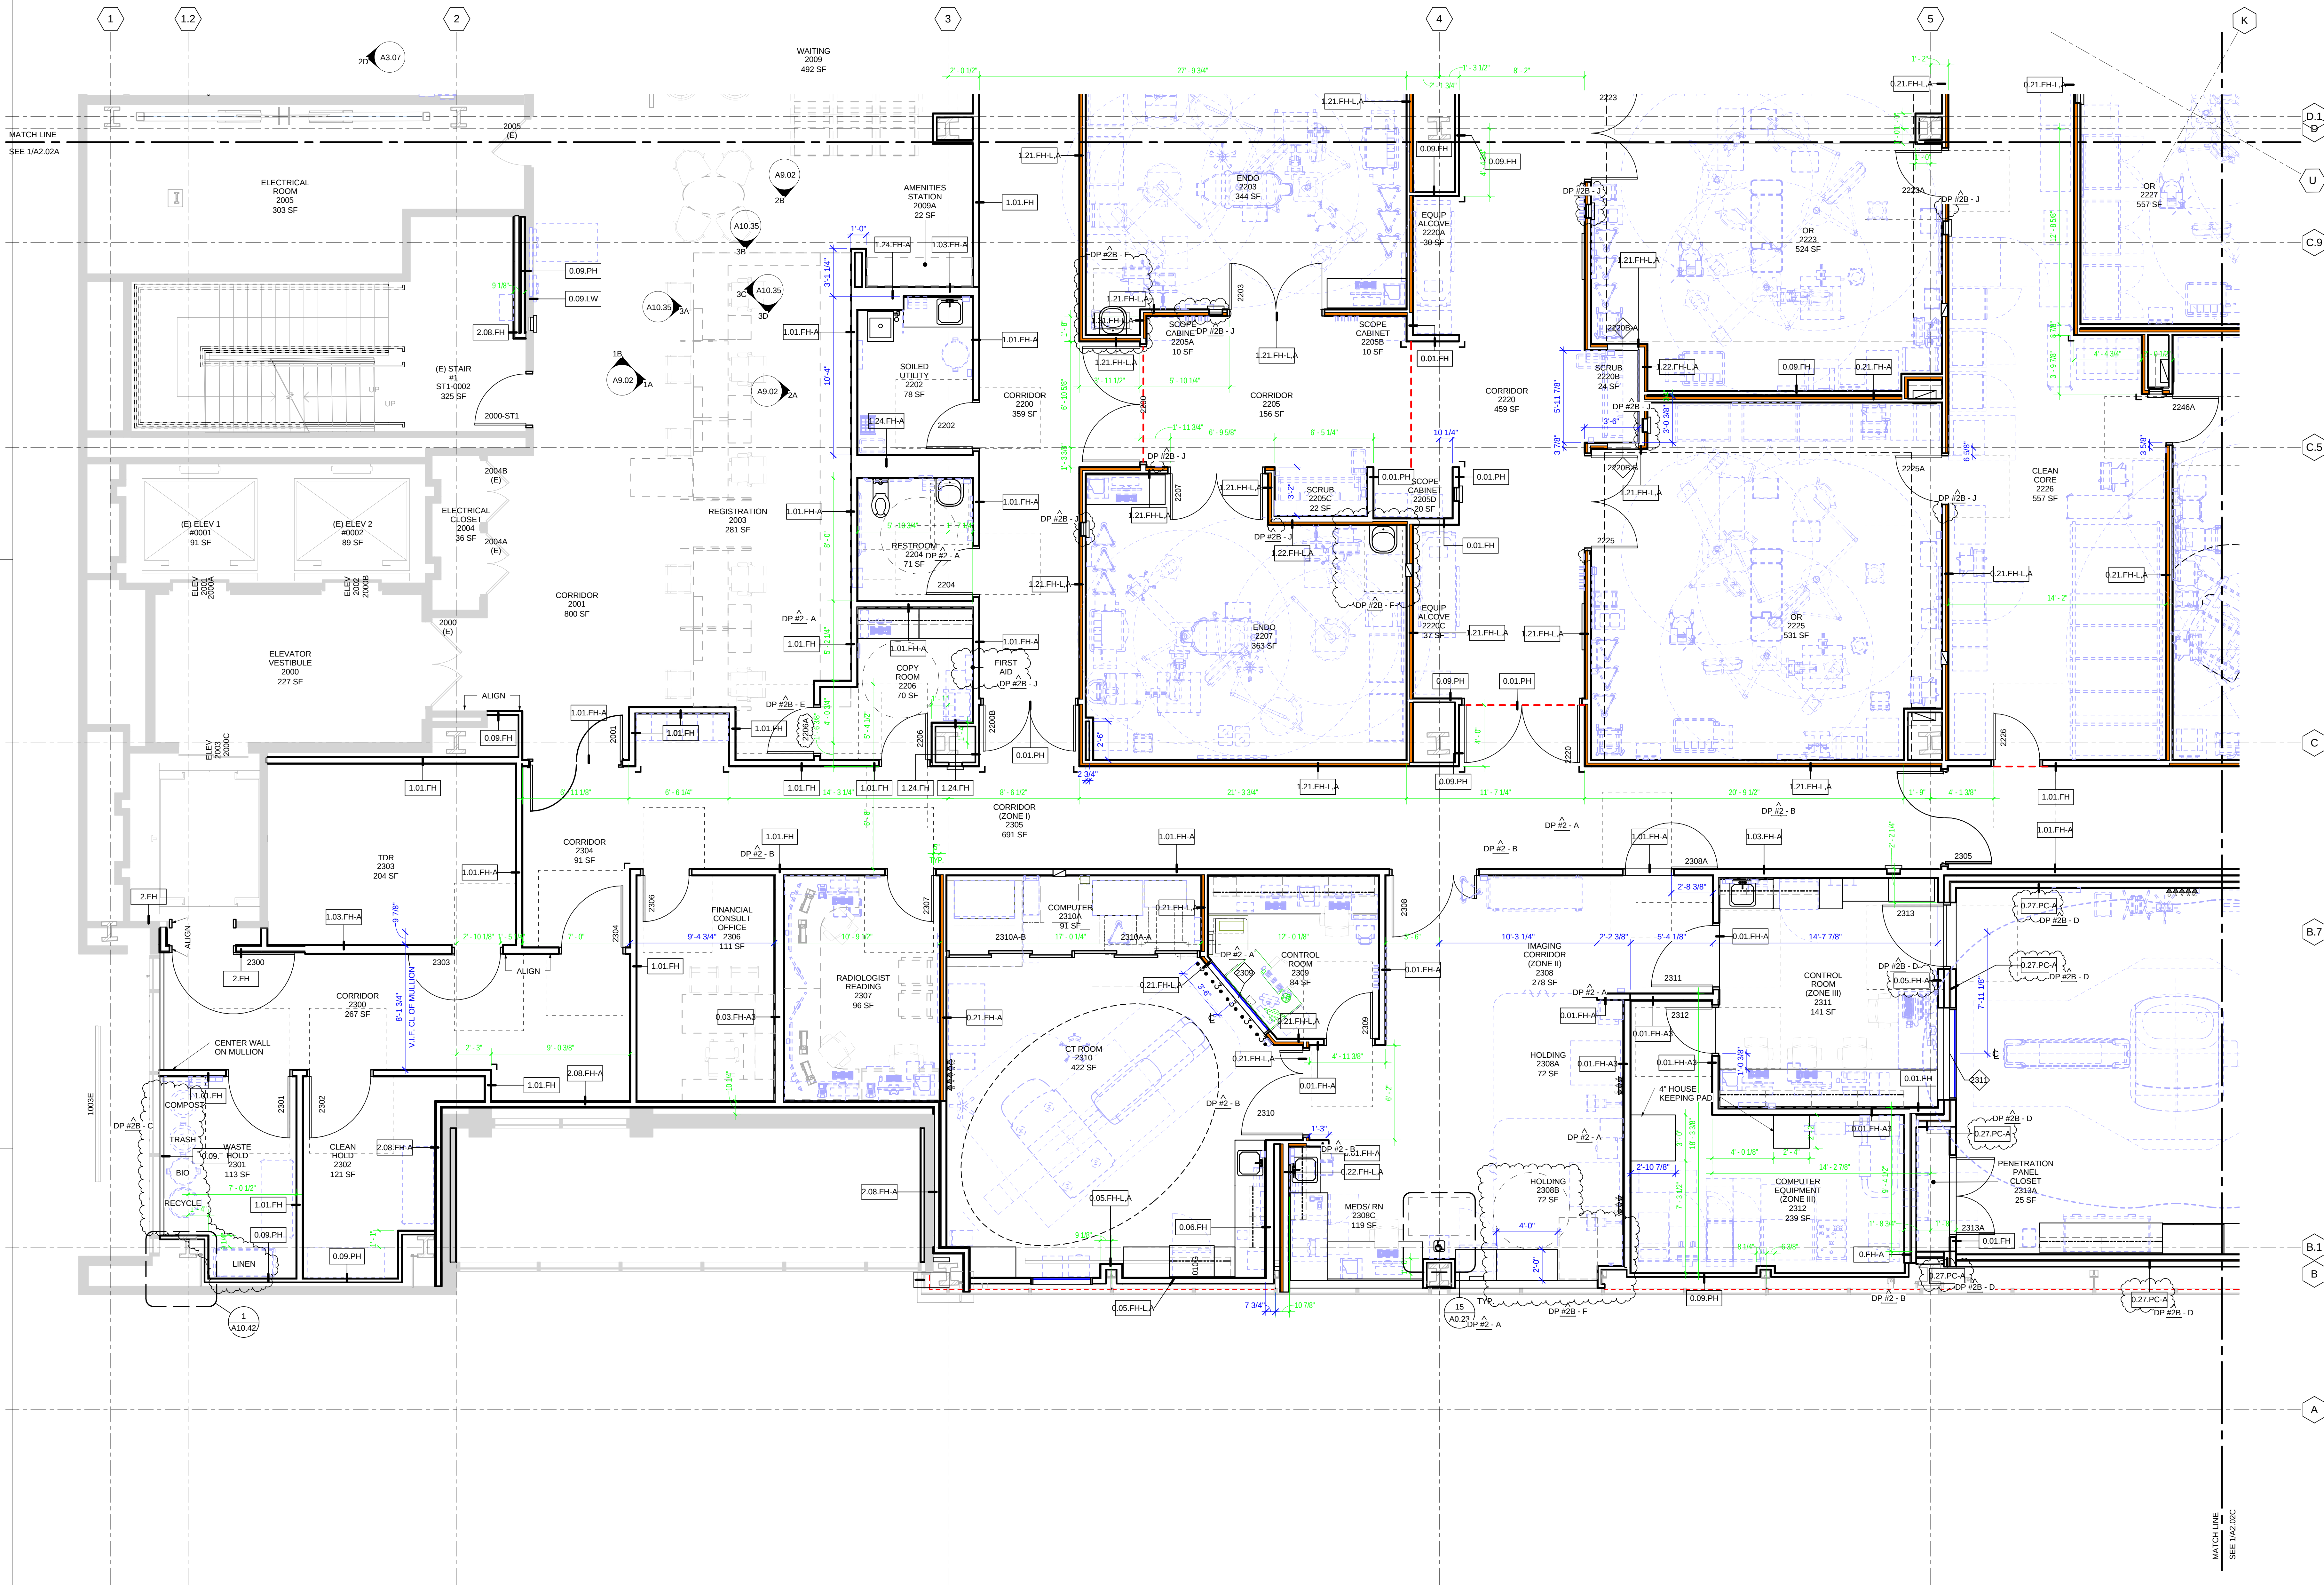

KEYNOTES AND LEGEND

- 1 APPLY FRIT TO INTERIOR OF (E) GLAZING
- SHADE SHADOW BOX SCREEN ON FRAME. SEE DETAILS 9/A10.11

KEY PLAN

THE NORTH

Stanford HEALTH CARE

STANFORD MEDICINE

HENSEL PHELPS

Plan. Build. Manage.

K M D ARCHITECTS

ARCHITECTURE PLANNING
122 WALL ST. SAN FRANCISCO, CA 94102
(415) 398-5131 FAX (415) 394-7158

NO.	DATE	ISSUED FOR
DP #28 - F	2016/07/29	RESPONSE TO PLAN REVIEW
DP #28 - E	2016/07/29	RESPONSE TO FIRE REVIEW
DP #28 - C	2016/07/29	WASTE MANAGEMENT
DP #28 - J	2016/07/29	GENERAL COORDINATION
DP #28 - A	2016/07/29	RESPONSE TO PLAN REVIEW
DP #28 - B	2016/07/29	RESPONSE TO PLAN REVIEW
DP #28 - D	2016/07/29	DP #28 - 100% CD PACKAGE
DP #28 - A	2016/07/29	DP #28 - 50% CD PACKAGE
DP #28 - A	2016/07/29	DESIGN DEVELOPMENT
DP #28 - A	2016/07/29	BP #3 - ADDENDUM A

100% ARCHITECT

NO. 11011

REN. 000011

STATE OF CALIFORNIA

CERTIFIED BY

STANFORD HEALTH CENTER EMERYVILLE

5800 HOLLIS STREET
EMERYVILLE, CA 94608

PLANCHECK#

PROJECT NO.

106-201

DATE


ENLARGED FLOOR PLAN - LEVEL 2 SECTOR B

A2.02B




KEYNOTES AND LEGEND

- 1 APPLY FRIT TO INTERIOR OF (E) GLAZING
- SHADE SHADOW BOX SCREEN ON FRAME. SEE DETAILS 9/A10.11

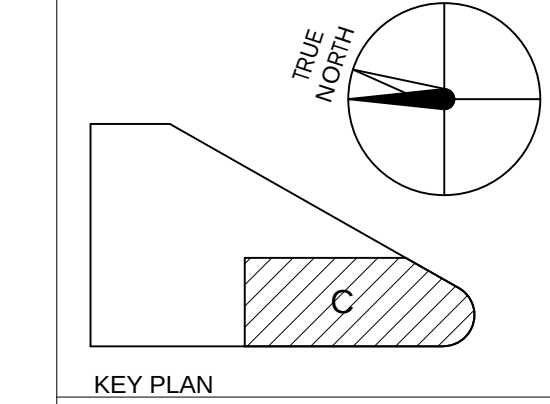

Stanford HEALTH CARE
STANFORD MEDICINE
HENSEL PHELPS
Plan. Build. Manage.
K M D ARCHITECTS
ARCHITECTURE PLANNING
222 WALLACE DRIVE SAN FRANCISCO, CA 94115
(415) 398-5131 FAX (415) 394-7158

NO.	DATE	ISSUED FOR
2016/04/26	2016/04/26	RESPONSE TO WC3 PLAN REVIEW
2016/04/26	2016/04/26	PHARMACY REFINEMENTS
2016/04/26	2016/04/26	CHANGE ORDER #01
2016/04/26	2016/04/26	SCHEMATIC DEVELOPMENT
2016/07/29	2016/07/29	RESPONSE TO PLAN REVIEW
2016/07/29	2016/07/29	MR. COORDINATION
2016/07/29	2016/07/29	GENERAL COORDINATION
2016/07/29	2016/07/29	GENERAL COORDINATION
2016/11/24	2016/11/24	DP #2 - 100% CD PACKAGE
2016/10/23	2016/10/23	DESIGN DEVELOPMENT
2016/09/28	2016/09/28	ISSUED FOR

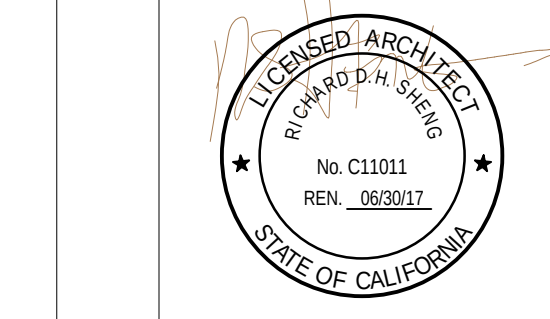

CERTIFIED BY
STANFORD HEALTH CENTER EMERYVILLE
5800 HOLLIS STREET
EMERYVILLE, CA 94608

PLAN CHECK#
PROJECT NO.
106-201
DATE


ENLARGED FLOOR PLAN -
LEVEL 2 SECTOR C

A2.02C

1 ENLARGED FLOOR PLAN - LVL 2 - SECTOR C
SCALE 1/4" = 1'-0"

KEYNOTES AND LEGEND

- ① APPLY FRIT TO INTERIOR OF (E) GLAZING
- SHADE SHADOW BOX SCREEN ON FRAME. SEE DETAILS 9/A10.11

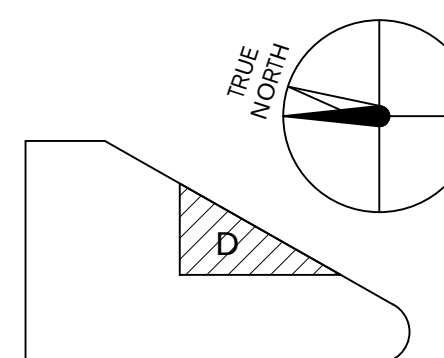

KEY PLAN


STANFORD MEDICINE
HENSEL PHELPS
Plan. Build. Manage.

K M D ARCHITECTS

ARCHITECTURE PLANNING
222 WILLOW SAN FRANCISCO, CA 94111
(415) 398-5151 FAX (415) 394-7158


1 ENLARGED FLOOR PLAN - LVL 2 - SECTOR D

SCALE 1/4" = 1'-0"

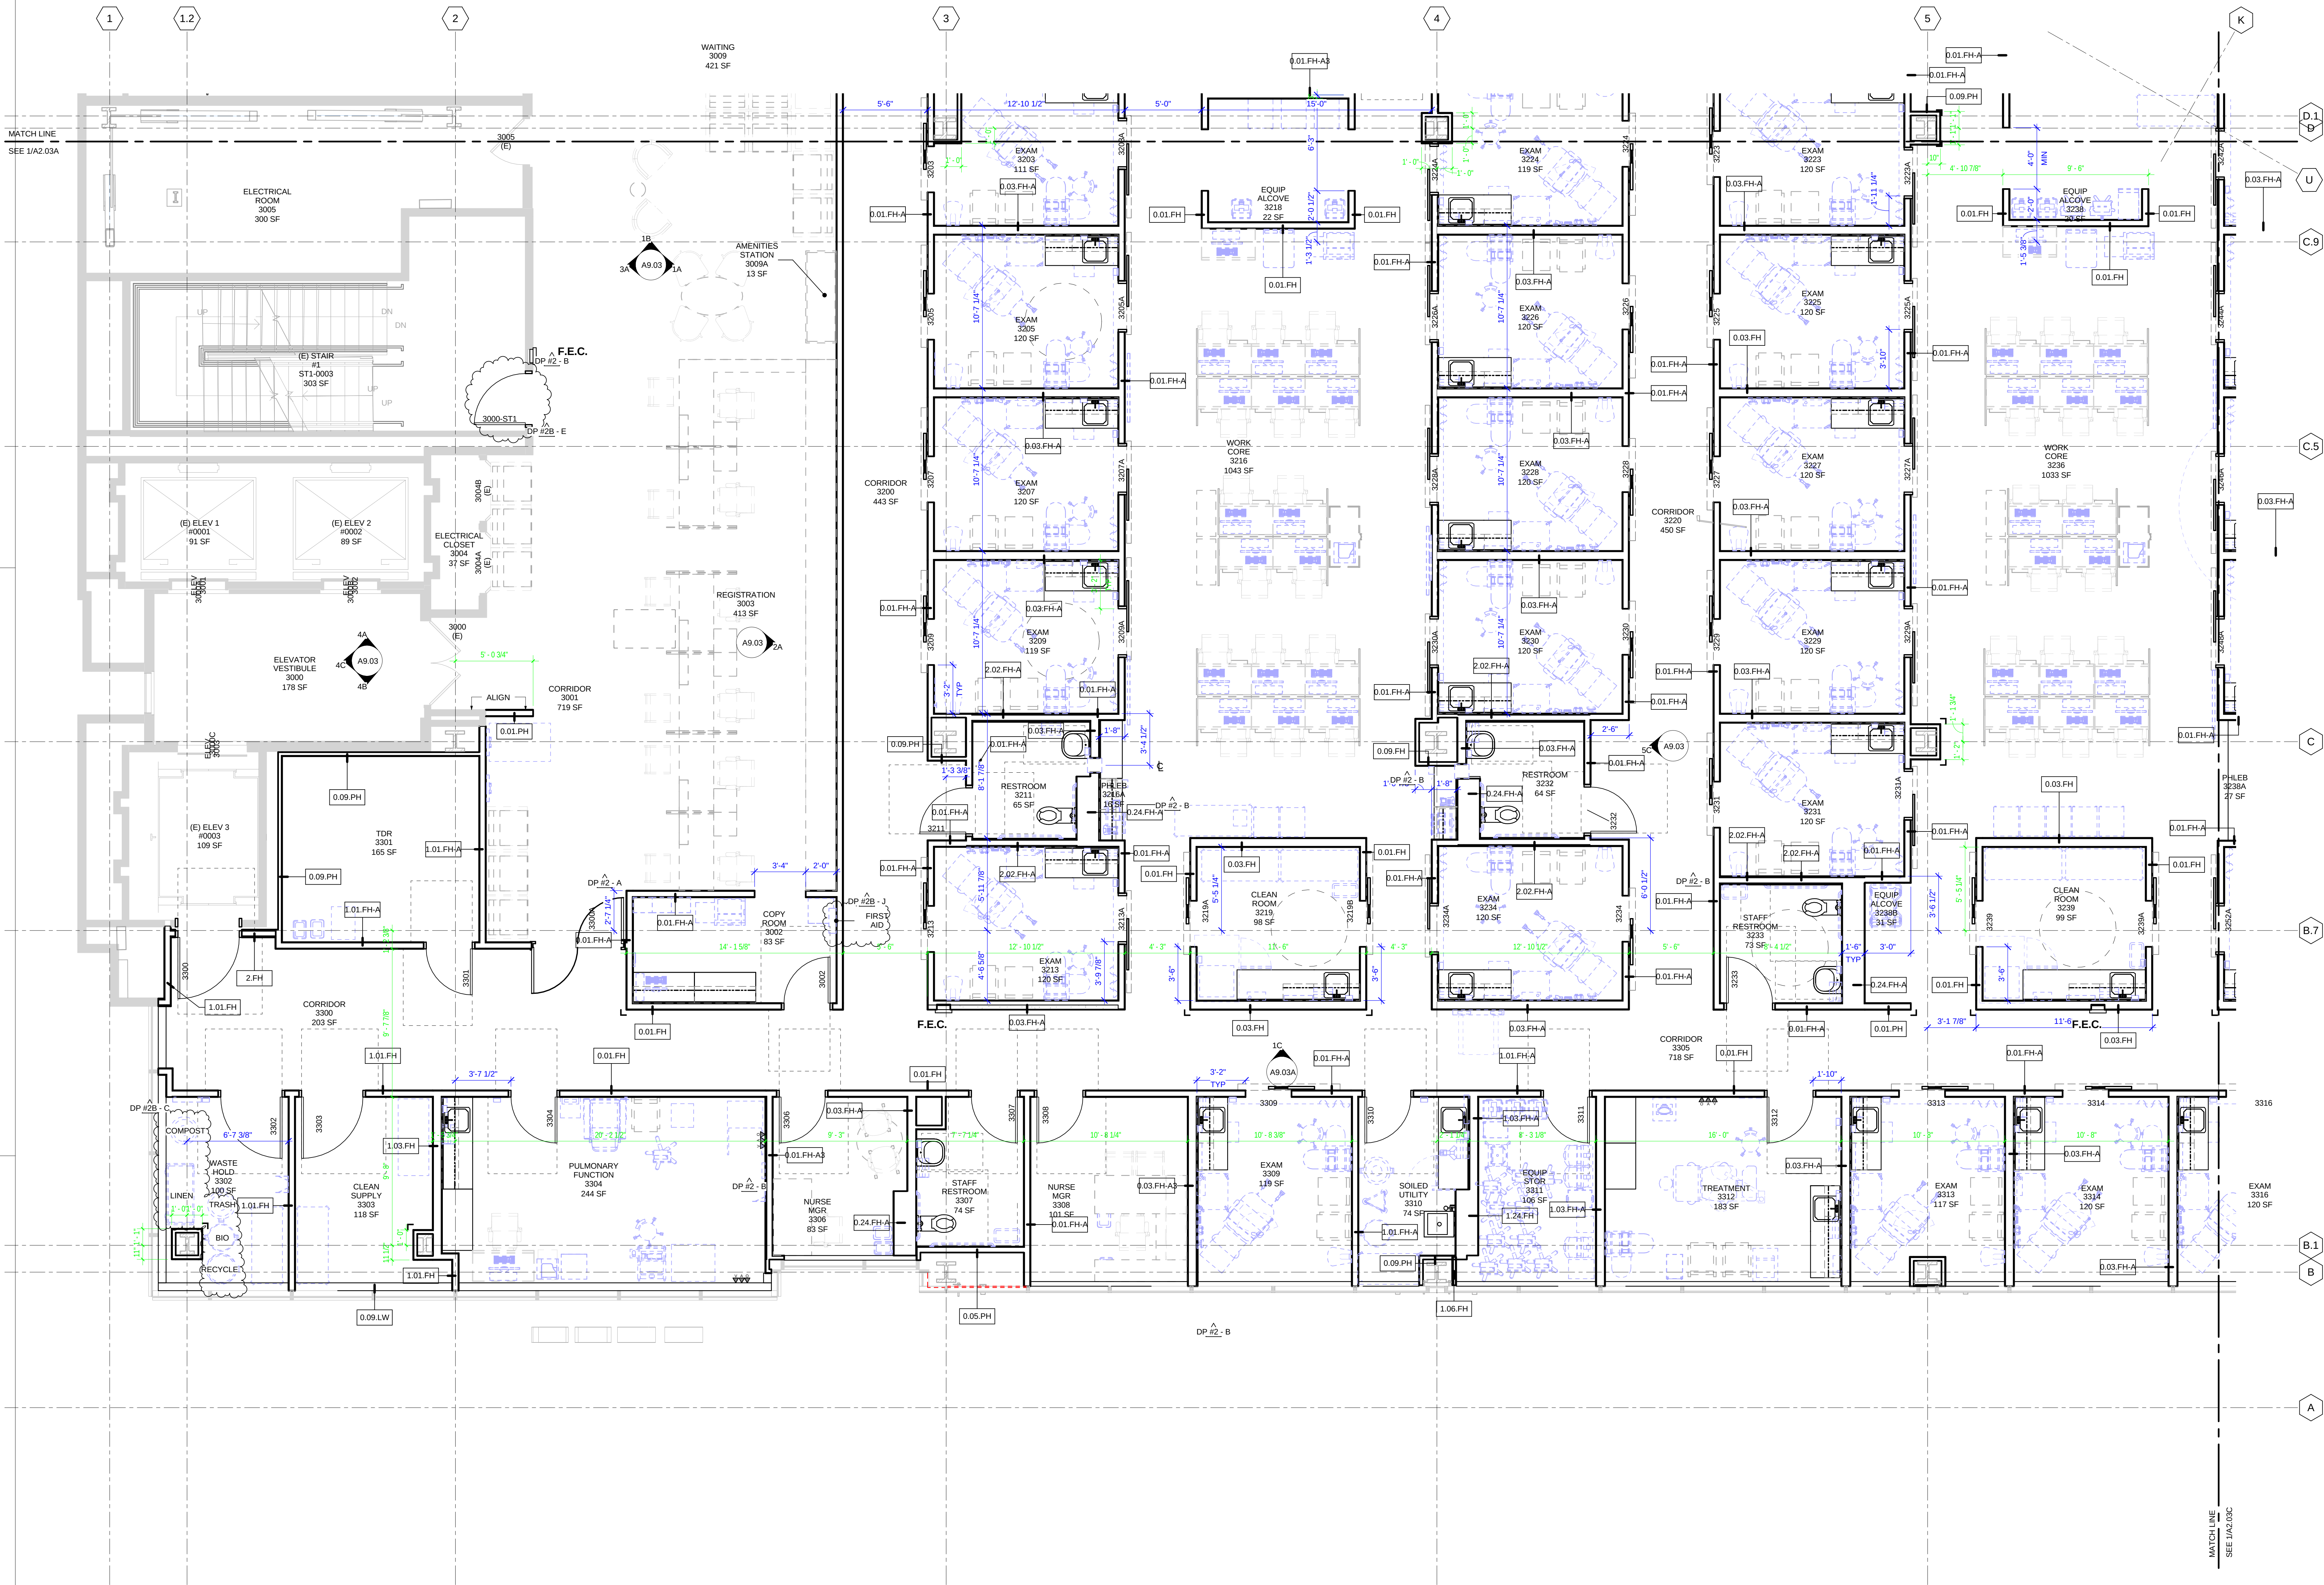


KEYNOTES AND LEGEND

- 1 APPLY FRIT TO INTERIOR OF (E) GLAZING
- SHADE SHADOW BOX SCREEN ON FRAME. SEE DETAILS 9/A10.11

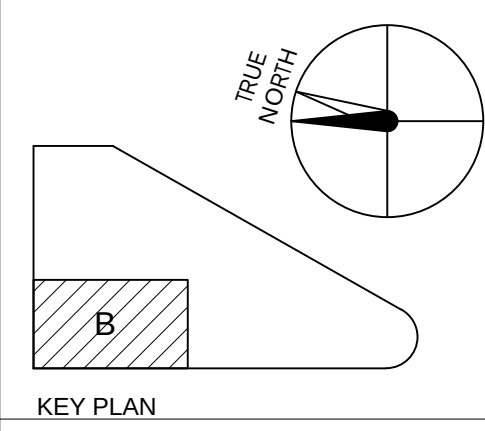

Stanford HEALTH CARE
STANFORD MEDICINE
HENSEL PHELPS
Plan. Build. Manage.
K M D ARCHITECTS
ARCHITECTURE PLANNING
122 WALL STREET SAN FRANCISCO, CA 94102
(415) 398-9131 FAX (415) 394-7158

NO.	DATE	ISSUED FOR
1	2016/01/29	RESPONSE TO RFP REVIEW
2	2016/01/29	WASTE MANAGEMENT
3	2016/01/29	GENERAL COORDINATION
4	2016/01/29	LEVELS 3 & 4 FRAMING - MEP
5	2016/01/29	MEP COORDINATION
6	2016/01/29	GENERAL COORDINATION
7	2016/01/29	MEP COORDINATION
8	2016/01/29	MEP COORDINATION
9	2016/01/29	MEP COORDINATION
10	2016/01/29	MEP COORDINATION

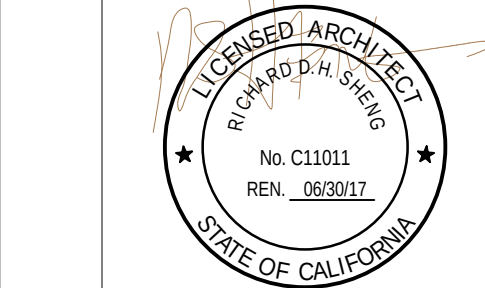

CERTIFIED BY
STANFORD HEALTH CENTER EMERYVILLE
5800 HOLLIS STREET
EMERYVILLE, CA 94608


PLAN CHECK#
PROJECT NO.
106-201
DATE

ENLARGED FLOOR PLAN - LEVEL 3 SECTOR B



KEYNOTES AND LEGEND


- 1 APPLY FRIT TO INTERIOR OF (E) GLAZING
- SHADE SHADOW BOX SCREEN ON FRAME, SEE DETAILS 9/A10.11

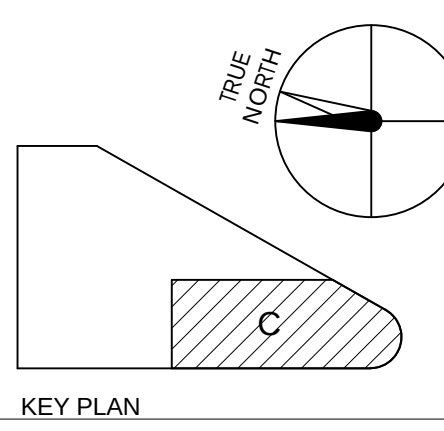

KEY PLAN

Stanford HEALTH CARE
STANFORD MEDICINE
HENSEL PHELPS
Plan. Build. Manage.
K M D ARCHITECTS
ARCHITECTURE PLANNING
222 WALL ST. SAN FRANCISCO, CA 94102
(415) 398-5131 FAX (415) 394-7158

NO.	DATE	ISSUED FOR
1	2016/01/29	RESPONSE TO FIRE REVIEW
2	2016/01/29	GENERAL COORDINATION
3	2016/01/29	LEVELS 3 & 4 FRAMING - MEP
4	2016/01/29	LEVELS 3 & 4 FRAMING - CIVIL
5	2016/01/29	GENERAL COORDINATION
6	2016/01/29	GENERAL COORDINATION
7	2016/01/29	GENERAL COORDINATION
100	2016/01/29	GENERAL COORDINATION

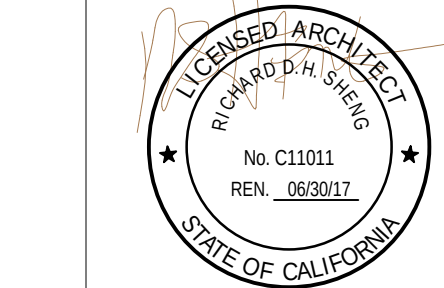


CERTIFIED BY
STANFORD HEALTH CENTER EMERYVILLE
5800 HOLLIS STREET
EMERYVILLE, CA 94608

PLAN CHECK#
PROJECT NO.
106-201
DATE

ENLARGED FLOOR PLAN - LEVEL 3 SECTOR C

- 1 APPLY FRIT TO INTERIOR OF (E) GLAZING
- SHADE SHADOW BOX SCREE ON FRAME, SEE DETAILS 9/A10.11

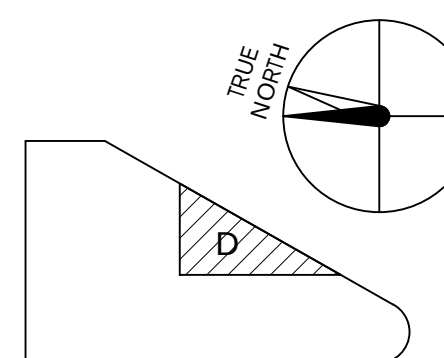

KEY PLAN




STANFORD MEDICAL CENTER



K			M			D		
K	M	D	A	R	C	H	I	T
			E			C		

ARCHITECTURE PLANNING
222 VALLEJO SAN FRANCISCO, CA 94133
(415) 398-5191 FAX (415) 394-5191

BP #2A - G	LEVELS 3 & 4 FRAMING - MEP	2016/01/26
BP #2A - A	RESERVE FOR REVIEW	2016/01/24
BP #2A - B	RESERVE FOR REVIEW	2016/01/24
BP #2B - G	LEVELS 5 & 6 FRAMING - MEP	2015/11/24
BP #2B - A	RESERVE FOR REVIEW	2015/11/24
BP #2B - B	RESERVE FOR REVIEW	2015/10/23

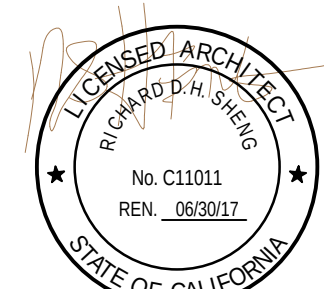

CERTIFIED BY

STANFORD HEALTH CARE

5800 HOLLIS STREET
EMERYVILLE, CA 94608


PLANCHECK#

PROJECT NO.
106 201

DATE _____

ENLARGED FLOOR PLAN -
LEVEL 3 SECTOR D

A2.03D

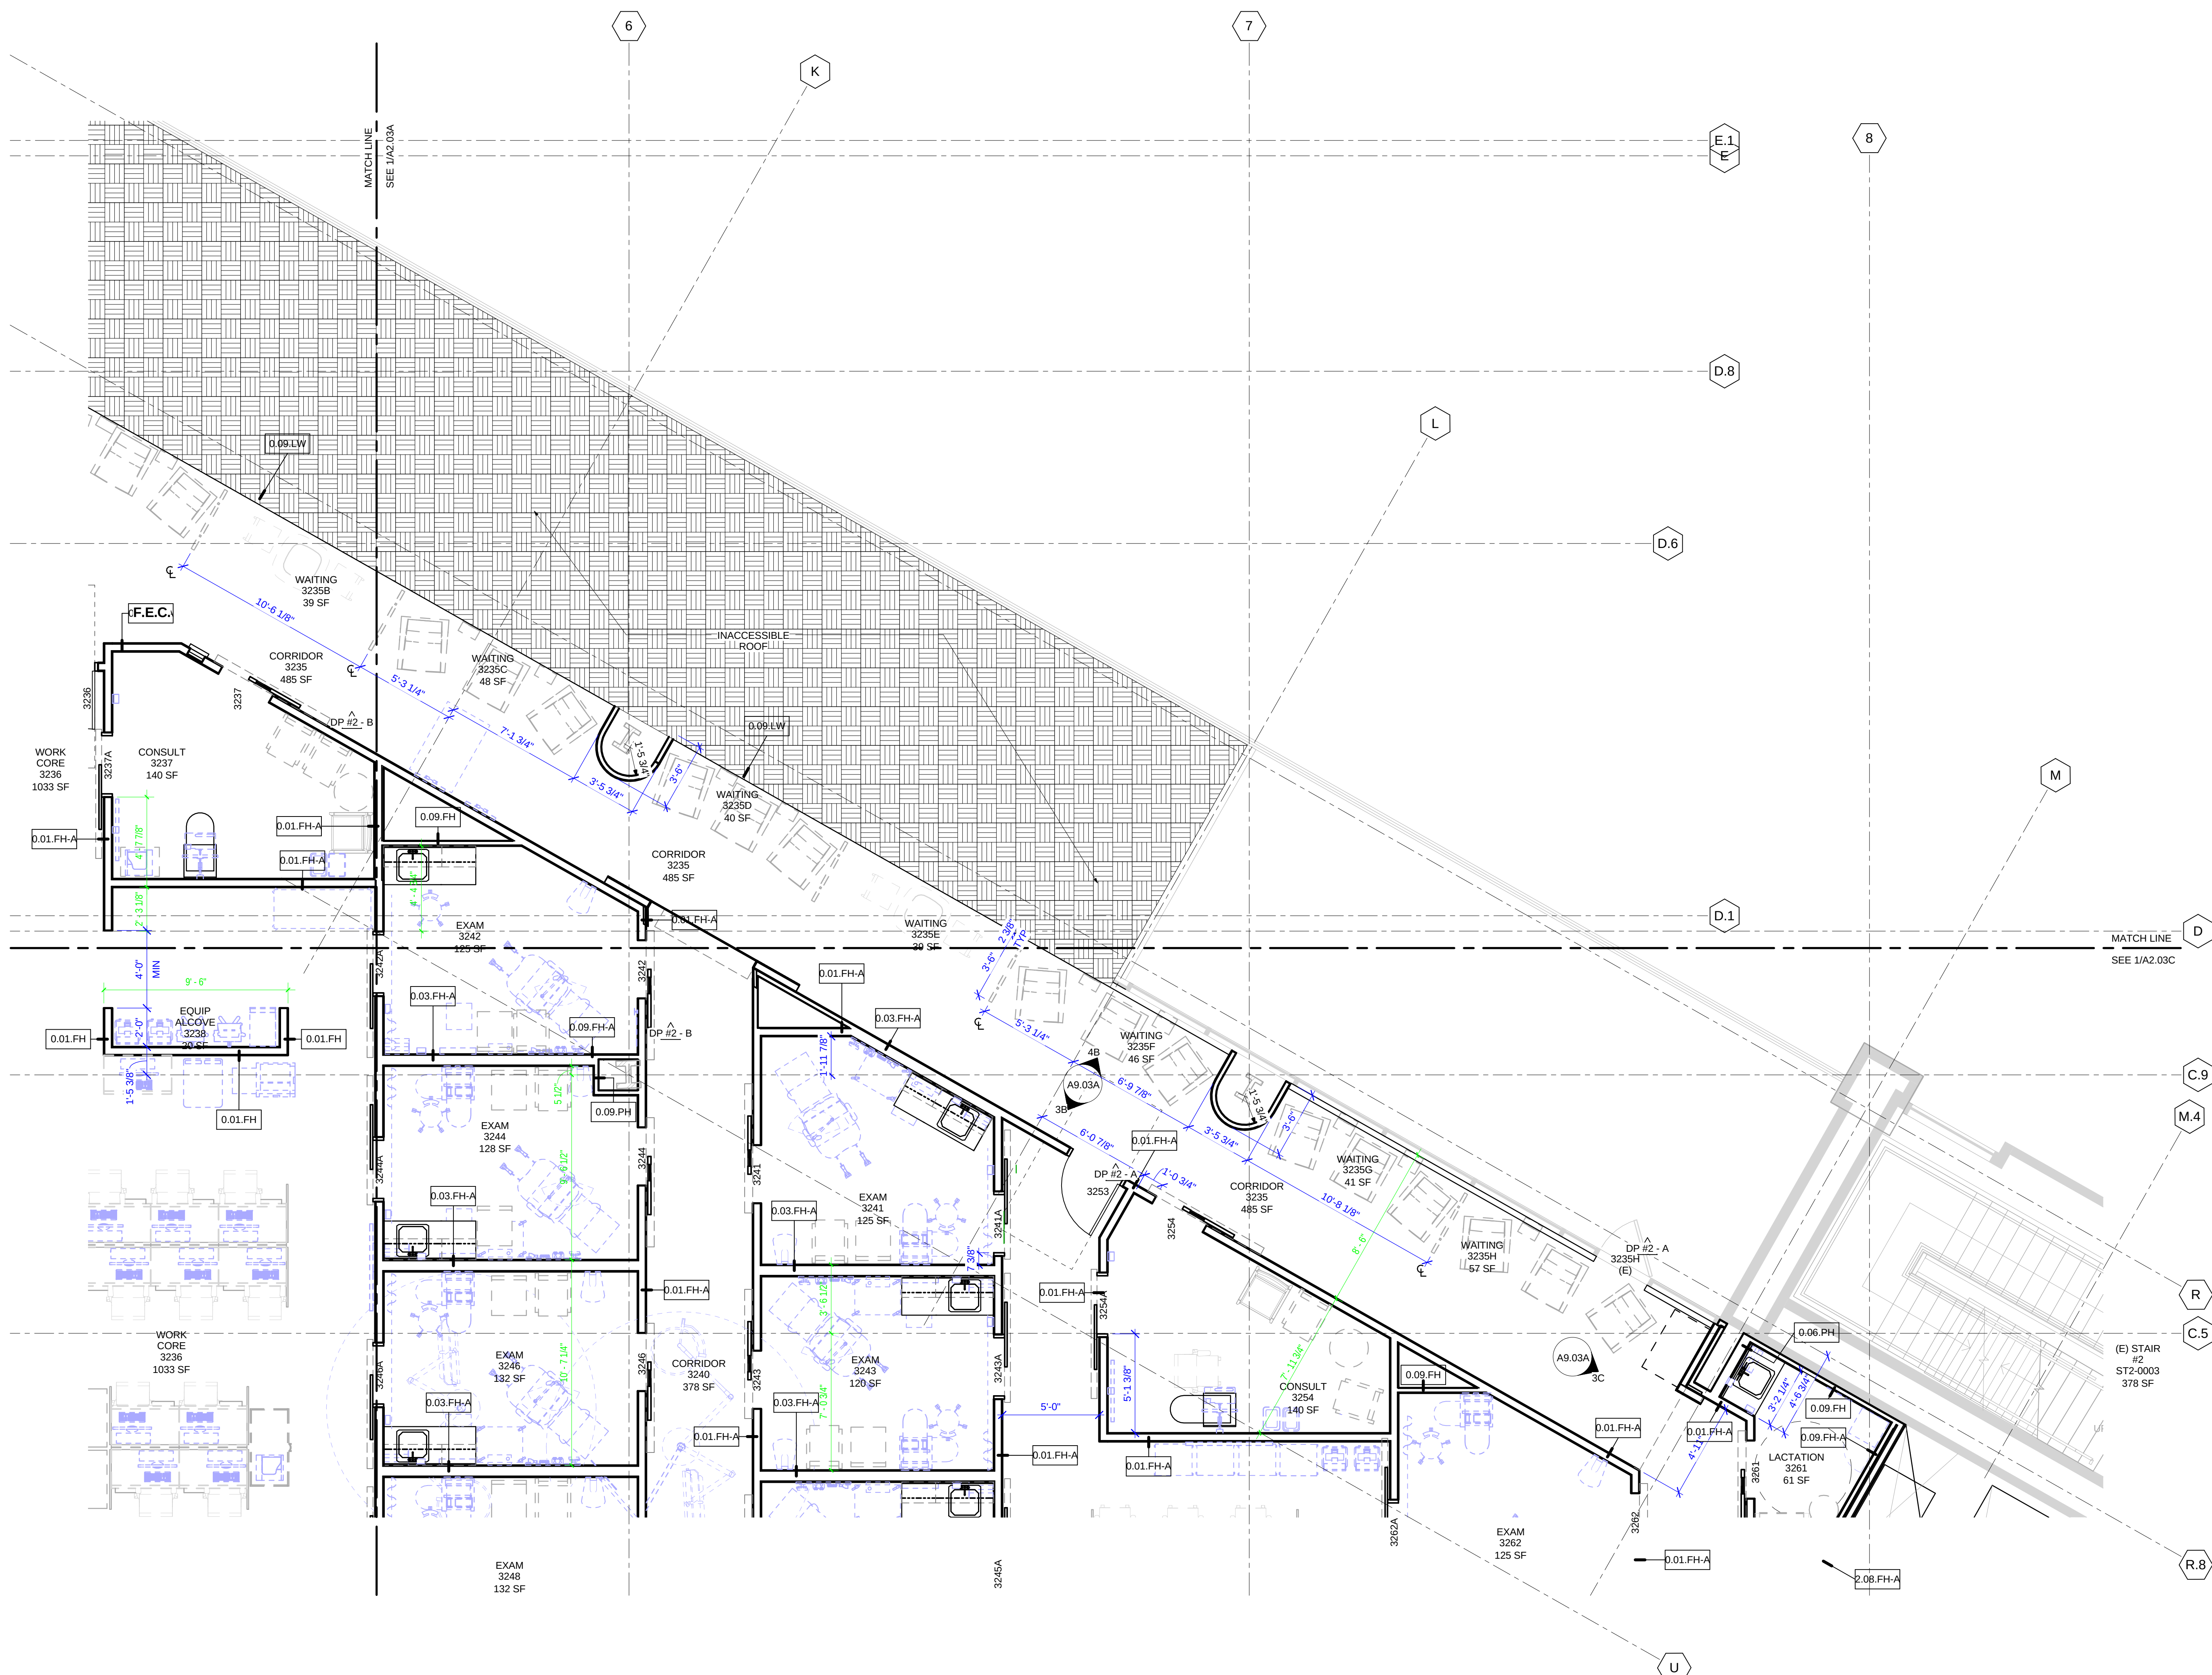




FLOOR PLAN - LEVEL 4
SCALE 1/8" = 1'-0"

GENERAL NOTES

- DIMENSIONS ARE TO FACE OF FINISH OR CENTERLINE OF COLUMN, U.O.N. DIMENSION STRINGS ARE STARTED AT STRUCTURAL GRIDLINES.
- FOR TYPICAL WALL FRAMING CONDITIONS AND DETAILING SEE SHEETS A10.00 - A10.11
- SEE A2.0X SECTOR PLANS FOR WALL TAGS; SEE SHEET A10.01 FOR INTERIOR PARTITION TYPES. COLUMN AND WALL FURRING IS 0.09 PH (TYP.), U.O.N.
- SEE FIRE/LIFE SAFETY PLANS FOR FIRE RATED WALL TYPES AND LOCATIONS.
- FOR DOOR TYPES, NOTES AND DETAIL REFERENCES SEE SHEET A10.50 TO A10.55.
- FOR INTERIOR WINDOW DETAILS SEE SHEET A10.54
- FOR WALL PROTECTION LOCATIONS SEE WALL FINISH PLANS.
- FOR CASEWORK DETAILS SEE A10.30 SERIES.
- HOT WATER AND DRAINPIPS ACCESSIBLE UNDER LAVATORIES SHALL BE INSULATED OR OTHERWISE COVERED. THERE SHALL BE NO SHARP OR ABRASIVE SURFACES UNDER LAVATORIES.
- PROVIDE BACKING FOR ALL EQUIPMENT AND CASEWORK MOUNTED ON THE WALL. REFER TO IS SERIES SHEETS FOR TYPICAL BACKING DETAILS.
- SEE A0.25 FOR TYP. ACCESSORY MOUNTING HEIGHTS.
- EQUIPMENT AND FURNITURE ARE SHOWN FOR REFERENCE ONLY. TYPICALLY THESE ITEMS WILL BE OWNER FURNISHED, CONTRACTOR INSTALLED (OFCI). VENDOR FURNISHED, VENDOR INSTALLED (VFI). SEE EQ SERIES FOR CORRESPONDING EQUIPMENT TAGS. SEE A3 SERIES FOR REFERENCE. REFER TO EQUIPMENT LIST FOR WEIGHT AND MOUNTING REQUIREMENTS TO COORDINATE BACKING DETAILS. REFER TO FURNITURE PLANS FOR LOCATIONS AND WEIGHTS OF WALL MOUNTED ITEMS TO COORDINATE BACKING DETAILS.
- SEE MECH. AND ELECTRICAL DWGS FOR LOCATION AND EXTENT OF ADDITIONAL WALL SWITCHES, OUTLETS, ETC. LOCATE ALL OUTLETS, SWITCHES, EQUIP. RECEPTACLE BOXES AND OTHER SIMILAR RELATED ITEMS FOR OWNER'S FINAL APPROVAL PRIOR TO CONDUIT/PIPE INSTALLATION. ALL OUTLETS FOR CLINICAL REFRIGERATORS AND FREEZERS SHALL BE ON EMERGENCY POWER.
- NON MEDICAL EQUIPMENT MONITORS, COMPUTERS, TELEPHONES, AV EQUIPMENT, CAMERAS, ETC. ARE SHOWN FOR REFERENCE ONLY. SEE IT DRAWINGS FOR WEIGHT AND MOUNTING REQUIREMENTS TO COORDINATE BACKING DETAILS. REFER TO FURNITURE PLANS FOR LOCATIONS AND WEIGHTS OF WALL MOUNTED ITEMS TO COORDINATE BACKING DETAILS.
- SEE FLOOR FINISH PLANS FOR BASE AND FLOOR FINISHES.
- IN WET WALL AREAS PROVIDE GLASS FIBER BACKED WATER RESISTANT WALL BOARD SHEATHING.
- FOR ACCESSORIES AND ACCESSORY GROUPS REFER TO SPECIFICATIONS.
- SEE A0.21 SERIES FOR ACCESSIBILITY DETAILS
- WALLS THAT ARE DESIGNATED AS HAVING LEAD SHIELDING SHALL BE 2# (2lbs/ft²) U.O.N.

SHEET NOTES


- PROVIDE BRACING OF LOW PARTITION AT PERIMETER CURTAIN WALL.
- WHERE SPAN IS LESS THAN 10'-6" USE DETAILS 2B AND 2C/A10.11.
- WHERE SPAN IS GREATER THAN 10'-6" PROVIDE DOUBLE STUD BRACES PER DETAILS 2B AND 6/A10.11.

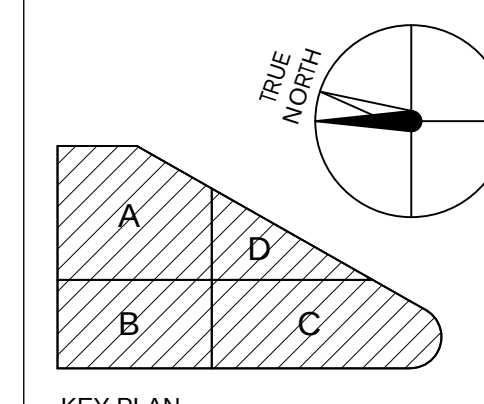

KEY PLAN

Stanford HEALTH CARE
STANFORD MEDICINE
HENSEL PHELPS
Plan. Build. Manage.
K M D ARCHITECTS
ARCHITECTURE PLANNING
222 PULVER STREET, SUITE 1111 SAN FRANCISCO, CA 94102
(415) 398-5151 FAX (415) 394-7158


NO.	DATE	ISSUED FOR
1	2016/01/29	RESPONSE TO PLAN REVIEW
2	2016/01/29	GENERAL COORDINATION
3	2016/01/29	LEVELS 3 & 4 FRAMING - MEP
4	2016/01/29	LEVELS 3 & 4 FRAMING - CIVIL
5	2016/01/29	GENERAL COORDINATION
6	2016/01/29	GENERAL COORDINATION
7	2016/01/29	DP #2 - 100% CD PACKAGE
8	2016/01/29	DP #2 - 50% CD PACKAGE
9	2016/01/29	DESIGN DEVELOPMENT

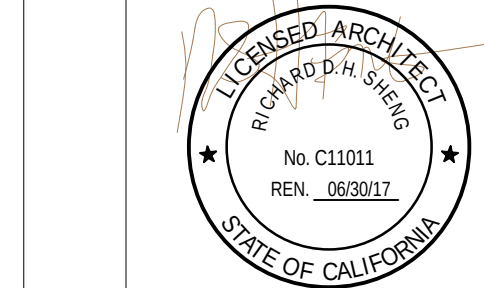

CERTIFIED BY
STANFORD HEALTH CENTER EMERYVILLE
5800 HOLLY STREET
EMERYVILLE, CA 94608

PLAN CHECK#
PROJECT NO.
106-201
DATE

FLOOR PLAN - LEVEL 4

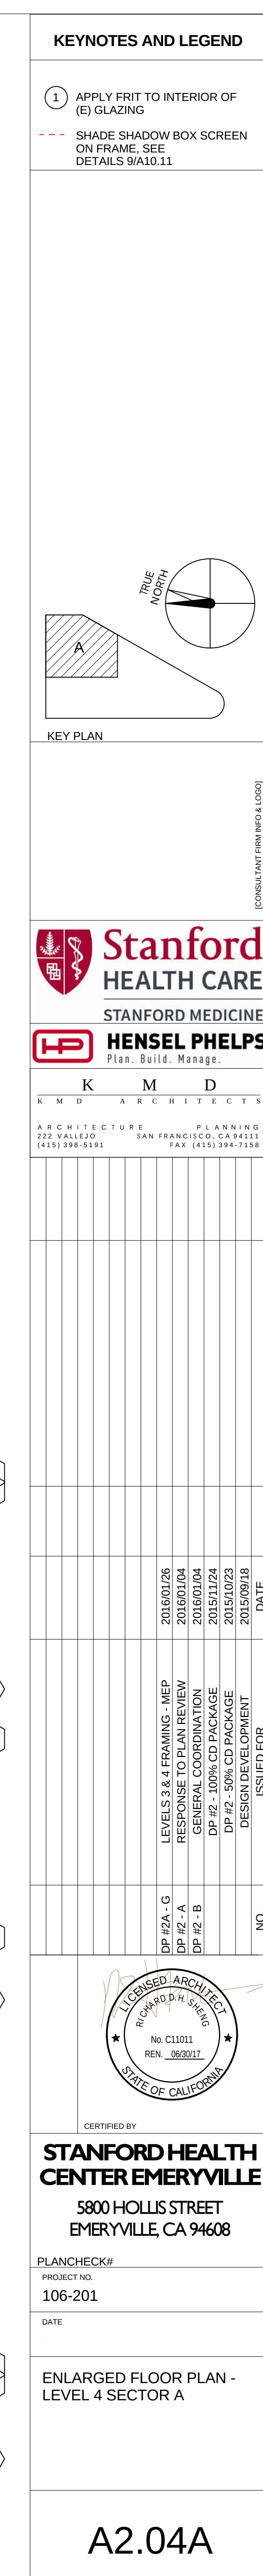



KEYNOTES AND LEGEND

- 1 APPLY FRIT TO INTERIOR OF (E) GLAZING
- SHADE SHADOW BOX SCREEN ON FRAME. SEE DETAILS 9/A10.11

KEY PLAN

Stanford HEALTH CARE
STANFORD MEDICINE
HENSEL PHELPS
Plan. Build. Manage.
K M D ARCHITECTS
ARCHITECTURE PLANNING
122 WALL ST. SAN FRANCISCO, CA 94103
(415) 398-9131 FAX (415) 394-7158


NO.	DATE	ISSUED FOR
20160129	20160129	RESPONSE TO PLAN REVIEW
20160129	20160129	WASTE MANAGEMENT
20160129	20160129	GENERAL COORDINATION
20160129	20160129	LEVELS 3 & 4 FRAMING - MEP
20160129	20160129	LEVELS 3 & 4 FRAMING - MECHANICAL
20160129	20160129	LEVELS 3 & 4 FRAMING - ELECTRICAL
20160129	20160129	GENERAL COORDINATION
20160129	20160129	DP #2 - 100% CD PACKAGE
20160129	20160129	DP #2 - 50% CD PACKAGE
20160129	20160129	DESIGN DEVELOPMENT

CERTIFIED BY
STANFORD HEALTH CENTER EMERYVILLE
5800 HOLLIS STREET
EMERYVILLE, CA 94608

PLANCHHECK#
PROJECT NO.
106-201
DATE


ENLARGED FLOOR PLAN - LEVEL 4 SECTOR B

A2.04B

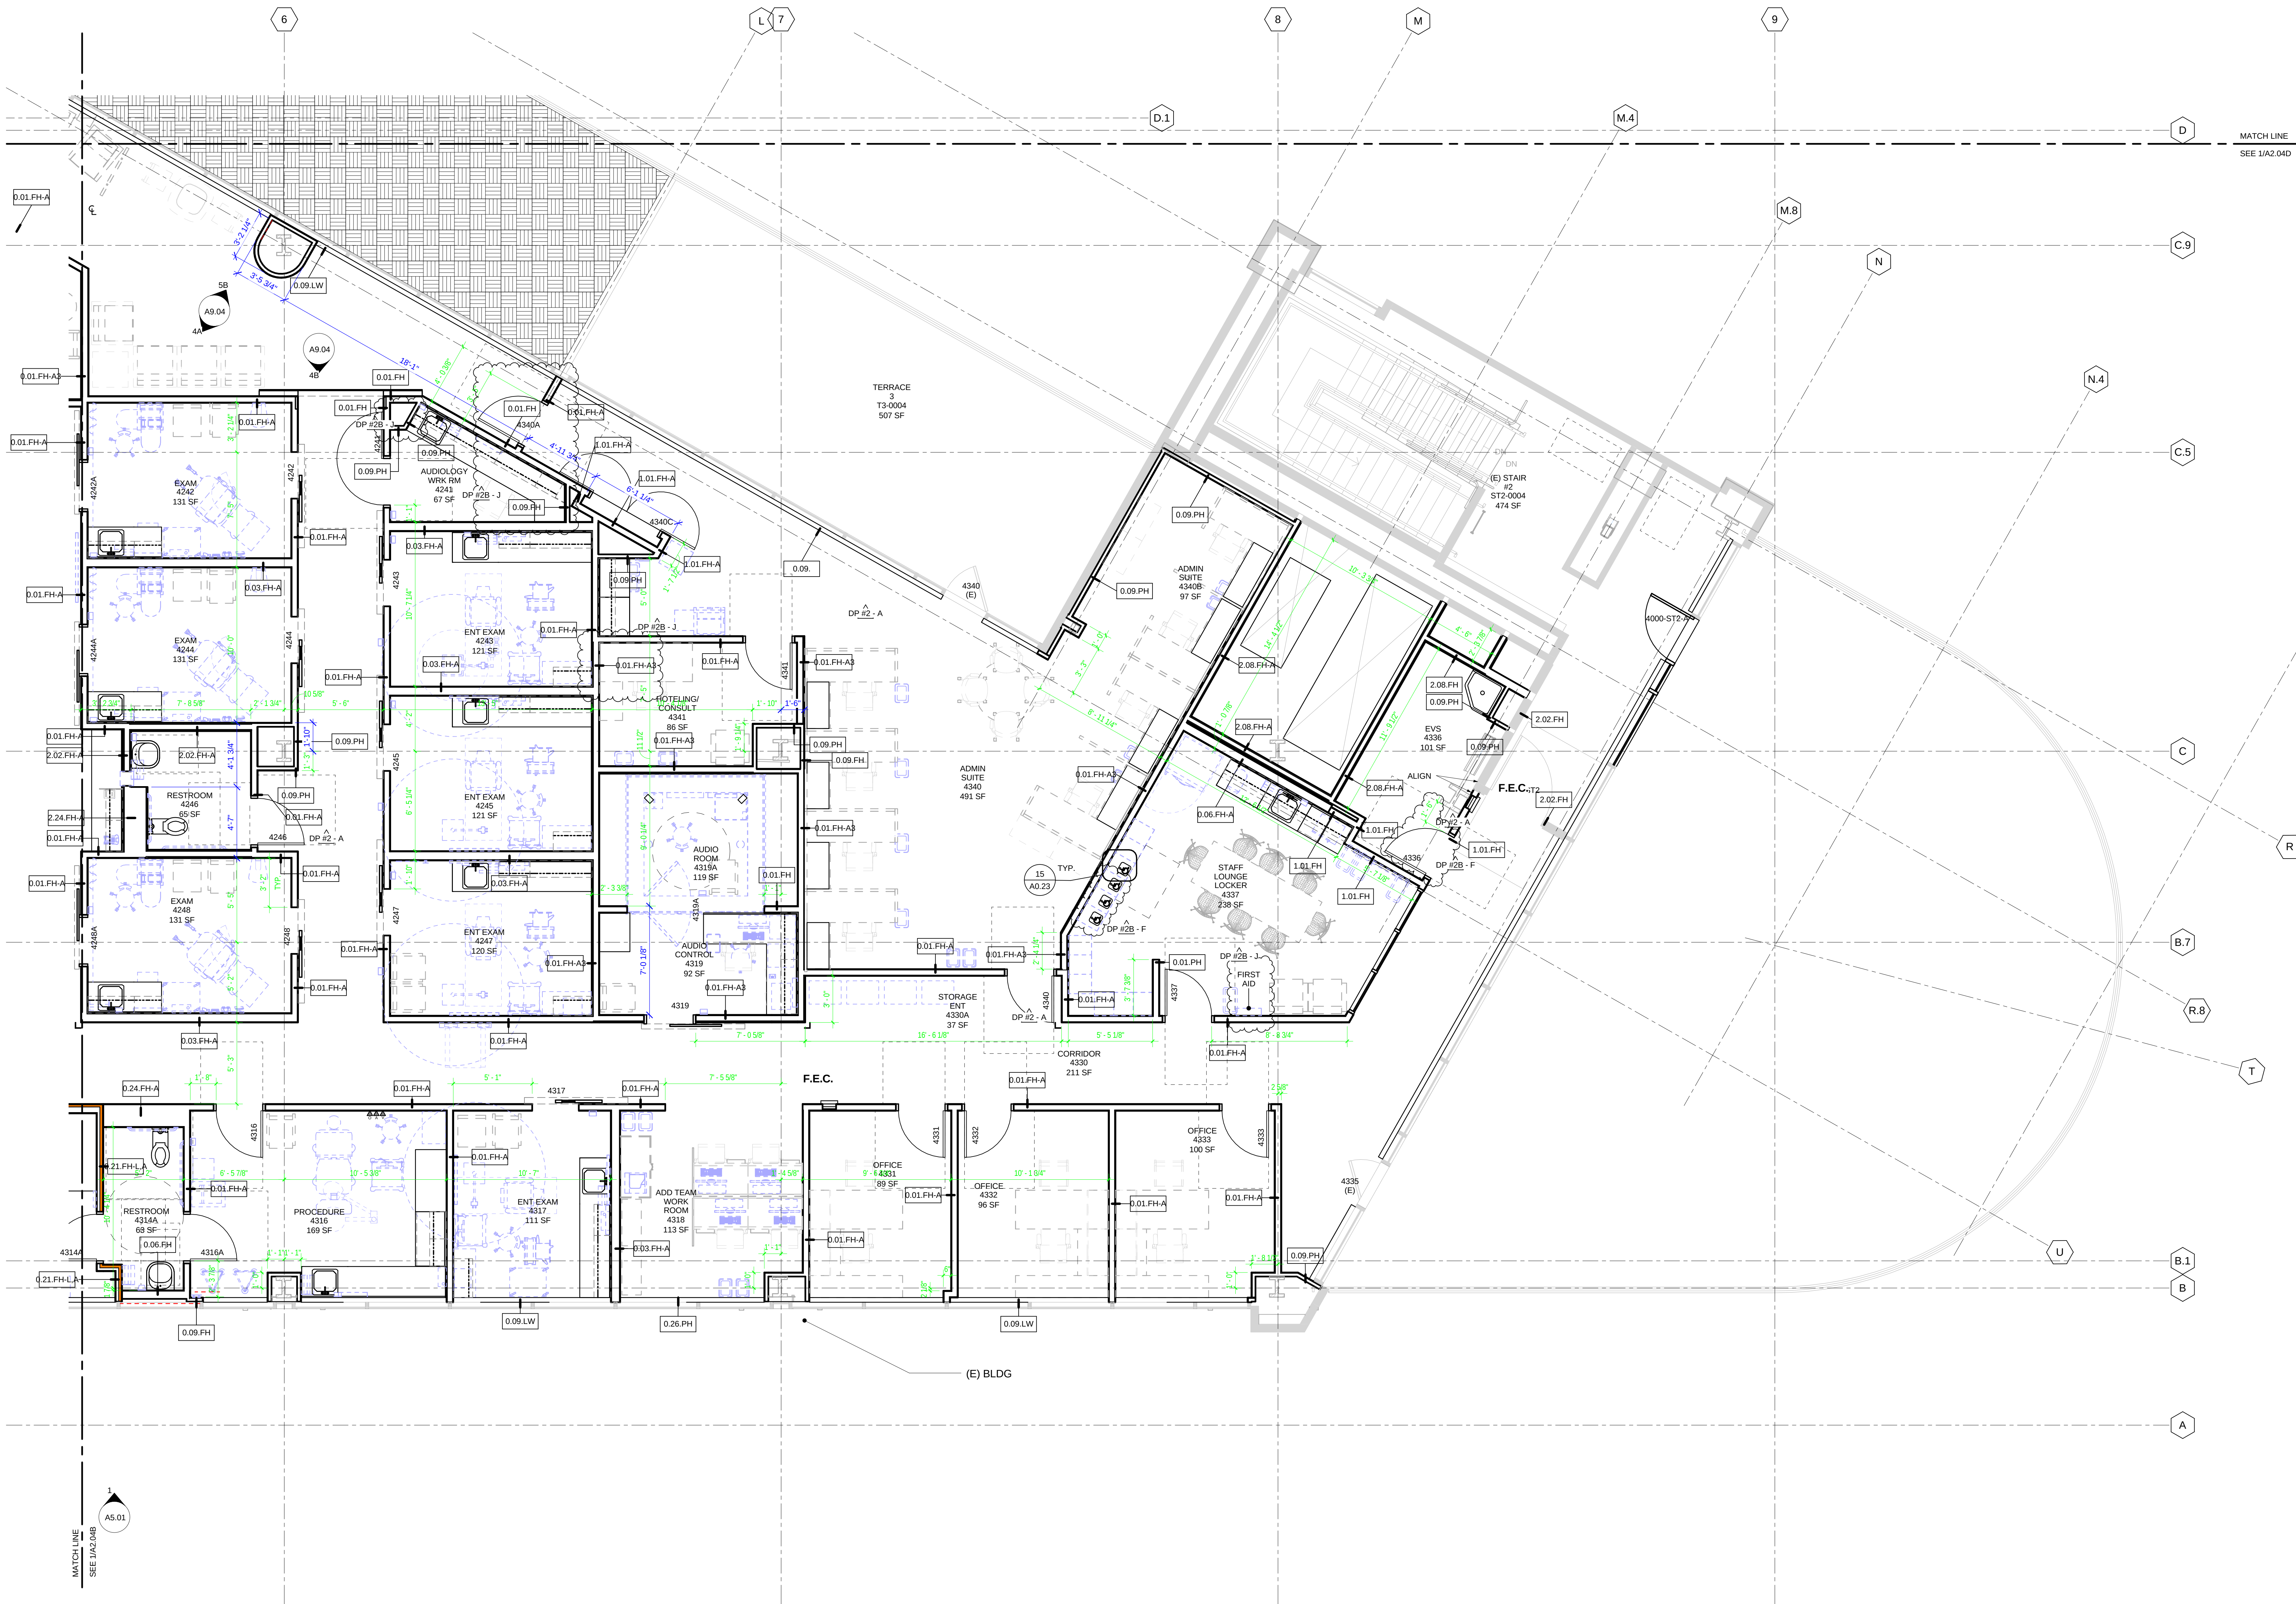


KEYNOTES AND LEGEND

- 1 APPLY FRIT TO INTERIOR OF (E) GLAZING
- SHADE SHADOW BOX SCREEN ON FRAME. SEE DETAILS 9/A10.11

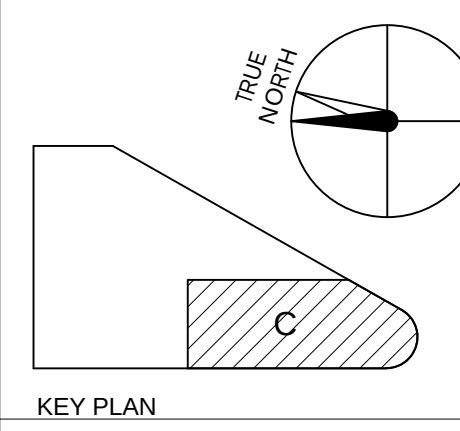

Stanford HEALTH CARE
STANFORD MEDICINE
HENSEL PHELPS
Plan. Build. Manage.
K M D ARCHITECTS
ARCHITECTURE PLANNING
222 WALL ST. SAN FRANCISCO, CA 94102
(415) 398-5153 FAX (415) 394-7158

NO.	DATE	ISSUED FOR
2016/07/29	RESPONSE TO PLAN REVIEW	
2016/07/29	GENERAL COORDINATION	
2016/07/29	REVISIONS	
2016/07/29	RESPONSE TO PLAN REVIEW	
2016/07/29	DP #2 - 100% CD PACKAGE	
2016/07/29	DESIGN DEVELOPMENT	
2016/07/29	ISSUED FOR	

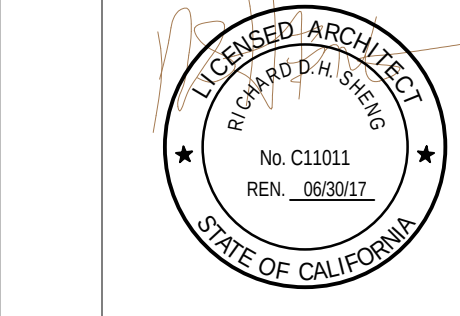


CERTIFIED BY
STANFORD HEALTH CENTER EMERYVILLE
5800 HOLLIS STREET
EMERYVILLE, CA 94608

PLANCHECK#
PROJECT NO.
106-201
DATE

ENLARGED FLOOR PLAN -
LEVEL 4 SECTOR C

A2.04C

1 ENLARGED FLOOR PLAN - LVL 4 - SECTOR C
SCALE 1/4" = 1'-0"

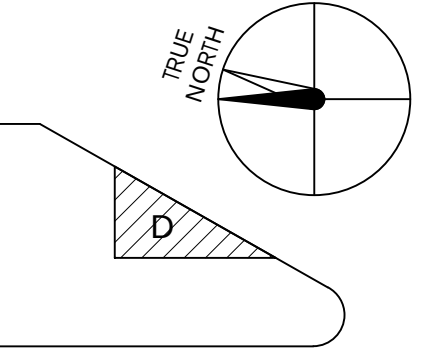

Y PLAN




STANFORD MEDICINE
 **HENSEL PHELPS**
Plan. Build. Manage.

K M D
D A R C H I T E C T S

ARCHITECTURE PLANNING
ALLEJO SAN FRANCISCO, CA 94111
398-5191 FAX (415) 394-7158

DP 12A - G	LEVELS 3 & 4 FRAMING - MEP	2016/01/26
DP 12 - B	GENERAL COORDINATION	2016/01/04
	DP 12 - 100% CD PACKAGE	2015/11/24
	DP 12 - 50% CD PACKAGE	2015/07/23
	DRESSING ROOMS	2015/01/08
NO	ISSUED FOR	DATE

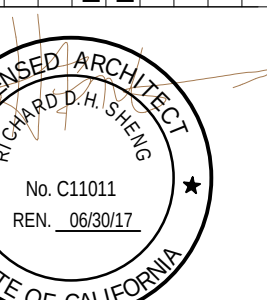

CERTIFIED BY	
--------------	--

**STANFORD HEALTH
CENTER EMERYVILLE**


5800 HOLLIS STREET
EMERYVILLE, CA 94608

CHECK#


6-201

LARGED FLOOR PLAN -
LEVEL 4 SECTOR D


A2.04D

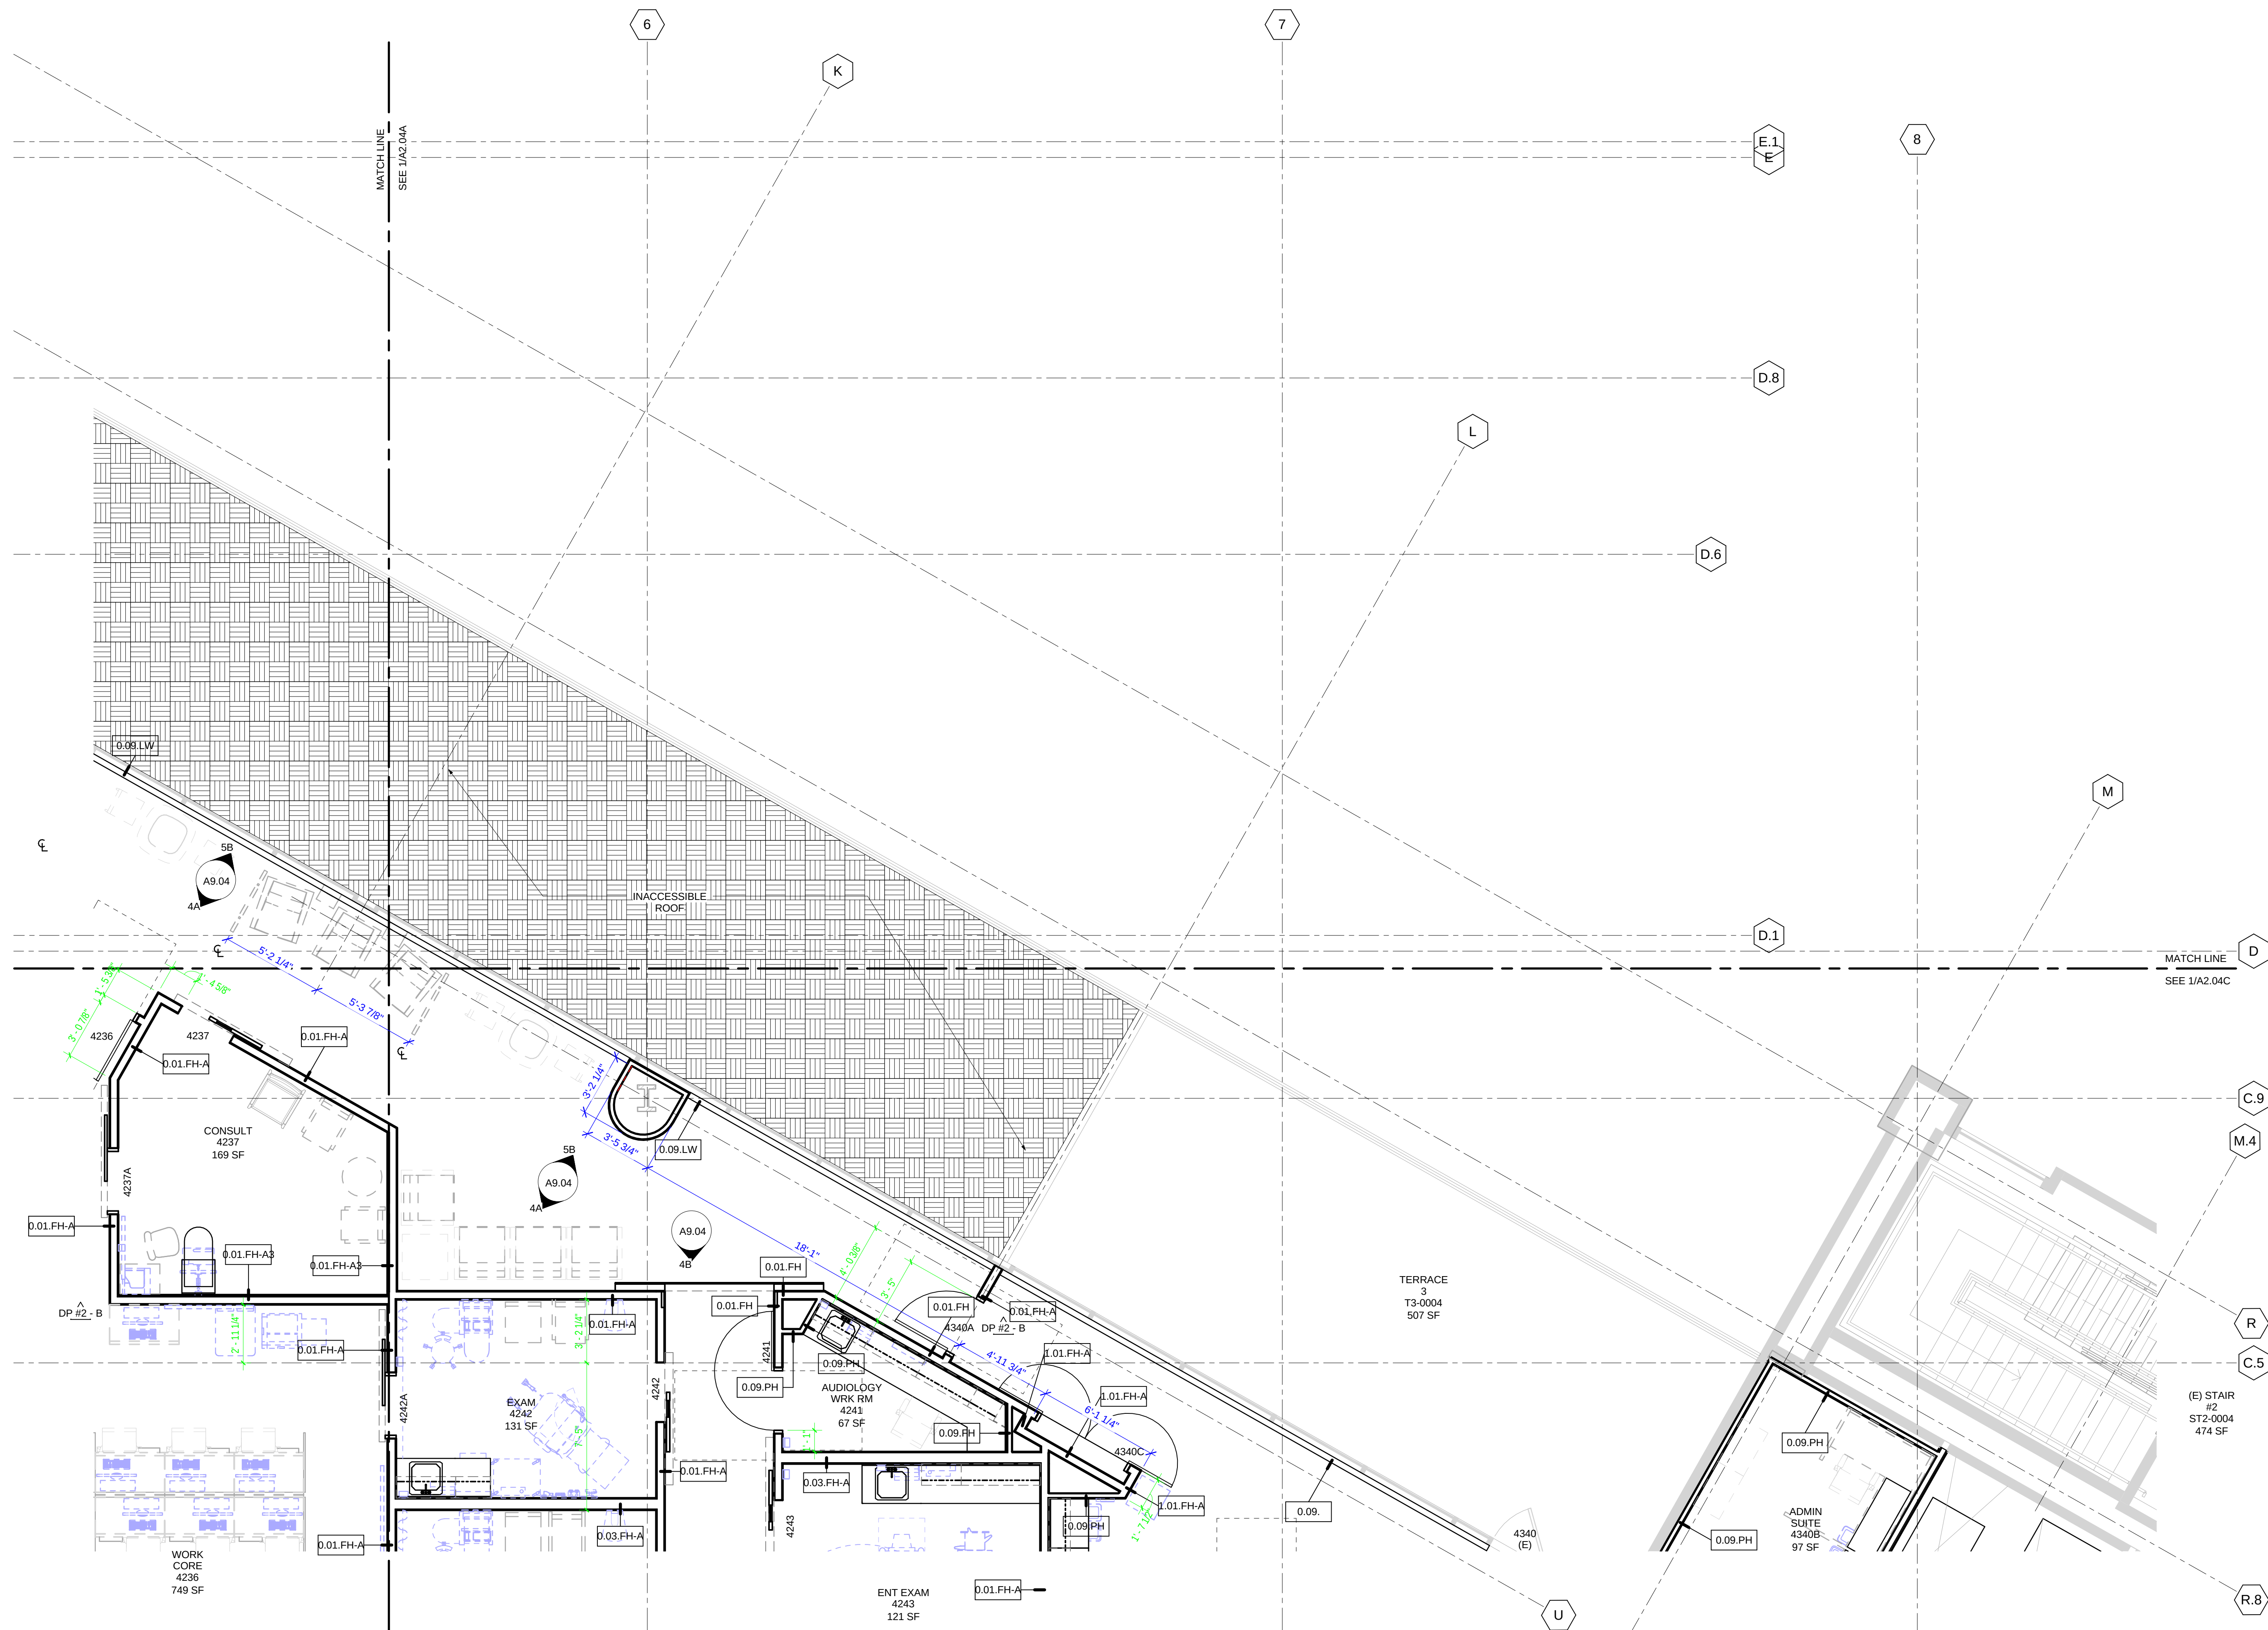

1 ENLARGED FLOOR PLAN - LVL 4 - SECTOR D
SCALE 1/4" = 1'-0"

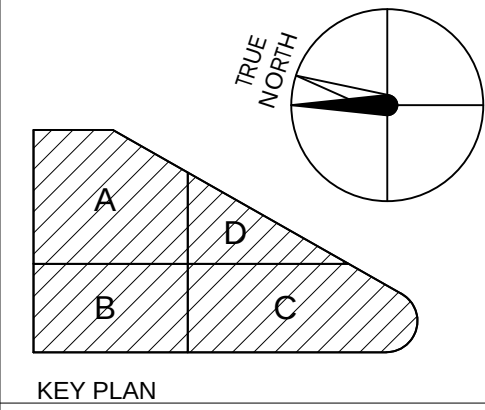

NO.	DATE	ISSUED FOR
DP #3 - A	2015/08/27	DP #2 (50% DD) COORDINATION
DP #3 - A	2015/09/18	BP #3 - ADDENDUM A
DP #2 - A	2015/10/23	DESIGN DEVELOPMENT
DP #2 - A	2015/11/24	DP #2 - 50% CD PACKAGE
DP #2 - A	2016/01/04	RESPONSE TO PLAN REVIEW
DP #2 - A	2016/01/29	RESPONSE TO FIRE REVIEW

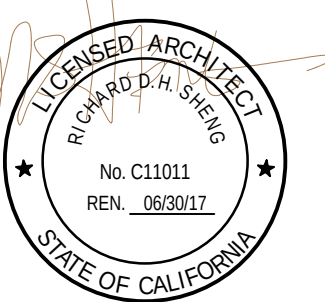


CERTIFIED BY

**STANFORD HEALTH
CENTER EMERYVILLE**

5800 HOLLIS STREET
EMERYVILLE, CA 94608

PLANCHECK#
PROJECT NO. 106-201
DATE

REFLECTED CEILING PLAN -
LEVEL 1

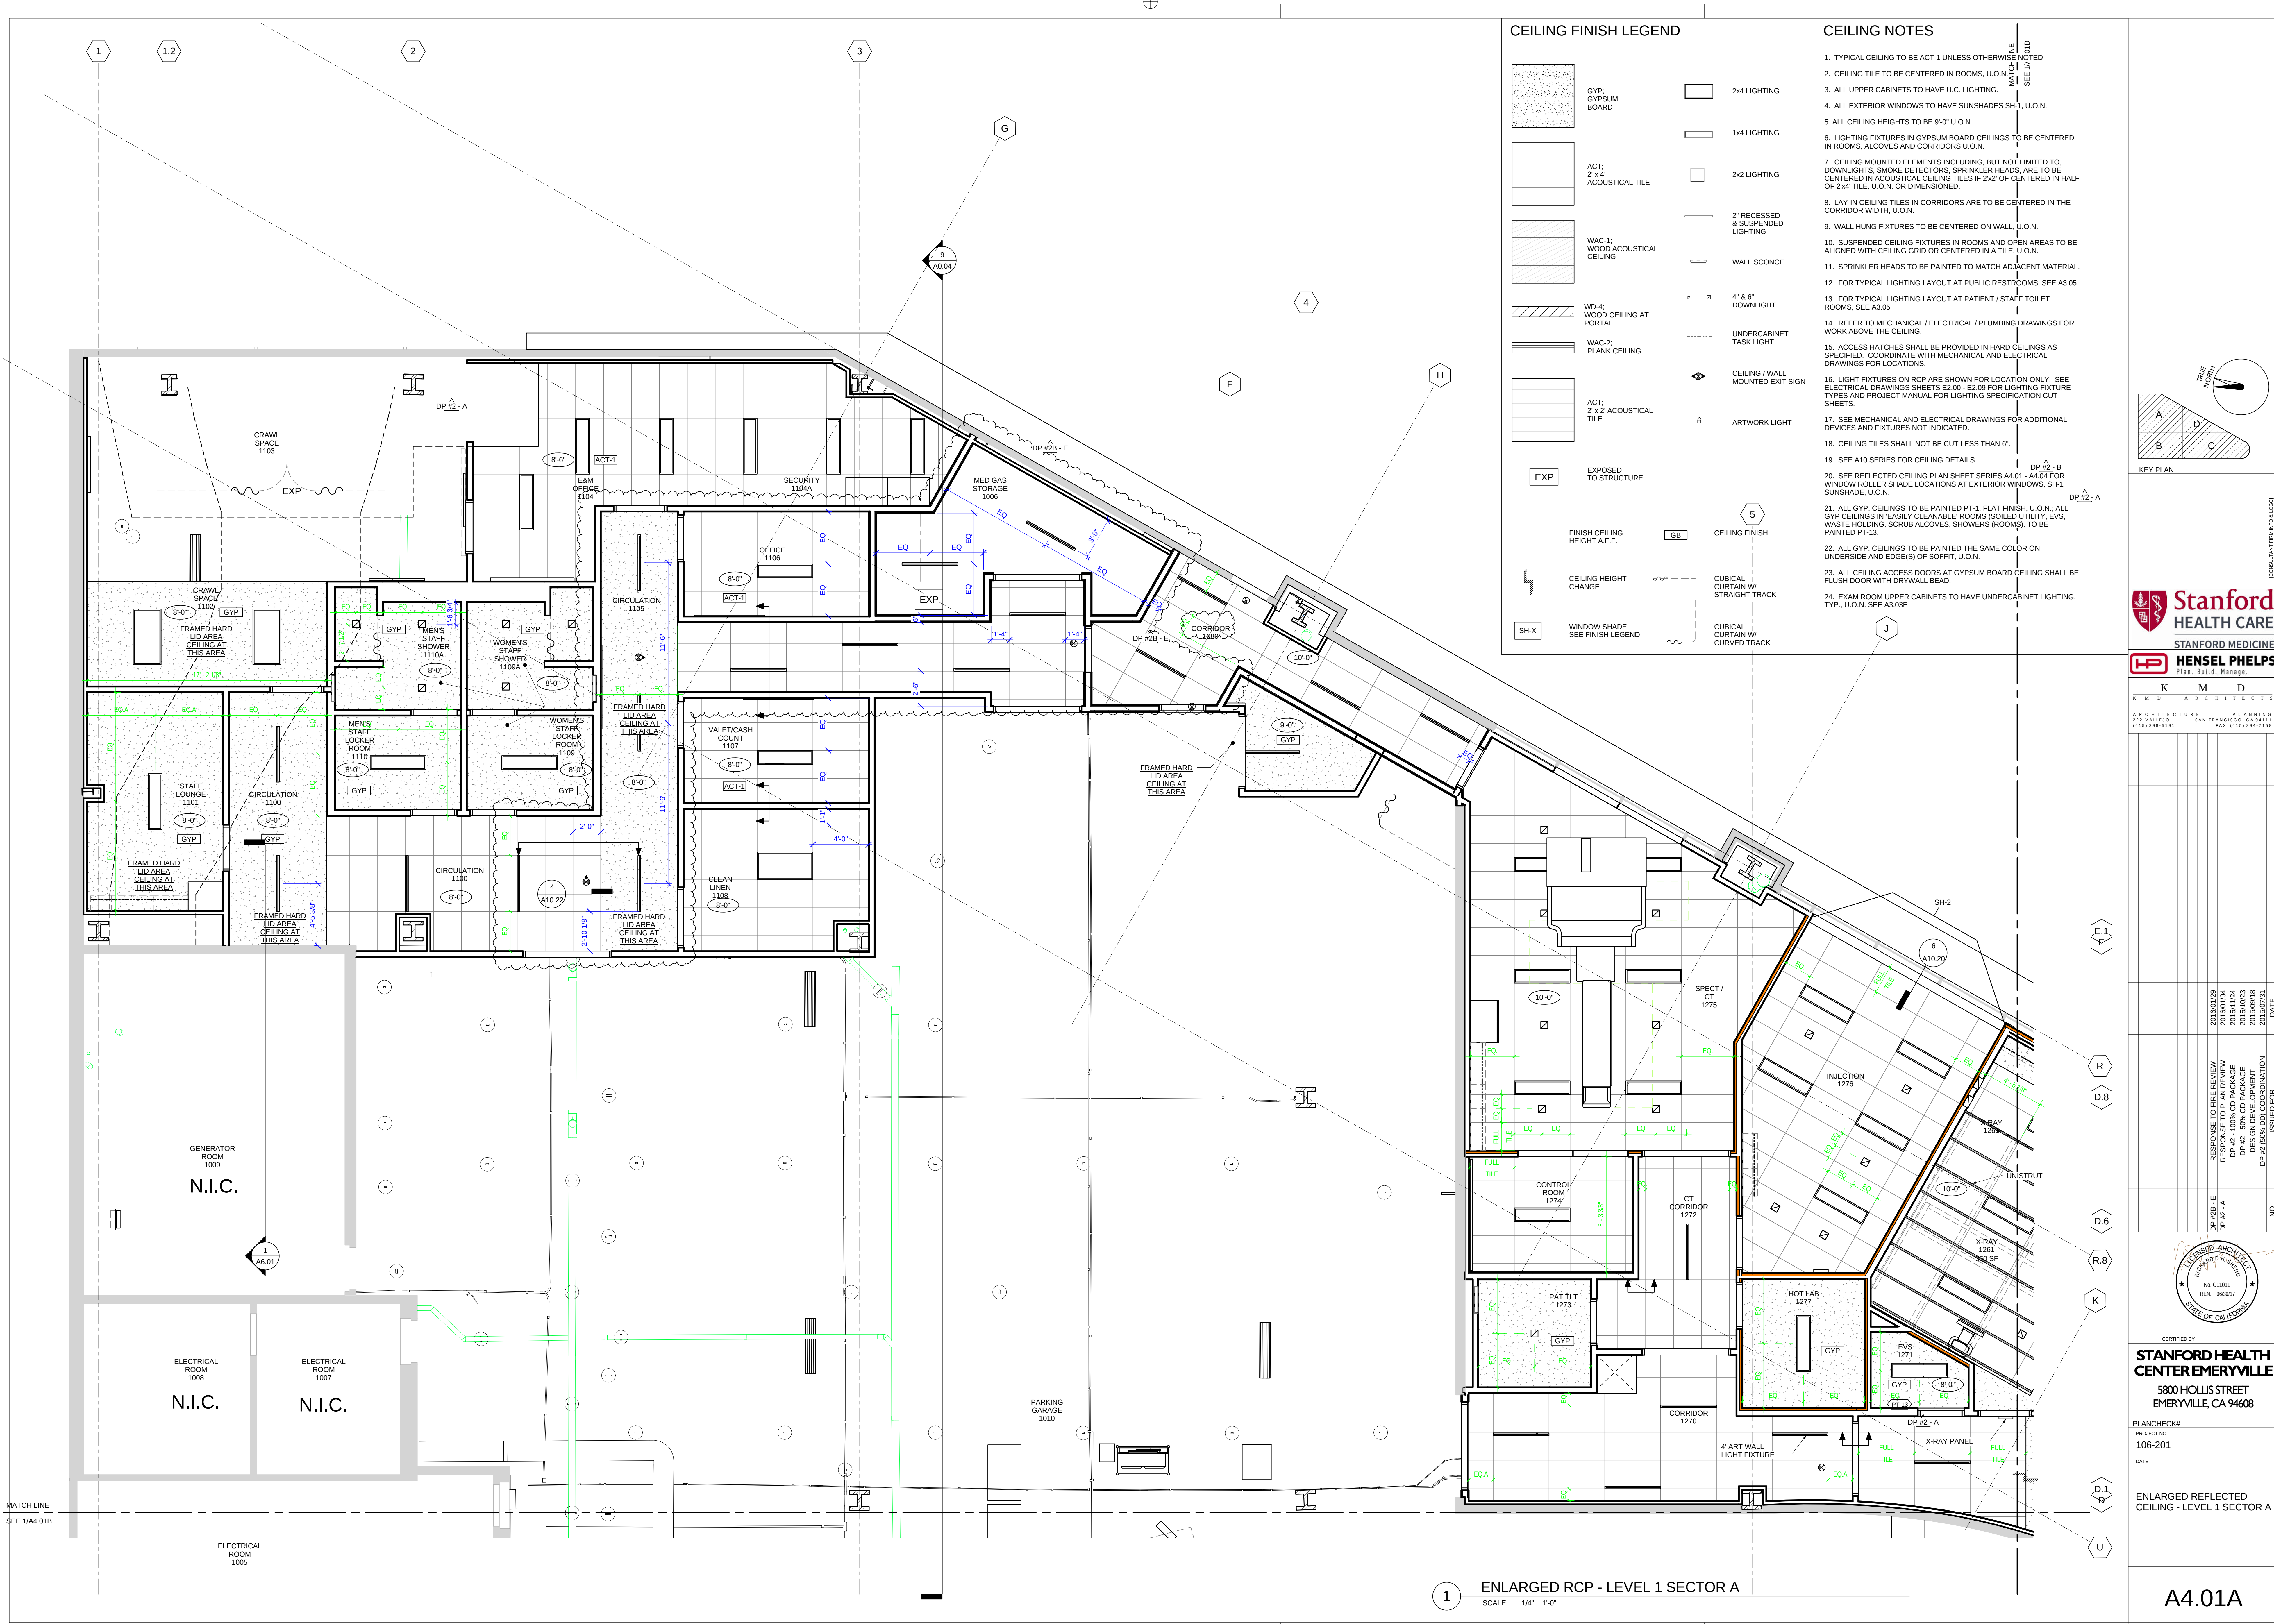


CEILING FINISH LEGEND

	GYP: GYPSUM BOARD		2x4 LIGHTING
	ACT: 2' x 4' ACOUSTICAL TILE		1x4 LIGHTING
	WAC-1: WOOD ACOUSTICAL CEILING		2x2 LIGHTING
	WD-4: WOOD CEILING AT PORTAL		2' RECESSED & SUSPENDED LIGHTING
	WAC-2: PLANK CEILING		WALL SCONCE
	ACT: 2' x 2' ACOUSTICAL TILE		4' & 6' DOWNLIGHT
	EXP: EXPOSED TO STRUCTURE		UNDERCABINET TASK LIGHT
	SH-X: WINDOW SHADE SEE FINISH LEGEND		CEILING / WALL MOUNTED EXIT SIGN
			ARTWORK LIGHT
			CEILING FINISH
			CUBICAL CURTAIN W/ STRAIGHT TRACK
			CUBICAL CURTAIN W/ CURVED TRACK


CEILING NOTES

1. TYPICAL CEILING TO BE ACT-1 UNLESS OTHERWISE NOTED
2. CEILING TILE TO BE CENTERED IN ROOMS, U.O.N. SEE 1/4.010
3. ALL UPPER CABINETS TO HAVE U.C. LIGHTING.
4. ALL EXTERIOR WINDOWS TO HAVE SUNSHADES SH-1, U.O.N.
5. ALL CEILING HEIGHTS TO BE 9'-0" U.O.N.
6. LIGHTING FIXTURES IN GYPSUM BOARD CEILINGS TO BE CENTERED IN ROOMS, ALCOVES AND CORRIDORS U.O.N.
7. CEILING MOUNTED ELEMENTS INCLUDING, BUT NOT LIMITED TO, DOWNLIGHTS, SMOKE DETECTORS, SPRINKLER HEADS, ARE TO BE CENTERED IN ACOUSTICAL CEILING TILES IF 2'x2' OF CENTERED IN HALF OF 2'x4 TILE, U.O.N. OR DIMENSIONED.
8. LAY-IN CEILING TILES IN CORRIDORS ARE TO BE CENTERED IN THE CORRIDOR WIDTH, U.O.N.
9. WALL HUNG FIXTURES TO BE CENTERED ON WALL, U.O.N.
10. SUSPENDED CEILING FIXTURES IN ROOMS AND OPEN AREAS TO BE ALIGNED WITH CEILING GRID OR CENTERED IN A TILE, U.O.N.
11. SPRINKLER HEADS TO BE PAINTED TO MATCH ADJACENT MATERIAL.
12. FOR TYPICAL LIGHTING LAYOUT AT PUBLIC RESTROOMS, SEE A3.05
13. FOR TYPICAL LIGHTING LAYOUT AT PATIENT / STAFF TOILET ROOMS, SEE A3.05
14. REFER TO MECHANICAL / ELECTRICAL / PLUMBING DRAWINGS FOR WORK ABOVE THE CEILING.
15. ACCESS HATCHES SHALL BE PROVIDED IN HARD CEILINGS AS SPECIFIED. COORDINATE WITH MECHANICAL AND ELECTRICAL DRAWINGS FOR LOCATIONS.
16. LIGHT FIXTURES ON RCP ARE SHOWN FOR LOCATION ONLY. SEE ELECTRICAL DRAWINGS SHEETS E2.00 - E2.09 FOR LIGHTING FIXTURE TYPES AND PROJECT MANUAL FOR LIGHTING SPECIFICATION CUT SHEETS.
17. SEE MECHANICAL AND ELECTRICAL DRAWINGS FOR ADDITIONAL DEVICES AND FIXTURES NOT INDICATED.
18. CEILING TILES SHALL NOT BE CUT LESS THAN 6".
19. SEE A10 SERIES FOR CEILING DETAILS.
20. SEE REFLECTED CEILING PLAN SHEET SERIES A4.01 - A4.04 FOR WINDOW ROLLER SHADE LOCATIONS AT EXTERIOR WINDOWS, SH-1 SUNSHADE, U.O.N.
21. ALL GYP. CEILINGS TO BE PAINTED PT-1, FLAT FINISH, U.O.N.; ALL GYP. CEILINGS IN EASILY CLEANABLE ROOMS (COILED UTILITY, EVS, WASTE HOLDING, SCRUB ALCOVES, SHOWERS (ROOMS), TO BE PAINTED PT-13.
22. ALL GYP. CEILINGS TO BE PAINTED THE SAME COLOR ON UNDERSIDE AND EDGE(S) OF SOFFIT, U.O.N.
23. ALL CEILING ACCESS DOORS AT GYPSUM BOARD CEILING SHALL BE FLUSH DOOR WITH DRYWALL BEAD.
24. EXAM ROOM UPPER CABINETS TO HAVE UNDERCABINET LIGHTING, TYP., U.O.N. SEE A3.03E

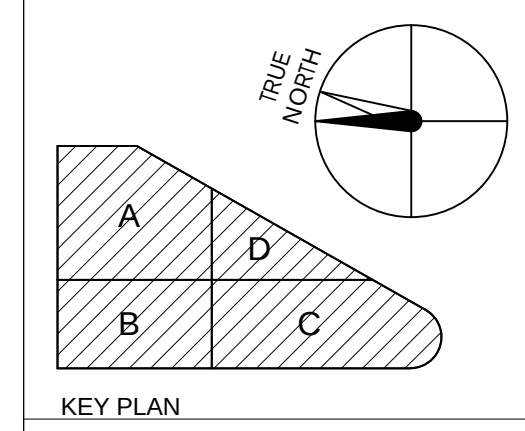

Stanford HEALTH CARE
STANFORD MEDICINE
HENSEL PHELPS
Plan. Build. Manage.
K M D ARCHITECTS
ARCHITECTURE PLANNING
222 WILLOW STREET SAN FRANCISCO, CA 94111
(415) 398-9131 FAX (415) 394-7150

NO.	DATE	ISSUED FOR
20160129	RESPONSE TO FIRE REVIEW	
20160129	DP #2 - A	
20160124	DP #2 - 10% CD PACKAGE	
20160123	DP #2 - 50% CD PACKAGE	
20160918	DESIGN DEVELOPMENT	
20160731	DP #2 (50% CD) COORDINATION	

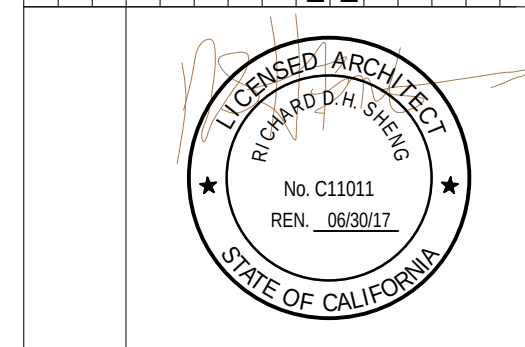


CERTIFIED BY
STANFORD HEALTH CENTER EMERYVILLE
5800 HOLLIS STREET
EMERYVILLE, CA 94608

PLAN CHECK#
PROJECT NO.
106-201
DATE

ENLARGED REFLECTED
CEILING - LEVEL 1 SECTOR A

1 ENLARGED RCP - LEVEL 1 SECTOR A
SCALE 1/4" = 1'-0"


A4.01A

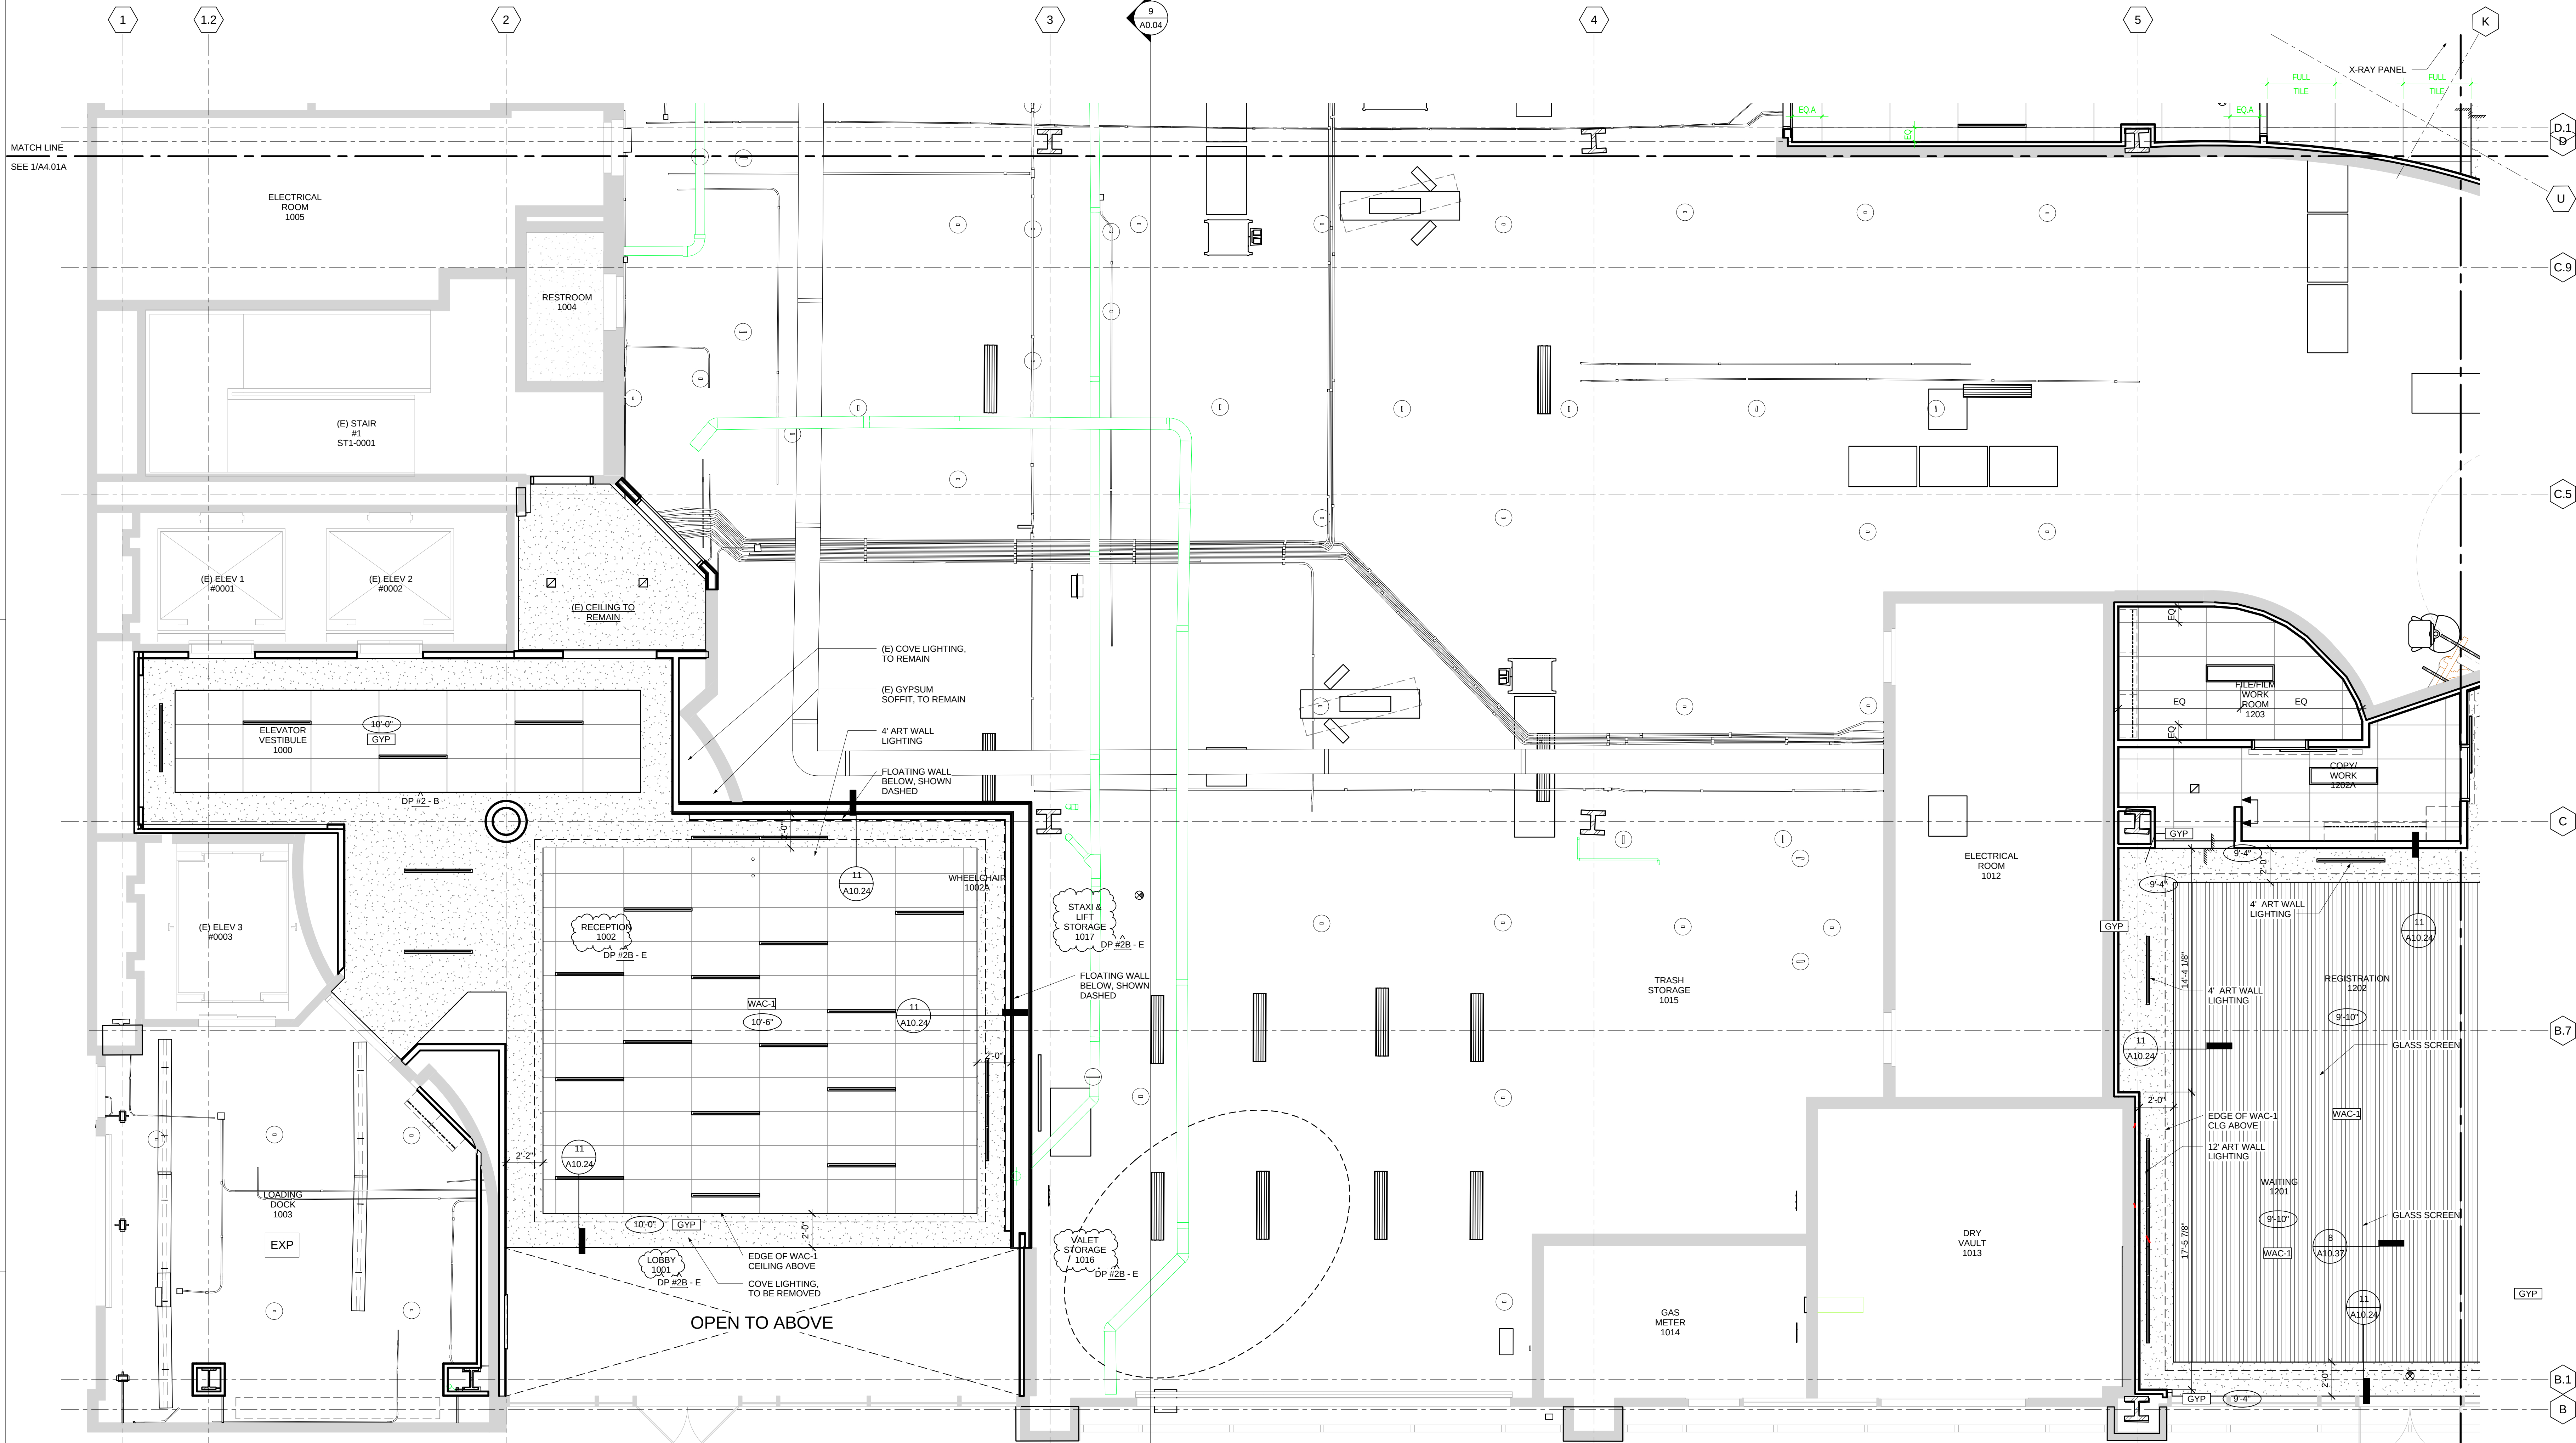


CEILING NOTES

1. TYPICAL CEILING TO BE ACT-1 UNLESS OTHERWISE NOTED
2. CEILING TILE TO BE CENTERED IN ROOMS, U.O.N.
3. ALL UPPER CABINETS TO HAVE U.C. LIGHTING.
4. ALL EXTERIOR WINDOWS TO HAVE SUNSHADES SH-1, U.O.N.
5. ALL CEILING HEIGHTS TO BE 9'-0" U.O.N.
6. LIGHTING FIXTURES IN GYPSUM BOARD CEILINGS TO BE CENTERED IN ROOMS, ALCOVES AND CORRIDORS U.O.N.
7. CEILING MOUNTED ELEMENTS INCLUDING, BUT NOT LIMITED TO, DOWNLIGHTS, SMOKE DETECTORS, SPRINKLER HEADS, ARE TO BE CENTERED IN ACOUSTICAL CEILING TILES IF 2'x2' OF CENTERED IN HALF OF 2'x4' TILE, U.O.N. OR DIMENSIONED.
8. LAY-IN CEILING TILES IN CORRIDORS ARE TO BE CENTERED IN THE CORRIDOR WIDTH, U.O.N.
9. WALL HUNG FIXTURES TO BE CENTERED ON WALL, U.O.N.
10. SUSPENDED CEILING FIXTURES IN ROOMS AND OPEN AREAS TO BE ALIGNED WITH CEILING GRID OR CENTERED IN A TILE, U.O.N.
11. SPRINKLER HEADS TO BE PAINTED TO MATCH ADJACENT MATERIAL.
12. FOR TYPICAL LIGHTING LAYOUT AT PUBLIC RESTROOMS, SEE A3.05
13. FOR TYPICAL LIGHTING LAYOUT AT PATIENT / STAFF TOILET ROOMS, SEE A3.05
14. REFER TO MECHANICAL / ELECTRICAL / PLUMBING DRAWINGS FOR WORK ABOVE THE CEILING.
15. ACCESS HATCHES SHALL BE PROVIDED IN HARD CEILINGS AS SPECIFIED. COORDINATE WITH MECHANICAL AND ELECTRICAL DRAWINGS FOR LOCATIONS.
16. LIGHT FIXTURES ON RCP ARE SHOWN FOR LOCATION ONLY. SEE ELECTRICAL DRAWINGS SHEETS E2.00 - E2.09 FOR LIGHTING FIXTURE TYPES AND PROJECT MANUAL FOR LIGHTING SPECIFICATION CUT SHEETS.
17. SEE MECHANICAL AND ELECTRICAL DRAWINGS FOR ADDITIONAL DEVICES AND FIXTURES NOT INDICATED.
18. CEILING TILES SHALL NOT BE CUT LESS THAN 6".
19. SEE A10 SERIES FOR CEILING DETAILS.
20. SEE REFLECTED CEILING PLAN SHEET SERIES A4.01 - A4.09 FOR WINDOW ROLLER SHADE LOCATIONS AT EXTERIOR WINDOWS, SH-1 SUNSHADE, U.O.N.
21. ALL GYP. CEILINGS TO BE PAINTED PT-1, FLAT FINISH, U.O.N.; ALL GYP CEILINGS IN "EASILY CLEANABLE" ROOMS (SOILED UTILITY; EVS, WASTE HOLDING, SCRUB ALCOVES, SHOWERS (ROOMS), TO BE PAINTED PT-13.
22. ALL GYP. CEILINGS TO BE PAINTED THE SAME COLOR ON UNDERSIDE AND EDGE(S) OF SOFFIT, U.O.N.
23. ALL CEILING ACCESS DOORS AT GYPSUM BOARD CEILING SHALL BE FLUSH DOOR WITH DRYWALL BEAD.
24. EXAM ROOM UPPER CABINETS TO HAVE UNDERCABINET LIGHTING, TYP., U.O.N. SEE A3.03E

1 ENLARGED RCP - LEVEL 1 SECTOR B
SCALE 1/4" = 1'-0"

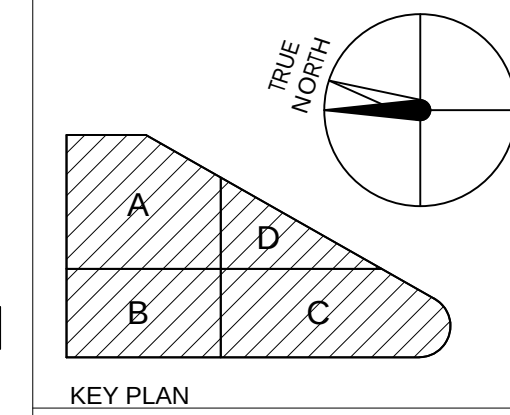

NO.	DATE	ISSUED FOR
2016/01/29	2016/01/29	RESPONSE TO FIRE REVIEW
DP #2B - E	2016/01/29	DP #2B - E
2015/11/24	2015/11/24	DP #2 - 100% CD PACKAGE
2015/10/23	2015/10/23	DP #2 - 50% CD PACKAGE
2015/09/18	2015/09/18	DESIGN DEVELOPMENT
2015/07/31	2015/07/31	DP #2 (50% CD) COORDINATION

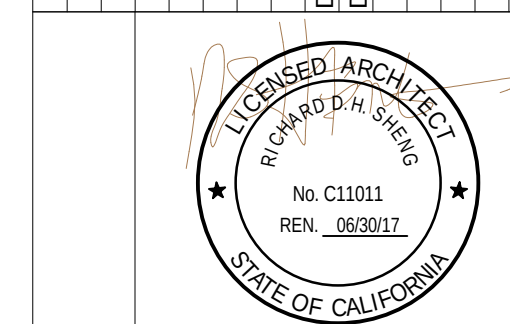

CERTIFIED BY
STANFORD HEALTH CENTER EMERYVILLE
5800 HOLLIS STREET
EMERYVILLE, CA 94608

PROJECT NO.
106-201
DATE


ENLARGED REFLECTED
CEILING - LEVEL 1 SECTOR B

A4.01B

CEILING NOTES


1. TYPICAL CEILING TO BE ACT-1 UNLESS OTHERWISE NOTED
2. CEILING TILE TO BE CENTERED IN ROOMS, U.O.N.
3. ALL UPPER CABINETS TO HAVE U.C. LIGHTING.
4. ALL EXTERIOR WINDOWS TO HAVE SUNSHADES SH-1, U.O.N.
5. ALL CEILING HEIGHTS TO BE 9'-0" U.O.N.
6. LIGHTING FIXTURES IN GYPSUM BOARD CEILINGS TO BE CENTERED IN ROOMS, ALCOVES AND CORRIDORS U.O.N.
7. CEILING MOUNTED ELEMENTS INCLUDING, BUT NOT LIMITED TO, DOWNLIGHTS, SMOKE DETECTORS, SPRINKLER HEADS, ARE TO BE CENTERED IN ACOUSTICAL CEILING TILES IF 2'X2' OF CENTERED IN HALF OF 2'X4' TILE, U.O.N. OR DIMENSIONED.
8. LAY-IN CEILING TILES IN CORRIDORS ARE TO BE CENTERED IN THE CORRIDOR WIDTH, U.O.N.
9. WALL HUNG FIXTURES TO BE CENTERED ON WALL, U.O.N.
10. SUSPENDED CEILING FIXTURES IN ROOMS AND OPEN AREAS TO BE ALIGNED WITH CEILING GRID OR CENTERED IN A TILE, U.O.N.
11. SPRINKLER HEADS TO BE PAINTED TO MATCH ADJACENT MATERIAL.
12. FOR TYPICAL LIGHTING LAYOUT AT PUBLIC RESTROOMS, SEE A3.05
13. FOR TYPICAL LIGHTING LAYOUT AT PATIENT / STAFF TOILET ROOMS, SEE A3.05
14. REFER TO MECHANICAL / ELECTRICAL / PLUMBING DRAWINGS FOR WORK ABOVE THE CEILING.
15. ACCESS HATCHES SHALL BE PROVIDED IN HARD CEILINGS AS SPECIFIED. COORDINATE WITH MECHANICAL AND ELECTRICAL DRAWINGS FOR LOCATIONS.
16. LIGHT FIXTURES ON RCP ARE SHOWN FOR LOCATION ONLY. SEE ELECTRICAL DRAWINGS SHEETS E2.00 - E2.09 FOR LIGHTING FIXTURE TYPES AND PROJECT MANUAL FOR LIGHTING SPECIFICATION CUT SHEETS.
17. SEE MECHANICAL AND ELECTRICAL DRAWINGS FOR ADDITIONAL DEVICES AND FIXTURES NOT INDICATED.
18. CEILING TILES SHALL NOT BE CUT LESS THAN 6".
19. SEE A10 SERIES FOR CEILING DETAILS.
20. SEE REFLECTED CEILING PLAN SHEET SERIES A4.01 - A4.09 FOR WINDOW ROLLER SHADE LOCATIONS AT EXTERIOR WINDOWS, SH-1 SUNSHADE, U.O.N.
21. ALL GYP. CEILINGS TO BE PAINTED PT-1, FLAT FINISH, U.O.N.; ALL GYP CEILINGS IN "EASILY CLEANABLE" ROOMS (SOILED UTILITY, EVS, WASTE HOLDING, SCRUB ALCOVES, SHOWERS (ROOMS), TO BE PAINTED PT-13.
22. ALL GYP. CEILINGS TO BE PAINTED THE SAME COLOR ON UNDERSIDE AND EDGE(S) OF SOFFIT, U.O.N.
23. ALL CEILING ACCESS DOORS AT GYPSUM BOARD CEILING SHALL BE FLUSH DOOR WITH DRYWALL BEAD.
24. EXAM ROOM UPPER CABINETS TO HAVE UNDERCABINET LIGHTING, TYP., U.O.N. SEE A3.03E

1 ENLARGED RCP - LEVEL 1 SECTOR C
SCALE 1/4" = 1'-0"

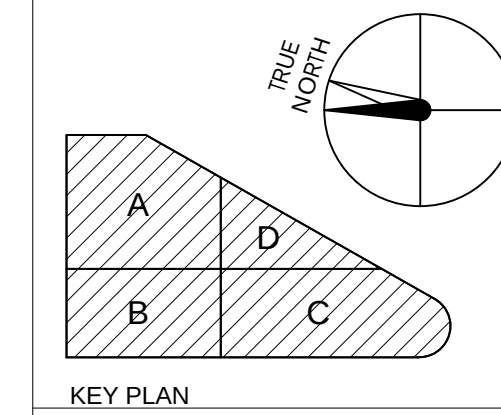

Stanford
HEALTH CARE
STANFORD MEDICINE
HENSEL PHELPS
Plan. Build. Manage.
K M D ARCHITECTS
ARCHITECTURE PLANNING
222 WALL ST. SAN FRANCISCO, CA 94102
(415) 398-9131 FAX (415) 394-7158

NO.	DATE	ISSUED FOR
1	2016/01/04	RESPONSE TO PLAN REVIEW
2	2016/01/24	DP #2 - 10% CD PACKAGE
3	2016/02/24	DP #2 - 50% CD PACKAGE
4	2016/09/18	DESIGN DEVELOPMENT
5	2016/07/31	DP #2 (50% CD) COORDINATION

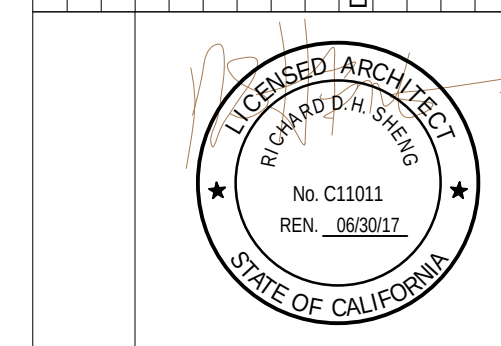

CERTIFIED BY
STANFORD HEALTH
CENTER EMERYVILLE
5800 HOLLIS STREET
EMERYVILLE, CA 94608

PLANCHECK#
PROJECT NO.
106-201
DATE

ENLARGED REFLECTED
CEILING - LEVEL 1 SECTOR C

A4.01C




CEILING FINISH LEGEND

	GYP: GYPSUM BOARD		2x4 LIGHTING
	ACT: 2' x 4' ACOUSTICAL TILE		1x4 LIGHTING
	WAC-1: WOOD ACOUSTICAL CEILING		2x2 LIGHTING
	WD-4: WOOD CEILING AT PORTAL		2\"/>
	WAC-2: PLANK CEILING		WALL SCONCE
	ACT: 2' x 2' ACOUSTICAL TILE		4\"/>
	EXP: EXPOSED TO STRUCTURE		UNDERCABINET TASK LIGHT
	SH-X: WINDOW SHADE SEE FINISH LEGEND		CEILING / WALL MOUNTED EXIT SIGN
	GB: CEILING FINISH		ARTWORK LIGHT
	CEILING HEIGHT CHANGE		CUBICAL CURTAIN W/ STRAIGHT TRACK
	D.8: WINDOW SHADE SEE FINISH LEGEND		CUBICAL CURTAIN W/ CURVED TRACK

CEILING NOTES


1. TYPICAL CEILING TO BE ACT-1 UNLESS OTHERWISE NOTED
2. CEILING TILE TO BE CENTERED IN ROOMS, U.O.N.
3. ALL UPPER CABINETS TO HAVE U.C. LIGHTING.
4. ALL EXTERIOR WINDOWS TO HAVE SUNSHADES SH-1, U.O.N.
5. ALL CEILING HEIGHTS TO BE 9'-0" U.O.N.
6. LIGHTING FIXTURES IN GYPSUM BOARD CEILINGS TO BE CENTERED IN ROOMS, ALCOVES AND CORRIDORS U.O.N.
7. CEILING MOUNTED ELEMENTS INCLUDING, BUT NOT LIMITED TO, DOWNLIGHTS, SMOKE DETECTORS, SPRINKLER HEADS, ARE TO BE CENTERED IN ACOUSTICAL CEILING TILES IF 2'x2' OF CENTERED IN HALF OF 2'x4' TILE, U.O.N. OR DIMENSIONED.
8. LAY-IN CEILING TILES IN CORRIDORS ARE TO BE CENTERED IN THE CORRIDOR WIDTH, U.O.N.
9. WALL HUNG FIXTURES TO BE CENTERED ON WALL, U.O.N.
10. SUSPENDED CEILING FIXTURES IN ROOMS AND OPEN AREAS TO BE ALIGNED WITH CEILING GRID OR CENTERED IN A TILE, U.O.N.
11. SPRINKLER HEADS TO BE PAINTED TO MATCH ADJACENT MATERIAL.
12. FOR TYPICAL LIGHTING LAYOUT AT PUBLIC RESTROOMS, SEE A3.05
13. FOR TYPICAL LIGHTING LAYOUT AT PATIENT / STAFF TOILET ROOMS, SEE A3.05
14. REFER TO MECHANICAL / ELECTRICAL / PLUMBING DRAWINGS FOR WORK ABOVE THE CEILING.
15. ACCESS HATCHES SHALL BE PROVIDED IN HARD CEILINGS AS SPECIFIED. COORDINATE WITH MECHANICAL AND ELECTRICAL DRAWINGS FOR LOCATIONS.
16. LIGHT FIXTURES ON RCP ARE SHOWN FOR LOCATION ONLY. SEE ELECTRICAL DRAWINGS SHEETS E2.00 - E2.09 FOR LIGHTING FIXTURE TYPES AND PROJECT MANUAL FOR LIGHTING SPECIFICATION CUT SHEETS.
17. SEE MECHANICAL AND ELECTRICAL DRAWINGS FOR ADDITIONAL DEVICES AND FIXTURES NOT INDICATED.
18. CEILING TILES SHALL NOT BE CUT LESS THAN 6".
19. SEE A10 SERIES FOR CEILING DETAILS.
20. SEE REFLECTED CEILING PLAN SHEET SERIES A4.01 - A4.04 FOR WINDOW ROLLER SHADE LOCATIONS AT EXTERIOR WINDOWS, SH-1 SUNSHADE, U.O.N.
21. ALL GYP. CEILINGS TO BE PAINTED PT-1, FLAT FINISH, U.O.N.; ALL GYP. CEILINGS IN EASILY CLEANABLE ROOMS (SOILED UTILITY, EVS, WASTE HOLDING, SCRUB ALCOVES, SHOWERS (ROOMS), TO BE PAINTED PT-13.
22. ALL GYP. CEILINGS TO BE PAINTED THE SAME COLOR ON UNDERSIDE AND EDGE(S) OF SOFFIT, U.O.N.
23. ALL CEILING ACCESS DOORS AT GYPSUM BOARD CEILING SHALL BE FLUSH DOOR WITH DRYWALL BEAD.
24. EXAM ROOM UPPER CABINETS TO HAVE UNDERCABINET LIGHTING, TYP., U.O.N. SEE A3.03E

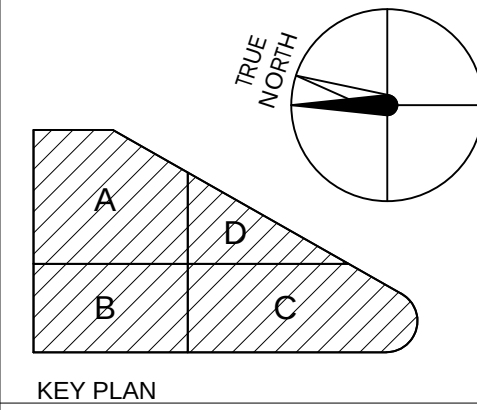

KEY PLAN

Stanford
HEALTH CARE
STANFORD MEDICINE
HENSEL PHELPS
Plan. Build. Manage.
K M D ARCHITECTS
ARCHITECTURE PLANNING
222 WILLOW ST. SAN FRANCISCO, CA 94101
(415) 398-5151 FAX (415) 394-7150

NO.	DATE	ISSUED FOR
1	2016/01/04	RESPONSE TO PLAN REVIEW
2	2016/01/24	DP #2 - 10% CD PACKAGE
3	2016/02/23	DP #2 - 50% CD PACKAGE
4	2016/09/18	DESIGN DEVELOPMENT
5	2016/07/31	DP #2 (50% CD) COORDINATION

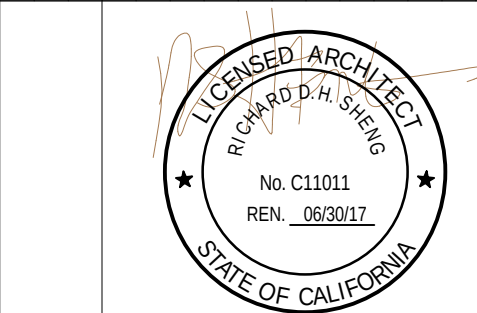


CERTIFIED BY
STANFORD HEALTH CENTER EMERYVILLE
5800 HOLLISS STREET
EMERYVILLE, CA 94608


PLAN CHECK#
PROJECT NO.
106-201
DATE

ENLARGED REFLECTED
CEILING - LEVEL 1 SECTOR D

A4.01D

1 ENLARGED RCP - LEVEL 1 SECTOR D
SCALE 1/4" = 1'-0"

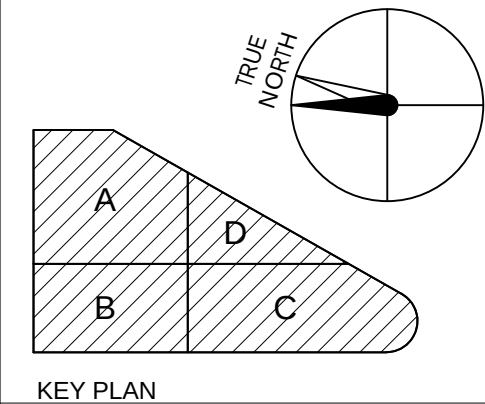

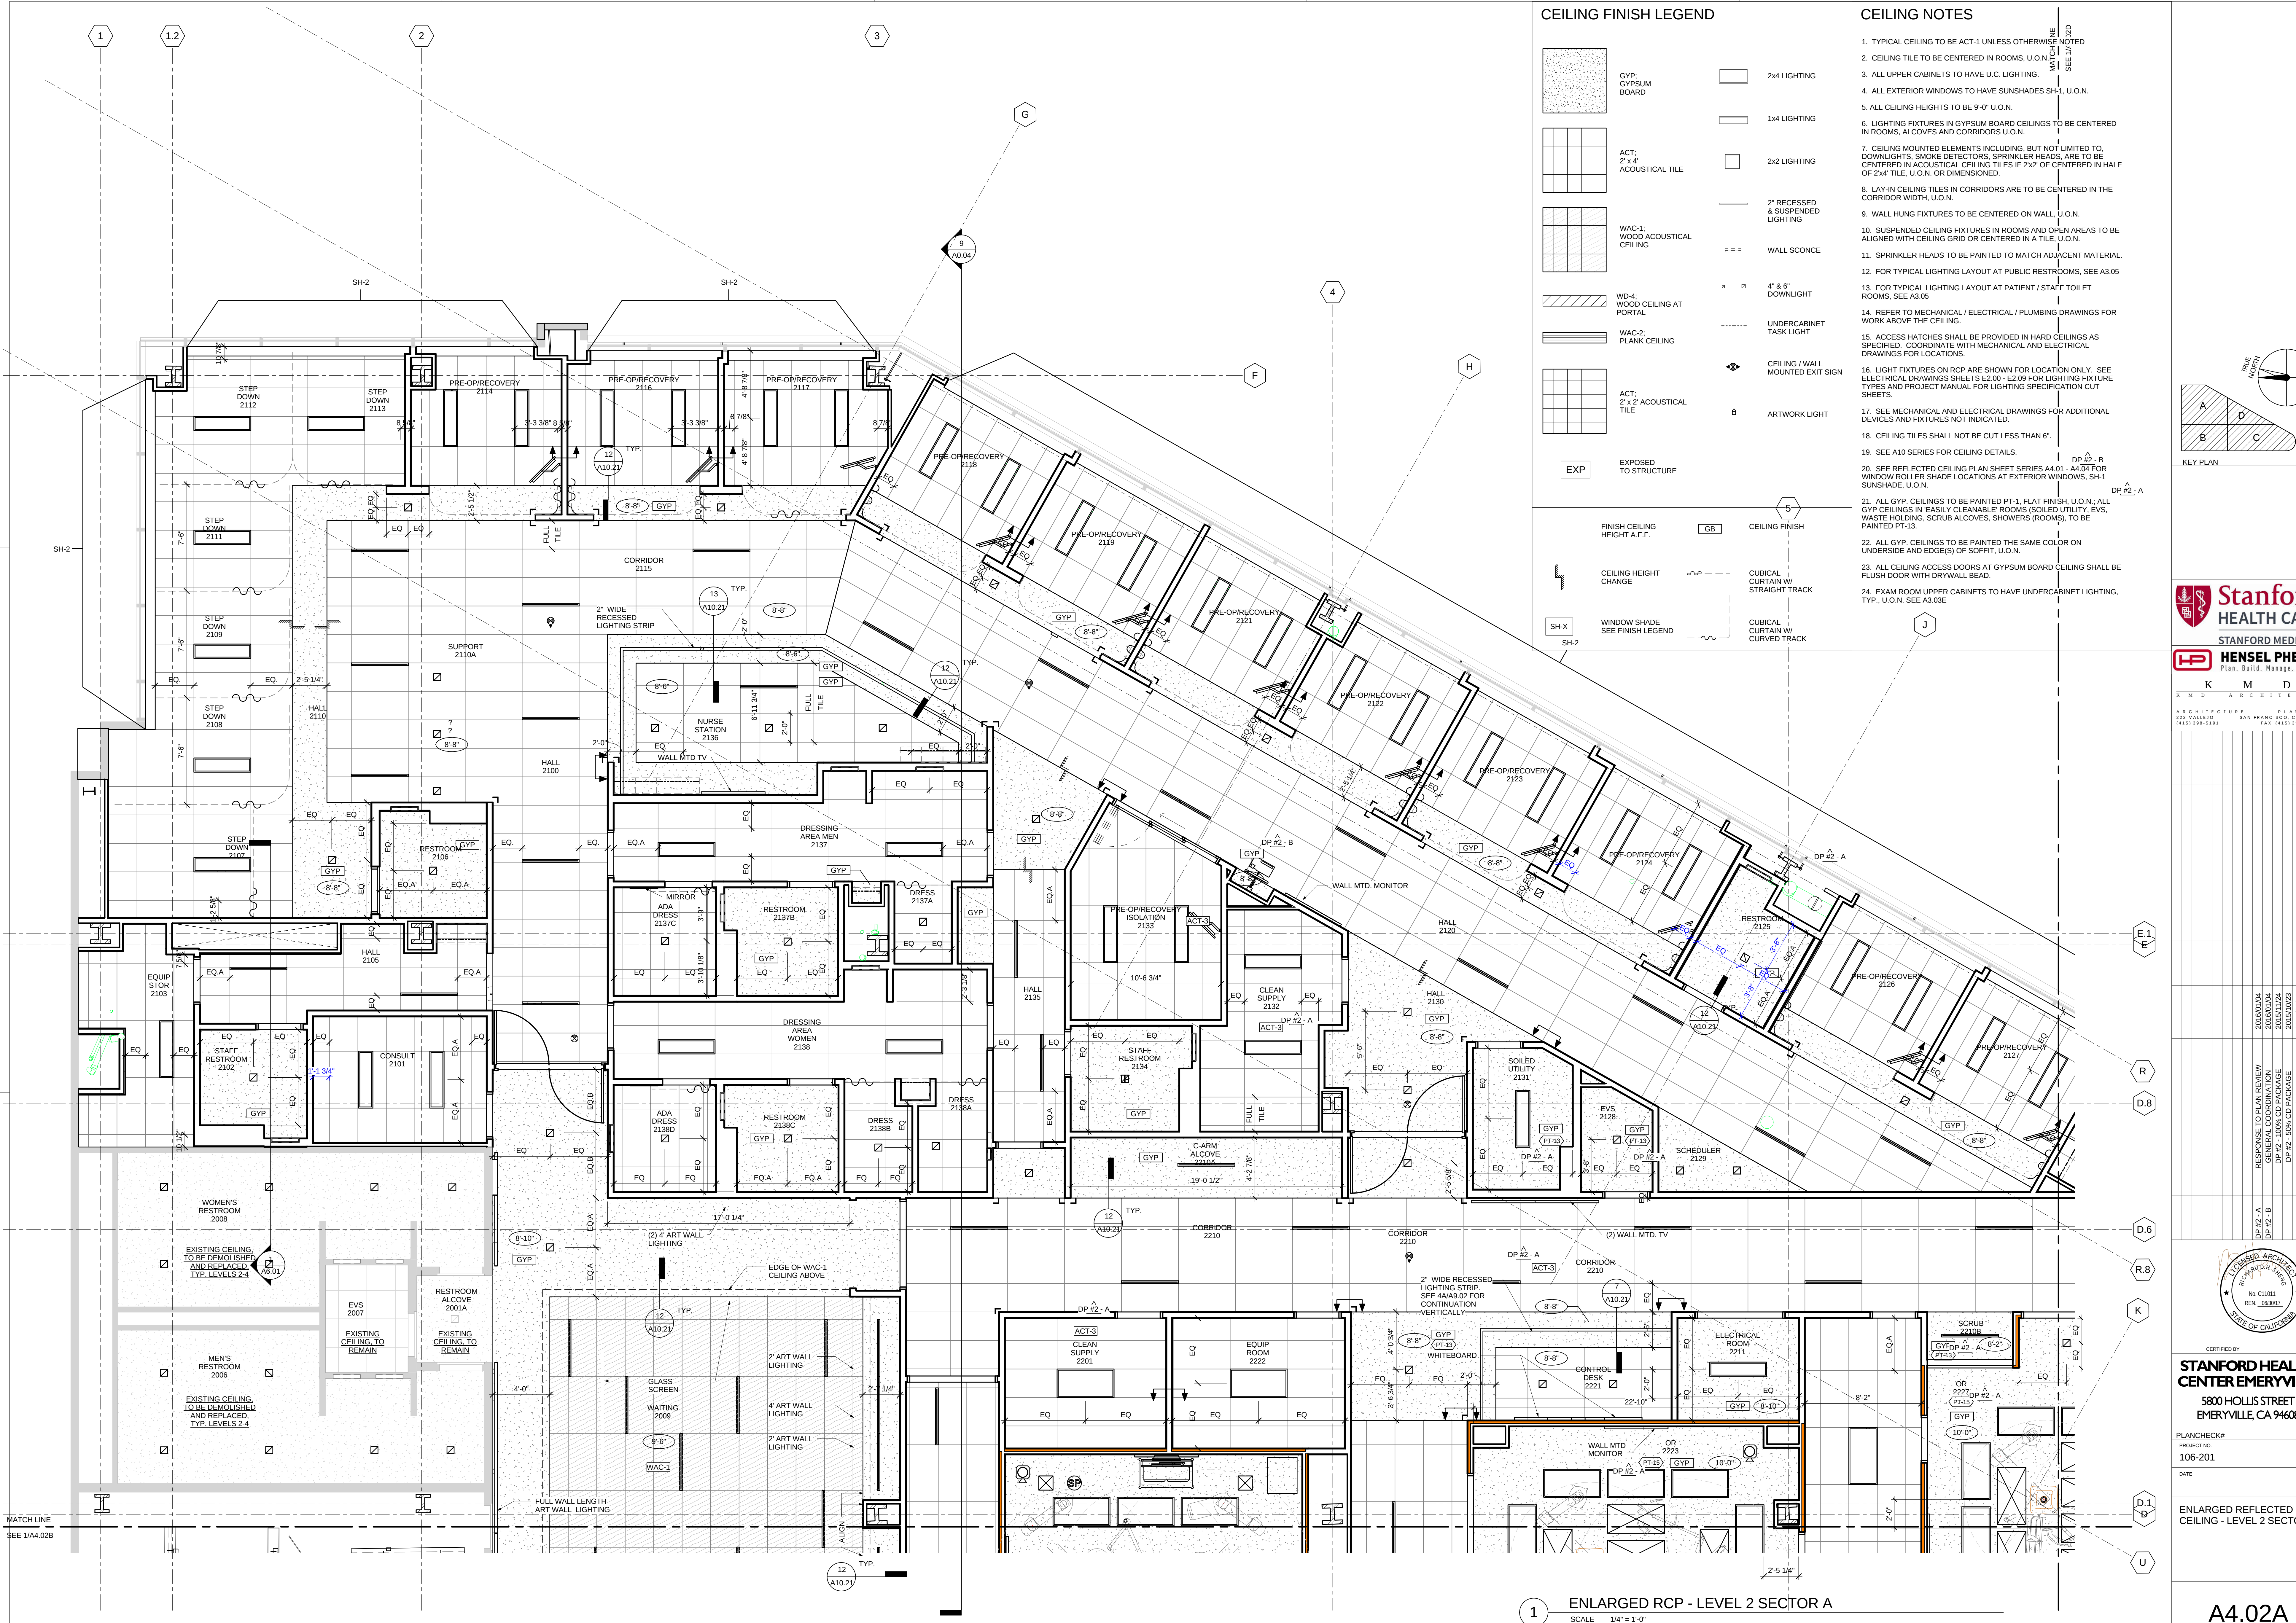


CEILING FINISH LEGEND

	GYP: GYPSUM BOARD		2x4 LIGHTING
	ACT: 2' x 4' ACOUSTICAL TILE		1x4 LIGHTING
	WAC-1: WOOD ACOUSTICAL CEILING		2x2 LIGHTING
	WD-4: WOOD CEILING AT PORTAL		2\"/>
	WAC-2: PLANK CEILING		WALL SCONCE
	EXP: EXPOSED TO STRUCTURE		4\"/>
	SH-X: WINDOW SHADE SEE FINISH LEGEND		UNDERCABINET TASK LIGHT
			CEILING / WALL MOUNTED EXIT SIGN
			ARTWORK LIGHT
			CEILING FINISH
			CUBICAL CURTAIN W/ STRAIGHT TRACK
			CUBICAL CURTAIN W/ CURVED TRACK

CEILING NOTES


1. TYPICAL CEILING TO BE ACT-1 UNLESS OTHERWISE NOTED.
2. CEILING TILE TO BE CENTERED IN ROOMS, U.O.N. SEE 1/4\"/>
3. ALL UPPER CABINETS TO HAVE U.C. LIGHTING.
4. ALL EXTERIOR WINDOWS TO HAVE SUNSHADES SH-2, U.O.N.
5. ALL CEILING HEIGHTS TO BE 9'-0\"/>
6. LIGHTING FIXTURES IN GYPSUM BOARD CEILINGS TO BE CENTERED IN ROOMS, ALCOVES AND CORRIDORS U.O.N.
7. CEILING MOUNTED ELEMENTS INCLUDING, BUT NOT LIMITED TO, DOWNLIGHTS, SMOKE DETECTORS, SPRINKLER HEADS, ARE TO BE CENTERED IN ACOUSTICAL CEILING TILES IF 2'x2' OF CENTERED IN HALF OF 2'x4' TILE, U.O.N. OR DIMENSIONED.
8. LAY-IN CEILING TILES IN CORRIDORS ARE TO BE CENTERED IN THE CORRIDOR WIDTH, U.O.N.
9. WALL HUNG FIXTURES TO BE CENTERED ON WALL, U.O.N.
10. SUSPENDED CEILING FIXTURES IN ROOMS AND OPEN AREAS TO BE ALIGNED WITH CEILING GRID OR CENTERED IN A TILE, U.O.N.
11. SPRINKLER HEADS TO BE PAINTED TO MATCH ADJACENT MATERIAL.
12. FOR TYPICAL LIGHTING LAYOUT AT PUBLIC RESTROOMS, SEE A3.05
13. FOR TYPICAL LIGHTING LAYOUT AT PATIENT / STAFF TOILET ROOMS, SEE A3.05
14. REFER TO MECHANICAL / ELECTRICAL / PLUMBING DRAWINGS FOR WORK ABOVE THE CEILING.
15. ACCESS HATCHES SHALL BE PROVIDED IN HARD CEILINGS AS SPECIFIED. COORDINATE WITH MECHANICAL AND ELECTRICAL DRAWINGS FOR LOCATIONS.
16. LIGHT FIXTURES ON RCP ARE SHOWN FOR LOCATION ONLY. SEE ELECTRICAL DRAWINGS SHEETS E2.00 - E2.09 FOR LIGHTING FIXTURE TYPES AND PROJECT MANUAL FOR LIGHTING SPECIFICATION CUT SHEETS.
17. SEE MECHANICAL AND ELECTRICAL DRAWINGS FOR ADDITIONAL DEVICES AND FIXTURES NOT INDICATED.
18. CEILING TILES SHALL NOT BE CUT LESS THAN 6\"/>
19. SEE A10 SERIES FOR CEILING DETAILS.
20. SEE REFLECTED CEILING PLAN SHEET SERIES A4.01 - A4.04 FOR WINDOW ROLLER SHADE LOCATIONS AT EXTERIOR WINDOWS, SH-1 SUNSHADE, U.O.N.
21. ALL GYP. CEILINGS TO BE PAINTED PT-1, FLAT FINISH, U.O.N.; ALL GYP. CEILINGS IN EASILY CLEANABLE ROOMS (SOILED UTILITY, EVS, WASTE HOLDING, SCRUB ALCOVES, SHOWERS (ROOMS), TO BE PAINTED PT-13.
22. ALL GYP. CEILINGS TO BE PAINTED THE SAME COLOR ON UNDERSIDE AND EDGE(S) OF SOFFIT, U.O.N.
23. ALL CEILING ACCESS DOORS AT GYPSUM BOARD CEILING SHALL BE FLUSH DOOR WITH DRYWALL BEAD.
24. EXAM ROOM UPPER CABINETS TO HAVE UNDERCABINET LIGHTING, TYP., U.O.N. SEE A3.03E

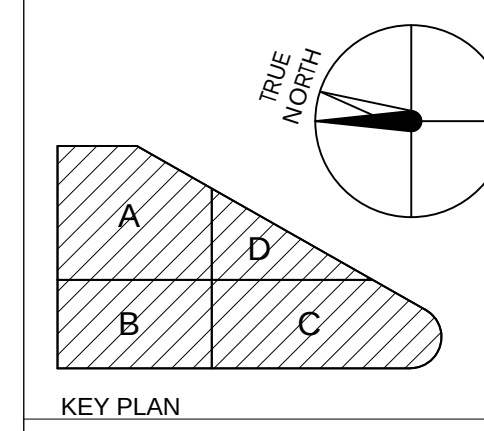

Stanford HEALTH CARE
STANFORD MEDICINE
HENSEL PHELPS
Plan. Build. Manage.
K M D ARCHITECTS
ARCHITECTURE PLANNING
222 WALL ST. SAN FRANCISCO, CA 94101
(415) 398-9131 FAX (415) 394-7158


NO.	DATE	ISSUED FOR
2016/01/04	RESPONSE TO PLAN REVIEW	
2016/01/04	DP #2 - A	
2016/01/04	DP #2 - B	
2016/01/04	DP #2 - C	
2016/01/04	DP #2 - D	
2016/01/04	DP #2 - E	
2016/01/04	DP #2 - F	
2016/01/04	DP #2 - G	
2016/01/04	DP #2 - H	
2016/01/04	DP #2 - I	
2016/01/04	DP #2 - J	
2016/01/04	DP #2 - K	
2016/01/04	DP #2 - L	
2016/01/04	DP #2 - M	
2016/01/04	DP #2 - N	
2016/01/04	DP #2 - O	
2016/01/04	DP #2 - P	
2016/01/04	DP #2 - Q	
2016/01/04	DP #2 - R	
2016/01/04	DP #2 - S	
2016/01/04	DP #2 - T	
2016/01/04	DP #2 - U	
2016/01/04	DP #2 - V	
2016/01/04	DP #2 - W	
2016/01/04	DP #2 - X	
2016/01/04	DP #2 - Y	
2016/01/04	DP #2 - Z	

STANFORD HEALTH CARE
CENTER EMERYVILLE
5800 HOLLS STREET
EMERYVILLE, CA 94608
PROJECT NO. 106-201
DATE
ENLARGED REFLECTED CEILING - LEVEL 2 SECTOR A
A4.02A

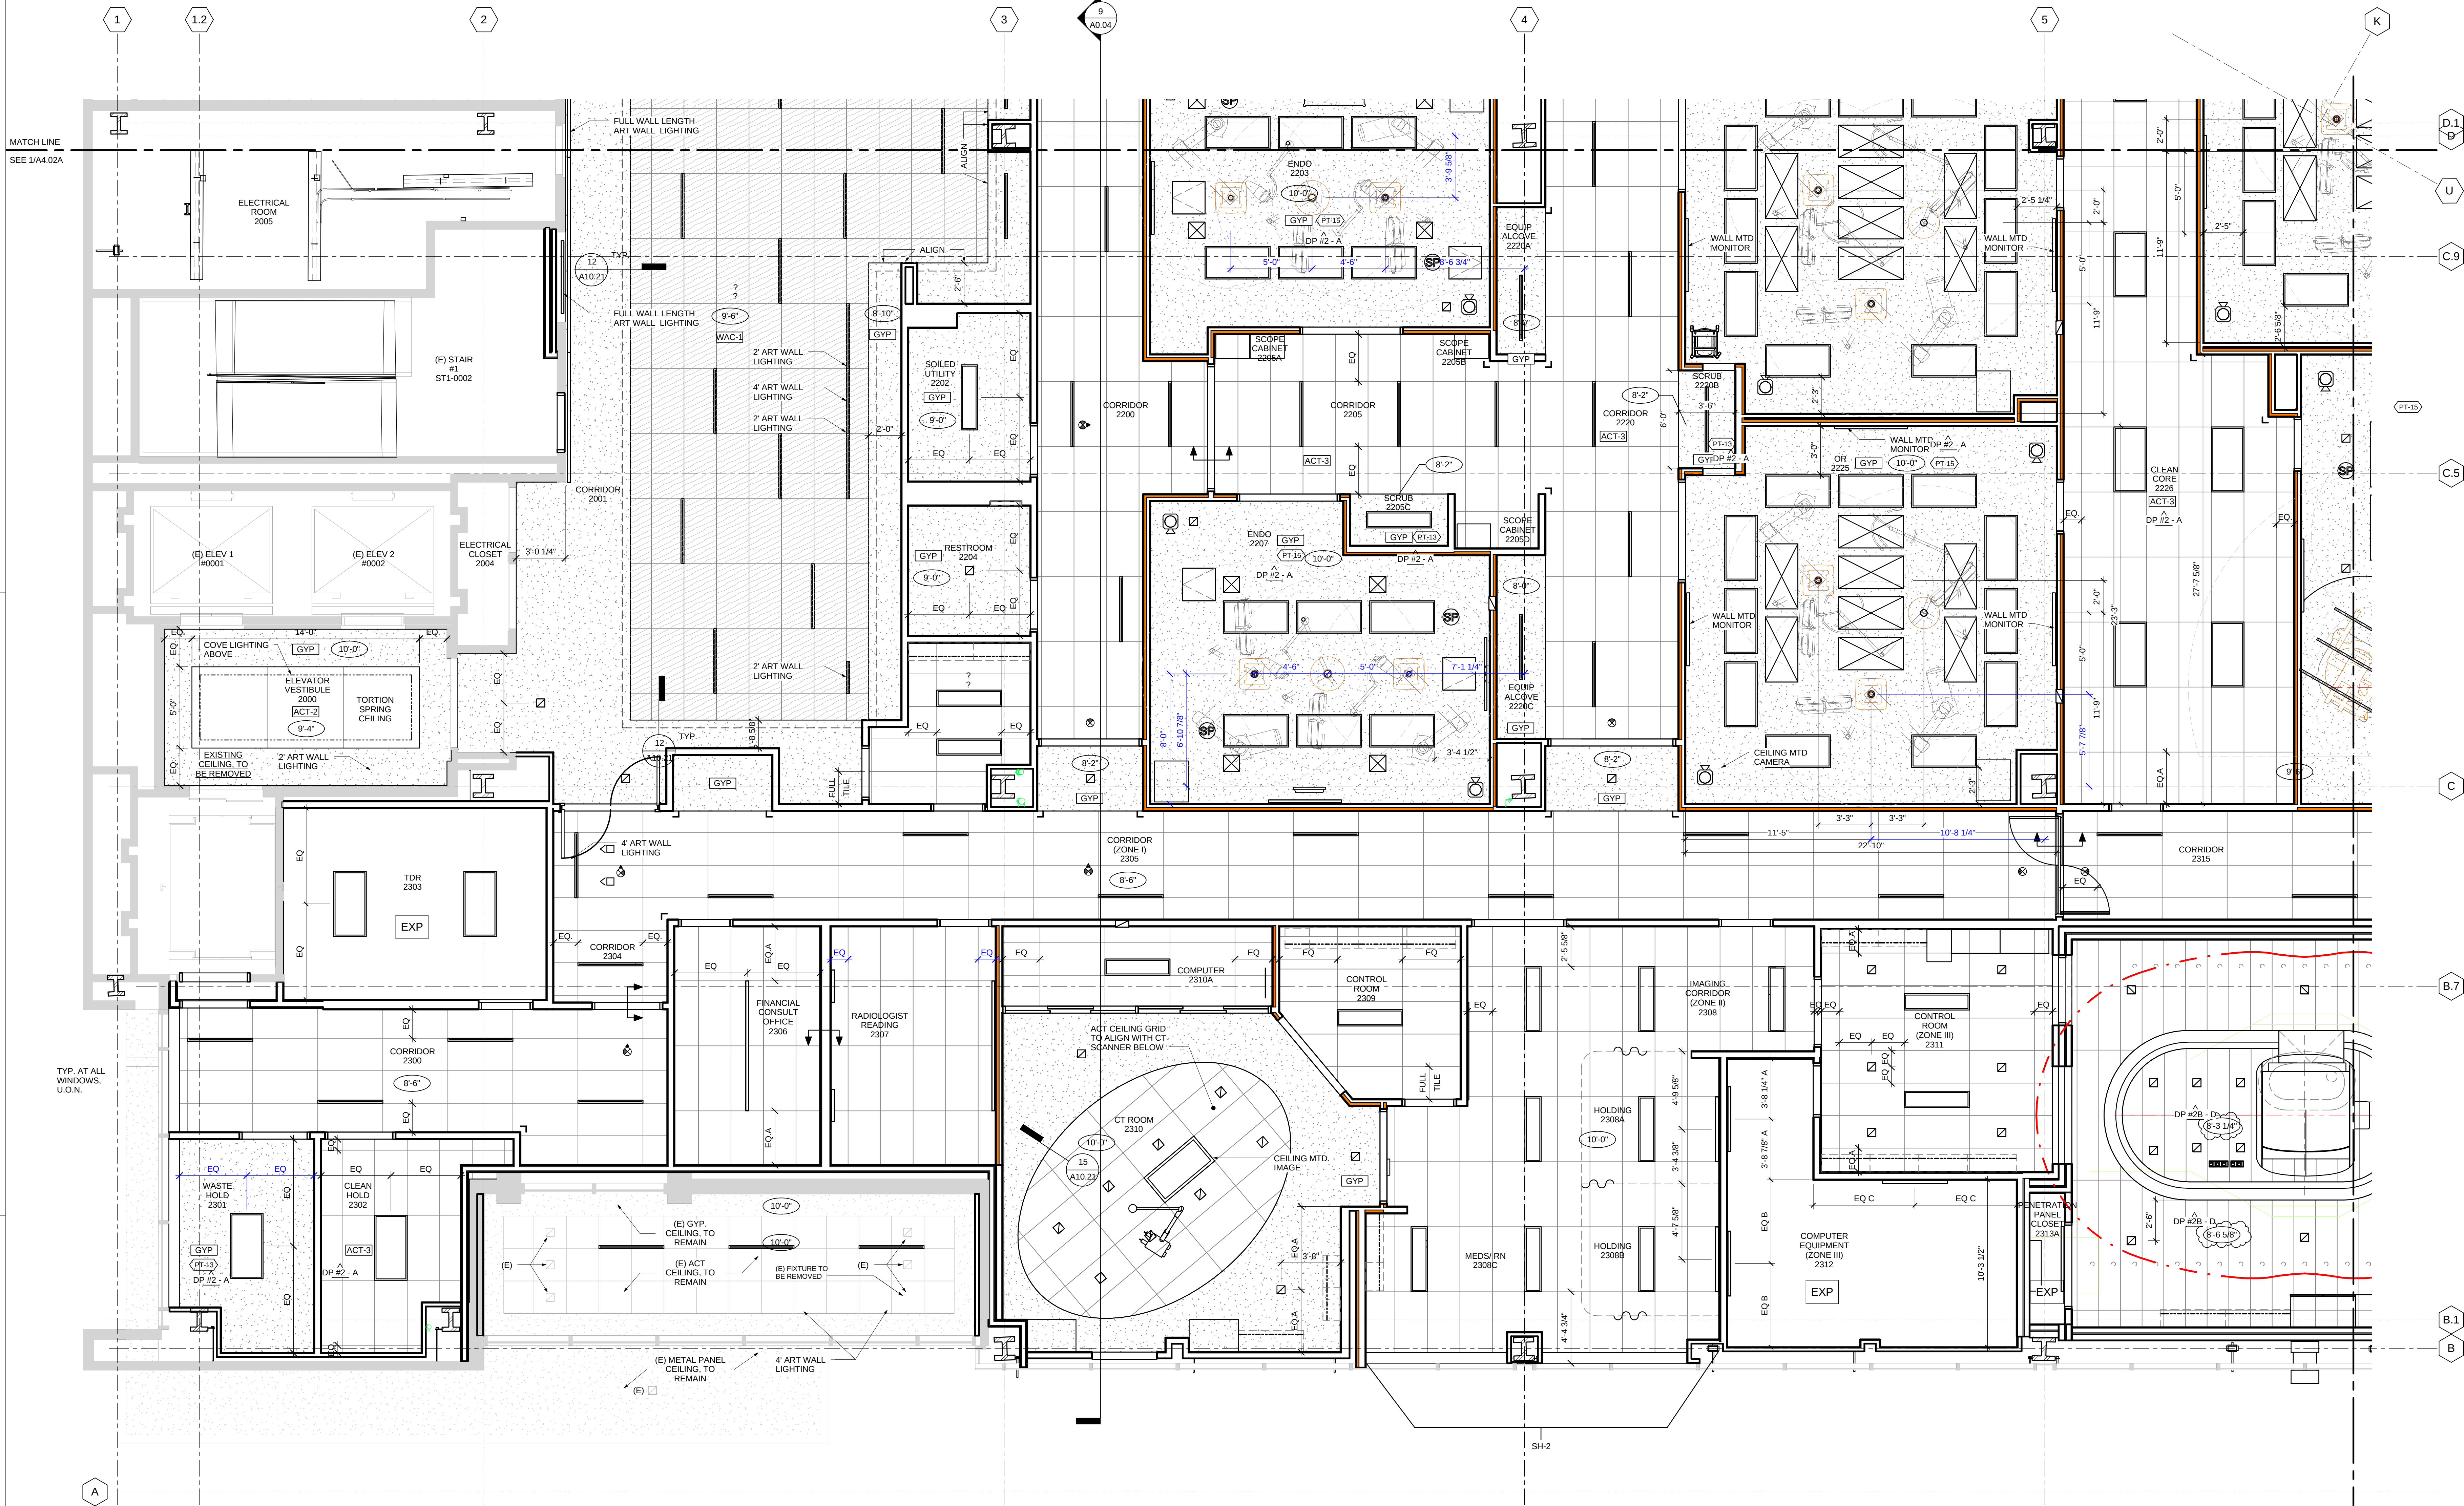

CEILING NOTES

1. TYPICAL CEILING TO BE ACT-1 UNLESS OTHERWISE NOTED
2. CEILING TILE TO BE CENTERED IN ROOMS, U.O.N.
3. ALL UPPER CABINETS TO HAVE U.C. LIGHTING.
4. ALL EXTERIOR WINDOWS TO HAVE SUNSHADES SH-1, U.O.N.
5. ALL CEILING HEIGHTS TO BE 9'-0" U.O.N.
6. LIGHTING FIXTURES IN GYPSUM BOARD CEILINGS TO BE CENTERED IN ROOMS, ALCOVES AND CORRIDORS U.O.N.
7. CEILING MOUNTED ELEMENTS INCLUDING, BUT NOT LIMITED TO, DOWNLIGHTS, SMOKE DETECTORS, SPRINKLER HEADS, ARE TO BE CENTERED IN ACOUSTICAL CEILING TILES IF 2'x2' OF CENTERED IN HALF OF 2'x4' TILE, U.O.N. OR DIMENSIONED.
8. LAY-IN CEILING TILES IN CORRIDORS ARE TO BE CENTERED IN THE CORRIDOR WIDTH, U.O.N.
9. WALL HUNG FIXTURES TO BE CENTERED ON WALL, U.O.N.
10. SUSPENDED CEILING FIXTURES IN ROOMS AND OPEN AREAS TO BE ALIGNED WITH CEILING GRID OR CENTERED IN A TILE, U.O.N.
11. SPRINKLER HEADS TO BE PAINTED TO MATCH ADJACENT MATERIAL.
12. FOR TYPICAL LIGHTING LAYOUT AT PUBLIC RESTROOMS, SEE A3.05
13. FOR TYPICAL LIGHTING LAYOUT AT PATIENT / STAFF TOILET ROOMS, SEE A3.05
14. REFER TO MECHANICAL / ELECTRICAL / PLUMBING DRAWINGS FOR WORK ABOVE THE CEILING.
15. ACCESS HATCHES SHALL BE PROVIDED IN HARD CEILINGS AS SPECIFIED. COORDINATE WITH MECHANICAL AND ELECTRICAL DRAWINGS FOR LOCATIONS.
16. LIGHT FIXTURES ON RCP ARE SHOWN FOR LOCATION ONLY. SEE ELECTRICAL DRAWINGS SHEETS E2.00 - E2.09 FOR LIGHTING FIXTURE TYPES AND PROJECT MANUAL FOR LIGHTING SPECIFICATION CUT SHEETS.
17. SEE MECHANICAL AND ELECTRICAL DRAWINGS FOR ADDITIONAL DEVICES AND FIXTURES NOT INDICATED.
18. CEILING TILES SHALL NOT BE CUT LESS THAN 6".
19. SEE A3.01 SERIES FOR CEILING DETAILS.
20. SEE REFLECTED CEILING PLAN SHEET SERIES A4.01 - A4.09 FOR WINDOW ROLLER SHADE LOCATIONS AT EXTERIOR WINDOWS, SH-1 SUNSHADE, U.O.N.
21. ALL GYP. CEILINGS TO BE PAINTED PT-1, FLAT FINISH, U.O.N.; ALL GYP CEILINGS IN "EASILY CLEANABLE" ROOMS (SOILED UTILITY; EVS, WASTE HOLDING, SCRUB ALCOVES, SHOWERS (ROOMS), TO BE PAINTED PT-13.
22. ALL GYP. CEILINGS TO BE PAINTED THE SAME COLOR ON UNDERSIDE AND EDGE(S) OF SOFFIT, U.O.N.
23. ALL CEILING ACCESS DOORS AT GYPSUM BOARD CEILING SHALL BE FLUSH DOOR WITH DRYWALL BEAD.
24. EXAM ROOM UPPER CABINETS TO HAVE UNDERCABINET LIGHTING, TYP., U.O.N. SEE A3.03E

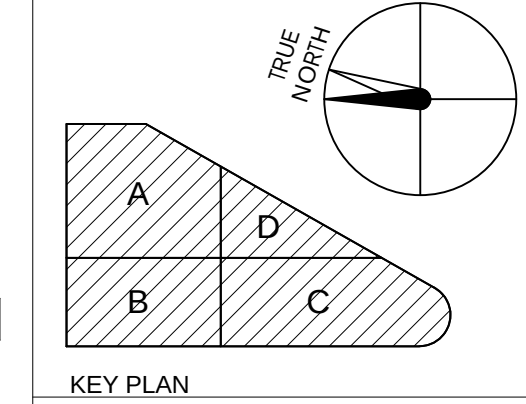

KEY PLAN


Stanford
HEALTH CARE

STANFORD MEDICINE
HENSEL PHELPS
Plan. Build. Manage.

K M D
ARCHITECTS

ARCHITECTURE PLANNING
122 WALL ST. SAN FRANCISCO, CA 94102
(415) 398-9131 FAX (415) 394-7158

NO.	DATE	ISSUED FOR
2016/01/29		MRI COORDINATION
2016/01/29		DESIGN DEVELOPMENT
2016/01/29		DP #2 - 10% CD PACKAGE
2016/01/29		DP #2 - 50% CD PACKAGE
2016/01/29		DESIGN DEVELOPMENT
2016/01/29		DP #2 (50% CD) COORDINATION

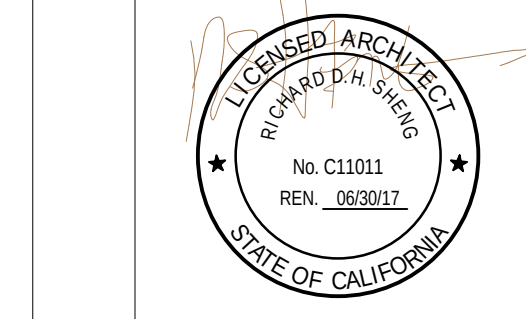

CERTIFIED BY
STANFORD HEALTH
CENTER EMERYVILLE
5800 HOLLIS STREET
EMERYVILLE, CA 94608

PLANCHHECK#
PROJECT NO.
106-201
DATE

ENLARGED REFLECTED
CEILING - LEVEL 2 SECTOR B


1 ENLARGED RCP - LEVEL 2 SECTOR B
SCALE 1/4" = 1'-0"

A4.02B




CEILING NOTES

1. TYPICAL CEILING TO BE ACT-1 UNLESS OTHERWISE NOTED
2. CEILING TILE TO BE CENTERED IN ROOMS, U.O.N.
3. ALL UPPER CABINETS TO HAVE U.C. LIGHTING.
4. ALL EXTERIOR WINDOWS TO HAVE SUNSHADES SH-1, U.O.N.
5. ALL CEILING HEIGHTS TO BE 9'-0" U.O.N.
6. LIGHTING FIXTURES IN GYPSUM BOARD CEILINGS TO BE CENTERED IN ROOMS, ALCOVES AND CORRIDORS U.O.N.
7. CEILING MOUNTED ELEMENTS INCLUDING, BUT NOT LIMITED TO, DOWNLIGHTS, SMOKE DETECTORS, SPRINKLER HEADS, ARE TO BE CENTERED IN ACOUSTICAL CEILING TILES IF 2'x2' OF CENTERED IN HALF OF 2'x4' TILE, U.O.N. OR DIMENSIONED.
8. LAY-IN CEILING TILES IN CORRIDORS ARE TO BE CENTERED IN THE CORRIDOR WIDTH, U.O.N.
9. WALL HUNG FIXTURES TO BE CENTERED ON WALL, U.O.N.
10. SUSPENDED CEILING FIXTURES IN ROOMS AND OPEN AREAS TO BE ALIGNED WITH CEILING GRID OR CENTERED IN A TILE, U.O.N.
11. SPRINKLER HEADS TO BE PAINTED TO MATCH ADJACENT MATERIAL.
12. FOR TYPICAL LIGHTING LAYOUT AT PUBLIC RESTROOMS, SEE A3.05
13. FOR TYPICAL LIGHTING LAYOUT AT PATIENT / STAFF TOILET ROOMS, SEE A3.05
14. REFER TO MECHANICAL / ELECTRICAL / PLUMBING DRAWINGS FOR WORK ABOVE THE CEILING.
15. ACCESS HATCHES SHALL BE PROVIDED IN HARD CEILINGS AS SPECIFIED. COORDINATE WITH MECHANICAL AND ELECTRICAL DRAWINGS FOR LOCATIONS.
16. LIGHT FIXTURES ON RCP ARE SHOWN FOR LOCATION ONLY. SEE ELECTRICAL DRAWINGS SHEETS E2.00 - E2.09 FOR LIGHTING FIXTURE TYPES AND PROJECT MANUAL FOR LIGHTING SPECIFICATION CUT SHEETS.
17. SEE MECHANICAL AND ELECTRICAL DRAWINGS FOR ADDITIONAL DEVICES AND FIXTURES NOT INDICATED.
18. CEILING TILES SHALL NOT BE CUT LESS THAN 6".
19. SEE A3.0 SERIES FOR CEILING DETAILS.
20. SEE REFLECTED CEILING PLAN SHEET SERIES A4.01 - A4.09 FOR WINDOW ROLLER SHADE LOCATIONS AT EXTERIOR WINDOWS, SH-1 SUNSHADE, U.O.N.
21. ALL GYP. CEILINGS TO BE PAINTED PT-1, FLAT FINISH, U.O.N.; ALL GYP CEILINGS IN "EASILY CLEANABLE" ROOMS (SOILED UTILITY, EVS, WASTE HOLDING, SCRUB ALCOVES, SHOWERS (ROOMS), TO BE PAINTED PT-13.
22. ALL GYP. CEILINGS TO BE PAINTED THE SAME COLOR ON UNDERSIDE AND EDGE(S) OF SOFFIT, U.O.N.
23. ALL CEILING ACCESS DOORS AT GYPSUM BOARD CEILING SHALL BE FLUSH DOOR WITH DRYWALL BEAD.
24. EXAM ROOM UPPER CABINETS TO HAVE UNDERCABINET LIGHTING, TYP., U.O.N. SEE A3.03E

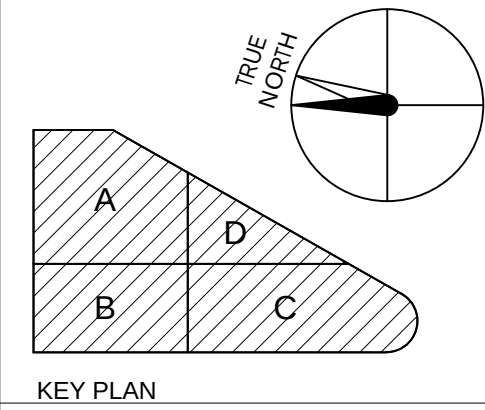

Stanford
HEALTH CARE
STANFORD MEDICINE
HENSEL PHELPS
Plan. Build. Manage.
K M D ARCHITECTS
ARCHITECTURE PLANNING
222 WILLOW SAN FRANCISCO, CA 94111
(415) 398-9131 FAX (415) 394-7158

	NO.	DATE
CHANGE ORDER #01	2016/04/04	
SFD UPDATES	2016/03/24	
MRI CEILING UPDATE	2016/03/23	
LIGHTING COORDINATION	2016/03/21	
RESEARCH REF STORAGE	2016/03/14	
DP #2 - 100% CD PACKAGE	2016/01/24	
DP #2 - 50% CD PACKAGE	2015/10/23	
DESIGN DEVELOPMENT	2015/09/18	
DP #2 (50% CD) COORDINATION	2015/07/31	
ISSUED FOR		



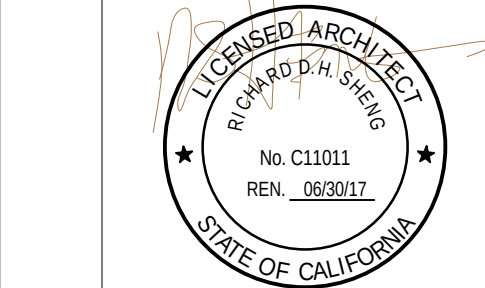


CERTIFIED BY
STANFORD HEALTH CENTER EMERYVILLE
5800 HOLLIS STREET
EMERYVILLE, CA 94608

PLANCHECK#
PROJECT NO.
106-201
DATE

ENLARGED REFLECTED
CEILING - LEVEL 2 SECTOR C

A4.02C

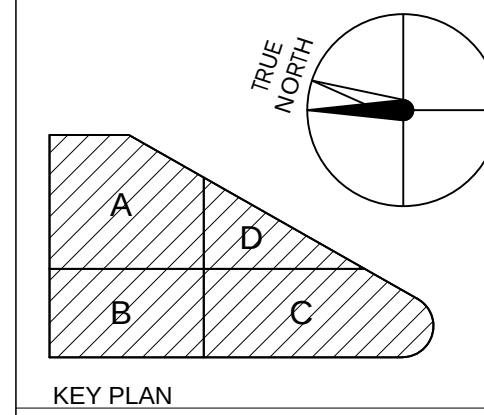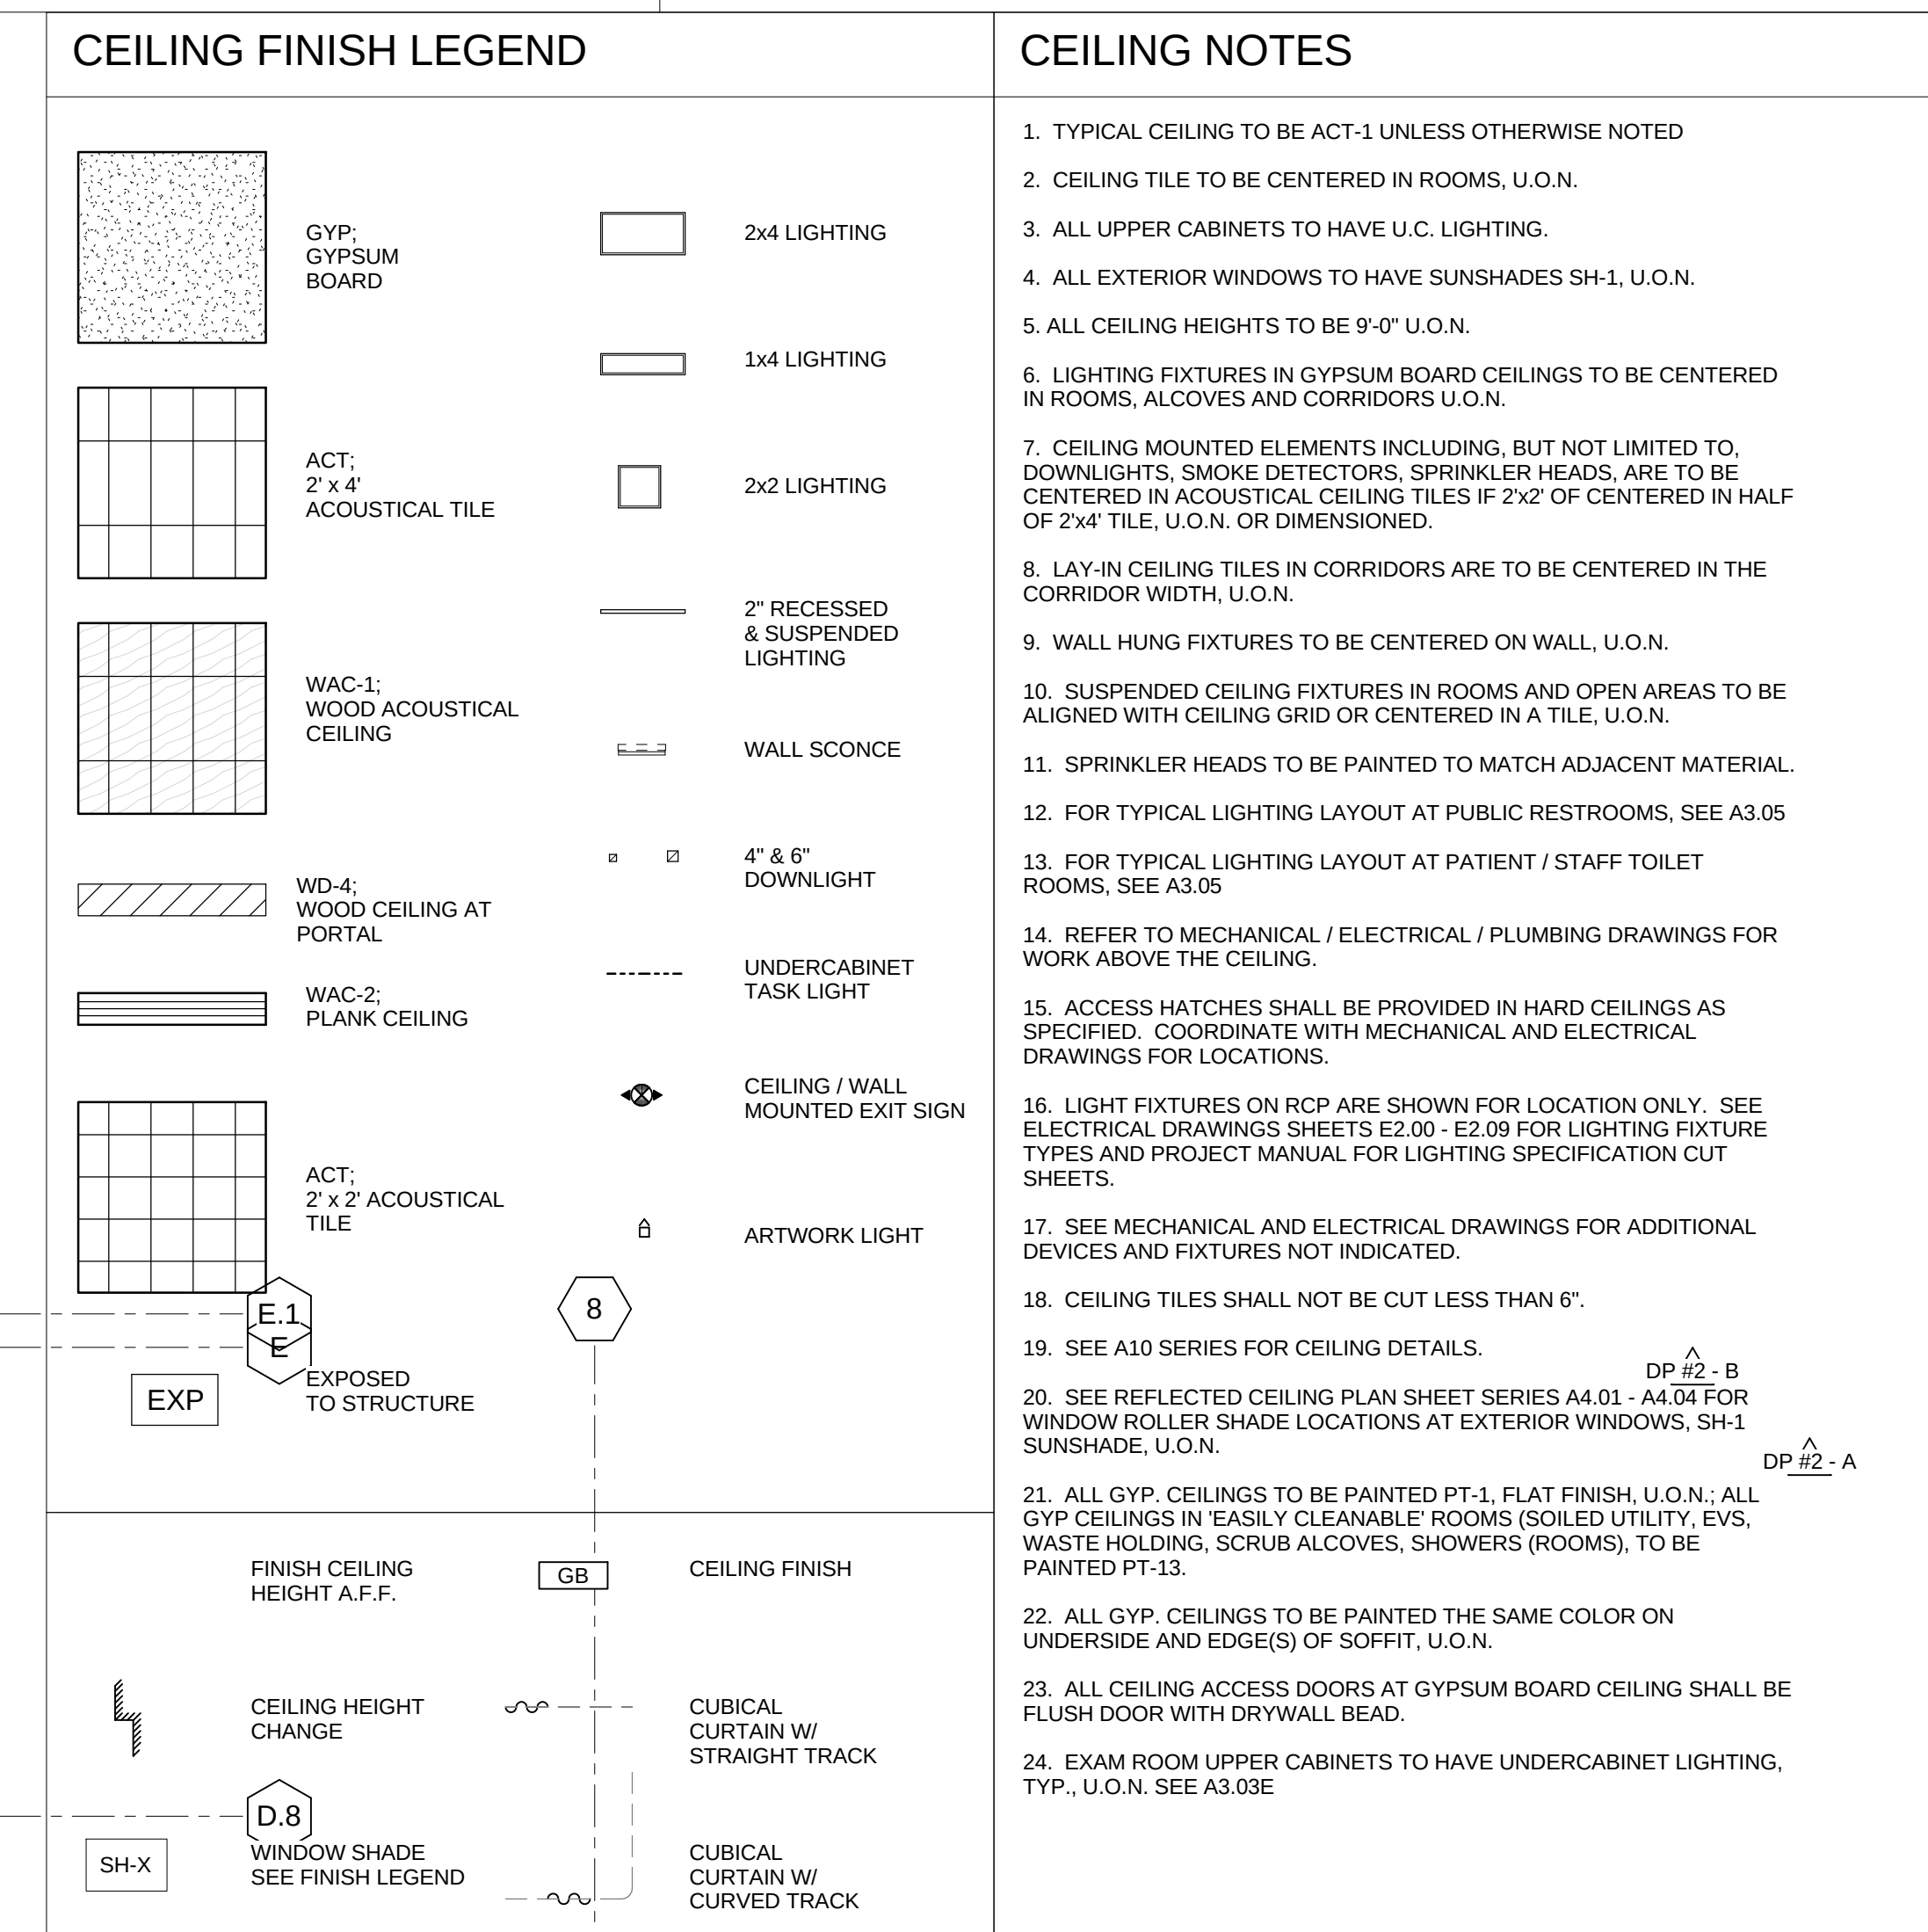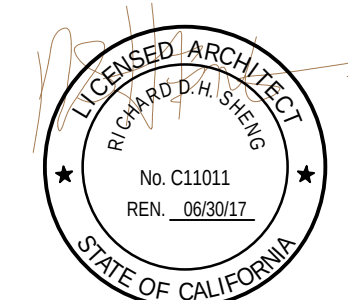[illegible]

CERTIFIED BY

**STANFORD HEALTH
CENTER EMERYVILLE**

5800 HOLLIS STREET
EMERYVILLE, CA 94608

PLANCHECK#
PROJECT NO. 106-201
DATE

ENLARGED REFLECTED
CEILING - LEVEL 2 SECTOR D

A4.02D




CEILING FINISH LEGEND

	GYP: GYPSUM BOARD		2x4 LIGHTING
	ACT: 2' x 4' ACOUSTICAL TILE		1x4 LIGHTING
	WAC-1: WOOD ACOUSTICAL CEILING		2' RECESSED & SUSPENDED LIGHTING
	WD-4: WOOD CEILING AT PORTAL		WALL SCONCE
	WD-4: WOOD CEILING AT PORTAL		4' & 6" DOWNLIGHT
	WAC-2: PLANK CEILING		UNDERCABINET TASK LIGHT
	ACT: 2' x 2' ACOUSTICAL TILE		CEILING / WALL MOUNTED EXHIBIT
	EXP EXPOSED TO STRUCTURE		ARTWORK LIGHTING

	FINISH CEILING HEIGHT A.F.F.		CEILING FINISH
	SH-X WINDOW SHADE SEE FINISH LEGEND		CUBICAL CURTAIN W/ STRAIGHT TRACK
			CUBICAL CURTAIN W/ CURVED TRACK


CEILING NOTES

1. TYPICAL CEILING TO BE ACT-1 UNLESS OTHERWISE NOTED
2. CEILING TILE TO BE CENTERED IN ROOMS, U.O.N.
3. ALL UPPER CABINETS TO HAVE U.C. LIGHTING.
4. ALL EXTERIOR WINDOWS TO HAVE SUNSHADES SH-1, U.O.N.
5. ALL CEILING HEIGHTS TO BE 9'-0" U.O.N.
6. LIGHTING FIXTURES IN GYPSUM BOARD CEILINGS TO BE CENTERED IN ROOMS, ALCOVES AND CORRIDORS U.O.N.
7. CEILING MOUNTED ELEMENTS INCLUDING, BUT NOT LIMITED TO, DOWNLIGHTS, SMOKE DETECTORS, SPRINKLER HEADS, ARE TO BE CENTERED IN ACOUSTICAL CEILING TILES IF 2'x2' OF CENTERED IN HALF OF 2'x4' TILE, U.O.N. OR DIMENSIONED.
8. LAY-IN CEILING TILES IN CORRIDORS ARE TO BE CENTERED IN THE CORRIDOR WIDTH, U.O.N.
9. WALL HUNG FIXTURES TO BE CENTERED ON WALL, U.O.N.
10. SUSPENDED CEILING FIXTURES IN ROOMS AND OPEN AREAS TO BE ALIGNED WITH CEILING GRID OR CENTERED IN A TILE, U.O.N.
11. SPRINKLER HEADS TO BE PAINTED TO MATCH ADJACENT MATERIAL.
12. FOR TYPICAL LIGHTING LAYOUT AT PUBLIC RESTROOMS, SEE A3.05
13. FOR TYPICAL LIGHTING LAYOUT AT PATIENT / STAFF TOILET ROOMS, SEE A3.05
14. REFER TO MECHANICAL / ELECTRICAL / PLUMBING DRAWINGS FOR WORK ABOVE THE CEILING.
15. ACCESS HATCHES SHALL BE PROVIDED IN HARD CEILINGS AS SPECIFIED. COORDINATE WITH MECHANICAL AND ELECTRICAL DRAWINGS FOR LOCATIONS.
16. LIGHT FIXTURES ON RCP ARE SHOWN FOR LOCATION ONLY. SEE ELECTRICAL DRAWINGS SHEETS E2.00 - E2.09 FOR LIGHTING FIXTURE TYPES AND PROJECT MANUAL FOR LIGHTING SPECIFICATION CUT SHEETS.
17. SEE MECHANICAL AND ELECTRICAL DRAWINGS FOR ADDITIONAL DEVICES AND FIXTURES NOT INDICATED.
18. CEILING TILES SHALL NOT BE CUT LESS THAN 6".
19. SEE A10 SERIES FOR CEILING DETAILS.
20. SEE REFLECTED CEILING PLAN SHEET SERIES A4.01 - A4.04 FOR WINDOW ROLLER SHADE LOCATIONS AT EXTERIOR WINDOWS, SH-1 SUNSHADE, U.O.N.
21. ALL GYP. CEILINGS TO BE PAINTED PT-1, FLAT FINISH, U.O.N.; ALL GYP. CEILINGS IN EASILY CLEANABLE ROOMS (SOILED UTILITY, EVS, WASTE HOLDING, SCRUB ALCOVES, SHOWERS (ROOMS), TO BE PAINTED PT-13.
22. ALL GYP. CEILINGS TO BE PAINTED THE SAME COLOR ON UNDERSIDE AND EDGE(S) OF SOFFIT, U.O.N.
23. ALL CEILING ACCESS DOORS AT GYPSUM BOARD CEILING SHALL BE FLUSH DOOR WITH DRYWALL BEAD.
24. EXAM ROOM UPPER CABINETS TO HAVE UNDERCABINET LIGHTING, TYP., U.O.N. SEE A3.03E

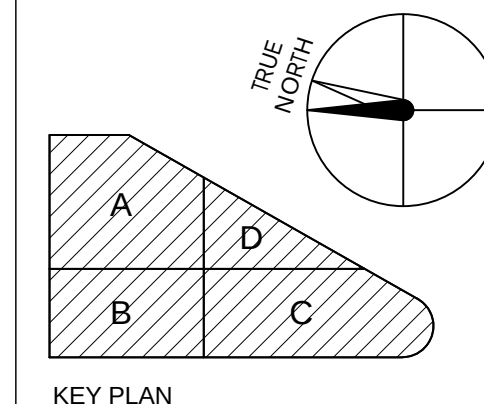

STANFORD HEALTH CARE
STANFORD MEDICINE
HENSEL PHELPS
K M D ARCHITECTS
ARCHITECTURE PLANNING
222 WILLOW STREET, SAN FRANCISCO, CA 94111
(415) 398-9131 FAX (415) 398-7158


NO.	DATE	ISSUED FOR
20160104	20160104	RESPONSE TO PLAN REVIEW
20160104	20160104	GENERAL COORDINATION
20160104	20160104	DP #2 - B
20160104	20160104	DP #2 - 50% CD PACKAGE
20160104	20160104	DESIGN DEVELOPMENT
20160104	20160104	BP #3 - ADDENDUM A
20160104	20160104	DP #2 (50% CD) COORDINATION

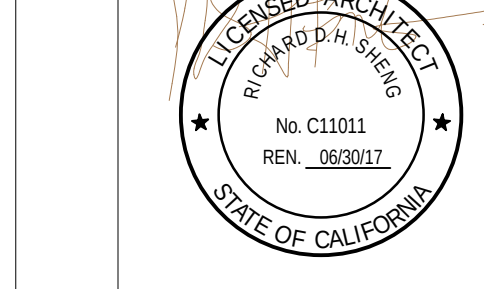

CERTIFIED BY
STANFORD HEALTH CARE
5800 HOLIS STREET
EMERYVILLE, CA 94608

PLAN CHECK#
PROJECT NO.
106-201
DATE

REFLECTED CEILING PLAN - LEVEL 3

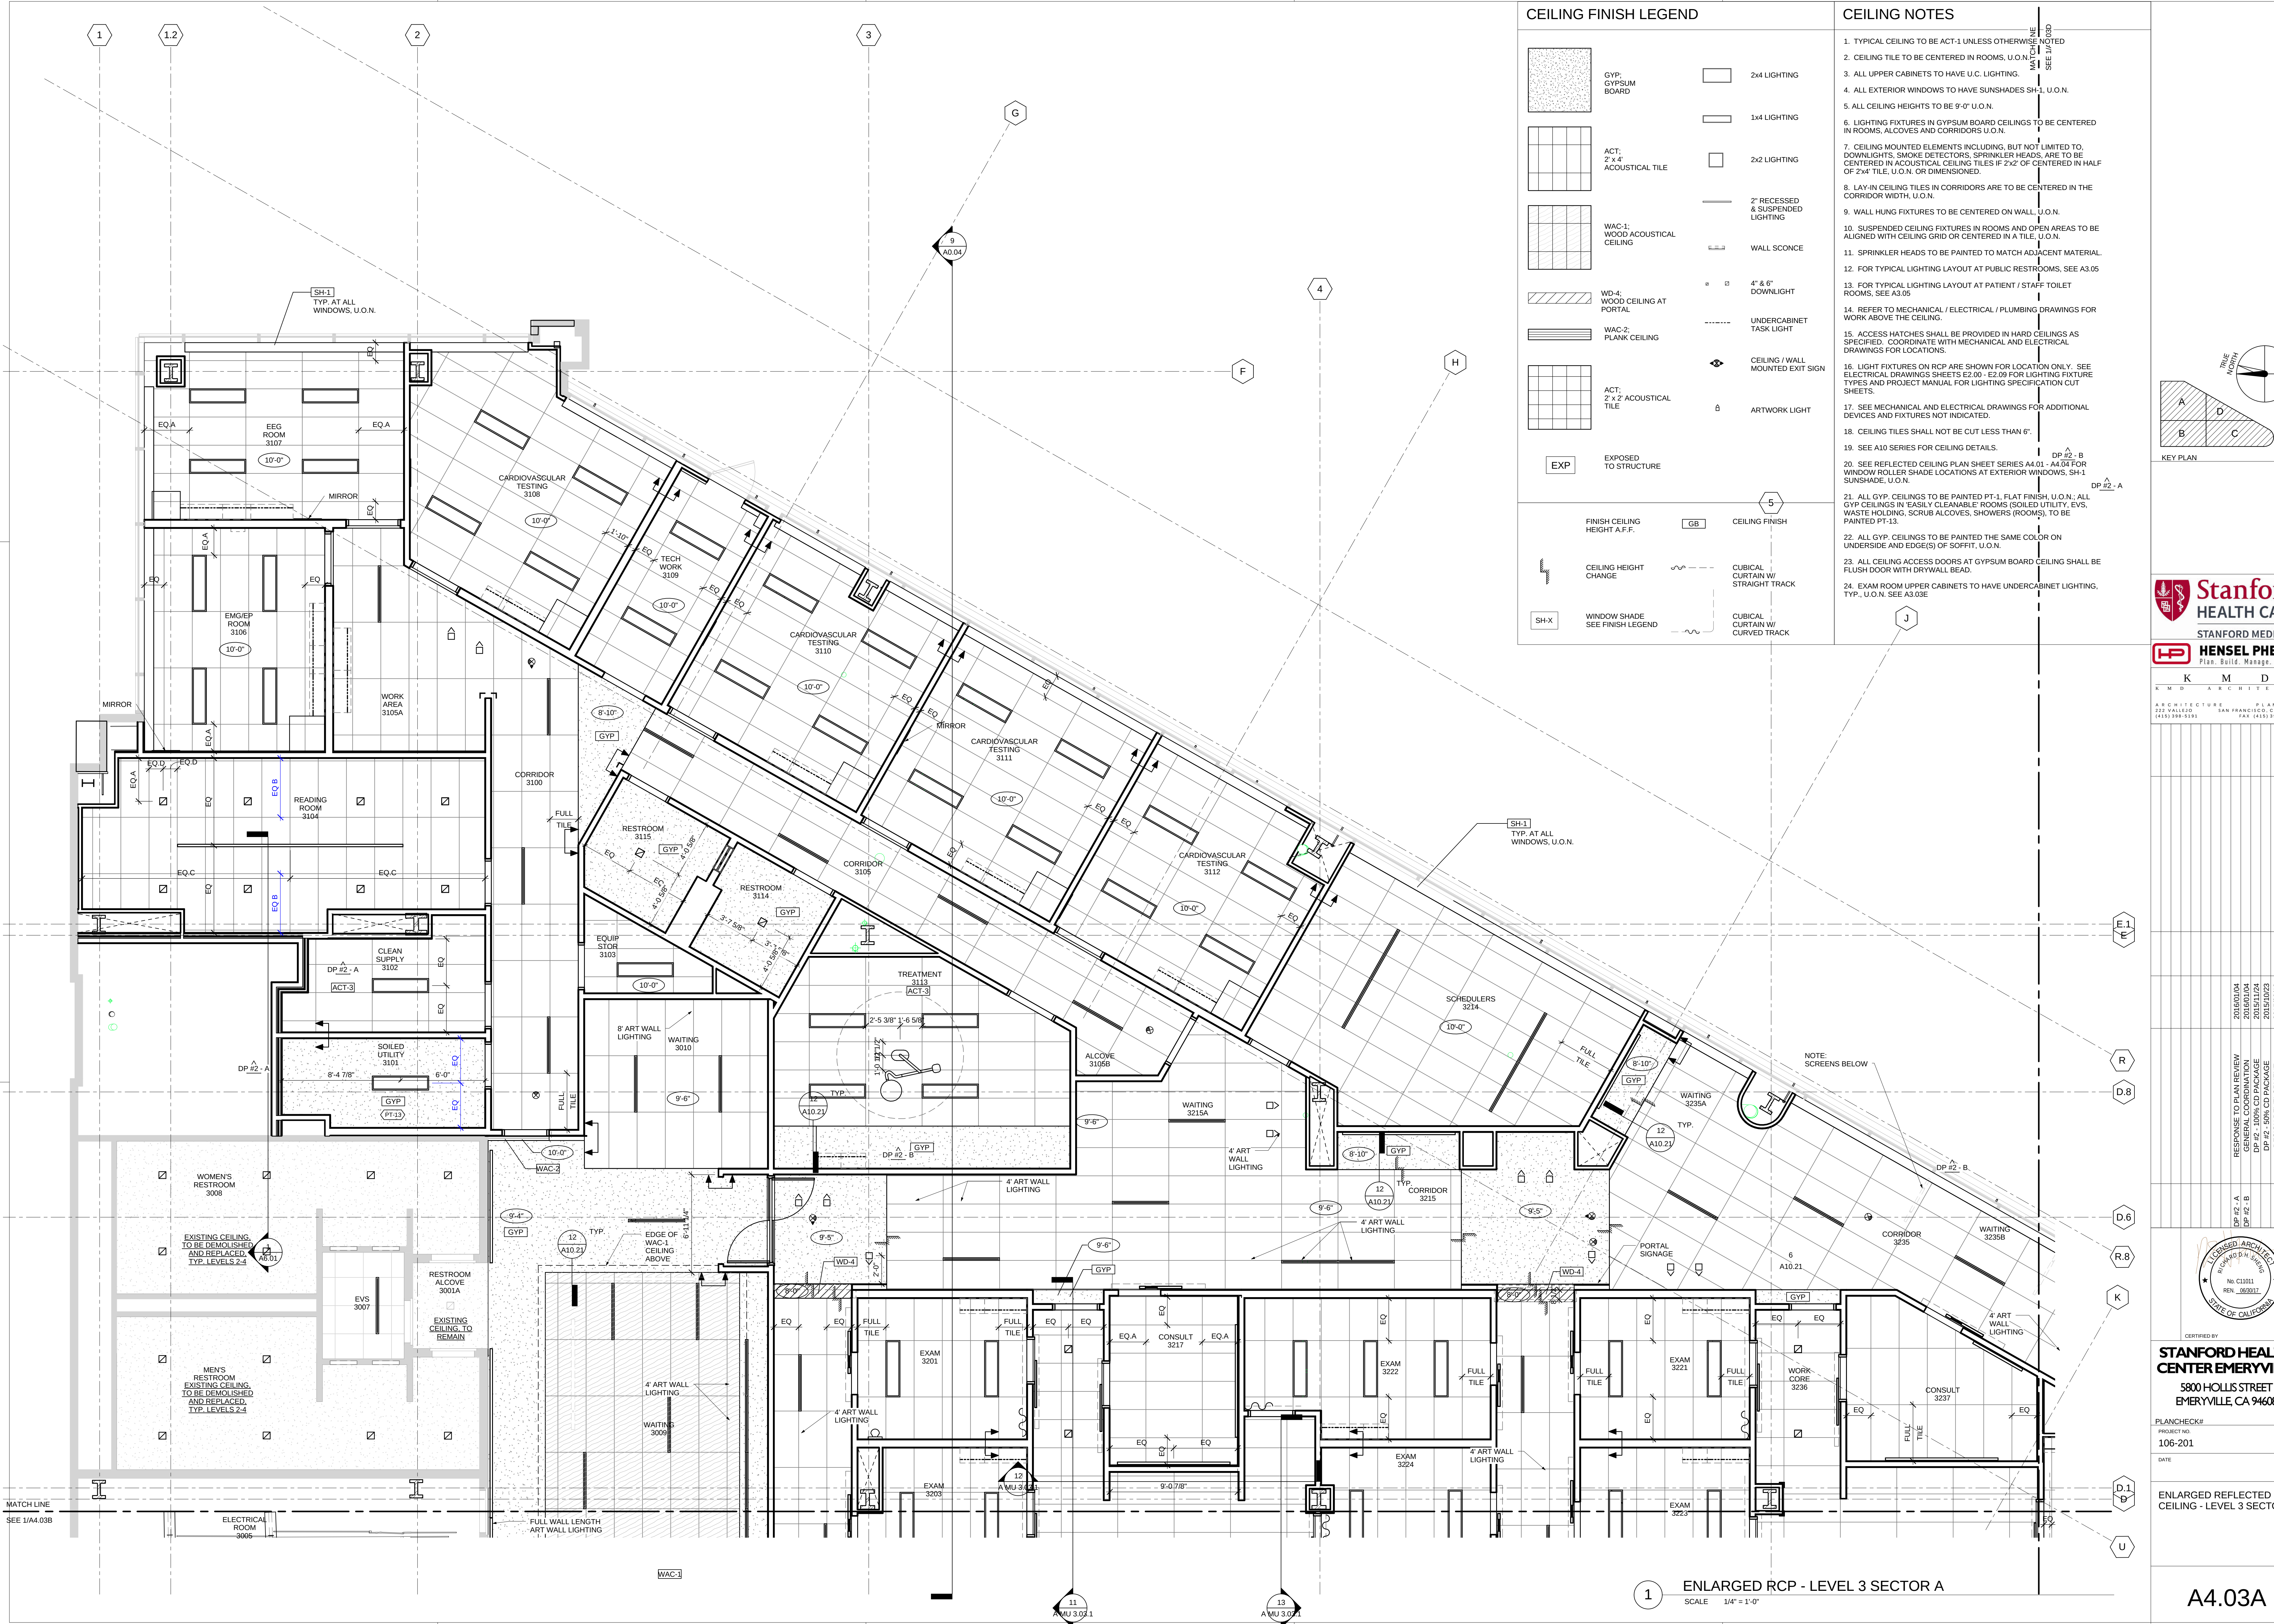


CEILING FINISH LEGEND

	GYP: GYPSUM BOARD		2x4 LIGHTING
	ACT: 2' x 4' ACOUSTICAL TILE		1x4 LIGHTING
	WAC-1: WOOD ACOUSTICAL CEILING		2x2 LIGHTING
	WD-4: WOOD CEILING AT PORTAL		2" RECESSED & SUSPENDED LIGHTING
	WAC-2: PLANK CEILING		WALL SCONCE
	ACT: 2' x 2' ACOUSTICAL TILE		4" & 6" DOWNLIGHT
	EXP: EXPOSED TO STRUCTURE		UNDERCABINET TASK LIGHT
	FINISH CEILING HEIGHT A.F.F.		CEILING / WALL MOUNTED EXIT SIGN
	SH-X: WINDOW SHADE SEE FINISH LEGEND		ARTWORK LIGHT
	GB: CEILING FINISH		
	CEILING HEIGHT CHANGE		CUBICAL CURTAIN W/ STRAIGHT TRACK
	SH-X: WINDOW SHADE SEE FINISH LEGEND		CUBICAL CURTAIN W/ CURVED TRACK


CEILING NOTES

1. TYPICAL CEILING TO BE ACT-1 UNLESS OTHERWISE NOTED.
2. CEILING TILE TO BE CENTERED IN ROOMS, U.O.N.
3. ALL UPPER CABINETS TO HAVE U.C. LIGHTING.
4. ALL EXTERIOR WINDOWS TO HAVE SUNSHADES SH-1, U.O.N.
5. ALL CEILING HEIGHTS TO BE 9'-0" U.O.N.
6. LIGHTING FIXTURES IN GYPSUM BOARD CEILINGS TO BE CENTERED IN ROOMS, ALCOVES AND CORRIDORS U.O.N.
7. CEILING MOUNTED ELEMENTS INCLUDING, BUT NOT LIMITED TO, DOWNLIGHTS, SMOKE DETECTORS, SPRINKLER HEADS, ARE TO BE CENTERED IN ACOUSTICAL CEILING TILES IF 2'x2' OF CENTERED IN HALF OF 2'x4 TILE, U.O.N. OR DIMENSIONED.
8. LAY-IN CEILING TILES IN CORRIDORS ARE TO BE CENTERED IN THE CORRIDOR WIDTH, U.O.N.
9. WALL HUNG FIXTURES TO BE CENTERED ON WALL, U.O.N.
10. SUSPENDED CEILING FIXTURES IN ROOMS AND OPEN AREAS TO BE ALIGNED WITH CEILING GRID OR CENTERED IN A TILE, U.O.N.
11. SPRINKLER HEADS TO BE PAINTED TO MATCH ADJACENT MATERIAL.
12. FOR TYPICAL LIGHTING LAYOUT AT PUBLIC RESTROOMS, SEE A3.05
13. FOR TYPICAL LIGHTING LAYOUT AT PATIENT / STAFF TOILET ROOMS, SEE A3.05
14. REFER TO MECHANICAL / ELECTRICAL / PLUMBING DRAWINGS FOR WORK ABOVE THE CEILING.
15. ACCESS HATCHES SHALL BE PROVIDED IN HARD CEILINGS AS SPECIFIED. COORDINATE WITH MECHANICAL AND ELECTRICAL DRAWINGS FOR LOCATIONS.
16. LIGHT FIXTURES ON RCP ARE SHOWN FOR LOCATION ONLY. SEE ELECTRICAL DRAWINGS SHEETS E2.00 - E2.09 FOR LIGHTING FIXTURE TYPES AND PROJECT MANUAL FOR LIGHTING SPECIFICATION CUT SHEETS.
17. SEE MECHANICAL AND ELECTRICAL DRAWINGS FOR ADDITIONAL DEVICES AND FIXTURES NOT INDICATED.
18. CEILING TILES SHALL NOT BE CUT LESS THAN 6".
19. SEE A10 SERIES FOR CEILING DETAILS.
20. SEE REFLECTED CEILING PLAN SHEET SERIES A4.01 - A4.04 FOR WINDOW ROLLER SHADE LOCATIONS AT EXTERIOR WINDOWS, SH-1 SUNSHADE, U.O.N.
21. ALL GYP. CEILINGS TO BE PAINTED PT-1, FLAT FINISH, U.O.N.; ALL GYP. CEILINGS IN EASILY CLEANABLE ROOMS (SOILED UTILITY, EVS, WASTE HOLDING, SCRUB ALCOVES, SHOWERS (ROOMS), TO BE PAINTED PT-13.
22. ALL GYP. CEILINGS TO BE PAINTED THE SAME COLOR ON UNDERSIDE AND EDGE(S) OF SOFFIT, U.O.N.
23. ALL CEILING ACCESS DOORS AT GYPSUM BOARD CEILING SHALL BE FLUSH DOOR WITH DRYWALL BEAD.
24. EXAM ROOM UPPER CABINETS TO HAVE UNDERCABINET LIGHTING, TYP., U.O.N. SEE A3.03E

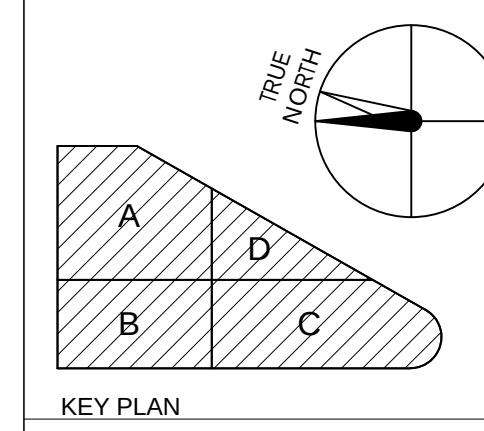

Stanford HEALTH CARE
STANFORD MEDICINE
HENSEL PHELPS
Plan. Build. Manage.
K M D ARCHITECTS
ARCHITECTURE PLANNING
222 WILLOW SAN FRANCISCO, CA 94111
(415) 398-9131 FAX (415) 394-7158

NO.	DATE	ISSUED FOR
20160104	20160104	RESPONSE TO PLAN REVIEW
20160104	20160104	REVISIONS
20160104	20160104	DP #2 - 10% CD PACKAGE
20160104	20160104	DP #2 - 50% CD PACKAGE
20160104	20160104	DESIGN DEVELOPMENT
20160104	20160104	DP #2 (50% CD) COORDINATION

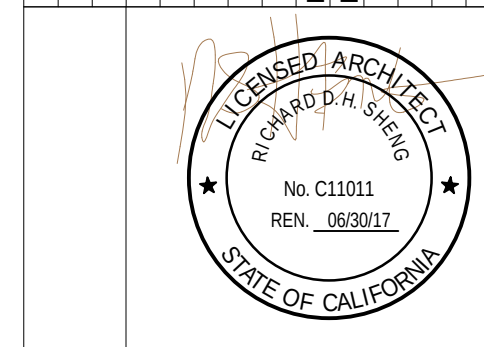


CERTIFIED BY
STANFORD HEALTH CENTER EMERYVILLE
5800 HOLLISS STREET
EMERYVILLE, CA 94608

PLANCHHECK#
PROJECT NO.
106-201
DATE

ENLARGED REFLECTED
CEILING - LEVEL 3 SECTOR A

A4.03A

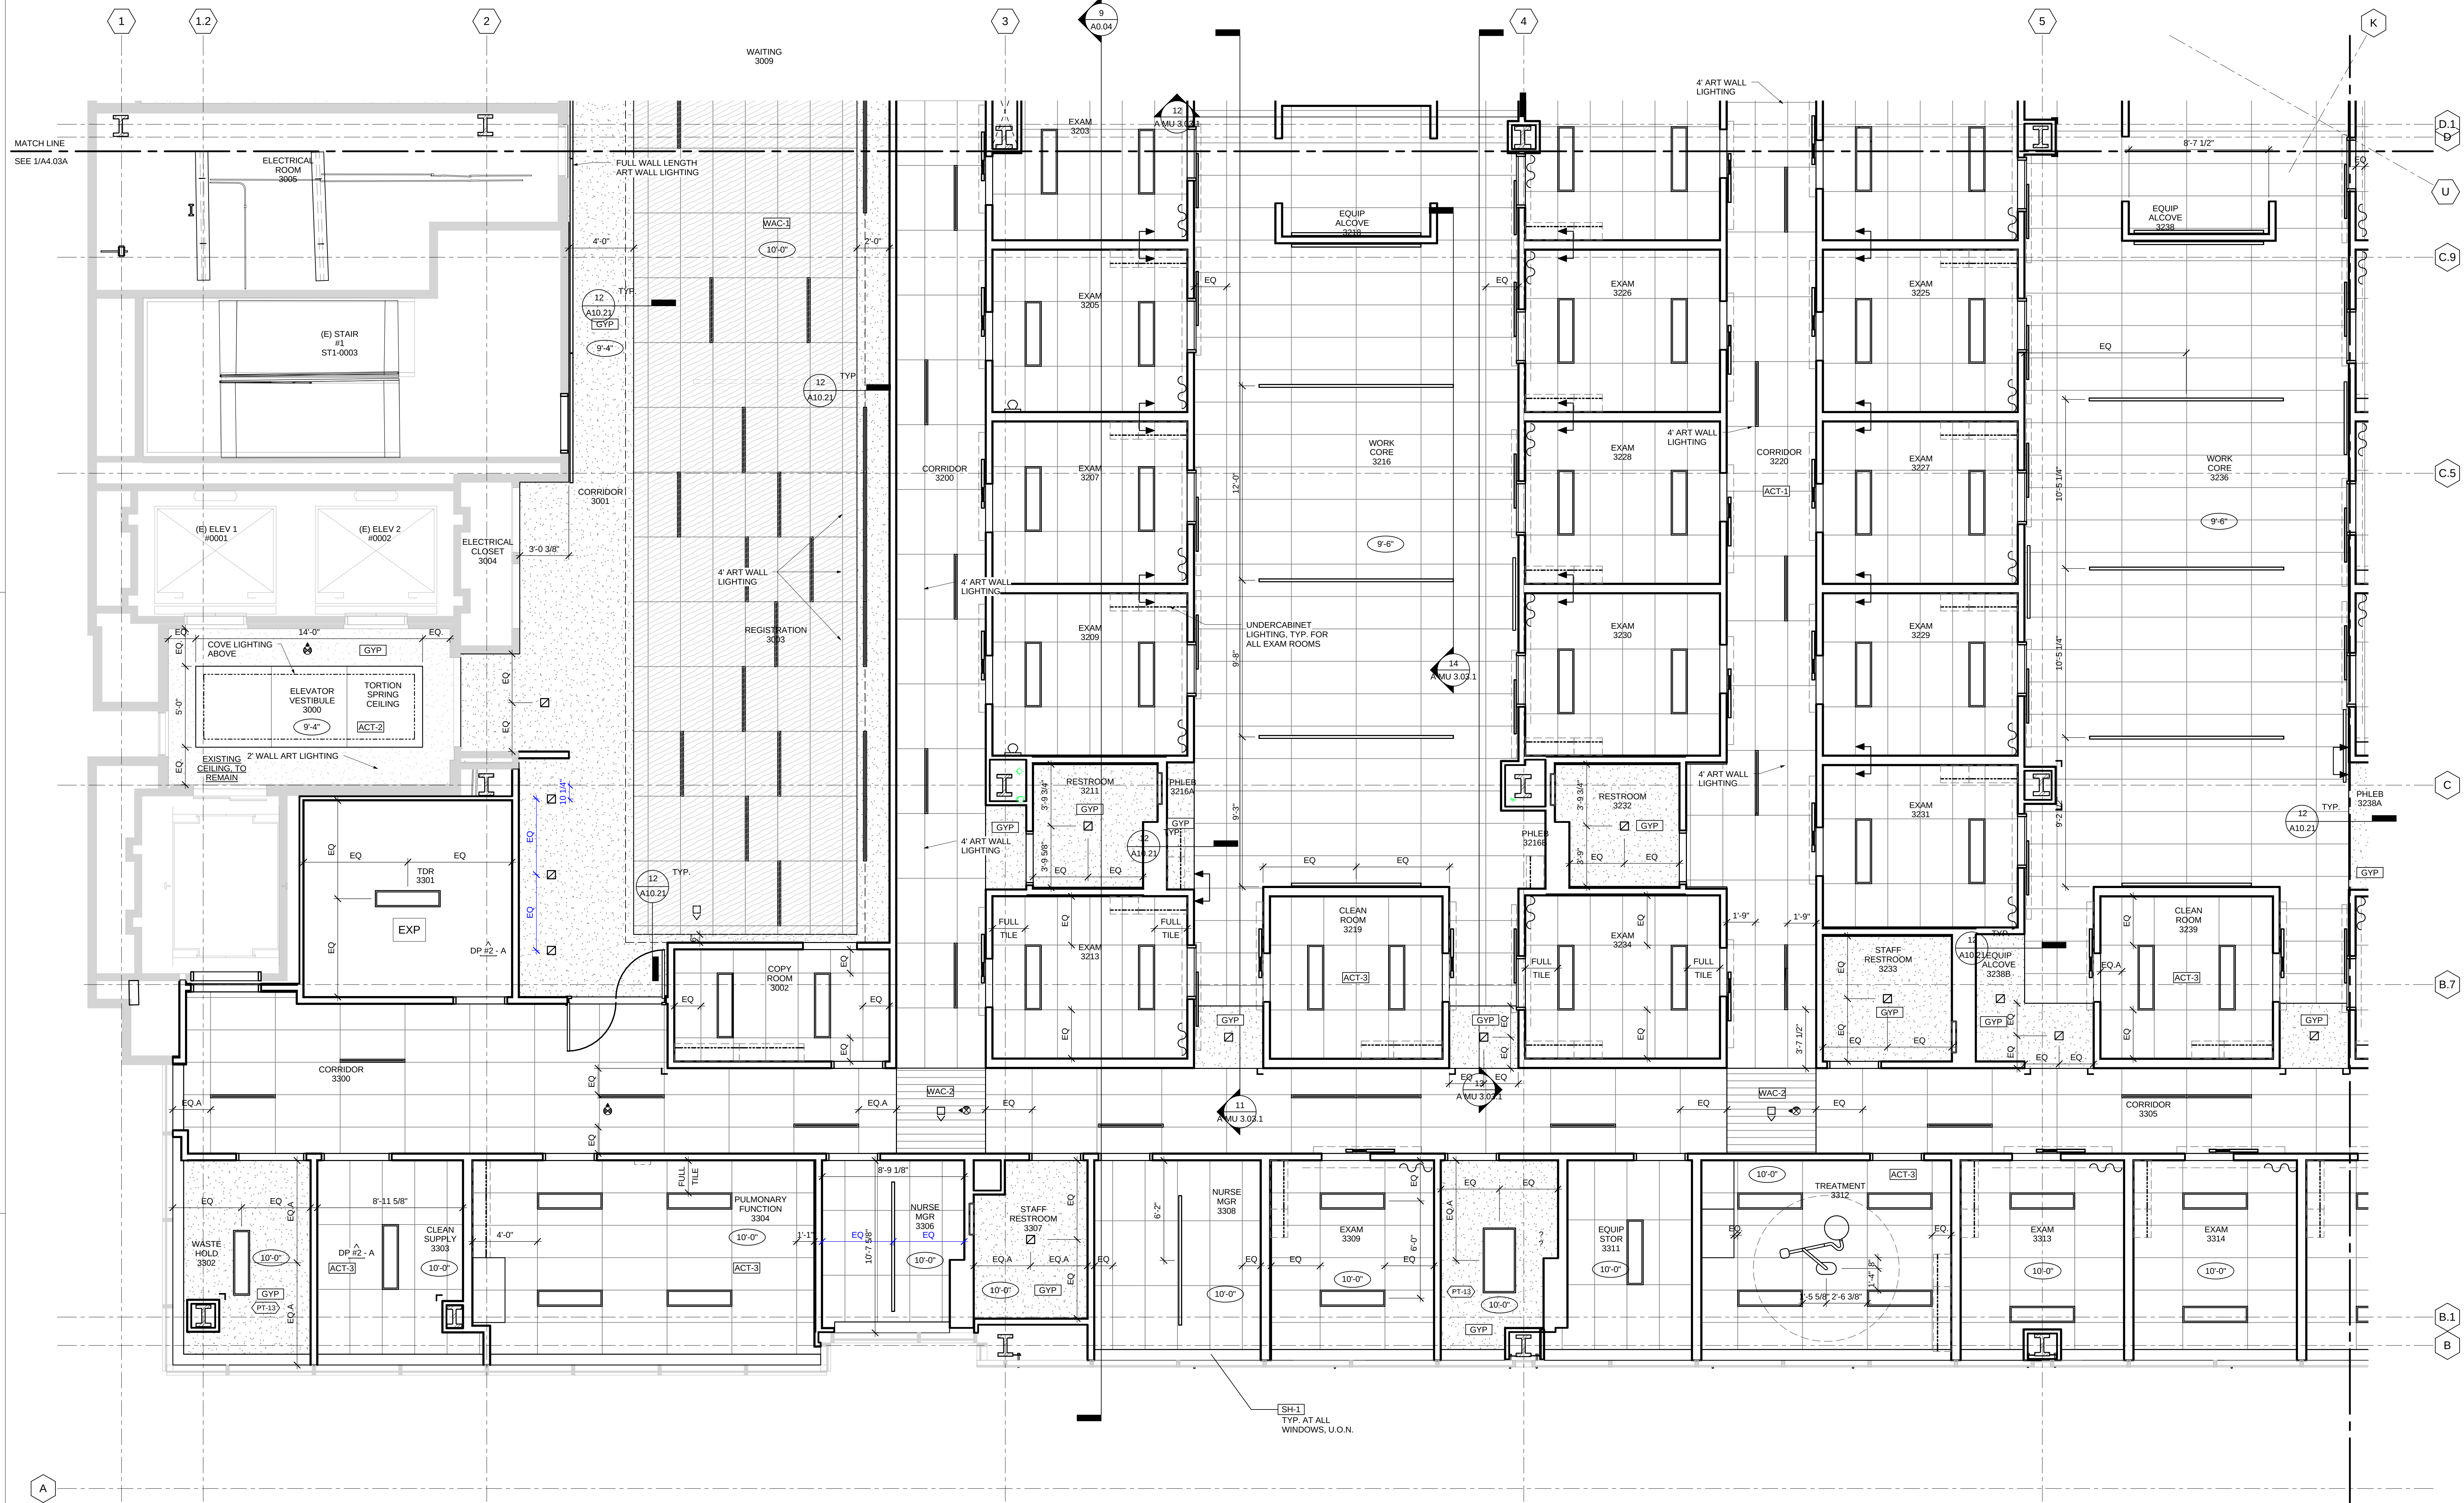


CEILING NOTES

1. TYPICAL CEILING TO BE ACT-1 UNLESS OTHERWISE NOTED
2. CEILING TILE TO BE CENTERED IN ROOMS, U.O.N.
3. ALL UPPER CABINETS TO HAVE U.C. LIGHTING.
4. ALL EXTERIOR WINDOWS TO HAVE SUNSHADES SH-1, U.O.N.
5. ALL CEILING HEIGHTS TO BE 9'-0" U.O.N.
6. LIGHTING FIXTURES IN GYPSUM BOARD CEILINGS TO BE CENTERED IN ROOMS, ALCOVES AND CORRIDORS U.O.N.
7. CEILING MOUNTED ELEMENTS INCLUDING, BUT NOT LIMITED TO, DOWNLIGHTS, SMOKE DETECTORS, SPRINKLER HEADS, ARE TO BE CENTERED IN ACOUSTICAL CEILING TILES IF 2'x2' OF CENTERED IN HALF OF 2'x4' TILE, U.O.N. OR DIMENSIONED.
8. LAY-IN CEILING TILES IN CORRIDORS ARE TO BE CENTERED IN THE CORRIDOR WIDTH, U.O.N.
9. WALL HUNG FIXTURES TO BE CENTERED ON WALL, U.O.N.
10. SUSPENDED CEILING FIXTURES IN ROOMS AND OPEN AREAS TO BE ALIGNED WITH CEILING GRID OR CENTERED IN A TILE, U.O.N.
11. SPRINKLER HEADS TO BE PAINTED TO MATCH ADJACENT MATERIAL.
12. FOR TYPICAL LIGHTING LAYOUT AT PUBLIC RESTROOMS, SEE A3.05
13. FOR TYPICAL LIGHTING LAYOUT AT PATIENT / STAFF TOILET ROOMS, SEE A3.05
14. REFER TO MECHANICAL / ELECTRICAL / PLUMBING DRAWINGS FOR WORK ABOVE THE CEILING.
15. ACCESS HATCHES SHALL BE PROVIDED IN HARD CEILINGS AS SPECIFIED. COORDINATE WITH MECHANICAL AND ELECTRICAL DRAWINGS FOR LOCATIONS.
16. LIGHT FIXTURES ON RCP ARE SHOWN FOR LOCATION ONLY. SEE ELECTRICAL DRAWINGS SHEETS E2.00 - E2.09 FOR LIGHTING FIXTURE TYPES AND PROJECT MANUAL FOR LIGHTING SPECIFICATION CUT SHEETS.
17. SEE MECHANICAL AND ELECTRICAL DRAWINGS FOR ADDITIONAL DEVICES AND FIXTURES NOT INDICATED.
18. CEILING TILES SHALL NOT BE CUT LESS THAN 6".
19. SEE A3.0 SERIES FOR CEILING DETAILS.
20. SEE REFLECTED CEILING PLAN SHEET SERIES A4.01 - A4.09 FOR WINDOW ROLLER SHADE LOCATIONS AT EXTERIOR WINDOWS, SH-1 SUNSHADE, U.O.N.
21. ALL GYP. CEILINGS TO BE PAINTED PT-1, FLAT FINISH, U.O.N.; ALL GYP CEILINGS IN "EASILY CLEANABLE" ROOMS (SOILED UTILITY, EVS, WASTE HOLDING, SCRUB ALCOVES, SHOWERS (ROOMS), TO BE PAINTED PT-13.
22. ALL GYP. CEILINGS TO BE PAINTED THE SAME COLOR ON UNDERSIDE AND EDGE(S) OF SOFFIT, U.O.N.
23. ALL CEILING ACCESS DOORS AT GYPSUM BOARD CEILING SHALL BE FLUSH DOOR WITH DRYWALL BEAD.
24. EXAM ROOM UPPER CABINETS TO HAVE UNDERCABINET LIGHTING, TYP., U.O.N. SEE A3.03E

1 ENLARGED RCP - LEVEL 3 SECTOR B
SCALE 1/4" = 1'-0"



DATE	NO.	ISSUED FOR
2016/01/04		RESPONSE TO PLAN REVIEW
2016/01/24		DP #2 - 10% CD PACKAGE
2016/02/23		DP #2 - 50% CD PACKAGE
2016/09/18		DESIGN DEVELOPMENT
2016/07/31		DP #2 (50% CD) COORDINATION

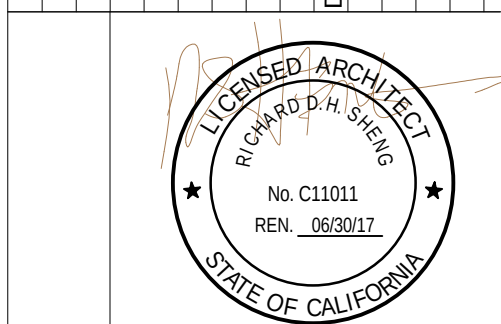

CERTIFIED BY
STANFORD HEALTH CENTER EMERYVILLE
5800 HOLLIS STREET
EMERYVILLE, CA 94608

PLAN CHECK#
PROJECT NO.
106-201
DATE


ENLARGED REFLECTED
CEILING - LEVEL 3 SECTOR B

A4.03B


CEILING NOTES

1. TYPICAL CEILING TO BE ACT-1 UNLESS OTHERWISE NOTED
2. CEILING TILE TO BE CENTERED IN ROOMS, U.O.N.
3. ALL UPPER CABINETS TO HAVE U.C. LIGHTING.
4. ALL EXTERIOR WINDOWS TO HAVE SUNSHADES SH-1, U.O.N.
5. ALL CEILING HEIGHTS TO BE 9'-0" U.O.N.
6. LIGHTING FIXTURES IN GYPSUM BOARD CEILINGS TO BE CENTERED IN ROOMS, ALCOVES AND CORRIDORS U.O.N.
7. CEILING MOUNTED ELEMENTS INCLUDING, BUT NOT LIMITED TO, DOWNLIGHTS, SMOKE DETECTORS, SPRINKLER HEADS, ARE TO BE CENTERED IN ACOUSTICAL CEILING TILES IF 2'x2' OF CENTERED IN HALF OF 2'x4' TILE, U.O.N. OR DIMENSIONED.
8. LAY-IN CEILING TILES IN CORRIDORS ARE TO BE CENTERED IN THE CORRIDOR WIDTH, U.O.N.
9. WALL HUNG FIXTURES TO BE CENTERED ON WALL, U.O.N.
10. SUSPENDED CEILING FIXTURES IN ROOMS AND OPEN AREAS TO BE ALIGNED WITH CEILING GRID OR CENTERED IN A TILE, U.O.N.
11. SPRINKLER HEADS TO BE PAINTED TO MATCH ADJACENT MATERIAL.
12. FOR TYPICAL LIGHTING LAYOUT AT PUBLIC RESTROOMS, SEE A3.05
13. FOR TYPICAL LIGHTING LAYOUT AT PATIENT / STAFF TOILET ROOMS, SEE A3.05
14. REFER TO MECHANICAL / ELECTRICAL / PLUMBING DRAWINGS FOR WORK ABOVE THE CEILING.
15. ACCESS HATCHES SHALL BE PROVIDED IN HARD CEILINGS AS SPECIFIED. COORDINATE WITH MECHANICAL AND ELECTRICAL DRAWINGS FOR LOCATIONS.
16. LIGHT FIXTURES ON RCP ARE SHOWN FOR LOCATION ONLY. SEE ELECTRICAL DRAWINGS SHEETS E2.00 - E2.09 FOR LIGHTING FIXTURE TYPES AND PROJECT MANUAL FOR LIGHTING SPECIFICATION CUT SHEETS.
17. SEE MECHANICAL AND ELECTRICAL DRAWINGS FOR ADDITIONAL DEVICES AND FIXTURES NOT INDICATED.
18. CEILING TILES SHALL NOT BE CUT LESS THAN 6".
19. SEE A3.0 SERIES FOR CEILING DETAILS.
20. SEE REFLECTED CEILING PLAN SHEET SERIES A4.01 - A4.09 FOR WINDOW ROLLER SHADE LOCATIONS AT EXTERIOR WINDOWS, SH-1 SUNSHADE, U.O.N.
21. ALL GYP. CEILINGS TO BE PAINTED PT-1, FLAT FINISH, U.O.N.; ALL GYP CEILINGS IN "EASILY CLEANABLE" ROOMS (SOILED UTILITY, EVS, WASTE HOLDING, SCRUB ALCOVES, SHOWERS (ROOMS), TO BE PAINTED PT-13.
22. ALL GYP. CEILINGS TO BE PAINTED THE SAME COLOR ON UNDERSIDE AND EDGE(S) OF SOFFIT, U.O.N.
23. ALL CEILING ACCESS DOORS AT GYPSUM BOARD CEILING SHALL BE FLUSH DOOR WITH DRYWALL BEAD.
24. EXAM ROOM UPPER CABINETS TO HAVE UNDERCABINET LIGHTING, TYP., U.O.N. SEE A3.03E

1 ENLARGED RCP - LEVEL 3 SECTOR C
SCALE 1/4" = 1'-0"

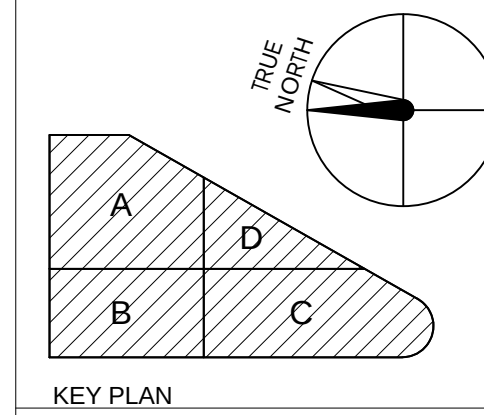

NO.	DATE	ISSUED FOR
2016/01/04	2016/01/04	RESPONSE TO PLAN REVIEW
2016/01/04	2016/01/04	DP #2 - A
2016/01/04	2016/01/04	DP #2 - B
2016/01/04	2016/01/04	DP #2 - 10% CD PACKAGE
2016/01/04	2016/01/04	DP #2 - 50% CD PACKAGE
2016/01/04	2016/01/04	DESIGN DEVELOPMENT
2016/01/04	2016/01/04	DP #2 (50% CD) COORDINATION

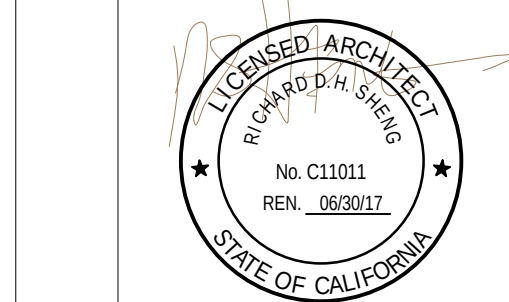


CERTIFIED BY
STANFORD HEALTH CENTER EMERYVILLE
5800 HOLLIS STREET
EMERYVILLE, CA 94608

PLAN CHECK#
PROJECT NO.
106-201
DATE

ENLARGED REFLECTED
CEILING - LEVEL 3 SECTOR C

A4.03C

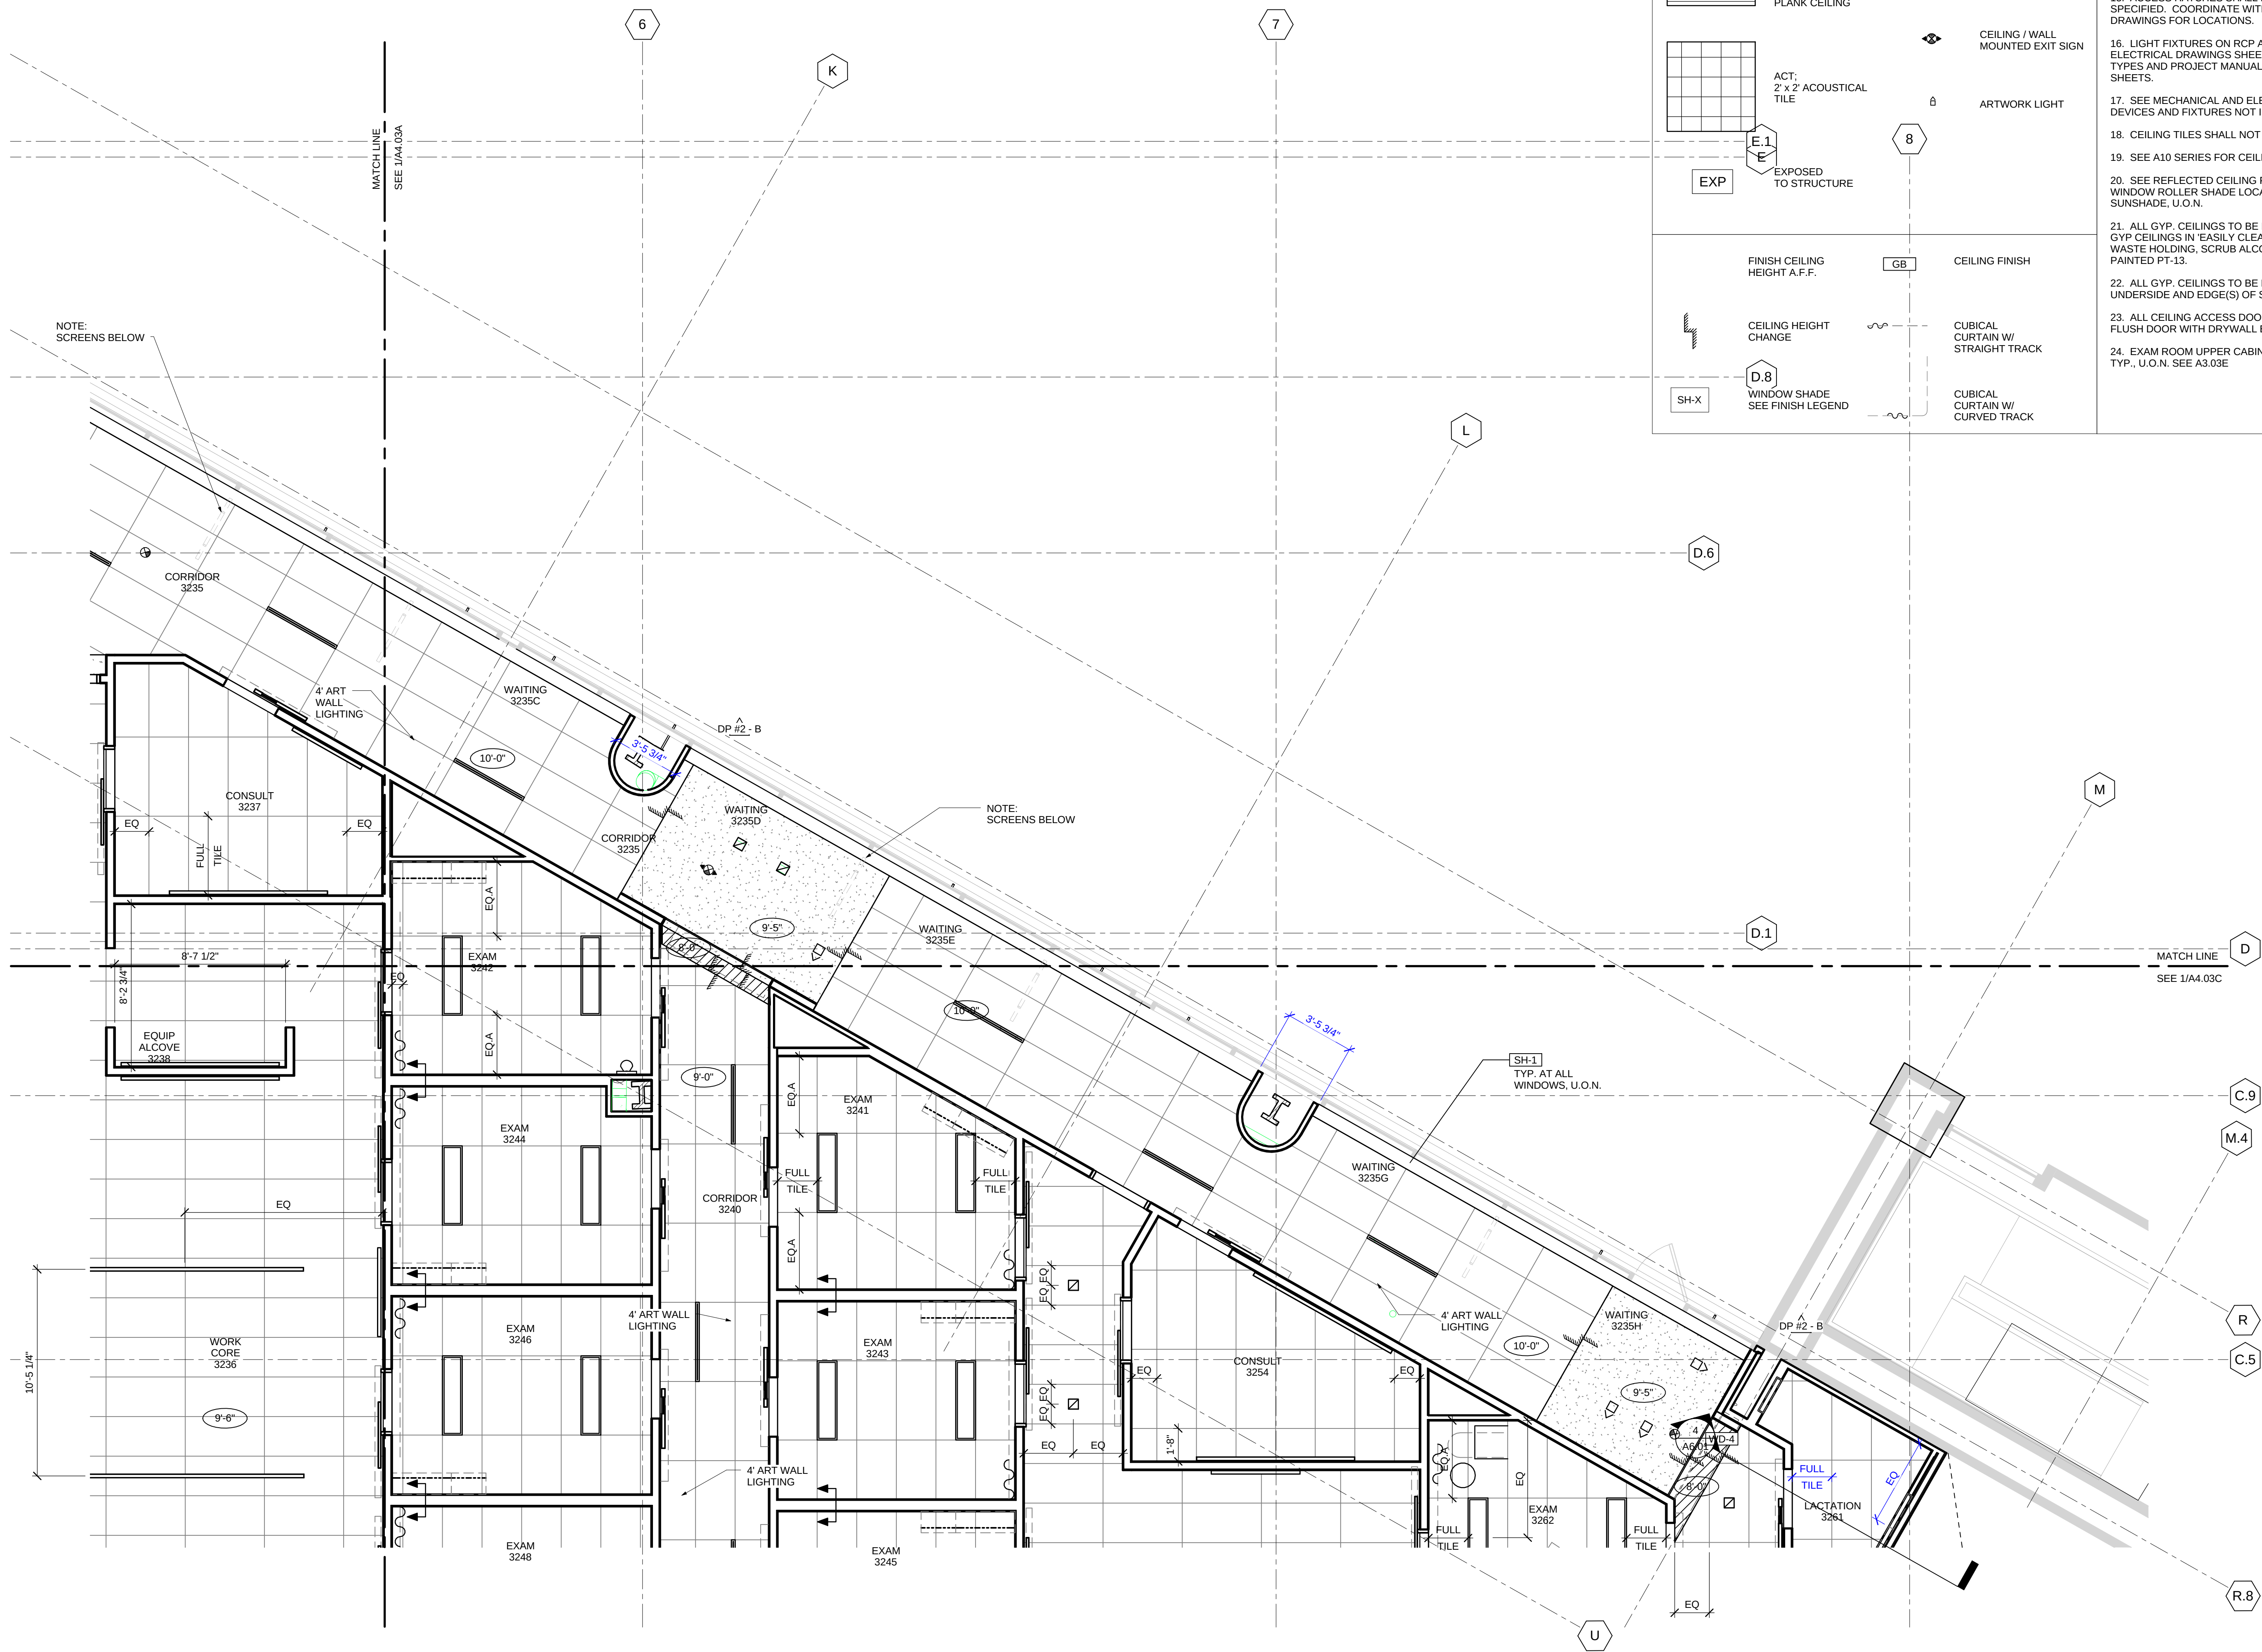


CEILING FINISH LEGEND

	GYP: GYPSUM BOARD		2x4 LIGHTING
	ACT: 2 x 4 ACOUSTICAL TILE		1x4 LIGHTING
	WAC-1: WOOD ACOUSTICAL CEILING		2x2 LIGHTING
	WD-4: WOOD CEILING AT PORTAL		2\"/>
	WAC-2: PLANK CEILING		WALL SCONCE
	ACT: 2 x 2 ACOUSTICAL TILE		4\"/>
	EXP EXPOSED TO STRUCTURE		UNDERCABINET TASK LIGHT
	CEILING FINISH		CEILING / WALL MOUNTED EXIT SIGN
	CEILING HEIGHT CHANGE		ARTWORK LIGHT
	SH-X WINDOW SHADE SEE FINISH LEGEND		

CEILING NOTES


1. TYPICAL CEILING TO BE ACT-1 UNLESS OTHERWISE NOTED
2. CEILING TILE TO BE CENTERED IN ROOMS, U.O.N.
3. ALL UPPER CABINETS TO HAVE U.C. LIGHTING.
4. ALL EXTERIOR WINDOWS TO HAVE SUNSHADES SH-1, U.O.N.
5. ALL CEILING HEIGHTS TO BE 9'-0" U.O.N.
6. LIGHTING FIXTURES IN GYPSUM BOARD CEILINGS TO BE CENTERED IN ROOMS, ALCOVES AND CORRIDORS U.O.N.
7. CEILING MOUNTED ELEMENTS INCLUDING, BUT NOT LIMITED TO, DOWNLIGHTS, SMOKE DETECTORS, SPRINKLER HEADS, ARE TO BE CENTERED IN ACOUSTICAL CEILING TILES IF 2'x2' OF CENTERED IN HALF OF 2'x4 TILE, U.O.N. OR DIMENSIONED.
8. LAY-IN CEILING TILES IN CORRIDORS ARE TO BE CENTERED IN THE CORRIDOR WIDTH, U.O.N.
9. WALL HUNG FIXTURES TO BE CENTERED ON WALL, U.O.N.
10. SUSPENDED CEILING FIXTURES IN ROOMS AND OPEN AREAS TO BE ALIGNED WITH CEILING GRID OR CENTERED IN A TILE, U.O.N.
11. SPRINKLER HEADS TO BE PAINTED TO MATCH ADJACENT MATERIAL.
12. FOR TYPICAL LIGHTING LAYOUT AT PUBLIC RESTROOMS, SEE A3.05
13. FOR TYPICAL LIGHTING LAYOUT AT PATIENT / STAFF TOILET ROOMS, SEE A3.05
14. REFER TO MECHANICAL / ELECTRICAL / PLUMBING DRAWINGS FOR WORK ABOVE THE CEILING.
15. ACCESS HATCHES SHALL BE PROVIDED IN HARD CEILINGS AS SPECIFIED. COORDINATE WITH MECHANICAL AND ELECTRICAL DRAWINGS FOR LOCATIONS.
16. LIGHT FIXTURES ON RCP ARE SHOWN FOR LOCATION ONLY. SEE ELECTRICAL DRAWINGS SHEETS E2.00 - E2.09 FOR LIGHTING FIXTURE TYPES AND PROJECT MANUAL FOR LIGHTING SPECIFICATION CUT SHEETS.
17. SEE MECHANICAL AND ELECTRICAL DRAWINGS FOR ADDITIONAL DEVICES AND FIXTURES NOT INDICATED.
18. CEILING TILES SHALL NOT BE CUT LESS THAN 6".
19. SEE A10 SERIES FOR CEILING DETAILS.
20. SEE REFLECTED CEILING PLAN SHEET SERIES A4.01 - A4.04 FOR WINDOW ROLLER SHADE LOCATIONS AT EXTERIOR WINDOWS, SH-1 SUNSHADE, U.O.N.
21. ALL GYP. CEILINGS TO BE PAINTED PT-1, FLAT FINISH, U.O.N.; ALL GYP. CEILINGS IN EASILY CLEANABLE ROOMS (SOILED UTILITY, EVS, WASTE HOLDING, SCRUB ALCOVES, SHOWERS (ROOMS), TO BE PAINTED PT-13.
22. ALL GYP. CEILINGS TO BE PAINTED THE SAME COLOR ON UNDERSIDE AND EDGE(S) OF SOFFIT, U.O.N.
23. ALL CEILING ACCESS DOORS AT GYPSUM BOARD CEILING SHALL BE FLUSH DOOR WITH DRYWALL BEAD.
24. EXAM ROOM UPPER CABINETS TO HAVE UNDERCABINET LIGHTING, TYP., U.O.N. SEE A3.03E

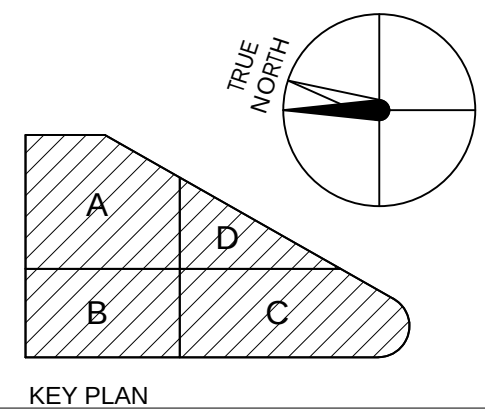


Stanford HEALTH CARE
STANFORD MEDICINE
HENSEL PHELPS
Plan. Build. Manage.
K M D ARCHITECTS
ARCHITECTURE PLANNING
222 WILLOW SAN FRANCISCO, CA 94111
(415) 398-9131 FAX (415) 394-7158









2016/01/04	2015/10/23	2015/09/18	2015/07/31	DATE
GENERAL COORDINATION	DP #2 - 50% CD PACKAGE	DESIGN DEVELOPMENT	DP #2 (50% CD) COORDINATION	ISSUED FOR
DP #2 - B	DP #2 - B	DP #2 - B	DP #2 - B	NO.

CERTIFIED BY
STANFORD HEALTH CENTER EMERYVILLE
5800 HOLLIS STREET
EMERYVILLE, CA 94608
PLAN CHECK#
PROJECT NO.
106-201
DATE
ENLARGED REFLECTED
CEILING - LEVEL 3 SECTOR D

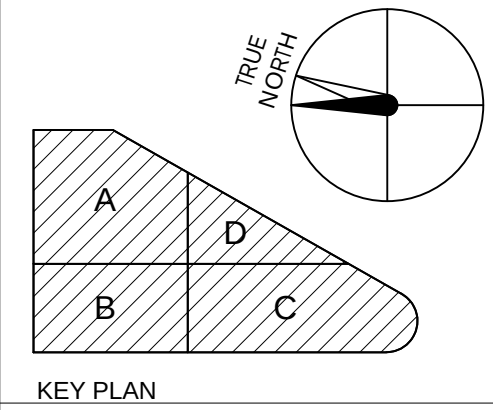

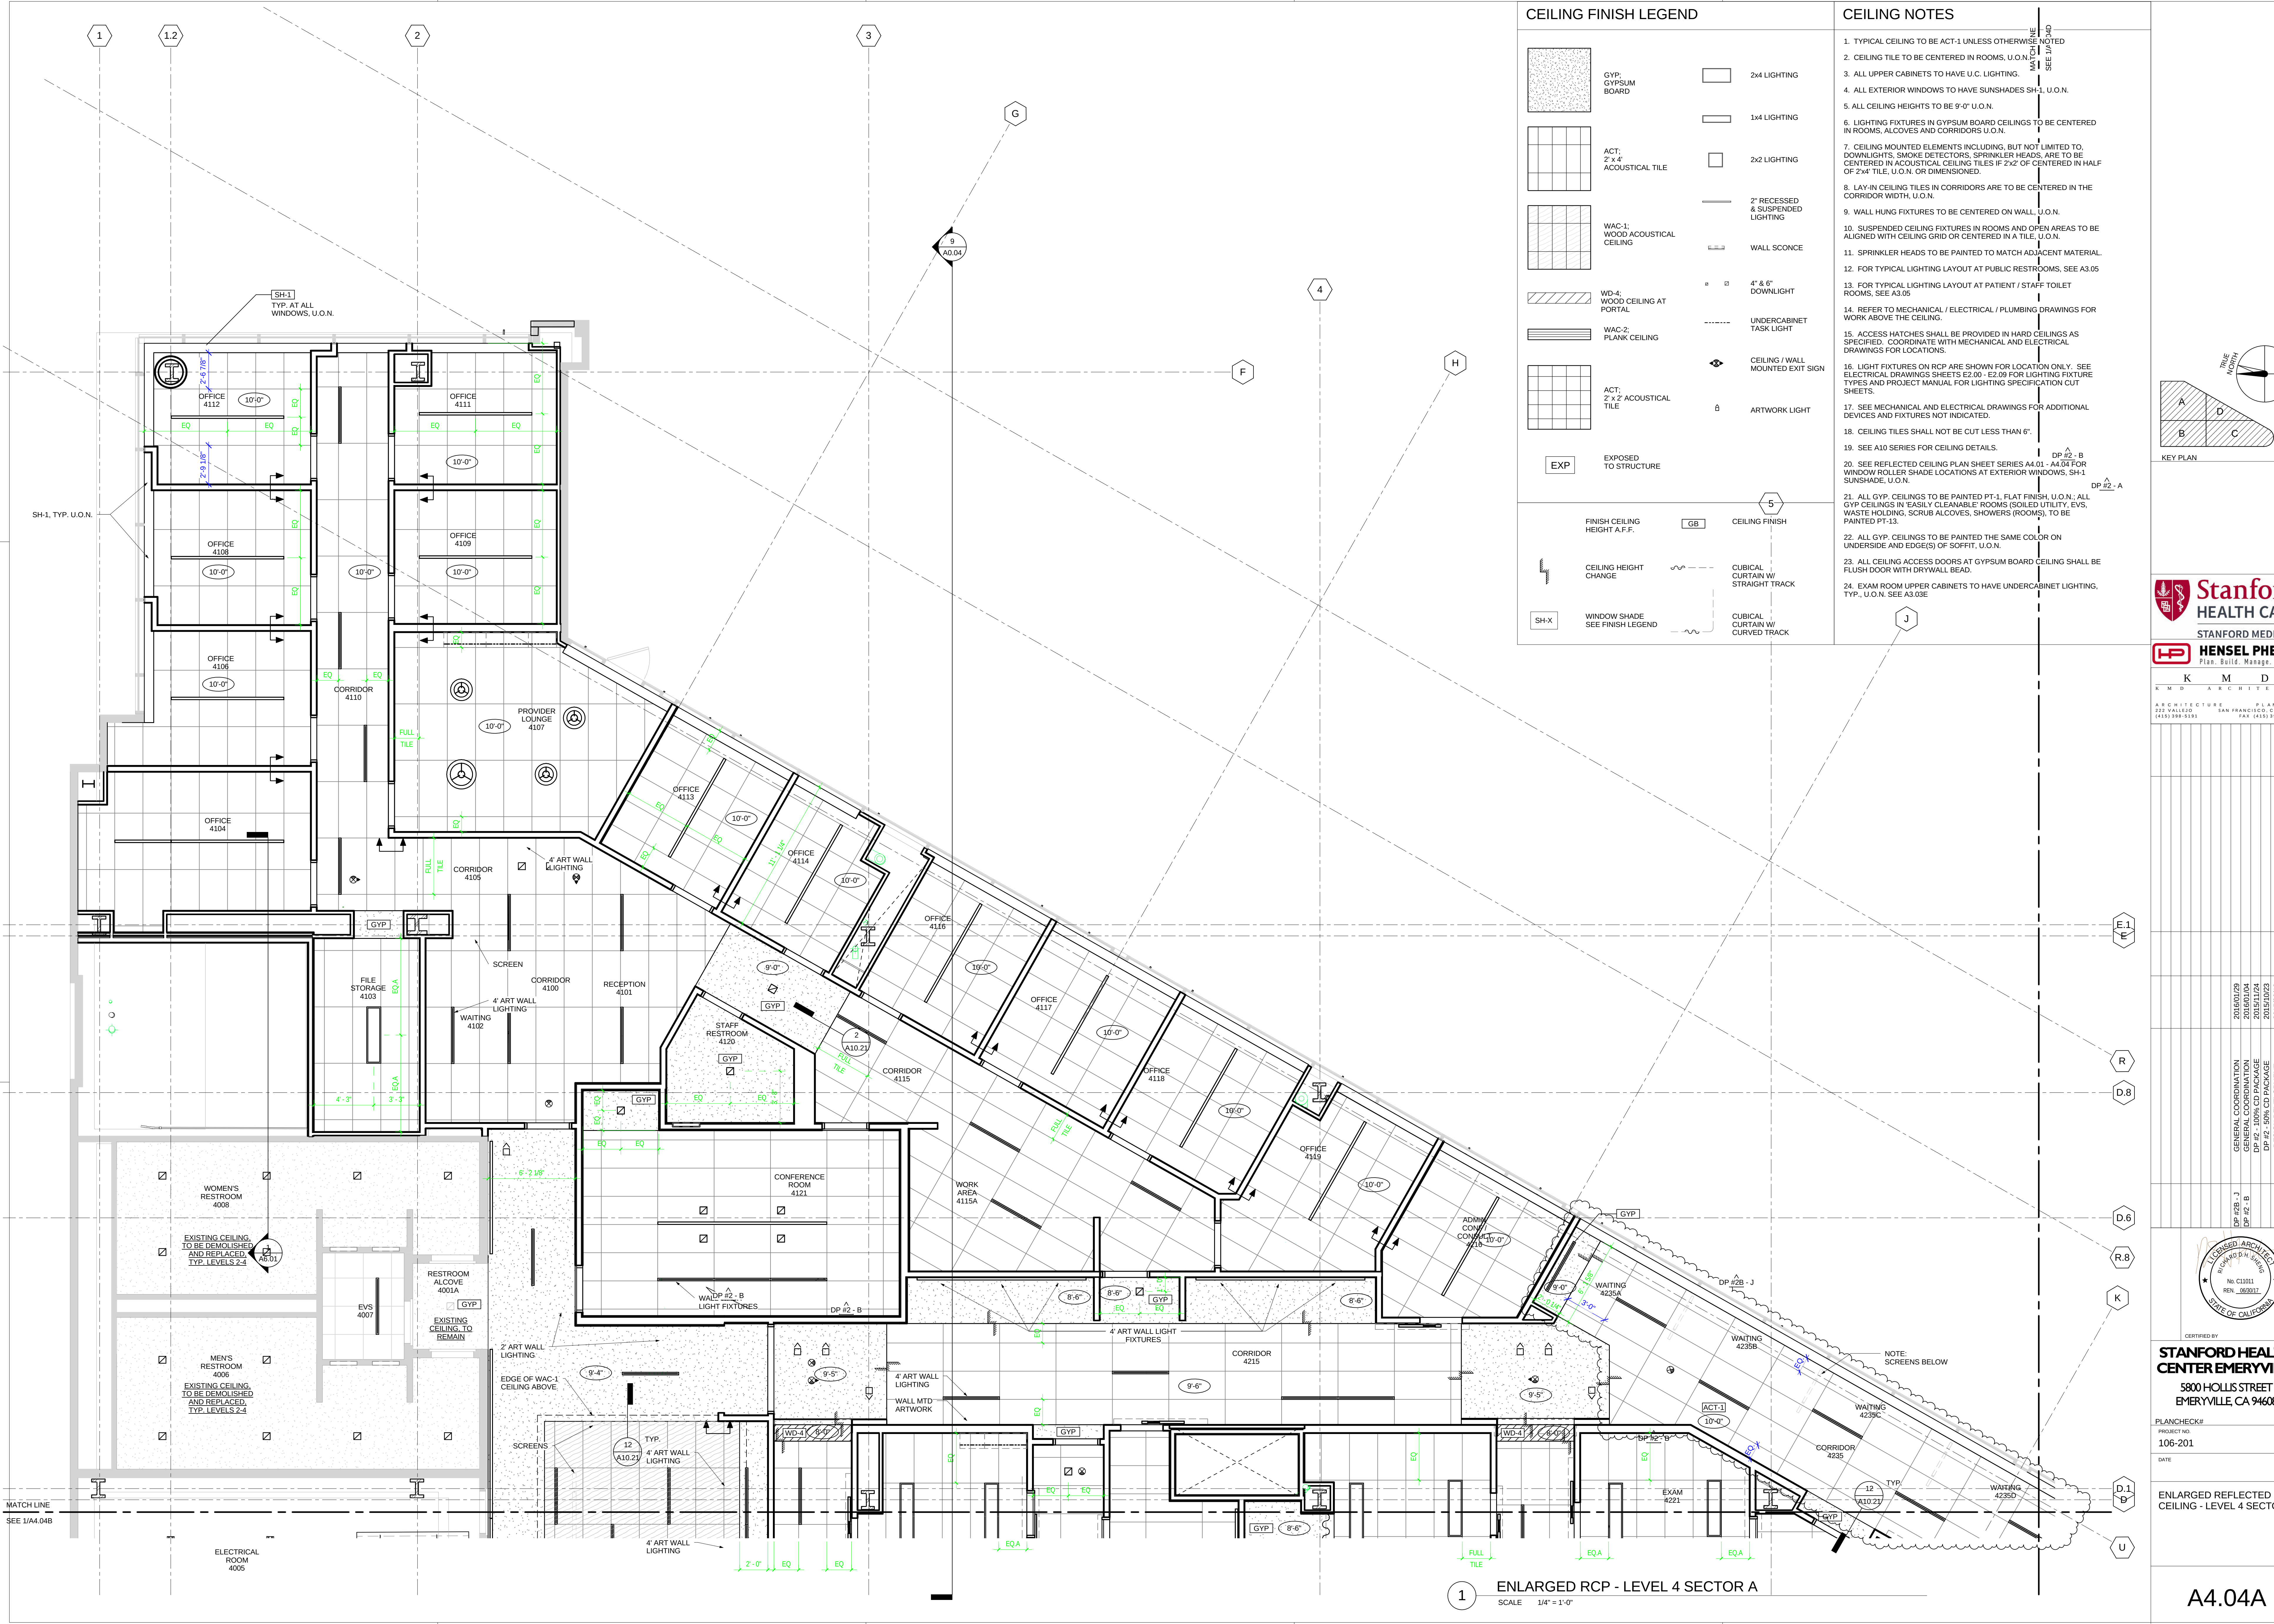


CEILING FINISH LEGEND

   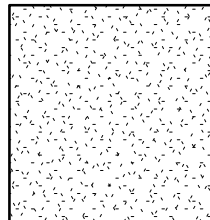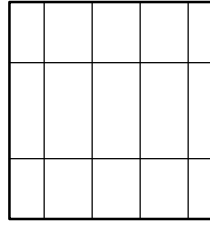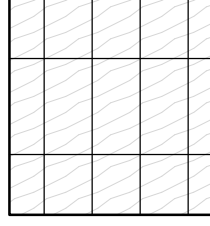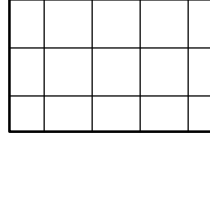 	GYP: GYPSUM BOARD		2x4 LIGHTING
	ACT: 2 x 4' ACOUSTICAL TILE		1x4 LIGHTING
	WAC-1: WOOD ACOUSTICAL CEILING		2x2 LIGHTING
	WD-4: WOOD CEILING AT PORTAL		2" RECESSED & SUSPENDED LIGHTING
	WAC-2: PLANK CEILING		WALL SCONCE
	EXPLODED VIEW		4" & 6" DOWNLIGHT
	ACT: 2 x 2' ACOUSTICAL TILE		UNDERCABINET TASK LIGHT
	SHADOW		CEILING / WALL MOUNTED EXHIBIT
	FINISH CEILING HEIGHT A.F.F.		ARTWORK LIGHTING


CEILING NOTES

1. TYPICAL CEILING TO BE ACT-1 UNLESS OTHERWISE NOTED.
2. CEILING TILE TO BE CENTERED IN ROOMS, U.O.N.
3. ALL UPPER CABINETS TO HAVE U.C. LIGHTING.
4. ALL EXTERIOR WINDOWS TO HAVE SUNSHADES SH-1, U.O.N.
5. ALL CEILING HEIGHTS TO BE 9'-0" U.O.N.
6. LIGHTING FIXTURES IN GYPSUM BOARD CEILINGS TO BE CENTERED IN ROOMS, ALCOVES AND CORRIDORS U.O.N.
7. CEILING MOUNTED ELEMENTS INCLUDING, BUT NOT LIMITED TO, DOWNLIGHTS, SMOKE DETECTORS, SPRINKLER HEADS, ARE TO BE CENTERED IN ACOUSTICAL CEILING TILES IF 2'x2' OF CENTERED IN HALF OF 2'x4' TILE, U.O.N. OR DIMENSIONED.
8. LAY-IN CEILING TILES IN CORRIDORS ARE TO BE CENTERED IN THE CORRIDOR WIDTH, U.O.N.
9. WALL HUNG FIXTURES TO BE CENTERED ON WALL, U.O.N.
10. SUSPENDED CEILING FIXTURES IN ROOMS AND OPEN AREAS TO BE ALIGNED WITH CEILING GRID OR CENTERED IN A TILE, U.O.N.
11. SPRINKLER HEADS TO BE PAINTED TO MATCH ADJACENT MATERIAL.
12. FOR TYPICAL LIGHTING LAYOUT AT PUBLIC RESTROOMS, SEE A3.05
13. FOR TYPICAL LIGHTING LAYOUT AT PATIENT / STAFF TOILET ROOMS, SEE A3.05
14. REFER TO MECHANICAL / ELECTRICAL / PLUMBING DRAWINGS FOR WORK ABOVE THE CEILING.
15. ACCESS HATCHES SHALL BE PROVIDED IN HARD CEILINGS AS SPECIFIED. COORDINATE WITH MECHANICAL AND ELECTRICAL DRAWINGS FOR LOCATIONS.
16. LIGHT FIXTURES ON RCP ARE SHOWN FOR LOCATION ONLY. SEE ELECTRICAL DRAWINGS SHEETS E2.00 - E2.09 FOR LIGHTING FIXTURE TYPES AND PROJECT MANUAL FOR LIGHTING SPECIFICATION CUT SHEETS.
17. SEE MECHANICAL AND ELECTRICAL DRAWINGS FOR ADDITIONAL DEVICES AND FIXTURES NOT INDICATED.
18. CEILING TILES SHALL NOT BE CUT LESS THAN 6".
19. SEE A10 SERIES FOR CEILING DETAILS.
20. SEE REFLECTED CEILING PLAN SHEET SERIES A4.01 - A4.04 FOR WINDOW ROLLER SHADE LOCATIONS AT EXTERIOR WINDOWS, SH-1 SUNSHADE, U.O.N.
21. ALL GYP. CEILINGS TO BE PAINTED PT-1, FLAT FINISH, U.O.N.; ALL GYP. CEILINGS IN EASILY CLEANABLE ROOMS (SOILED UTILITY, EVS, WASTE HOLDING, SCRUB ALCOVES, SHOWERS (ROOMS), TO BE PAINTED PT-13.
22. ALL GYP. CEILINGS TO BE PAINTED THE SAME COLOR ON UNDERSIDE AND EDGE(S) OF SOFFIT, U.O.N.
23. ALL CEILING ACCESS DOORS AT GYPSUM BOARD CEILING SHALL BE FLUSH DOOR WITH DRYWALL BEAD.
24. EXAM ROOM UPPER CABINETS TO HAVE UNDERCABINET LIGHTING, TYP., U.O.N. SEE A3.03E

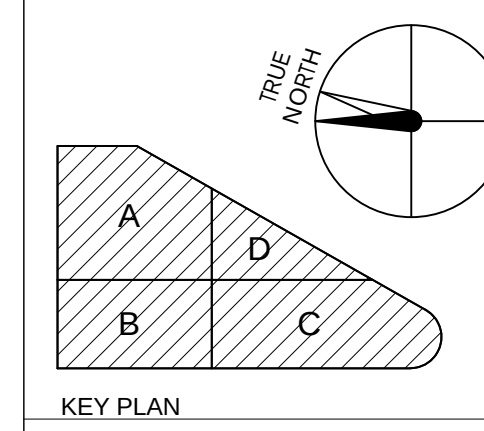

Stanford HEALTH CARE
STANFORD MEDICINE
HENSEL PHELPS
Plan. Build. Manage.
K M D ARCHITECTS
ARCHITECTURE PLANNING
222 WILLOW ST. SAN FRANCISCO, CA 94111
(415) 398-9131 FAX (415) 394-7158

NO.	DATE	ISSUED FOR
20160129	20160129	GENERAL COORDINATION
DP #18 - J	20160129	DP #18 - J
DP #2 - B	20160129	DP #2 - B
20151124	20151124	DP #2 - 10% CD PACKAGE
20151023	20151023	DP #2 - 50% CD PACKAGE
20150918	20150918	DESIGN DEVELOPMENT
20150731	20150731	DP #2 (50% CD) COORDINATION

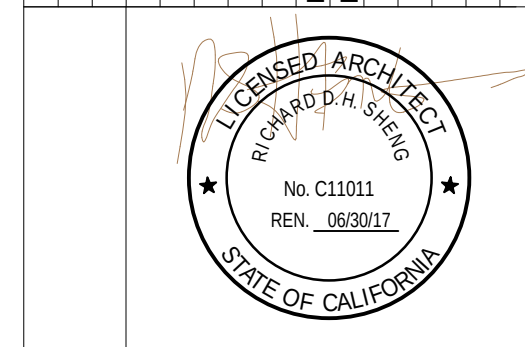

CERTIFIED BY
STANFORD HEALTH CENTER EMERYVILLE
5800 HOLLISS STREET
EMERYVILLE, CA 94608

PLANCHHECK#
PROJECT NO.
106-201
DATE

ENLARGED REFLECTED
CEILING - LEVEL 4 SECTOR A


A4.04A




CEILING NOTES

1. TYPICAL CEILING TO BE ACT-1 UNLESS OTHERWISE NOTED
2. CEILING TILE TO BE CENTERED IN ROOMS, U.O.N.
3. ALL UPPER CABINETS TO HAVE U.C. LIGHTING.
4. ALL EXTERIOR WINDOWS TO HAVE SUNSHADES SH-1, U.O.N.
5. ALL CEILING HEIGHTS TO BE 9'-0" U.O.N.
6. LIGHTING FIXTURES IN GYPSUM BOARD CEILINGS TO BE CENTERED IN ROOMS, ALCOVES AND CORRIDORS U.O.N.
7. CEILING MOUNTED ELEMENTS INCLUDING, BUT NOT LIMITED TO, DOWNLIGHTS, SMOKE DETECTORS, SPRINKLER HEADS, ARE TO BE CENTERED IN ACOUSTICAL CEILING TILES IF 2'x2' OF CENTERED IN HALF OF 2'x4' TILE, U.O.N. OR DIMENSIONED.
8. LAY-IN CEILING TILES IN CORRIDORS ARE TO BE CENTERED IN THE CORRIDOR WIDTH, U.O.N.
9. WALL HUNG FIXTURES TO BE CENTERED ON WALL, U.O.N.
10. SUSPENDED CEILING FIXTURES IN ROOMS AND OPEN AREAS TO BE ALIGNED WITH CEILING GRID OR CENTERED IN A TILE, U.O.N.
11. SPRINKLER HEADS TO BE PAINTED TO MATCH ADJACENT MATERIAL.
12. FOR TYPICAL LIGHTING LAYOUT AT PUBLIC RESTROOMS, SEE A3.05
13. FOR TYPICAL LIGHTING LAYOUT AT PATIENT / STAFF TOILET ROOMS, SEE A3.05
14. REFER TO MECHANICAL / ELECTRICAL / PLUMBING DRAWINGS FOR WORK ABOVE THE CEILING.
15. ACCESS HATCHES SHALL BE PROVIDED IN HARD CEILINGS AS SPECIFIED. COORDINATE WITH MECHANICAL AND ELECTRICAL DRAWINGS FOR LOCATIONS.
16. LIGHT FIXTURES ON RCP ARE SHOWN FOR LOCATION ONLY. SEE ELECTRICAL DRAWINGS SHEETS E2.00 - E2.09 FOR LIGHTING FIXTURE TYPES AND PROJECT MANUAL FOR LIGHTING SPECIFICATION CUT SHEETS.
17. SEE MECHANICAL AND ELECTRICAL DRAWINGS FOR ADDITIONAL DEVICES AND FIXTURES NOT INDICATED.
18. CEILING TILES SHALL NOT BE CUT LESS THAN 6".
19. SEE A10 SERIES FOR CEILING DETAILS.
20. SEE REFLECTED CEILING PLAN SHEET SERIES A4.01 - A4.09 FOR WINDOW ROLLER SHADE LOCATIONS AT EXTERIOR WINDOWS, SH-1 SUNSHADE, U.O.N.
21. ALL GYP. CEILINGS TO BE PAINTED PT-1, FLAT FINISH, U.O.N.; ALL GYP CEILINGS IN "EASILY CLEANABLE" ROOMS (SOILED UTILITY, EVS, WASTE HOLDING, SCRUB ALCOVES, SHOWERS (ROOMS), TO BE PAINTED PT-13.
22. ALL GYP. CEILINGS TO BE PAINTED THE SAME COLOR ON UNDERSIDE AND EDGE(S) OF SOFFIT, U.O.N.
23. ALL CEILING ACCESS DOORS AT GYPSUM BOARD CEILING SHALL BE FLUSH DOOR WITH DRYWALL BEAD.
24. EXAM ROOM UPPER CABINETS TO HAVE UNDERCABINET LIGHTING, TYP., U.O.N. SEE A3.03E

1 ENLARGED RCP - LEVEL 4 SECTOR B
SCALE 1/4" = 1'-0"

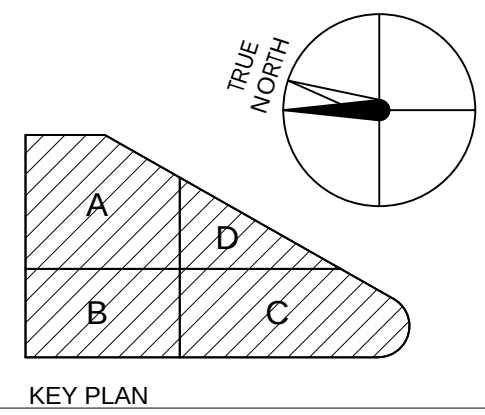

NO.	DATE	ISSUED FOR
2016/01/04	2016/01/04	RESPONSE TO PLAN REVIEW
2016/01/24	2016/01/24	DP #2 - 10% CD PACKAGE
2016/02/23	2016/02/23	DP #2 - 50% CD PACKAGE
2016/09/18	2016/09/18	DESIGN DEVELOPMENT
2016/07/31	2016/07/31	DP #2 (50% CD) COORDINATION

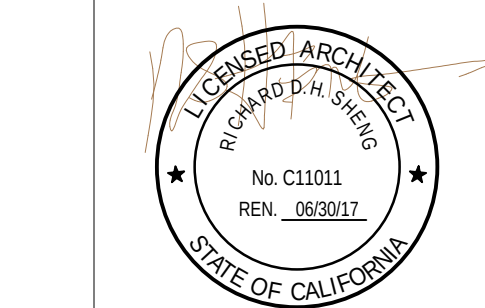

CERTIFIED BY
STANFORD HEALTH CENTER EMERYVILLE
5800 HOLLIS STREET
EMERYVILLE, CA 94608

PLANCHHECK#
PROJECT NO.
106-201
DATE

ENLARGED REFLECTED
CEILING - LEVEL 4 SECTOR B

A4.04B



- CEILING NOTES**
1. TYPICAL CEILING TO BE ACT-1 UNLESS OTHERWISE NOTED
 2. CEILING TILE TO BE CENTERED IN ROOMS, U.O.N.
 3. ALL UPPER CABINETS TO HAVE U.C. LIGHTING.
 4. ALL EXTERIOR WINDOWS TO HAVE SUNSHADES SH-1, U.O.N.
 5. ALL CEILING HEIGHTS TO BE 9'-0" U.O.N.
 6. LIGHTING FIXTURES IN GYPSUM BOARD CEILINGS TO BE CENTERED IN ROOMS, ALCOVES AND CORRIDORS U.O.N.
 7. CEILING MOUNTED ELEMENTS INCLUDING, BUT NOT LIMITED TO, DOWNLIGHTS, SMOKE DETECTORS, SPRINKLER HEADS, ARE TO BE CENTERED IN ACOUSTICAL CEILING TILES IF 2'x2' OF CENTERED IN HALF OF 2'x4' TILE, U.O.N. OR DIMENSIONED.
 8. LAY-IN CEILING TILES IN CORRIDORS ARE TO BE CENTERED IN THE CORRIDOR WIDTH, U.O.N.
 9. WALL HUNG FIXTURES TO BE CENTERED ON WALL, U.O.N.
 10. SUSPENDED CEILING FIXTURES IN ROOMS AND OPEN AREAS TO BE ALIGNED WITH CEILING GRID OR CENTERED IN A TILE, U.O.N.
 11. SPRINKLER HEADS TO BE PAINTED TO MATCH ADJACENT MATERIAL.
 12. FOR TYPICAL LIGHTING LAYOUT AT PUBLIC RESTROOMS, SEE A3.05
 13. FOR TYPICAL LIGHTING LAYOUT AT PATIENT / STAFF TOILET ROOMS, SEE A3.05
 14. REFER TO MECHANICAL / ELECTRICAL / PLUMBING DRAWINGS FOR WORK ABOVE THE CEILING.
 15. ACCESS HATCHES SHALL BE PROVIDED IN HARD CEILINGS AS SPECIFIED. COORDINATE WITH MECHANICAL AND ELECTRICAL DRAWINGS FOR LOCATIONS.
 16. LIGHT FIXTURES ON RCP ARE SHOWN FOR LOCATION ONLY. SEE ELECTRICAL DRAWINGS SHEETS E2.00 - E2.09 FOR LIGHTING FIXTURE TYPES AND PROJECT MANUAL FOR LIGHTING SPECIFICATION CUT SHEETS.
 17. SEE MECHANICAL AND ELECTRICAL DRAWINGS FOR ADDITIONAL DEVICES AND FIXTURES NOT INDICATED.
 18. CEILING TILES SHALL NOT BE CUT LESS THAN 6".
 19. SEE A10 SERIES FOR CEILING DETAILS.
 20. SEE REFLECTED CEILING PLAN SHEET SERIES A4.01 - A4.09 FOR WINDOW ROLLER SHADE LOCATIONS AT EXTERIOR WINDOWS, SH-1 SUNSHADE, U.O.N.
 21. ALL GYP. CEILINGS TO BE PAINTED PT-1, FLAT FINISH, U.O.N.; ALL GYP CEILINGS IN "EASILY CLEANABLE" ROOMS (SOILED UTILITY, EVS, WASTE HOLDING, SCRUB ALCOVES, SHOWERS (ROOMS), TO BE PAINTED PT-13.
 22. ALL GYP. CEILINGS TO BE PAINTED THE SAME COLOR ON UNDERSIDE AND EDGE(S) OF SOFFIT, U.O.N.
 23. ALL CEILING ACCESS DOORS AT GYPSUM BOARD CEILING SHALL BE FLUSH DOOR WITH DRYWALL BEAD.
 24. EXAM ROOM UPPER CABINETS TO HAVE UNDERCABINET LIGHTING, TYP., U.O.N. SEE A3.03E

KEY PLAN

Stanford HEALTH CARE
STANFORD MEDICINE
HENSEL PHELPS
Plan. Build. Manage.
K M D ARCHITECTS
ARCHITECTURE PLANNING
222 WILLOW SAN FRANCISCO, CA 94111
(415) 398-5151 FAX (415) 394-7158

NO.	DATE	ISSUED FOR
20160729	20160729	GENERAL COORDINATION
20160729	20160729	RESPONSE TO PLAN REVIEW
20160729	20160729	DP #2 - A
20160729	20160729	DP #2 - B
20160729	20160729	DP #2 - 10% CD PACKAGE
20160729	20160729	DP #2 - 50% CD PACKAGE
20160729	20160729	DESIGN DEVELOPMENT
20160729	20160729	DP #2 (50% CD) COORDINATION

STANFORD HEALTH CENTER EMERYVILLE
5800 HOLLIS STREET
EMERYVILLE, CA 94608

PLANCHECK#
PROJECT NO.
106-201
DATE

ENLARGED REFLECTED
CEILING - LEVEL 4 SECTOR C


A4.04C

1 ENLARGED RCP - LEVEL 4 SECTOR C
SCALE 1/4" = 1'-0"

CERTIFIED BY
Stanford Health Center Emeryville
5800 Hollis Street
Emeryville, CA 94608

1/29/2016 3:37:27 PM

COPYRIGHT © 2016 BY KMD ARCHITECTS. ALL RIGHTS RESERVED.

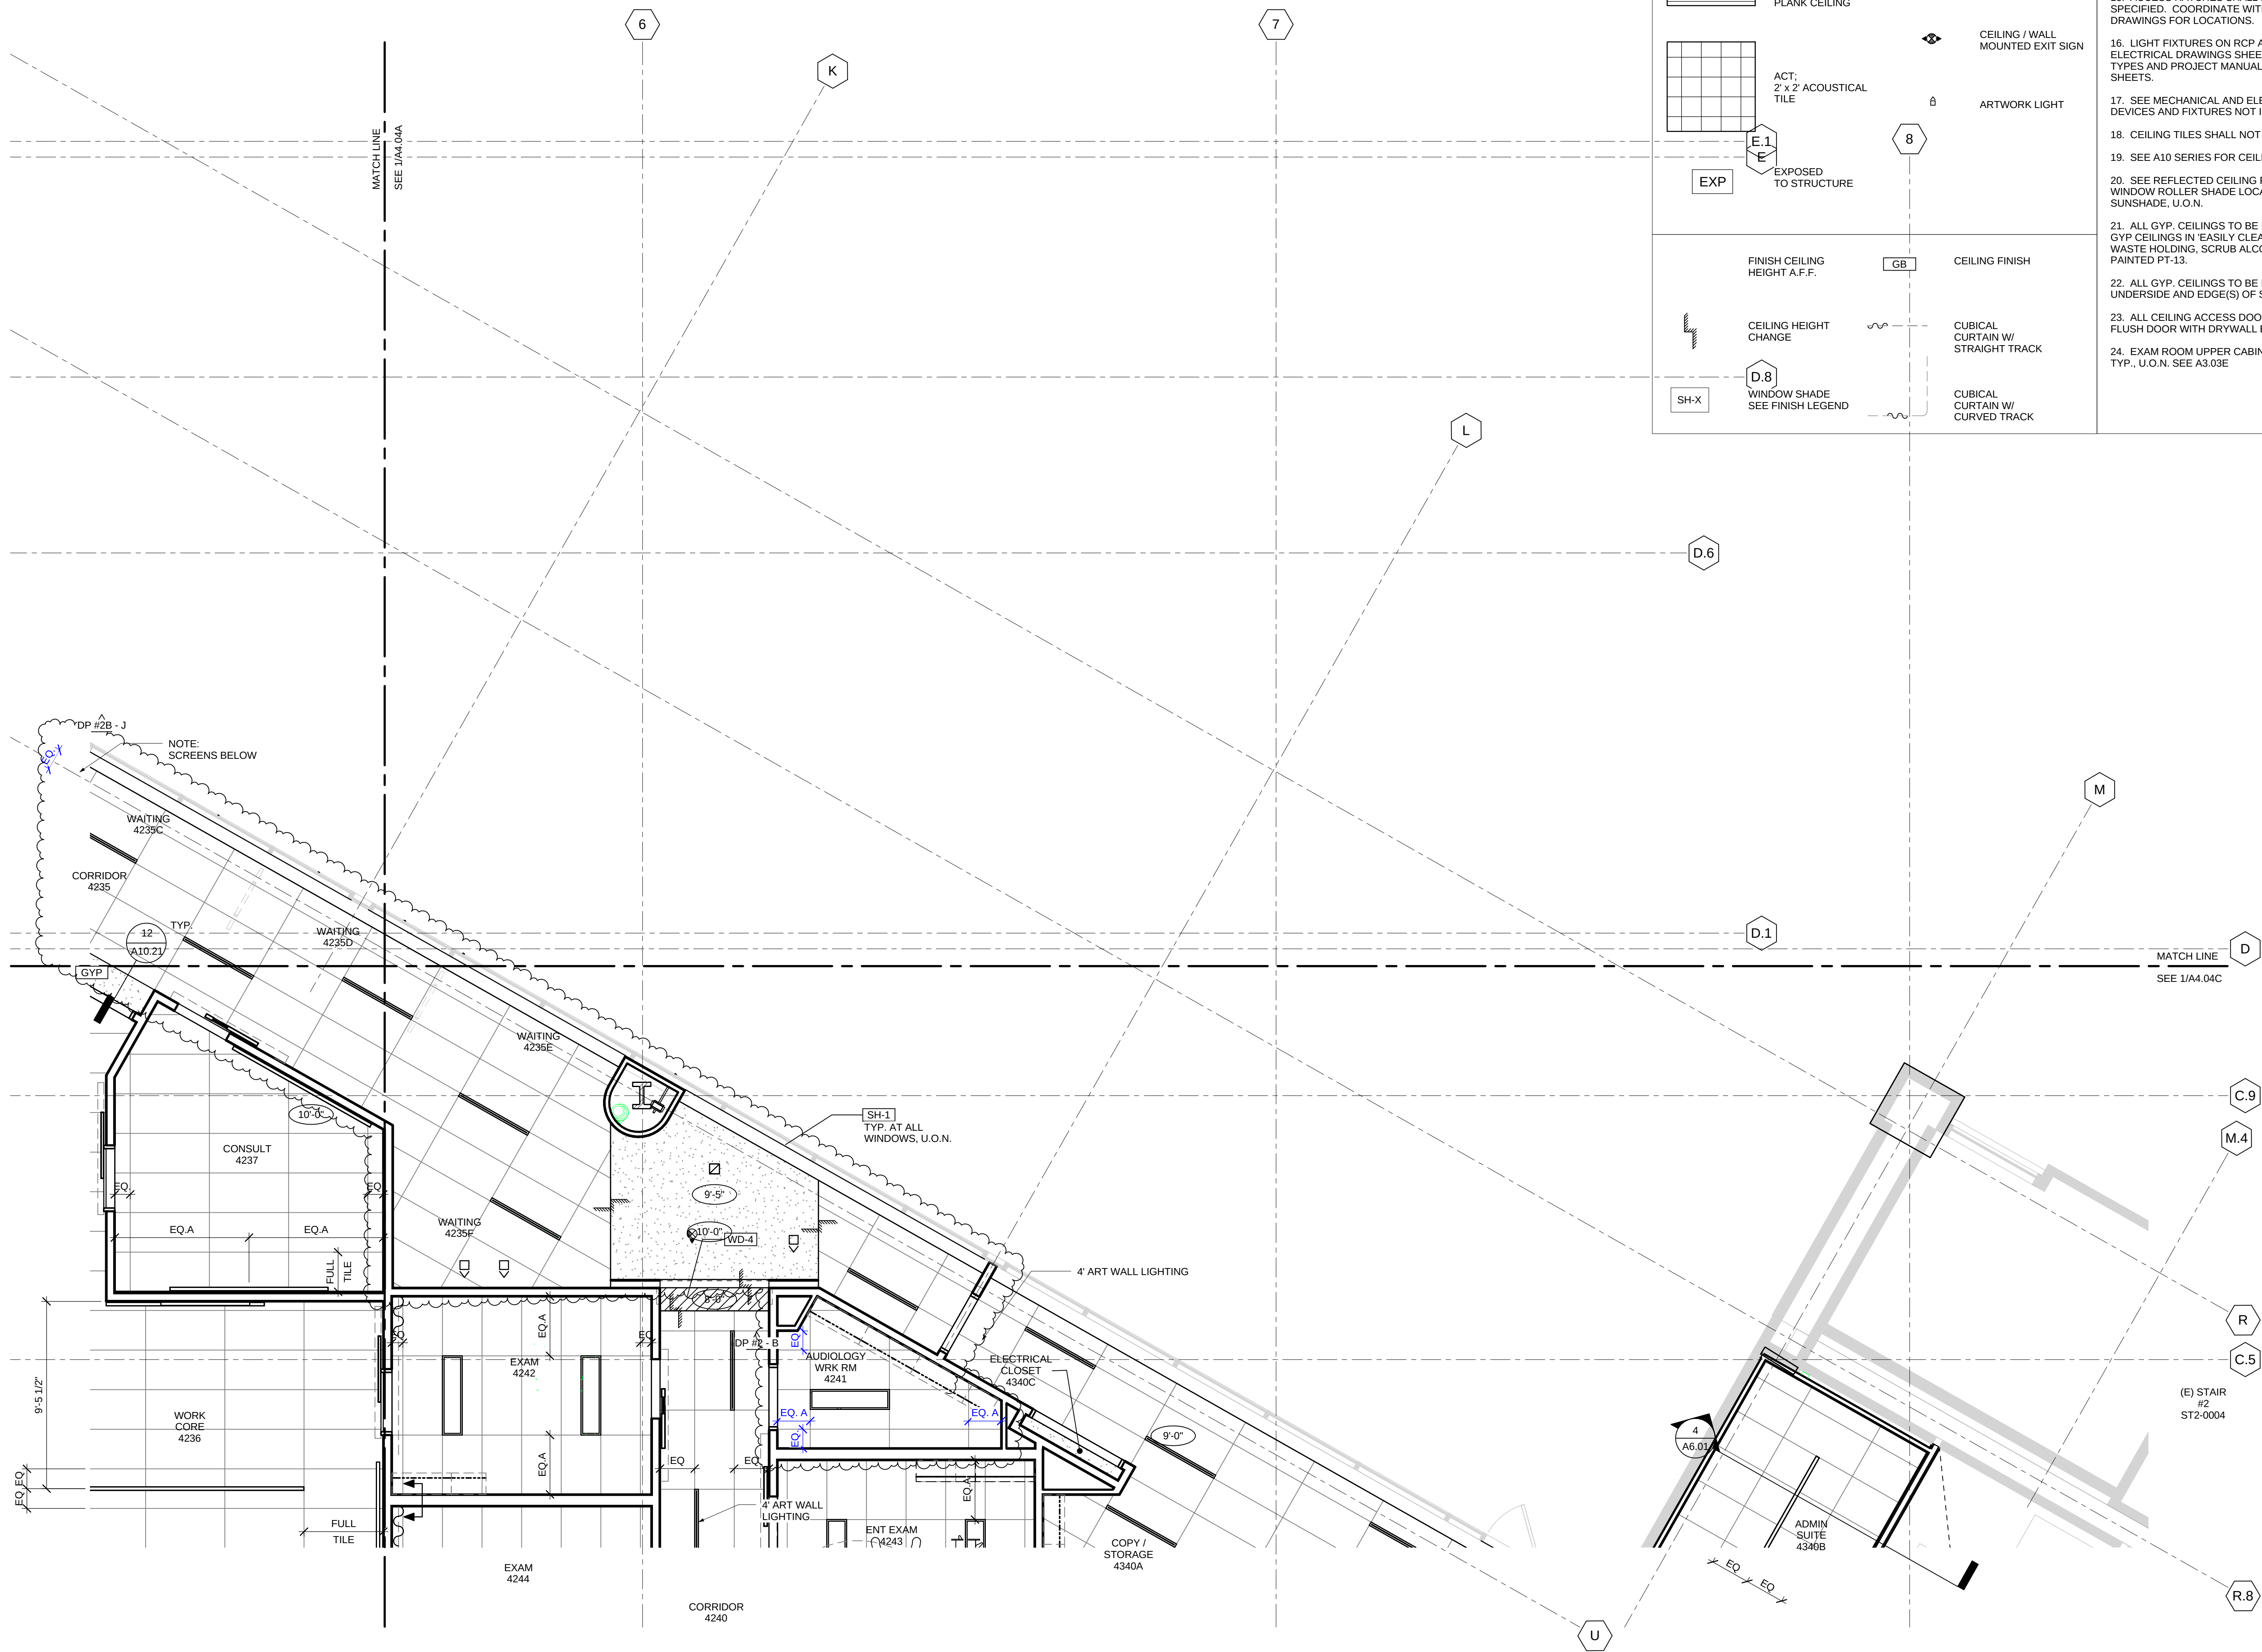


CEILING FINISH LEGEND

	GYP: GYPSUM BOARD		2x4 LIGHTING
	ACT: 2' x 4' ACOUSTICAL TILE		1x4 LIGHTING
	WAC-1: WOOD ACOUSTICAL CEILING		2x2 LIGHTING
	WD-4: WOOD CEILING AT PORTAL		2\"/>
	WAC-2: PLANK CEILING		4\"/>
	ACT: 2' x 2' ACOUSTICAL TILE		UNDERCABINET TASK LIGHT
	EXP: EXPOSED TO STRUCTURE		CEILING / WALL MOUNTED EXIT SIGN
	CEILING FINISH		ARTWORK LIGHT
	CEILING HEIGHT CHANGE		CUBICAL CURTAIN W/ STRAIGHT TRACK
	SH-X: WINDOW SHADE SEE FINISH LEGEND		CUBICAL CURTAIN W/ CURVED TRACK

CEILING NOTES


1. TYPICAL CEILING TO BE ACT-1 UNLESS OTHERWISE NOTED
2. CEILING TILE TO BE CENTERED IN ROOMS, U.O.N.
3. ALL UPPER CABINETS TO HAVE U.C. LIGHTING.
4. ALL EXTERIOR WINDOWS TO HAVE SUNSHADES SH-1, U.O.N.
5. ALL CEILING HEIGHTS TO BE 9'-0" U.O.N.
6. LIGHTING FIXTURES IN GYPSUM BOARD CEILINGS TO BE CENTERED IN ROOMS, ALCOVES AND CORRIDORS U.O.N.
7. CEILING MOUNTED ELEMENTS INCLUDING, BUT NOT LIMITED TO, DOWNLIGHTS, SMOKE DETECTORS, SPRINKLER HEADS, ARE TO BE CENTERED IN ACOUSTICAL CEILING TILES IF 2'x2' OF CENTERED IN HALF OF 2'x4 TILE, U.O.N. OR DIMENSIONED.
8. LAY-IN CEILING TILES IN CORRIDORS ARE TO BE CENTERED IN THE CORRIDOR WIDTH, U.O.N.
9. WALL HUNG FIXTURES TO BE CENTERED ON WALL, U.O.N.
10. SUSPENDED CEILING FIXTURES IN ROOMS AND OPEN AREAS TO BE ALIGNED WITH CEILING GRID OR CENTERED IN A TILE, U.O.N.
11. SPRINKLER HEADS TO BE PAINTED TO MATCH ADJACENT MATERIAL.
12. FOR TYPICAL LIGHTING LAYOUT AT PUBLIC RESTROOMS, SEE A3.05
13. FOR TYPICAL LIGHTING LAYOUT AT PATIENT / STAFF TOILET ROOMS, SEE A3.05
14. REFER TO MECHANICAL / ELECTRICAL / PLUMBING DRAWINGS FOR WORK ABOVE THE CEILING.
15. ACCESS HATCHES SHALL BE PROVIDED IN HARD CEILINGS AS SPECIFIED. COORDINATE WITH MECHANICAL AND ELECTRICAL DRAWINGS FOR LOCATIONS.
16. LIGHT FIXTURES ON RCP ARE SHOWN FOR LOCATION ONLY. SEE ELECTRICAL DRAWINGS SHEETS E2.00 - E2.09 FOR LIGHTING FIXTURE TYPES AND PROJECT MANUAL FOR LIGHTING SPECIFICATION CUT SHEETS.
17. SEE MECHANICAL AND ELECTRICAL DRAWINGS FOR ADDITIONAL DEVICES AND FIXTURES NOT INDICATED.
18. CEILING TILES SHALL NOT BE CUT LESS THAN 6".
19. SEE A10 SERIES FOR CEILING DETAILS.
20. SEE REFLECTED CEILING PLAN SHEET SERIES A4.01 - A4.04 FOR WINDOW ROLLER SHADE LOCATIONS AT EXTERIOR WINDOWS, SH-1 SUNSHADE, U.O.N.
21. ALL GYP. CEILINGS TO BE PAINTED PT-1, FLAT FINISH, U.O.N.; ALL GYP CEILINGS IN EASILY CLEANABLE ROOMS (SOILED UTILITY, EVS, WASTE HOLDING, SCRUB ALCOVES, SHOWERS (ROOMS), TO BE PAINTED PT-13.
22. ALL GYP. CEILINGS TO BE PAINTED THE SAME COLOR ON UNDERSIDE AND EDGE(S) OF SOFFIT, U.O.N.
23. ALL CEILING ACCESS DOORS AT GYPSUM BOARD CEILING SHALL BE FLUSH DOOR WITH DRYWALL BEAD.
24. EXAM ROOM UPPER CABINETS TO HAVE UNDERCABINET LIGHTING, TYP., U.O.N. SEE A3.03E

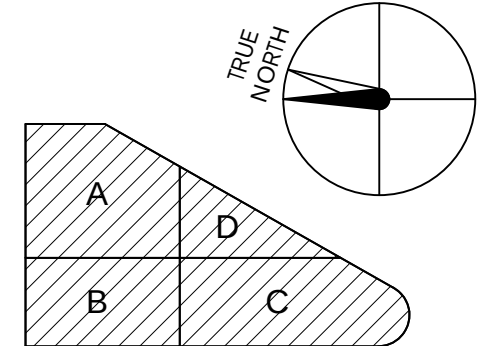

KEY PLAN

Stanford HEALTH CARE
STANFORD MEDICINE
HENSEL PHELPS
Plan. Build. Manage.
K M D ARCHITECTS
ARCHITECTURE PLANNING
222 WILLOW SAN FRANCISCO, CA 94111
(415) 398-9131 FAX (415) 394-7158

NO.	DATE	ISSUED FOR
2016/01/29	GENERAL COORDINATION	
2016/02/02	REVISIONS	
2016/01/24	DP #2 - 10% CD PACKAGE	
2016/02/23	DP #2 - 50% CD PACKAGE	
2016/09/18	DESIGN DEVELOPMENT	
2016/07/31	DP #2 (50% CD) COORDINATION	

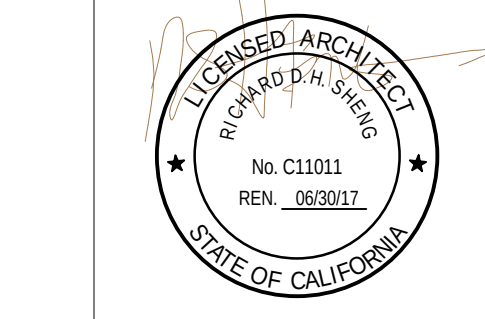

CERTIFIED BY
STANFORD HEALTH CENTER EMERYVILLE
5800 HOLLIS STREET
EMERYVILLE, CA 94608

PLANCHCK#
PROJECT NO.
106-201
DATE

ENLARGED REFLECTED
CEILING - LEVEL 4 SECTOR D

A4.04D

1 ENLARGED RCP - LEVEL 4 SECTOR D
SCALE 1/4" = 1'-0"